


NOTES

Notes

1. Unless noted otherwise, all underground drainage to be constructed in osma, or equivalent, installed strictly in accordance with manufacturers recommendations.
2. All pipework below buildings, handstandings or within 1.0m of ground level, to have 150mm concrete bed and surround.
3. All pipework below footpaths, landscaped areas or greater than 1.0m of ground level, to have 150mm thick pea shingle bed and surround.
4. All cover levels are approximate and subject to confirmation on site.
5. All foul drains to be laid to a minimum fall of 1:40.
6. All storm drains to be laid to a minimum fall of 1:80.
7. * Invert level of public foul sewer estimated and to be checked and confirmed on site by contractor. Adoptable standard manhole.

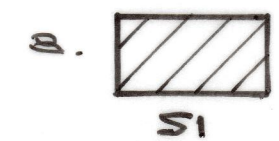

4.0m x 2.0m x 1.2m deep soakaway constructed in Warren Aquacell Prime Crates.

Top of Crates:- 53.15m
Bottom of Crates:- 51.95m
Bottom of Excavation:- 51.85m
(100mm thick pea shingle base)




5.0m x 1.0m x 2.0m deep soakaway constructed in Warren Aquacell Plus Crates.

Top of Crates:- 52.18m
Bottom of Crates:- 50.18m
Bottom of Excavation:- 50.08m
(100mm thick pea shingle base)

Warren Aquacell Crate Soakaways to be installed strictly in accordance with manufacturers recommendations.


10. Key:-

- Foul water manhole
- Storm water inspection chamber
- +— Foul water drains
- +— Storm water drains
- r.e. Rodding Eye
- r. Roddable Rainwater Downpipe
- SVP Soils and vent pipe
- SS Stub Stack
- DC Heavy duty drainage channels

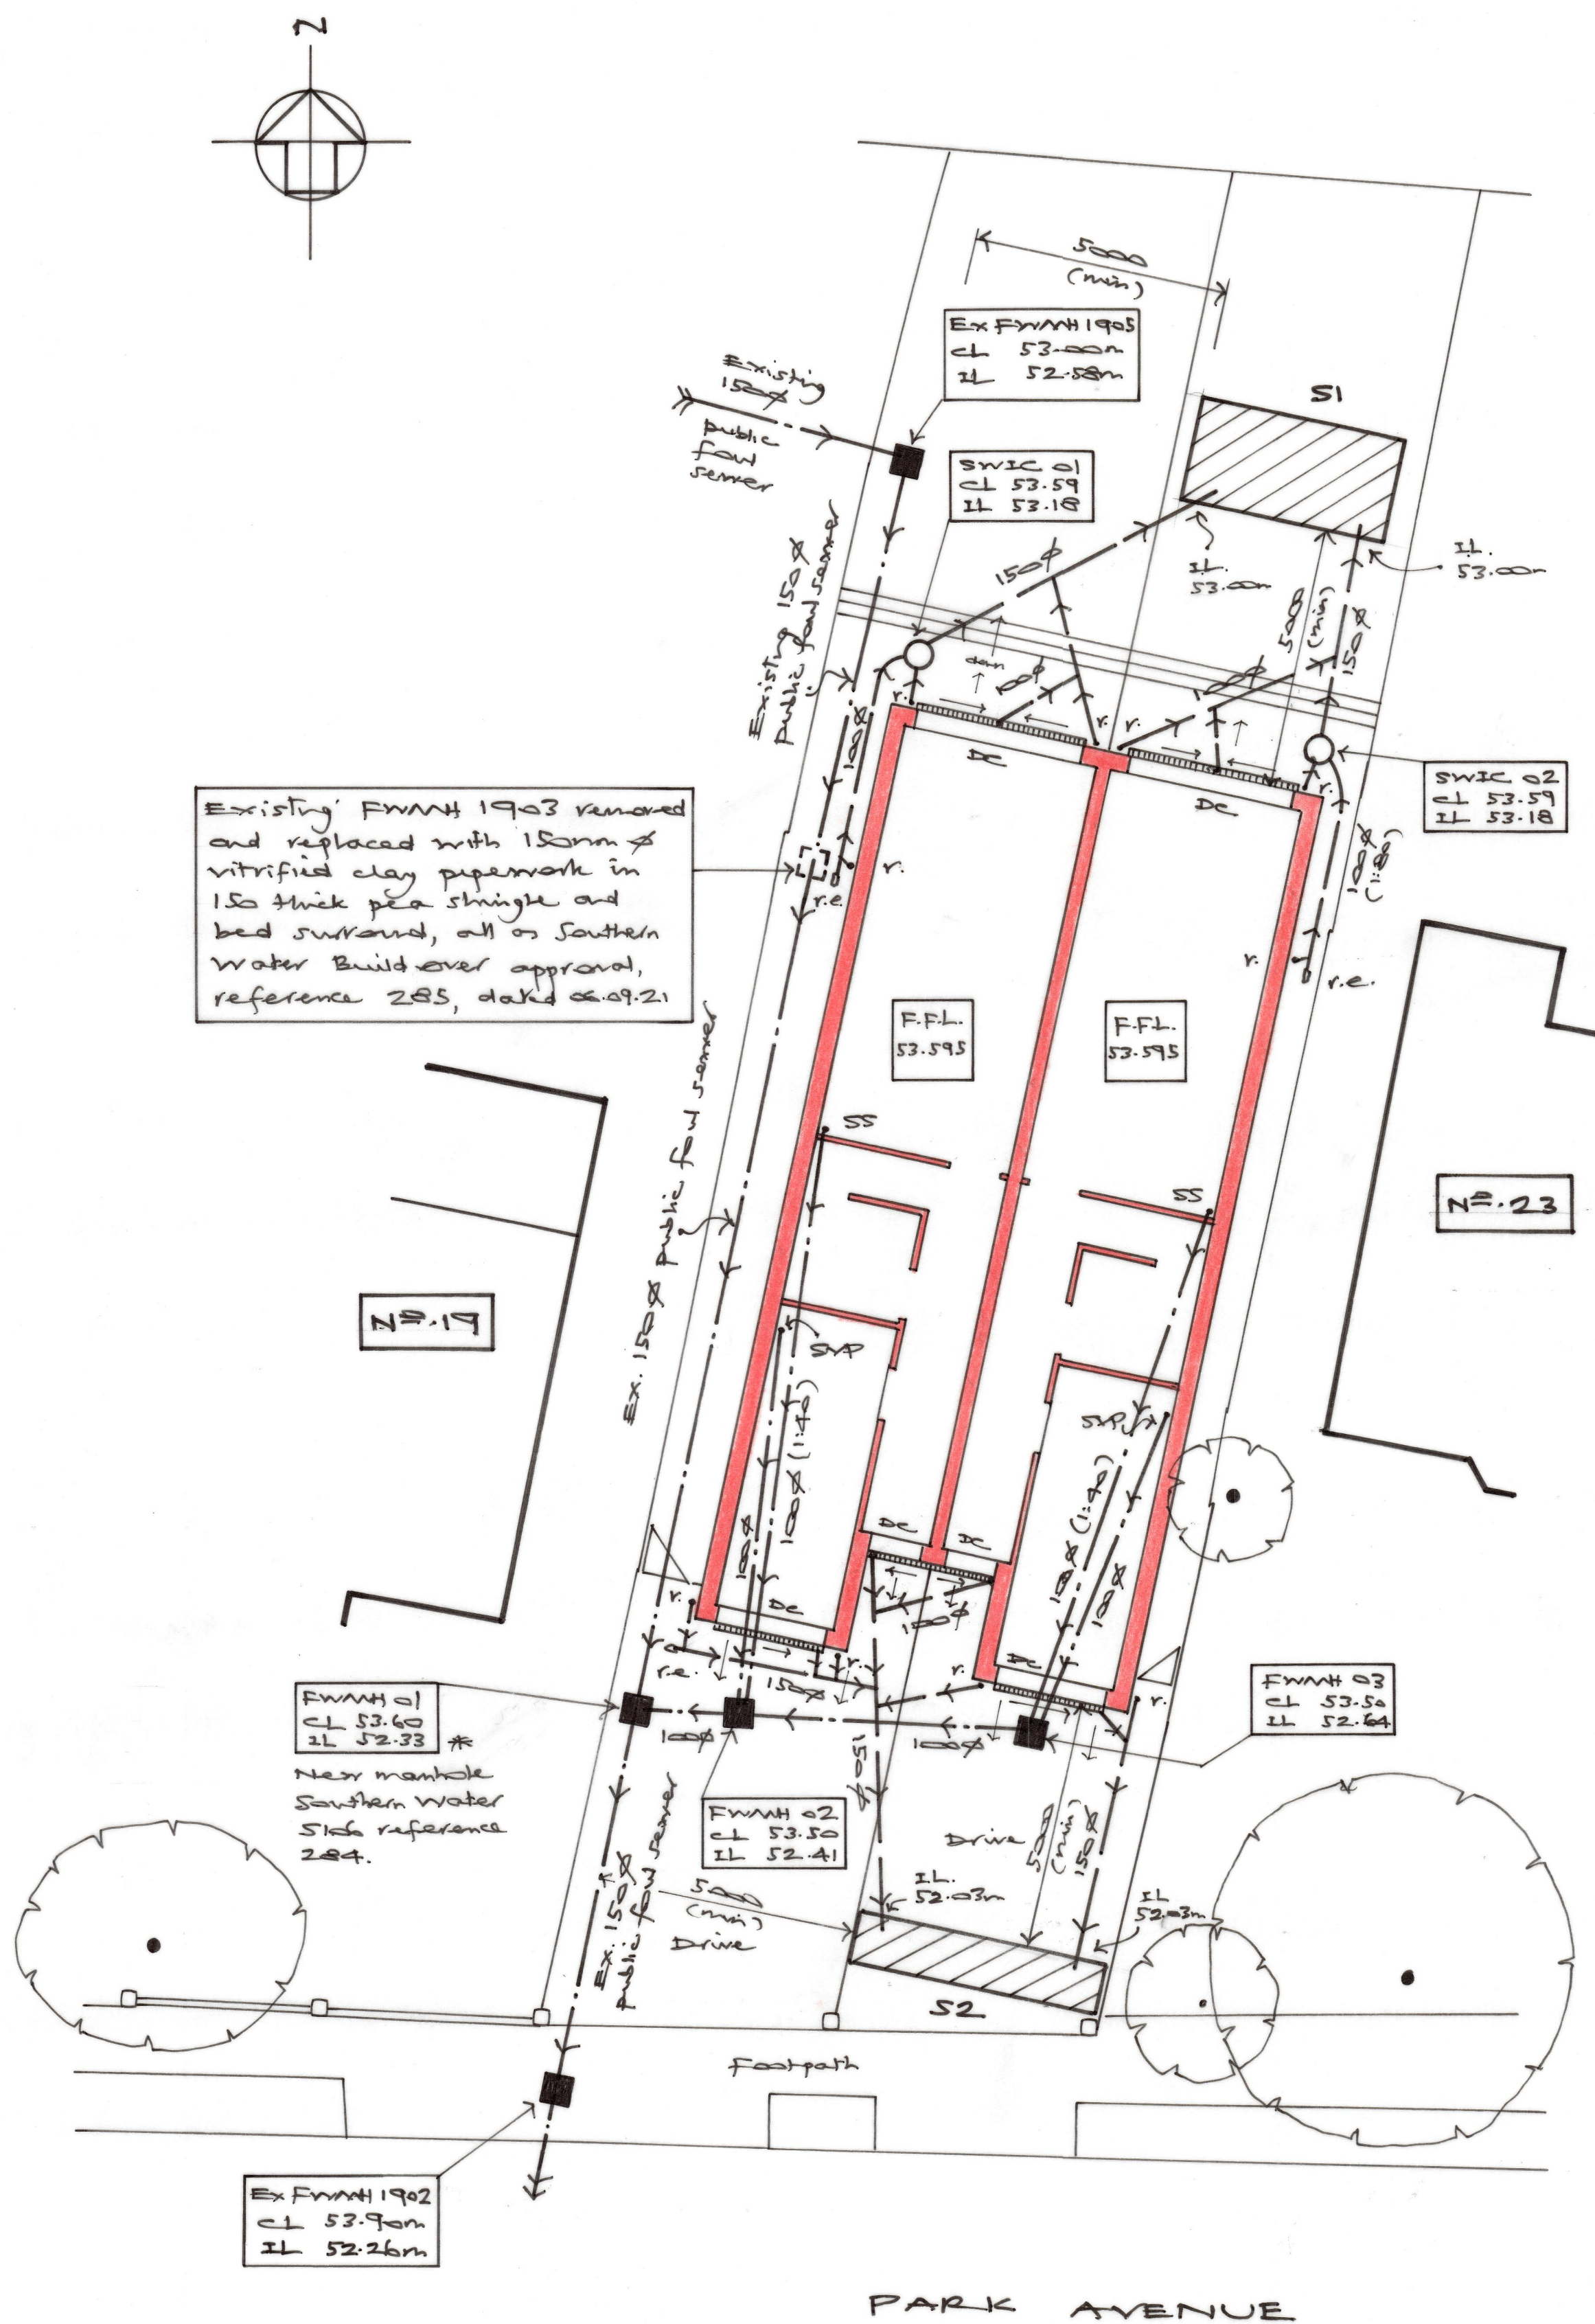

Stiff	Date	Revisions

© copyright

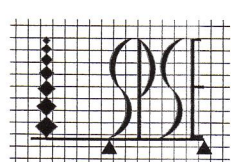

stephen penfold
structural engineer
unit 6, northam business centre, princes street, northam
southampton, hants. so14 5rp
e-mail: stephen@spenfold.co.uk james@spenfold.co.uk tel: (023) 8059 2072

Client

**CHARACTER BUILDING
DEVELOPMENTS LIMITED**

Job Title

**PROPOSED DEVELOPMENT
2.1 PARK AVENUE
WATERLOOVILLE
HANTS**

Drawing Title

**PROPOSED UNDERGROUND
DRAINAGE LAYOUT**

Scale 1:100 @ A1

Date Sept '21 Drawn by SP.

Drg No. 2.1539/100

Rev.