



Equipment Schedule


#REF	System	Manufacturer	Model	Electrical supply	Phase	Fuse Rating (amp)	No. of Power Cable Cores	Input Power (Watt)	FLC (amp)	Start Current (amp)	Sound Pressure level dB(A)	Weight (Kg)	No. Interconnecting Cable Cores	CONTROLLER POSITION	COMMENTS
01	CUSTOMER AREA CASSETTE AC UNIT	MHI	FDT71VH	220 - 240v, 50Hz	Single	-	-	-	-	-	28@3m	26	3+E (1.5mm)	WITHIN THE ROOM	POWER VIA OUTDOOR
02	CUSTOMER AREA CASSETTE AC UNIT	MHI	FDT71VH	220 - 240v, 50Hz	Single	-	-	-	-	-	28@3m	26	3+E (1.5mm)	WITHIN THE ROOM	POWER VIA OUTDOOR
03	CUSTOMER AREA CASSETTE AC UNIT	MHI	FDT71VH	220 - 240v, 50Hz	Single	-	-	-	-	-	28@3m	26	3+E (1.5mm)	WITHIN THE ROOM	POWER VIA OUTDOOR
04	CUSTOMER AREA EXTRACT FAN	ELTA SELECT	SEL355/4-1AC	220 - 240v, 50Hz	Single	13	3	150w	.7	-	45@3m	14	3+E	G/F GLASS WASH	POWER TO CONTROLLER
05	DISABLED WC EXTRACT FAN	VENT AXIA	VASF100TV	220 - 240v, 50Hz	Single	13	3	7.5w	-	-	20@3m	1.2	3	ON WITH LIGHTS	POWER TO FAN
06	DHW CYLINDER	MEGAFLO	250DDDD	220 - 240v, 50Hz	Single	4 X 13	4 X 3	12Kw	-	-	-	300	-	VIA TIMECLOCK	POWER TO TIME CLOCK
07	CLEANERS STORE EXTRACT FAN	VENT AXIA	VASF100TV	220 - 240v, 50Hz	Single	13	3	7.5w	-	-	20@3m	1.2	3	ON WITH LIGHTS	POWER TO FAN
08	POT WASH / VEG PREP EXTRACT FAN	ELTA SELECT	HIT250	220 - 240v, 50Hz	Single	-	3	-	.79	-	52@3m	5.3	-	VIA THE LIGHTS	POWER TO FAN
09	KITCHEN EXTRACT FAN	SYSTEMAIR	MUB062 630D4-A2 IE2	380 - 415v, 50Hz	3ph	-	5	4411w	8.12	60.9	68@3m	114	-	WITHIN THE KITCHEN	POWER TO FAN
10	EXTRACT AIR PRESSURE SWITCH	-	-	-	-	-	-	-	-	-	-	-	2	WIRED INTO INTERLOCK	screened 2 pair 0.25mm
11	WALK IN FRIDGE COOLER	MODINE	EVS131ED	220 - 240v, 50Hz	Single	13	3	22w	-	-	34@3m	7.7	-	ON THE UNIT	POWER TO UNIT
12	WALK IN FREEZER COOLER	MODINE	EVS291/BED	220 - 240v, 50Hz	Single	13	3	33w	-	-	36@3m	12.1	-	ON THE UNIT	POWER TO UNIT
13	KITCHEN DUCTED AC UNIT	MHI	FDU200VH	380 - 415v, 50Hz	3ph	16	5	-	-	-	52@3m	88	3+E (1.5mm)	KITCHEN	POWER TO UNIT
14	KITCHEN SUPPLY FAN	FLAKT WOODS	56JM	380 - 415v, 50Hz	3ph	-	5	1320w	6.7	13.5	58@3m	38	-	WITHIN THE KITCHEN	POWER TO FAN
15	SUPPLY AIR PRESSURE SWITCH	-	-	-	-	-	-	-	-	-	-	-	2	WIRED INTO INTERLOCK	screened 2 pair 0.25mm
16	CUSTOMER AREA AC CONDENSER	MHI	FDC200VSA-W	380 - 415v, 50Hz	3ph	32	5	6150w	23	5	59@1m	144	-	N/A	POWER TO UNIT
17	WALK IN FRIDGE CONDENSER	DANFOS	OP-MSYM012MPW05G	220 - 240v, 50Hz	Single	16	3	-	-	-	34@10m	51	-	N/A	POWER TO UNIT
18	KITCHEN DUCTED AC CONDENSER	MHI	FDC200VSA-W	380 - 415v, 50Hz	3ph	32	5	6150w	23	5	59@1m	144	-	N/A	POWER TO UNIT
19	WALK IN FREEZER CONDENSER	DANFOS	OP-LSQM048NTW05G	220 - 240v, 50Hz	Single	16	3	-	-	-	40@10m	62	-	N/A	POWER TO UNIT

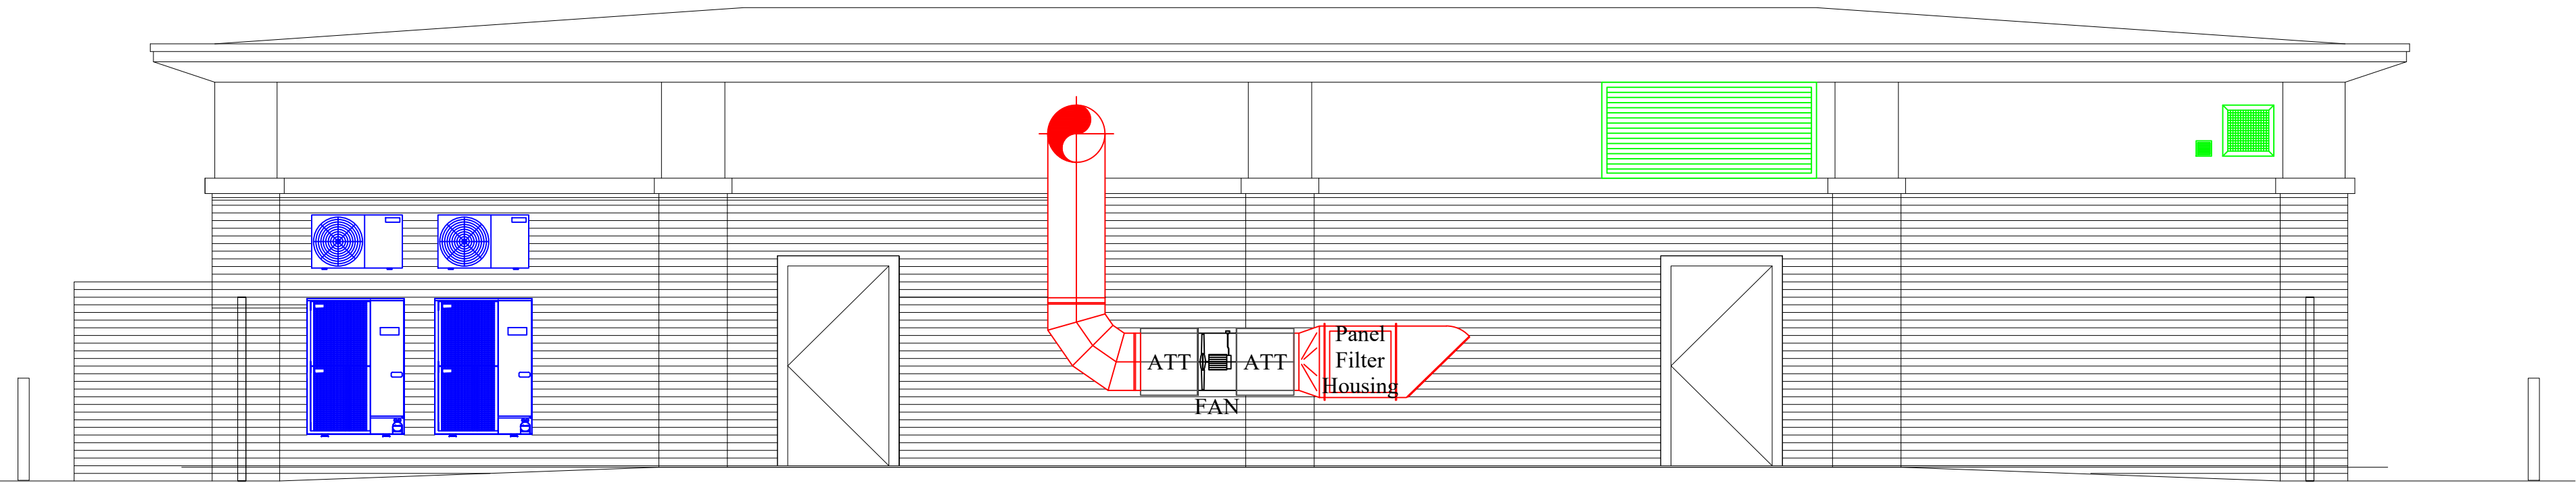


REAR ELEVATION AS PROPOSED

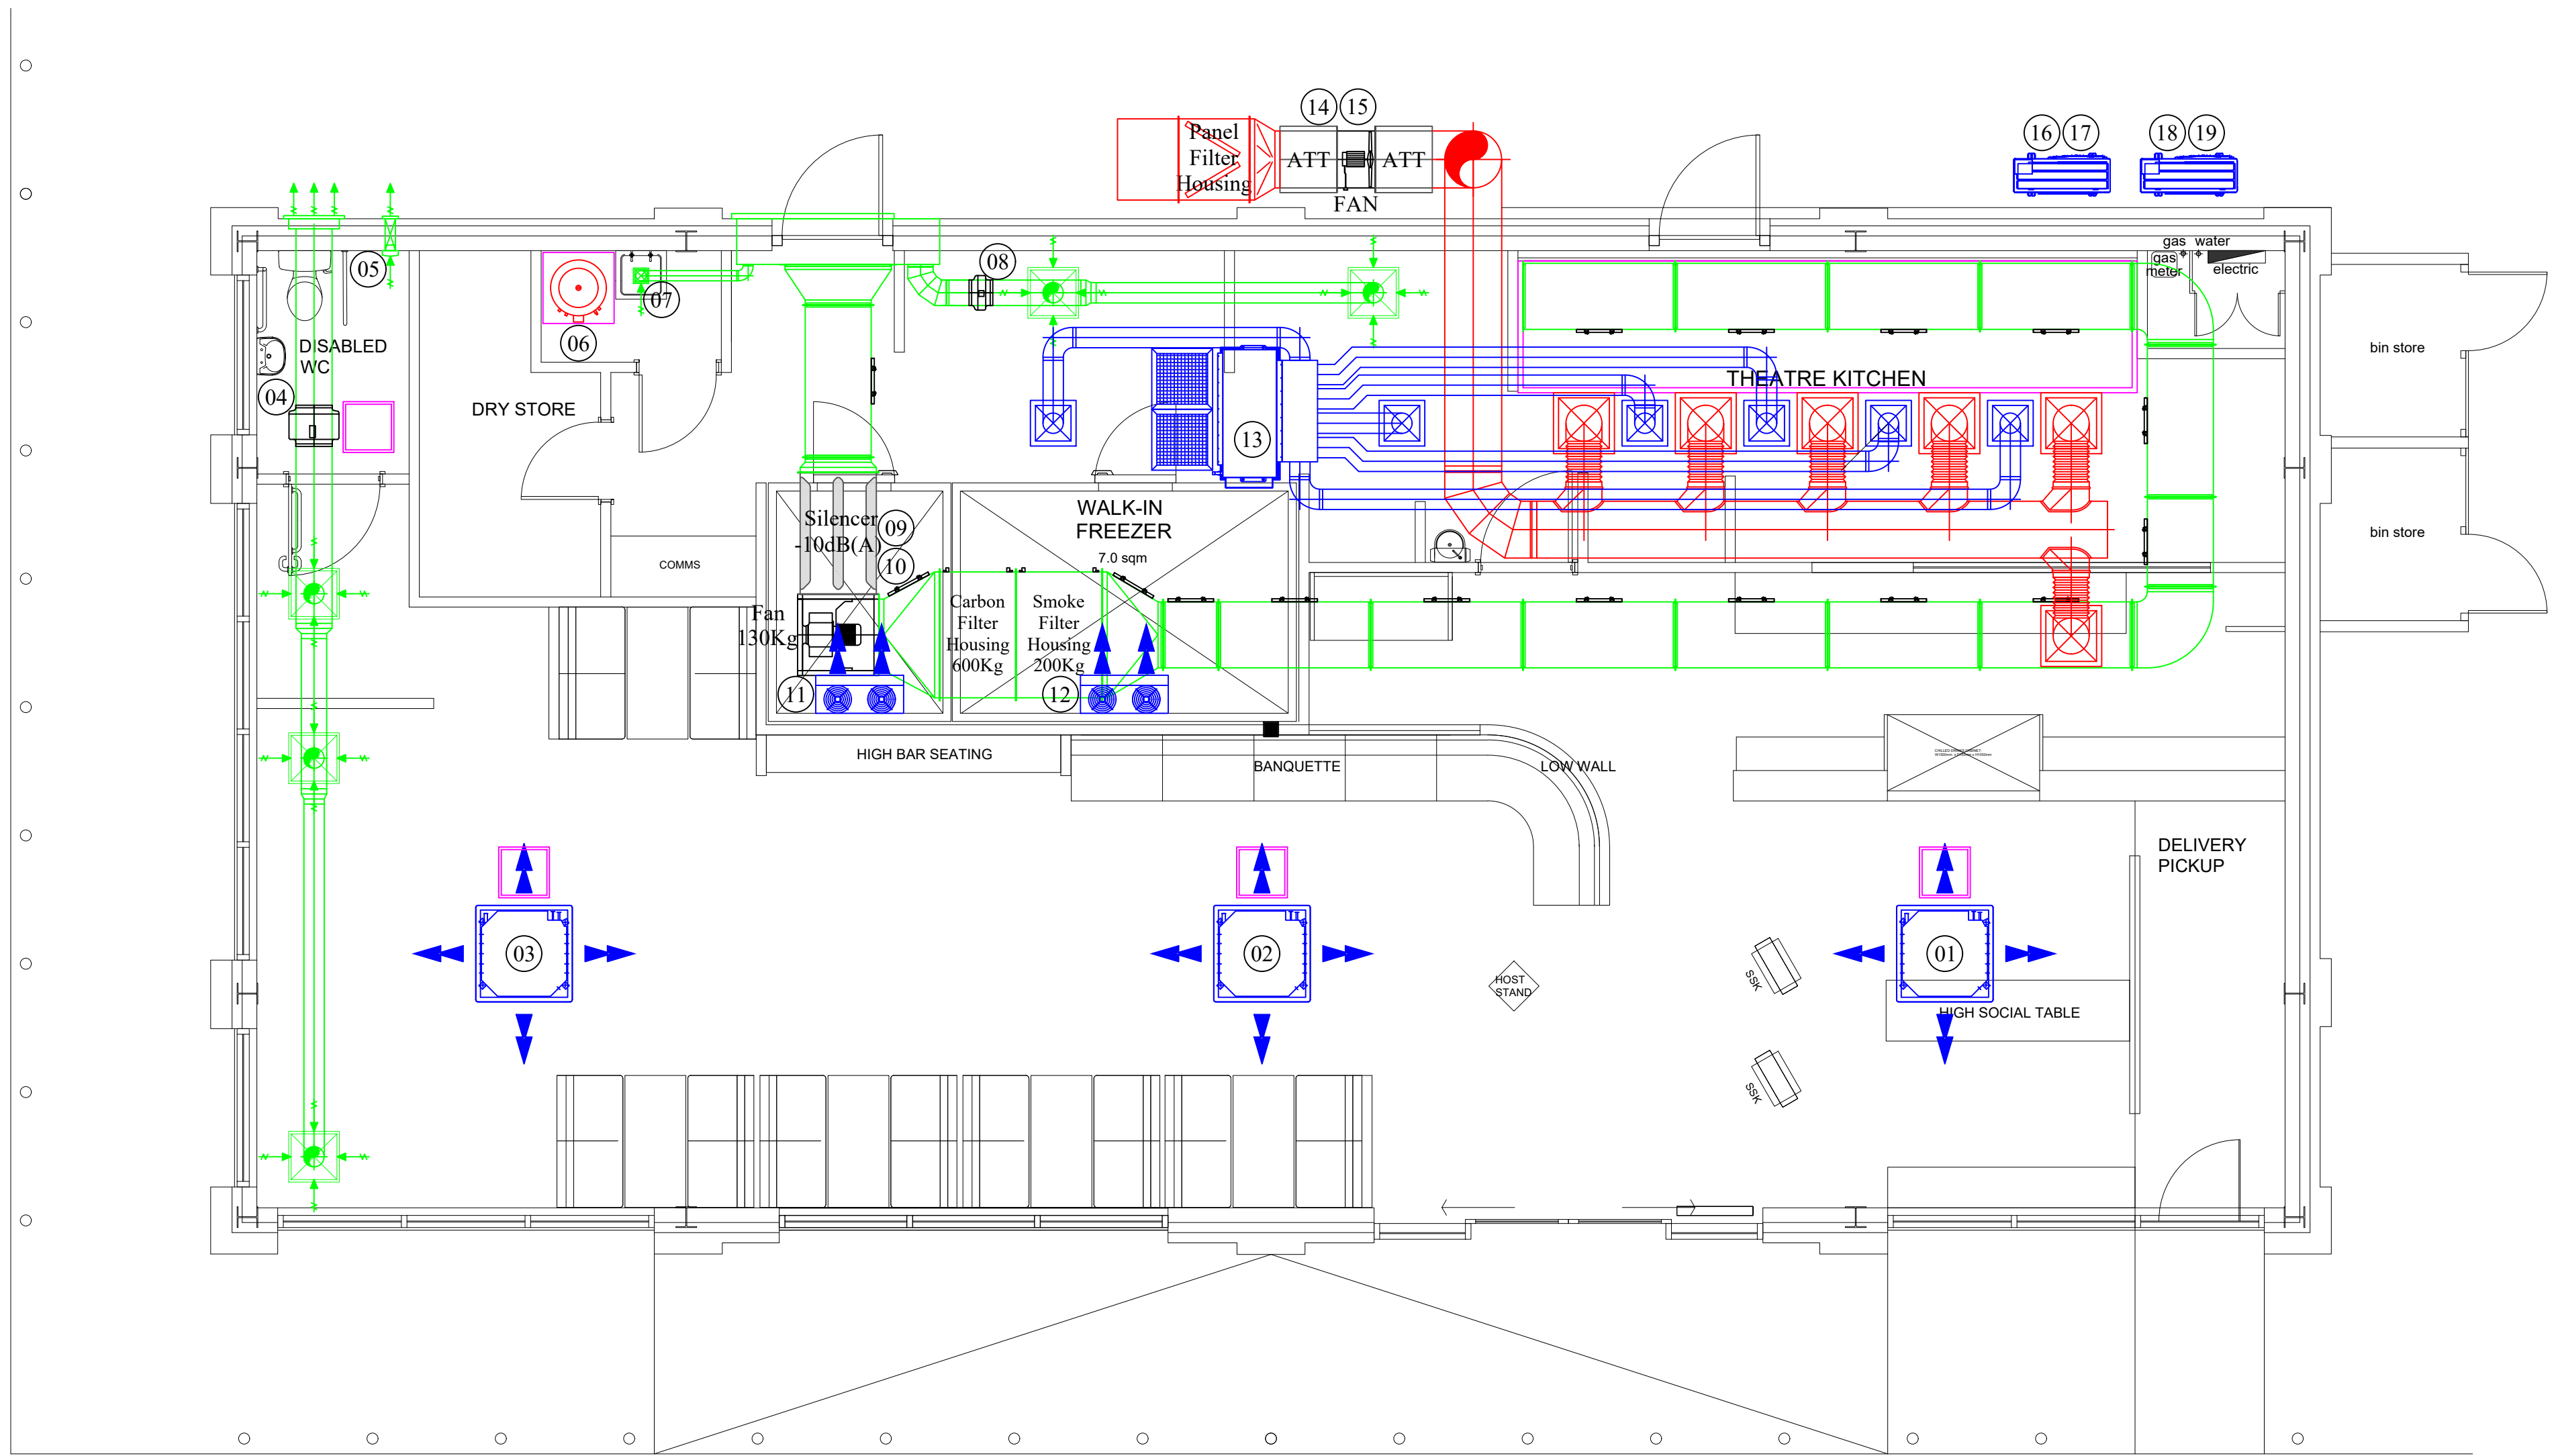

PLAN AS PROPOSED:

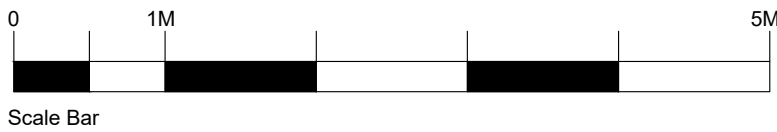

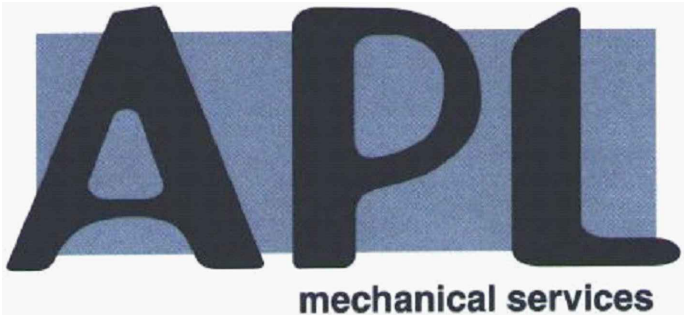A		14/10/21	Notes amended
Rev	Date	Description	
Client: GDK			
Job Title: HAVANT			
Dwg Title: PROPOSED GROUND FLOOR & ELEVATION LAYOUT PLAN			
Date:	08-10-21	Drawn By:	DB
Scale:	1:50@A1	Checked By:	SH
Dwg No:	GDK-HAV-00	Rev:	A
			
Abbey Plumbing Ltd 3 Whitehills Drive Whitehills Business Park Blackpool, FY4 5LW Tel: 01253 698 159 Email: admin@aplmechanical.co.uk			