




CLIENT	One Stop	REF No.	RA/5554	REV	DATE	DESCRIPTION
STORE NAME	Waterlooville	DATE	02/09/2016	B	02/09/2016	Open Hrs + ACM 'B'
EPOS CODE	1332	SCALE	as detailed @ A3	-	-	-
PROJ TYPE	Re-Fresh	DRAWN	IW	-	-	-
PM	Rob Archer	DWG No.	B	-	-	-

PROPOSED SITE SIGNAGE

Item 1 - Fascia See specification page for detail size: 8,274mm x 670mm H x 80mm D	Item 2 - ACM Direct Print Panels Aluminium composite panels with digitally printed image to face of the panel. a. size: 2185mm x 1895mm H b. size: 2185mm x 1934mm H	Item 3 - Manifestation Push/Pull and window manifestation size: to suit area
--	--	--


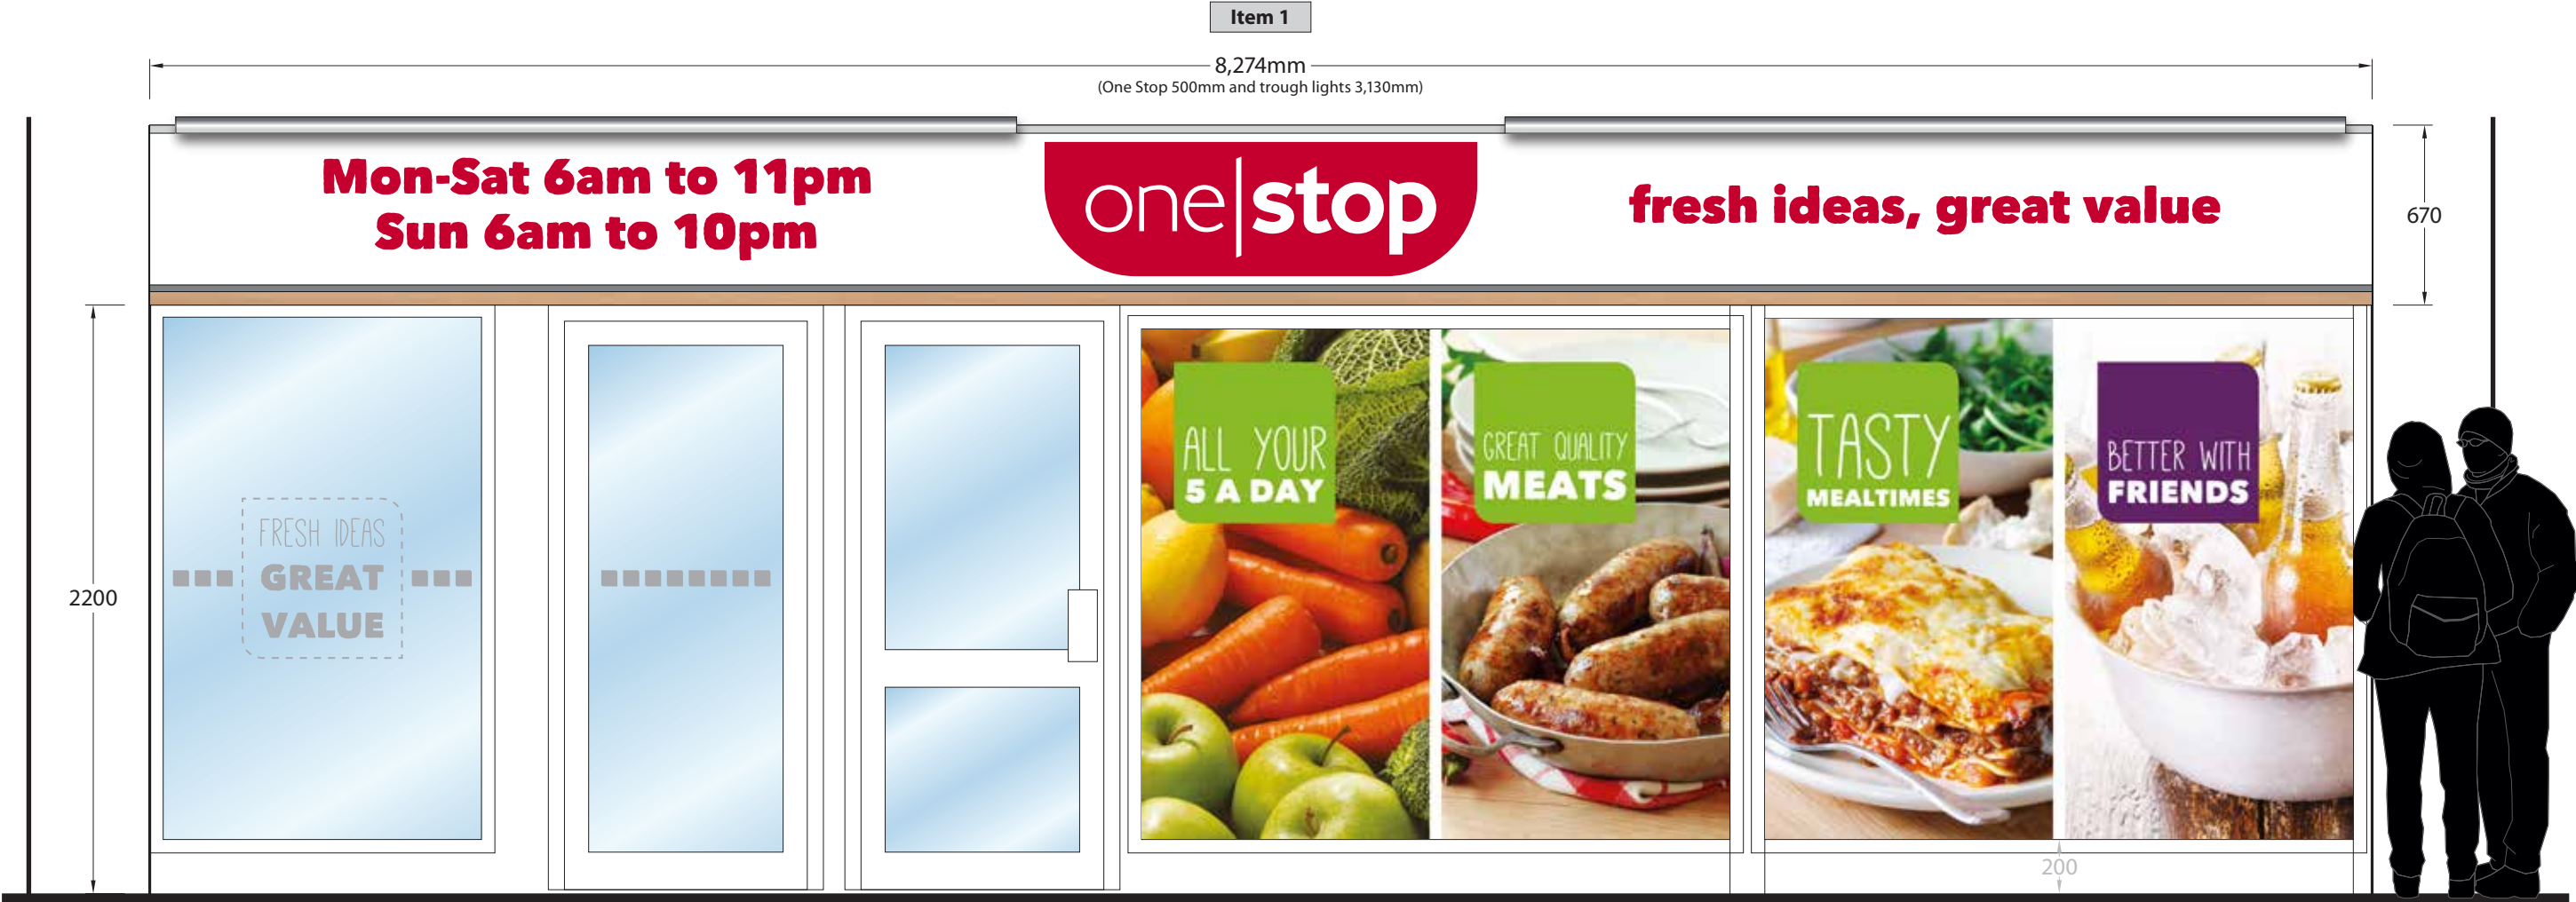


Front Elevation / scale 1:25 @ A3

Item 3	Item 2 A	B
---------------	------------------------	----------

CLIENT	One Stop	REF No.	RA/5554	REV	DATE	DESCRIPTION
STORE NAME	Waterlooville	DATE	02/09/2016	B	02/09/2016	Open Hrs + ACM 'B'
EPOS CODE	1332	SCALE	as detailed @ A3	-	-	-
PROJ TYPE	Re-Fresh	DRAWN	IW	-	-	-
PM	Rob Archer	DWG No.	B	-	-	-

FASCIA SIGN SPECIFICATION

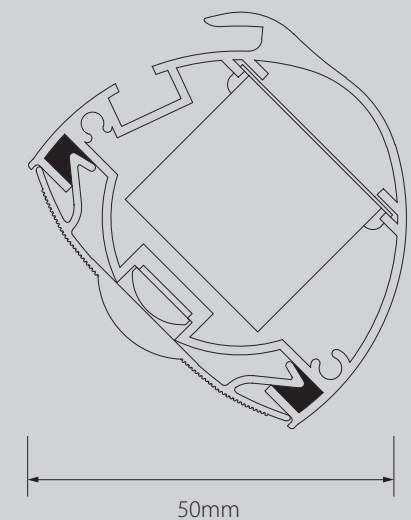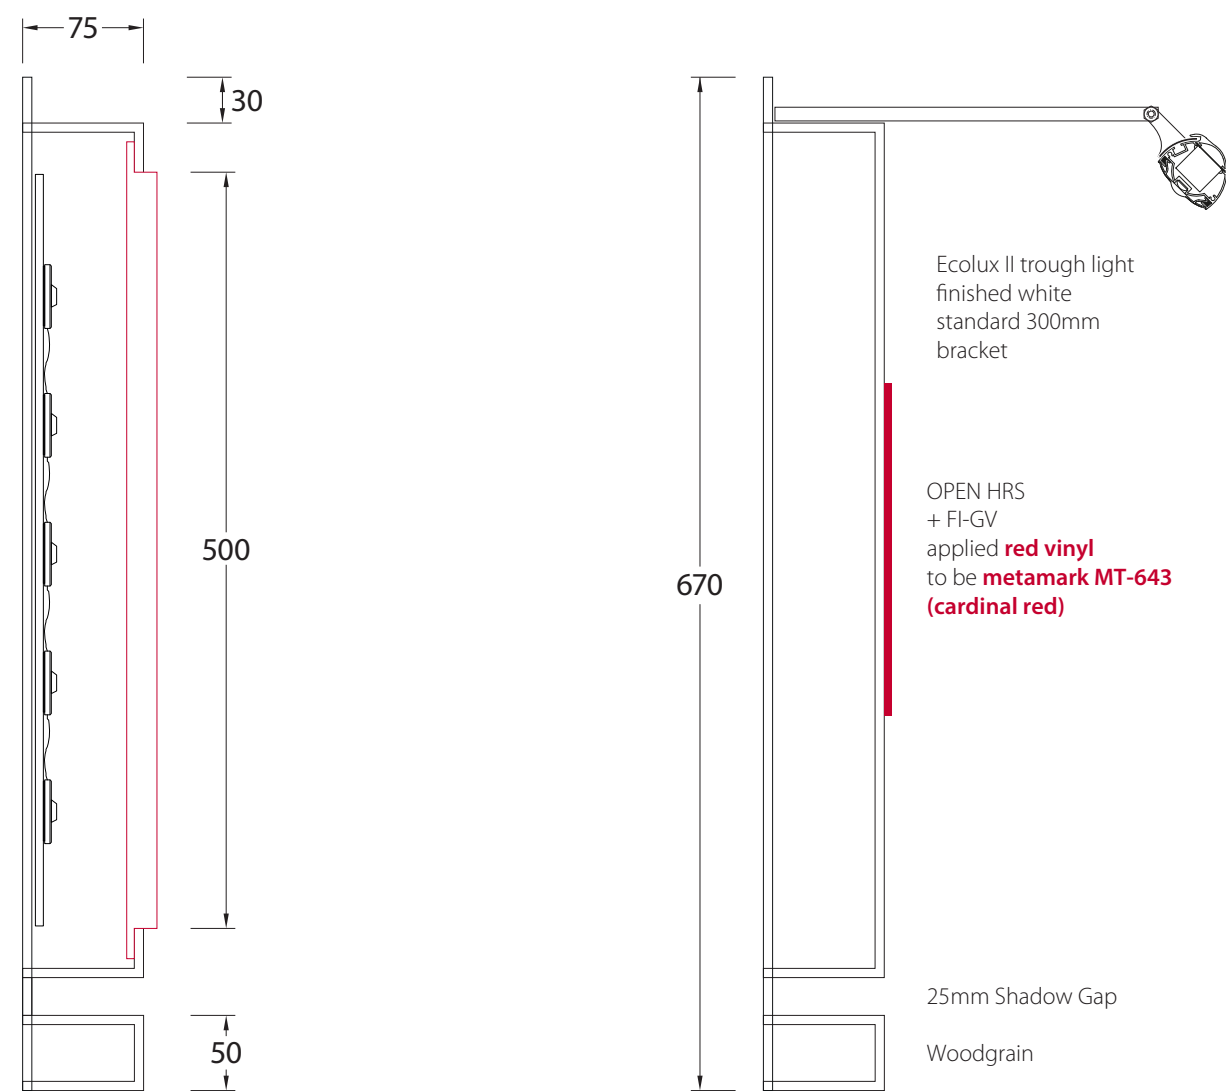

Technical Specification

LED strip
Latest high lighting chip technology giving. 120 degree angle. IP65 protected, 50,000 hrs+ lamp life. Full CE certification and ROHS compliant.

Drivers
Epoxy encapsulated fully isolated case with IP67 protection. Constant voltage design. Short circuit, over current, over voltage protection. Fitted onto Kwik release slide in Gear Trays. Full CE certification and ROHS compliant.

Light Fitting
Specially designed 50mm diameter aluminium extrusion supplied up to 6000mm lengths which can be joined together using cast aluminium connectors. Die cast aluminium end caps. Standard 300mm Kwik Fit brackets. Snap-in polycarbonate 90 degree magnifying lens diffuser.



CLIENT	One Stop	REF No.	RA/5554	REV	DATE	DESCRIPTION
STORE NAME	Waterlooville	DATE	02/09/2016	B	02/09/2016	Open Hrs + ACM 'B'
EPOS CODE	1332	SCALE	as detailed @ A3	-	-	-
PROJ TYPE	Re-Fresh	DRAWN	IW	-	-	-
PM	Rob Archer	DWG No.	B	-	-	-