
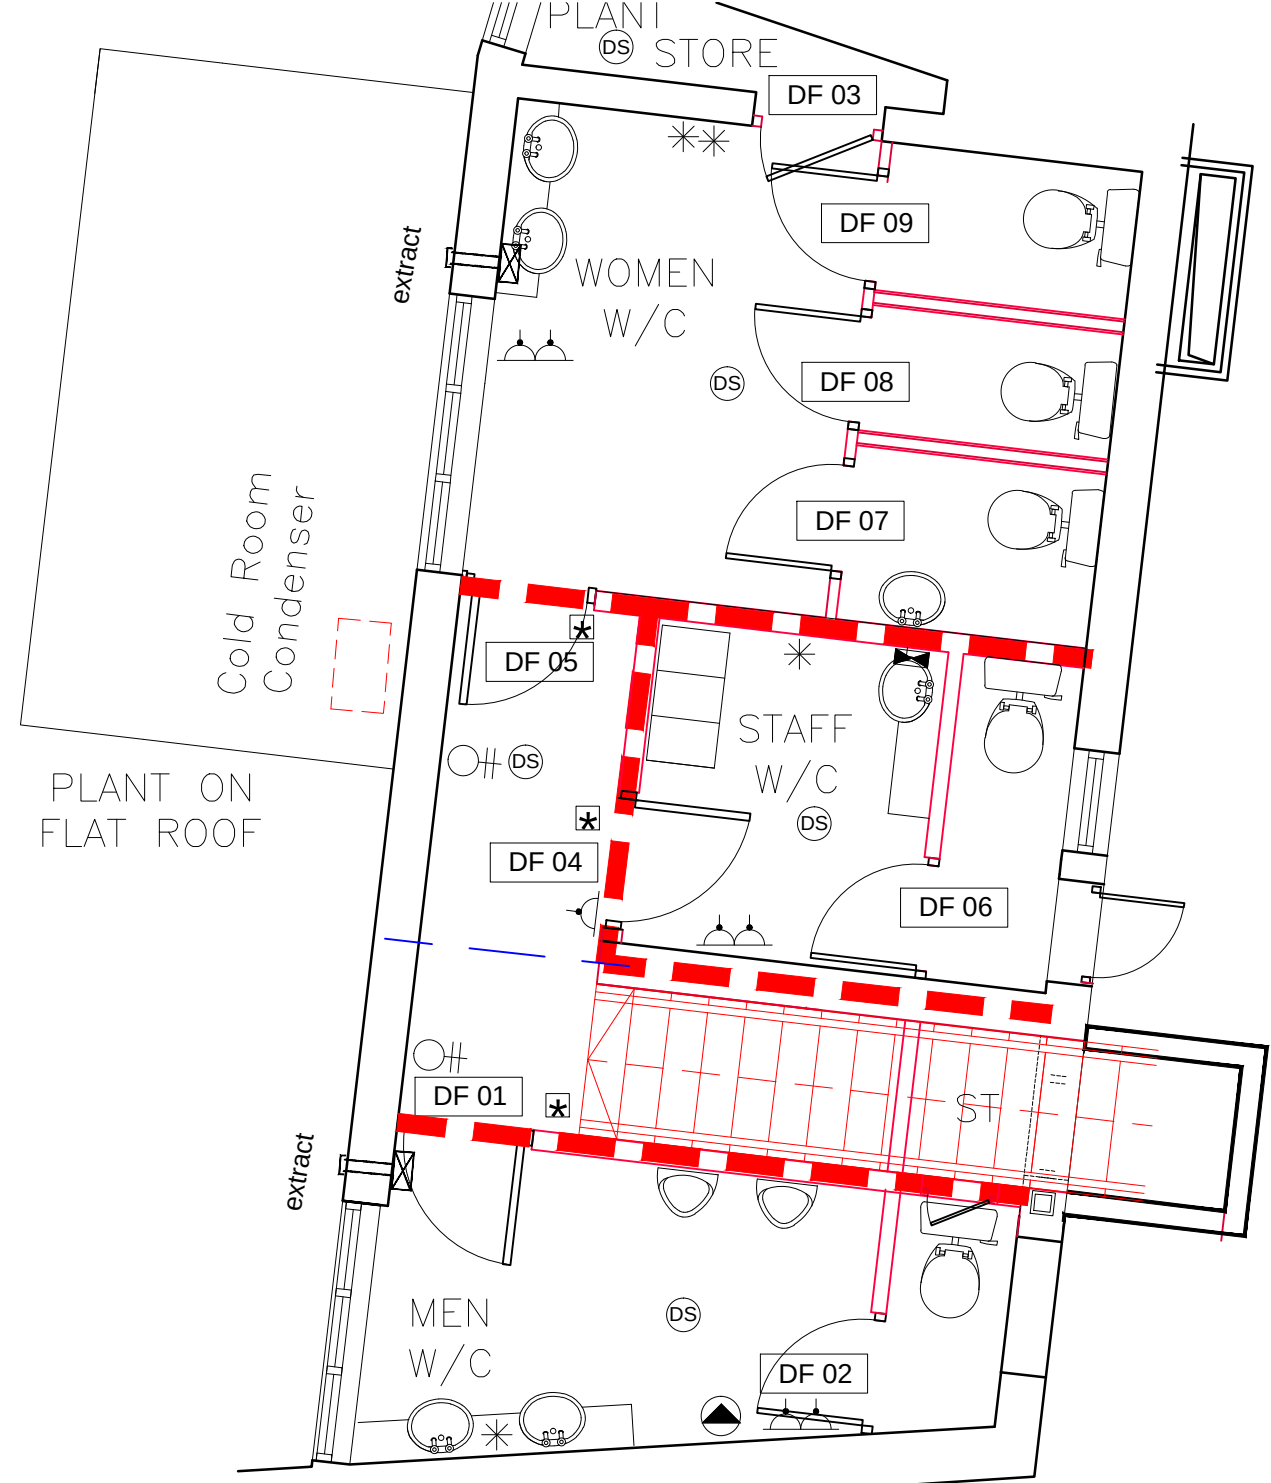


- 0 1 5 10m
- Move rwp... check direction of run... if under extension then relocate rwp
- Existing walls
 - Existing walls to be removed
 - New walls masonry/conc block
 - New walls engineering brick piers
 - New walls stud
 - New structural stud walls

Electrical Symbols Legend	
	Consumer unit
	Electric meter box
	Pendant light fitting denotes efficient lighting
	Batten holder fixing
	External light fitting mounted 1950 above f.f.l.
	Feature downlighter IP Rated in canopy
	Light switch 1 way, 1 gang mounted 1050 above f.f.l.
	Light switch 2 way, 1 gang mounted 1050 above f.f.l.
	Light switch 2 way, 2 gang mounted 1050 above f.f.l.
	Dimmer switch mounted 1050 above f.f.l.
	Fan isolator switch mounted 2100 above f.f.l.
	Fan Booster switch mounted 1050 above f.f.l.
	Single switched socket outlet 13A mounted 450 above f.f.l.
	Twin switched socket outlet 13A mounted 450 above f.f.l.
	High Level Twin switched socket outlet 13A mounted 1050 above f.f.l.
	High Level Twin switched IP Rated socket outlet 13A mounted 1800 above f.f.l.
	blanked off power point for future use mounted 1650 above f.f.l.
	Clean DSO for Data Equipment
	Data Points mounted 1050 above f.f.l.
	Television coax aenal socket mounted 450 above f.f.l.
	Smoke detector
	Shaver socket no light mounted 1050 above f.f.l.
	Ceiling mounted fan
	Telephone point mounted 450 above f.f.l.
	Recessed downlighter with intumescent cover
	Directional 'intimacy' lights
	Column mounted uplighters
	Recessed downlighter with intumescent cover
	Fluorescent strip lights - general lighting 1200mm
	Moisture Resistant Recessed downlighter with intumescent cover
	Wall mounted light fitting mounted 1950 above f.f.l.
	20 amp. supply
	indicative position of radiator, exact location & quantity to be determined by H&V engineer
	Bell sounder
	LED strip rope lights
	Bell push
	Alarm Control Panel Position (wiring only)
	Alarm keypad Position (wiring only)
Note dimensions shown are to u/s of electrical plate	

DEMISE 370m²

 
OCCUPANCY
LOUNGE 30 people
BAR 60 people
STAFF 10 people
100 total

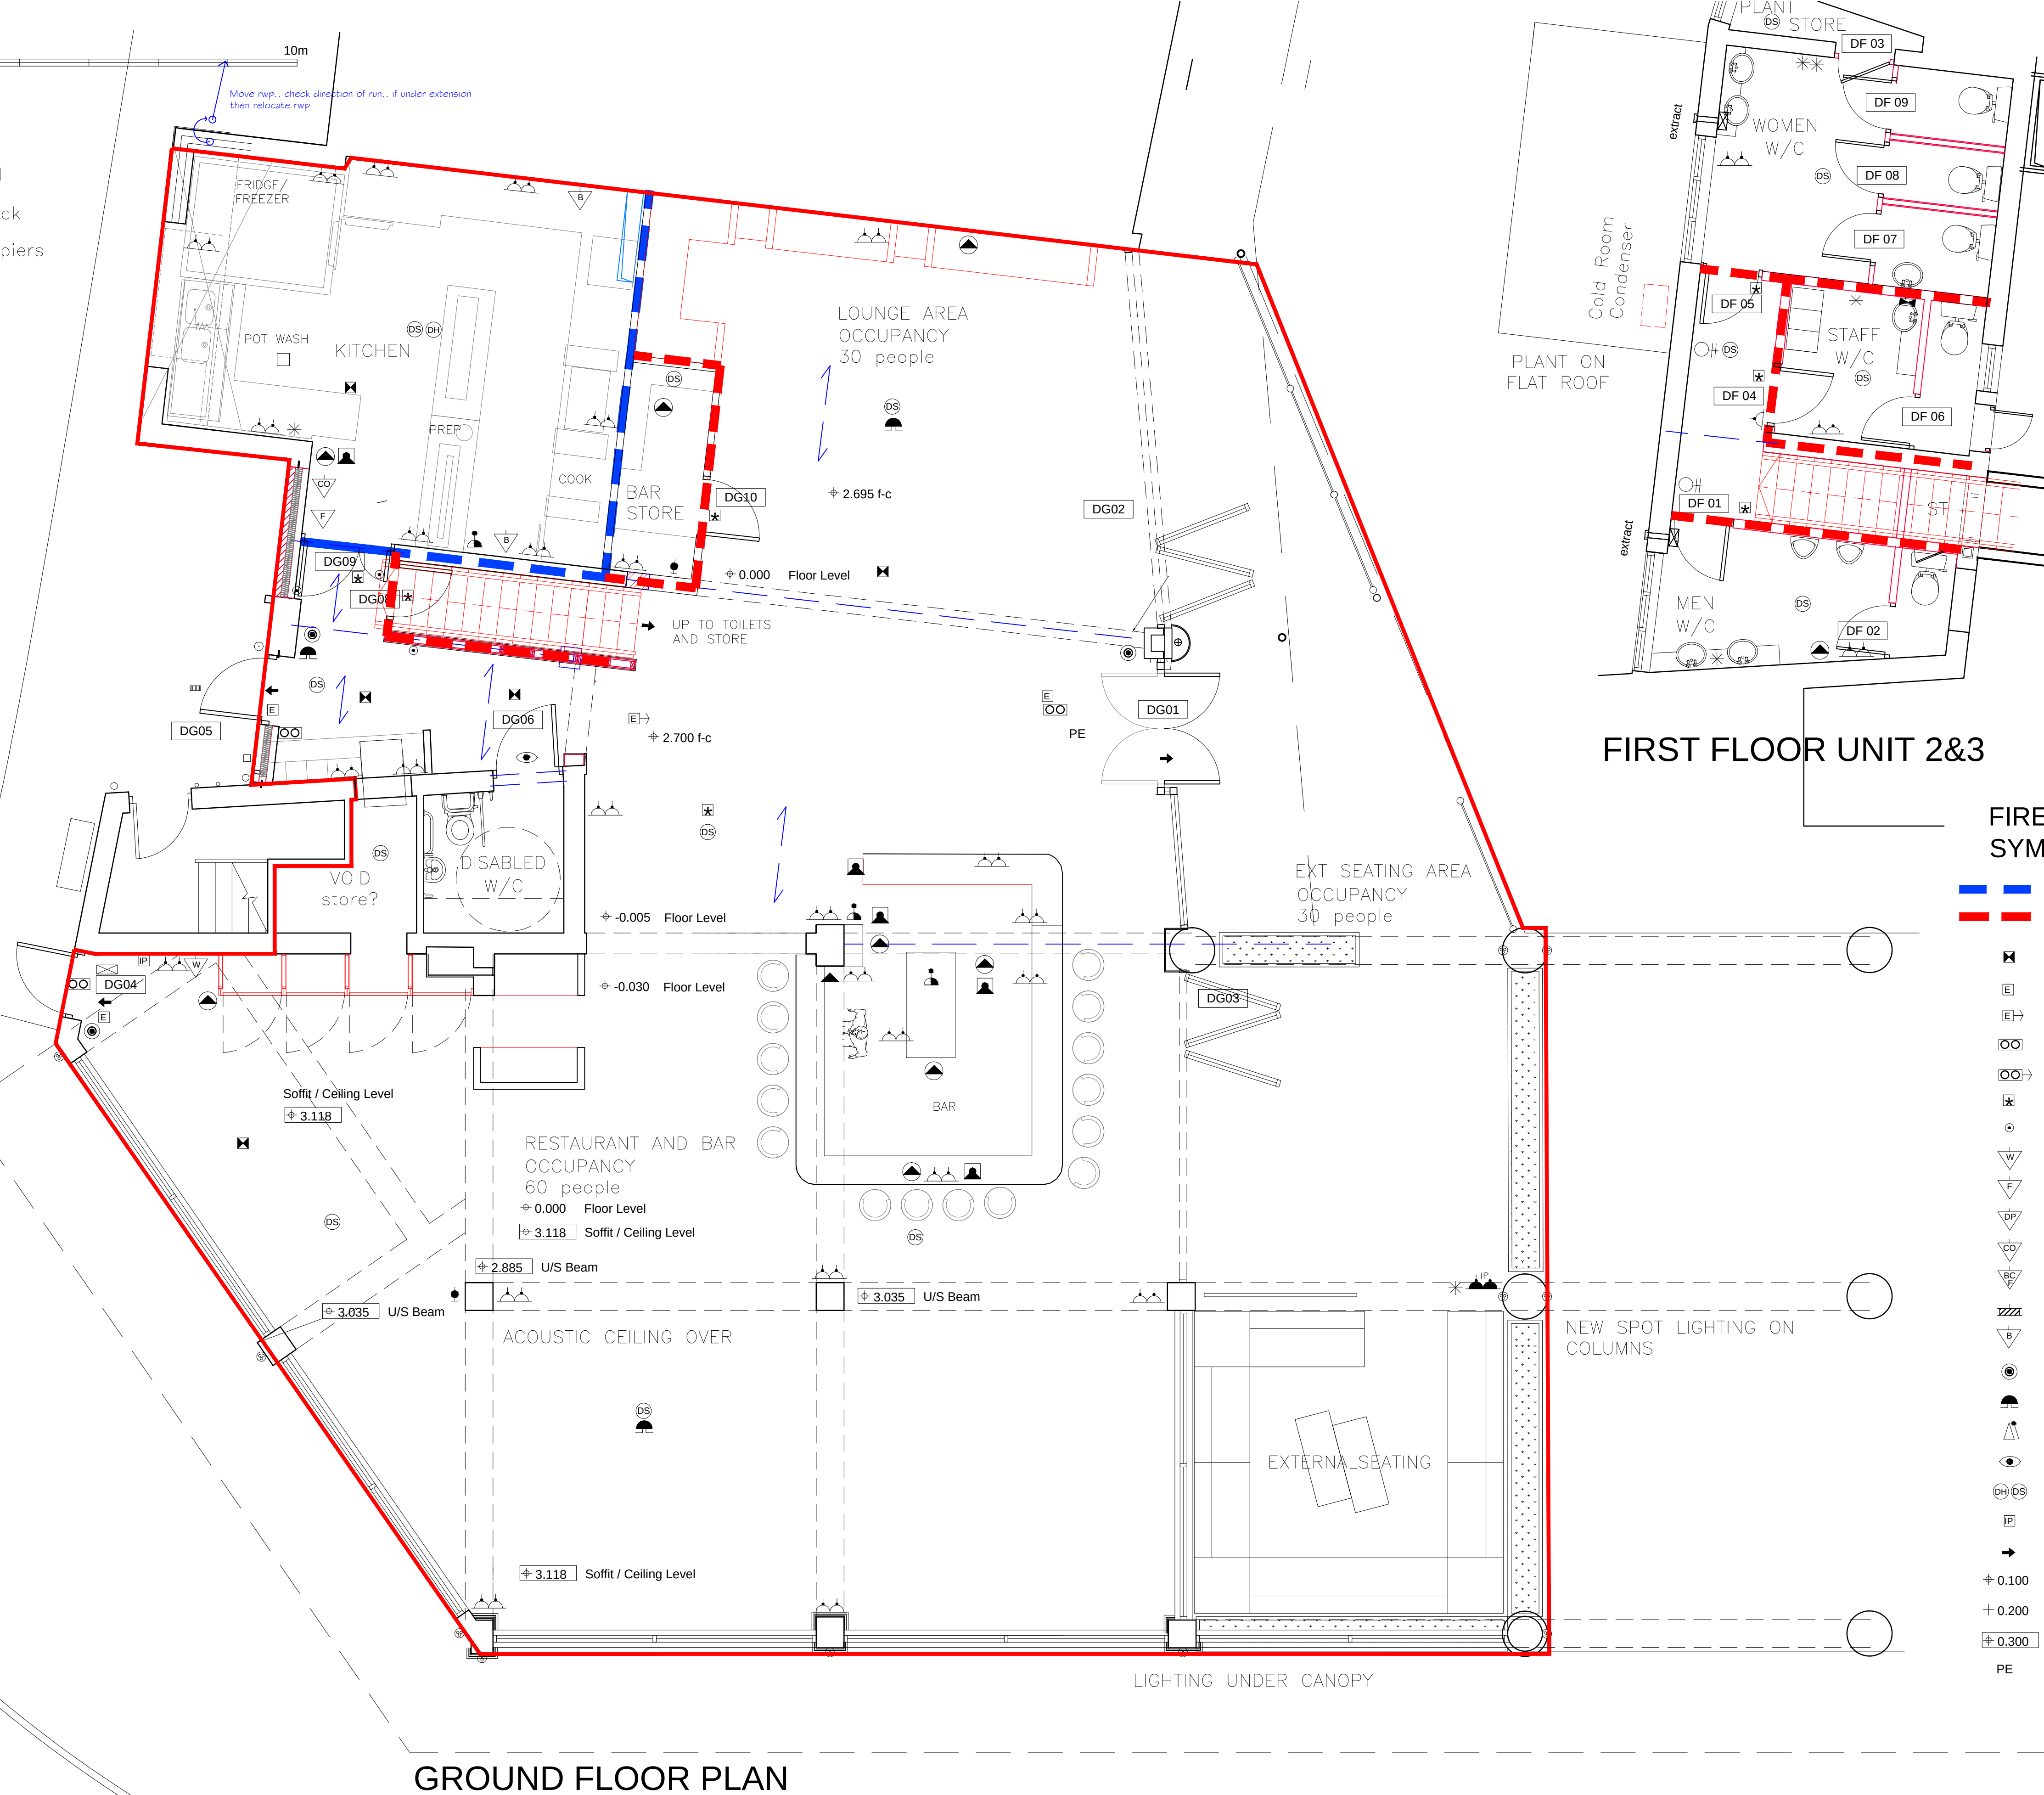

FIRE PRECAUTIONS SYMBOLS LEGEND

- 1 hour fire rated walls
- 1/2 hour fire rated walls
- Emergency Lighting Point
- "Fire Exit" sign
- "To Fire Exit" directional signs
- Illuminated "Exit" sign boxes
- Illuminated "Exit" directional sign boxes
- Fire Door with smoke seal
- Hold open device linked to L1 System
- Fire extinguisher - water type
- Fire extinguisher - foam type
- Fire extinguisher - dry powder type
- Fire extinguisher - carbon dioxide type
- Fire extinguisher - vapour liquid type
- Hose reel
- Fire blanket(s)
- Fire alarm call point
- Audible warning device
- Manual fire alarm sounder
- Visual warning device
- Automatic fire detector - heat/smoke
- Fire alarm indicator panel
- Escape Route
- + 0.100 Floor Level
- + 0.200 Above Floor Level
- + 0.300 Soffit / Ceiling Level
- PE Principle Entrance

notes:



NOTE: The contractor is responsible for checking all site dimensions and levels. These should be checked prior to the ordering of any components and before the commencement of the works. All discrepancies should be brought to the attention of the Contract Administrator

revisions: | 06.02.2009 |

revisions:

1-3 North Street Arcade
Grastar
Havant

drawing information

status:
date:
scale:
drawn by:
chk'd by:

FLOOR PLANS
GENERAL ARRANGEMENT
BUILDING REGULATIONS
October 15
1:50 @ A1
SL

pwparchitects

PWP Architects Ltd 61 South Street, Havant, Hampshire PO9 1BZ
t: 02392 482494 f: 02392 481152
e: design@pwp-architects.com
w: www.pwp-architects.com

job: 5193 dwg: 1200 rev: L