


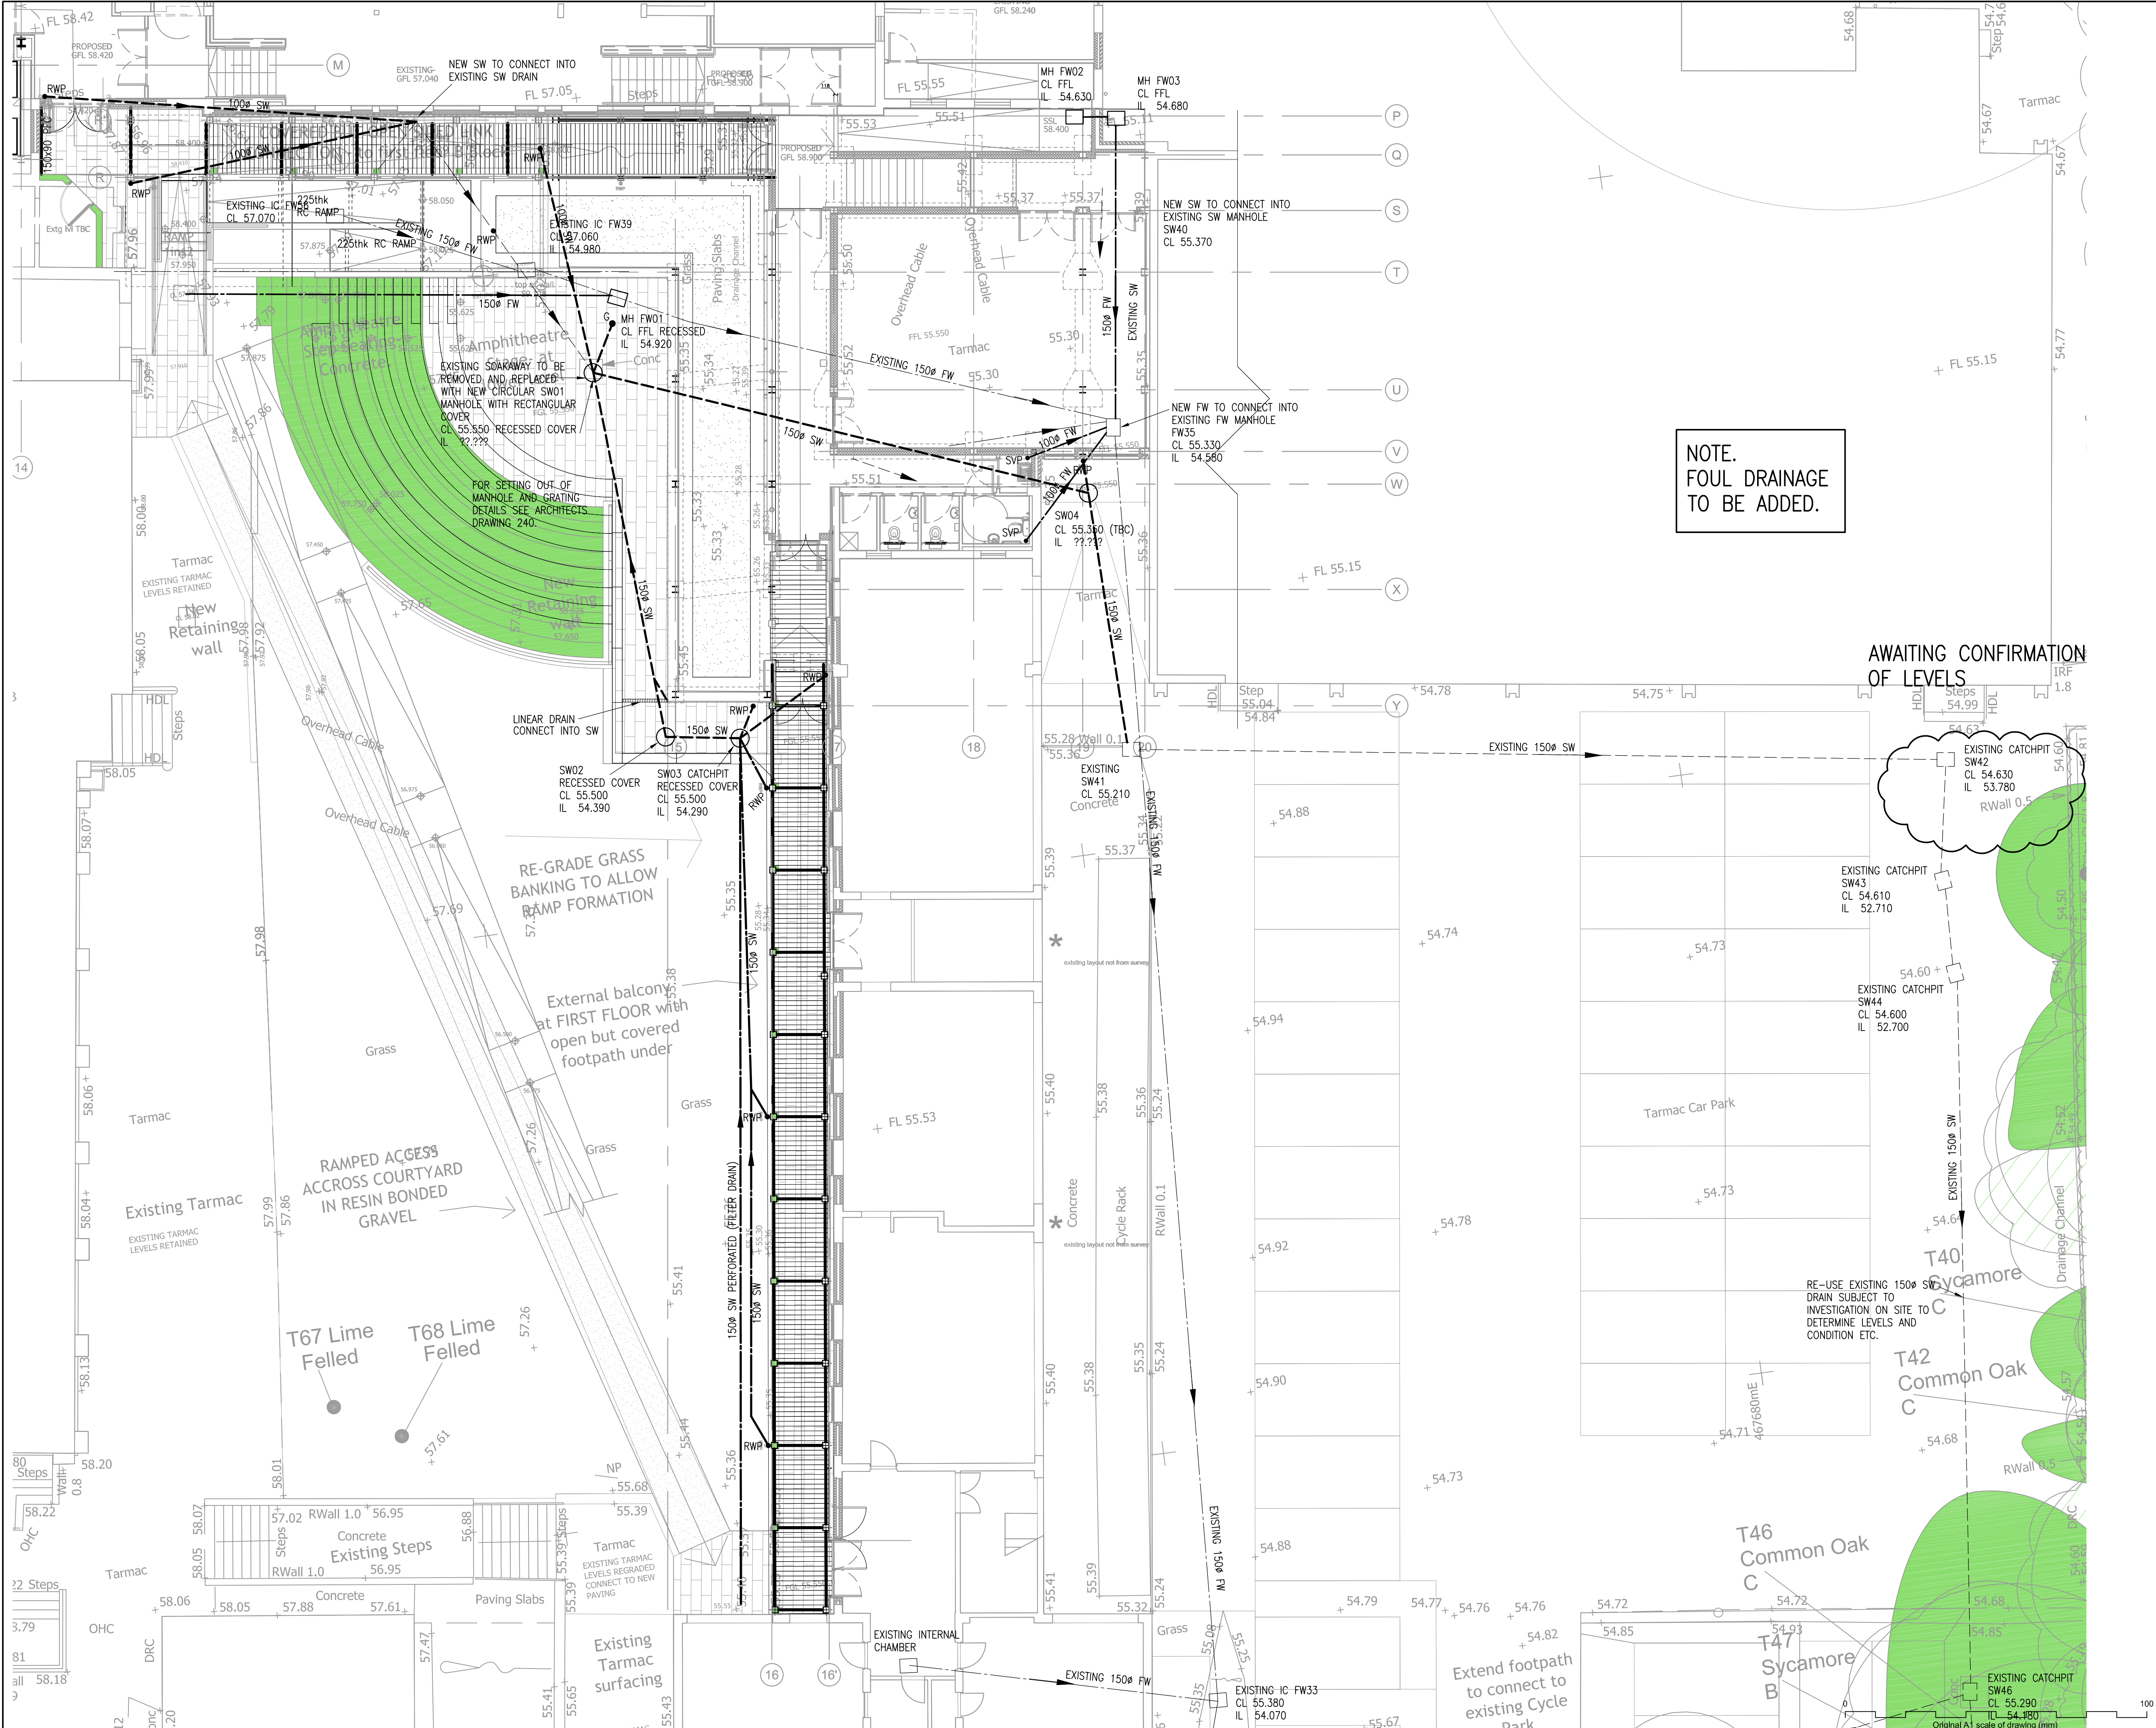

- Notes
1. THIS DRAWING IS COPYRIGHT & MUST NOT BE DISCLOSED TO THIRD PARTIES WITHOUT OUR PERMISSION.
 2. SCALED DIMENSIONS ARE NOT TO BE USED FOR CONSTRUCTION.

ISSUED FOR CONSTRUCTION

C4	12.08.16	MPE	DRAINAGE REVISED
C3	05.08.16	MPE	FW DRAINAGE ADDED
C2	29.07.16	MPE	DRAINAGE UPDATED
C1	24.07.16	MPE	CONSTRUCTION ISSUE
P1	15.07.16	MPE	PRELIMINARY FOR COMMENT

Project
PURBROOK PARK SCHOOL
REDEVELOPMENT

BLOCK B
DRAINAGE LAYOUT
SHEET 1



RJWatkinson
Consulting Civil and Structural Engineers
12 High Street, Lyndhurst,
Hampshire SO43 7BD
t: 023 8028 3794
e: rjwptrs@rjwatkinson.co.uk
www.rjwatkinson.co.uk

Drawn MPE	Date JUL 2016	Scale 1:100	Size A1
Drawing No. 10225-50	Revision C4		