


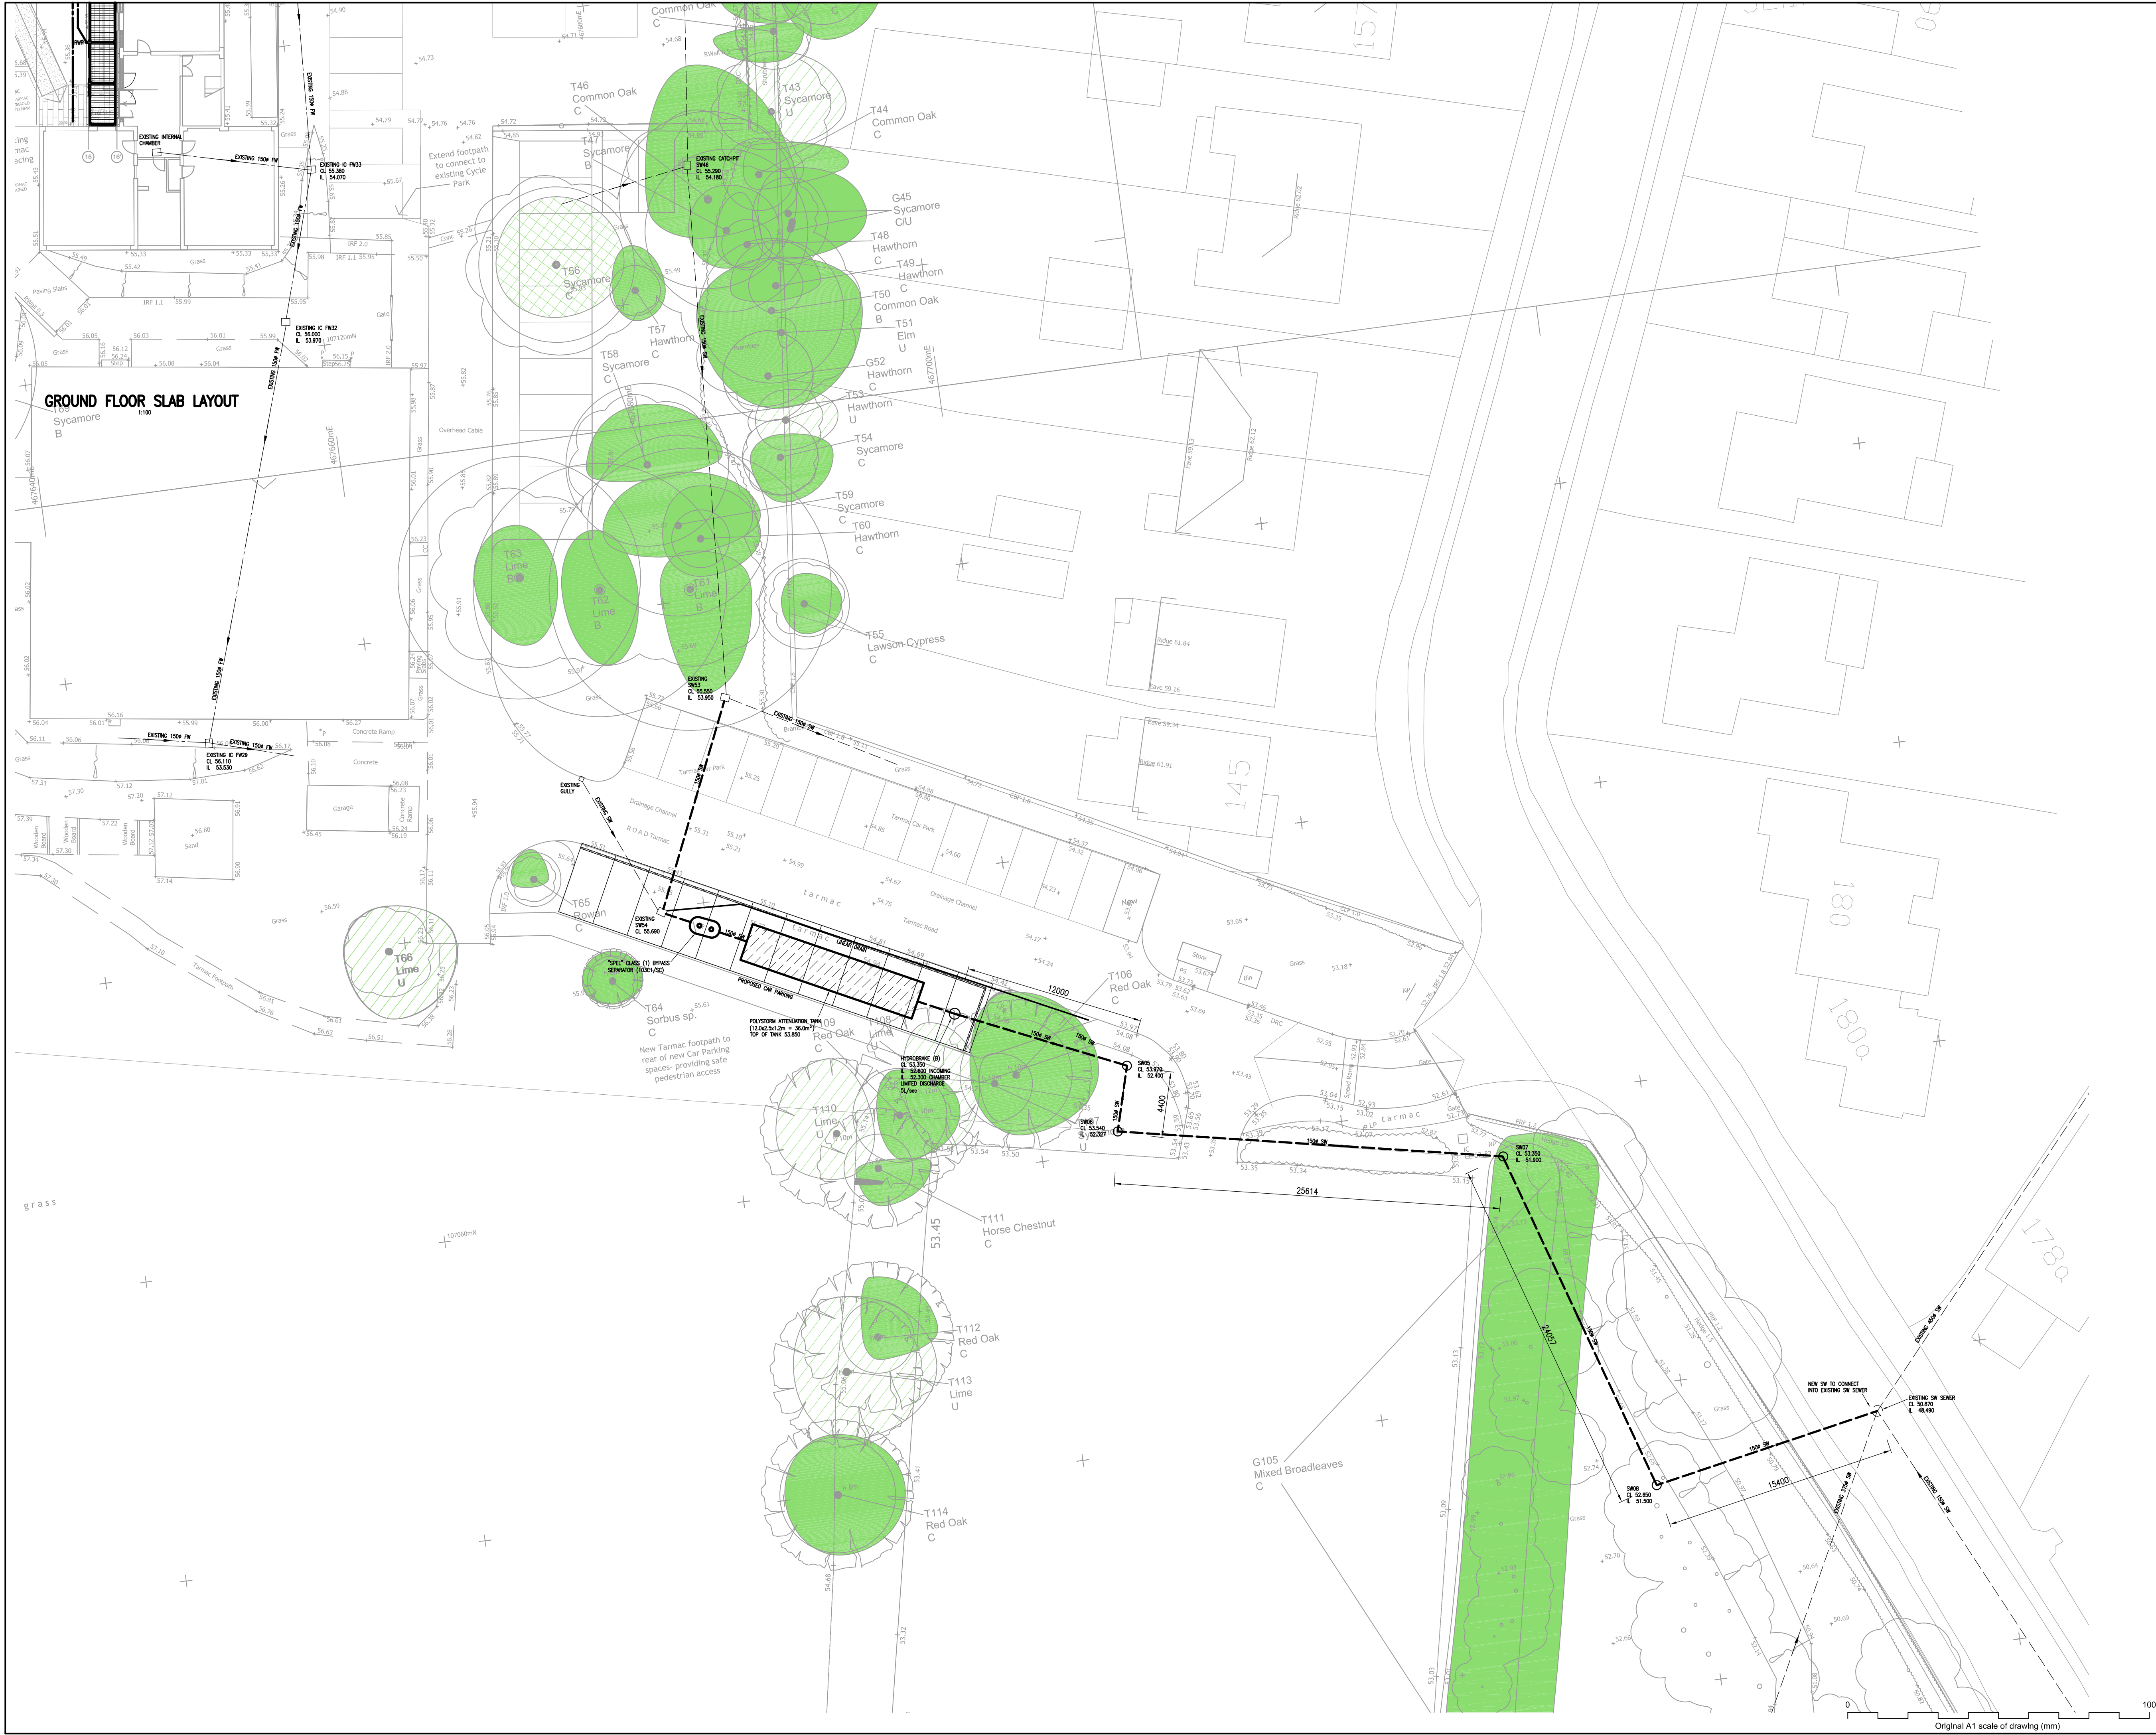

Notes

1. THIS DRAWING IS COPYRIGHT & MUST NOT BE DISCLOSED TO THIRD PARTIES WITHOUT OUR PERMISSION.
2. SCALED DIMENSIONS ARE NOT TO BE USED FOR CONSTRUCTION.

ISSUED FOR CONSTRUCTION

C4	05.08.16	MPE	FW DRAINAGE ADDED. DRAWING SCALE REVISED.
C3	03.08.16	DEF	AS CLOUDED
C2	29.07.16	MPE	DRAINAGE UPDATED
C1	24.07.16	MPE	CONSTRUCTION ISSUE
P1	15.07.16	MPE	PRELIMINARY FOR COMMENT

rev.	date	dm	description

Project

PURBROOK PARK SCHOOL REDEVELOPMENT

BLOCK B DRAINAGE LAYOUT SHEET 2



RJWatkinson
Consulting Civil and Structural Engineers

12 High Street, Lyndhurst,
Hampshire SO43 7BD
t: 023 8028 3794
e: rjwptrs@rjwatkinson.co.uk
www.rjwatkinson.co.uk

Drawn	Date	Scale	Size
MPE	JUL 2016	1:200	A1

Drawing No.	Revision
10225-51	C4