
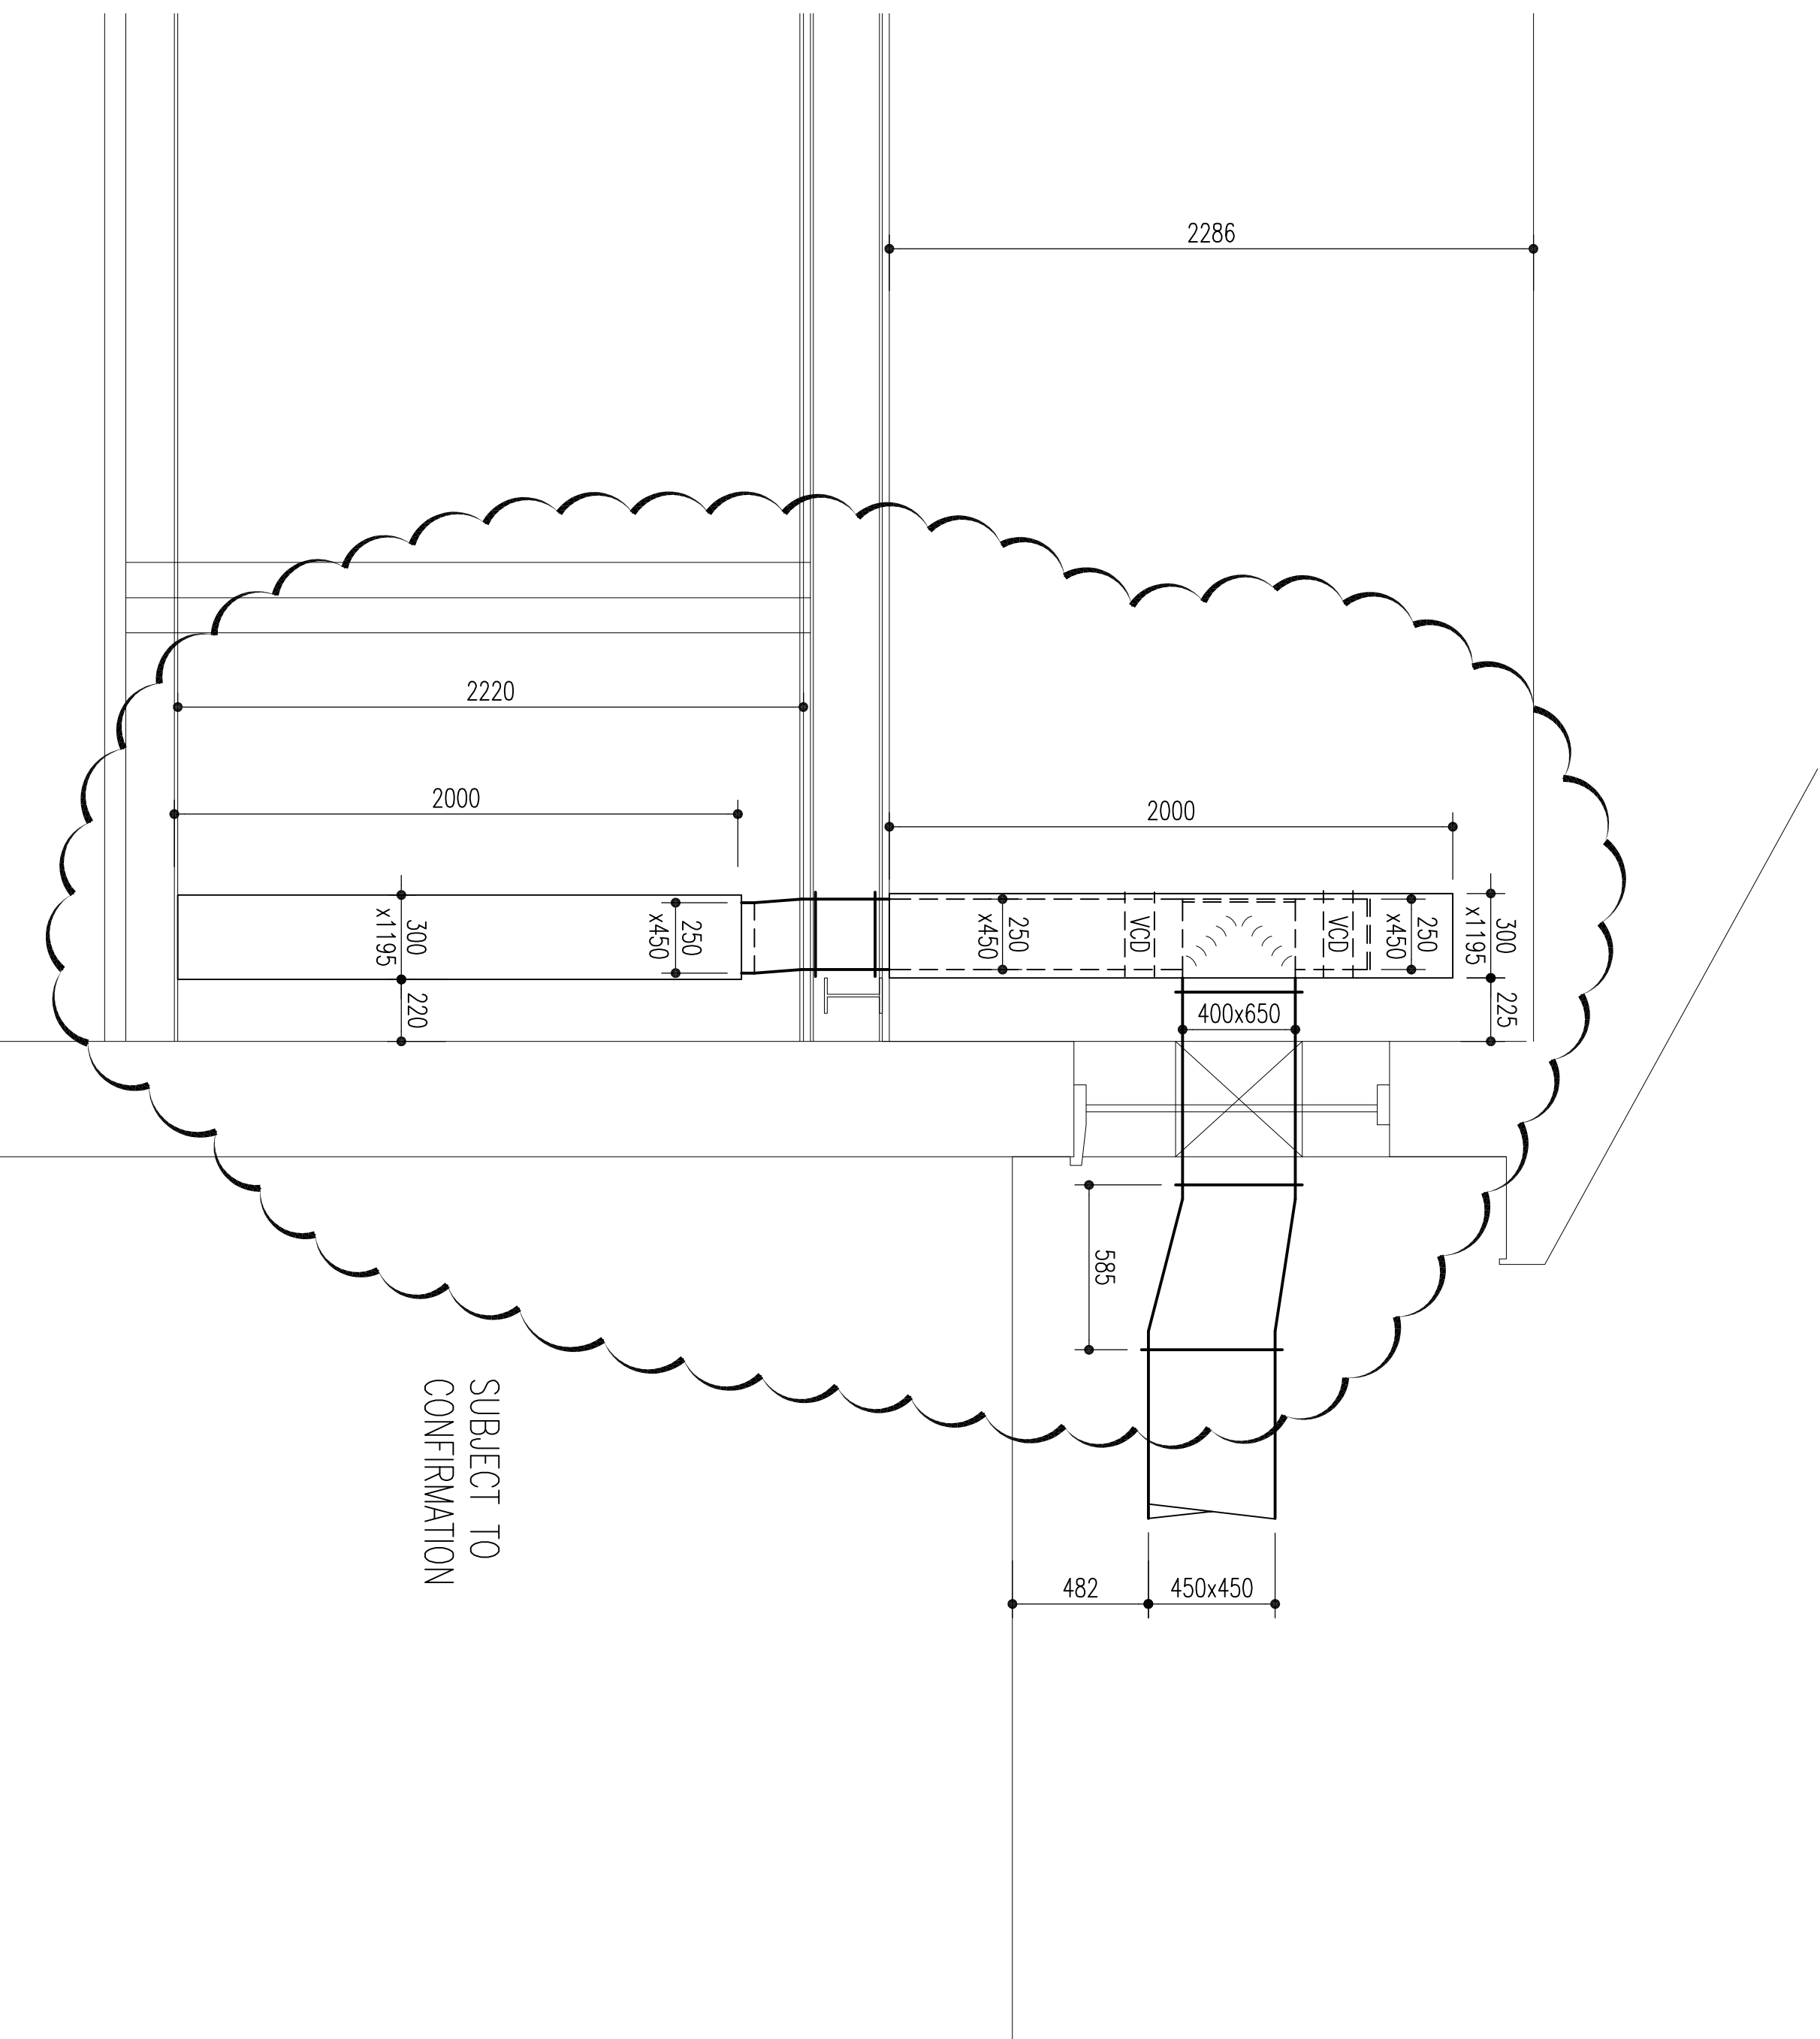
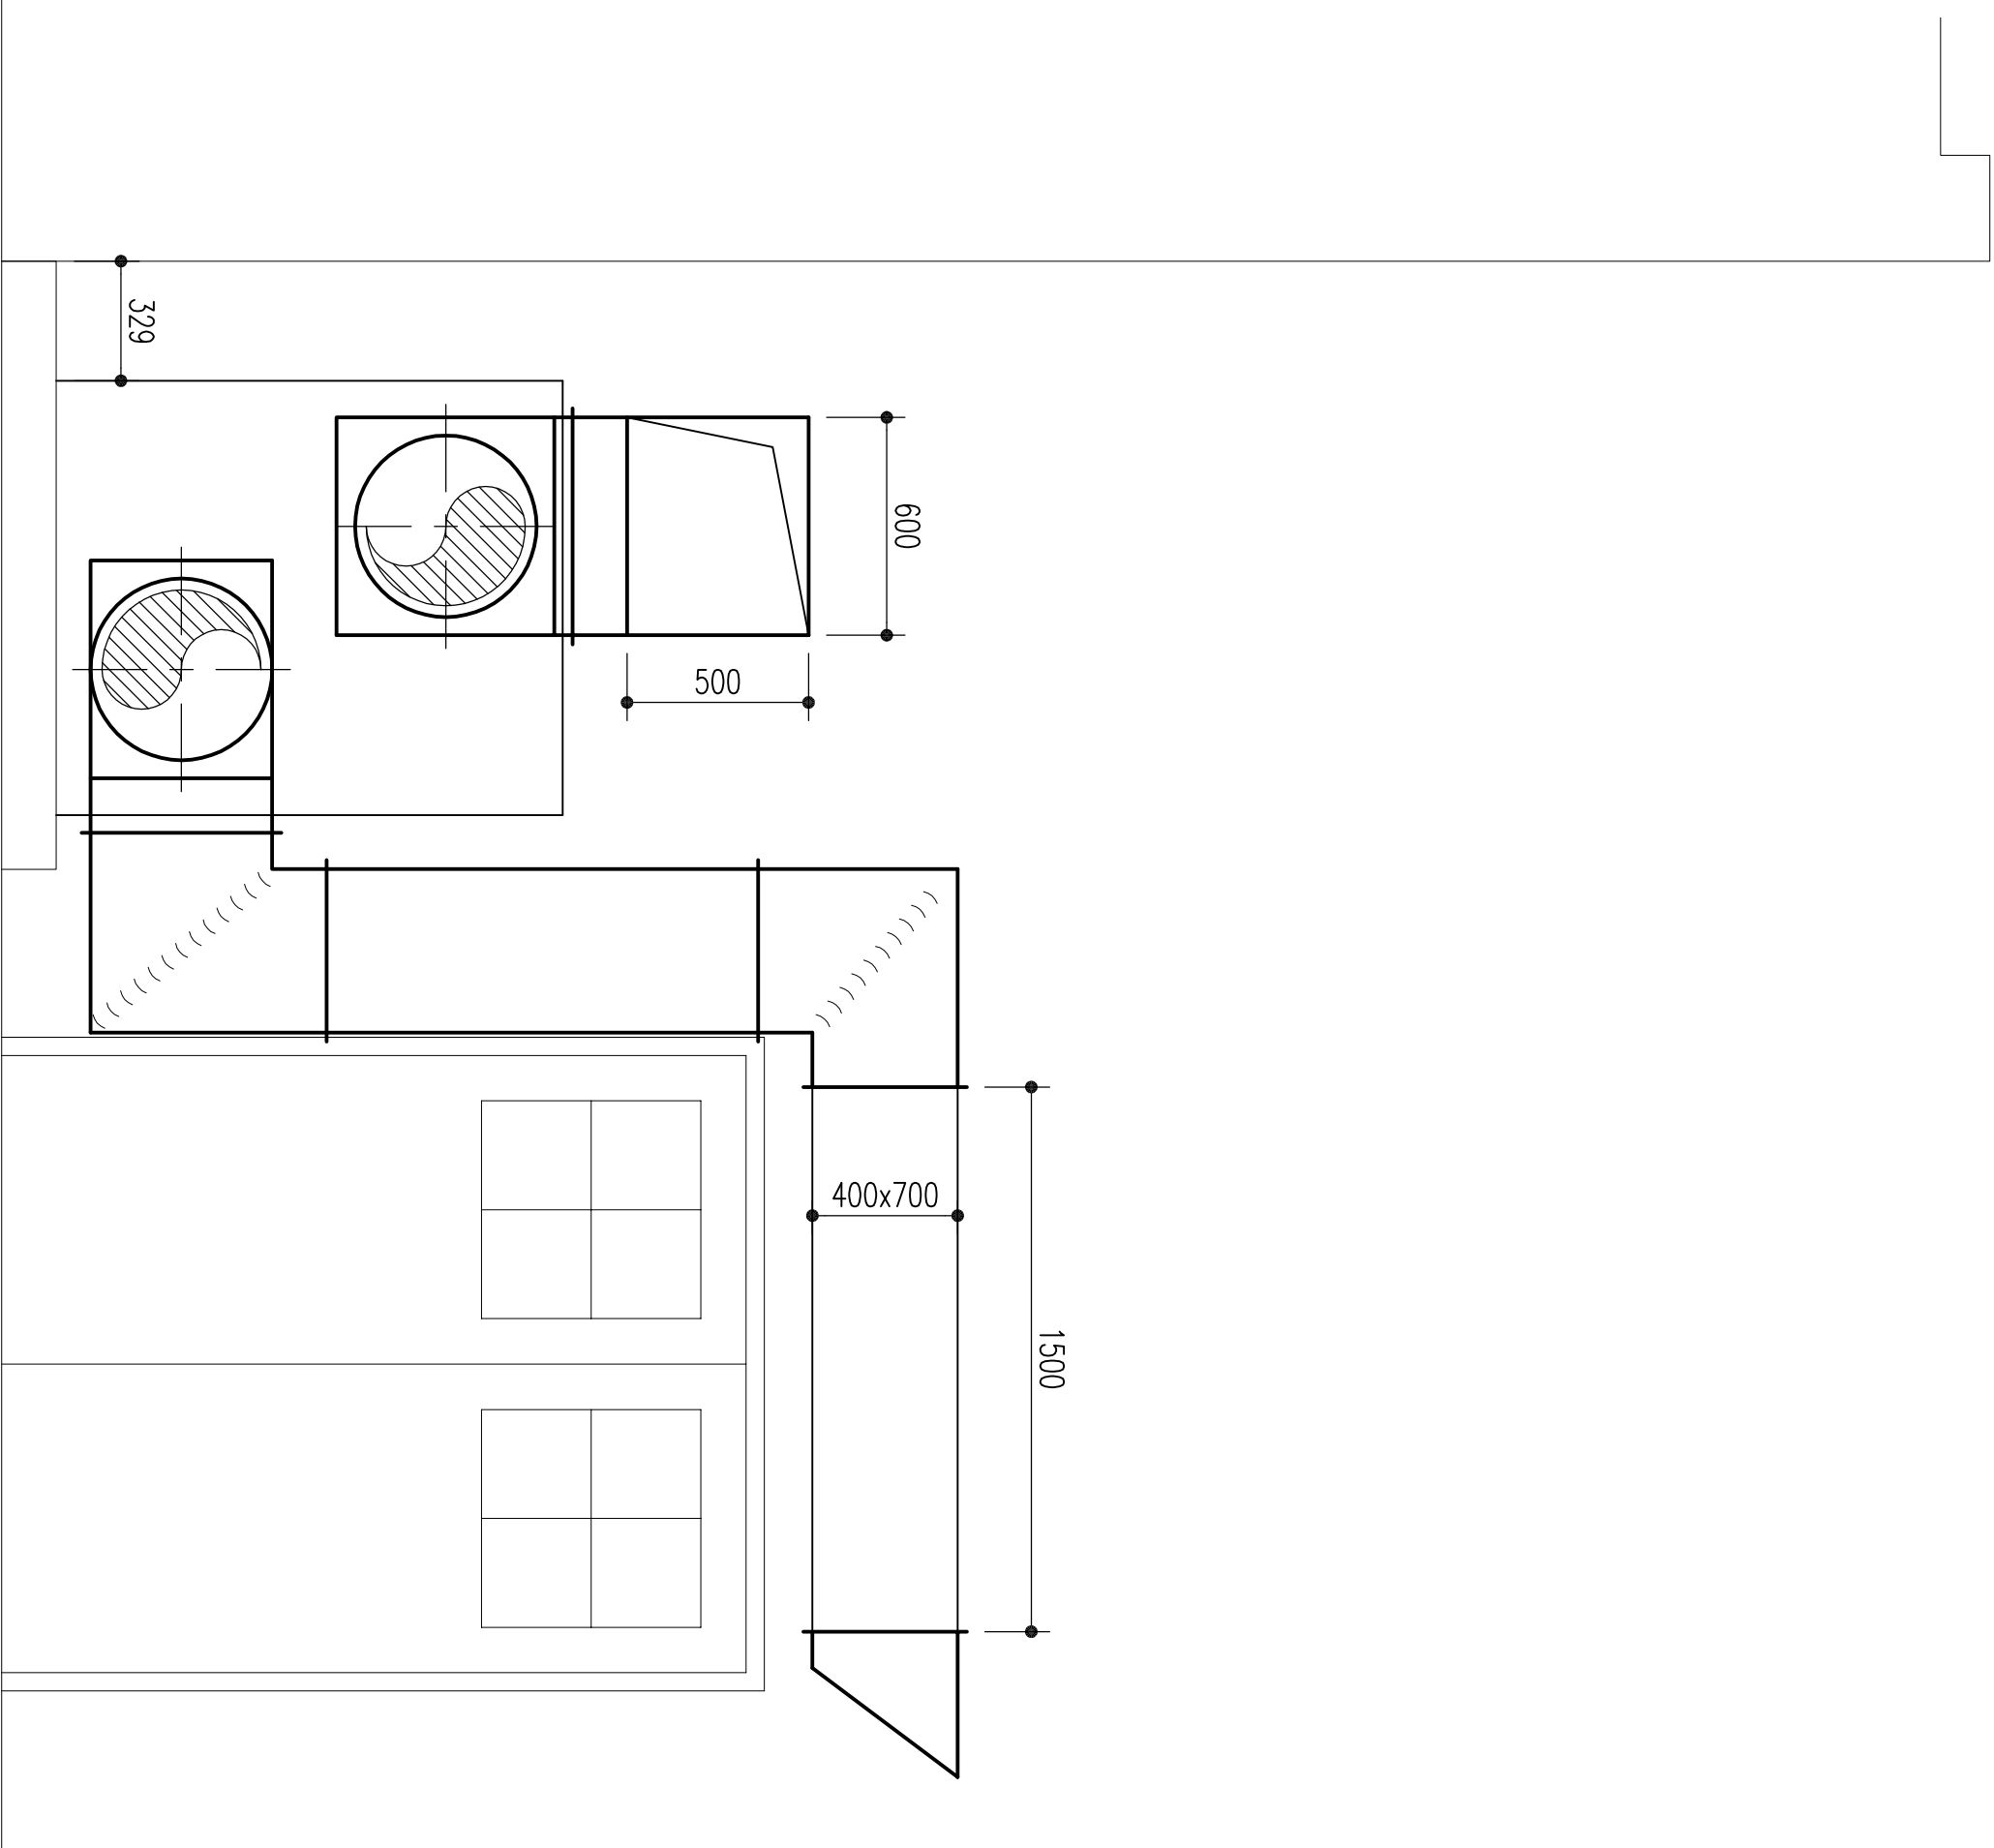
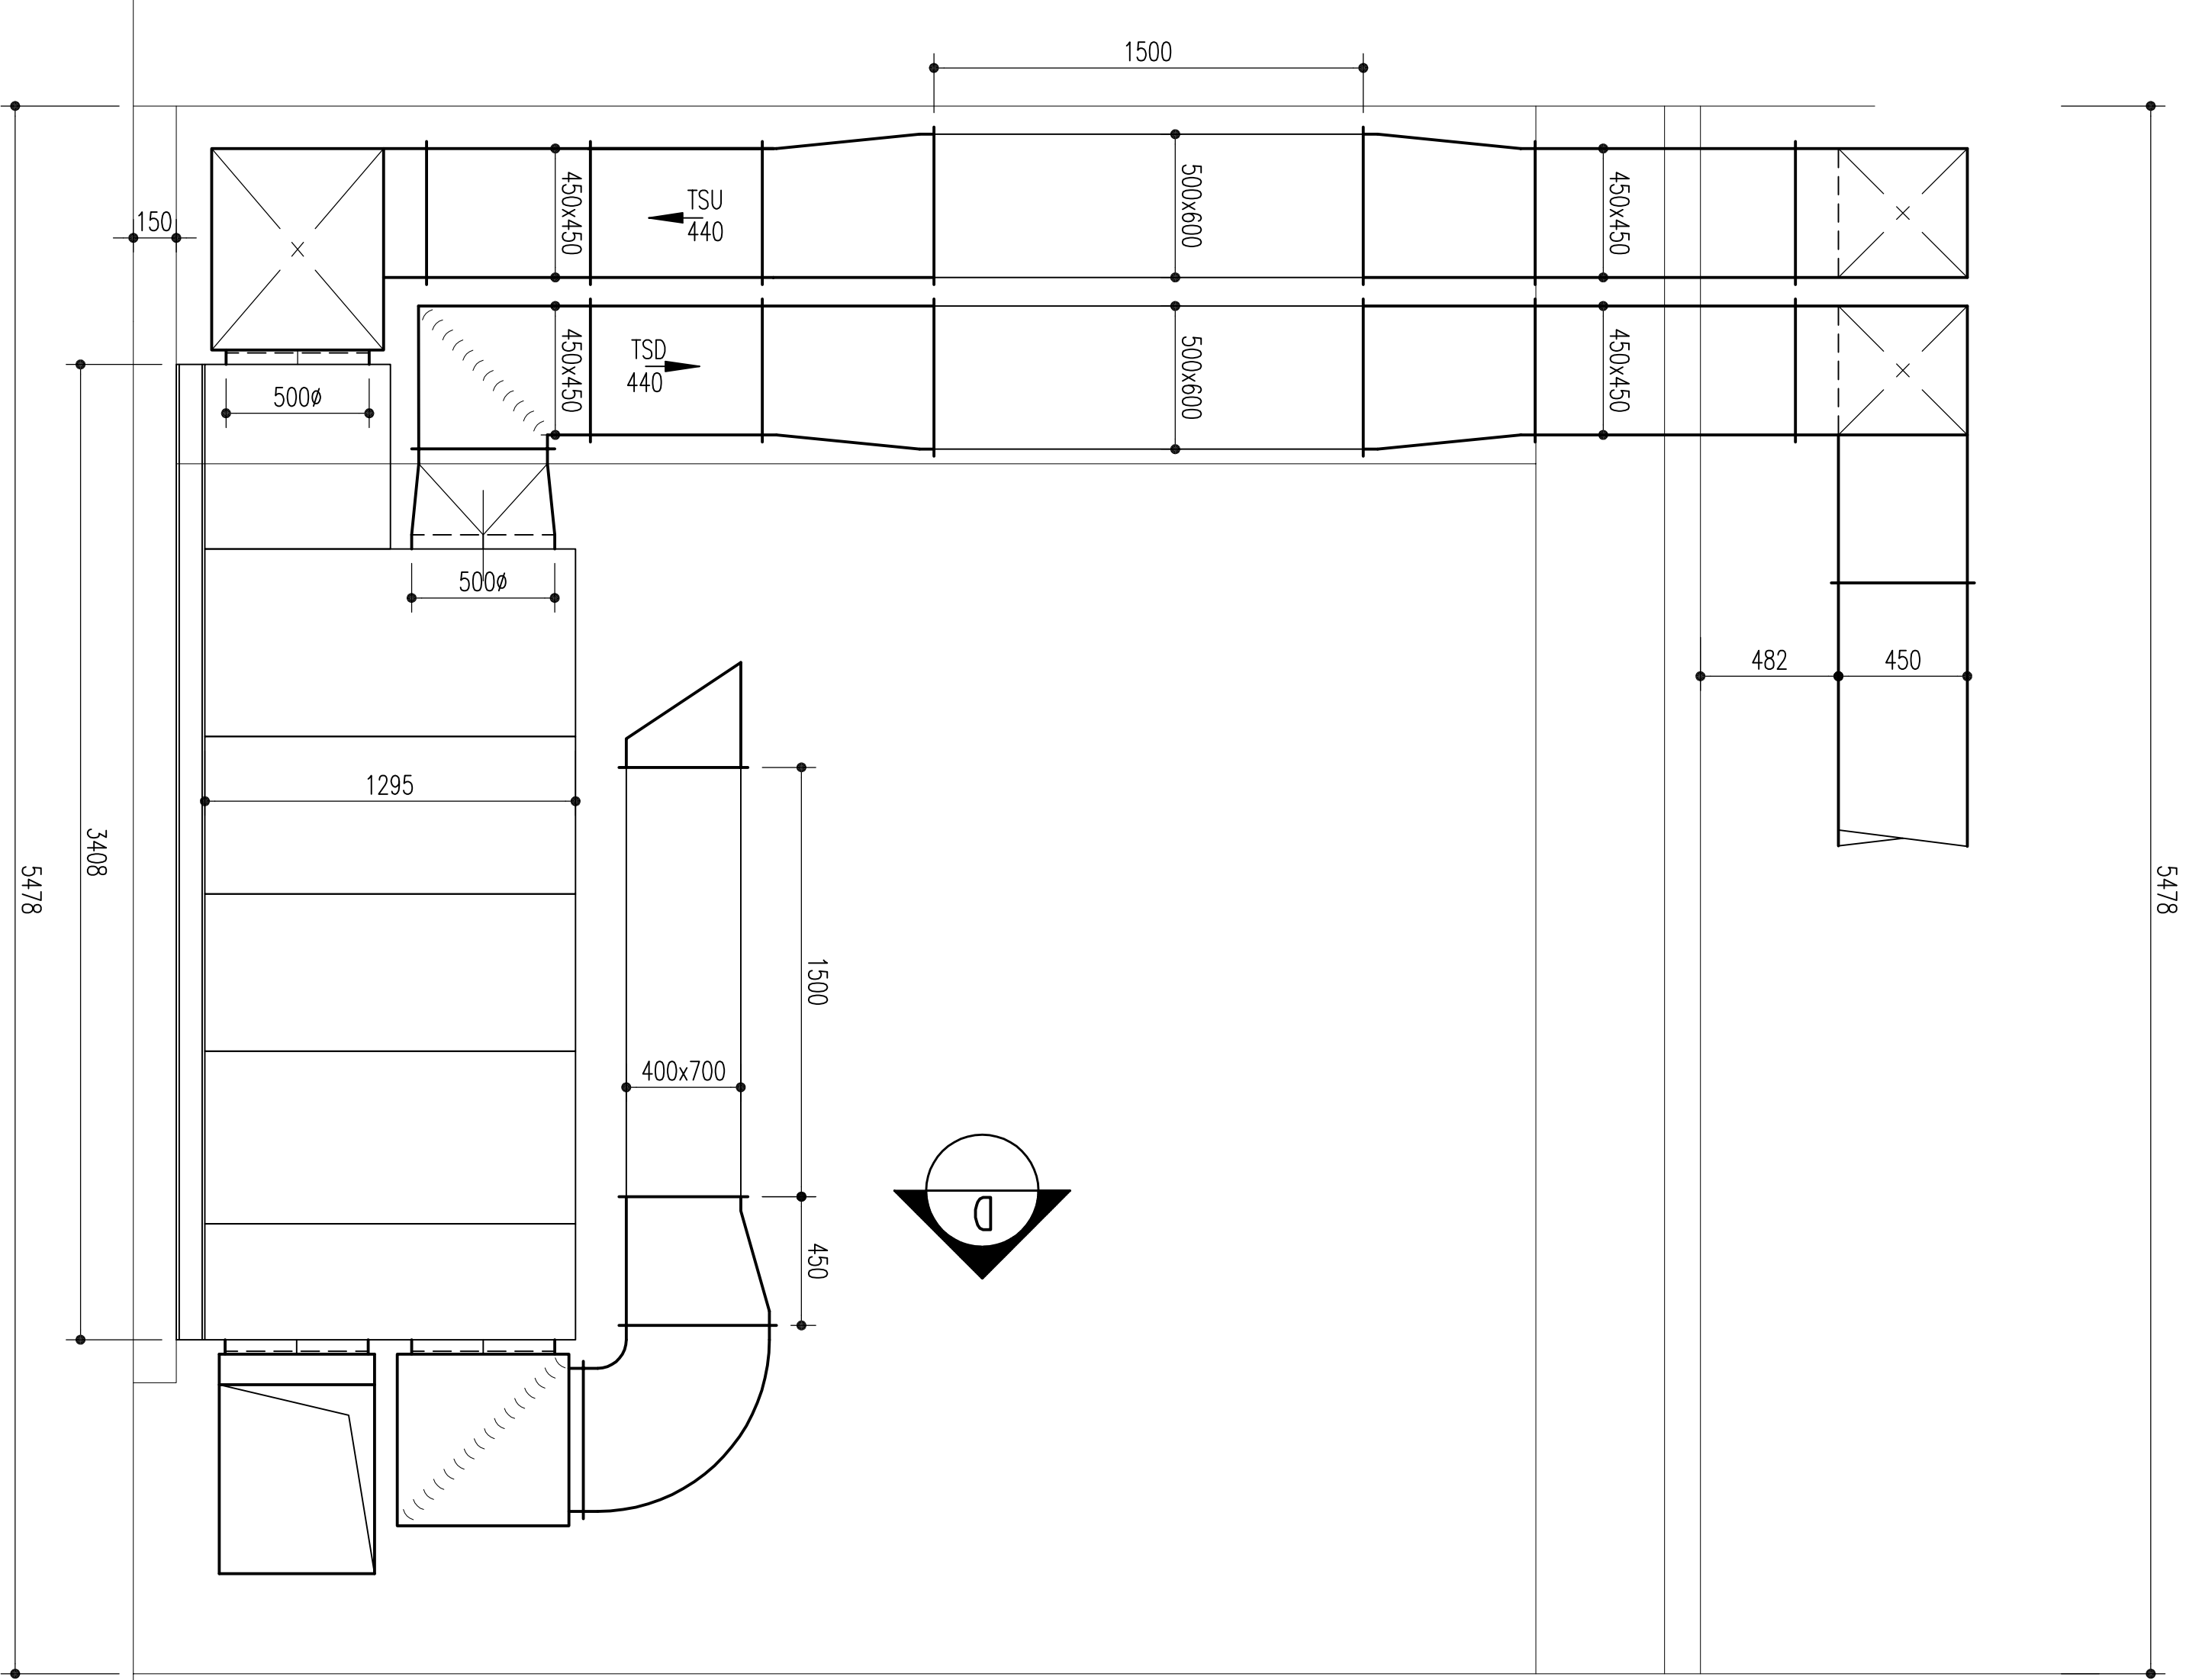


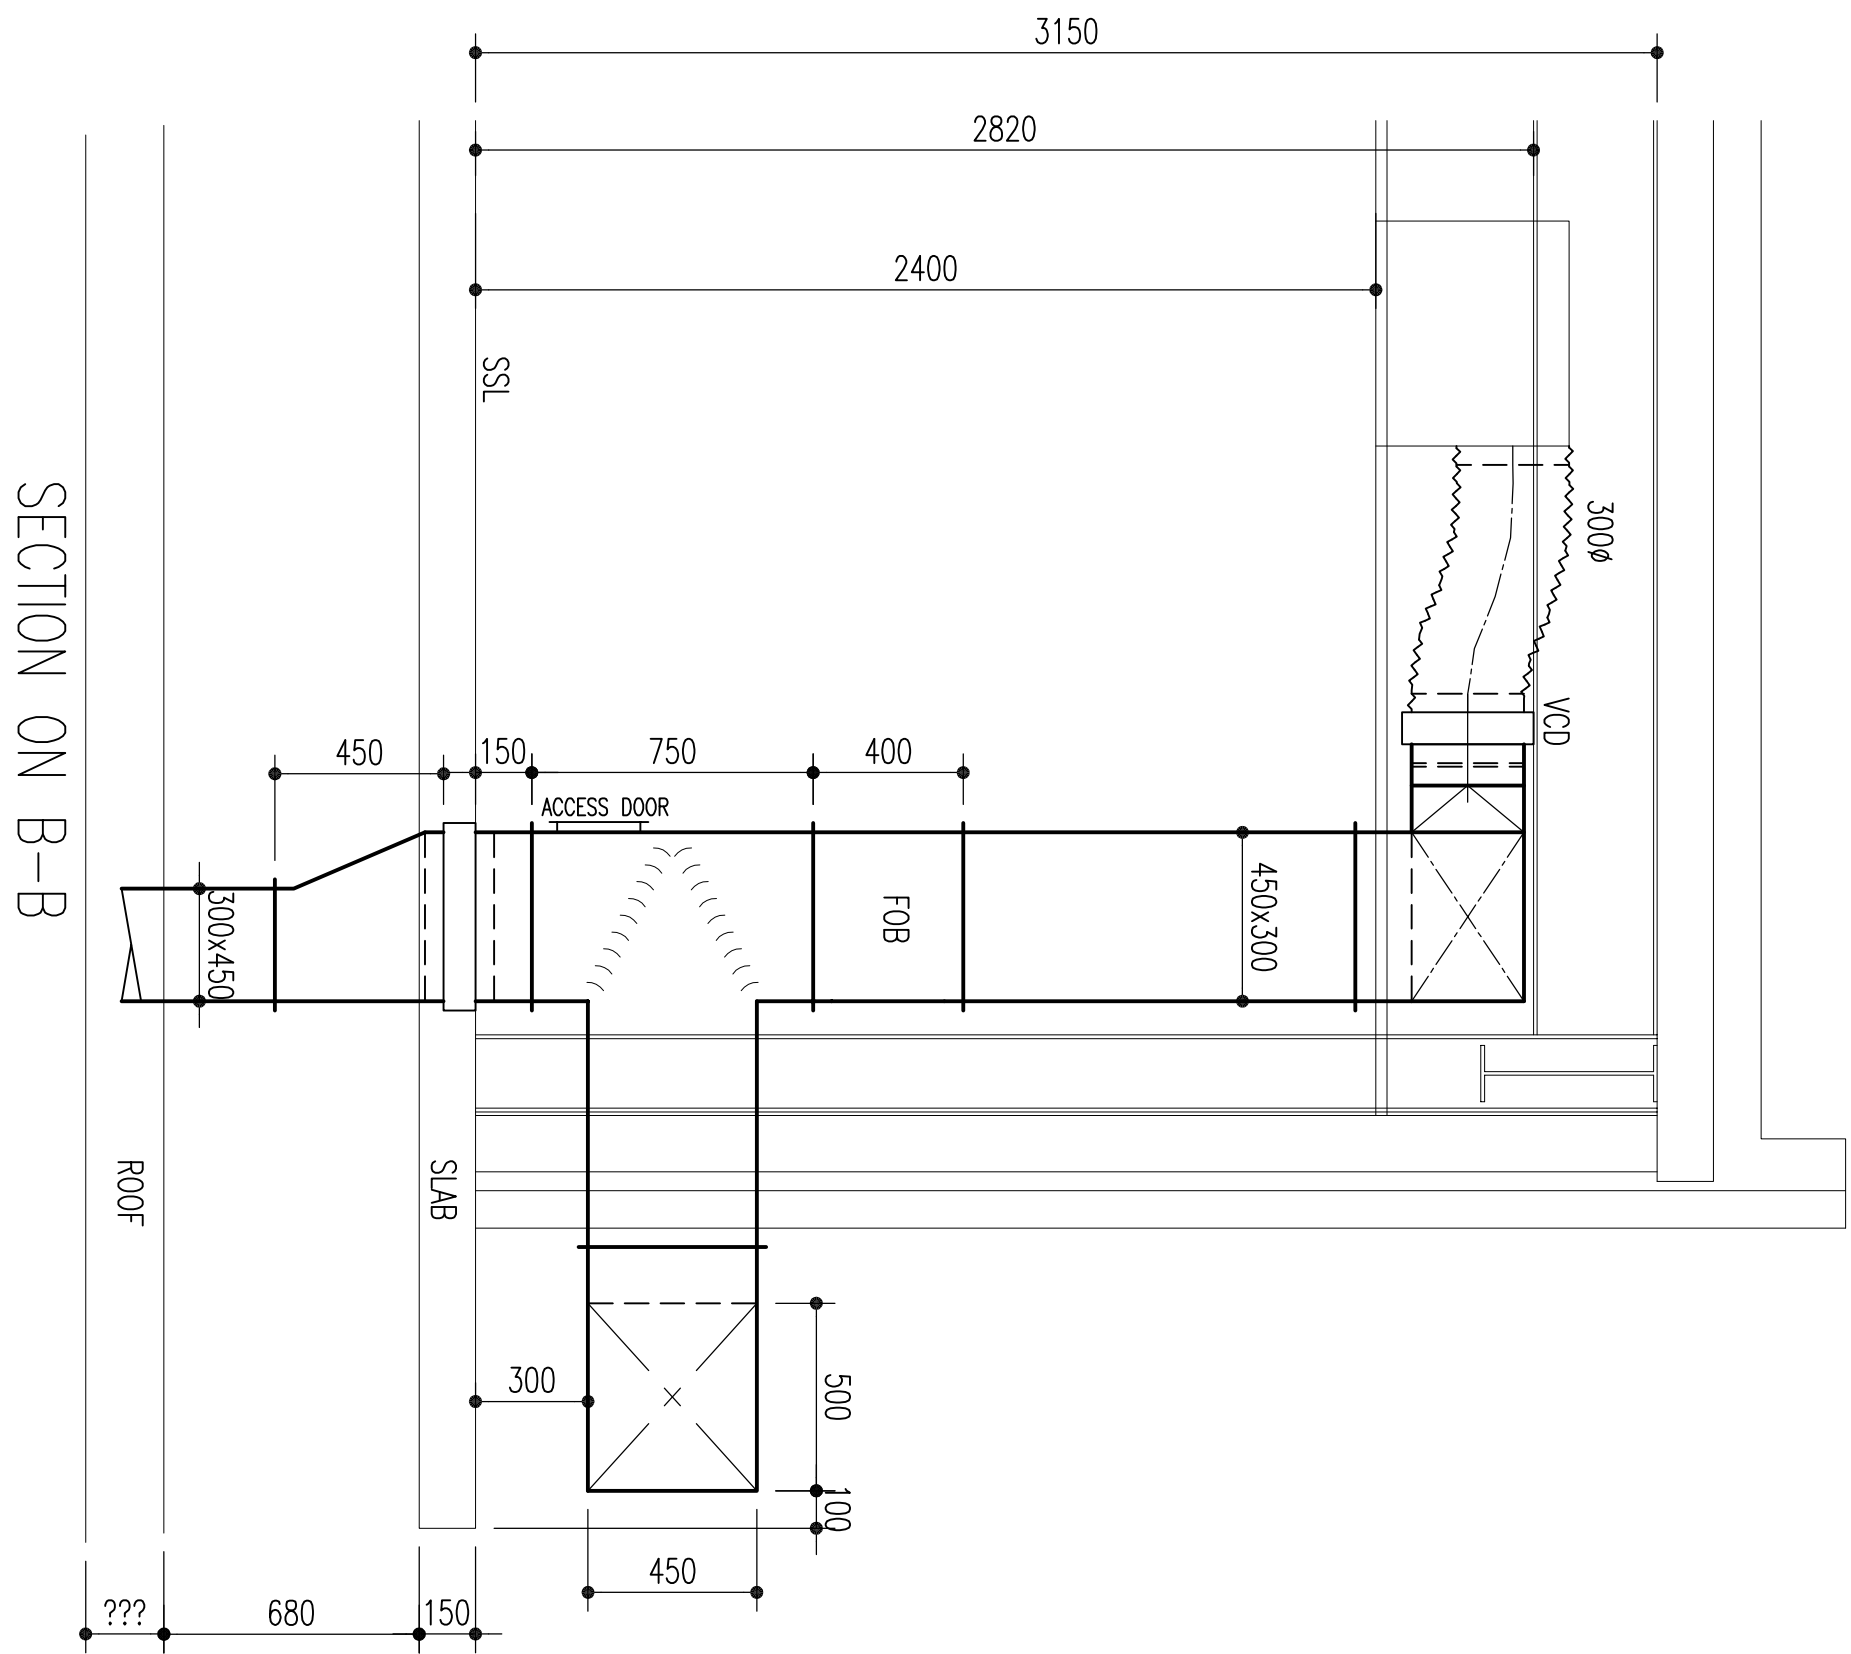

ALL DUCTWORK SUPPLIED AND
INSTALLED TO DW144 LOW VELOCITY

REV.	DRAWN	DATE	REVISIONS	NOTES	DRAWING PREPARED USING THE FOLLOWING	ABBREVIATIONS	SITE PLAN	DRAWING STATUS			
A	JTWINE	13-01-16	ATTENUATORS ADDED TO DINING HALL PLANT		#/REV	ATTENUATOR		PRELIMINARY	Tobel Sheepmista Ltd. PURBROOK SCHOOL PARK AVENUE, PURBROOK PO7 5DS DETAILS OF VENTILATION DUCTWORK SERVING BLOCK A & B SECTIONS SCALE 1:20 @ A4 DATE 14-12-16 DRAWING No. 2312-004 REV B		
B	JTWINE	18-01-16	FRESH AIR INTAKE AMENDED TO HAU 3		CS	CUT TO SLAT		FOR INFORMATION			
			DISPLACEMENT UNITS DRAWN ACTUAL SIZE		CS	CUT TO SLAT		FOR APPROVAL			
					CS	CUT TO SLAT		FOR RE-APPROVAL			