




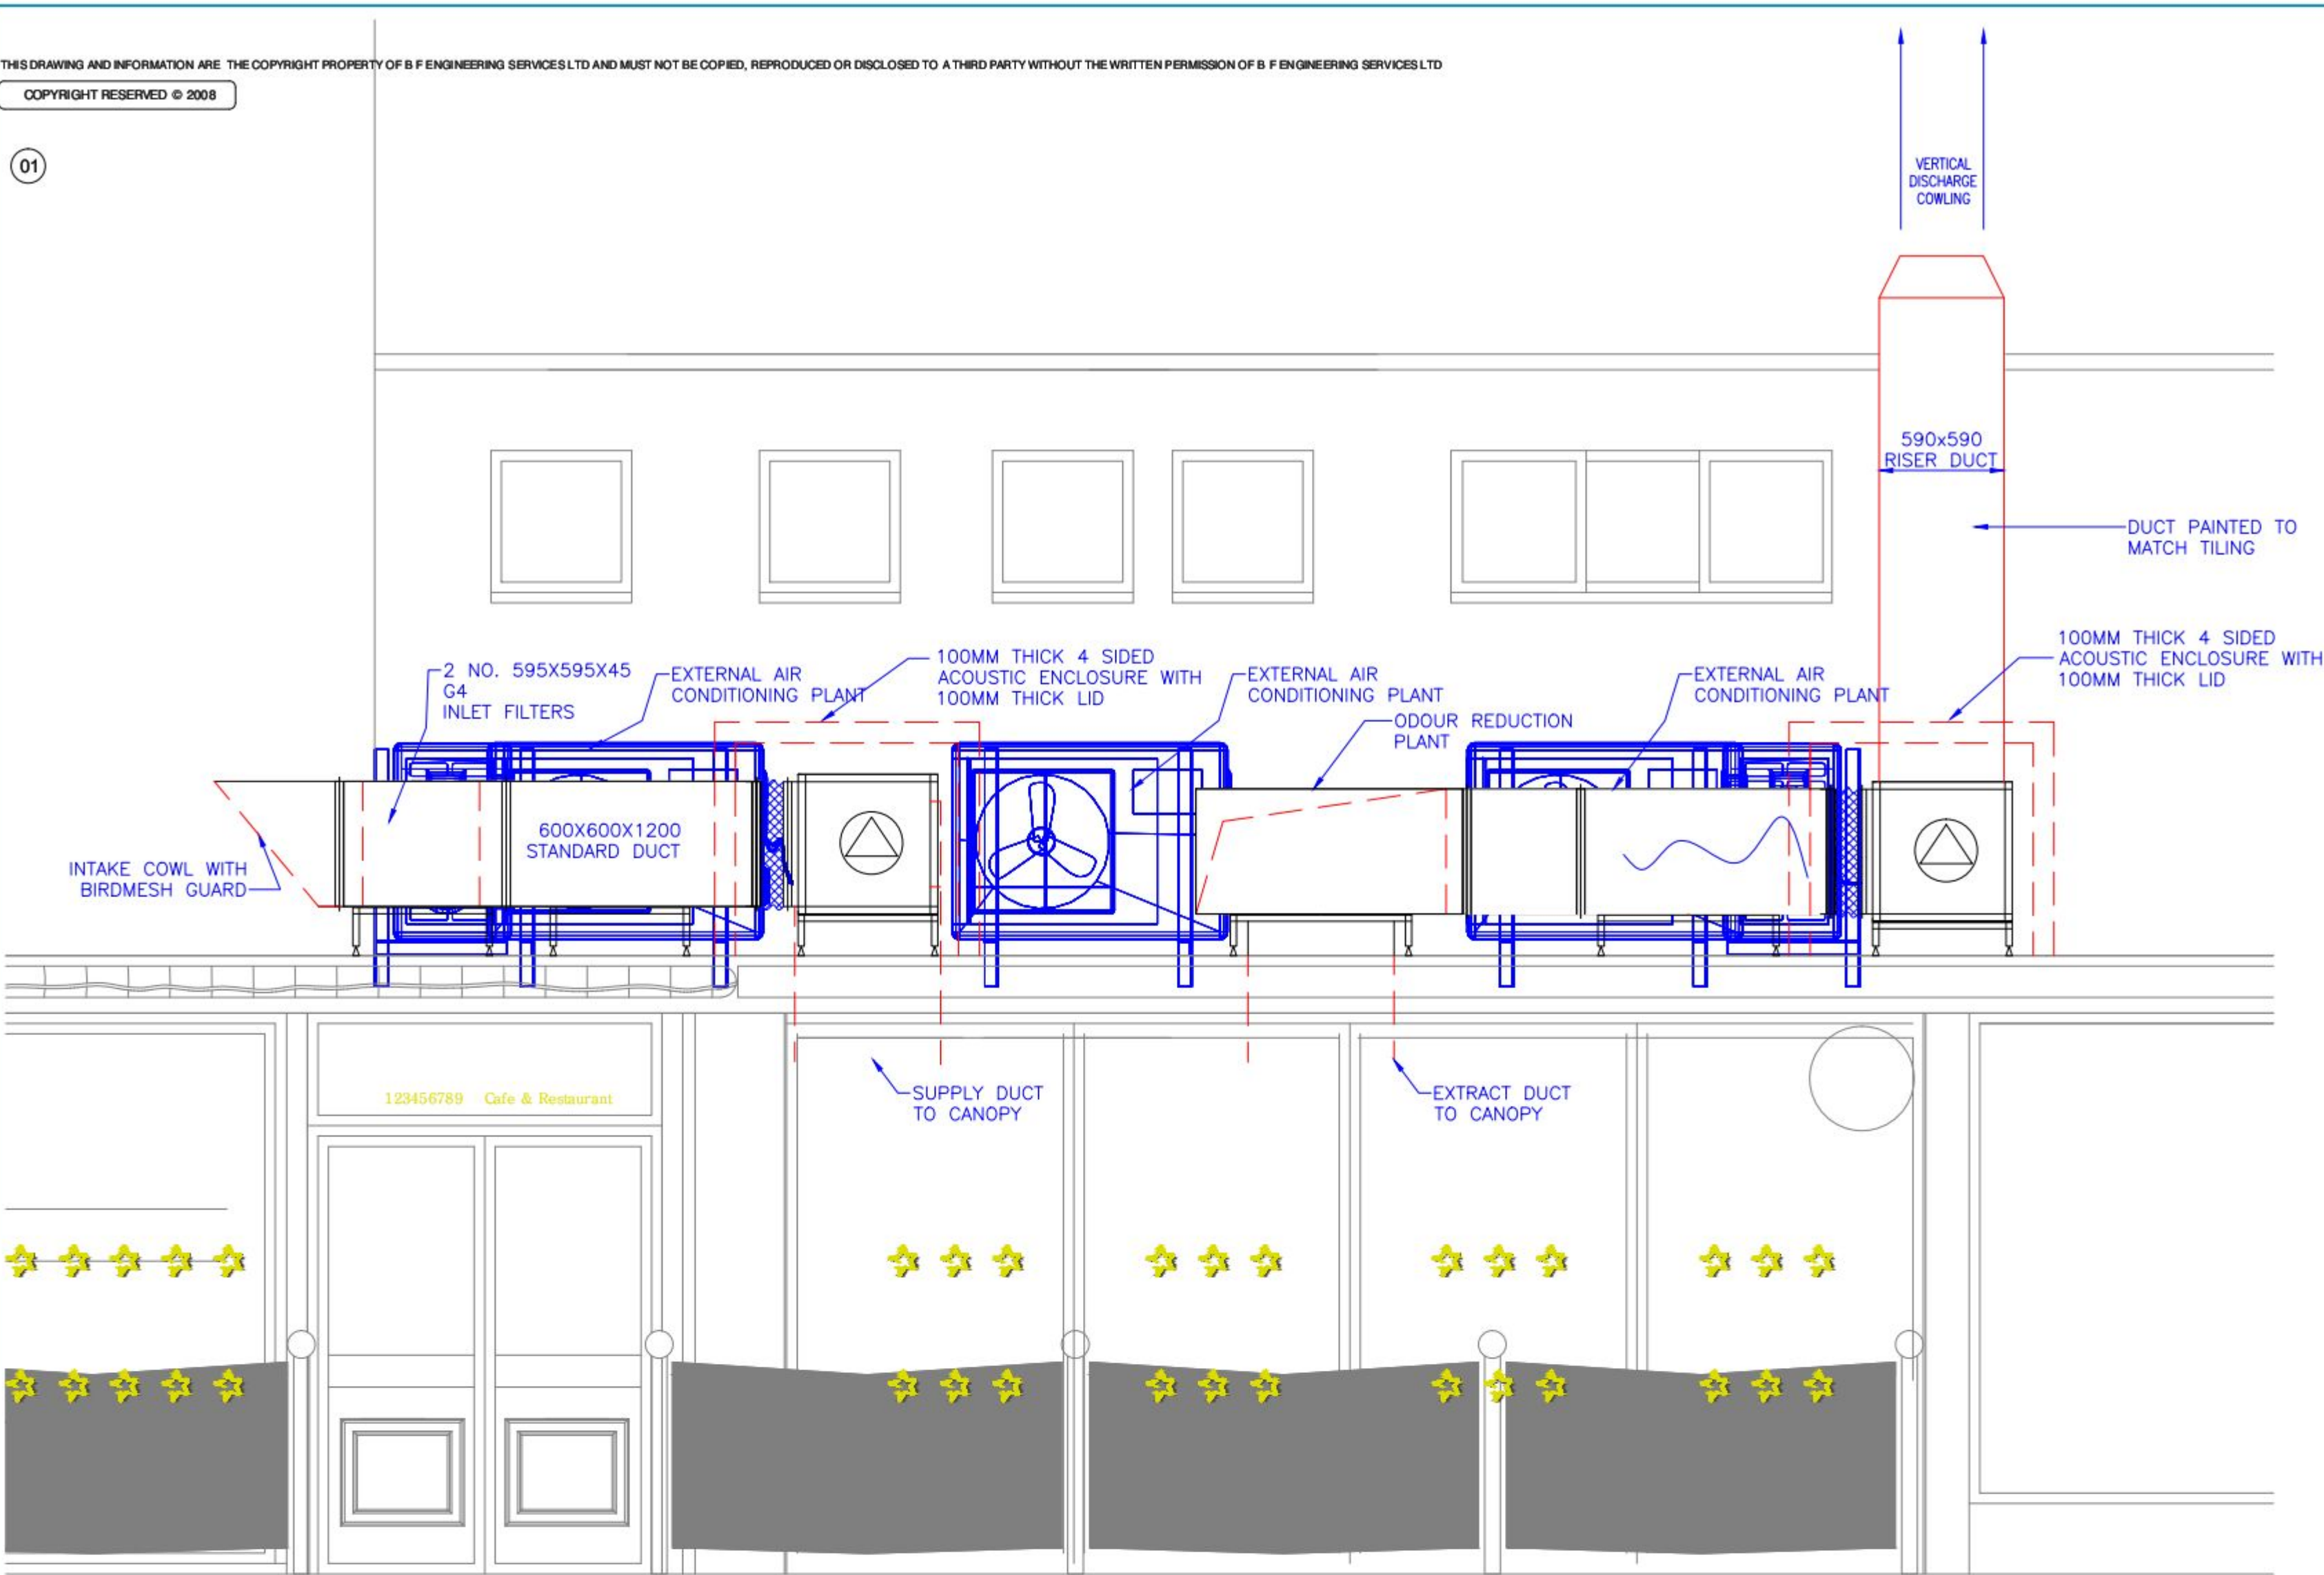


PROPOSED WEST SECTION

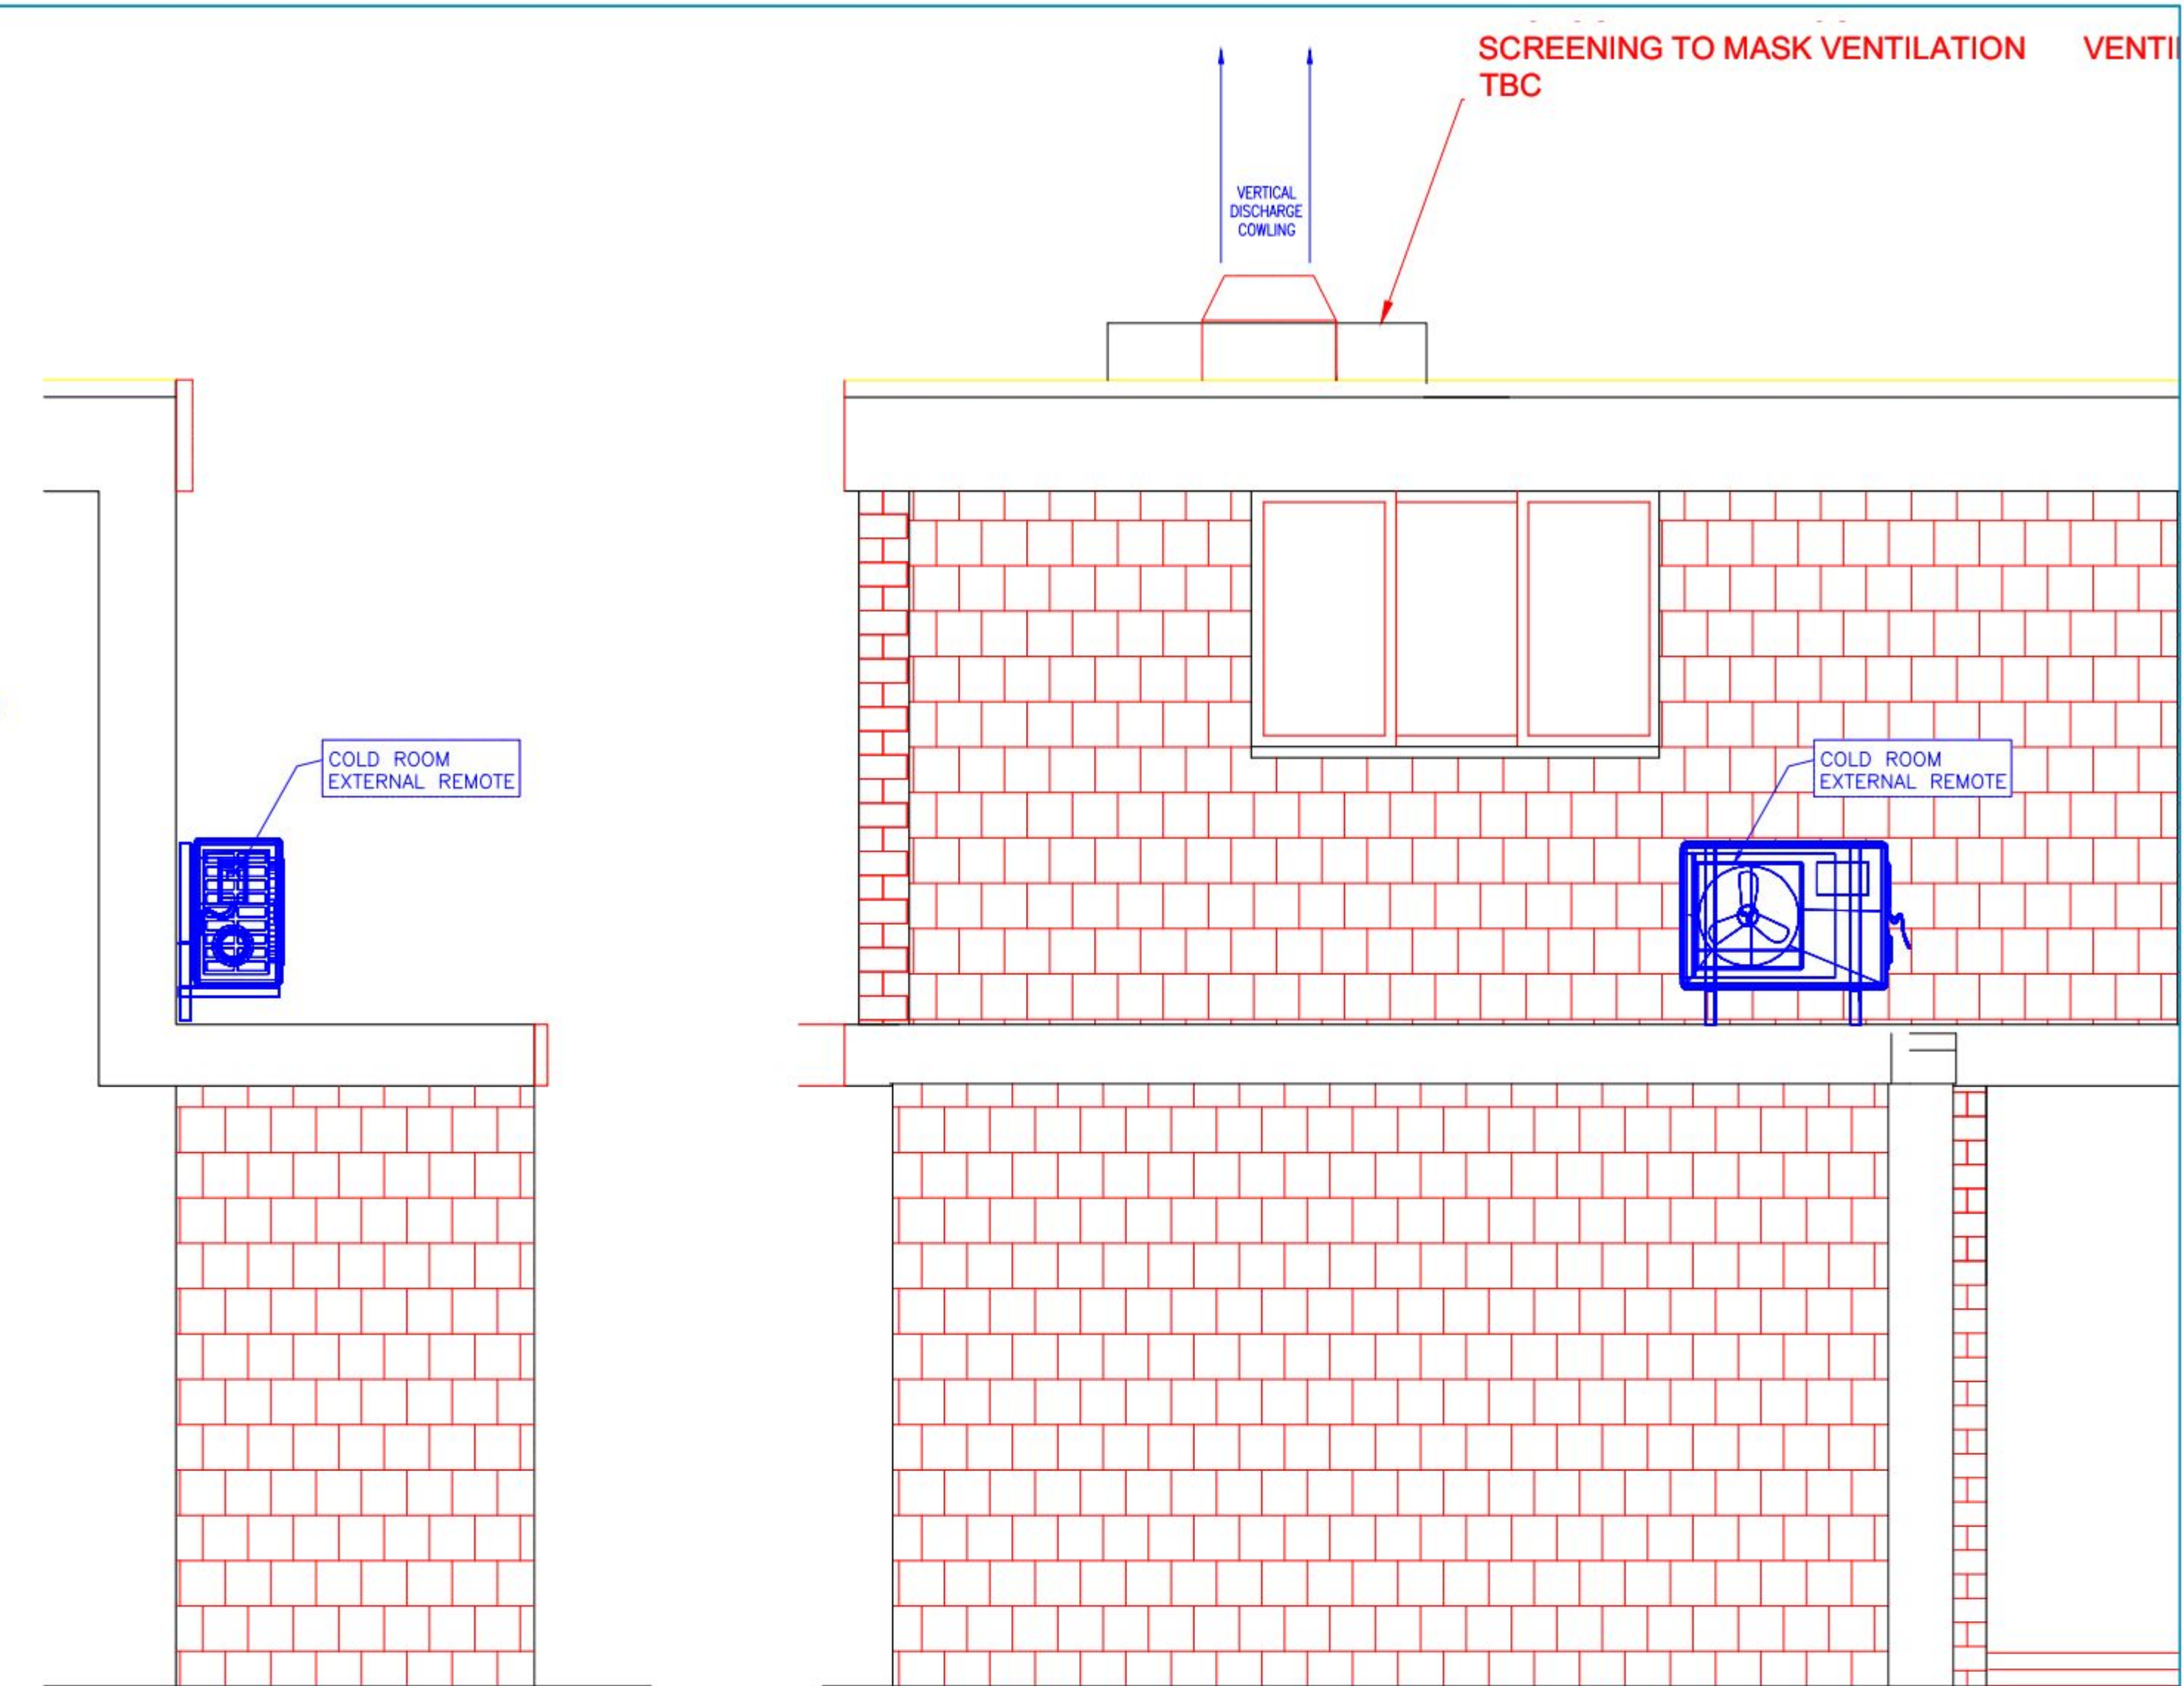

PROPOSED NORTH ELEVATION

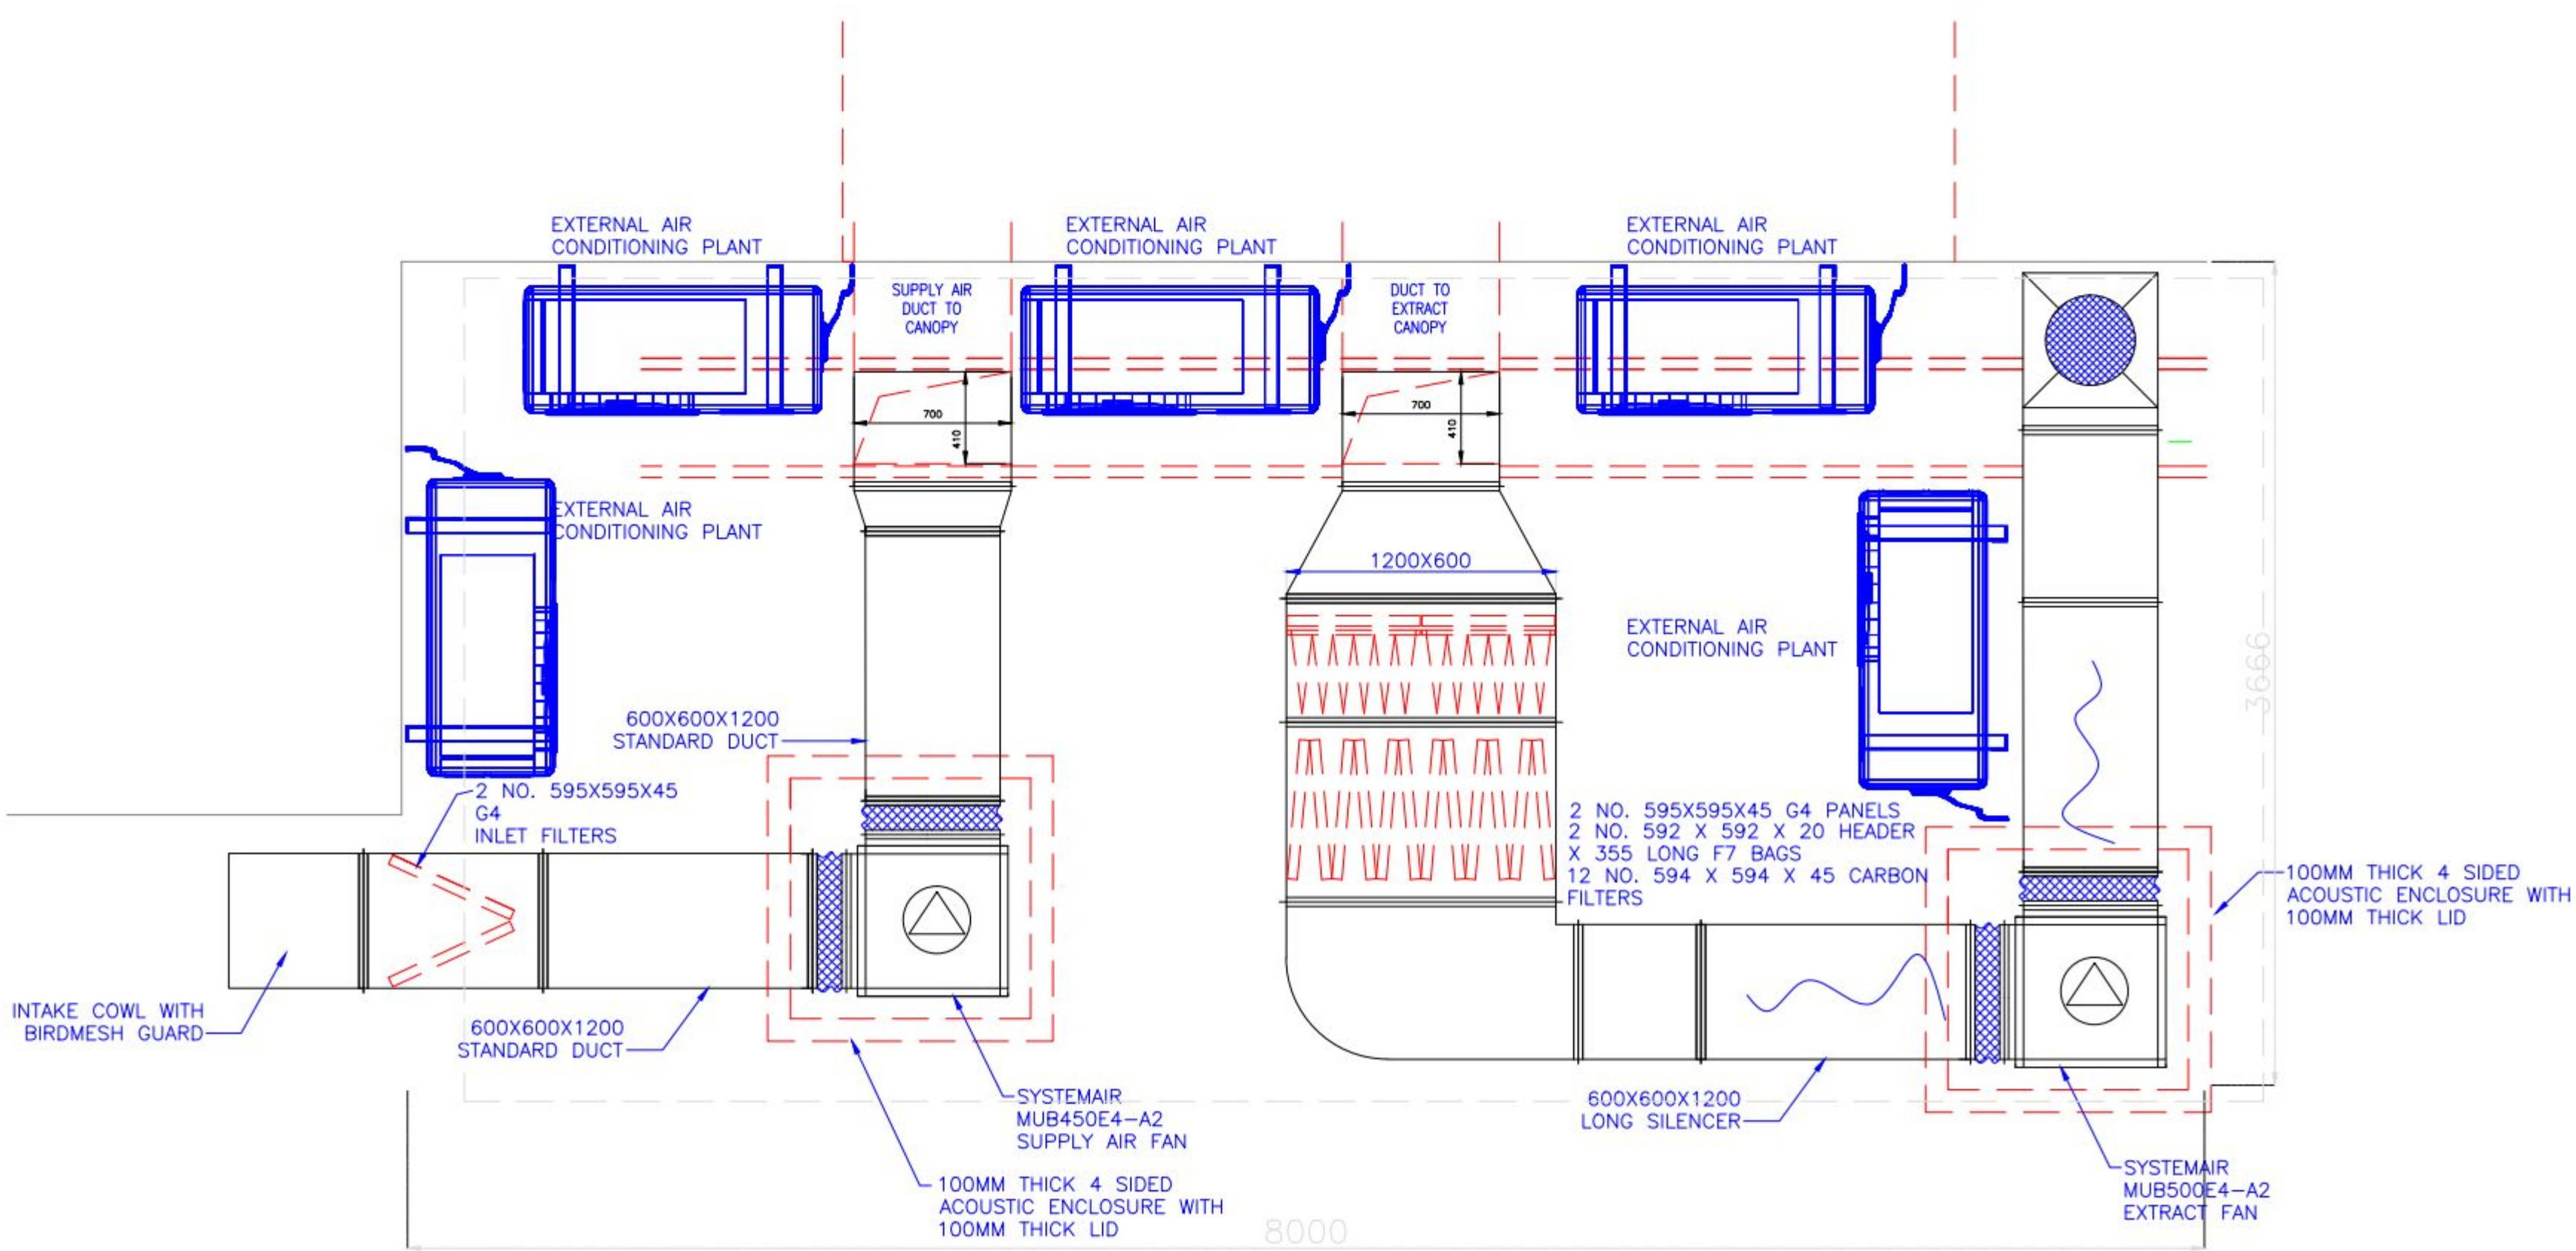

PLAN VIEW
ROOFSIDE VENTILATION, ODOUR REDUCTION AND ATTENUATION PLANT

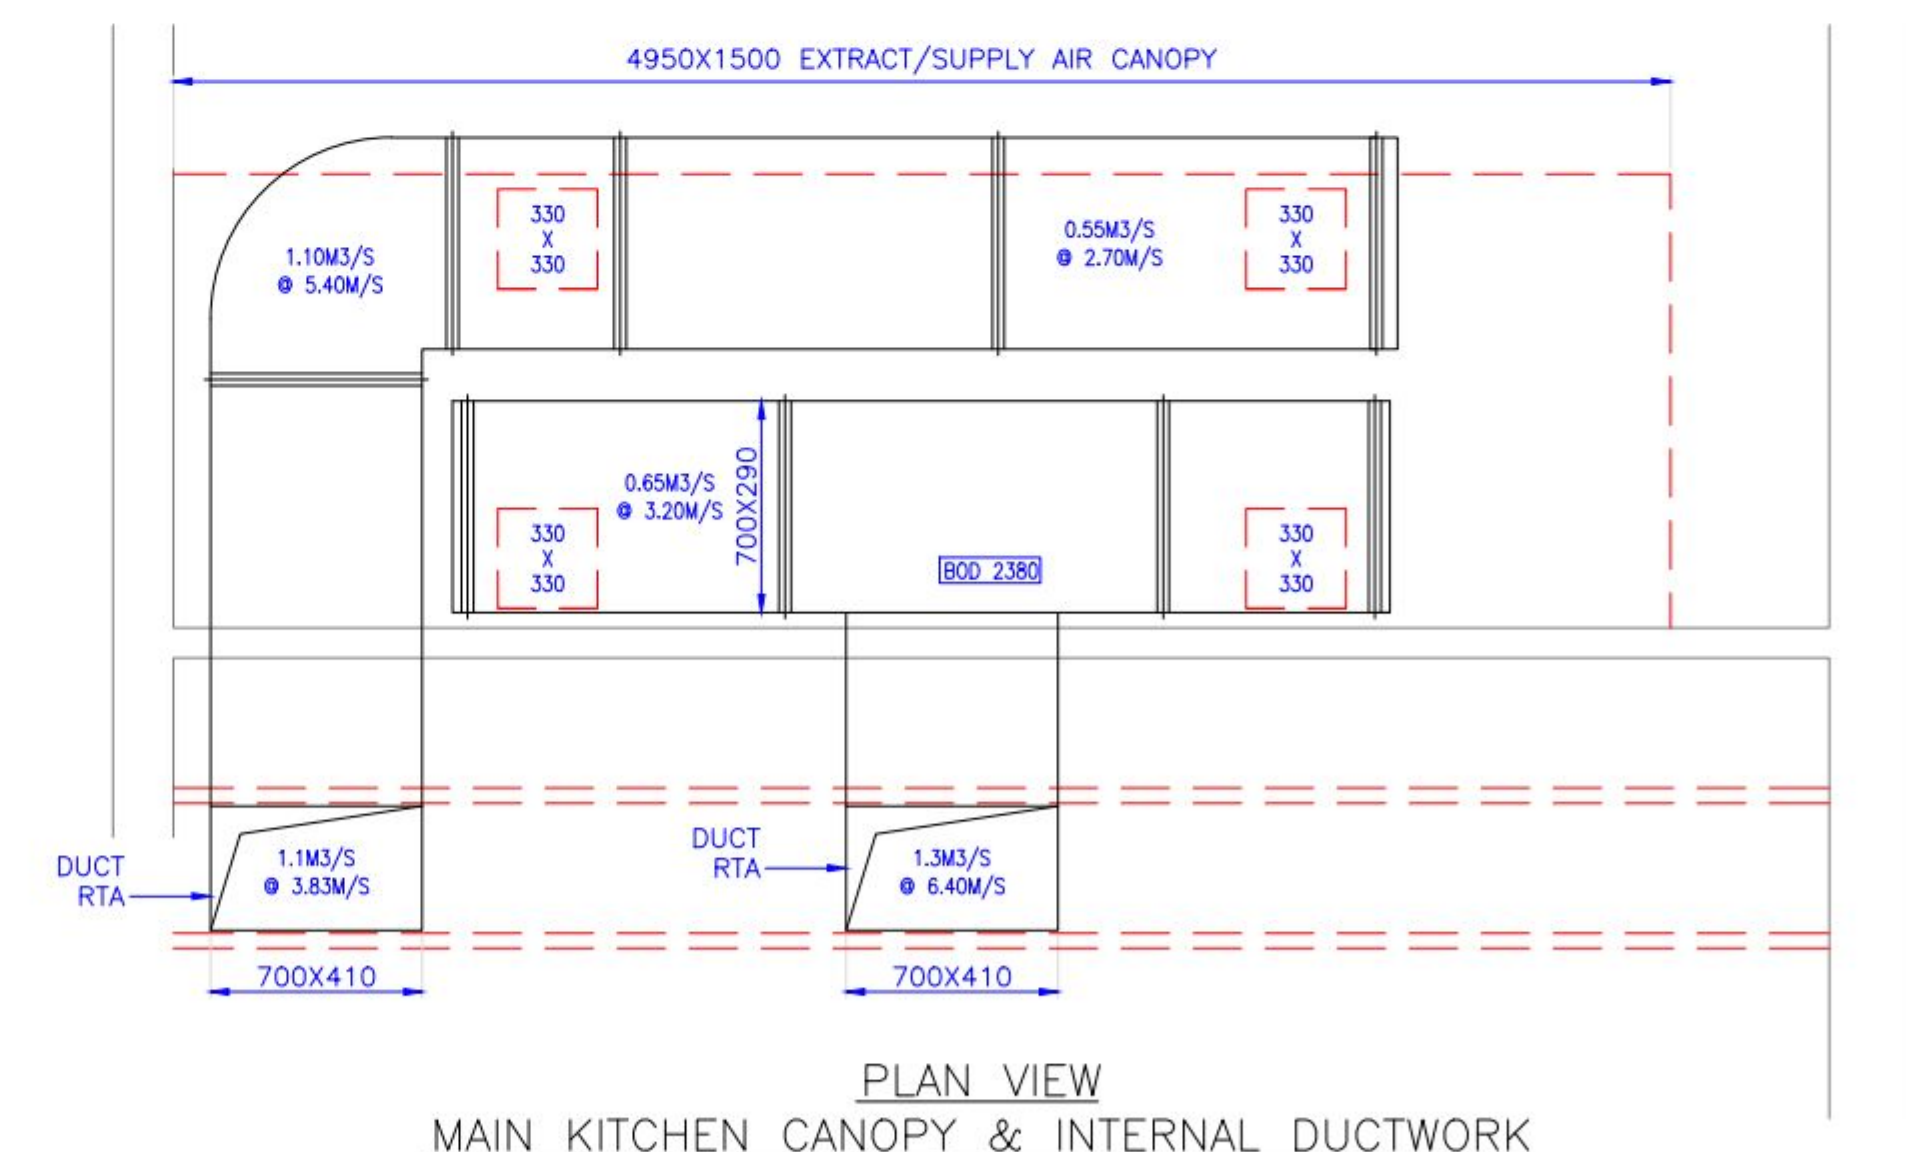

Client	GRASTAR	A		
Project	HAVANT	A	COLD ROOM PLANT ADDED	22/09/15 CKK
Title	EXTRACT /AIR CON SYSTEM			
Drawn	CKK	Checked	Contract No.	2015-19
Date	21/09/2015	Scale	Drawing No.	2015-19-02

BF Engineering Services Ltd
T 023 9249 8080 W www.bfes.co.uk E office@bfes.co.uk
Catering Specialists