


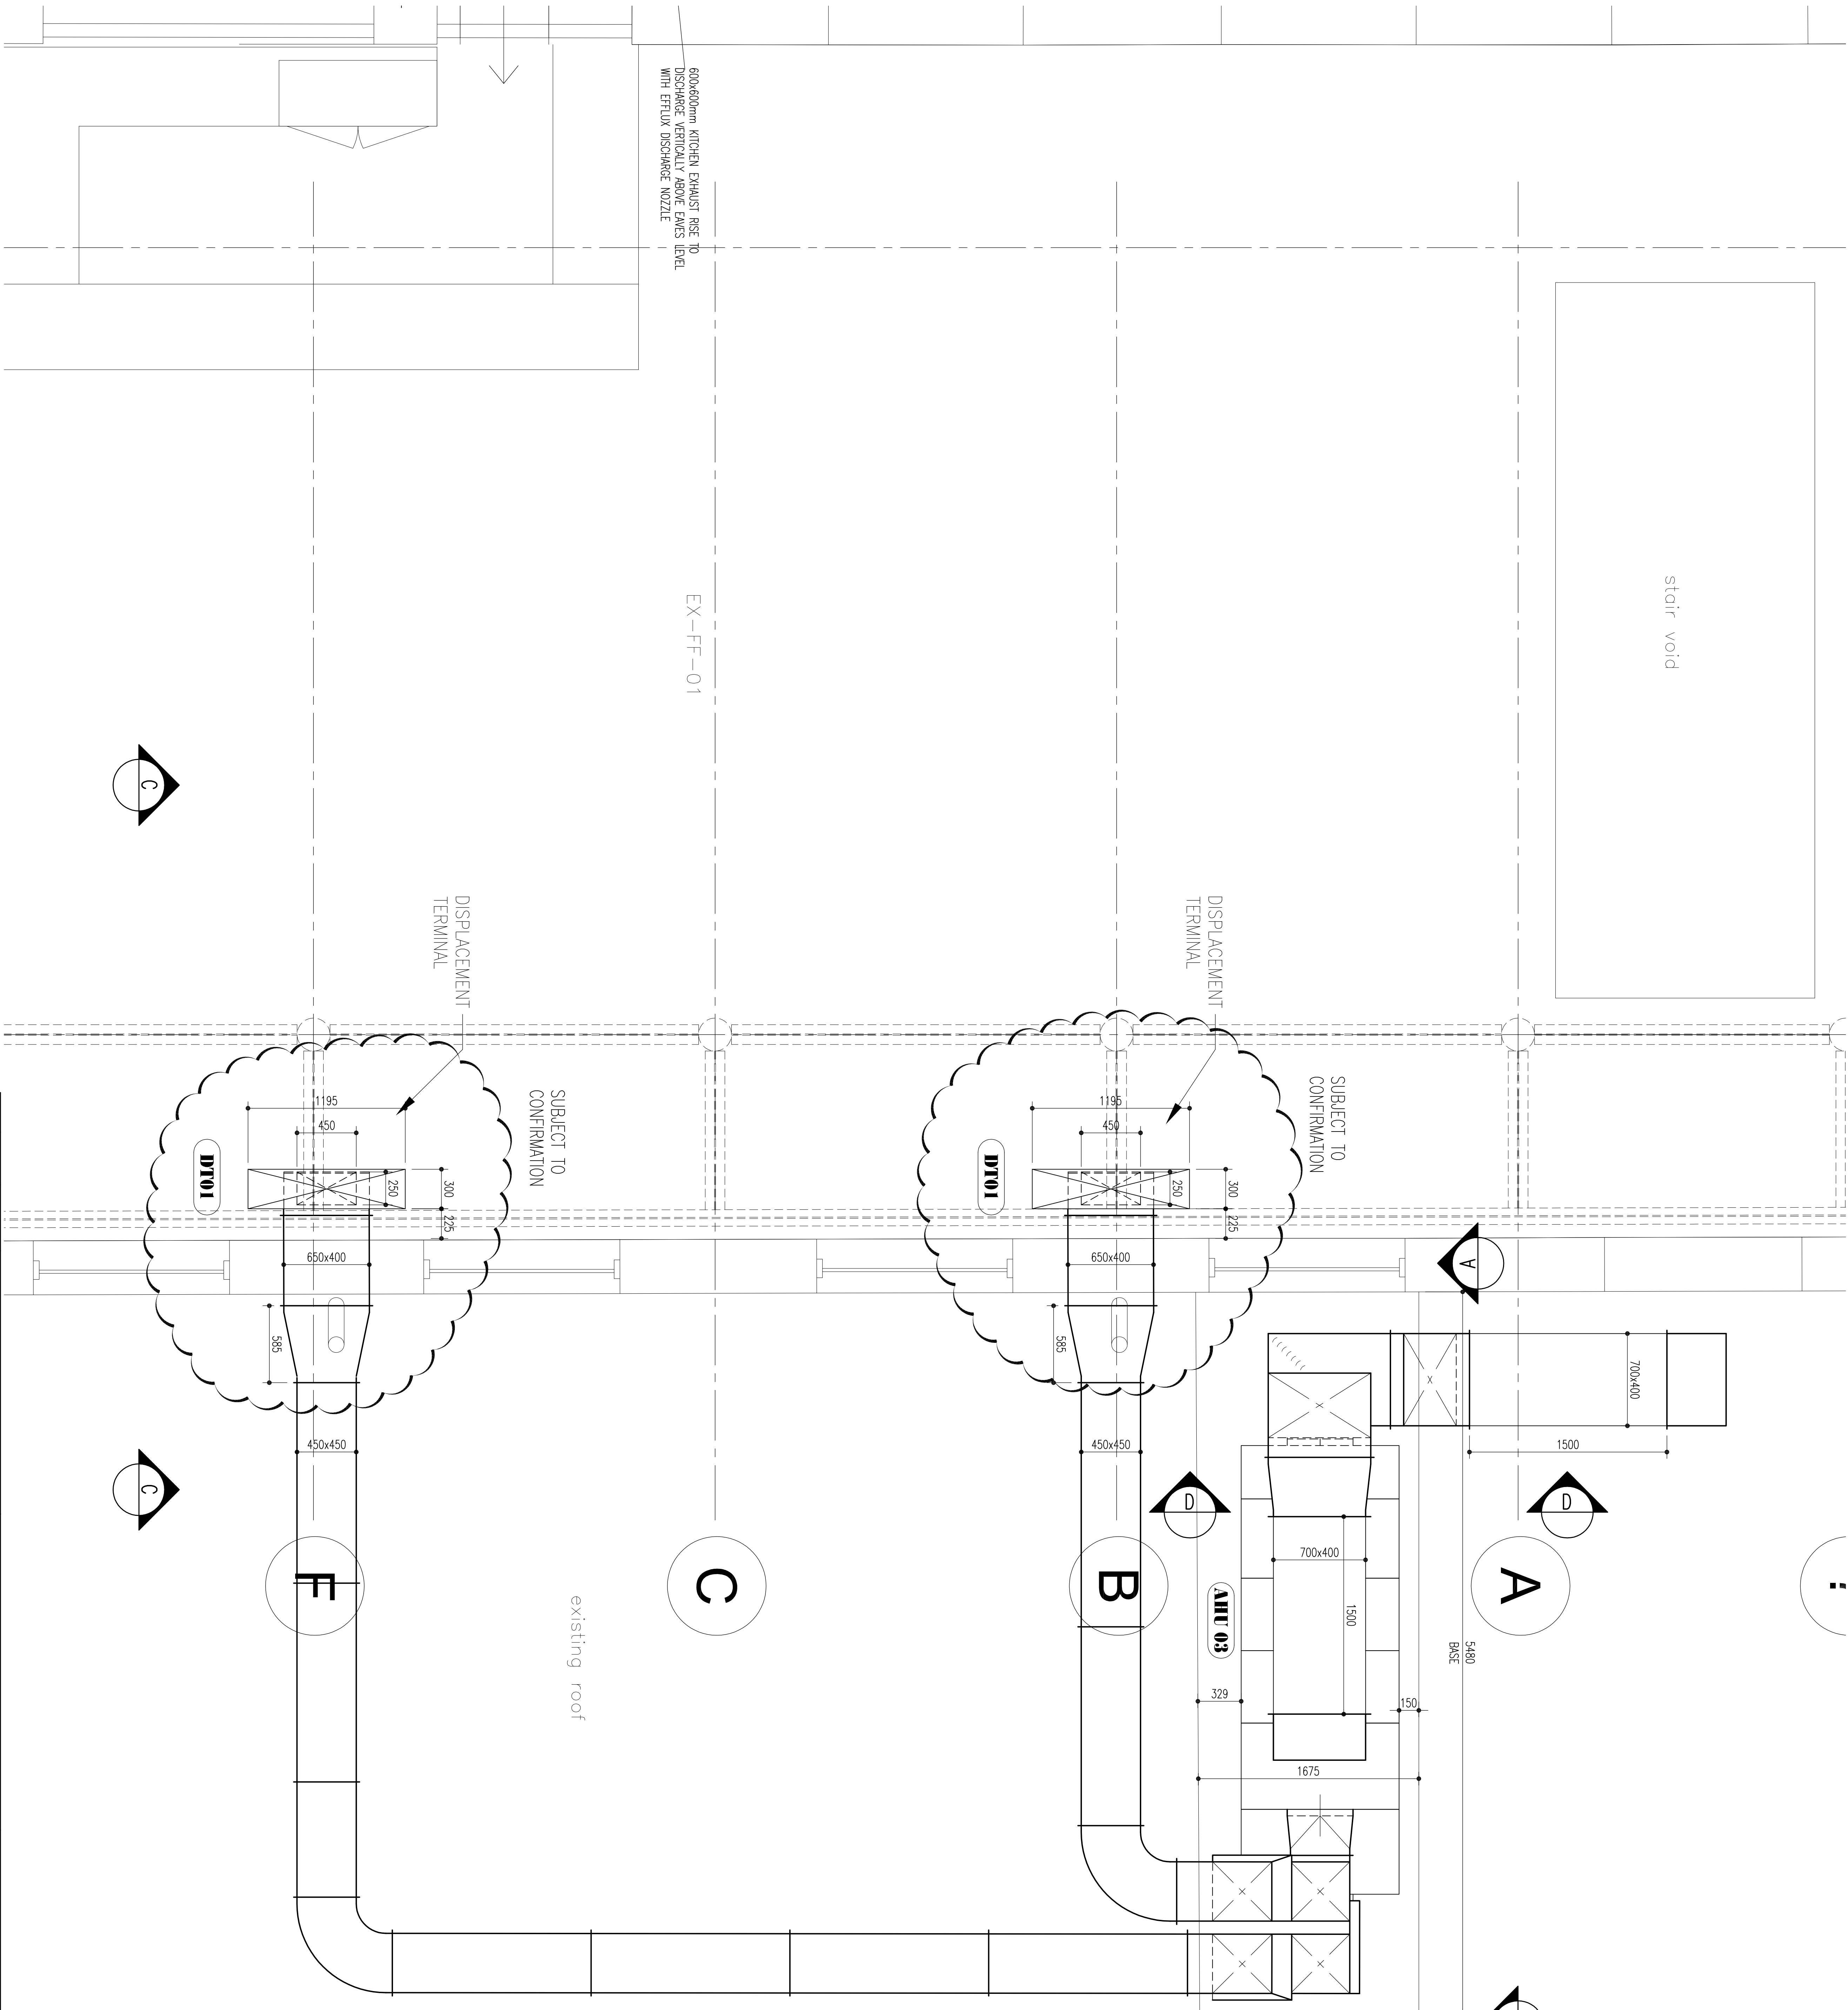

ALL DUCTWORK SUPPLIED AND
INSTALLED TO DW144 LOW VELOCITY

REV.	DRAWN	DATE	REVISIONS	NOTES	DRAWING PREPARED USING THE FOLLOWING	ABBREVIATIONS	SITE PLAN	DRAWING STATUS					
A	JTWINE	13-01-16	ATTENUATORS ADDED TO DINING HALL PLANT			#/46 ACCESS PANEL / DOOR		☐	PRELIMINARY	 Druck's Way Hilham Tel: 01235 44234 Fax: 01235 44486 PURBROOK SCHOOL, PARK AVENUE, PURBROOK PO7 5DS DETAILS OF VENTILATION DUCTWORK SERVING BLOCK B DINING HALL DISPLACEMENT DIFFUSERS SCALE 1:20 @ A0 DRAWING No			
B	JTWINE	18-01-16	FRESH AIR INTAKE AMENDED TO AHU 3			CS CAP END SUIT EGGAL TOP & BOTTOM IN VIEW FRESH AIR INTAKE FRESH							