


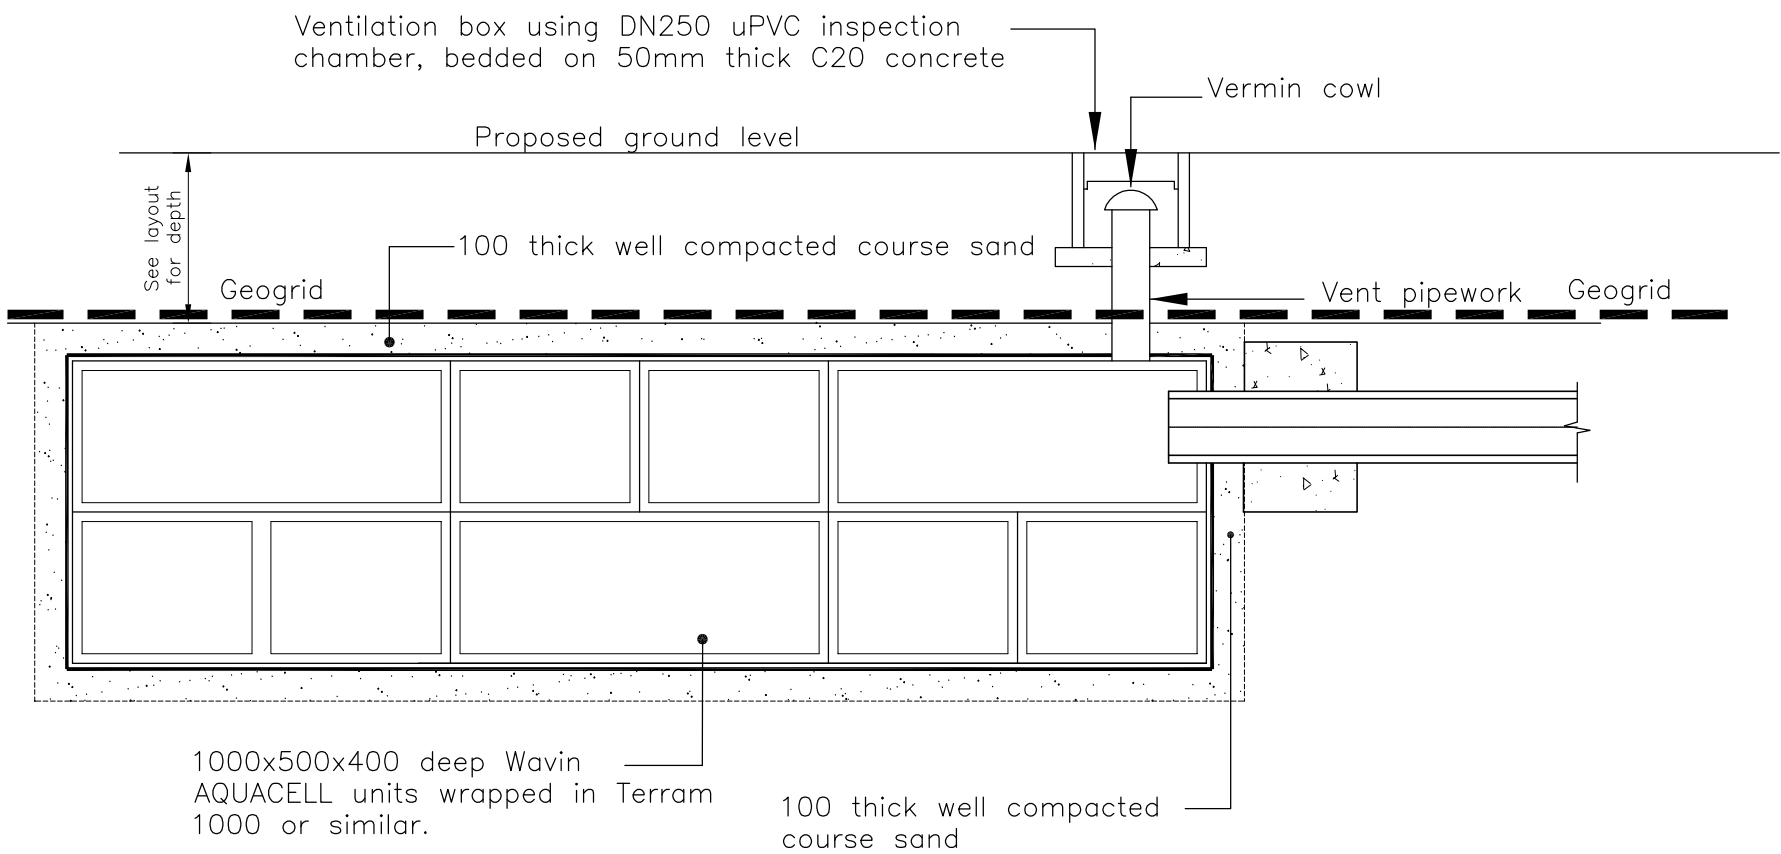


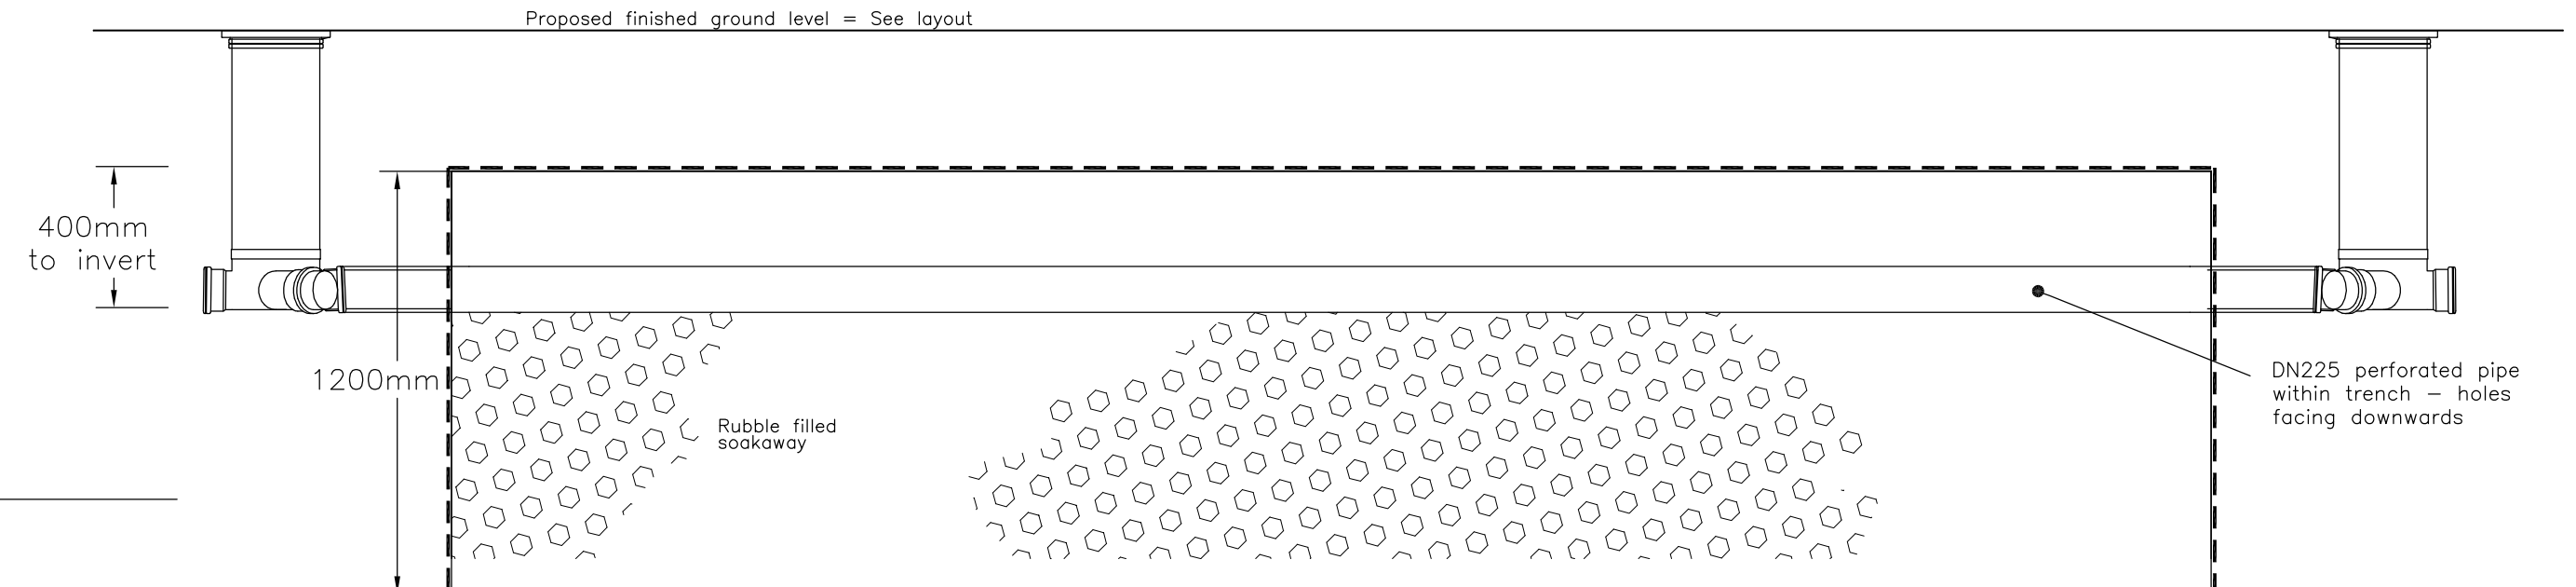

TYPICAL SECTION THROUGH AQUACELL CRATE SOAKAWAY
SEE DRAINAGE LAYOUT FOR SIZE AND DEPTH

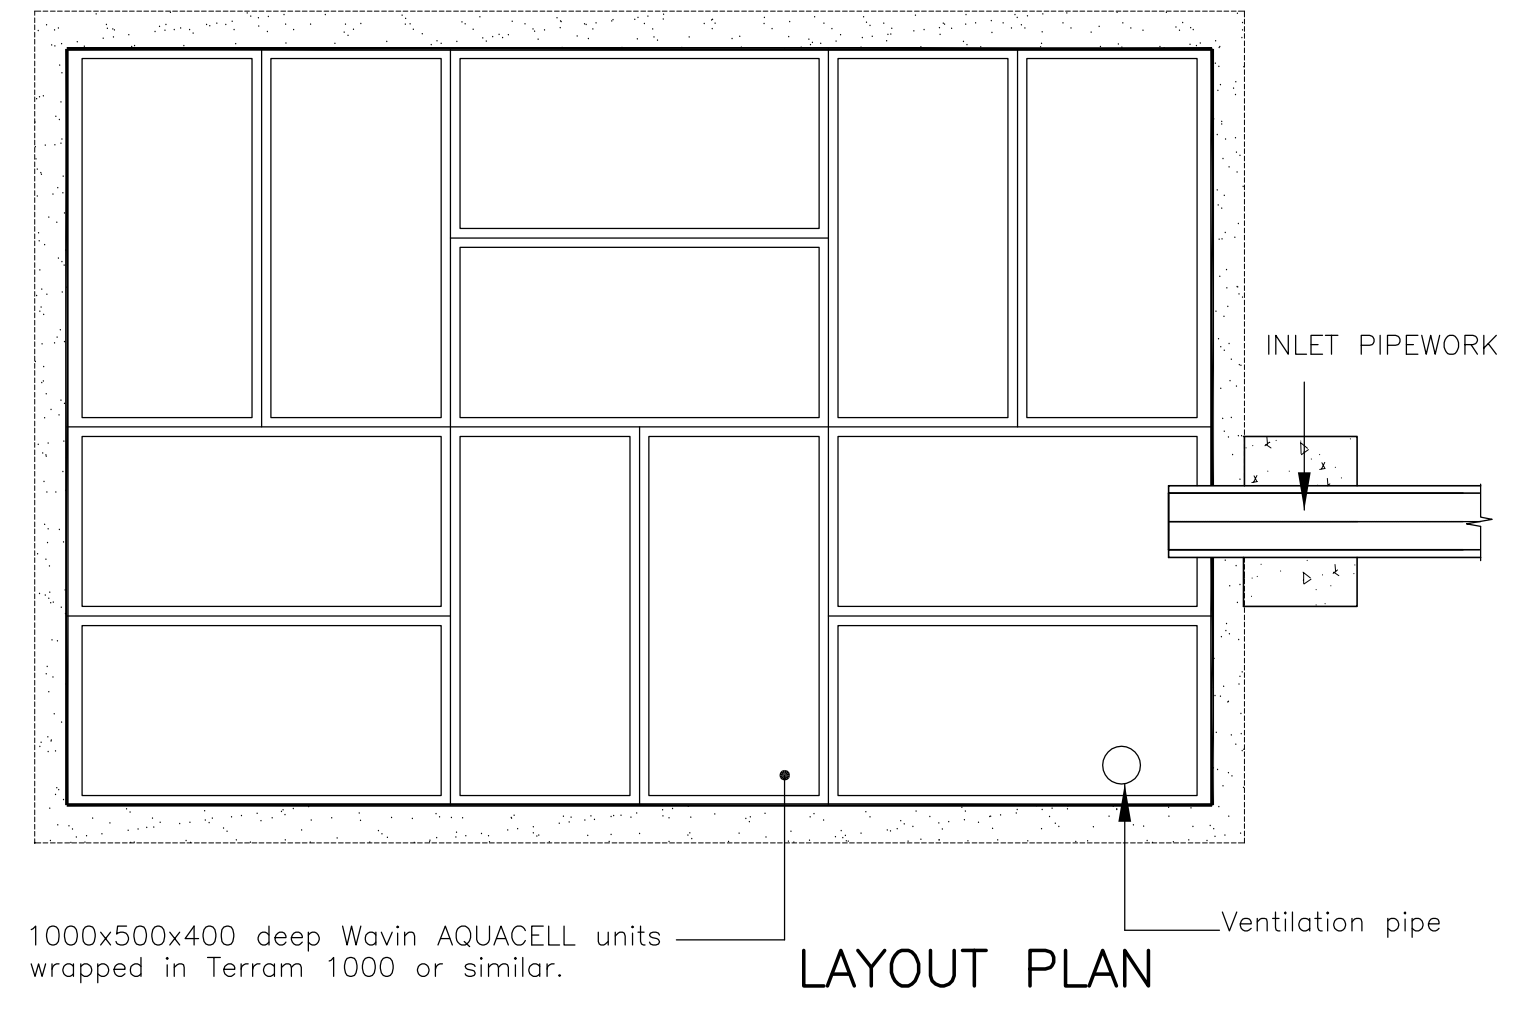


TYPICAL SECTION THROUGH TRENCH SOAKAWAY
Scale 1:20

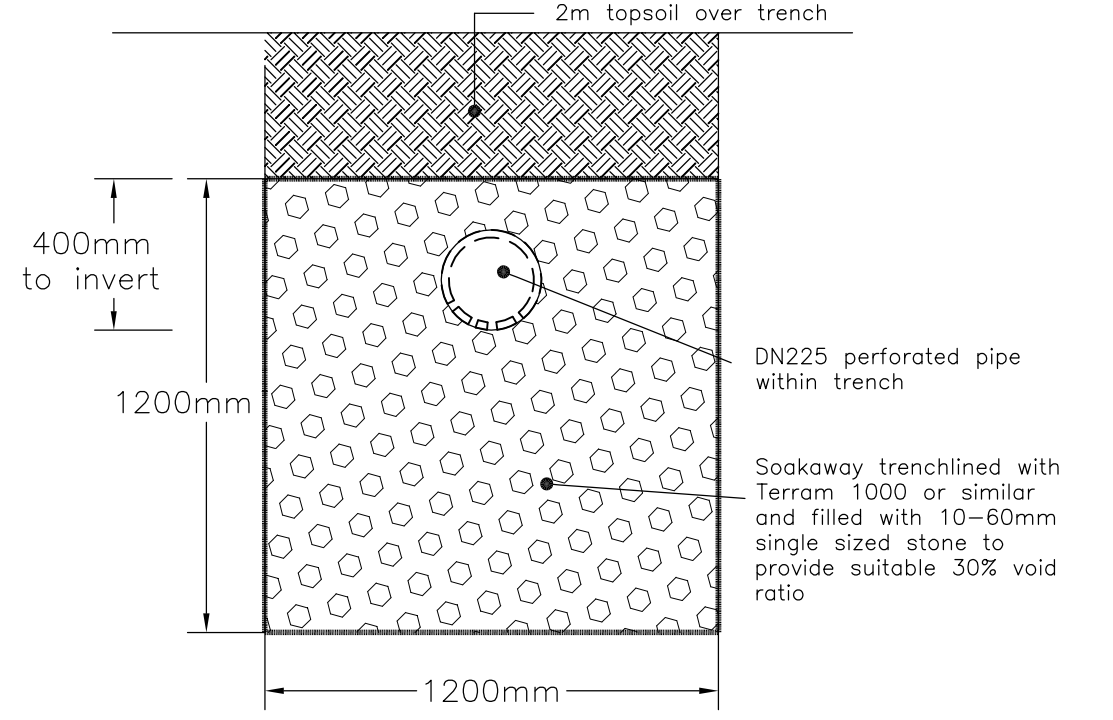



TYPICAL CROSS SECTION THROUGH TRENCH SOAKAWAY
Scale 1:20

TYPICAL SECTION THROUGH STORMBRIXX CRATE SOAKAWAY
SEE DRAINAGE LAYOUT FOR SIZE AND DEPTH


This drawing is to be read in conjunction with the manufacturer's installation recommendations

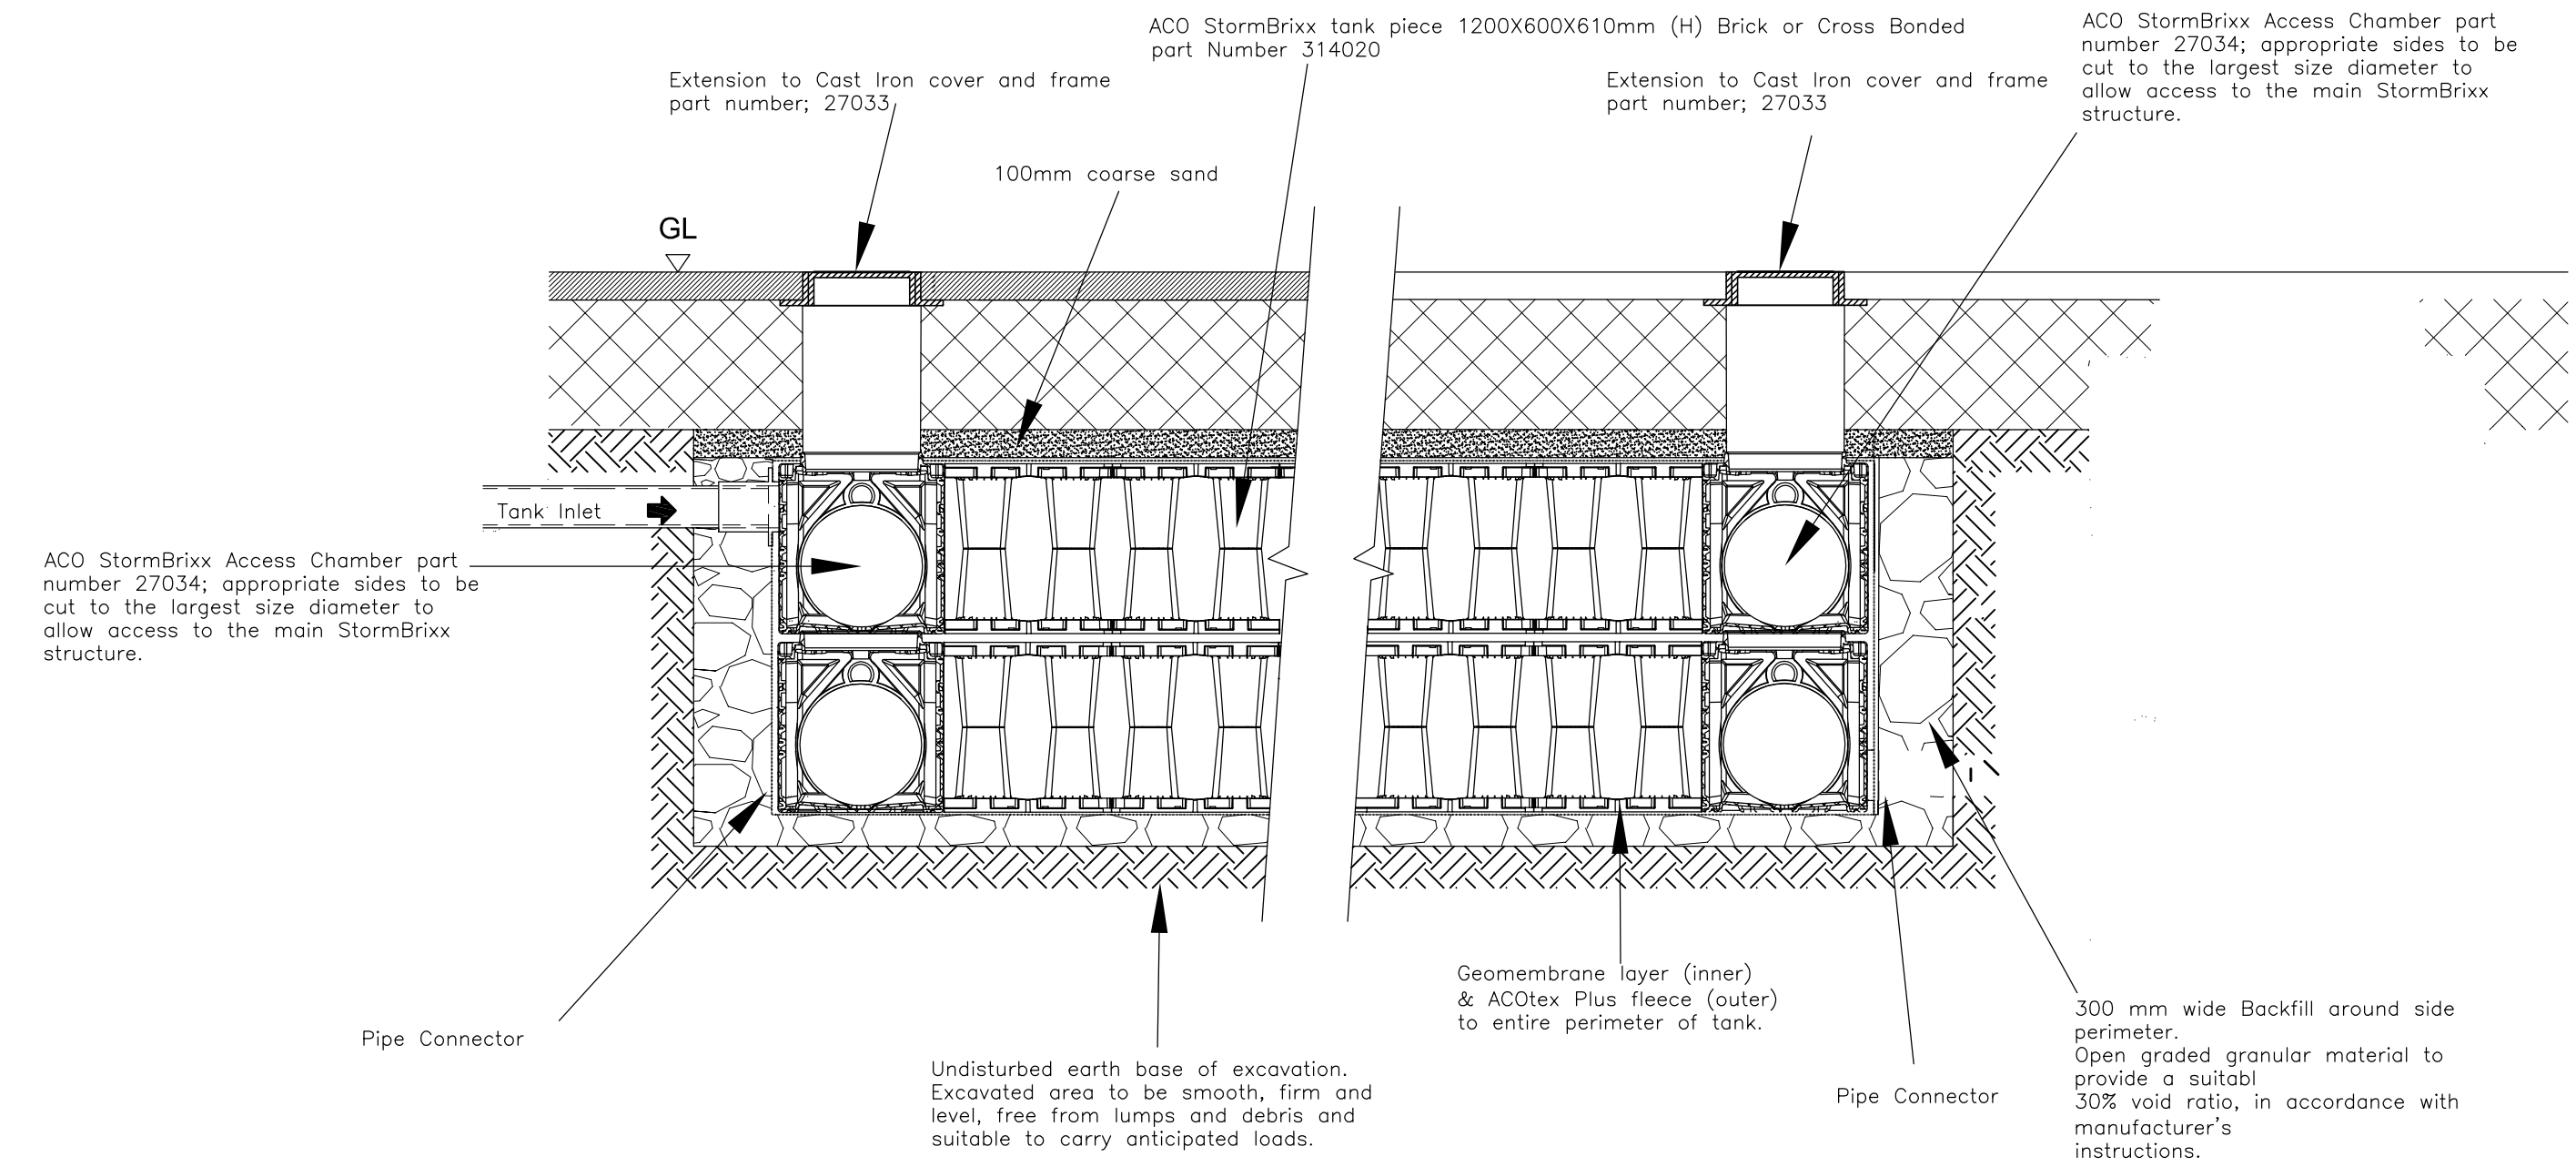

NOTE:
Top covers part Number 314022 shown below to be installed on top layer of StormBrixx Modules only.

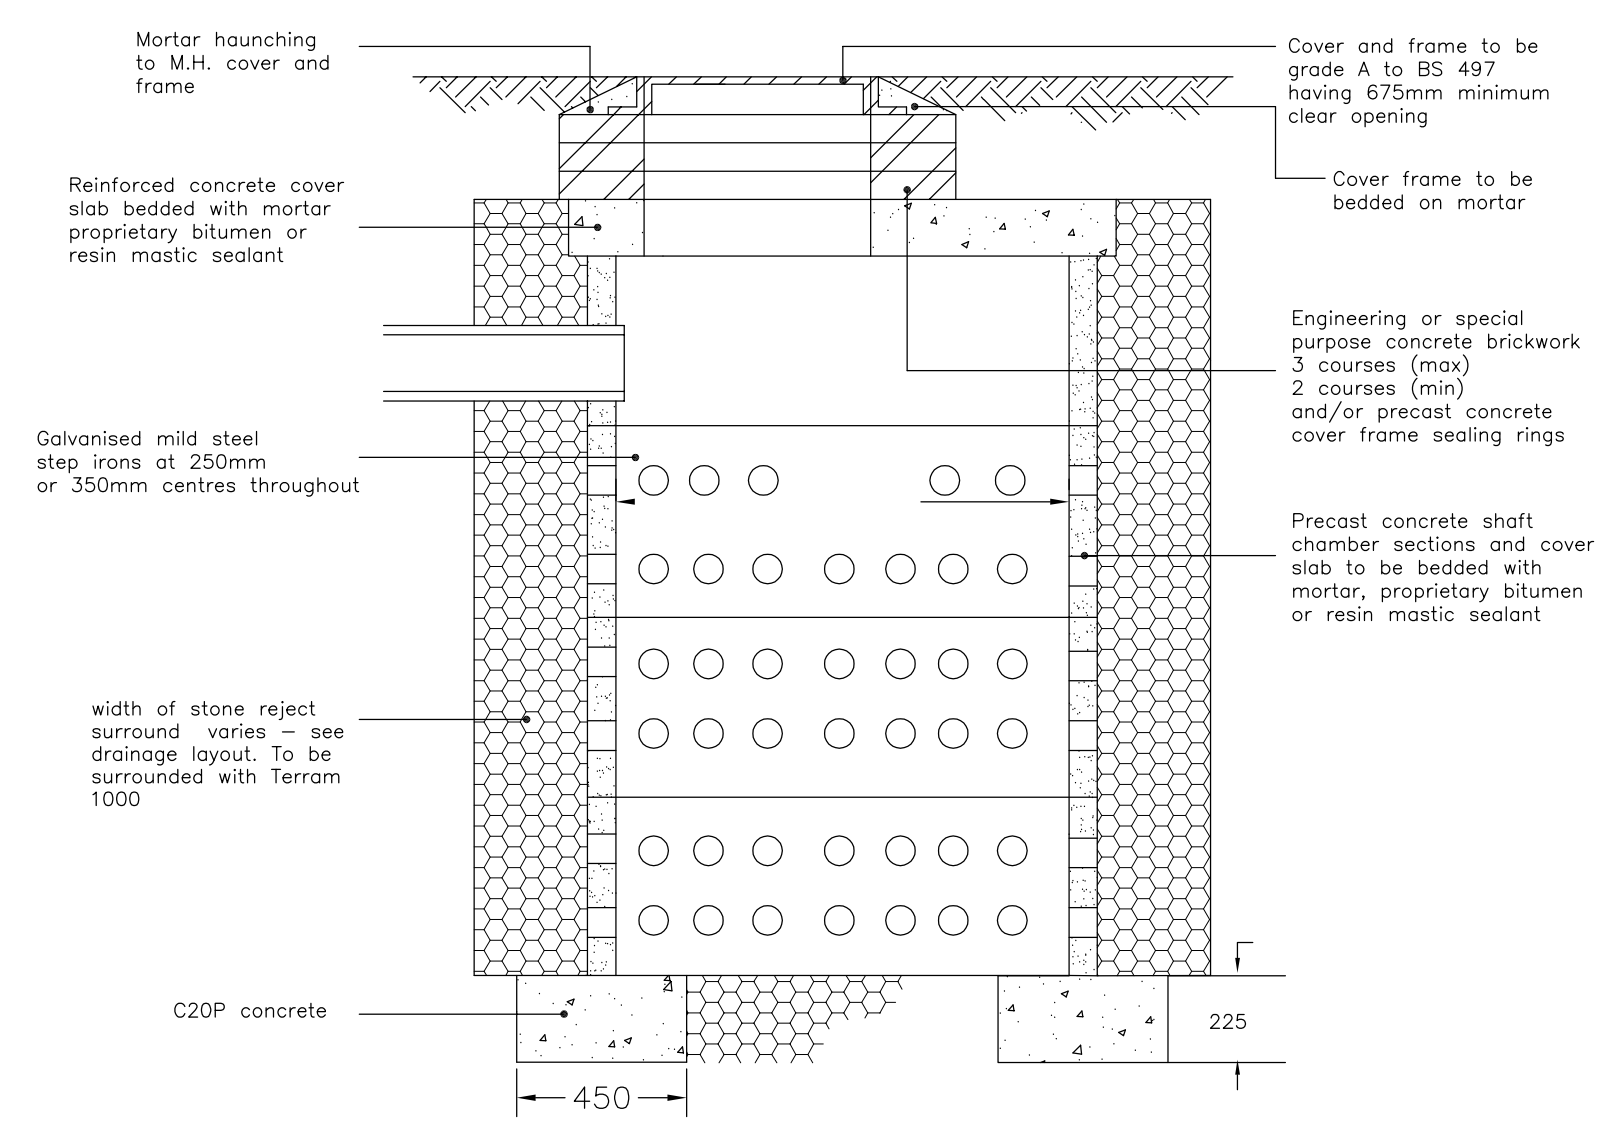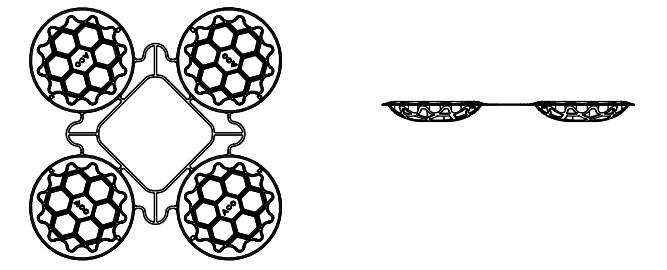

TYPICAL SECTION THROUGH RING SOAKAWAY
NTS
SEE DRAINAGE LAYOUT FOR SIZES AND DEPTHS

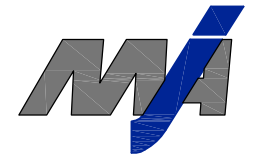REV. No.	DATE	DESCRIPTION	INITIALS
Client		MJA CONSULTING CIVIL AND STRUCTURAL ENGINEERS Monarch House, Barton Lane, Abingdon, Oxon, OX14 3NB Tel: 01235 555173 Fax: 01235 523226	
Project	Havant Retail Park Bedhampton	Scale As shown@A1	Date April 14
Title	Private Drainage Construction Details	Checked KTG	Drawn JOK
Rev	4982:22	Drawing No.	Rev