




PROPOSED SECTION C-C

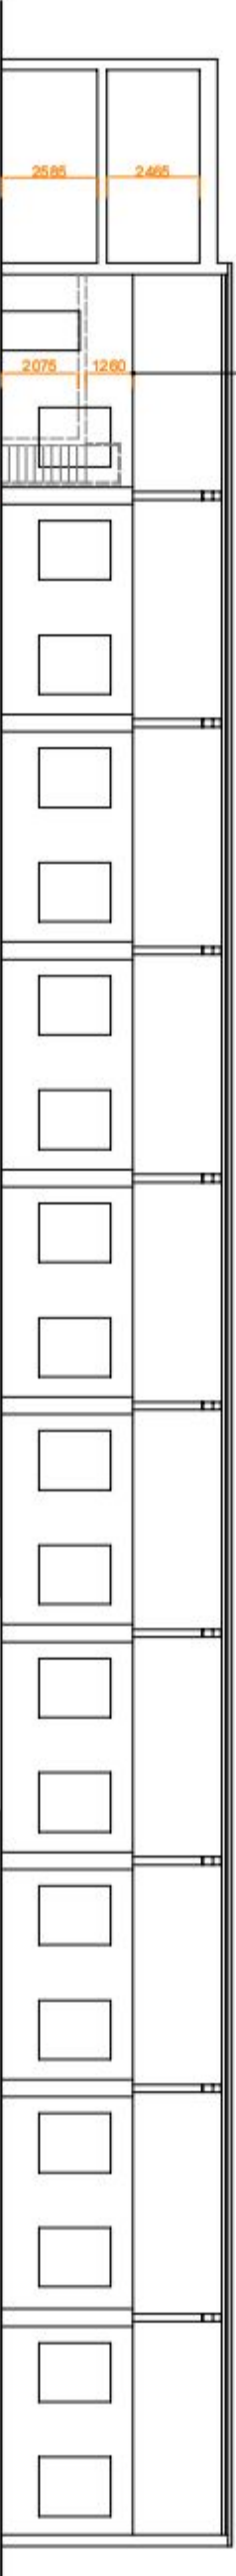


EXISTING SECTION C-C

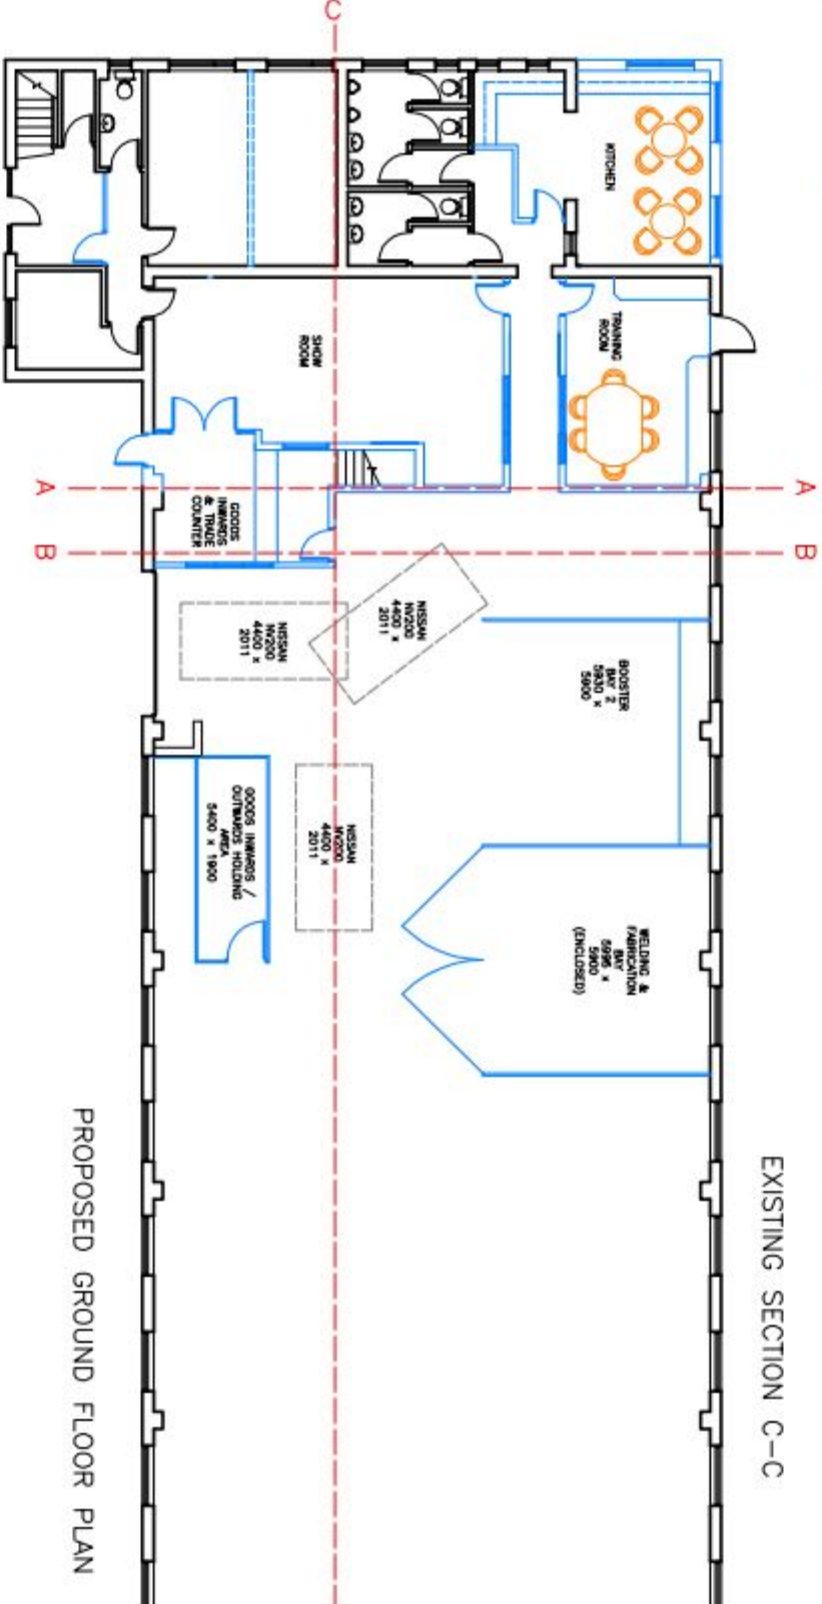


PROPOSED GROUND FLOOR PLAN

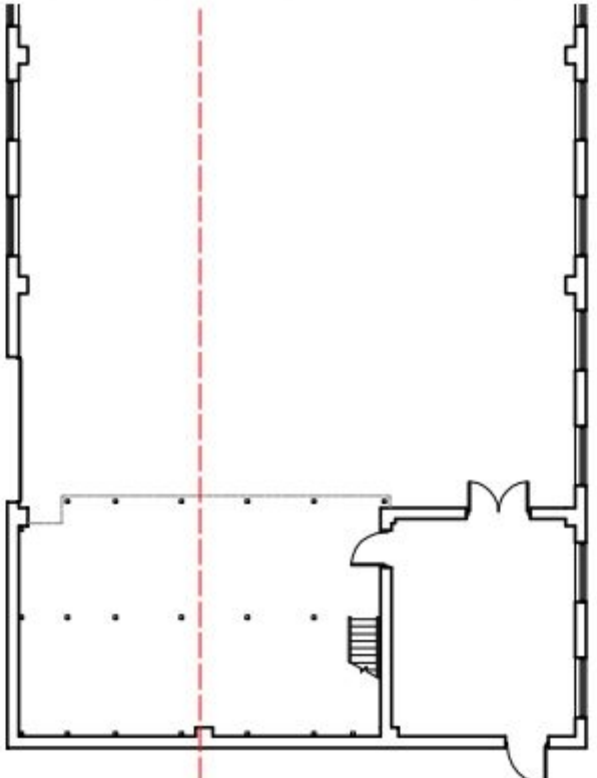


LOCATION PLAN
1:1250@A3

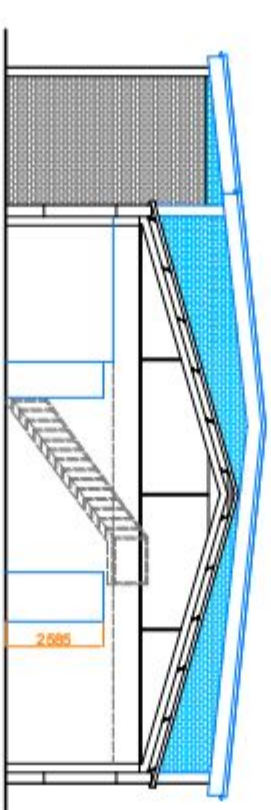


PROPOSED SECTION B-B

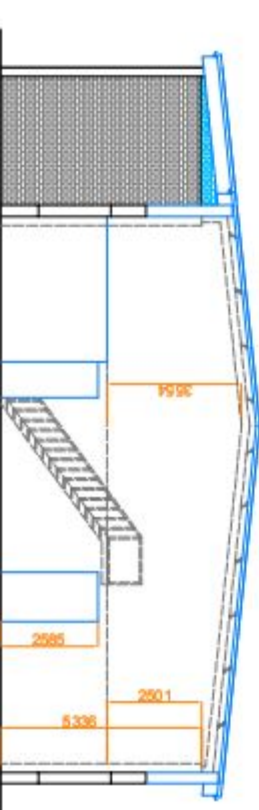

PROPOSED SECTION A-A

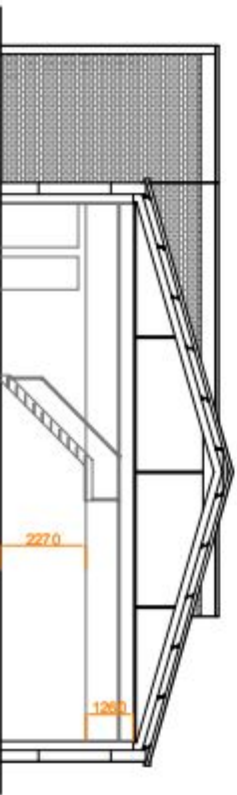

EXISTING SECTION B-B

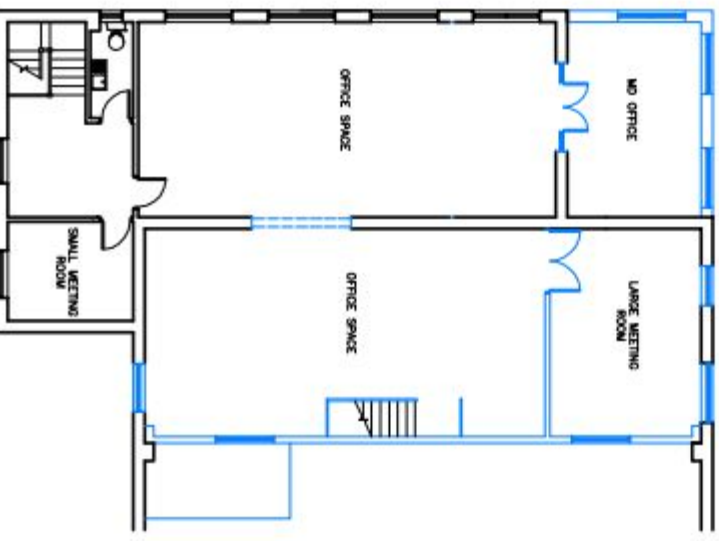

PROPOSED FIRST FLOOR

K NIGHT ARCHITECTURAL
K.A.D. DESIGN

The Oakhouse, Arnside Wood
7 Colliest Way
Sunderland
SR2 1XT
Tel: 0191 346 679
E: k.ad@knight.co.uk

K.A.D. LTD
The Oakhouse, Arnside Wood
7 Colliest Way
Sunderland
SR2 1XT
Tel: 0191 346 679
E: k.ad@knight.co.uk

Project: ACTION PUMPS

Location: 14 ARNSIDE ROAD WATERLOOVILLE

Scale: 1:200@A3

Date: MAR 2015

Rev	Description	By	Date
07	A	P&S	B

SUPERSEDED