


Do Not Scale
Copyright © 2014 Henderson Green Ltd.
This is a working drawing. Dimensions shall be checked on site.
This drawing shall be read in conjunction with all relevant specifications and/or specialist drawings/documents.
Any discrepancies or variations shall be notified to the engineer prior to commencement of works.

- STANDARD NOTES**
1. FOR ELECTRICAL LEGEND, SEE PROJECT LEGEND DRAWING NO. E1(00)101.
 2. THIS DRAWING SHALL BE USED IN CONJUNCTION WITH THE LATEST ARCHITECTURAL DRAWINGS & ALL ASSOCIATED ROOM DETAIL DRAWINGS.
 3. THE ELECTRICAL CONTRACTOR SHALL CO-ORDINATE HIS SERVICES LAYOUT IN CONJUNCTION WITH ALL OTHER TRADES. NO WORK SHALL COMMENCE UNTIL HE HAS VERIFIED THAT HIS SERVICES WILL NOT FOUL THOSE OF OTHER SERVICES & TRADES.
 4. DUCTS TO BE INSTALLED AT A DEPTH OF 600mm BELOW FINISHED GROUND LEVEL.
 5. 230V SUPPLY REQUIRED AT EACH DOME CAMERA POSITION. CONTRACTOR TO ALLOW CAT5 CONNECTION FROM EACH CAMERA TO RECORDING EQUIPMENT LOCATED IN PLANT ROOM (EXG20).

- KEY**
- EXTENT OF TRENCH (INDICATIVE)
 - 100mm BLACK DUCT FOR EXTERNAL LIGHTING
 - 150mm BLACK TWIN WALLED DUCT
 - EXTERNAL PTZ DOME CAMERA PROVIDING GENERAL VIDEO SURVEILLANCE

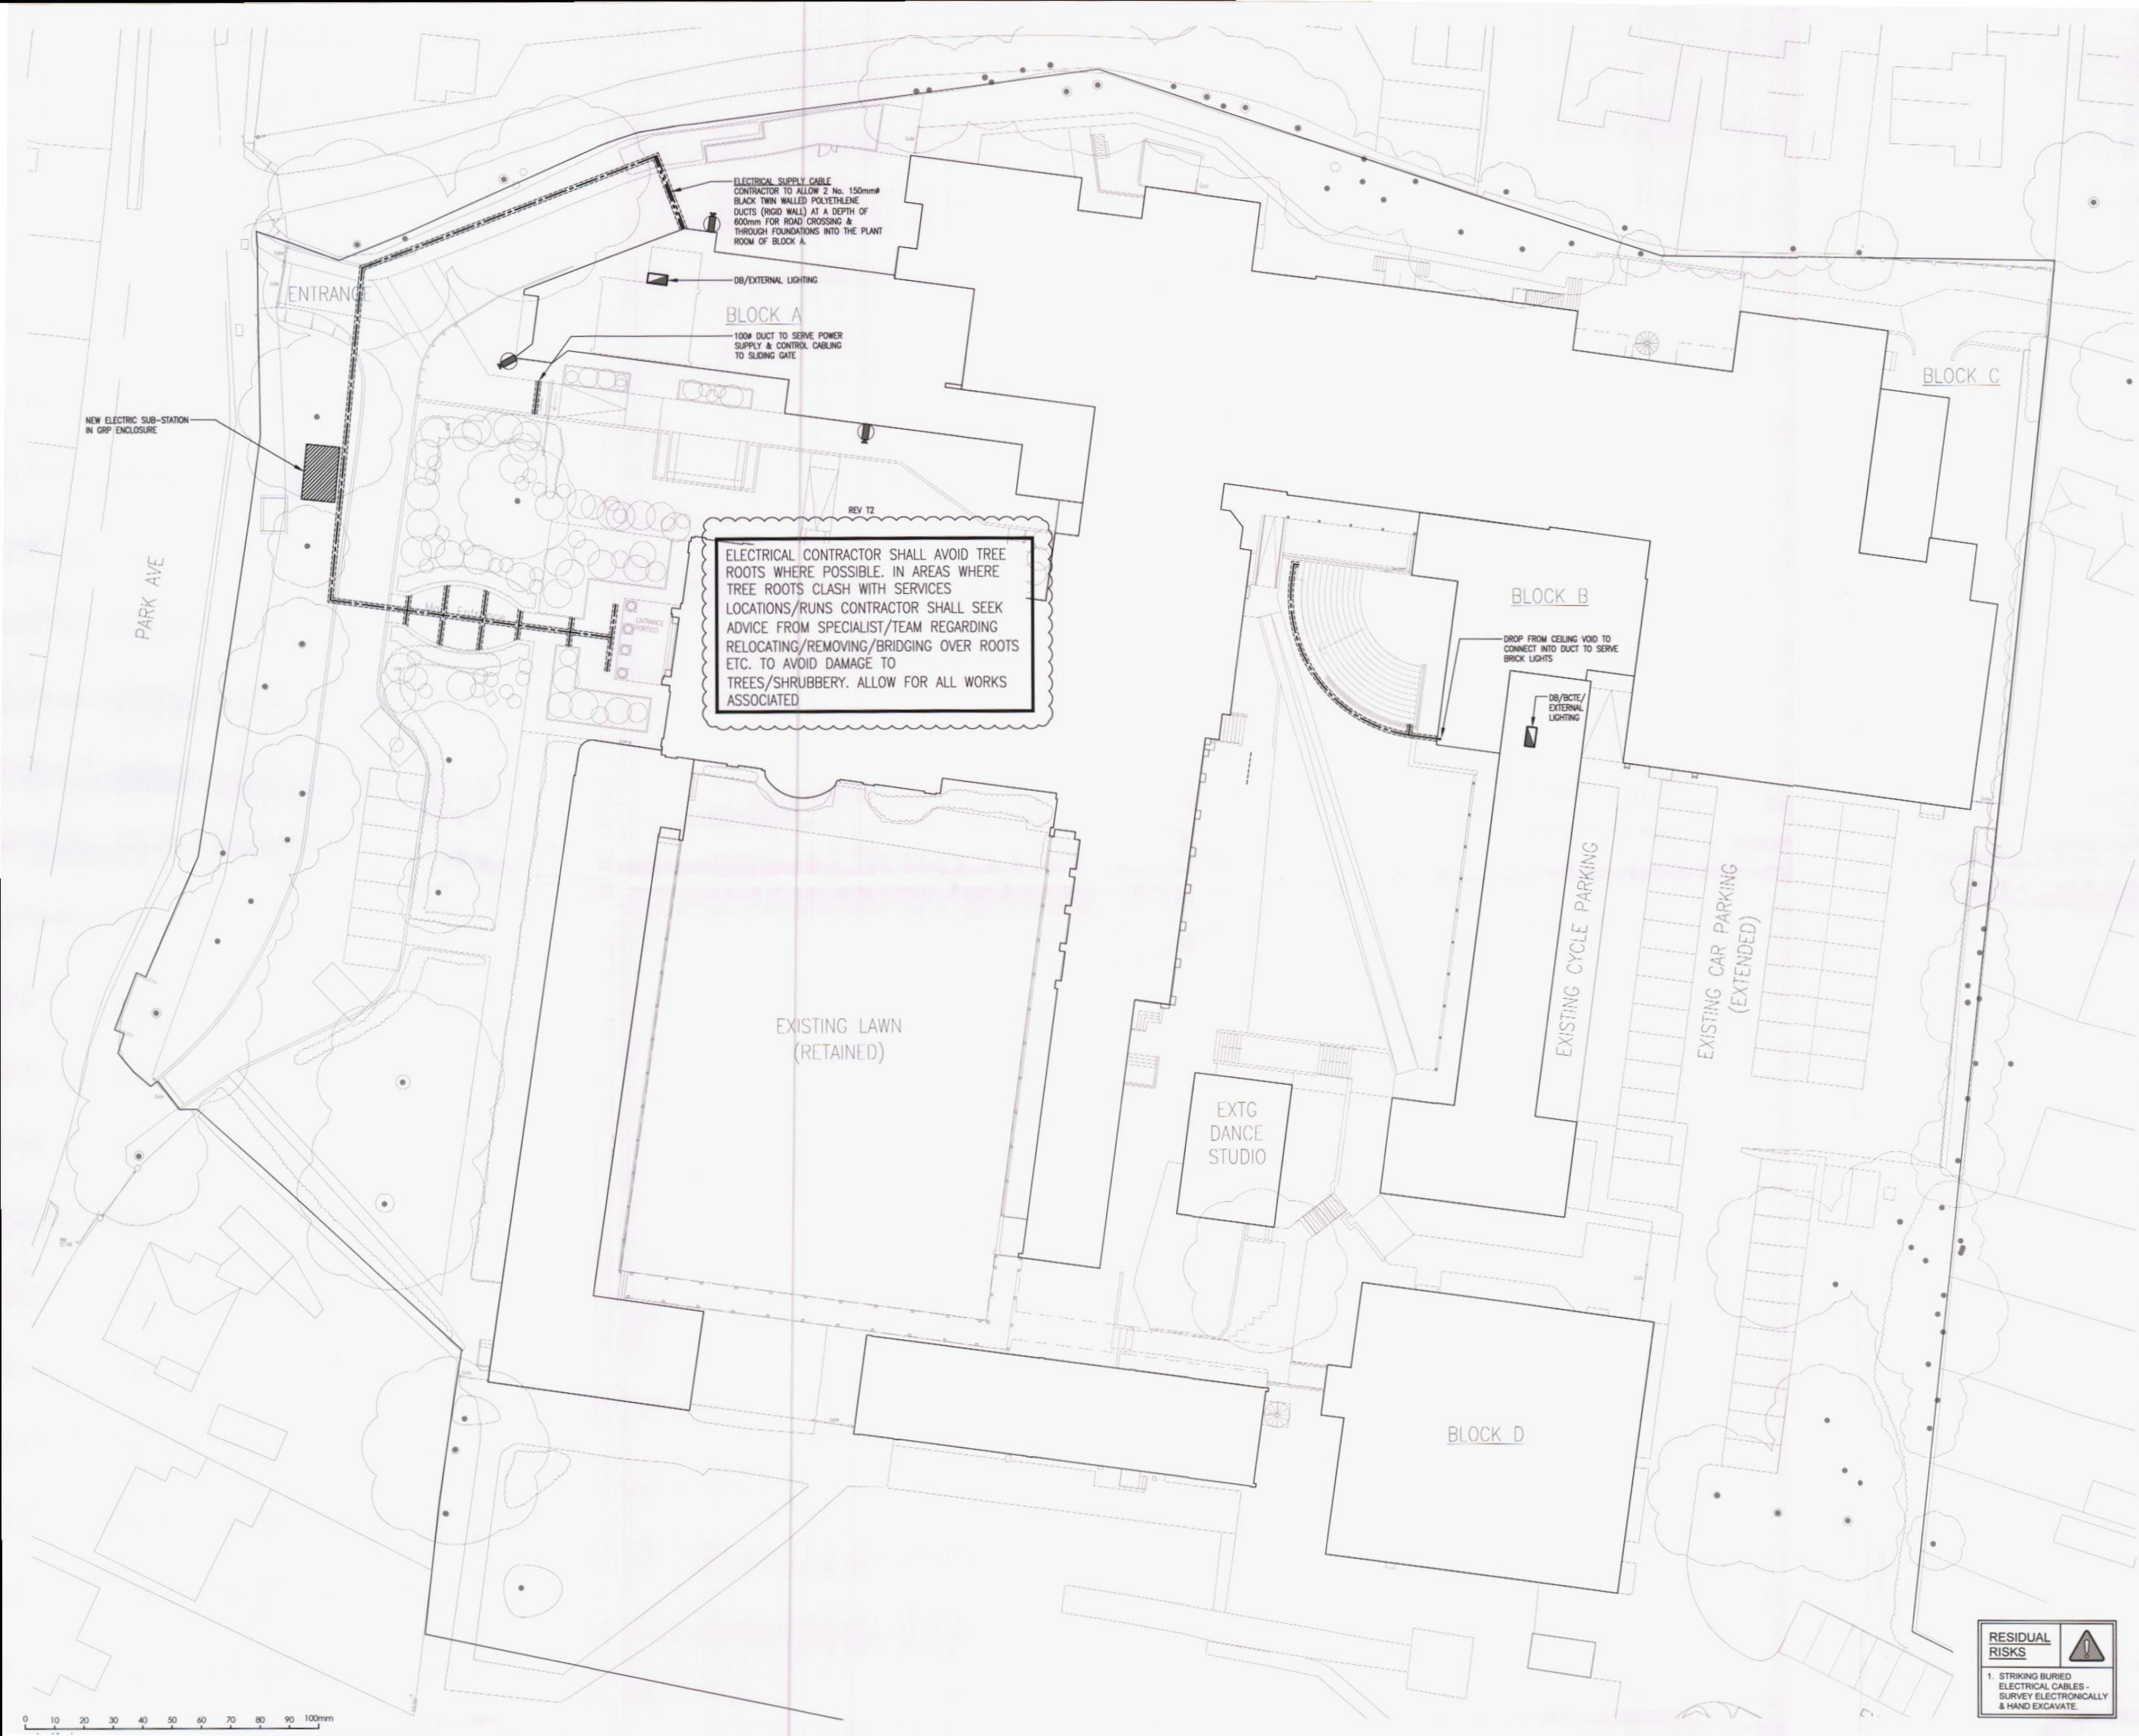

HAVANT BOROUGH COUNCIL
- 1 DEC 2014

Issue Date NOV14 GAD:TF ENG:RC
T2 TENDER ISSUE
REVISIONS CLOUDED

Issue Date OCT14 CAD:KC ENG:RC
T1 TENDER ISSUE

hendersongreen
Consult > Consider > Deliver
Henderson Green Limited
t: +44 (0)23 8022 5900 e: headoffice@hgce.co.uk
www.hendersongreen.co.uk
Jersey Southampton Guernsey

Client
**PURBROOK PARK SCHOOL
WATERLOOVILLE**

Project
**PURBROOK PARK SCHOOL
REDEVELOPMENT**

Title
**EXTERNAL SERVICES LAYOUT
PROPOSED TRENCHING & DUCTS**

Originator CAD/ENG. Original Date Scale @ A1
KC/RC OCT14 1:250
Job No. Drawing No. Issue
J2140115 E2(XT)213 T2

**RESIDUAL
RISKS**
1. STRIKING BURIED
ELECTRICAL CABLES -
SURVEY ELECTRONICALLY
& HAND EXCAVATE.

0 10 20 30 40 50 60 70 80 90 100mm