

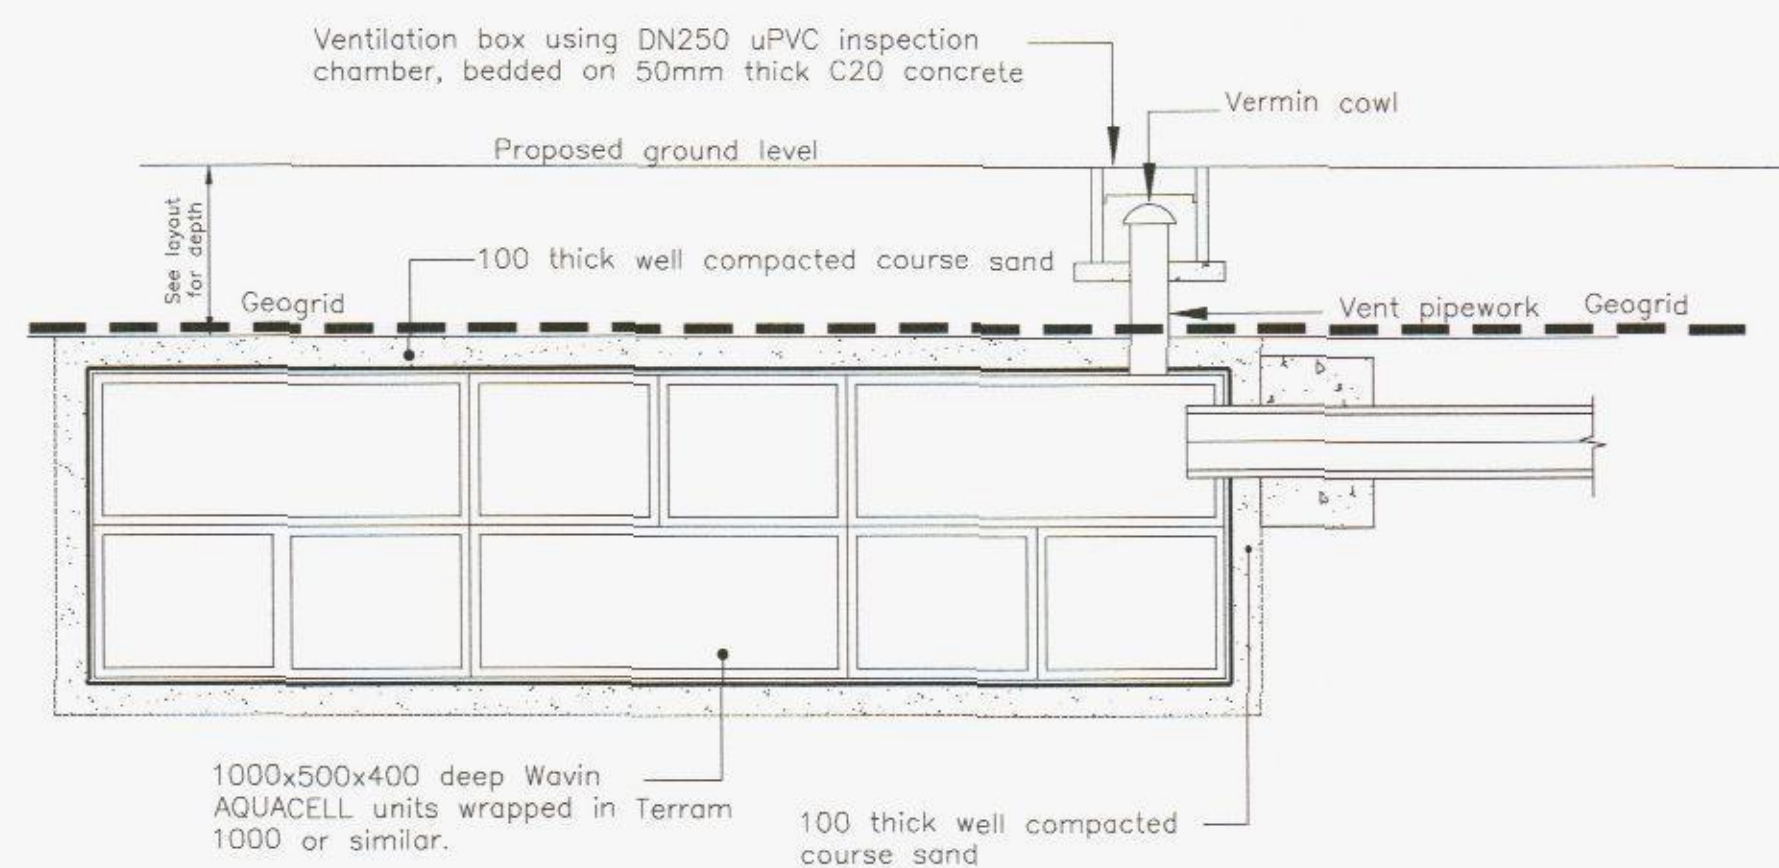
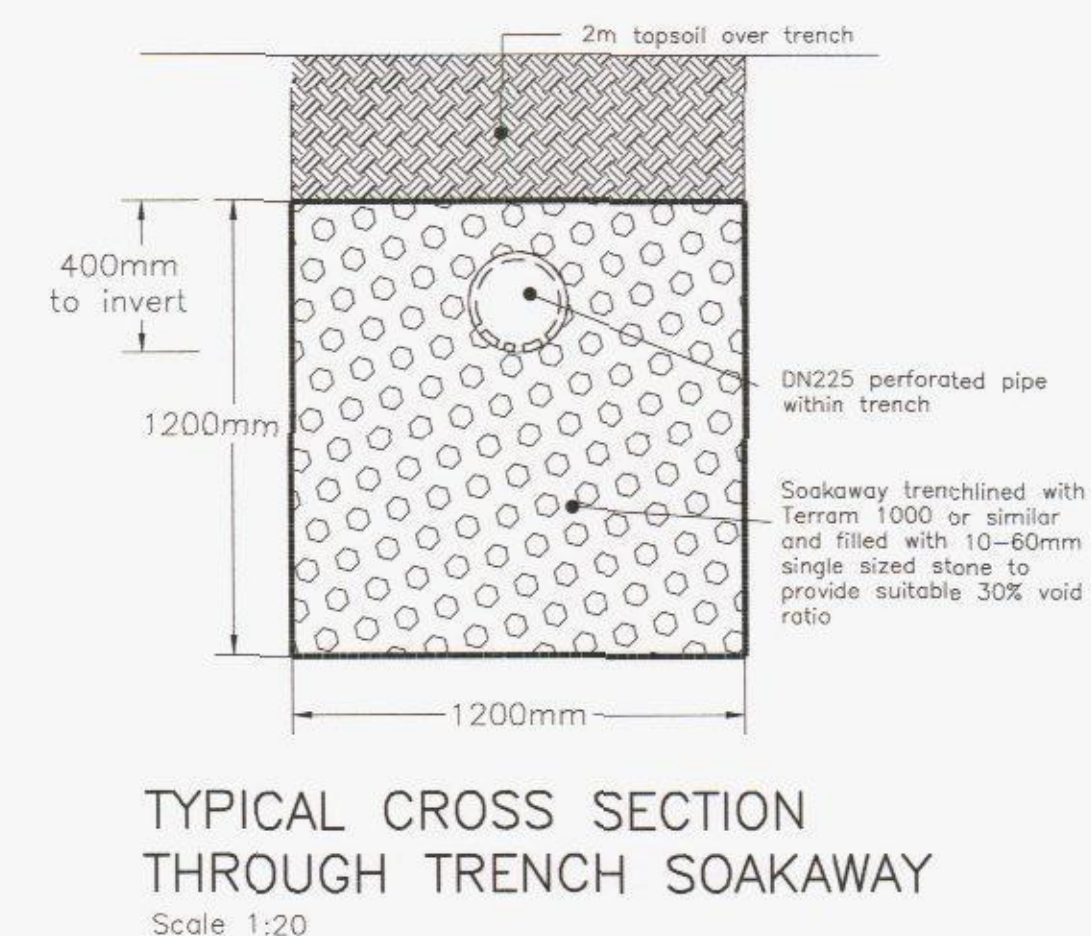


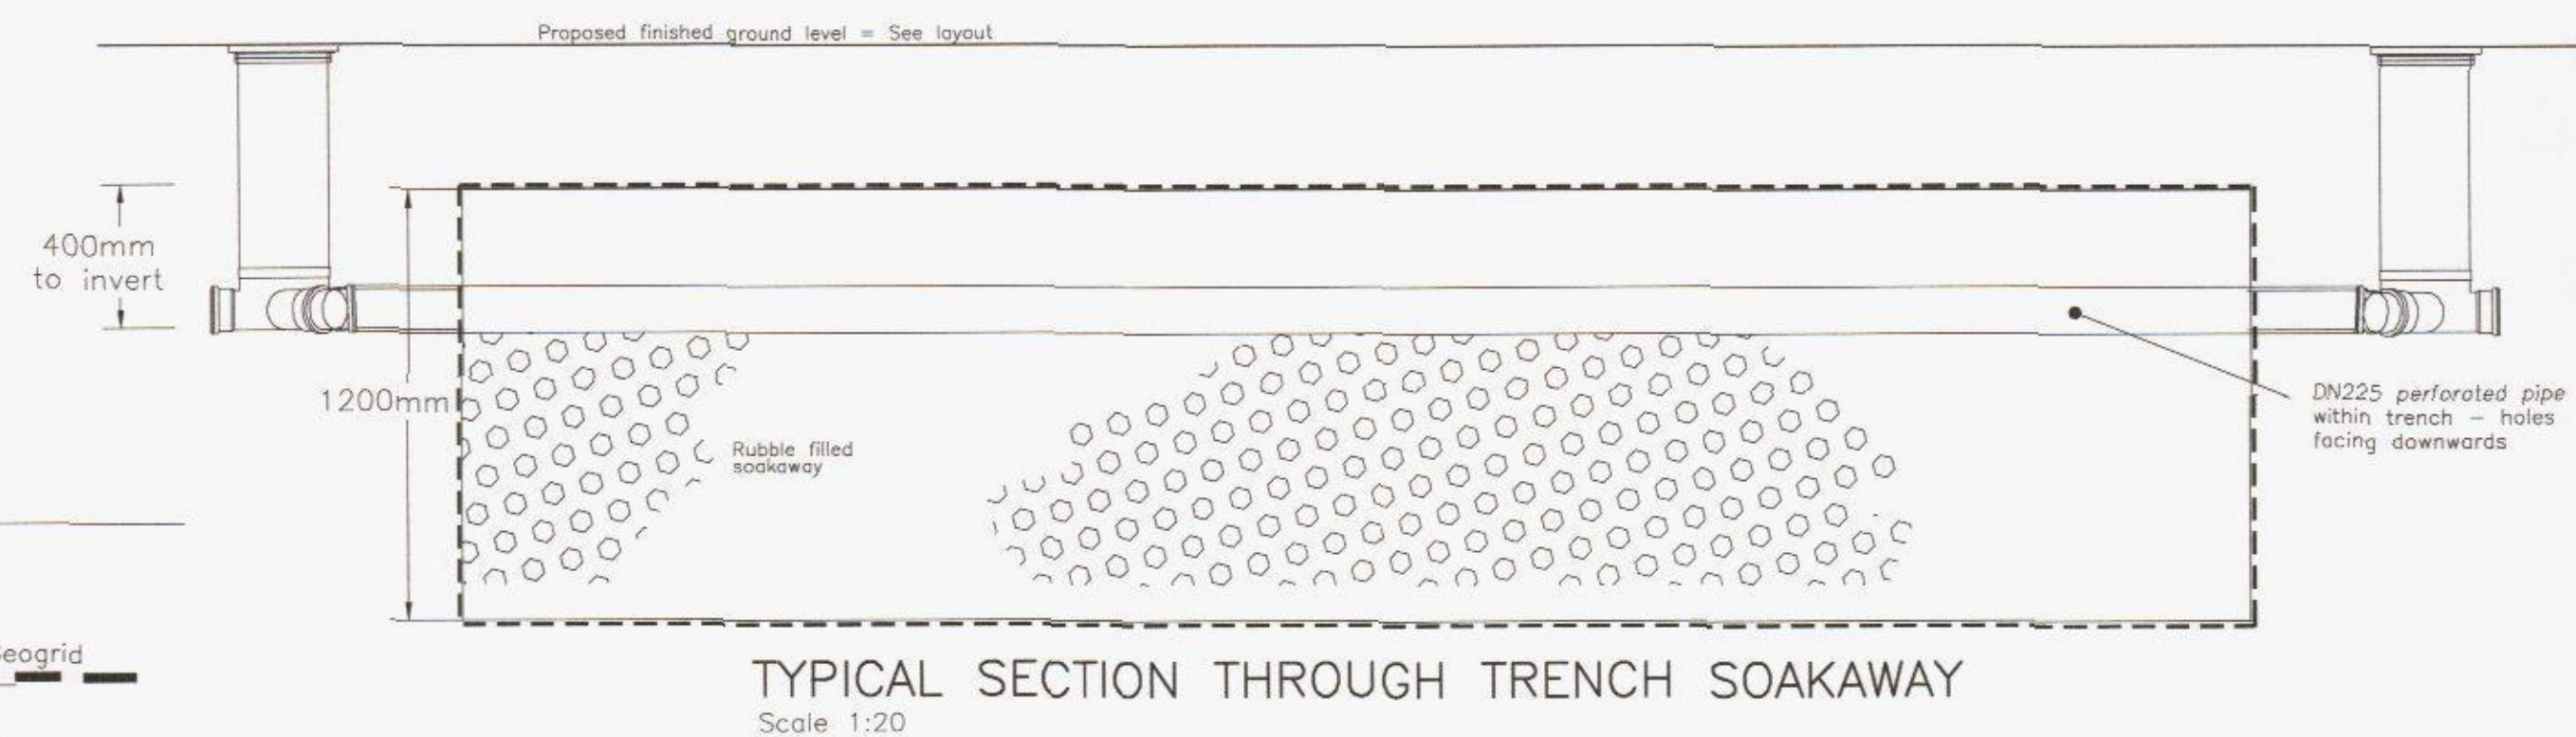


TYPICAL SECTION THROUGH AQUACELL CRATE SOAKAWAY
SEE DRAINAGE LAYOUT FOR SIZE AND DEPTH


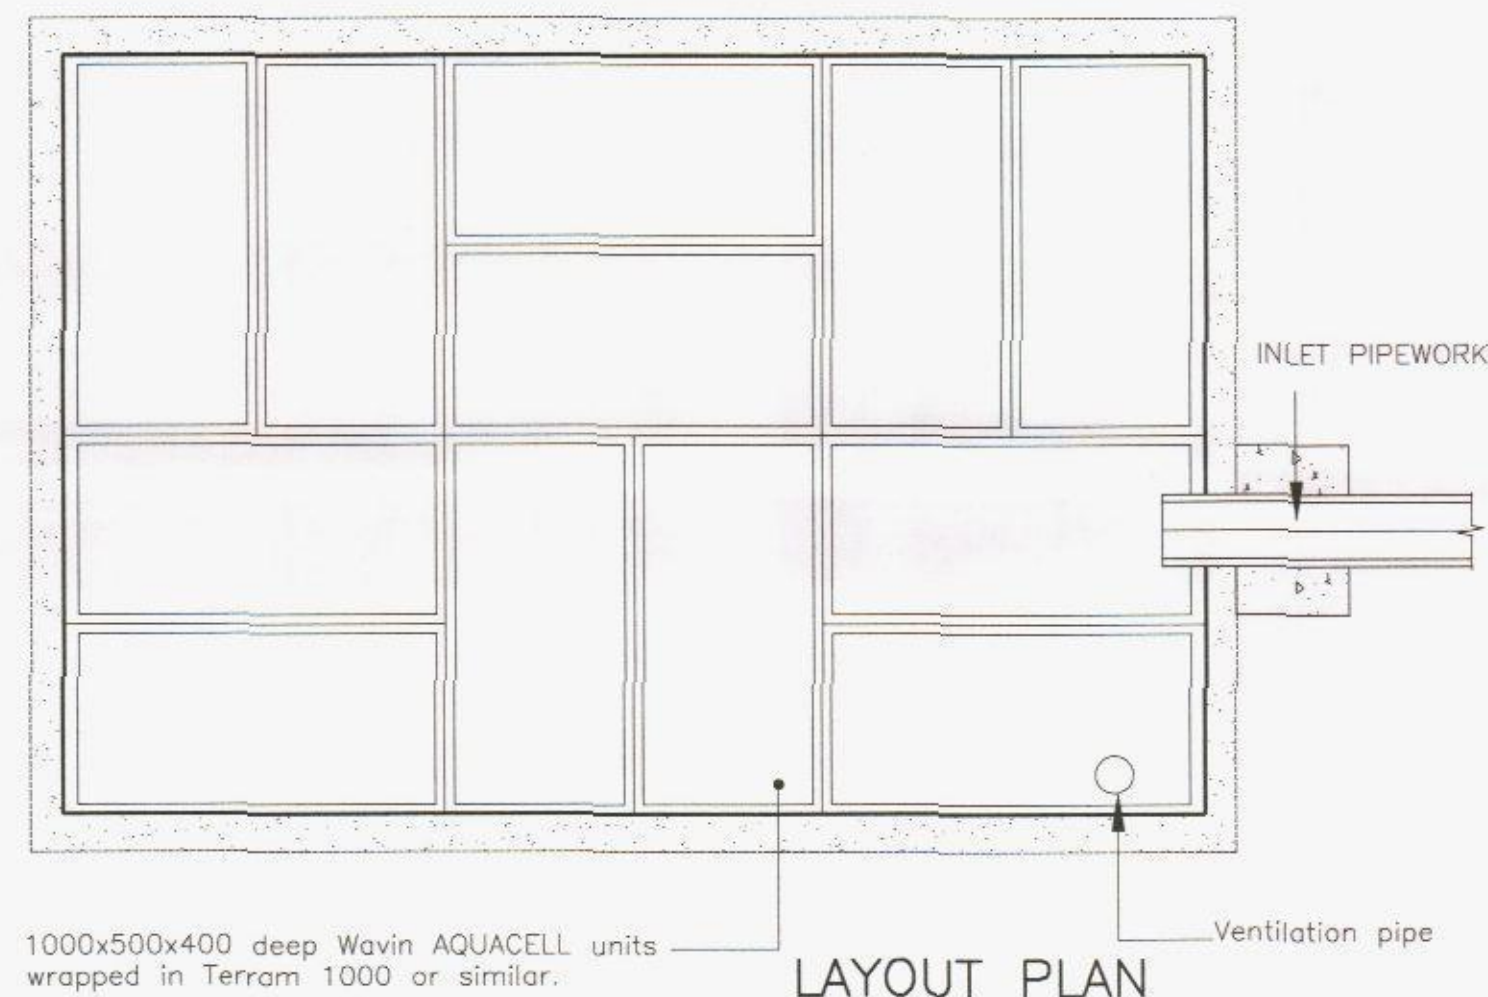


TYPICAL SECTION THROUGH STORMBRIXX CRATE SOAKAWAY
SEE DRAINAGE LAYOUT FOR SIZE AND DEPTH

This drawing is to be read in conjunction with the manufacturer's installation recommendations

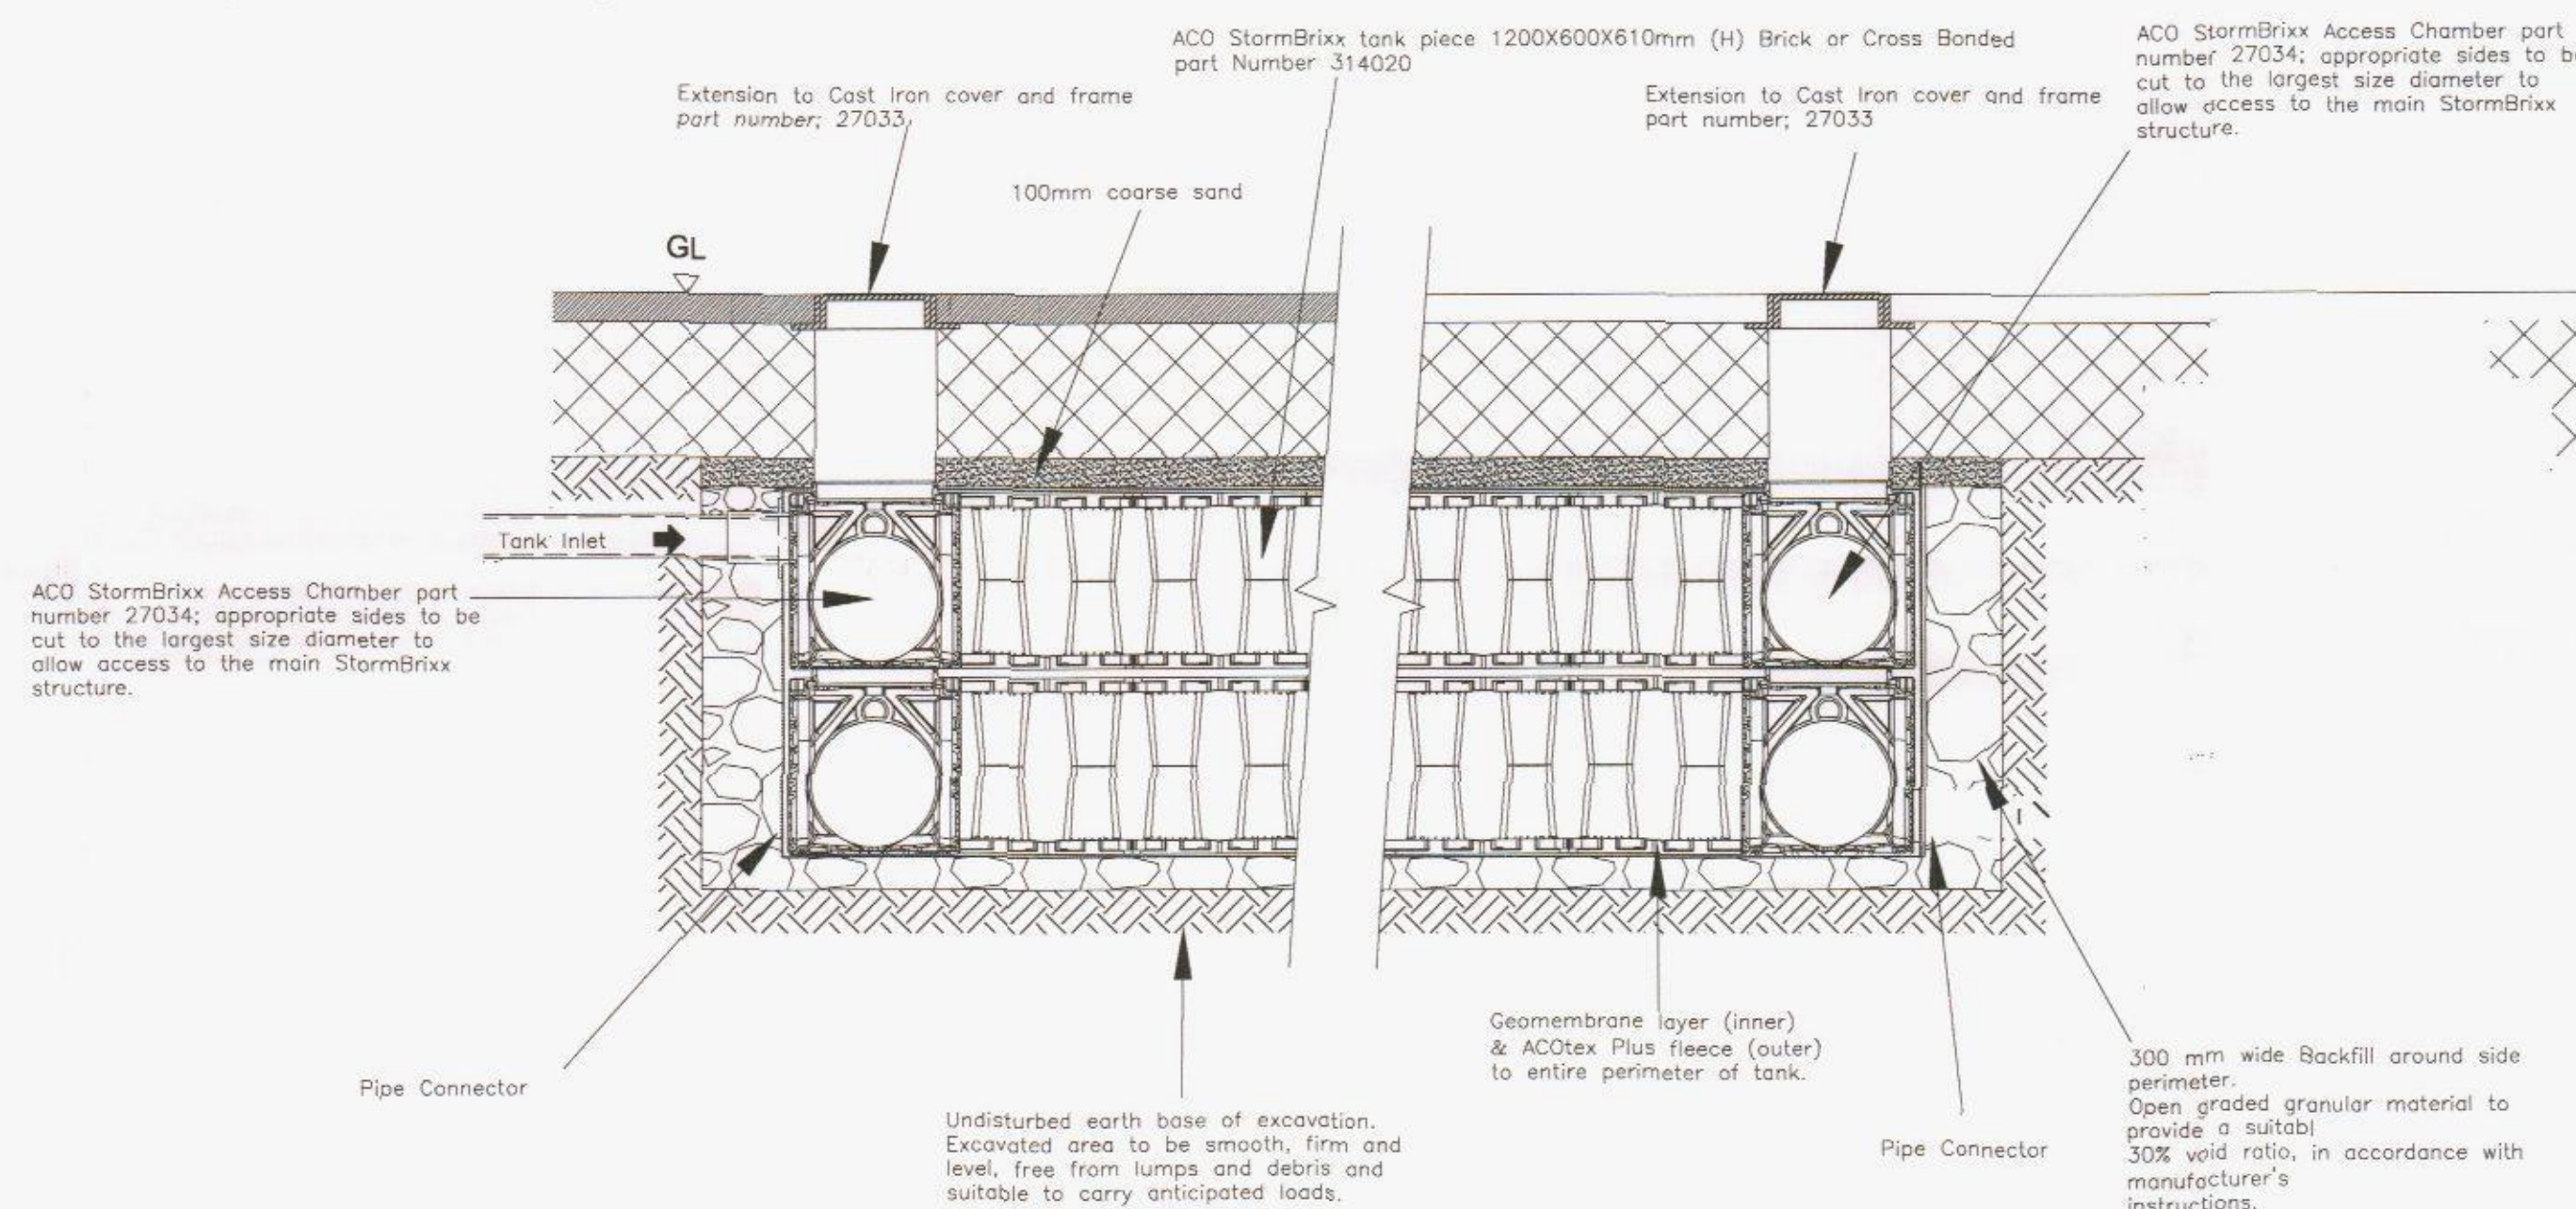

NOTE:
Top covers part Number 314022 shown below to be installed on top layer of StormBrixx Modules only.

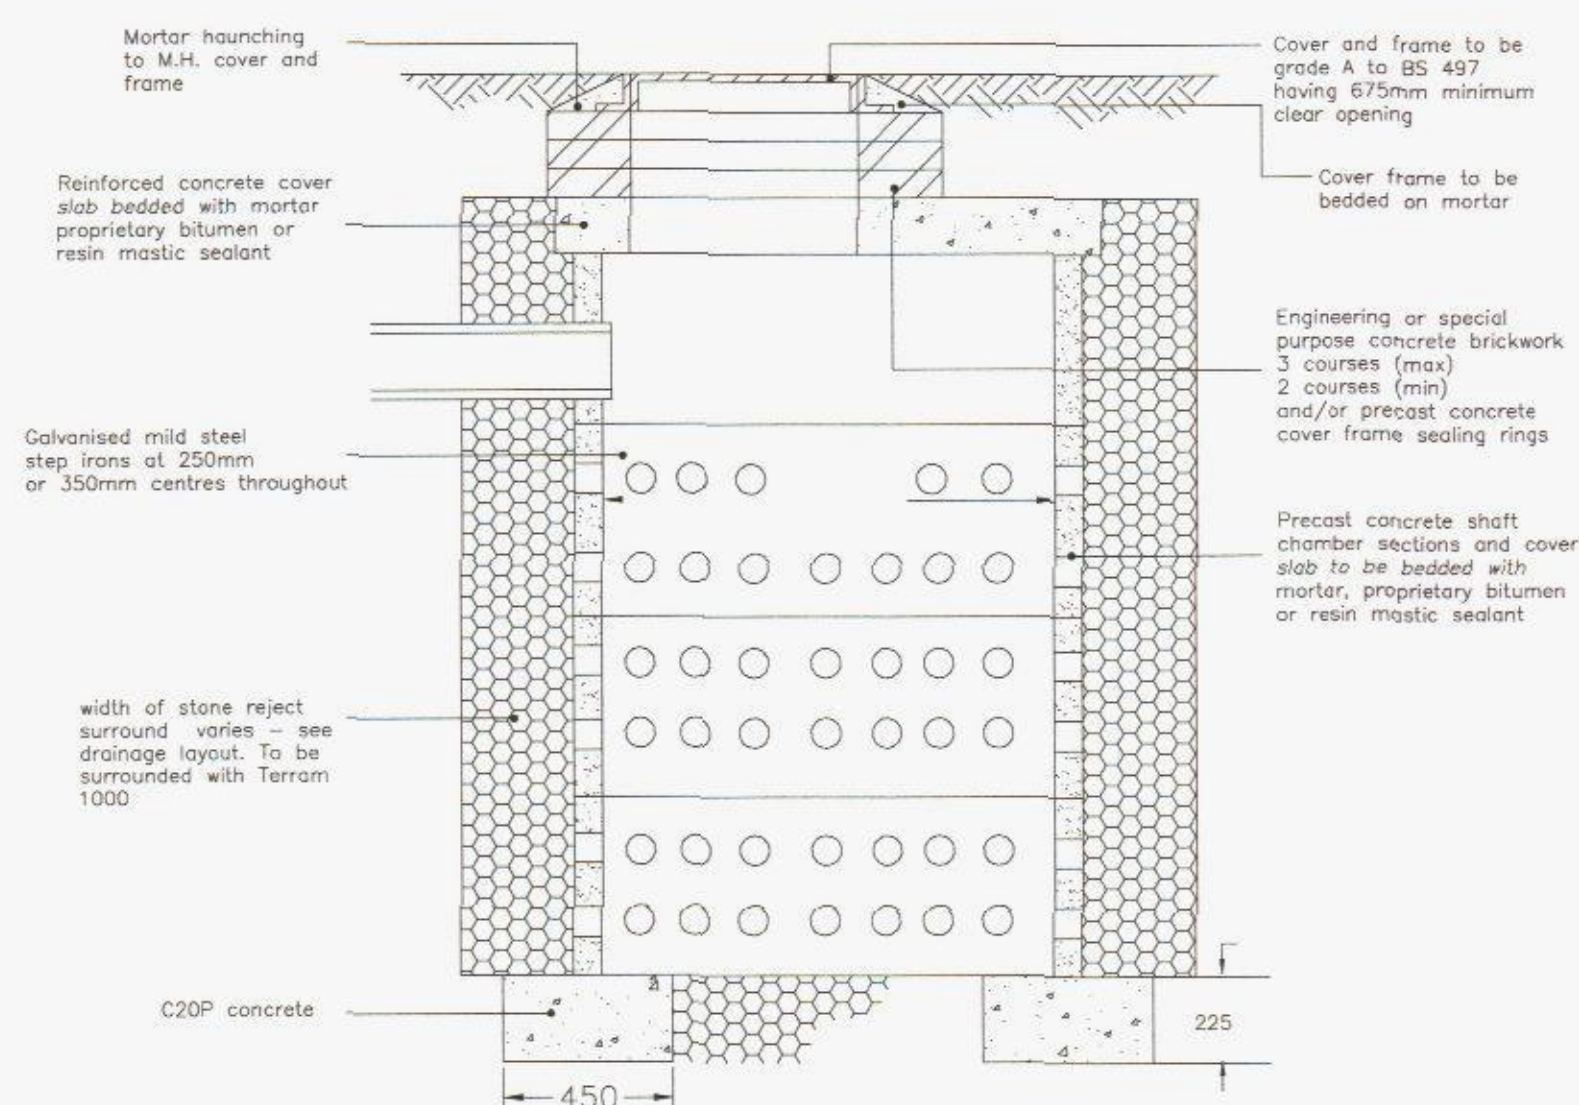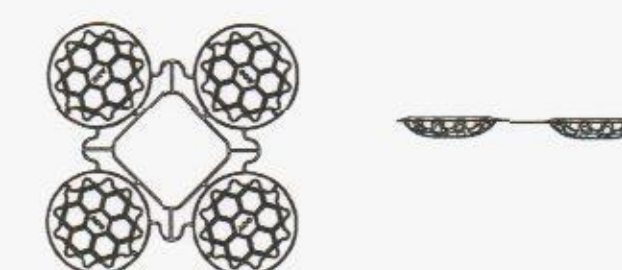

TYPICAL SECTION THROUGH RING SOAKAWAY
NTS
SEE DRAINAGE LAYOUT FOR SIZES AND DEPTHS

HAVANT BOROUGH COUNCIL
- 4 JUN 2014
RECEIVED

REV. No.	DATE	DESCRIPTION	INITIALS
Client	Linden HOMES	MJA CONSULTING CIVIL AND STRUCTURAL ENGINEERS Monarch House, Barton Lane, Abingdon, Oxon, OX14 3NB Tel: 01235 555173 Fax: 01235 523226	
Project	Havant Retail Park Bedhampton		
Title	Private Drainage Construction Details	Scale As shown@A1 Checked KTG	Date April 14 Drawn JOK
		Drawing No. 4982:22	Rev