


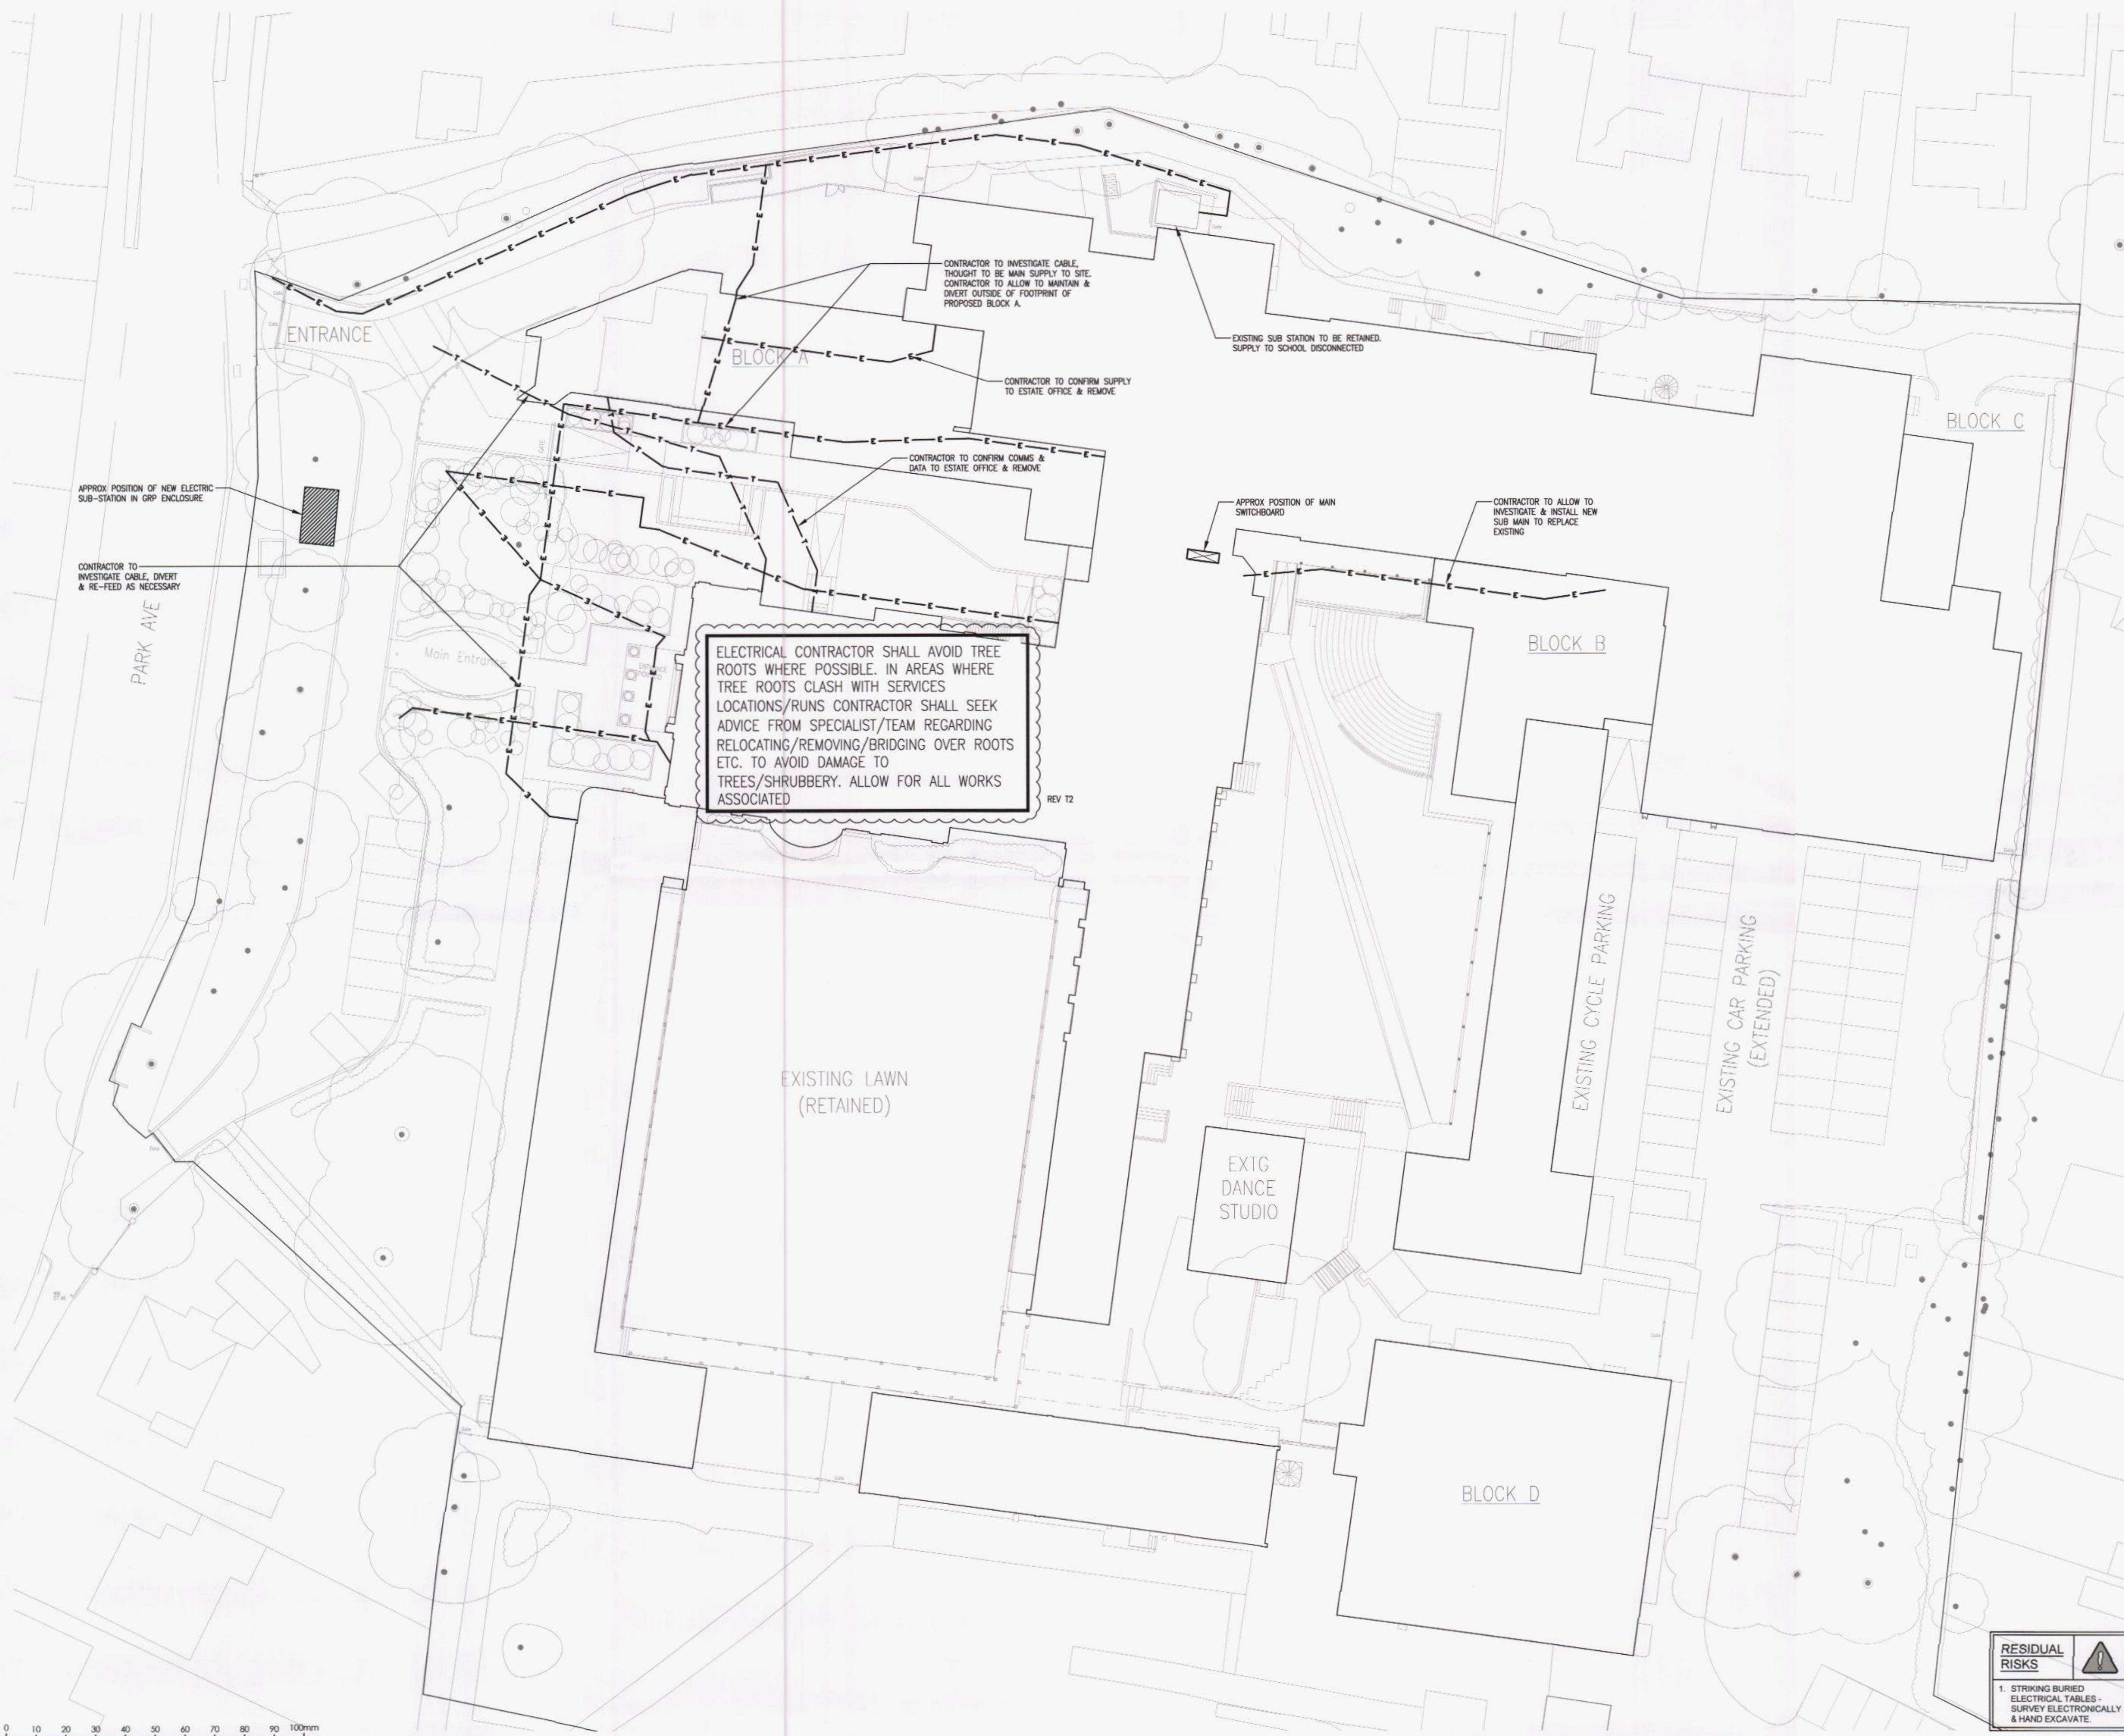

- Do Not Scale**
Copyright © 2014 Henderson Green Ltd.
This is not a working drawing. Figured dimensions shall be checked on site.
This drawing shall be read in conjunction with all relevant consultation and/or specialist drawings/documents.
Any discrepancies or variations shall be notified to the engineer prior to commencement of works.
- STANDARD NOTES**
1. FOR ELECTRICAL LEGEND, SEE PROJECT LEGEND DRAWING NO. E1(00)101.
 2. THIS DRAWING SHALL BE USED IN CONJUNCTION WITH THE LATEST ARCHITECTURAL DRAWINGS & ALL ASSOCIATED ROOM DETAIL DRAWINGS.
 3. THE ELECTRICAL CONTRACTOR SHALL CO-ORDINATE HIS SERVICES LAYOUT IN CONJUNCTION WITH ALL OTHER TRADES. NO WORK SHALL COMMENCE UNTIL HE HAS VERIFIED THAT HIS SERVICES WILL NOT FOUL THOSE OF OTHER SERVICES & TRADES.
 4. INFORMATION ON THIS DRAWING HAS BEEN TAKEN FROM SAFE DIGGER PLAN 3342 BNS DATED 04/14. CONTRACTOR TO CONDUCT CAT & Genny SURVEY TO DETERMINE LOCATIONS OF ALL CABLES TO BE REMOVED/DIVERTED.
 5. ALL EXCAVATIONS TO BE CARRIED OUT BY HAND.
- KEY**
- E — ELECTRICITY CABLE
 - T — TELECOMS/CCTV CABLE

HAVANT BOROUGH COUNCIL
- 1 DEC 2014
RECEIVED

Issue	Date NOV14	CAD ZF	ENG KC
DESCRIPTION			
T2	TENDER ISSUE		
REVISIONS CLOUDED			
Issue	Date OCT14	CAD KC	ENG KC
DESCRIPTION			
T1	TENDER ISSUE		

hendersongreen 

Consult > Consider > Deliver

Henderson Green Limited
t: +44 (0)23 8022 5900 e: headoffice@hgce.co.uk
www.hendersongreen.co.uk
Jersey Southampton Guernsey

Client
**PURBROOK PARK SCHOOL
WATERLOOVILLE**

Project
**PURBROOK PARK SCHOOL
REDEVELOPMENT**

Title
**EXTERNAL SERVICES LAYOUT
EXISTING ELECTRIC & TELECOM CABLES**

Originator CAD/ENG.	Original Date	Scale @ A1
KC/RC	OCT'14	1:250
Job No.	Drawing No.	Issue
J2140115	E2(XT)214	T2

RESIDUAL RISKS


1. STRIKING BURIED ELECTRICAL TABLES - SURVEY ELECTRONICALLY & HAND EXCAVATE.