


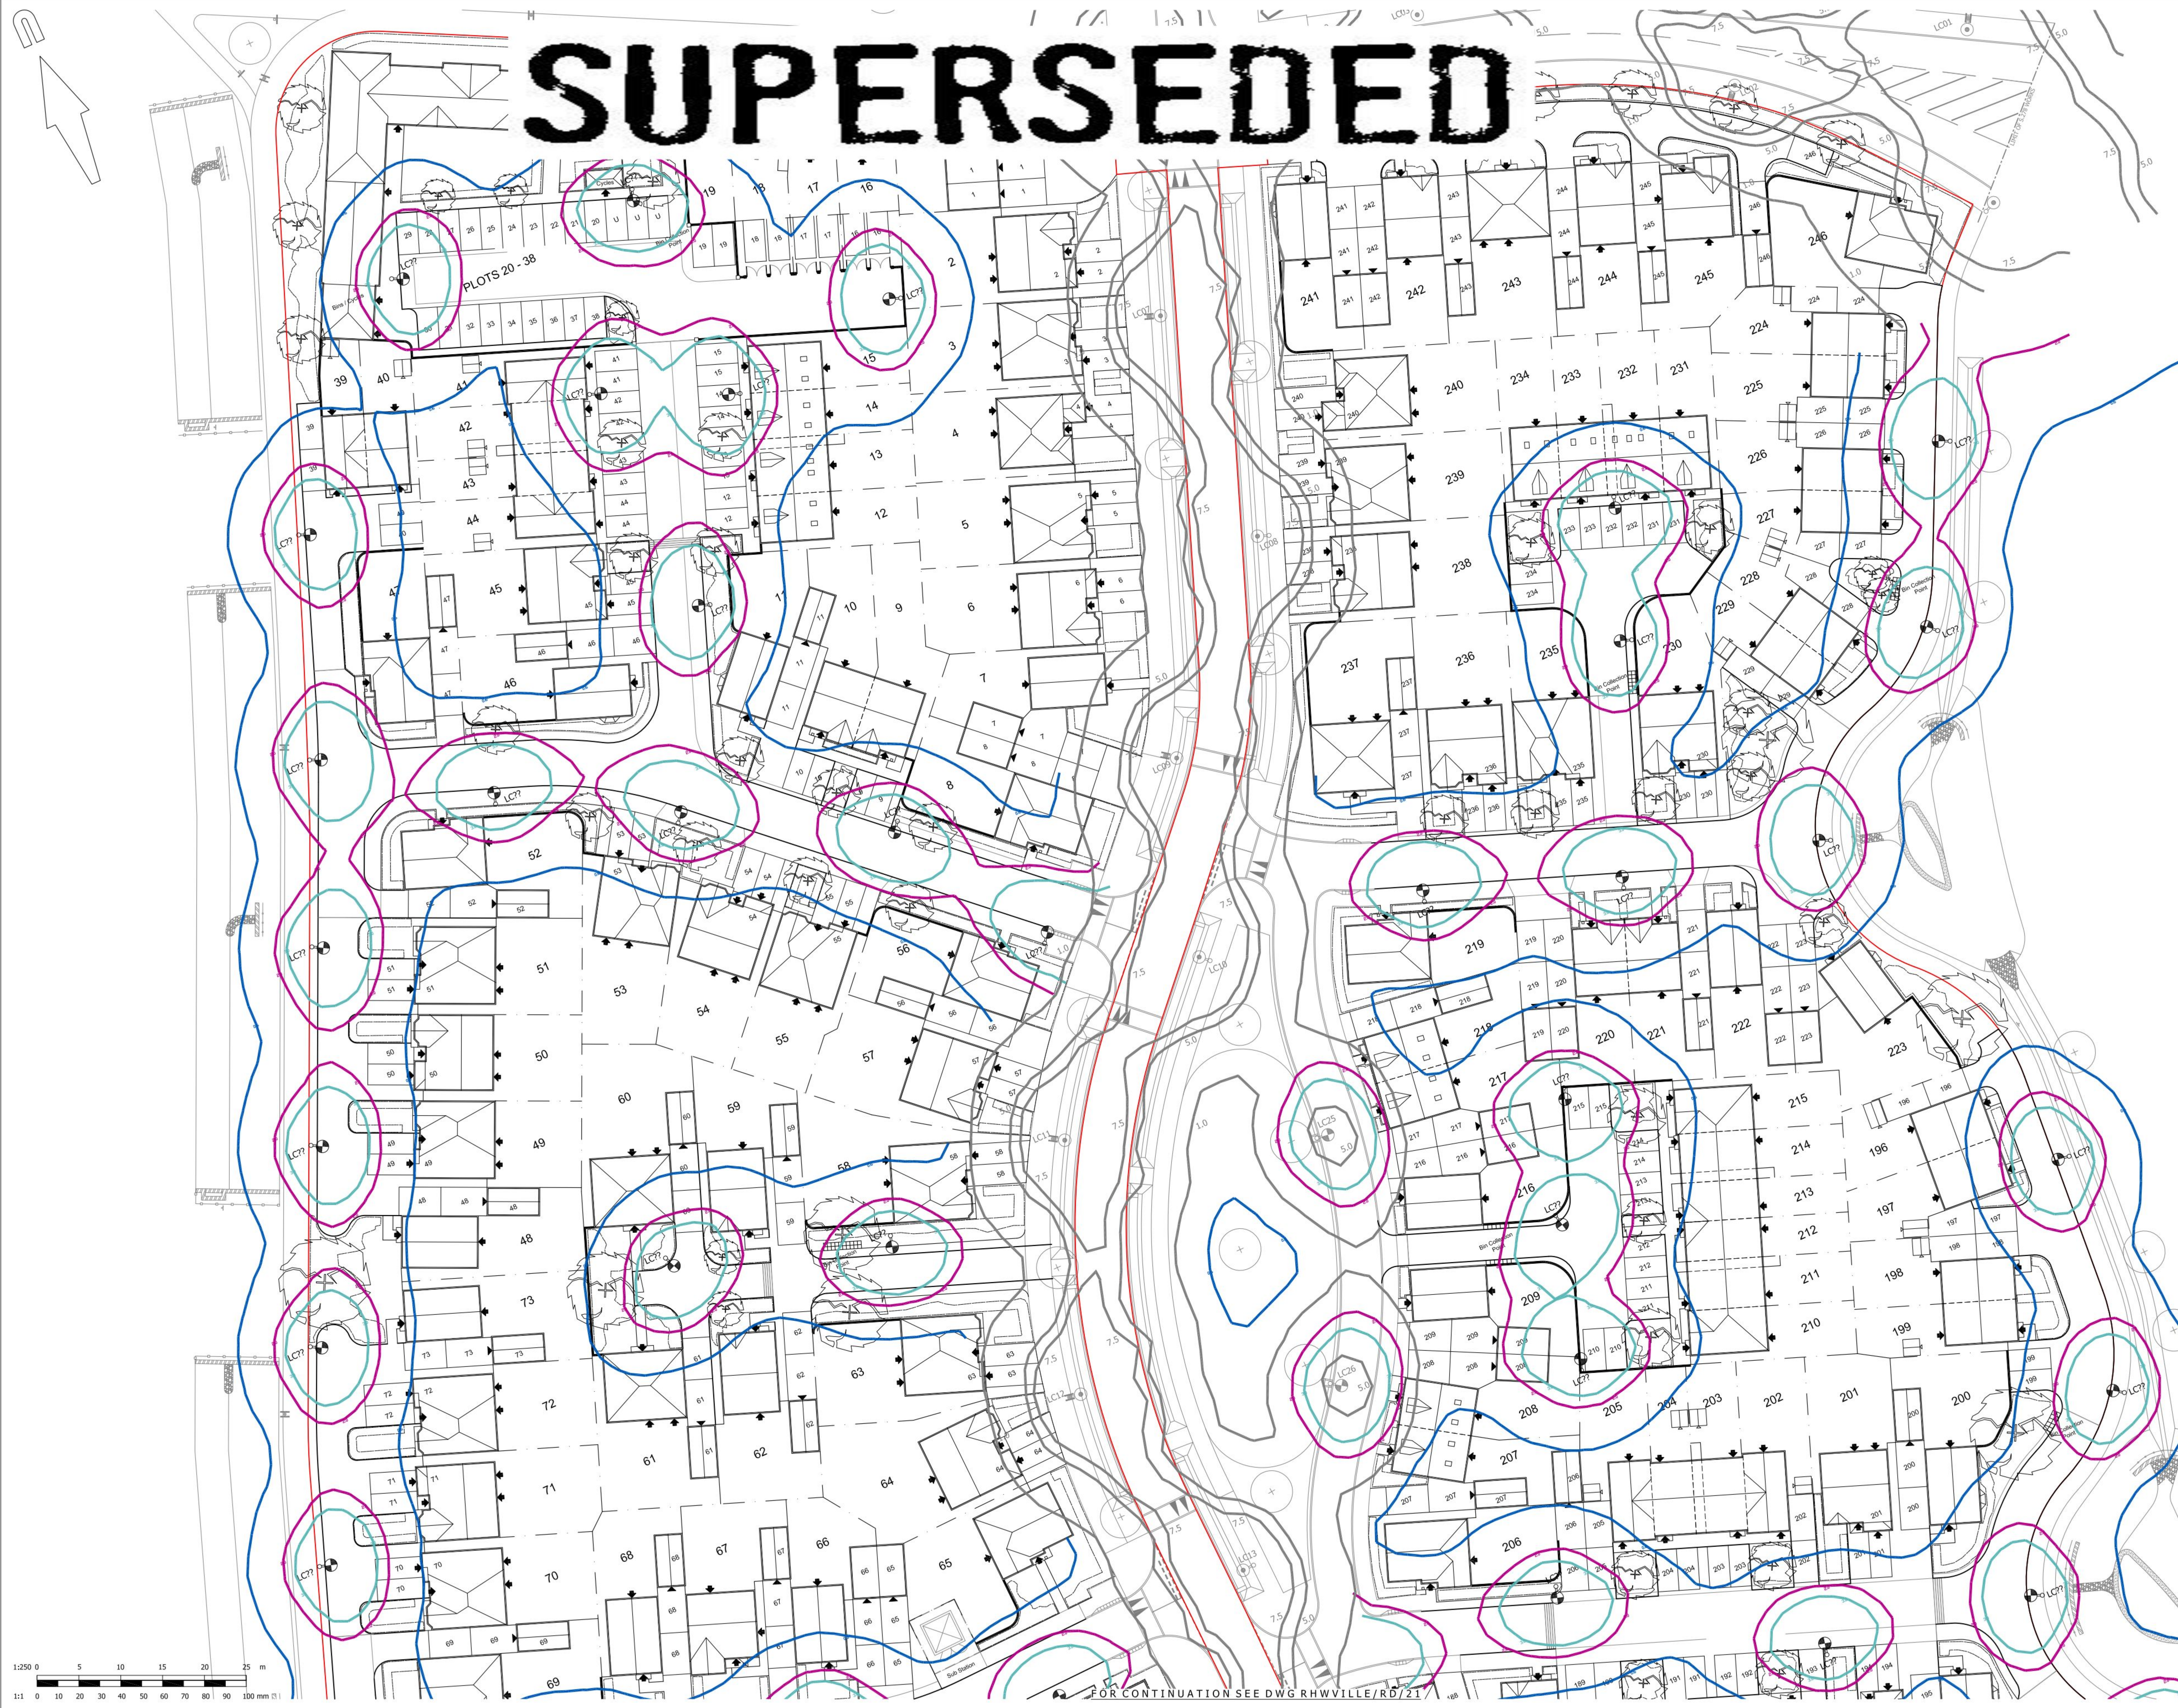

© Mayer Brown Limited Copyright. The drawings, information and data recorded in this document ("the information") is the property of Mayer Brown. This document and the information are solely for the use of the authorised recipient and the document may not be used, copied or reproduced in whole or part for any purposes other than which it was supplied by Mayer Brown. Mayer Brown makes no representation, undertakes no duty and accepts no responsibility to any third party who may use or rely upon this document or the information.

A0 ORIGINAL

- KEY:
- LC PROPOSED 6m COLUMN (TYPE A), POST TOP MOUNTED, 5° TILT WITH VRLT ARC LCPG-TW 60W LUMINAIRE (6.90 km), MATRIX NO. 2686 ASR FG SNN/1A.
 - LC PROPOSED 6m COLUMN (TYPE B), POST TOP MOUNTED, 5° TILT WITH METACRAFT GLASTONE TYPE WITH PHILIPS 30W MASTER PL-T LAMP (1.80 km), MATRIX NO. 26W/830/4 PL-T-TOP PHILIP WITHIN A PHILIPS SGS 203 POT OPTIC.
 - * SEE NOTE 9
 - 3.0 ISOLUX CONTOUR
 - 2.0 ISOLUX CONTOUR
 - 0.6 ISOLUX CONTOUR

- Notes:
- Refer to FABRIK drawings for proposed landscaping.
 - Highways arrangements subject to approval by Hampshire County Council.
 - Subs arrangements subject to approval in accordance with the S106 Agreement.
 - Street lighting has been designed to Lighting Category S6.
 - Columns to be painted black. 00E53 to BS4800.
 - Metcraft column to be fitted with Metcraft 'Turner' embellishment kit, and 0.5m Metcraft single post-top mounting bracket to code PMB1031.
 - Dimming ballast HF-R DALI, fitted with Mayflower sleep-in MENA socket.
 - Mayflower Complete Lighting Control DALI Sub-master unit to be installed to control Nodes and link to Central Management System.
 - Where indicated with an asterisk, columns shall be of hinged raised/lowered type. Kallitite Superflex or alternative.

PRELIMINARY
NOT FOR CONSTRUCTION

A		Updated to reflect Tetlow King masterplan (revisions, P0)	PAS	09/01/2014
rev.	amendment	checked	date	



mayer brown

Mayer Brown Limited
Oneil Road, Woking, Surrey GU24 0AB
Telephone 01483 750 506 Fax 01483 750 437
woking@mbm.co.uk www.mayerbrown.co.uk

Client	REDROW HOMES				
Project	BEREWOOD, WATERLOOVILLE PHASE 2 HOUSING				
Scale	1:250	Drawn by	PB	Checked by	PAS
Date	DECEMBER 2013	cad file	RD_20-21.dwg		
Title	STREET LIGHTING LAYOUT SHEET 1 OF 2				
Drawing number	RHVVILLE/RD/20	rev.	A		