
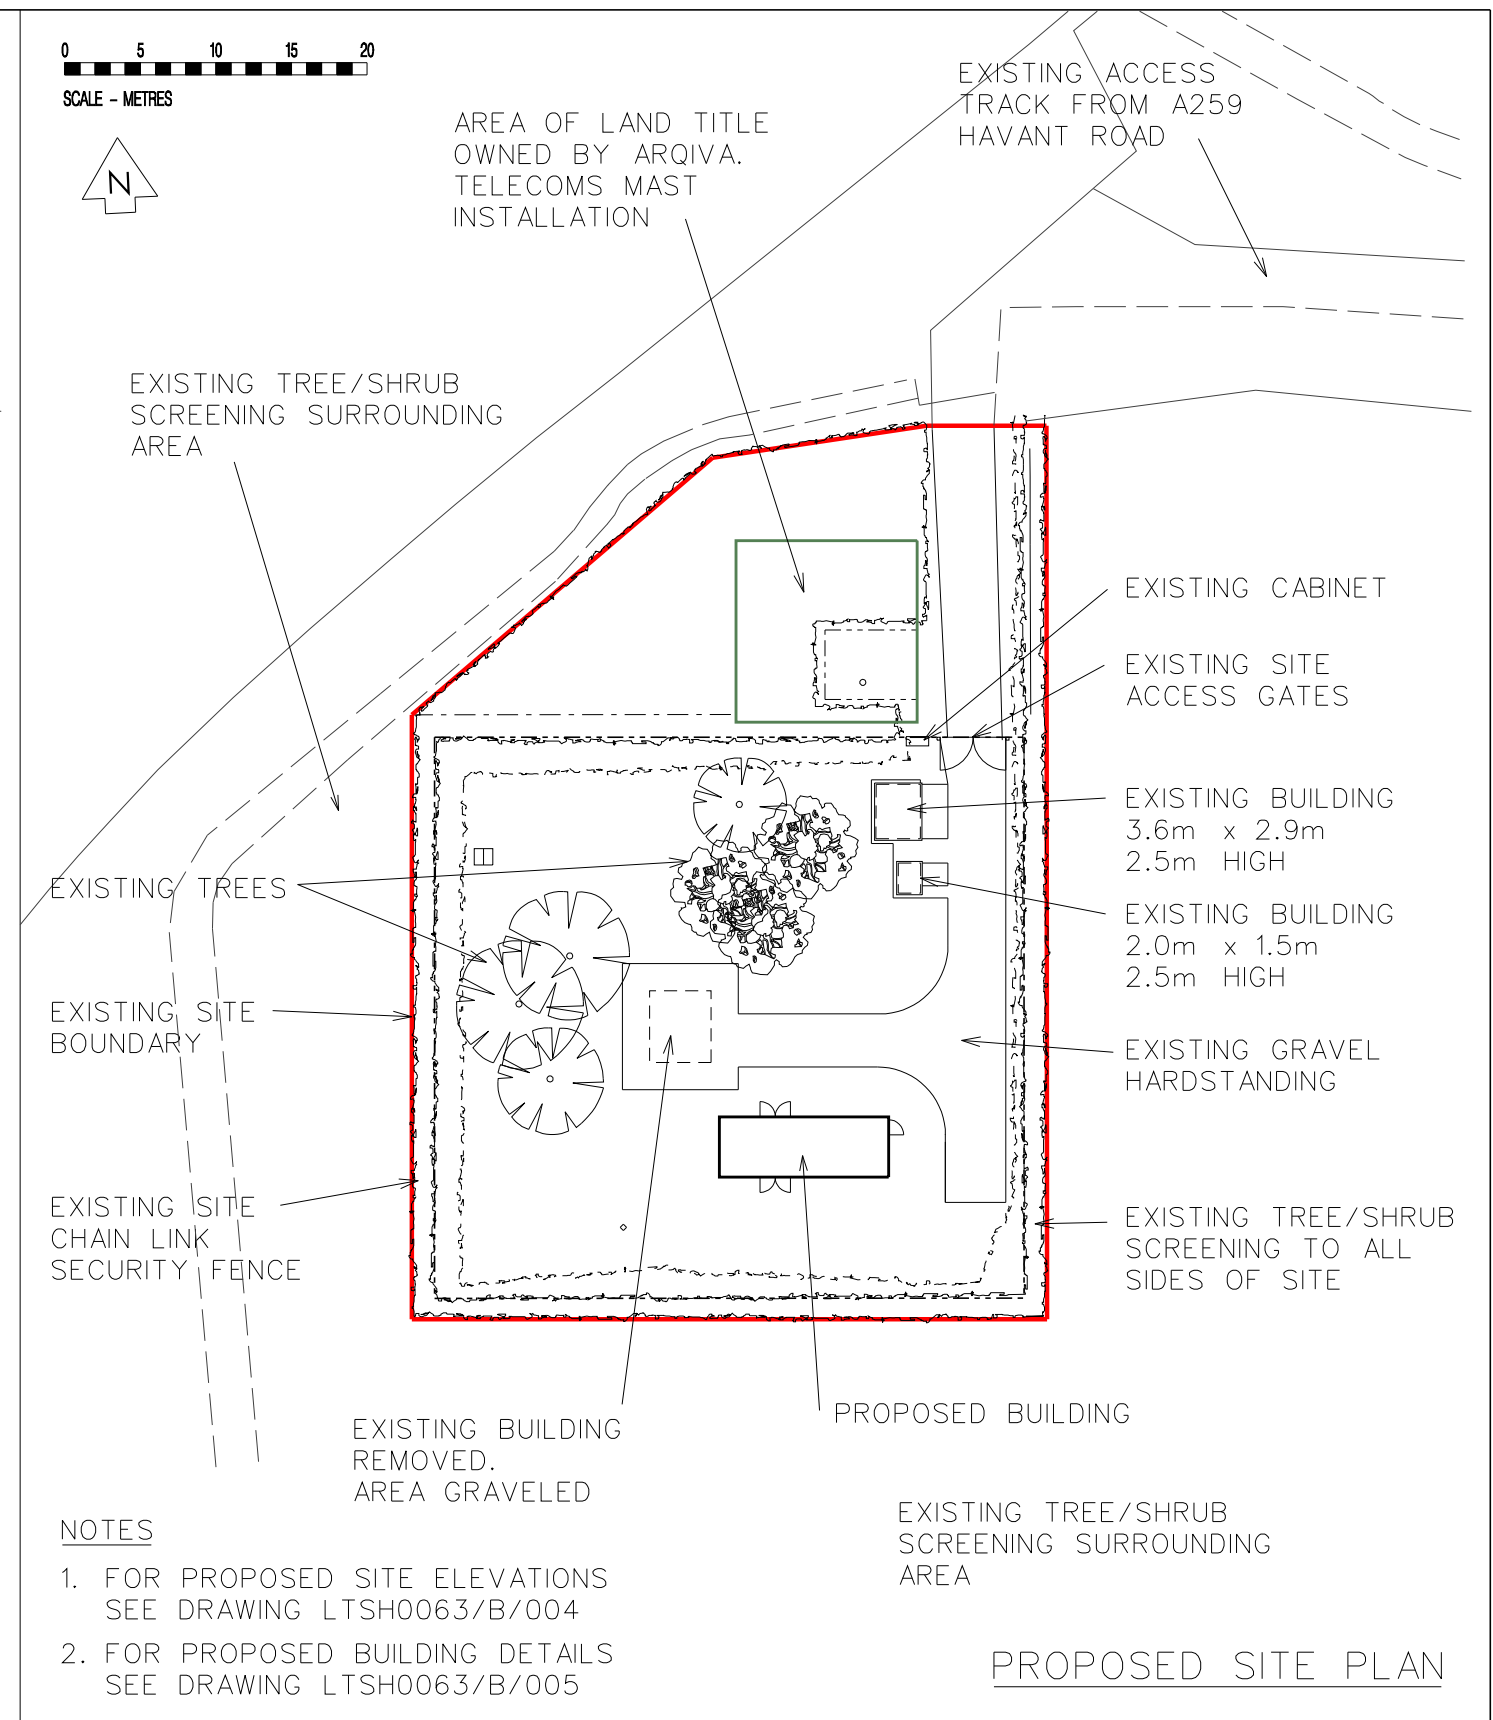


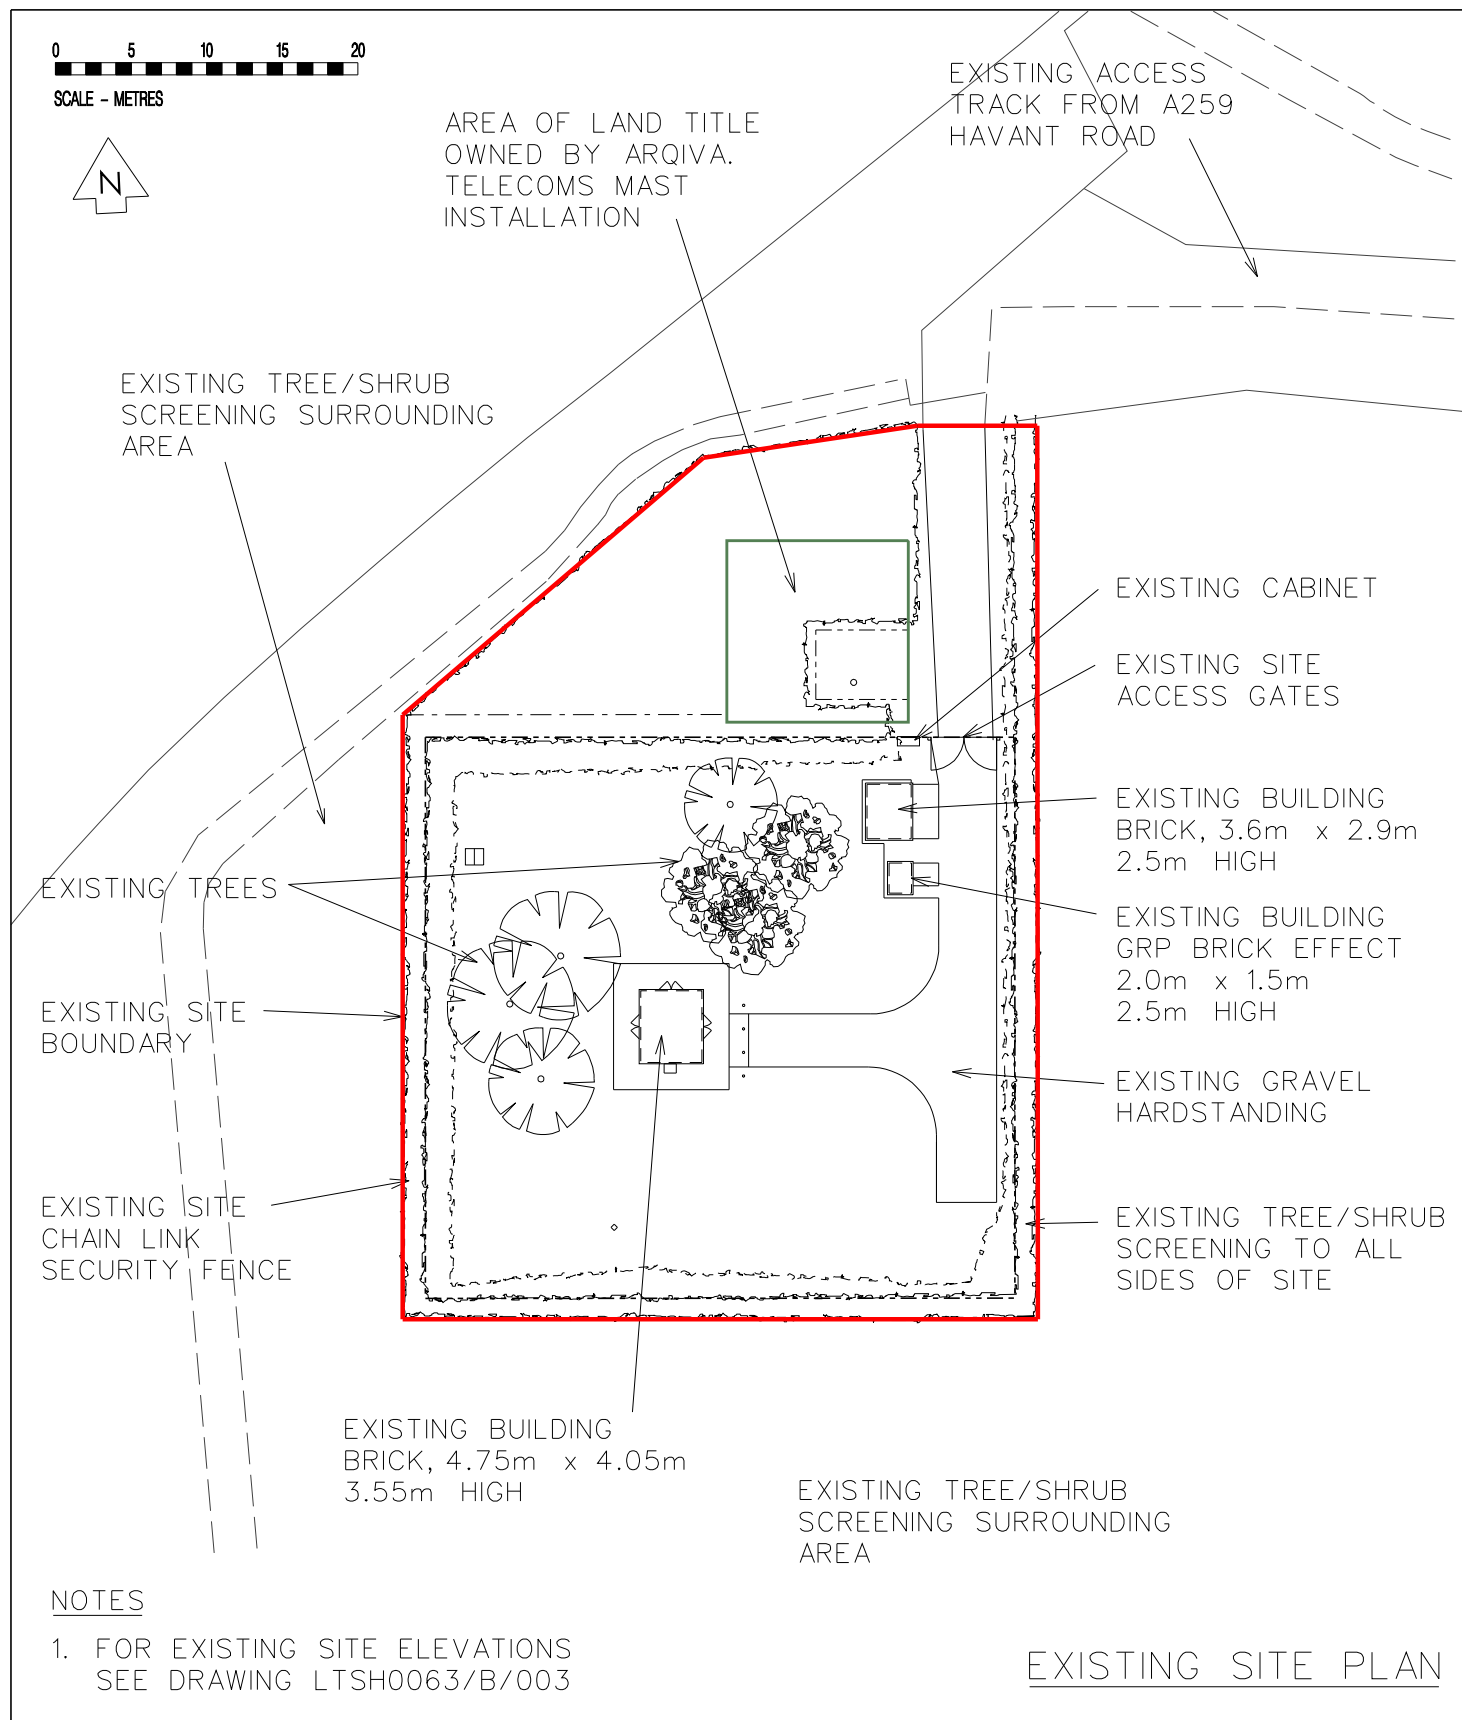

A	22/04/14	GH	ISSUED FOR PLANNING APPLICATION			SITE / PROJECT WARBLINGTON REGULATOR INSTALLATION	DATE 04/14	DR'WN GH	CHK'D	APPR'D		
							SCALE 1:500	A3	© Copyright of Scotia Gas Networks Ltd			
							EXTERNAL REFERENCE			REV.		
REV	DATE	DR'WN	DESCRIPTION	CHK'D	APP'D	TITLE PLANNING APPLICATION EXISTING & PROPOSED SITE PLAN	DRAWING No. LTSH0063/B/002			REV. A		