





Key:

- MH  Existing Surface Water Man Hole
-  New 150mmØ PVC-U pipe

Notes:

1. All rainwater downpipes to have traps fitted at the base to prevent debris getting into the drainage system.
2. All new pipework to have a minimum fall of 1:60

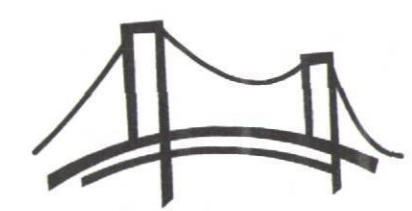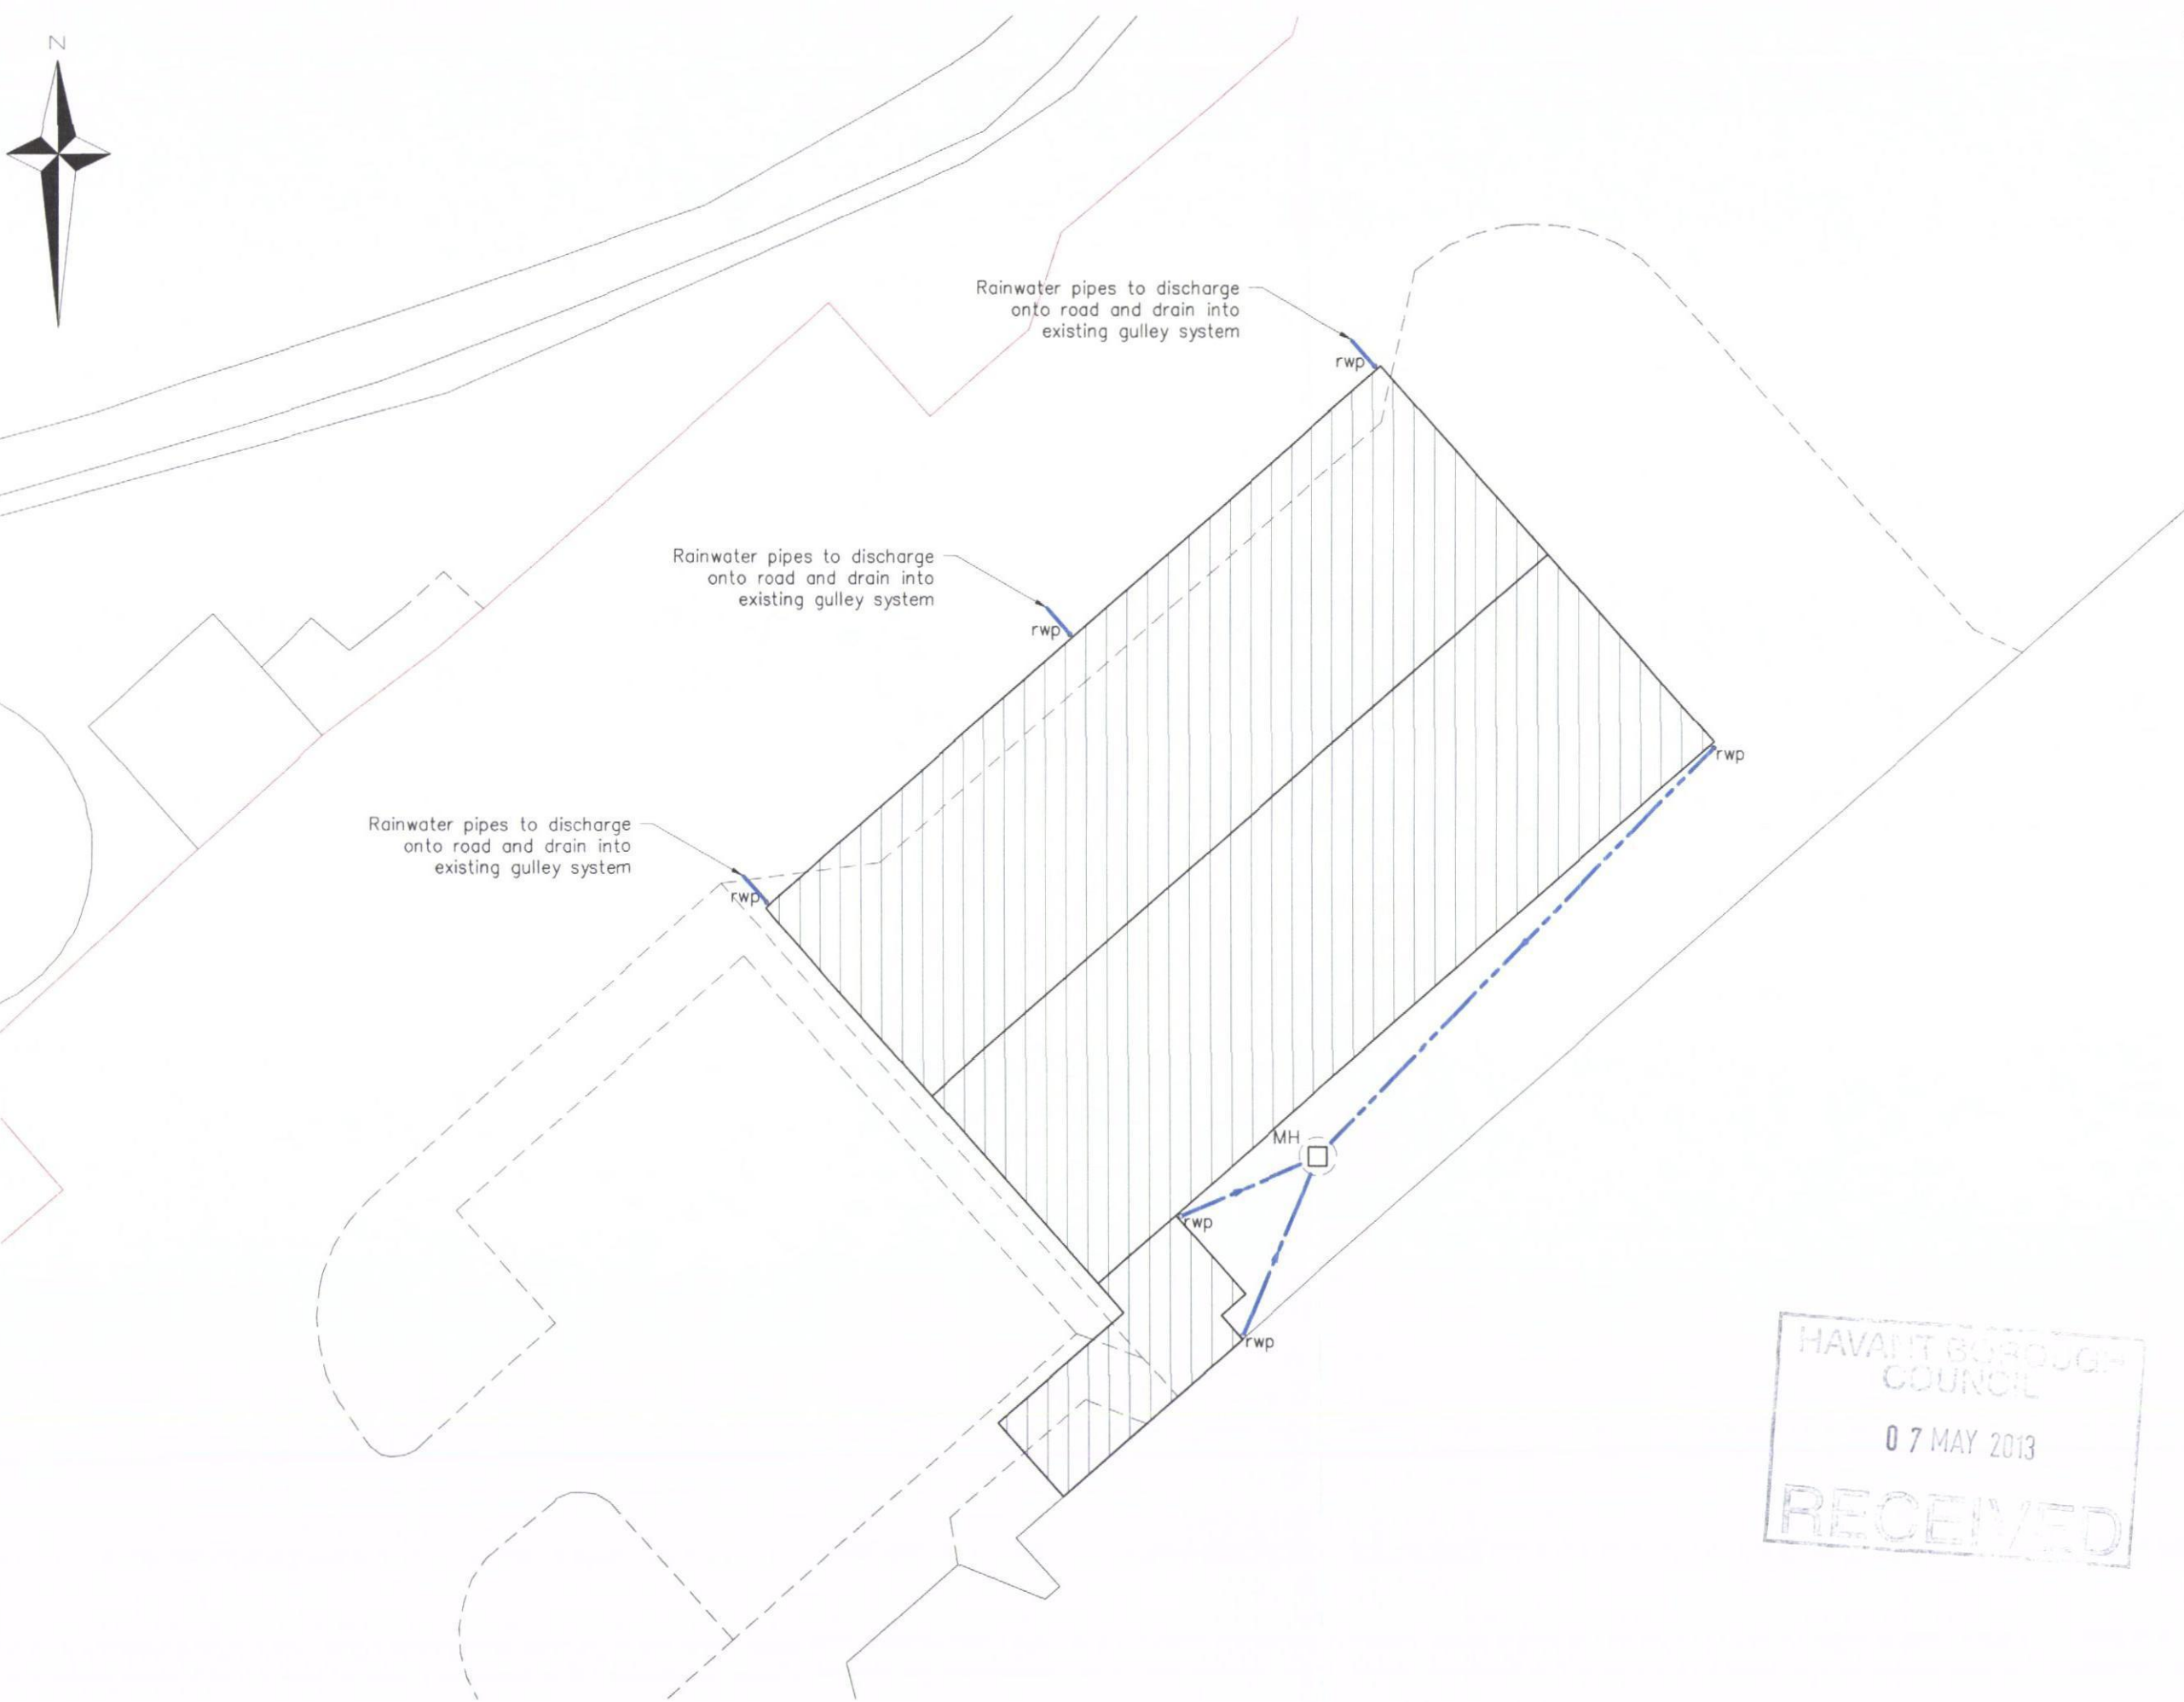

ARVdesign

Rev	Comment	Date
Designer: Ross Vinter		

Client: Smart-Space Buildings Ltd

Project: New Warehouse & Link Building
for Hampshire Cosmetics, Waterlooville

Title: Drainage Layout

Job No.	20199
Drawing No.	DRG09
Revision No.	00
Scale:	1:200 @ A3

© ARV Design
4 Lang Rigg, South Queensferry, EH30 9WN
www.arvdesign.co.uk ross@arvdesign.co.uk
07921 993 680

