





FOR CONTINUATION SEE DWG DR/06

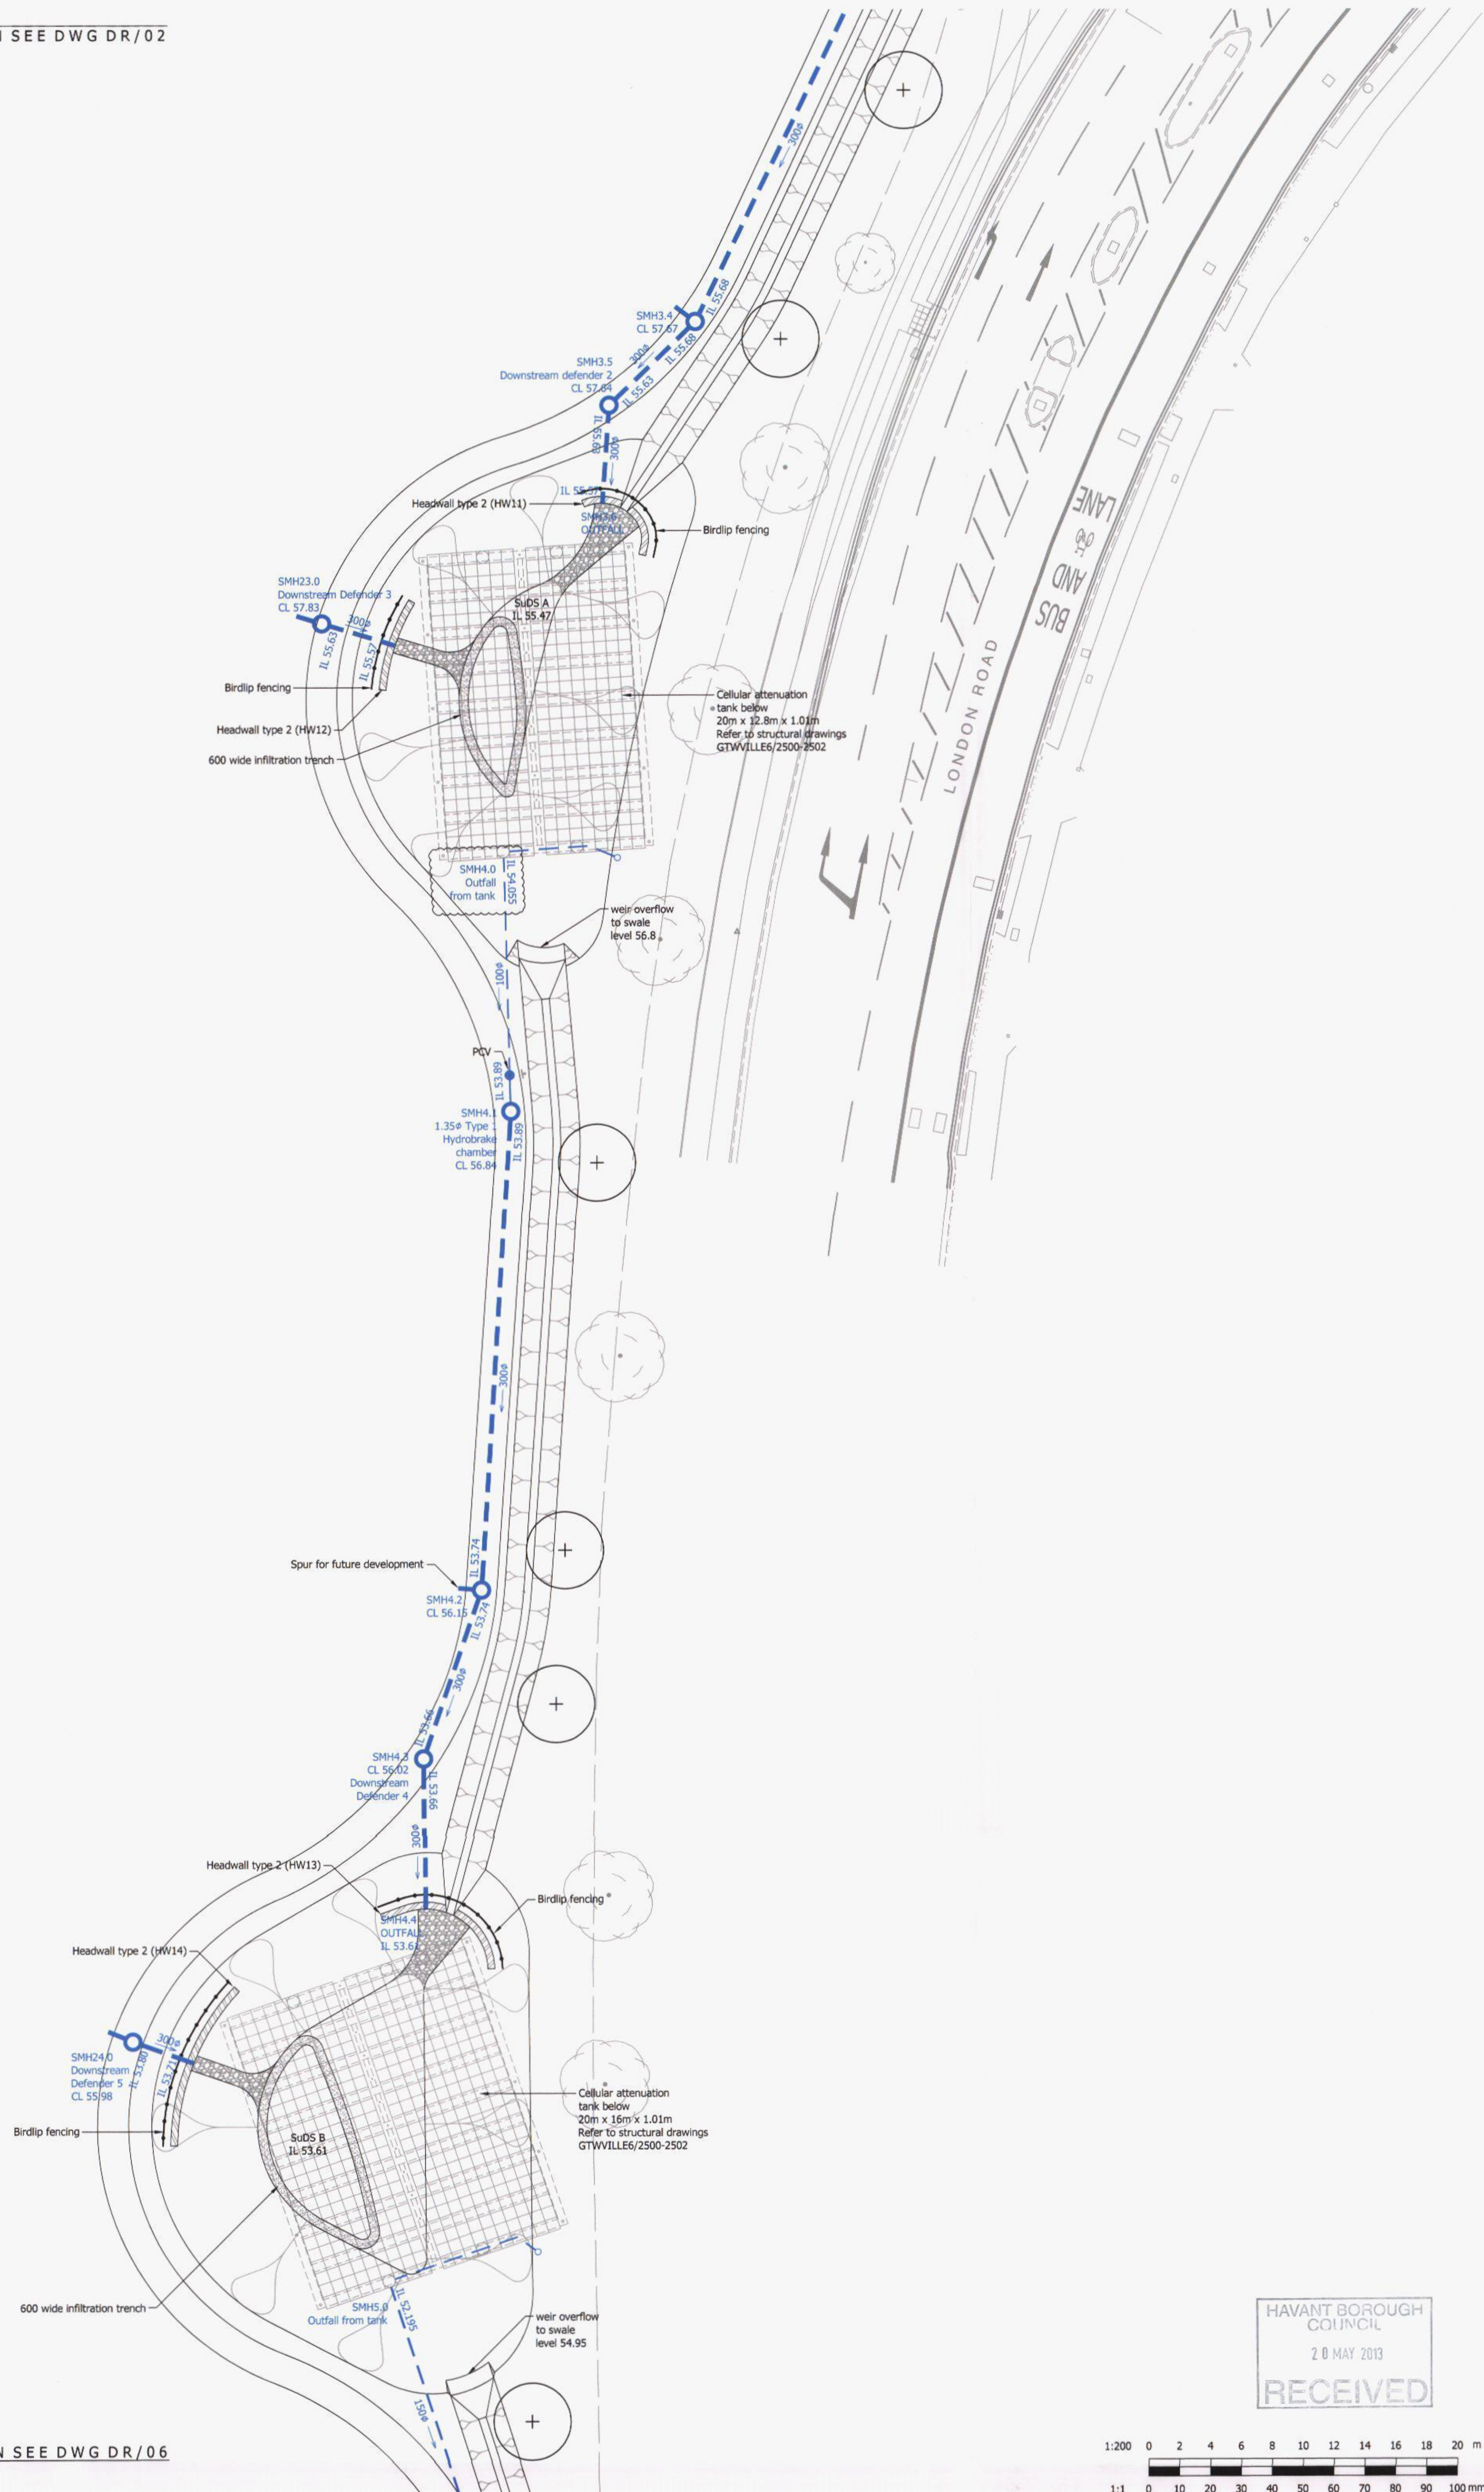

00 ORIGINAL

-  ADAPTABLE SURFACE WATER MANHOLE
-  ADAPTABLE SURFACE WATER SEWER
-  SURFACE WATER GULLY AND GULLY LEAD
-  ADAPTABLE SURFACE WATER CATCHPIT (CP)
-  SURFACE WATER COMBINED CATCHPIT GULLY (CCG)
-  SURFACE WATER FILTER DRAIN (FD)
-  SURFACE WATER FILTER DRAIN CATCHPIT (CPF)
-  SURFACE WATER RODDING EYE (RE)
-  SURFACE WATER CAPPING DRAIN (CD)
-  SURFACE WATER CAPPING DRAIN CATCHPIT (CPF)
-  SURFACE WATER RODDING EYE (RE)
-  ADAPTABLE FOUL WATER MANHOLE
-  ADAPTABLE FOUL WATER SEWER

2. Sewer arrangements subject to SSE approval under S104 of the Water Industry Act.
3. Highway drainage subject to Hampshire County Council approval under S38 of the Highways Act.
4. Filter drain catchpits and capping drain catchpits within block paving are to be recessed.

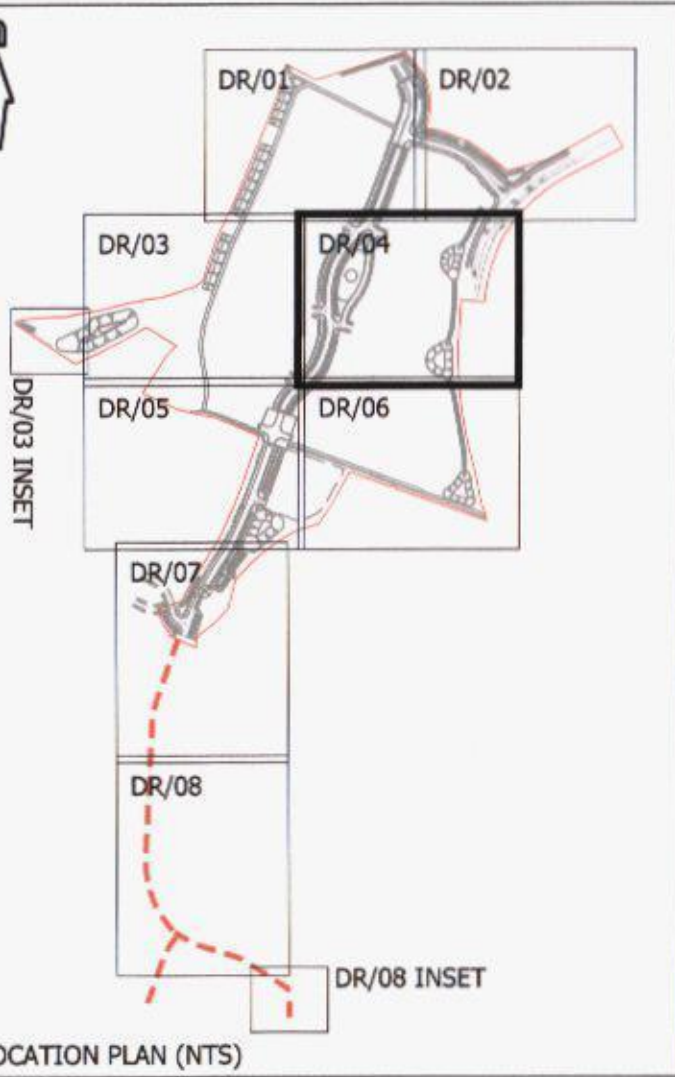

FOR APPROVAL
NOT FOR CONSTRUCTION

D	Filter drains and associated rodding eyes and access removed from highway areas and gullies moved according to layout amendments following HCC comments (7/5/13). Tank details updated. DD10 & DD11 added, Run 13 moved. (H3)	PAS	16/05/14
C	Additional drainage labeling added. (H7)	PAS	25/04/2014
B	Capping drains and catchpit connections added. Tree drains shown. Some previous pavement drainage removed. (H1)	PAS	15/04/2014
A	Drawing amended to 1:200. (H1)	PAS	25/02/2014

rev.	amendment	checked	date
------	-----------	---------	------



Investing in homes since 1912

BEREWOOD, WATERLOOVILLE
PHASE 2 INFRASTRUCTURE

1:200	drawn by	HJ	checked by	PAS
-------	----------	----	------------	-----

JANUARY 2013	cad file	DR_04_D.dwg
--------------	----------	-------------

PROPOSED DRAINAGE LAYOUT
SHEET 4 OF 8

wing number	rev.
GTWVILLE6/DR/04	D

HAVANT BOROUGH
COUNCIL
20 MAY 2013

RECEIVED

