


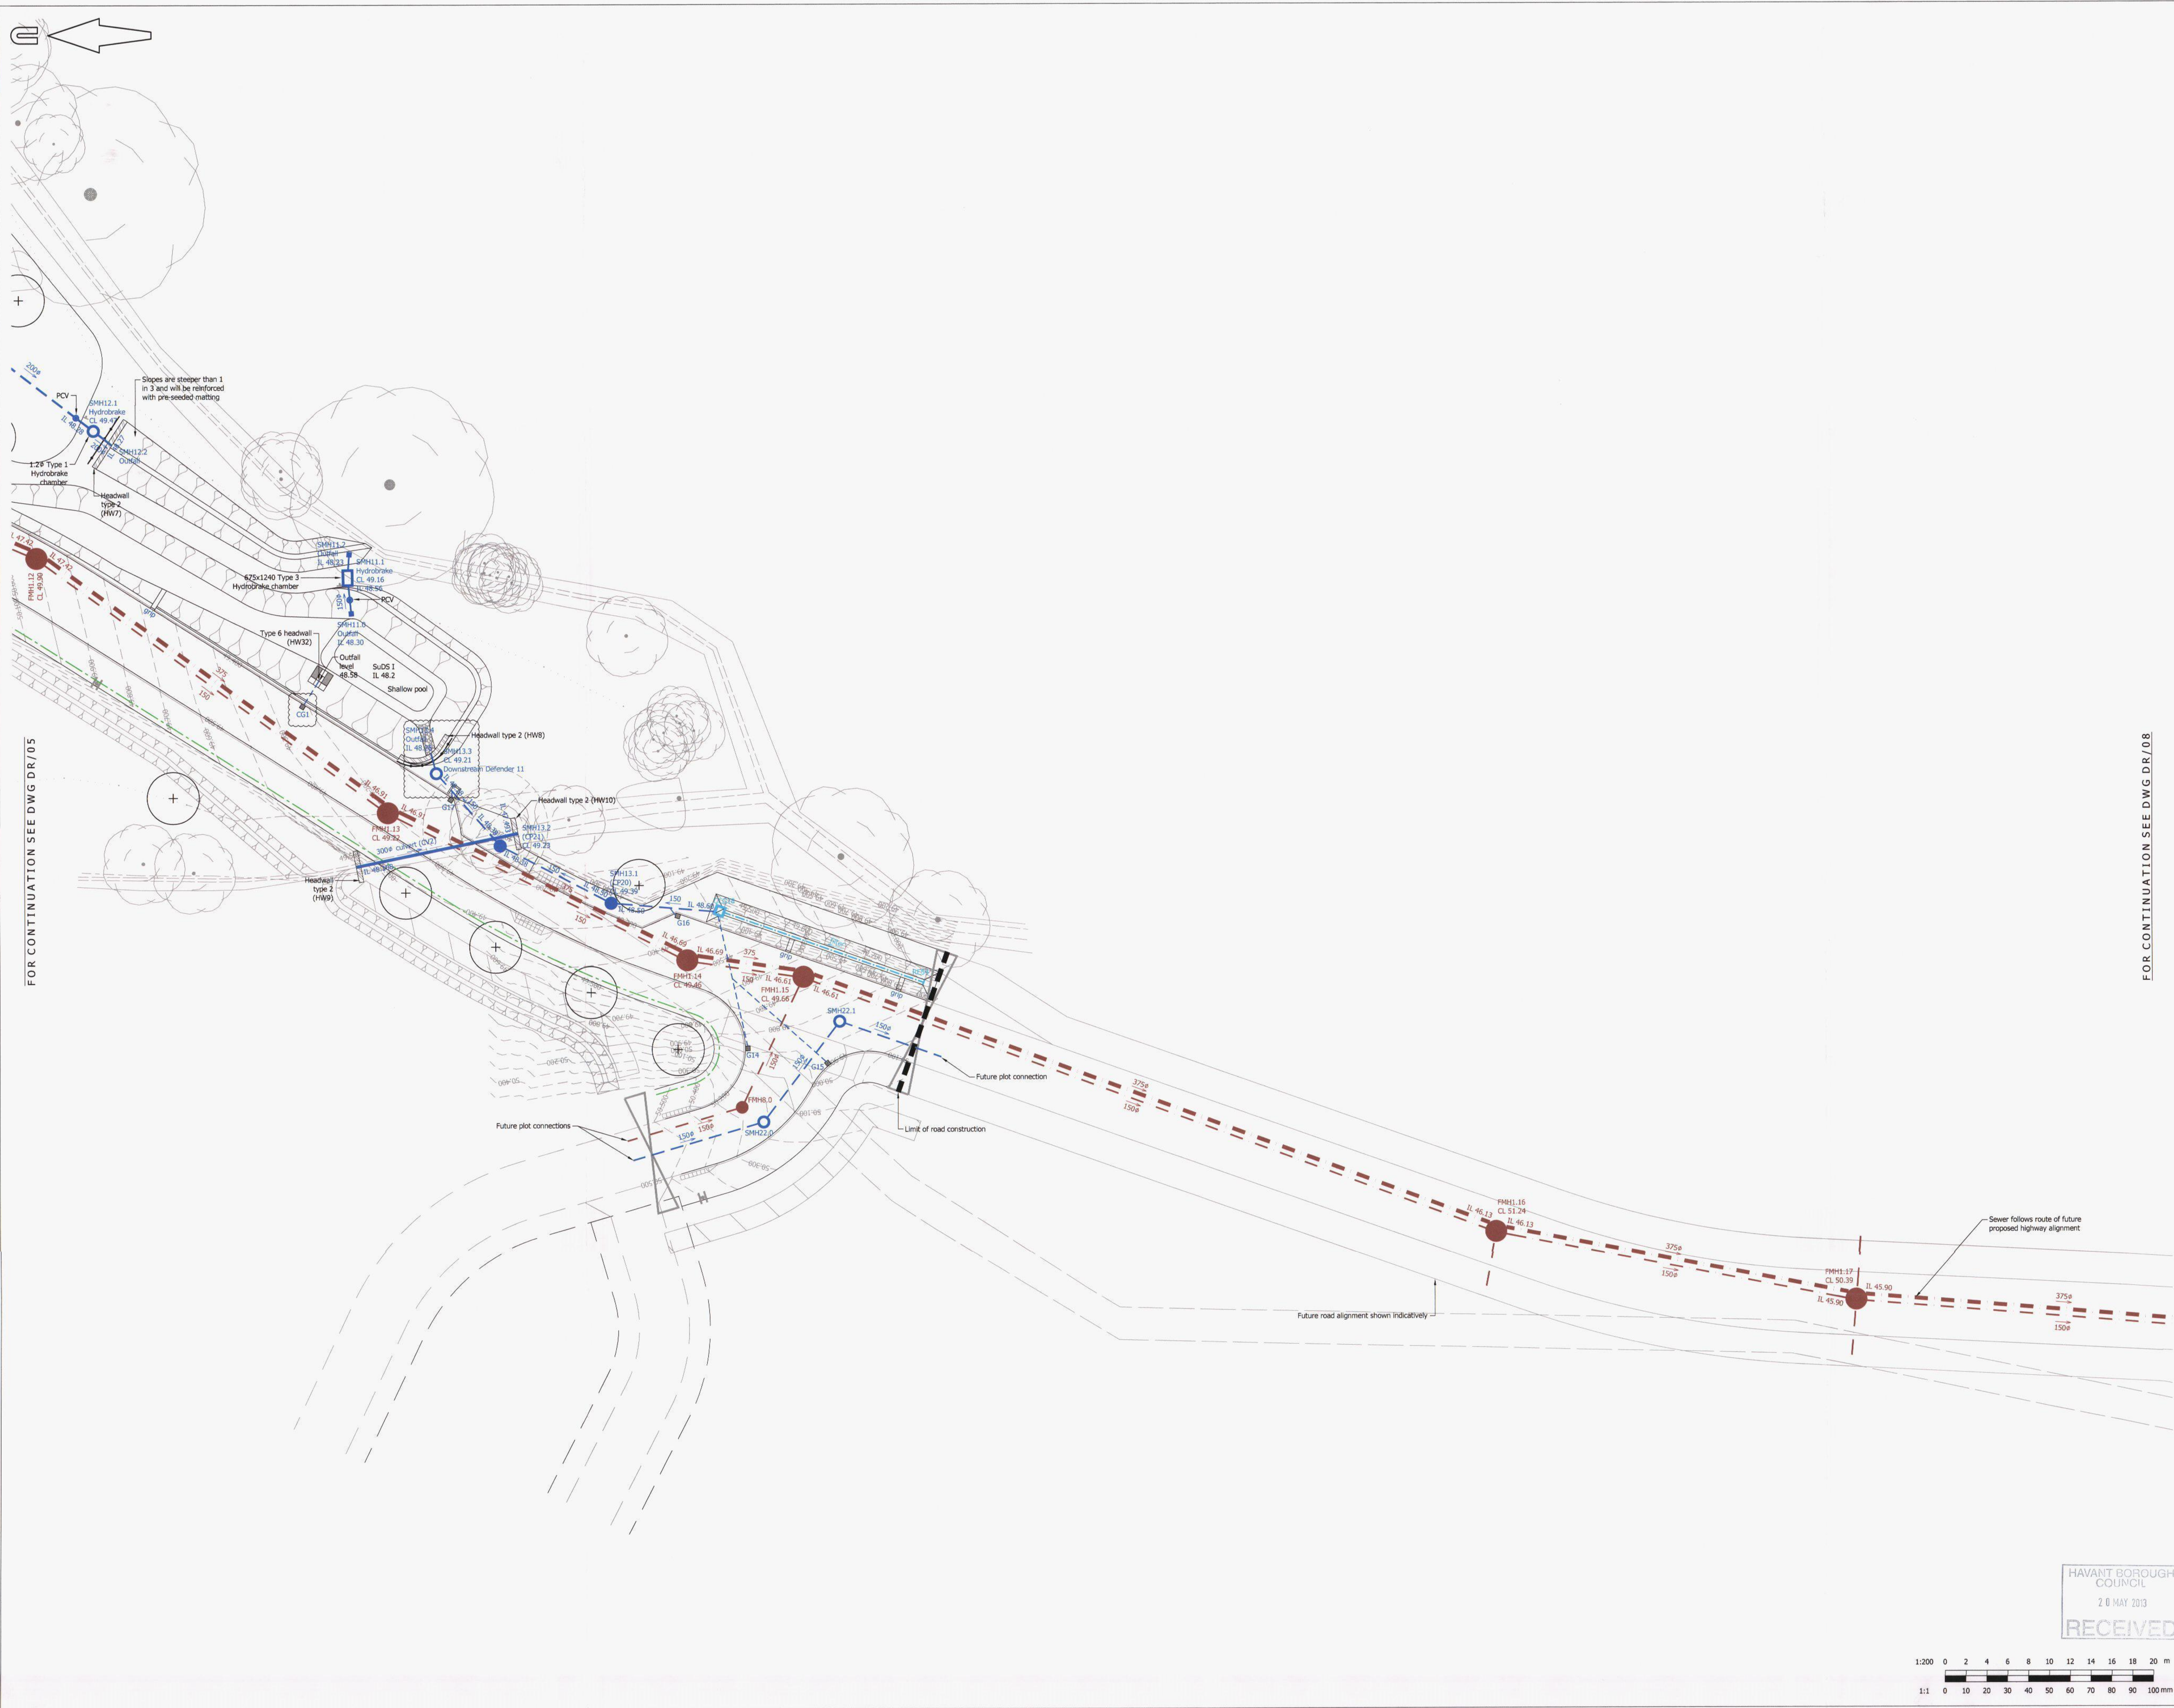

FOR CONTINUATION SEE DWG DR/05

FOR CONTINUATION SEE DWG DR/08

© Mayer Brown Limited Copyright. The drawings, information and data recorded in this document ("the information") is the property of Mayer Brown. This document and the information are solely for the use of the authorized recipient and this document may not be used, copied or reproduced in whole or part for any purpose other than which it was supplied by Mayer Brown. Mayer Brown makes no representation, undertakes no duty and accepts no responsibilities to any third party who may use or rely upon this document or the information.


A0 ORIGINAL

KEY:

- ADOPTABLE SURFACE WATER MANHOLE
- ADOPTABLE SURFACE WATER SEWER
- SURFACE WATER GULLY AND GULLY LEAD
- ADOPTABLE SURFACE WATER CATCHPIT (CP)
- SURFACE WATER COMBINED CATCHPIT GULLY (CCG)
- SURFACE WATER FILTER DRAIN (FD)
- SURFACE WATER FILTER DRAIN CATCHPIT (CPF)
- SURFACE WATER RODDING EYE (RE)
- SURFACE WATER CAPPING DRAIN (CD)
- SURFACE WATER CAPPING DRAIN CATCHPIT (CPF)
- SURFACE WATER RODDING EYE (RE)
- ADOPTABLE FOUL WATER MANHOLE
- ADOPTABLE FOUL WATER SEWER

Notes:

- Sewer arrangements subject to SSE approval under S104 of the Water Industry Act.
- Highway drainage subject to Hampshire County Council approval under S38 of the Highways Act.
- Filter drain catchpits and capping drain catchpits within block paving are to be recessed.

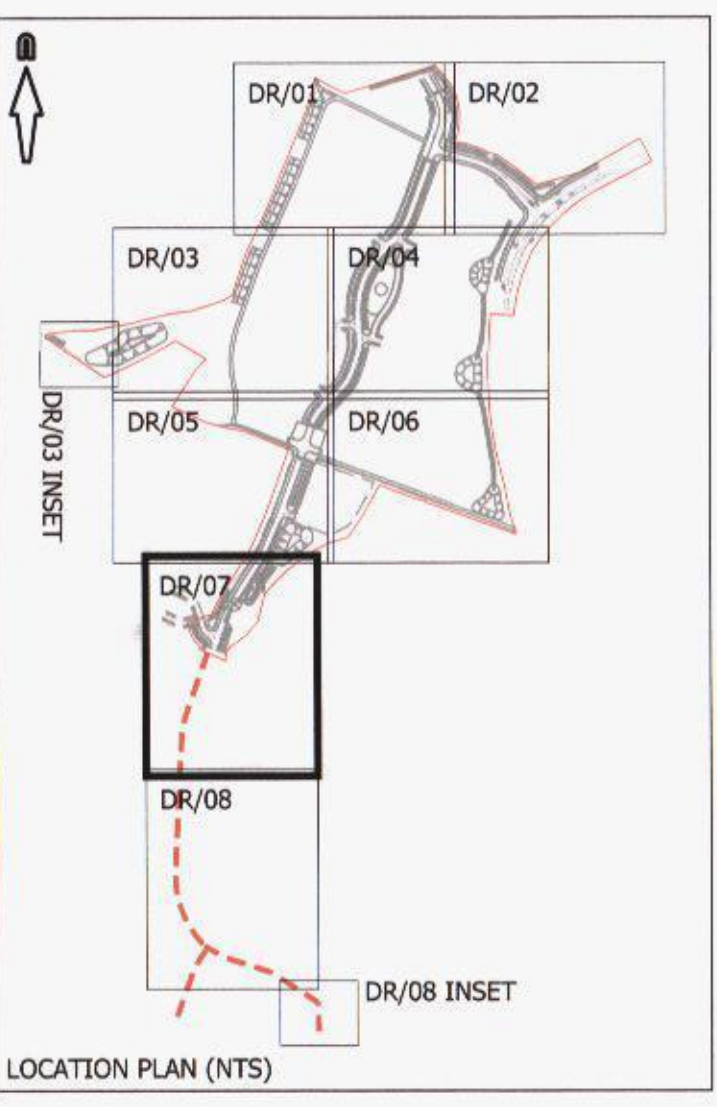

Berewood
HAMPSHIRE
FOR APPROVAL
NOT FOR CONSTRUCTION

C	Filter drains and associated rodding eyes and catchpits removed from highway areas and gullies moved according to layout amendments following HCC comments (7/5/13). Tank details updated. CD10 & CD11 added. Run 13 moved. (10)	PAS	16/05/13
B	Additional drainage labeling added. (14)	PAS	25/04/2013
A	Capping drains and catchpit connections added. Tree drains shown. Some previous pavement drainage removed. (15)	PAS	15/04/2013

rev.	amendment	checked	date
------	-----------	---------	------

m3
mayer brown
Mayer Brown Limited Lion House
Oriente Road Woking Surrey GU24 8AB
Telephone 01483 750 588 Fax 01483 750 437
wokingoffice@mayerbrown.co.uk www.mayerbrown.co.uk

client **grainger plc**
project **BEREWOOD, WATERLOOVILLE
PHASE 2 INFRASTRUCTURE**
scale 1:200 drawn by HJ checked by PAS
date JANUARY 2013 cad file DR_07_C.dwg
title **PROPOSED DRAINAGE LAYOUT
SHEET 7 OF 8**
drawing number **GTWILLE6/DR/07** rev. **C**

HAVANT BOROUGH COUNCIL
20 MAY 2013
RECEIVED

