


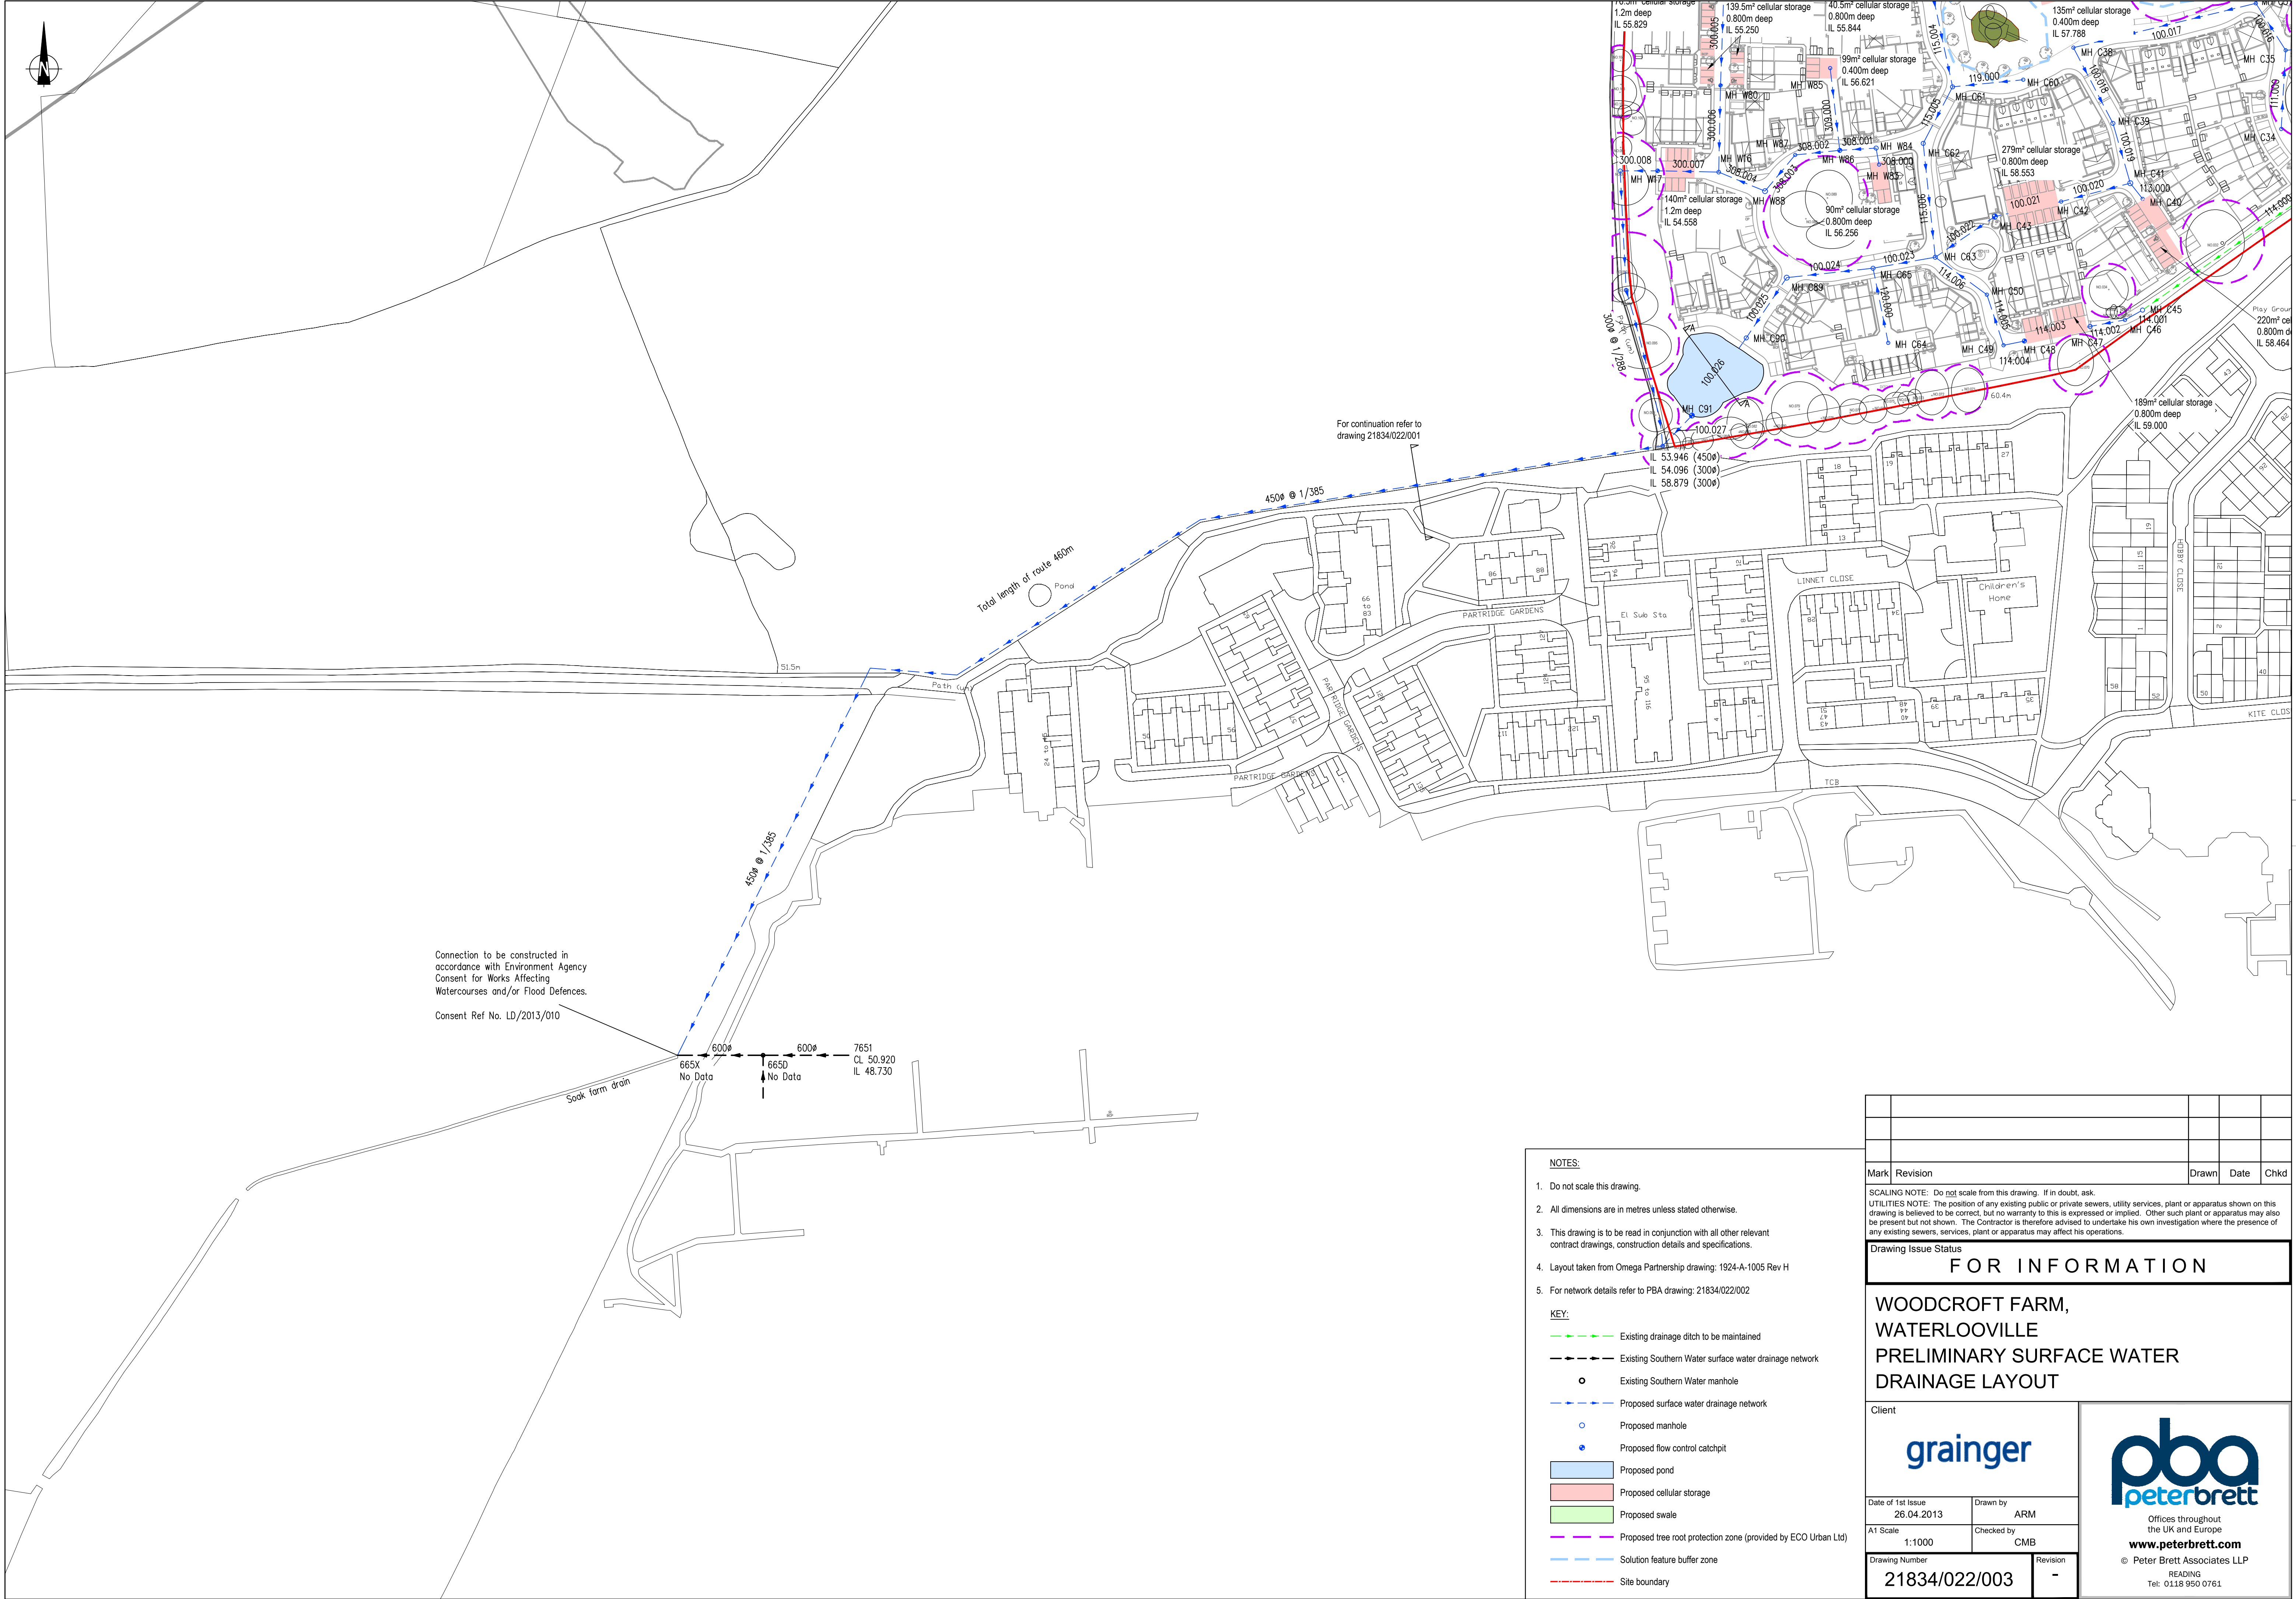

NOTES:

- Do not scale this drawing.
- All dimensions are in metres unless stated otherwise.
- This drawing is to be read in conjunction with all other relevant contract drawings, construction details and specifications.
- Layout taken from Omega Partnership drawing: 1924-A-1005 Rev H
- For network details refer to PBA drawing: 21834/022/002

KEY:

- Existing drainage ditch to be maintained
- Existing Southern Water surface water drainage network
- Existing Southern Water manhole
- Proposed surface water drainage network
- Proposed manhole
- Proposed flow control catchpit
- Proposed pond
- Proposed cellular storage
- Proposed swale
- Proposed tree root protection zone (provided by ECO Urban Ltd)
- Solution feature buffer zone
- Site boundary

Mark	Revision	Drawn	Date	Chkd

SCALING NOTE: Do not scale from this drawing. If in doubt, ask.
UTILITIES NOTE: The position of any existing public or private sewers, utility services, plant or apparatus shown on this drawing is believed to be correct, but no warranty to this is expressed or implied. Other such plant or apparatus may also be present but not shown. The Contractor is therefore advised to undertake his own investigation where the presence of any existing sewers, services, plant or apparatus may affect his operations.

Drawing Issue Status

FOR INFORMATION

**WOODCROFT FARM,
WATERLOOVILLE
PRELIMINARY SURFACE WATER
DRAINAGE LAYOUT**

Client	
grainger	
Date of 1st Issue 26.04.2013	Drawn by ARM
A1 Scale 1:1000	Checked by CMB
Drawing Number 21834/022/003	Revision -

Offices throughout the UK and Europe
www.peterbrett.com
© Peter Brett Associates LLP
READING
Tel: 0118 950 0761