



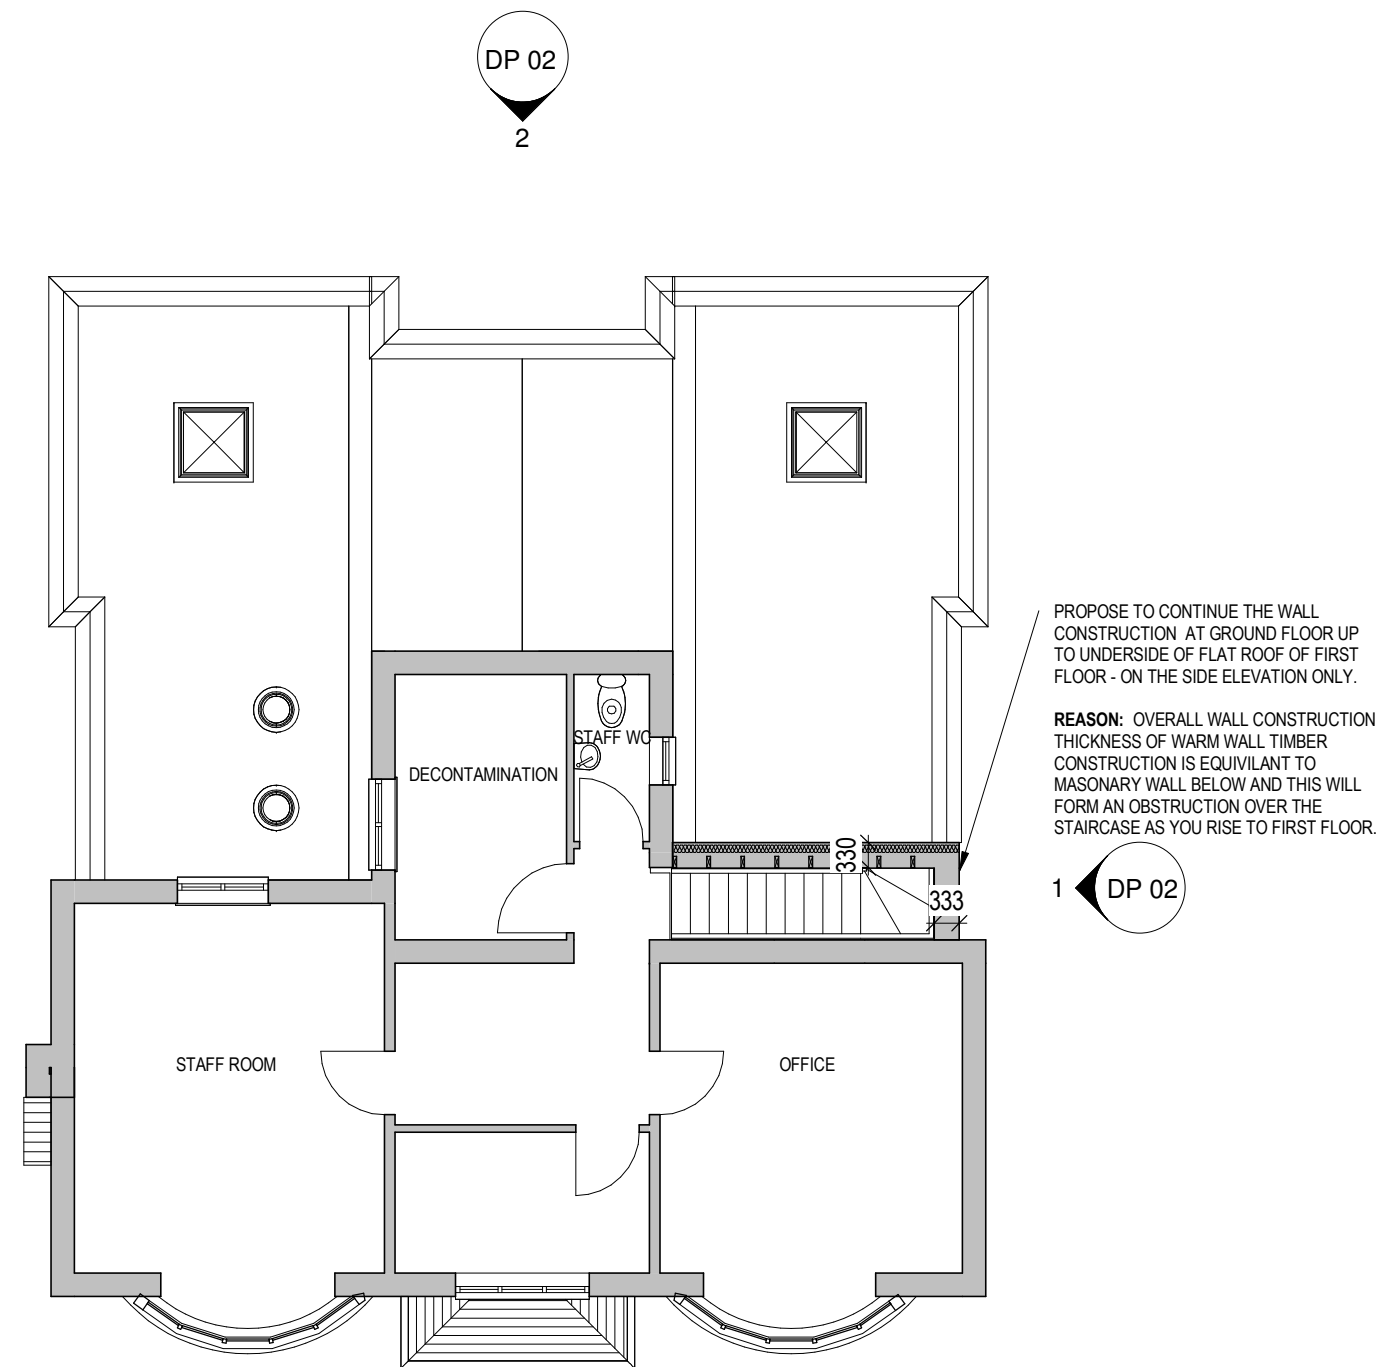

1 Proposed Ground Floor
1 : 100

2 proposed First Floor
1 : 100

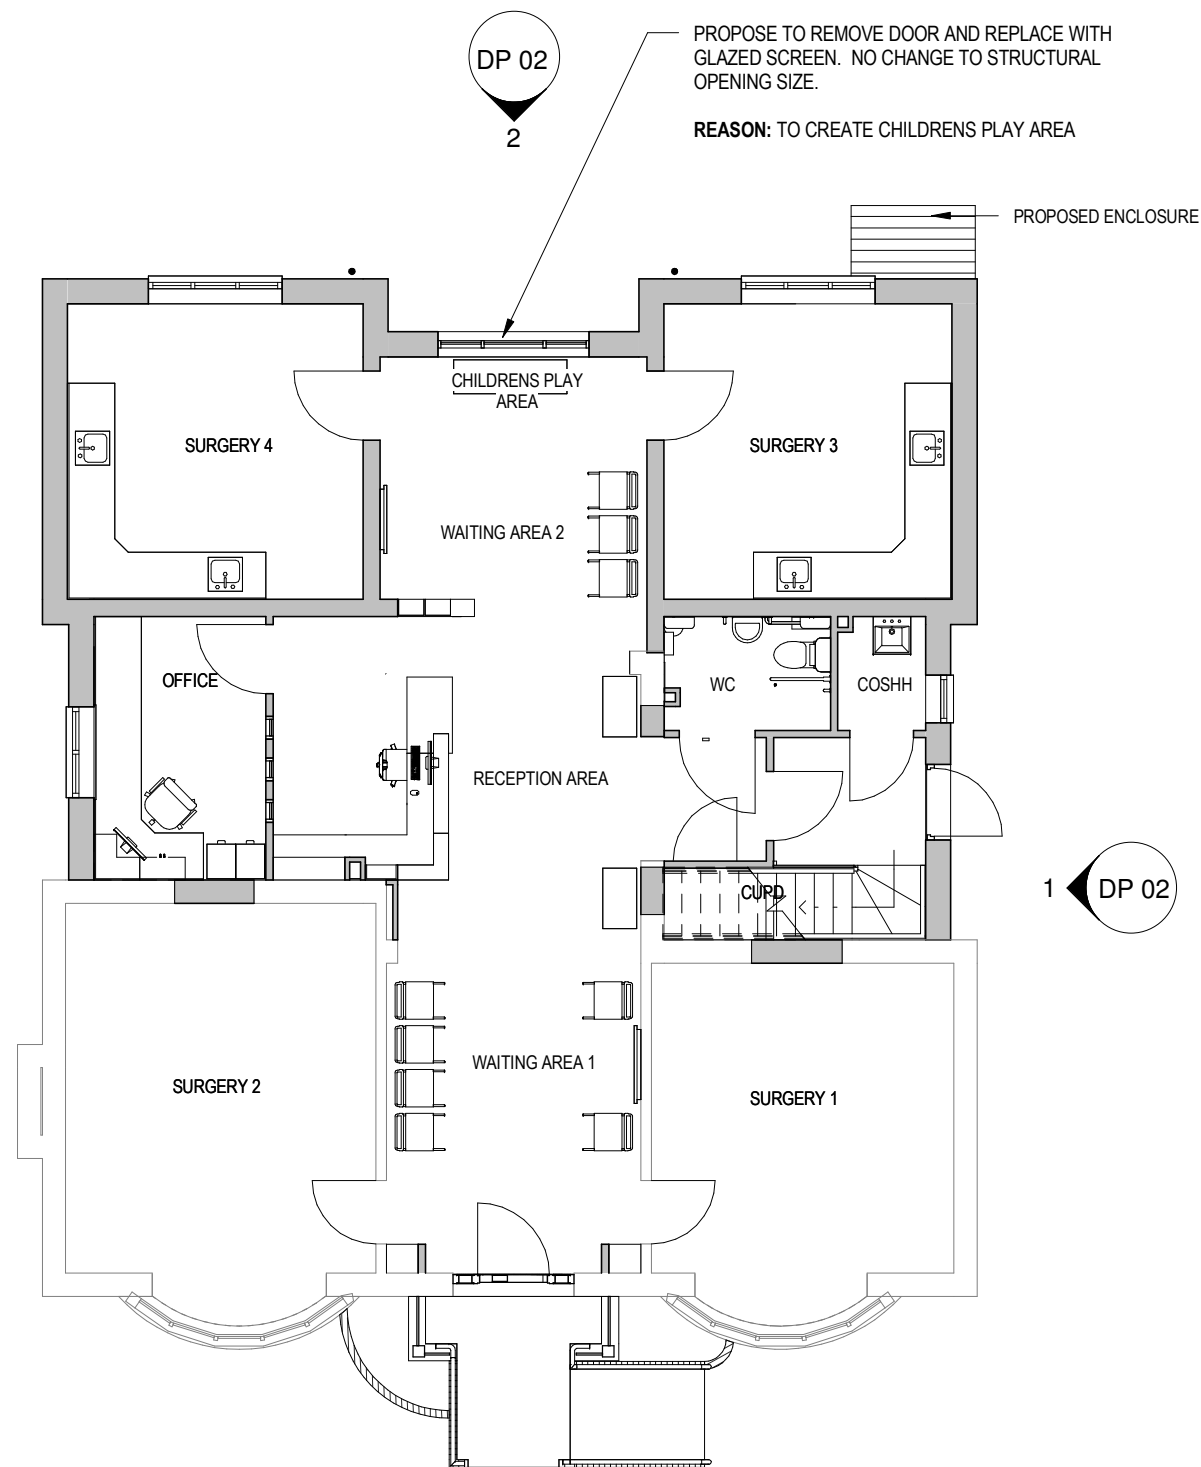

VISUAL SCALE 1:100 @ A3

PETER MINETT & PARTNERS LTD

Building Design and Project Management Consultants

Bridge House 3 Fleet Road Farnborough Hampshire GU14 9RU

Tel: 01252 543342

Fax: 01252 370482

email: farnborough@peterminett.co.uk

Client:

Mr & Mrs Cottrell

Project name:

Parkway Dentalcare

100 Bedhampton Road

Havant, Hampshire

PO9 3EZ

Drawing:

Proposal for 'Non-material Amendments' - Floor Plans

Project number 6132

Date 21.06.13

Drawn by wm

Checked by gp Scale

DP 01

1 : 100 @ A3

