


CROOKHORN COLLEGE OF TECHNOLOGY.
Proposed Dance Studio, Part Roof Plan.
Scale 1:200.

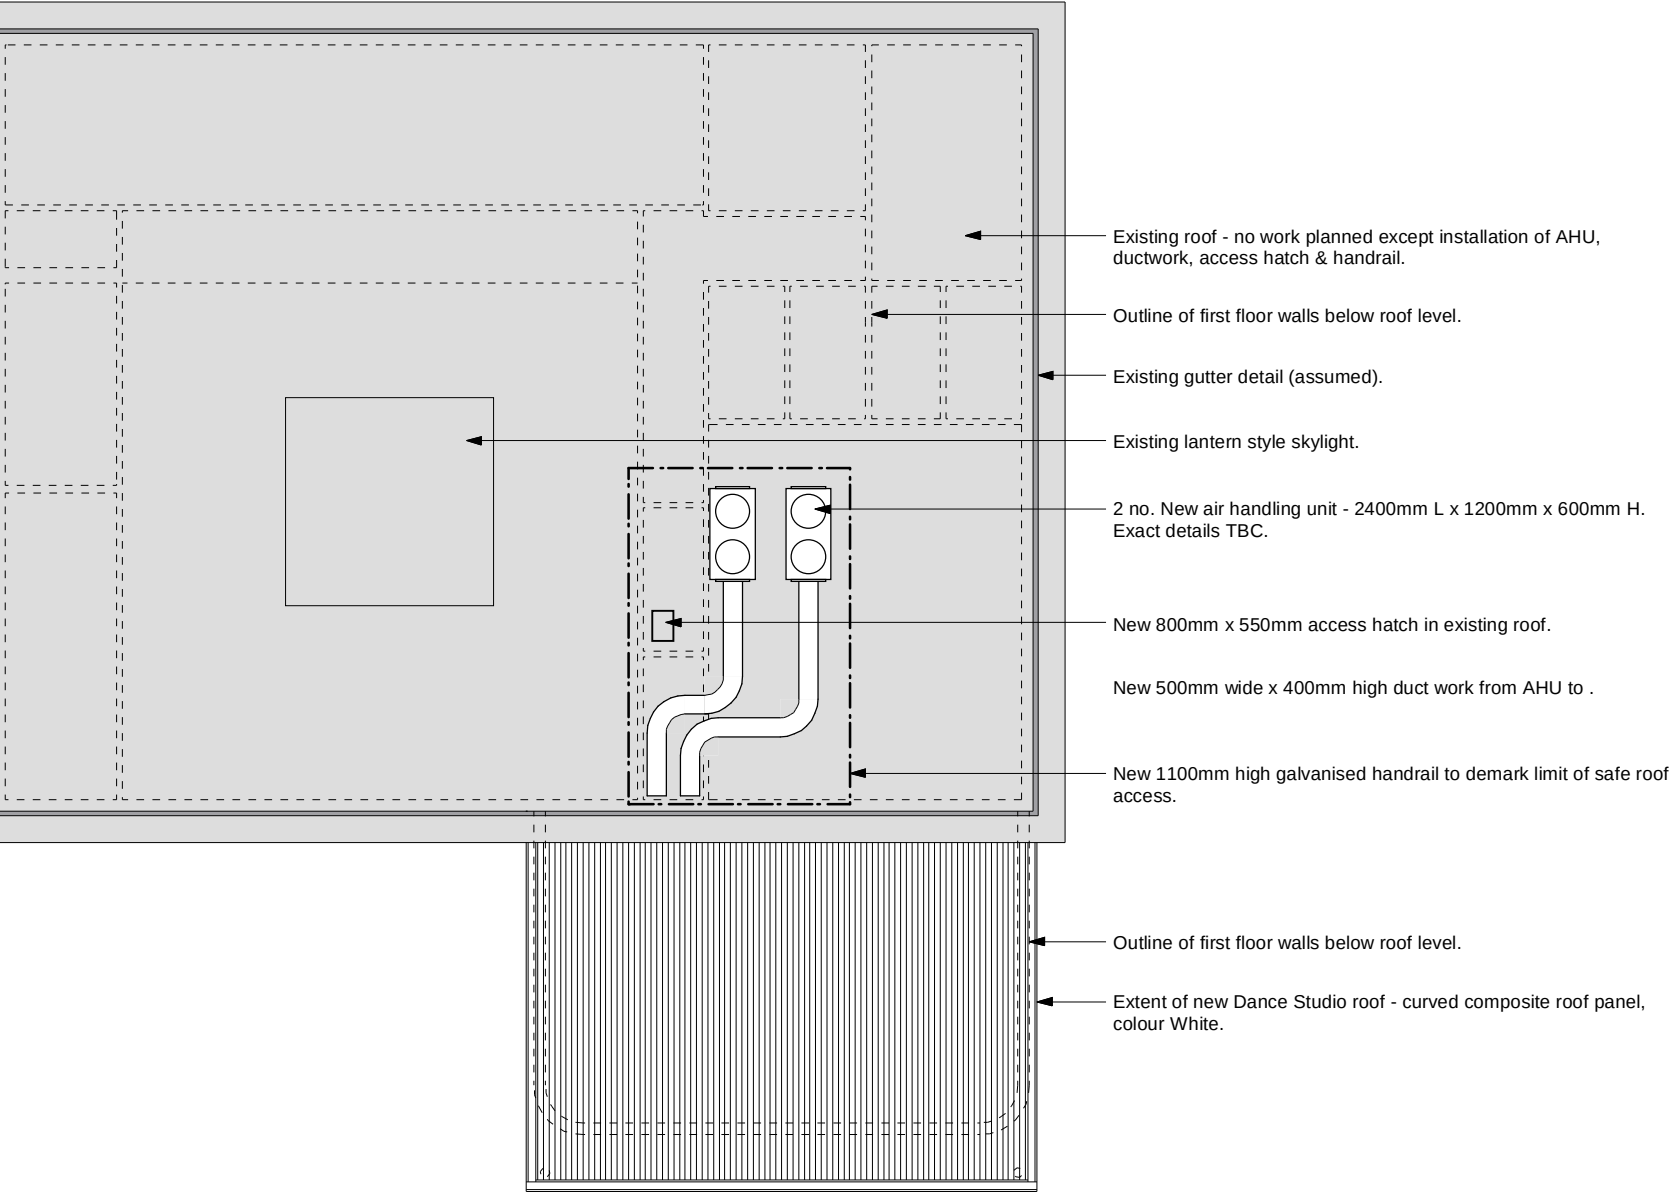

PLANNING



HCC Property Services,
Three Minsters House,
76 High Street, Winchester SO23 8UL.
tel: (01962) 847801

Notes	
1 This drawing is © copyright Hampshire County Council 2012. No unauthorised reproduction permitted. All rights reserved.	3 This map is reproduced from Ordnance Survey material with the permission of Ordnance Survey on behalf of the controller of Her Majesty's Stationery Office © Crown Copyright. Unauthorised reproduction infringes Crown Copyright and may lead to prosecution or civil proceedings. (100019180), (2012)
2 No dimensions are to be scaled from this drawing	

rev	description	date	by
A	Planning	02.01.13	LGN

PROJECT				SHEET CONTENTS	
CROOKHORN COLLEGE OF TECHNOLOGY				PROPOSED PART ROOF PLAN	
Provision of Dance Studio				Property Services	
SCALE	DATE	DRAWN.	CHKD.	DRAWING No.	REVISION
1:200 @ A3	02 Jan 13	LGN	---	P09958-4159-16	A
				FILE REF.	P09958 - Planning Roof Plan