


LIGHTING KEY:

- Location of proposed street lighting columns
- Column: 6m straight shaft post top mounted polymer coated (12B21)
- Lanterns: WRTL Libra Performer 2565/2566/SNN with 36W PLL Lamp and dimming ballast HF-R DALI, fitted with Mayflower six pin NEMA socket, post top mounted max 5 degree tilt.
- Switch Controls: Mayflower Intelligent Management System (NIMS) remote monitoring NODE to plug into six pin NEMA socket in each lantern.
- Scheme to include one Mayflower Mobitex GPRS Sub-master unit to control Nodes and link to central control system.
- All columns to be sited at back of footway or verge, minimum clear distance to kerb of 800mm
- All to Hampshire Council specification

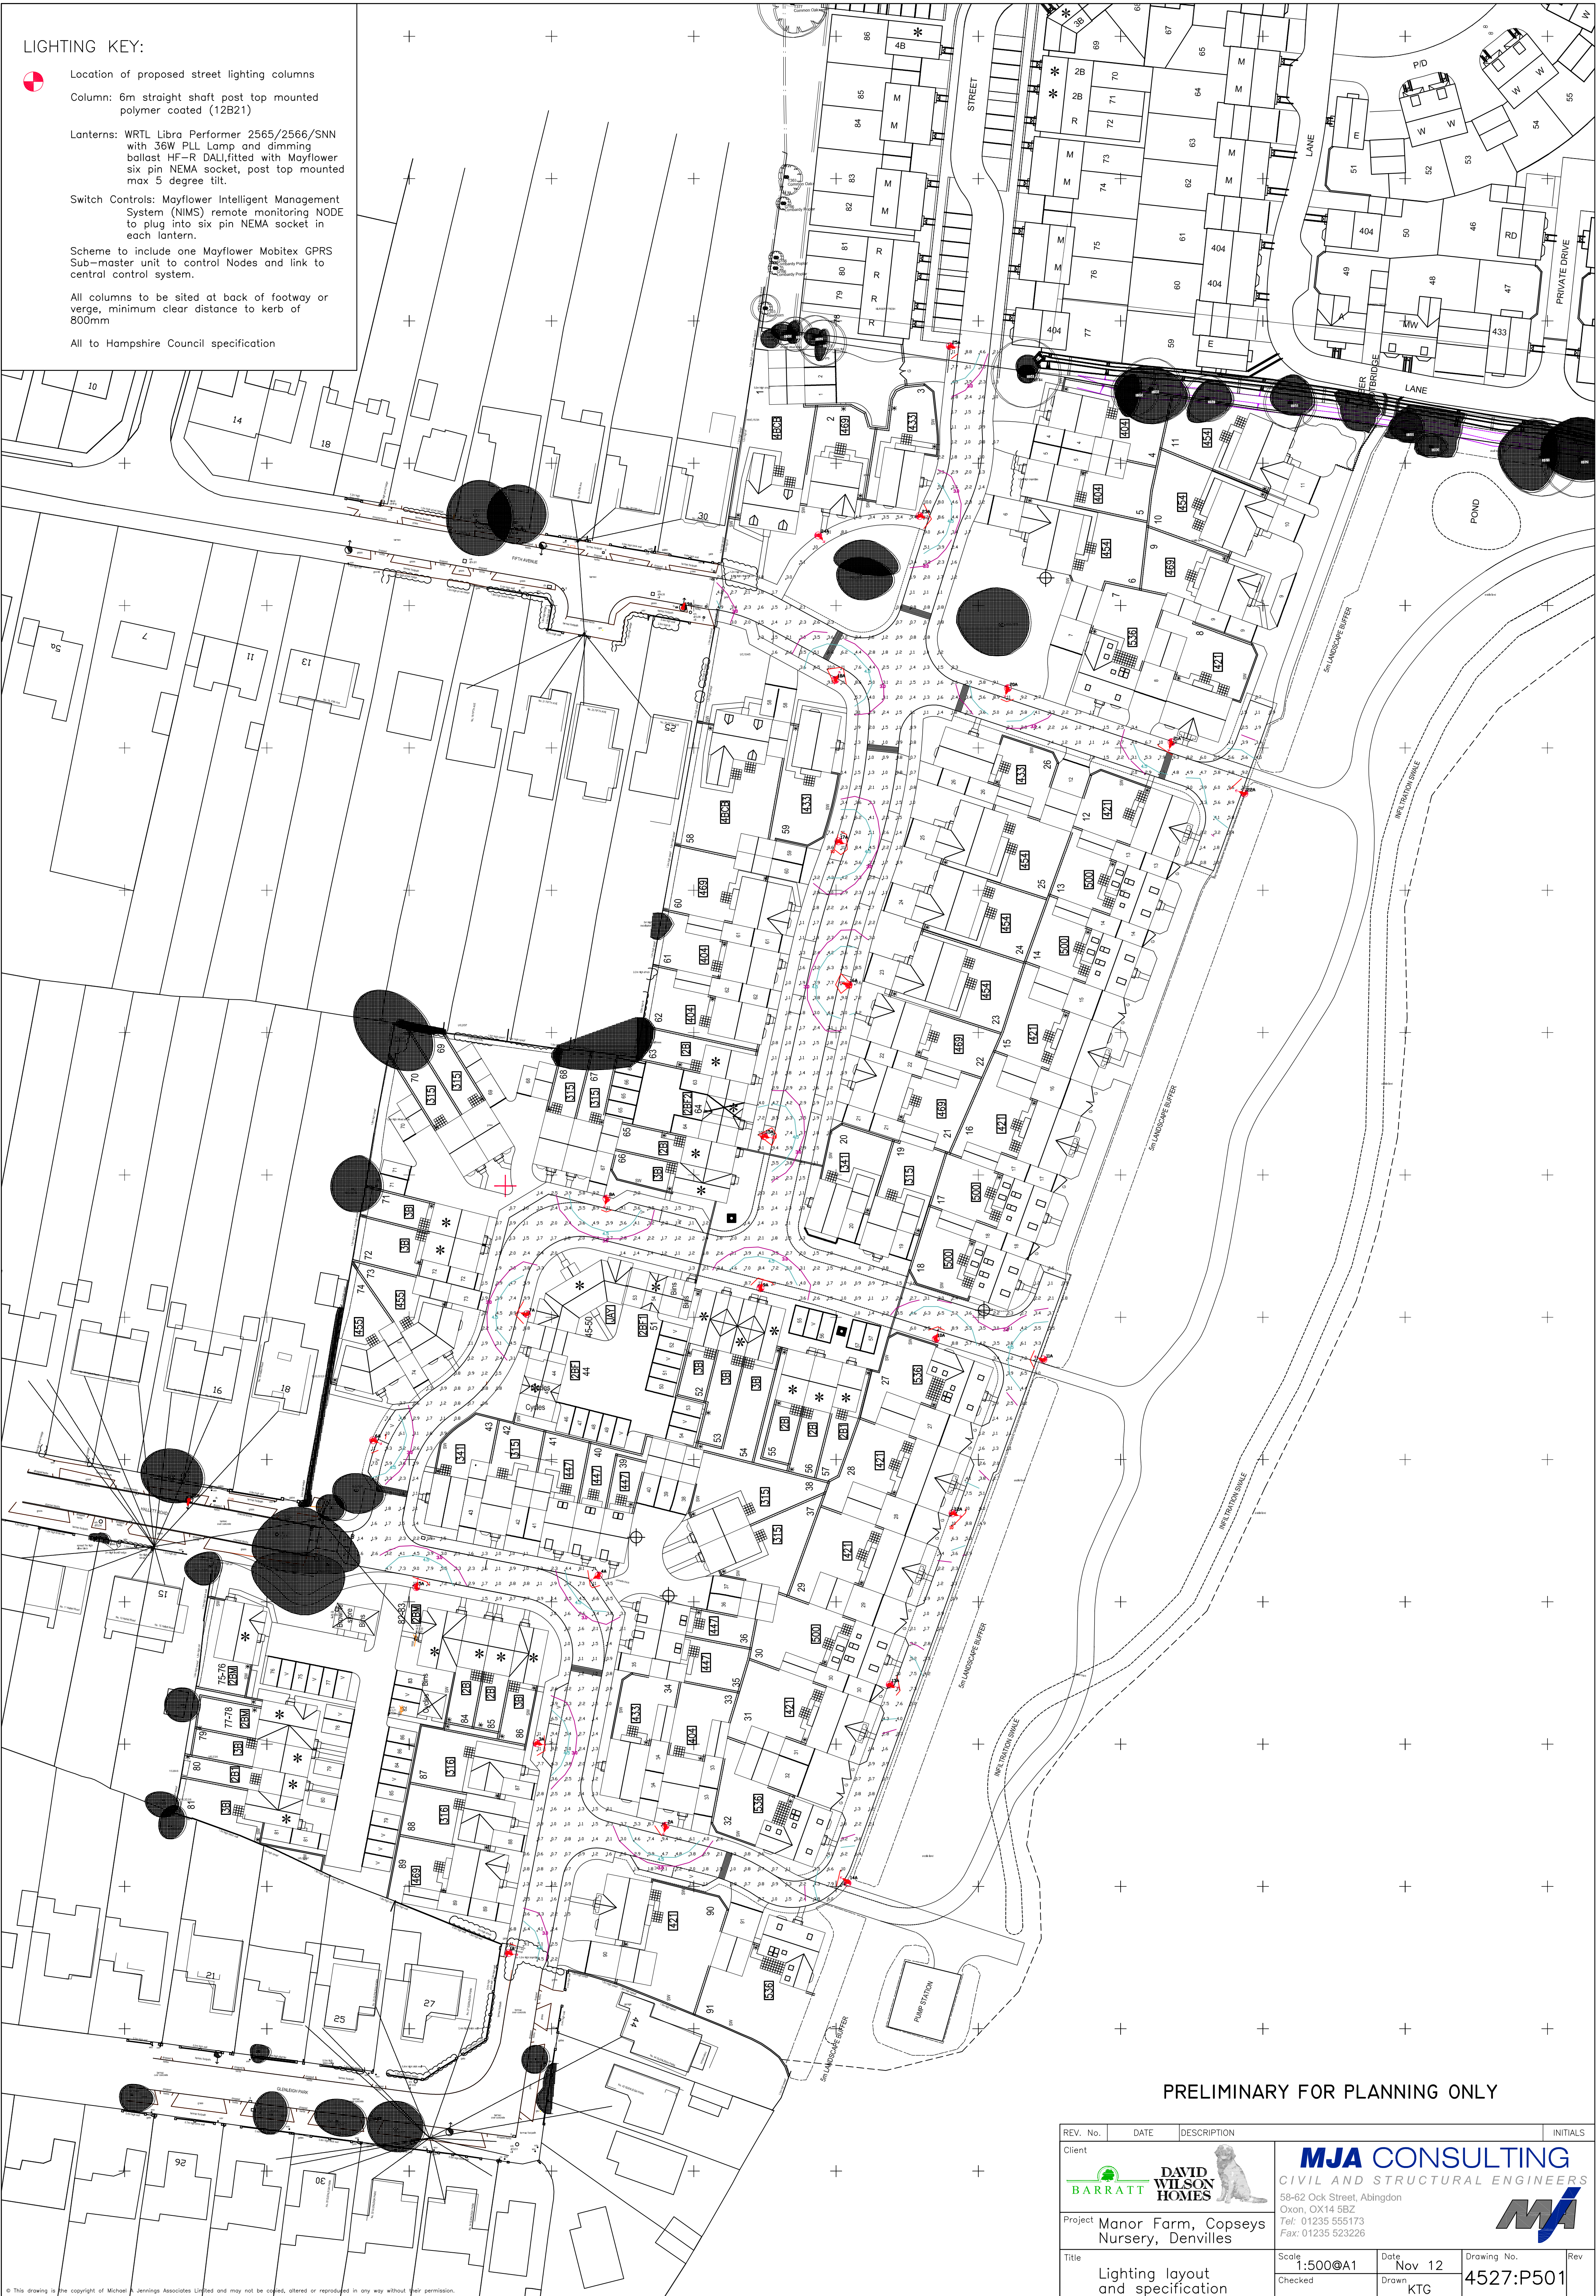

PRELIMINARY FOR PLANNING ONLY

REV. No.	DATE	DESCRIPTION	INITIALS
Client			
Project		Manor Farm, Copseys Nursery, Denvilles	
Title		Lighting layout and specification	
Scale		1:500@A1	
Checked			
Date		Nov 12	
Drawn		KTG	
Drawing No.		4527:P501	
Rev			

**BARRATT**

**DAVID WILSON HOMES**

MJA CONSULTING
CIVIL AND STRUCTURAL ENGINEERS
58-62 Oak Street, Abingdon
Oxon, OX14 5BZ
Tel: 01235 555173
Fax: 01235 523226

