


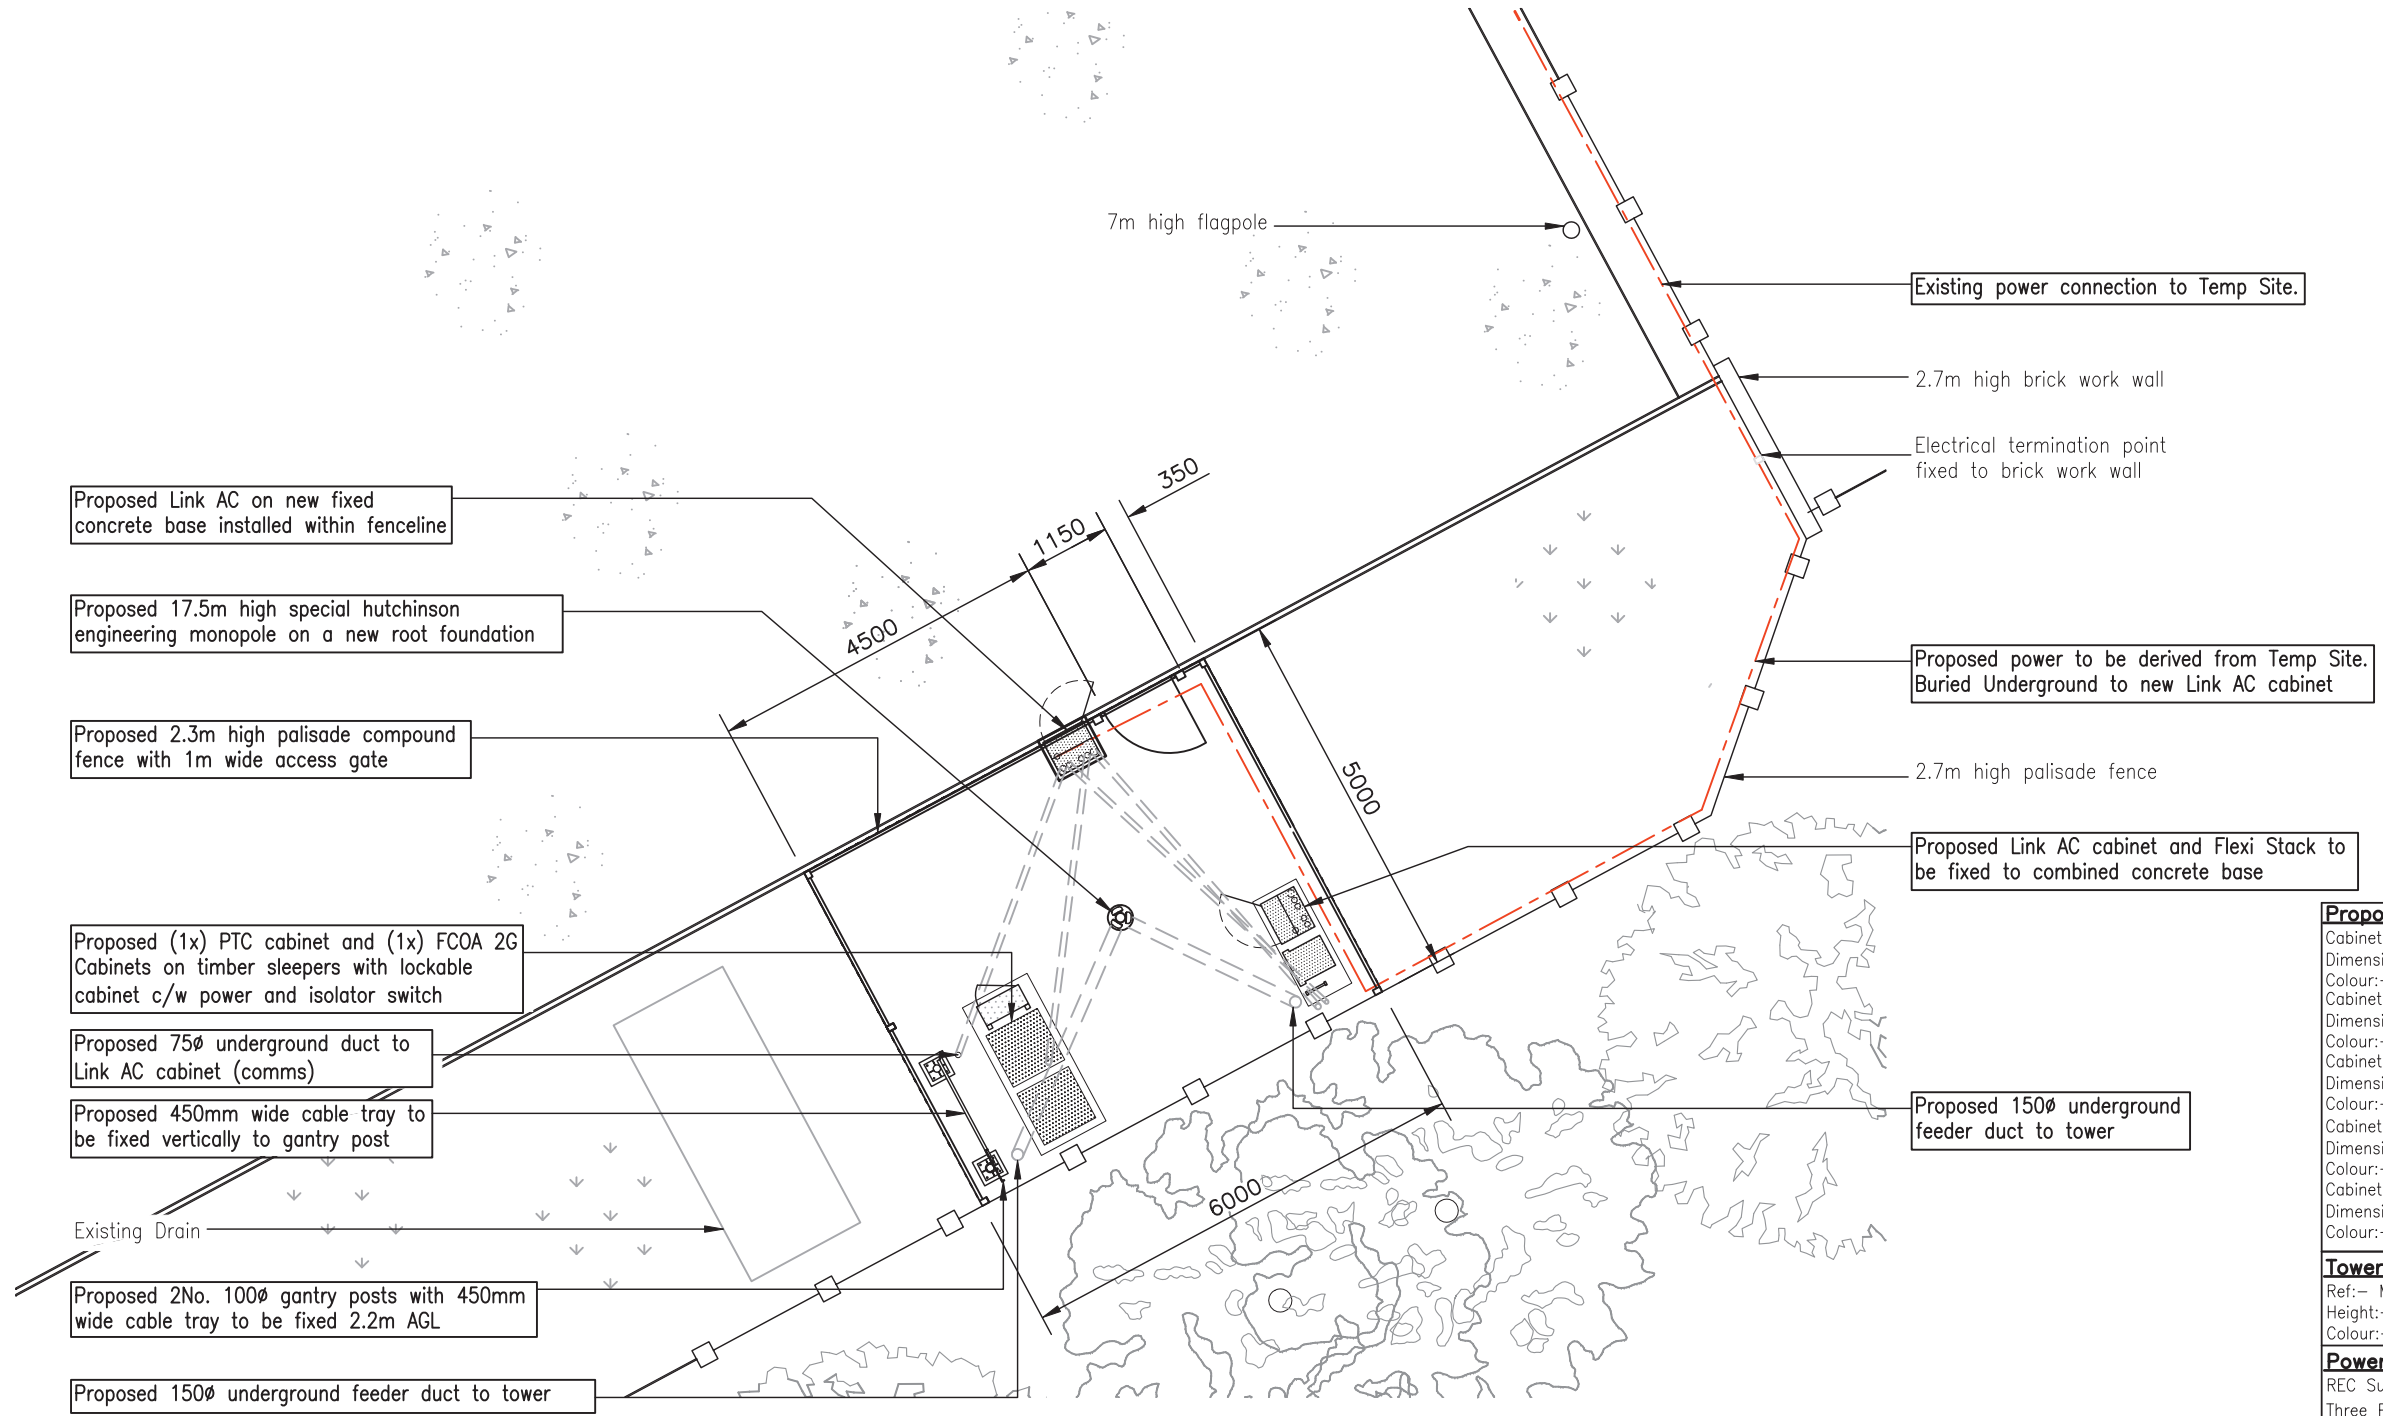

SITE PLAN
SCALE 1:100

- Proposed Equipment Details**
Cabinet:- 1x PTC cabinet
Dimensions:- 750x750x2050 high
Colour:- Grey
Cabinet:- 1x FCOA cabinets
Dimensions:- 770x770x1940 high
Colour:- Grey
Cabinet:- Lockable Electrical cabinet
Dimensions:- TBC
Colour:- Grey
Cabinet:- Flexi stack
Dimensions:- 600x540x1000 High
Colour:- Grey
Cabinet:- 2 x Link AC
Dimensions:- 600x500x1100 High
Colour:- Grey
- Tower Details**
Ref:- Monopole Hutchinson Engineering
Height:- 17.5m Dual user
Colour:- Galvanised
- Power Details**
REC Supply - Landlord Supply
Three Phase - 100Amp
- Exclusion zone**
Exclusion zone is based upon ICNIRP public exposure limits.

COMMERCIAL IN CONFIDENCE									TITLE CONSTRUCTED SITE PLAN WESSEX SELF DRIVE WESSEX SELF DRIVE FULFLOOD ROAD, HAVANT, HAMPSHIRE PO9 5AX				everything everywhere™ Hatfield Business Park Hatfield Hertfordshire AL10 9BW Tel 01707 315000 Fax 01707 319001					
DO NOT SCALE																		
RELEVANT BS STANDARDS		BS 308	BS 3429															
LCC the knowledge that powers the network™ DELTA HOUSE, DELTA WAY, EGHAM, SURREY TW20 8RX TEL: 01784 471045 FAX: 01784 435982				D	DIMENSION REVISED	NTA	29/06/12	JR					DRAWING NUMBER 55905/103D		EXTRANET DOC -			
				C	DESIGN REVISED	NTA	01/06/12	JR										
				B	DESIGN REVISED	NTA	27/04/12	MH										
				A	FIRST ISSUE	NTA	23/04/12	MH										
				REV	DESCRIPTION	BY	DATE	CHKD										
				SCALE AS SHOWN		DRAWN NTA DATE 23/04/12		CHECKED MH DATE 23/04/12		APPROVED JR DATE 23/04/12								