


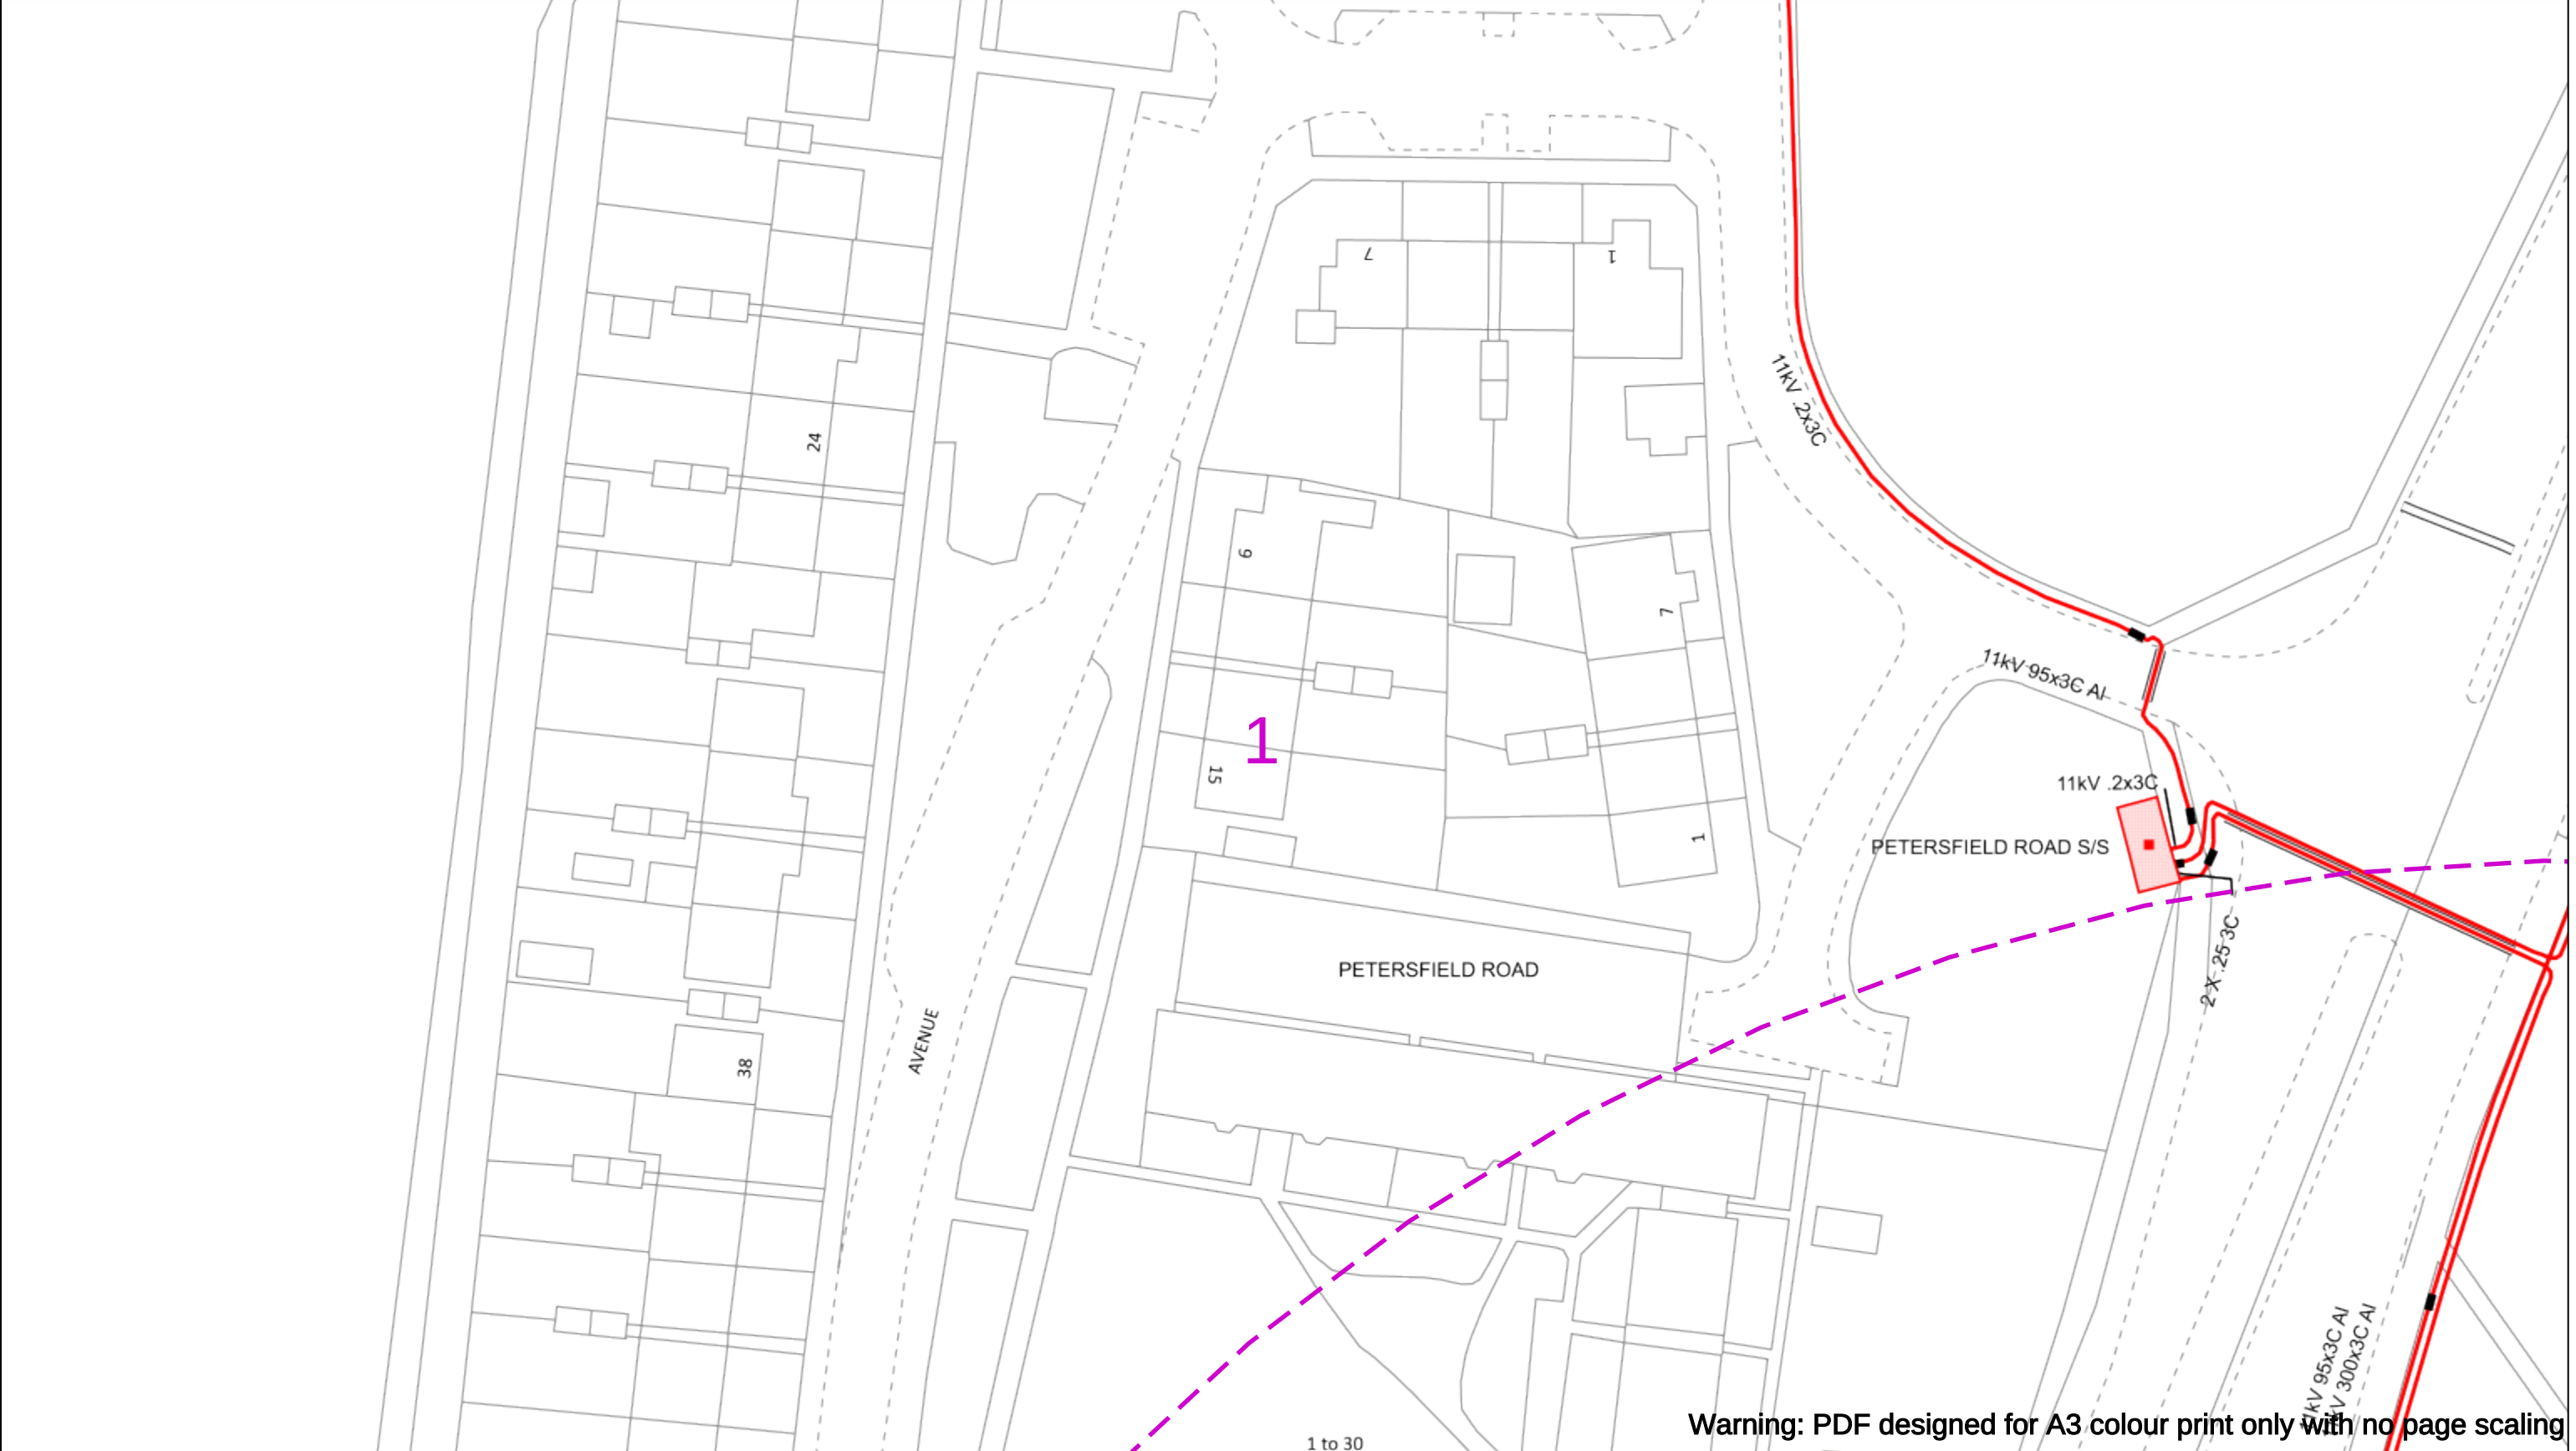

Warning: PDF designed for A3 colour print only with no page scaling

050m

Dig Sites

Area:

Line:

Extra High Voltage cables in vicinity

Date Requested: 13/03/2025

Job Reference: 36616240

Site Location: 472167 108026

Requested by:
Mr TDS Southern

Your Scheme/Reference: SBL.U.01

WARNING

There may have been subsequent alteration to the surface levels. Trial holes must be undertaken to determine position and depths of cables. HS (G) 47 Booklet from the Health and Safety Executive – Avoiding Danger from Buried Cables – should be consulted before commencing excavation work.

WHEN WORKING IN THE VICINITY OF OVERHEAD LINES THE HEALTH AND SAFETY GUIDANCE NOTES GS6 SHOULD BE CONSULTED (AVAILABLE FROM THE HSE WEBSITE)

Voltages (V)				
LV (Low Voltage) and Services	Up to 1,000V			
HV (High Voltage)	Over 1,000V to 11,000V			
EHV (Extra High Voltage)	22,000V to 132,000V			
Transmission	275,000V and 400,000V			

NORMAL DEPTH TO THE TOP OF THE CABLE WHEN LAID				
	Services	LV	HV	EHV
Footpath/Unmade	0.45m	0.45m	0.6m	0.8m
Road Crossing	0.6m	0.6m	0.75m	0.9m
Agricultural	1m	1m	1m	1.1m

Legend

Service Cable

LV Mains

2-3.3kV

6.6kV

11kV

22kV

33kV

66kV

132kV

275kV

400kV

Fibre Optic

Pilot Cable

Distribution Structures [Electric]

Pole, Existing Location

Pole, Existing Location - Single

Pole, Existing Location - H

Duct Route

Cross Section Route

Scottish & Southern

Electricity Networks

Southern Electric Power Distribution plc

Registered Office: No.1 Forbury Place

43 Forbury Road Reading RG1 3JH

Registered In England & Wales No.04094290

If you're unsure & need to seek advice before commencing excavations please contact:

General Enquiries: 0800 048 3516

Subject to revision – Master held by SSEN Asset Data Team:


Asset.Data@sse.com

01256 337 294

Scale: 1:500 (When plotted at A3)

BASED UPON THE ORDNANCE SURVEY MAP WITH THE SANCTION OF THE CONTROLLER OF H.M STATIONERY OFFICE CROWN COPYRIGHT RESERVED.

This copy has been made by or with the authority of Scottish and Southern Energy Power Distribution Ltd. Pursuant to section 47 of the Copyright, Designs and Patents Act 1988 ('The Act'). Unless the Act provides a relevant exception to copyright the copy must not be copied without prior permission of the copyright owner. Plans generated by DigSAFE Pro™ software provided by LinesearchbeforeUdig.

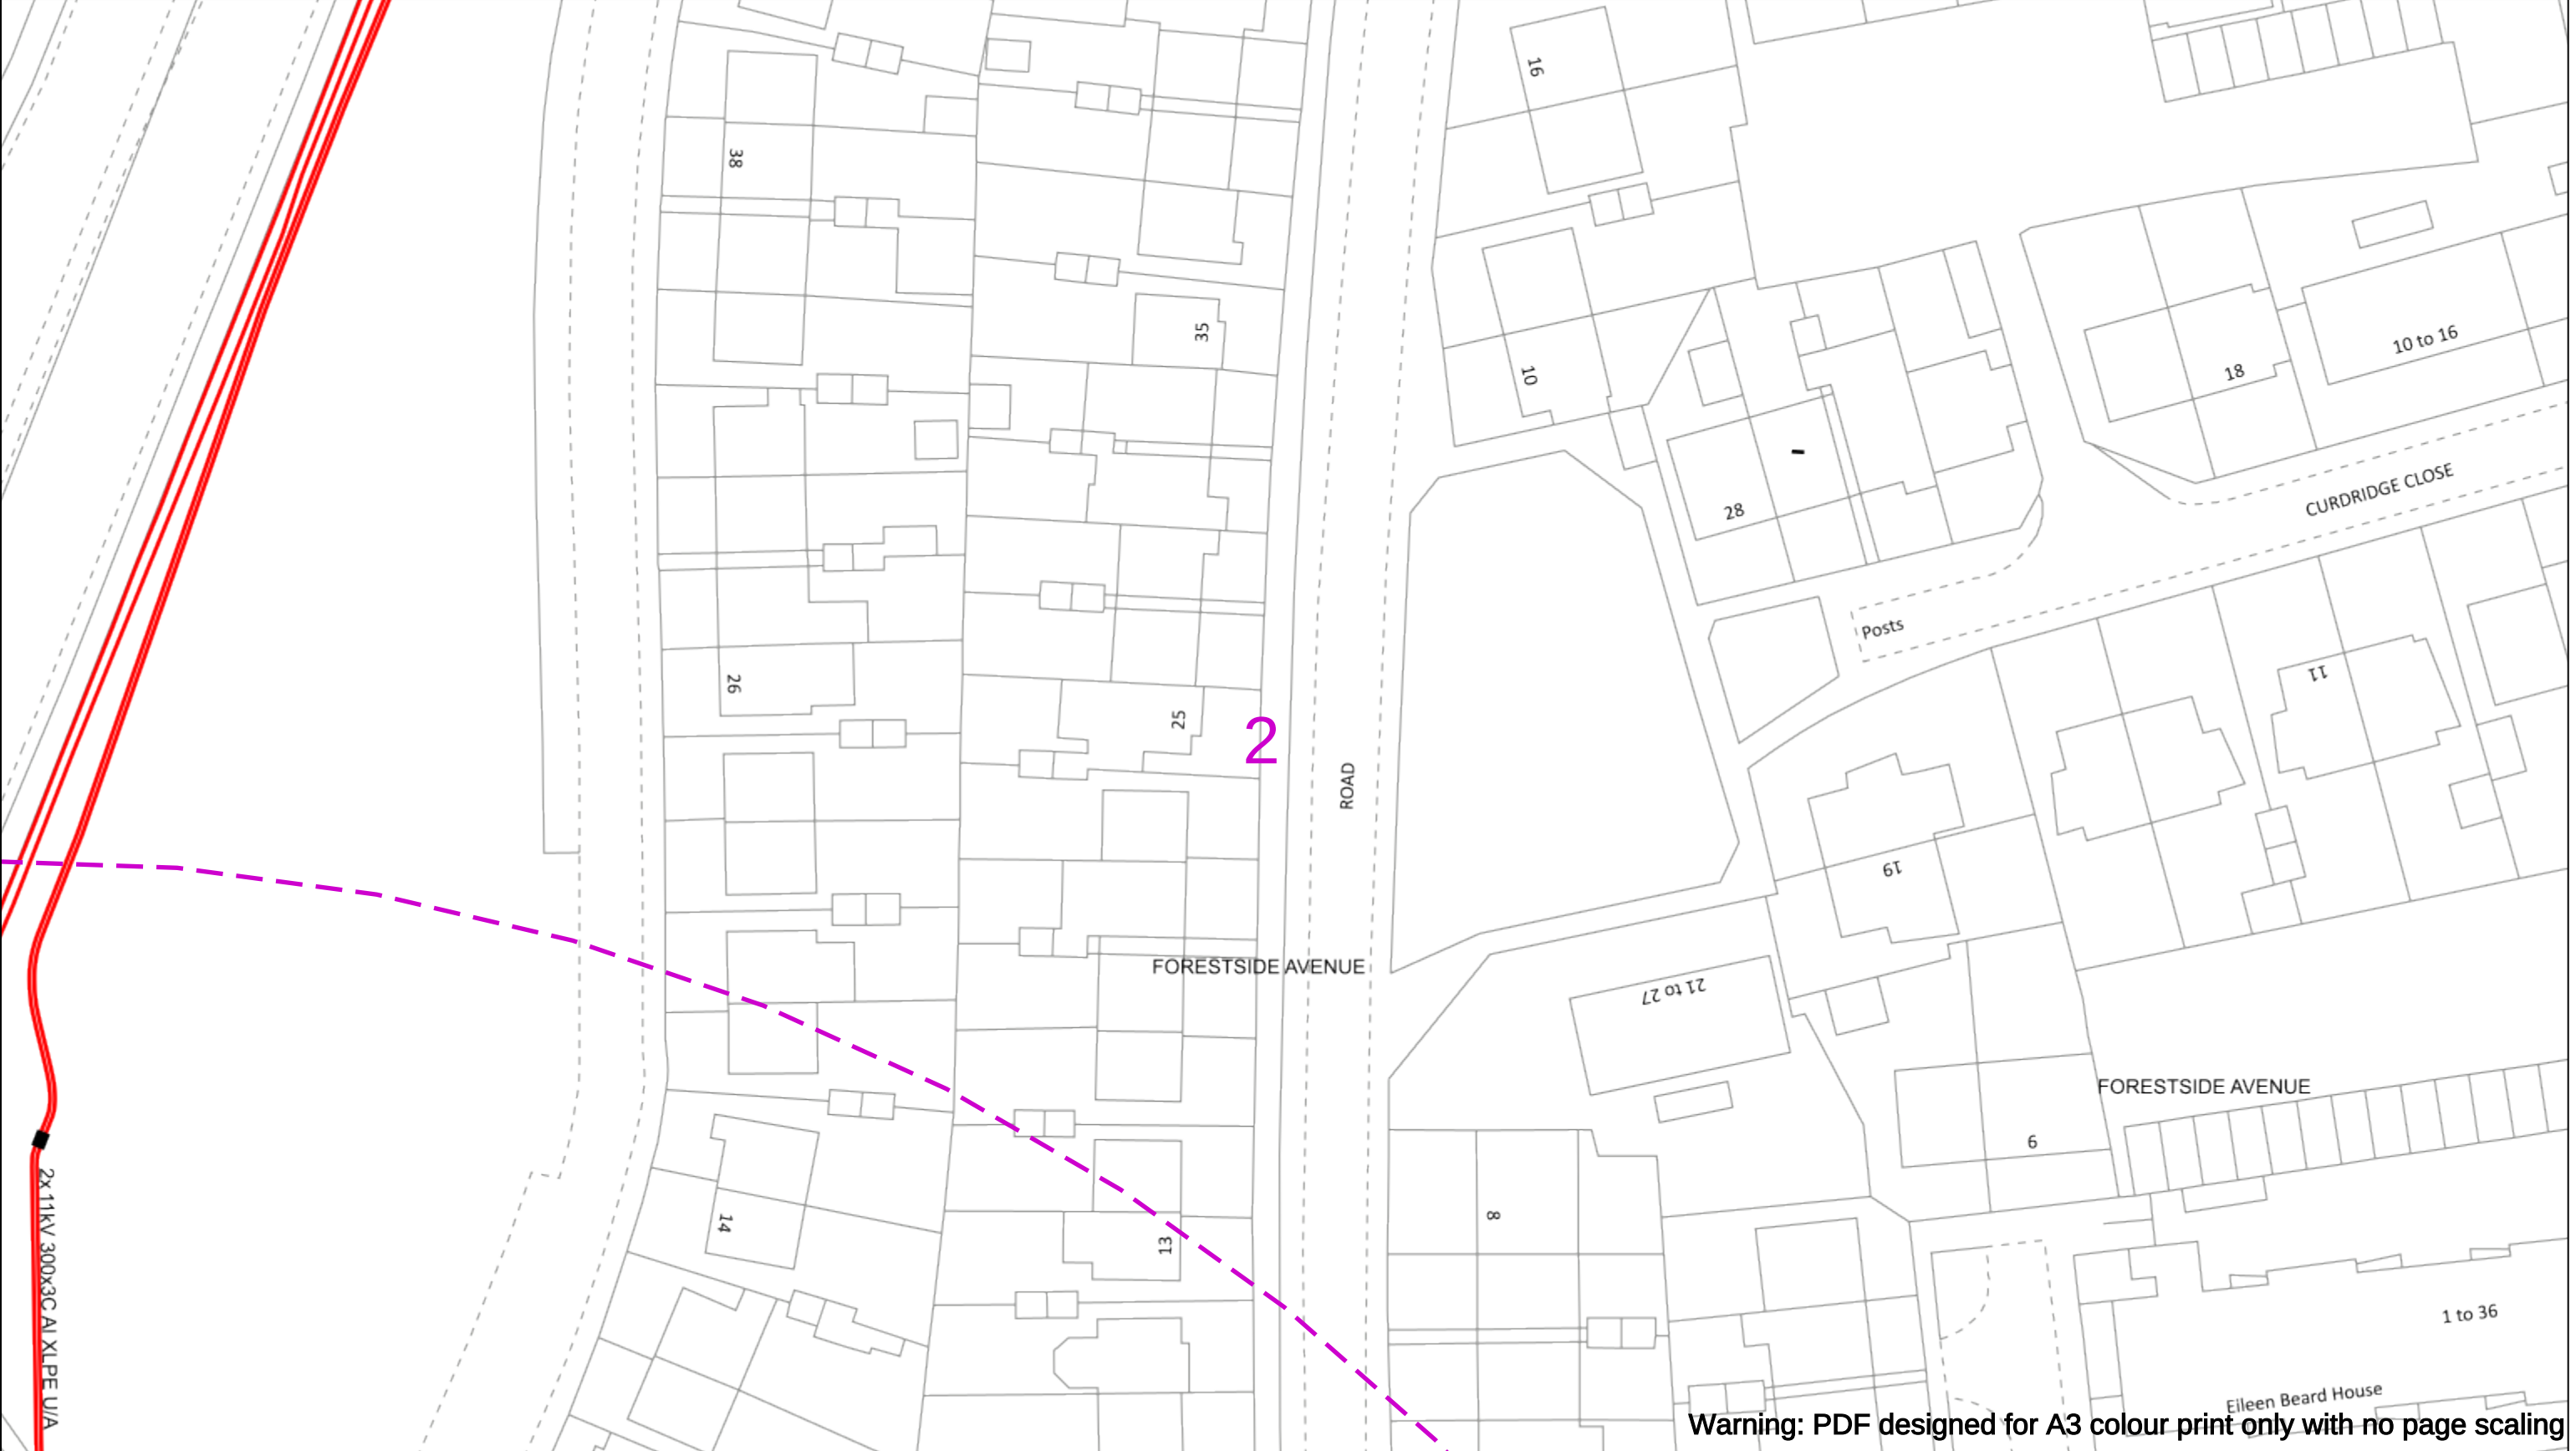

Warning: PDF designed for A3 colour print only with no page scaling

050m

Dig Sites

Area:

Line:

Extra High Voltage cables in vicinity

Date Requested: 13/03/2025

Job Reference: 36616240

Site Location: 472167 108026

Requested by:
Mr TDS Southern

Your Scheme/Reference: SBL.U.01

WARNING

There may have been subsequent alteration to the surface levels. Trial holes must be undertaken to determine position and depths of cables. HS (G) 47 Booklet from the Health and Safety Executive – Avoiding Danger from Buried Cables – should be consulted before commencing excavation work.

WHEN WORKING IN THE VICINITY OF OVERHEAD LINES THE HEALTH AND SAFETY GUIDANCE NOTES GS6 SHOULD BE CONSULTED (AVAILABLE FROM THE HSE WEBSITE)

Voltages (V)				
LV (Low Voltage) and Services	Up to 1,000V			
HV (High Voltage)	Over 1,000V to 11,000V			
EHV (Extra High Voltage)	22,000V to 132,000V			
Transmission	275,000V and 400,000V			

NORMAL DEPTH TO THE TOP OF THE CABLE WHEN LAID				
	Services	LV	HV	EHV
Footpath/Unmade	0.45m	0.45m	0.6m	0.8m
Road Crossing	0.6m	0.6m	0.75m	0.9m
Agricultural	1m	1m	1m	1.1m

Legend

Service Cable

LV Mains

2-3.3kV

6.6kV

11kV

22kV

33kV

66kV

132kV

275kV

400kV

Fibre Optic

Pilot Cable

Distribution Structures [Electric]

Pole, Existing Location

Pole, Existing Location - Single

Pole, Existing Location - H

Duct Route

Cross Section Route

Southern Electric Power Distribution plc

Registered Office: No.1 Forbury Place
43 Forbury Road Reading RG1 3JH
Registered In England & Wales No.04094290

 
If you're unsure & need to seek advice before commencing excavations please contact:
General Enquiries: 0800 048 3516

 
Subject to revision – Master held by SSEN Asset Data Team:
Asset.Data@sse.com
01256 337 294


Scale: 1:500 (When plotted at A3)

BASED UPON THE ORDNANCE SURVEY MAP WITH THE SANCTION OF THE CONTROLLER OF THE OFFICE OF H.M. STATIONERY OFFICE CROWN COPYRIGHT RESERVED.

This copy has been made by or with the authority of Scottish and Southern Energy Power Distribution Ltd. Pursuant to section 47 of the Copyright, Designs and Patents Act 1988 ('The Act'). Unless the Act provides a relevant exception to copyright the copy must not be copied without prior permission of the copyright owner. Plans generated by DigSAFE Pro™ software provided by LinesearchbeforeUdig.





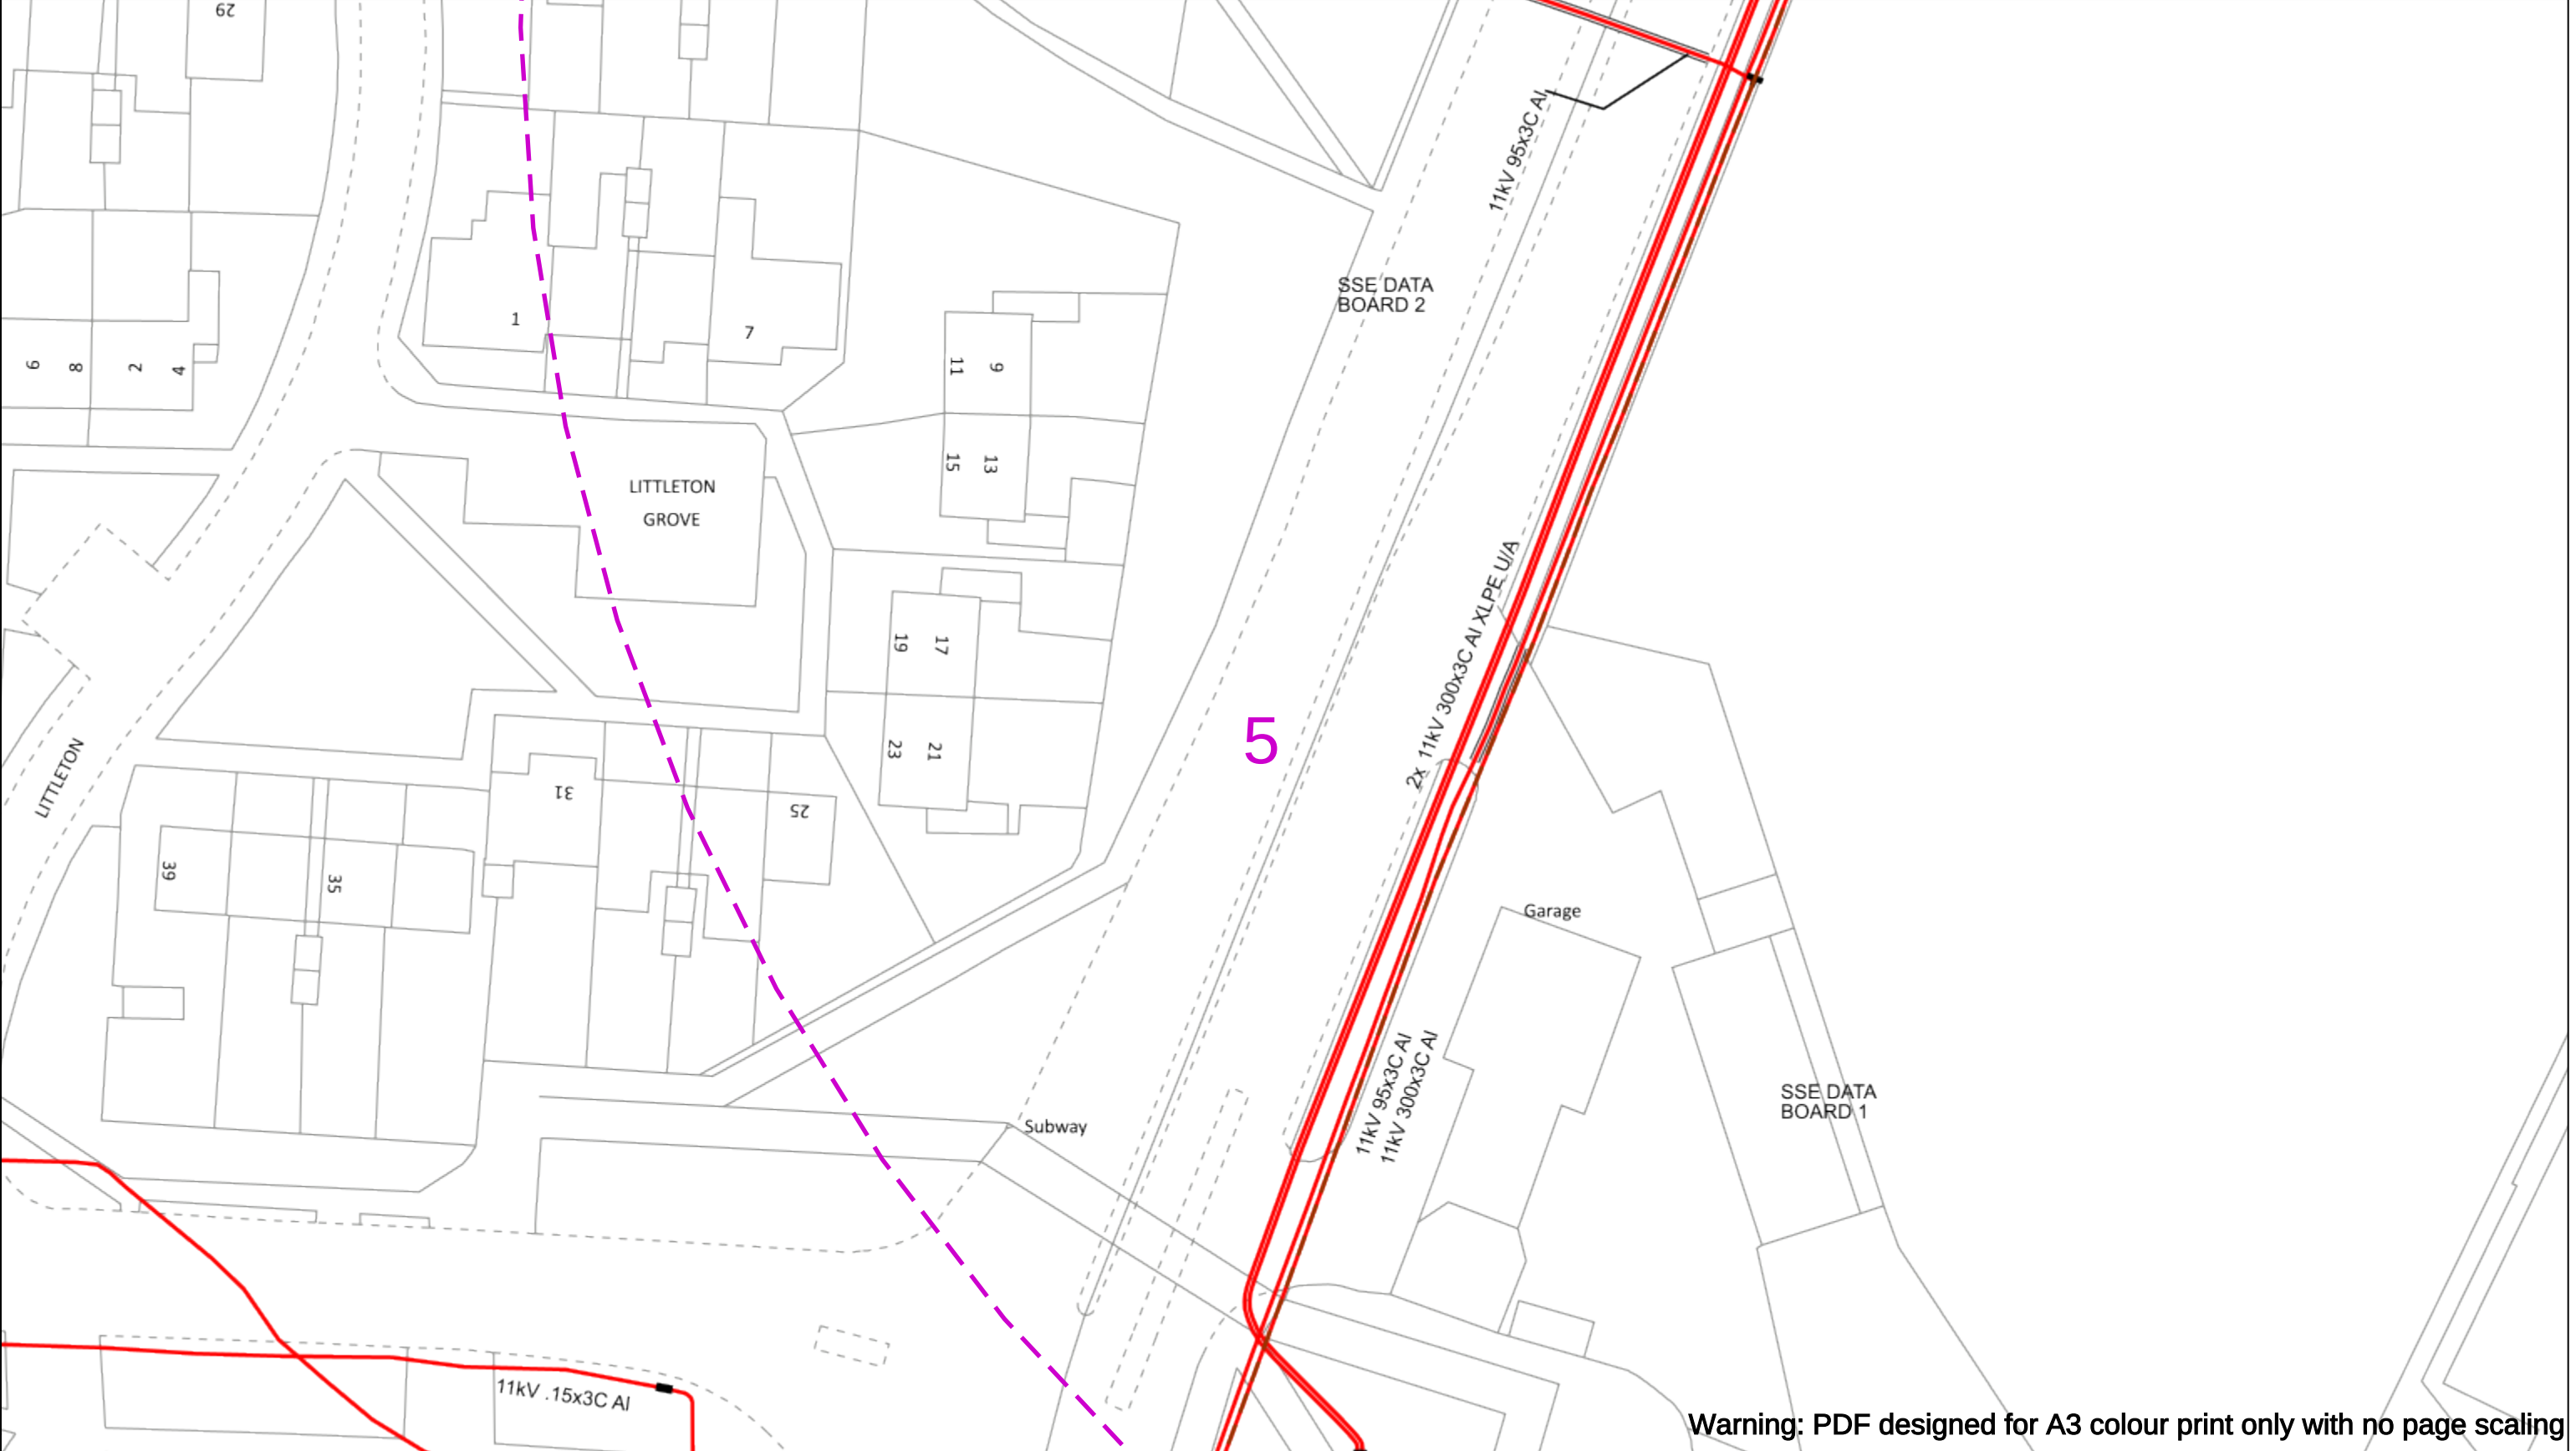

Warning: PDF designed for A3 colour print only with no page scaling

050m

Dig Sites

Area:

Line:

Extra High Voltage cables in vicinity

Date Requested: 13/03/2025

Job Reference: 36616240

Site Location: 472167 108026

Requested by:
Mr TDS Southern

Your Scheme/Reference: SBL.U.01

Scale: 1:500 (When plotted at A3)

WARNING

There may have been subsequent alteration to the surface levels. Trial holes must be undertaken to determine position and depths of cables. HS (G) 47 Booklet from the Health and Safety Executive – Avoiding Danger from Buried Cables – should be consulted before commencing excavation work.

WHEN WORKING IN THE VICINITY OF OVERHEAD LINES THE HEALTH AND SAFETY GUIDANCE NOTES GS6 SHOULD BE CONSULTED (AVAILABLE FROM THE HSE WEBSITE)

	Voltages (V)			
LV (Low Voltage) and Services	Up to 1,000V			
HV (High Voltage)	Over 1,000V to 11,000V			
EHV (Extra High Voltage)	22,000V to 132,000V			
Transmission	275,000V and 400,000V			

	NORMAL DEPTH TO THE TOP OF THE CABLE WHEN LAID			
	Services	LV	HV	EHV
Footpath/Unmade	0.45m	0.45m	0.6m	0.8m
Road Crossing	0.6m	0.6m	0.75m	0.9m
Agricultural	1m	1m	1m	1.1m

Legend

Service Cable

LV Mains

2-3.3kV

6.6kV

11kV

22kV

33kV

66kV

132kV

275kV

400kV

Fibre Optic

Pilot Cable

Distribution Structures [Electric]

Pole, Existing Location

Pole, Existing Location - Single

Pole, Existing Location - H

Duct Route

Cross Section Route

Southern Electric Power Distribution plc
Registered Office: No.1 Forbury Place
43 Forbury Road Reading RG1 3JH
Registered In England & Wales No.04094290


If you're unsure & need to seek advice before commencing excavations please contact:
General Enquiries: 0800 048 3516

Subject to revision – Master held by SSEN Asset Data Team:
Asset.Data@sse.com
01256 337 294

BASED UPON THE ORDNANCE SURVEY MAP WITH THE SANCTION OF THE CONTROLLER OF THE STATIONERY OFFICE CROWN COPYRIGHT RESERVED.

This copy has been made by or with the authority of Scottish and Southern Energy Power Distribution Ltd. Pursuant to section 47 of the Copyright, Designs and Patents Act 1988 ('The Act'). Unless the Act provides a relevant exception to copyright the copy must not be copied without prior permission of the copyright owner. Plans generated by DigSAFE Pro™ software provided by LinesearchbeforeUdig.



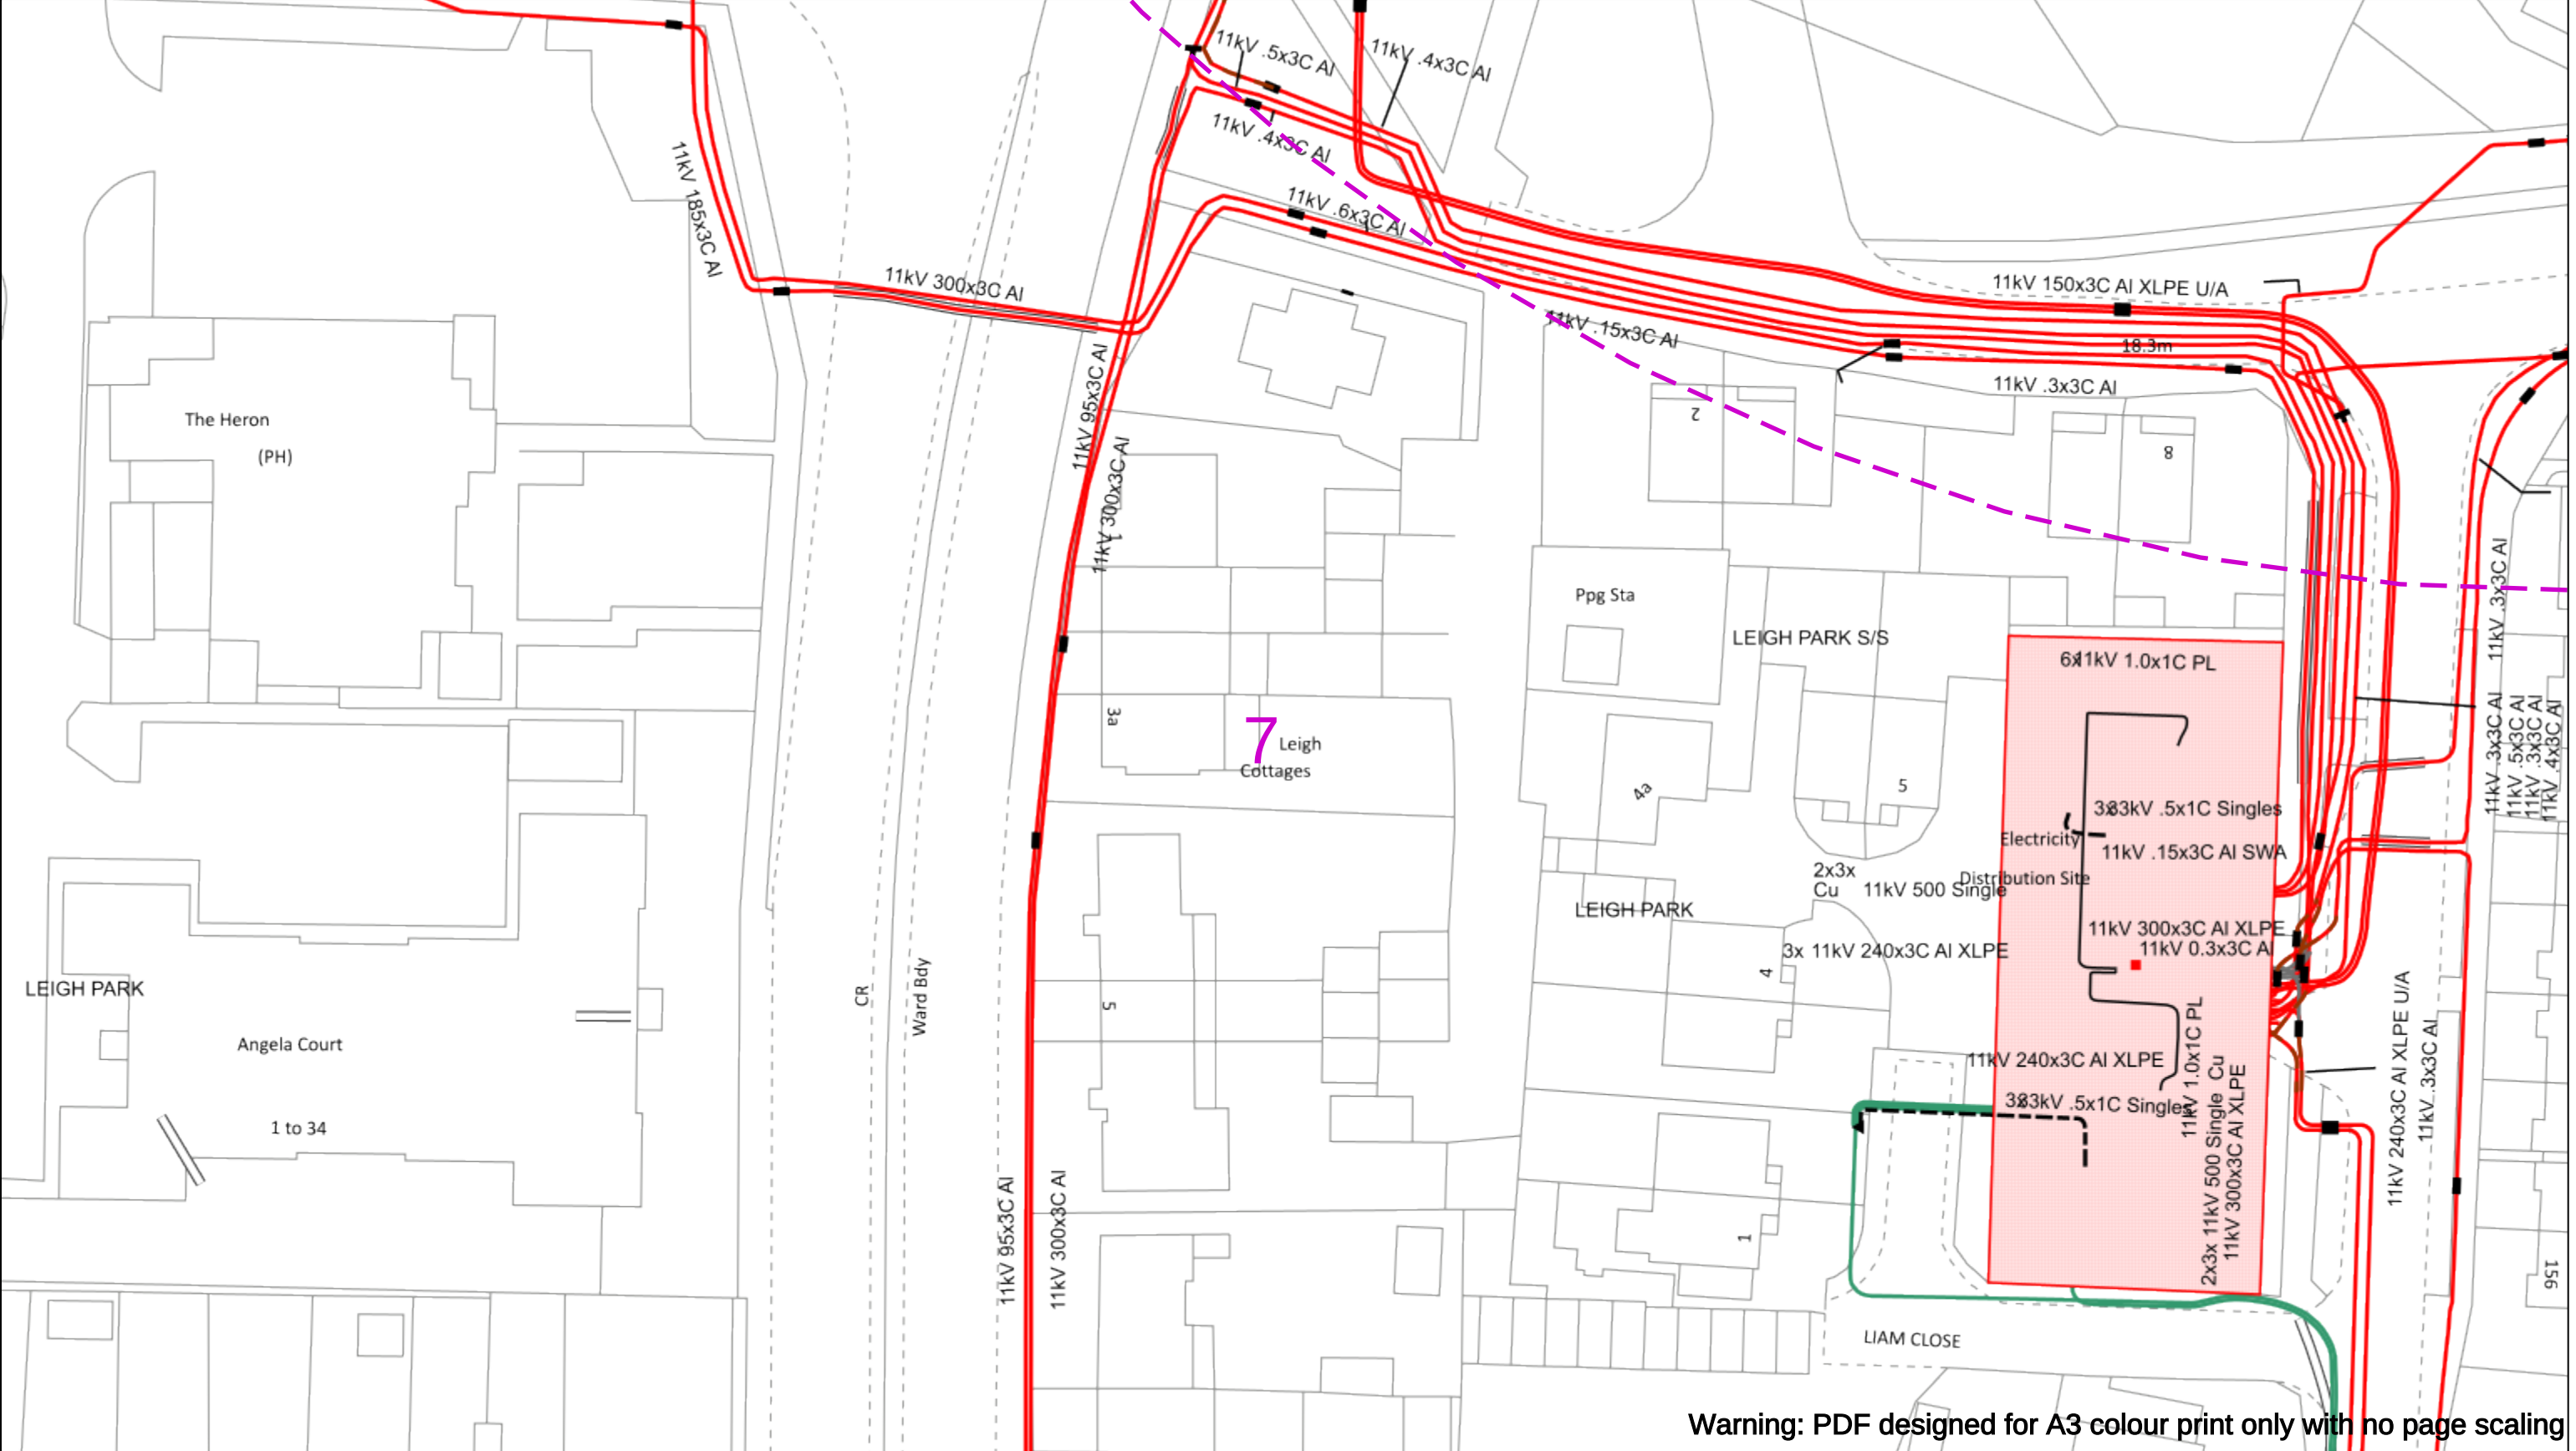

Warning: PDF designed for A3 colour print only with no page scaling

050m

Dig Sites

Area:

Line:

Extra High Voltage cables in vicinity

Legend

Service Cable

LV Mains

2-3.3kV

6.6kV

11kV

22kV

33kV

66kV

132kV

275kV

400kV

Fibre Optic

Pilot Cable

Distribution Structures [Electric]

Pole, Existing Location

Pole, Existing Location - Single

Pole, Existing Location - H

Duct Route

Cross Section Route

Date Requested: 13/03/2025

Job Reference: 36616240

Site Location: 472167 108026

Requested by: Mr TDS Southern

Your Scheme/Reference: SBL.U.01

Scale: 1:500 (When plotted at A3)

WARNING

There may have been subsequent alteration to the surface levels. Trial holes must be undertaken to determine position and depths of cables. HS (G) 47 Booklet from the Health and Safety Executive – Avoiding Danger from Buried Cables – should be consulted before commencing excavation work.

WHEN WORKING IN THE VICINITY OF OVERHEAD LINES THE HEALTH AND SAFETY GUIDANCE NOTES GS6 SHOULD BE CONSULTED (AVAILABLE FROM THE HSE WEBSITE)

	Voltages (V)			
	Up to 1,000V	Over 1,000V to 11,000V	22,000V to 132,000V	275,000V and 400,000V
LV (Low Voltage) and Services	Up to 1,000V	Over 1,000V to 11,000V	22,000V to 132,000V	275,000V and 400,000V
HV (High Voltage)				
EHV (Extra High Voltage)				
Transmission				

	NORMAL DEPTH TO THE TOP OF THE CABLE WHEN LAID			
	Services	LV	HV	EHV
Footpath/Unmade	0.45m	0.45m	0.6m	0.8m
Road Crossing	0.6m	0.6m	0.75m	0.9m
Agricultural	1m	1m	1m	1.1m

Scottish & Southern

Electricity Networks

Southern Electric Power Distribution plc

Registered Office: No.1 Forbury Place

43 Forbury Road Reading RG1 3JH

Registered In England & Wales No.04094290

If you're unsure & need to seek advice before commencing excavations please contact:

General Enquiries: 0800 048 3516

 
Subject to revision – Master held by SSEN Asset Data Team:

Asset.Data@sse.com

01256 337 294


BASED UPON THE ORDNANCE SURVEY MAP WITH THE SANCTION OF H.M STATIONERY OFFICE CROWN COPYRIGHT RESERVED.

This copy has been made by or with the authority of Scottish and Southern Energy Power Distribution Ltd. Pursuant to section 47 of the Copyright, Designs and Patents Act 1988 ('The Act'). Unless the Act provides a relevant exception to copyright the copy must not be copied without prior permission of the copyright owner. Plans generated by DigSAFE Pro™ software provided by LinesearchbeforeUdig.



Appendix 6 – Telecoms Infrastructure

Maps on Demand Plant Information Reply

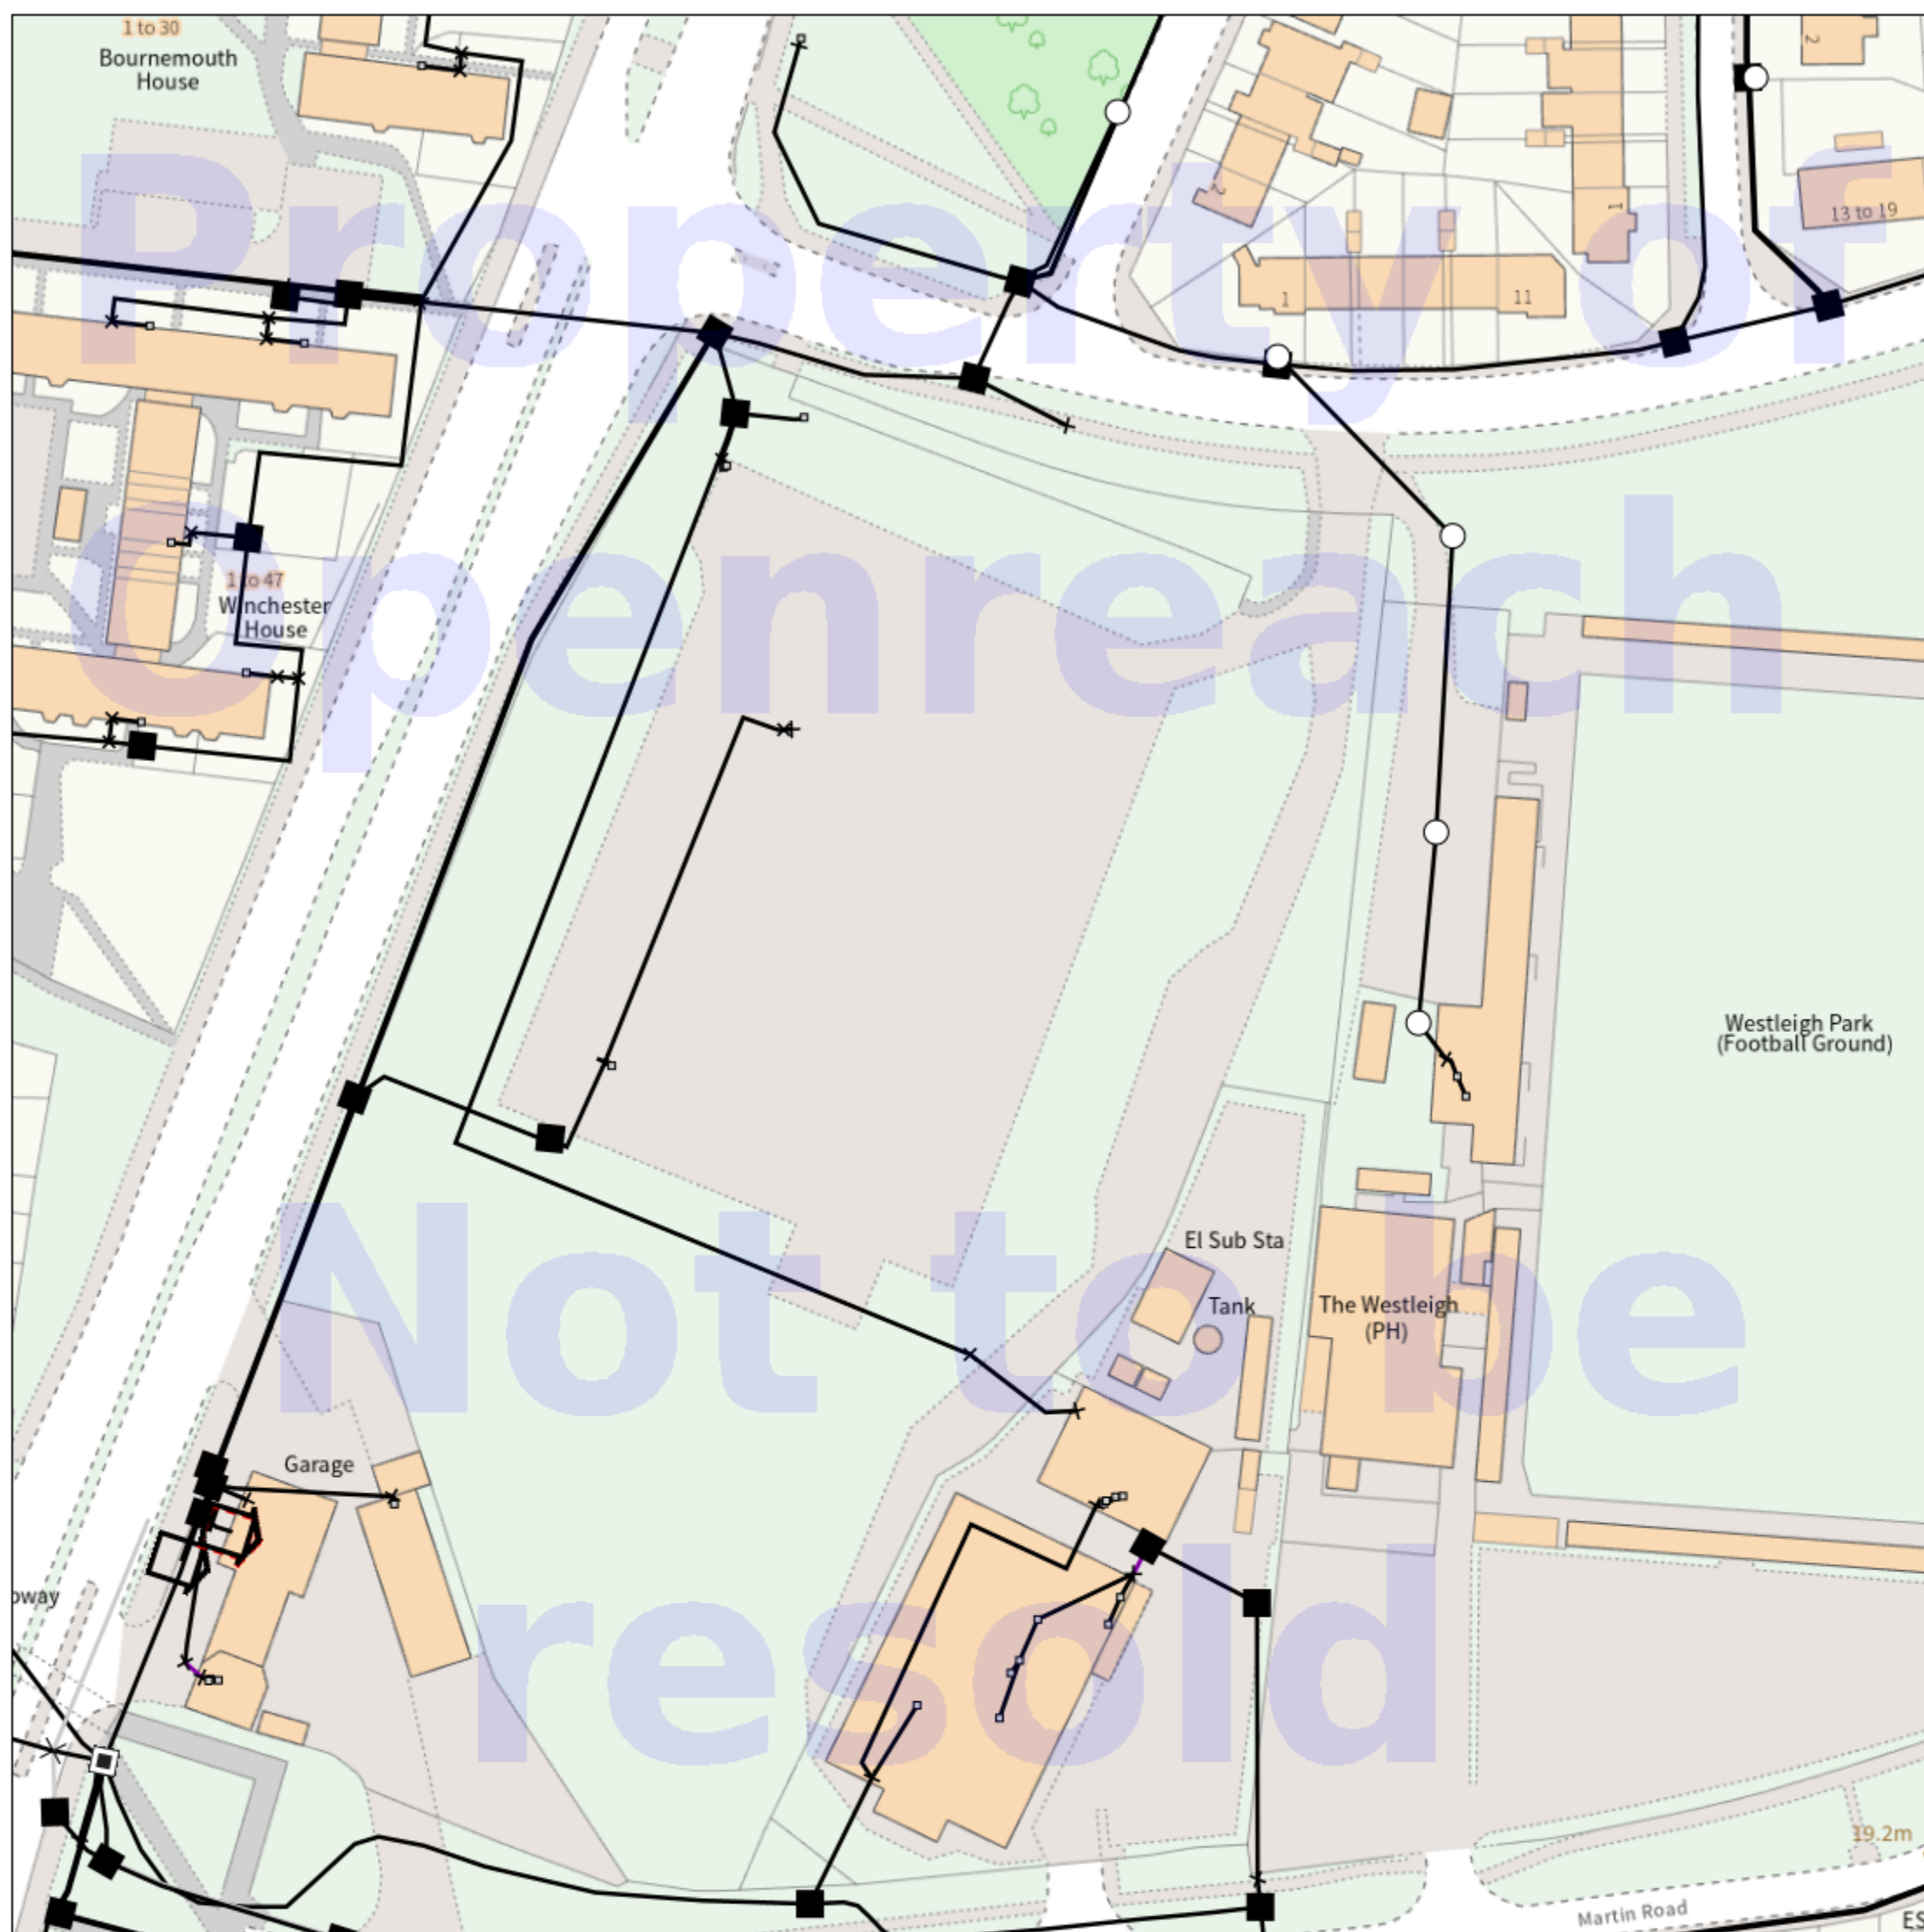

IMPORTANT WARNING

Information regarding the location of BT apparatus is given for your assistance and is intended for general guidance only. No guarantee is given of its accuracy. It should not be relied upon in the event of excavations or other works being made near to BT apparatus which may exist at various depths and may deviate from the marked route.

openreach

CLICK BEFORE YOU DIG

FOR PROFESSIONAL FREE ON SITE ASSISTANCE PRIOR TO COMMENCEMENT OF EXCAVATION WORKS INCLUDING LOCATE AND MARKING SERVICE

email cbyd@openreach.co.uk

ADVANCE NOTICE REQUIRED
(Office hours: Monday - Friday 08.00 to 17.00)
www.openreach.co.uk/cbyd

Accidents happen

If you do damage any Openreach equipment please let us know by calling 0800 023 2023 (opt 1 + opt 1) and we can get it fixed ASAP

© Crown copyright 2023 OS 100028040. You are permitted to use this data solely to enable you to respond to, or interact with, the organisation that provided you with the data. You are not permitted to copy, sub-license, distribute or sell any of this data to third parties in any form.

KEY TO BT SYMBOLS

	Planned	Live	Change Of State	+	Hatchings	
			Split Coupling	×	Built	
PCP			Duct Tee	▲	Planned	
Pole			Building		Inferred	
Box			Kiosk	Ⓚ	Duct	
Manhole			Other proposed plant is shown using dashed lines. BT Symbols not listed above may be disregarded. Existing BT Plant may not be recorded. Information valid at time of preparation. Maps are only valid for 90 days after the date of publication.			
Cabinet						
	Pending Add	In Place	Pending Remove	Not In Use		
Power Cable						
Power Duct				N/A		

BT Ref : NFA11163F

Map Reference : (centre) SU7217508026

Easting/Northing : (centre) 472175,108026

Scale : 1:250

Issued : 13/03/2025 11:16:13

WARNING: IF PLANNED WORKS FALL INSIDE HATCHED AREA IT IS ESSENTIAL BEFORE PROCEEDING THAT YOU CONTACT THE NATIONAL NOTICE HANDLING CENTRE. PLEASE SEND E-MAIL TO: nnhc@openreach.co.uk

Appendix 7 – Media & Pipelines Search

Enquirer

Name	Mr TDS Southern	Phone	01403 276 888
Company	TDS Southern	Mobile	Not Supplied
Address	54 Queen Street Queen Street Horsham Horsham WSX RH13 5AD		
Email	dan.wright@t-d-s.com		


Enquiry Details

Enquiry type	Initial Enquiry
Work category	Development Projects
Work type	Housing
Work type buffer*	25 metres
Start date	14/03/2025
End date	14/03/2025
Scheme/Reference	SBL.U.01
Search location	PO95HP
Confirmed location	472167 108026
Site size	325 metres diameter
Site Contact Name	Not Supplied
Site Phone No.	Not Supplied

Description of Works

* The WORK TYPE BUFFER is a distance added to your search area based on the Work type you have chosen.

Site Map

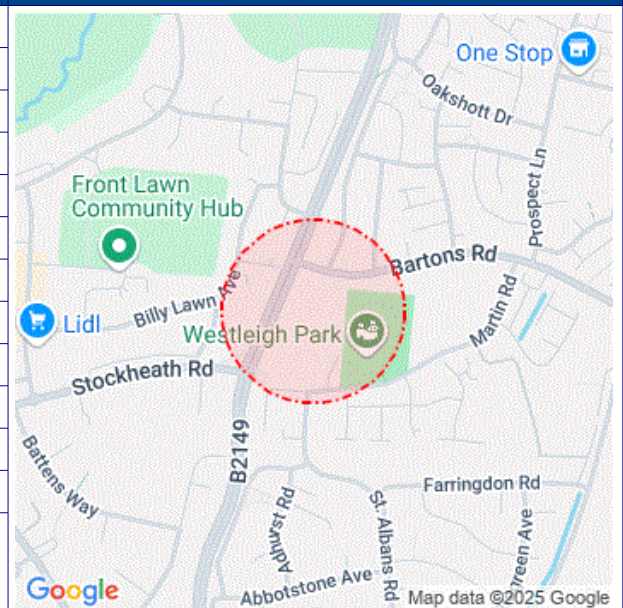

Please note that the above map only displays the location of the proposed work site and will not display any of the Members' pipes and cables. It is imperative that this area accurately reflects the proposed work site.

Affected LSBUD members

(LSBUD Members who have assets registered on LSBUD within the vicinity of your search area.)

Do not proceed until all Members listed below have confirmed that your works can continue.

Asset Owner	Phone/Email	Emergency Only	Status
Neos Networks	03453053337	03453053337	Await response
Portsmouth Water	02392499888	02392477999	Await response
Scottish and Southern Electricity Networks	08000483516	08000727282	Await response
SGN	08009121722	0800111999	Await response

Status explanation

Await Response means that the asset owner will contact you. This is typically by sending the plan response but they may ask for further information before being able to do so, particularly if any payments or authorisations are required.

Email Additional Info means that the asset owner needs further information about your works to assess your enquiry before providing a response. Please provide any details you have available including plans, method statements etc. if available.

Important notices

It is very important that you correctly understand what the service does and the procedures in order for you to work safely. Please refer to the LSBUD Support Page (www.lsbud.co.uk/lineasearchbeforeudig-support) for further guidance.

This information includes how to provide additional information to the LSBUD Members who request it to provide a response to your enquiry.

Validity and search criteria. The results of this enquiry are based on the confirmed information you entered and are valid only as at the date and time of the enquiry. It is your responsibility to ensure that the Enquiry Details are correct, and LineasearchbeforeUdig (LSBUD) accepts no responsibility for any errors or omissions in the Enquiry Details or any consequences thereof. LSBUD Members update their asset information on a regular basis so you are advised to consider this when undertaking any works. It is your responsibility to choose the period of time after which you need to resubmit any enquiry but the maximum time (after which your enquiry will no longer be dealt with by the LSBUD Helpdesk and LSBUD Members) is 28 days. If any details of the enquiry change, particularly including, but not limited to, the location of the work, then a further enquiry must be made.

Terms and Conditions. Please note that this enquiry is subject always to our standard terms and conditions available at www.lsbud.co.uk ("Terms of Use") and the disclaimer at the end of this document. Please note that in the event of any conflict or ambiguity between the terms of this Enquiry Confirmation and the Terms of Use, the Terms of Use shall take precedence.

List of not affected LSBUD members (LSBUD Members who do not have assets registered on the LSBUD service within the vicinity of your search area.)

AllPoints Fibre	Angus Energy	AWE Pipeline
B & D Energy Limited	Balfour Beatty Investments Limited	BOC Limited (A Member of the Linde Group)
Box Broadband	BP Exploration Operating Company Limited	BPA
Cadent Gas	Cambridge Water	Cambridgeshire County Council Climate Change and Energy Services
CATS Pipeline c/o Wood Group PSN	Cemex	Centrica Storage Ltd
CNG Services Ltd	Concept Solutions People Ltd	ConocoPhillips (UK) Teesside Operator Ltd
D.S.Smith	Diamond Transmission Corporation	DIO (MOD Live Pipelines)
Drax Power Limited	EDF Energy Renewables Ltd	EET Fuels
EirGrid	Eleclink Limited	Electricity North West Limited
Energy Assets Networks	ENI & Himor c/o Penspen Ltd	EnQuest NNS Limited
EP Langage Limited	ESB CCGT Power station (Carrington Gas Pipeline)	ESP Utilities Group
Esso Petroleum Company Limited	euNetworks Fiber UK Ltd	EXA Infrastructure
Exolum Pipeline System	Fulcrum Electricity Assets Limited	Fulcrum Pipelines Limited
G.Network Communication Ltd c/o JSM Group Ltd	Gamma	Gas Networks Ireland (UK)
Gateshead Energy Company	Gigaclear Ltd	Greenlink Interconnector Ltd
Harbour Energy	Heathrow Airport LTD	Humbly Grove Energy
IGas Energy	Impala Terminals Infrastructure Ltd	INEOS FPS Pipelines
INEOS Manufacturing (Scotland and TSEP)	INOVYN ChlorVinyls Limited	INOVYN Enterprises Limited
Intergen (Coryton Energy or Spalding Energy)	Kensa Utilities	Last Mile
Liverpool City Region Connect	Mainline Pipelines Limited	Manchester Jetline Limited
Manx Cable Company	Marchwood Power Ltd (Gas Pipeline)	Melbourn Solar Limited
MUA Group Limited	National Gas Transmission	National Grid Electricity Distribution
National Grid Electricity Transmission	National Grid Ventures	Northern Gas Networks Limited
Northumbrian Water Group	NPower CHP Pipelines	NTT Global Data Centers EMEA UK Ltd
NYnet Ltd	Ogi	Oikos Storage Limited
Ørsted	Palm Paper Ltd	Perenco UK Limited (Purbeck Southampton Pipeline)
Petroineos	Phillips 66	Premier Transmission Ltd (SNIP)
Redundant Pipelines - LPDA	RWE - Great Yarmouth Pipeline (Bacton to Great Yarmouth Power Station)	RWEnpower (Little Barford and South Haven)
SABIC UK Petrochemicals	SAS Utility Services Ltd	Scottish Power Generation
Seabank Power Ltd	SES Water	Shell
Shell NOP	South Staffs Water	SP Energy Networks

Spring Fibre Limited	Squire Energy Networks	SSE Generation Ltd
SSE Transmission	SSE Utility Solutions Limited	Storengy
Tata Communications (c/o JSM Construction Ltd)	TfL – London Underground HV Cables (Road & Track Side Cables)	toob Limited
Total (Colnbrook) c/o Penspen	Total Finaline Pipelines	Transmission Capital
Trojan Energy Limited	UK Power Distribution	UK Power Networks
Uniper UK Ltd	University of Cambridge Granta Backbone Network	Vattenfall
Veolia ES SELCHP Limited	Veolia ES Sheffield Ltd	Voneus Limited
VPI Power Limited	Wales and West Utilities	Welsh Power
West of Duddon Sands Transmission Ltd	West Sussex OpenNetwork (Cooperative National Infrastructure)	Westminster City Council
Winnington CHP Ltd	Zayo Group UK Ltd c/o JSM Group Ltd	

Non-LSBUD members (Asset owners not registered on LSBUD)

(The following Non-LSBUD Members may have assets in your search area. It is YOUR RESPONSIBILITY to contact them before proceeding.

Please be aware this list is not exhaustive and it is your responsibility to identify and contact all asset owners within your search area.)

Asset Owner	Preferred contact method	Phone	Status
Bring Energy	nrsua@bringenergy.com	0800 130 3600	Not Notified
BT	https://www.swns.bt.com/pls/mbe/welcome.home	08000232023	Not Notified
CityFibre	asset.team@cityfibre.com	033 3150 7282	Not Notified
Colt	plantenquiries@catelecomuk.com	01227768427	Not Notified
GTC	https://pe.gtc-uk.co.uk/PlantEnqMembership	01359240363	Not Notified
Lumen Technologies	plantenquiries@ocugroup.com	02087314613	Not Notified
Mobile Broadband Network Limited	mbnl.plant.enquiries@turntown.com	01212 621 100	Not Notified
Sky UK Limited	nrsua@sky.uk	02070323234	Not Notified
Sota	sota.plantenquiries@ocugroup.com		Not Notified
Southern Water	www.digdat.co.uk	08452700212	Not Notified
Utility assets Ltd	assetrecords@utilityassets.co.uk		Not Notified
Verizon Business	osp-team@uk.verizonbusiness.com	01293611736	Not Notified
Virgin Media	http://www.digdat.co.uk	08708883116	Not Notified
Vodafone	osm.enquiries@atkinsglobal.com	01454662881	Not Notified

Disclaimer

Please refer to LSBUD's Terms of Use for full terms of use available at www.lsbud.co.uk

The results of this Enquiry are personal to the Enquirer and shall not be shared with or relied upon by any other party. The asset information on which the Enquiry results are based has been provided by LSBUD Members, therefore LSBUD will provide no guarantee that such information is accurate or reliable nor does it monitor such asset information for accuracy and reliability going forward. There may also be asset owners which do not participate in the enquiry service operated by LSBUD, including but not exclusively those set out above. Therefore, LSBUD cannot make any representation or give any guarantee or warranty as to the completeness of the information contained in the enquiry results or accept any responsibility for the accuracy of the mapping images used. LSBUD and its employees, agents and consultants accept no liability (save that nothing in this Enquiry Confirmation excludes or limits our liability for death or personal injury arising from our negligence, or our fraud or fraudulent misrepresentation, or any other liability that cannot be excluded or limited by English law) arising in respect thereof or in any other way for errors or omissions including responsibility to any person by reason of negligence.



(c) Crown copyright and database rights 2024 Ordnance Survey 100019209
Data updated: 01/06/24

Scale: 1:1250
Map Centre: 472159,108006

Date: 27/06/24
Our Ref: 1505611 - 1

Telecoms Plan A3
Powered by digdat

Duct, Trench

Chamber / Pole

Cabinet

ben.evans2@atkinsglobal.com

226475



Important Information - please read The purpose of this plan is to identify Virgin Media apparatus. We have tried to make it as accurate as possible but we cannot warrant its accuracy. In addition, we caution that within Virgin Media apparatus there may be instances where mains voltage power cables have been placed inside green, rather than black ducting. Further details can be found using the "Affected Postcodes.pdf", which can be downloaded from this website. Therefore, you must not rely solely on this plan if you are carrying out any excavation or other works in the vicinity of Virgin Media apparatus. The actual position of any underground service must be verified by cable detection equipment, etc. and established on site before any mechanical plant is used. Accordingly, unless it is due to the negligence of Virgin Media, its employees or agents, Virgin Media will not have any liability for any omissions or inaccuracies in the plan or for any loss or damage caused or arising from the use of and/or any reliance on this plan. This plan is produced by Virgin Media Limited (c) Crown copyright and database rights 2024 Ordnance Survey 100019209.



Legend

- Access Chamber.Location Active Footway Chamber
- Underground Route.Route Active - Owned
- Underground Route.Route Active - Leased
- Underground Route.Route Active - Third Party




Vodafone Limited (No01471587) registered office is at Vodafone House, The Connection, Newbury, Berkshire, RG142FN

Plot Date : 28/06/2024

Scale : 1:1250

This plan shows apparatus owned by members of the Vodafone Group of companies (including legacy telecommunication companies currently within the group)

Information with regard to such apparatus should always be obtained from Vodafone or its appointed agents.

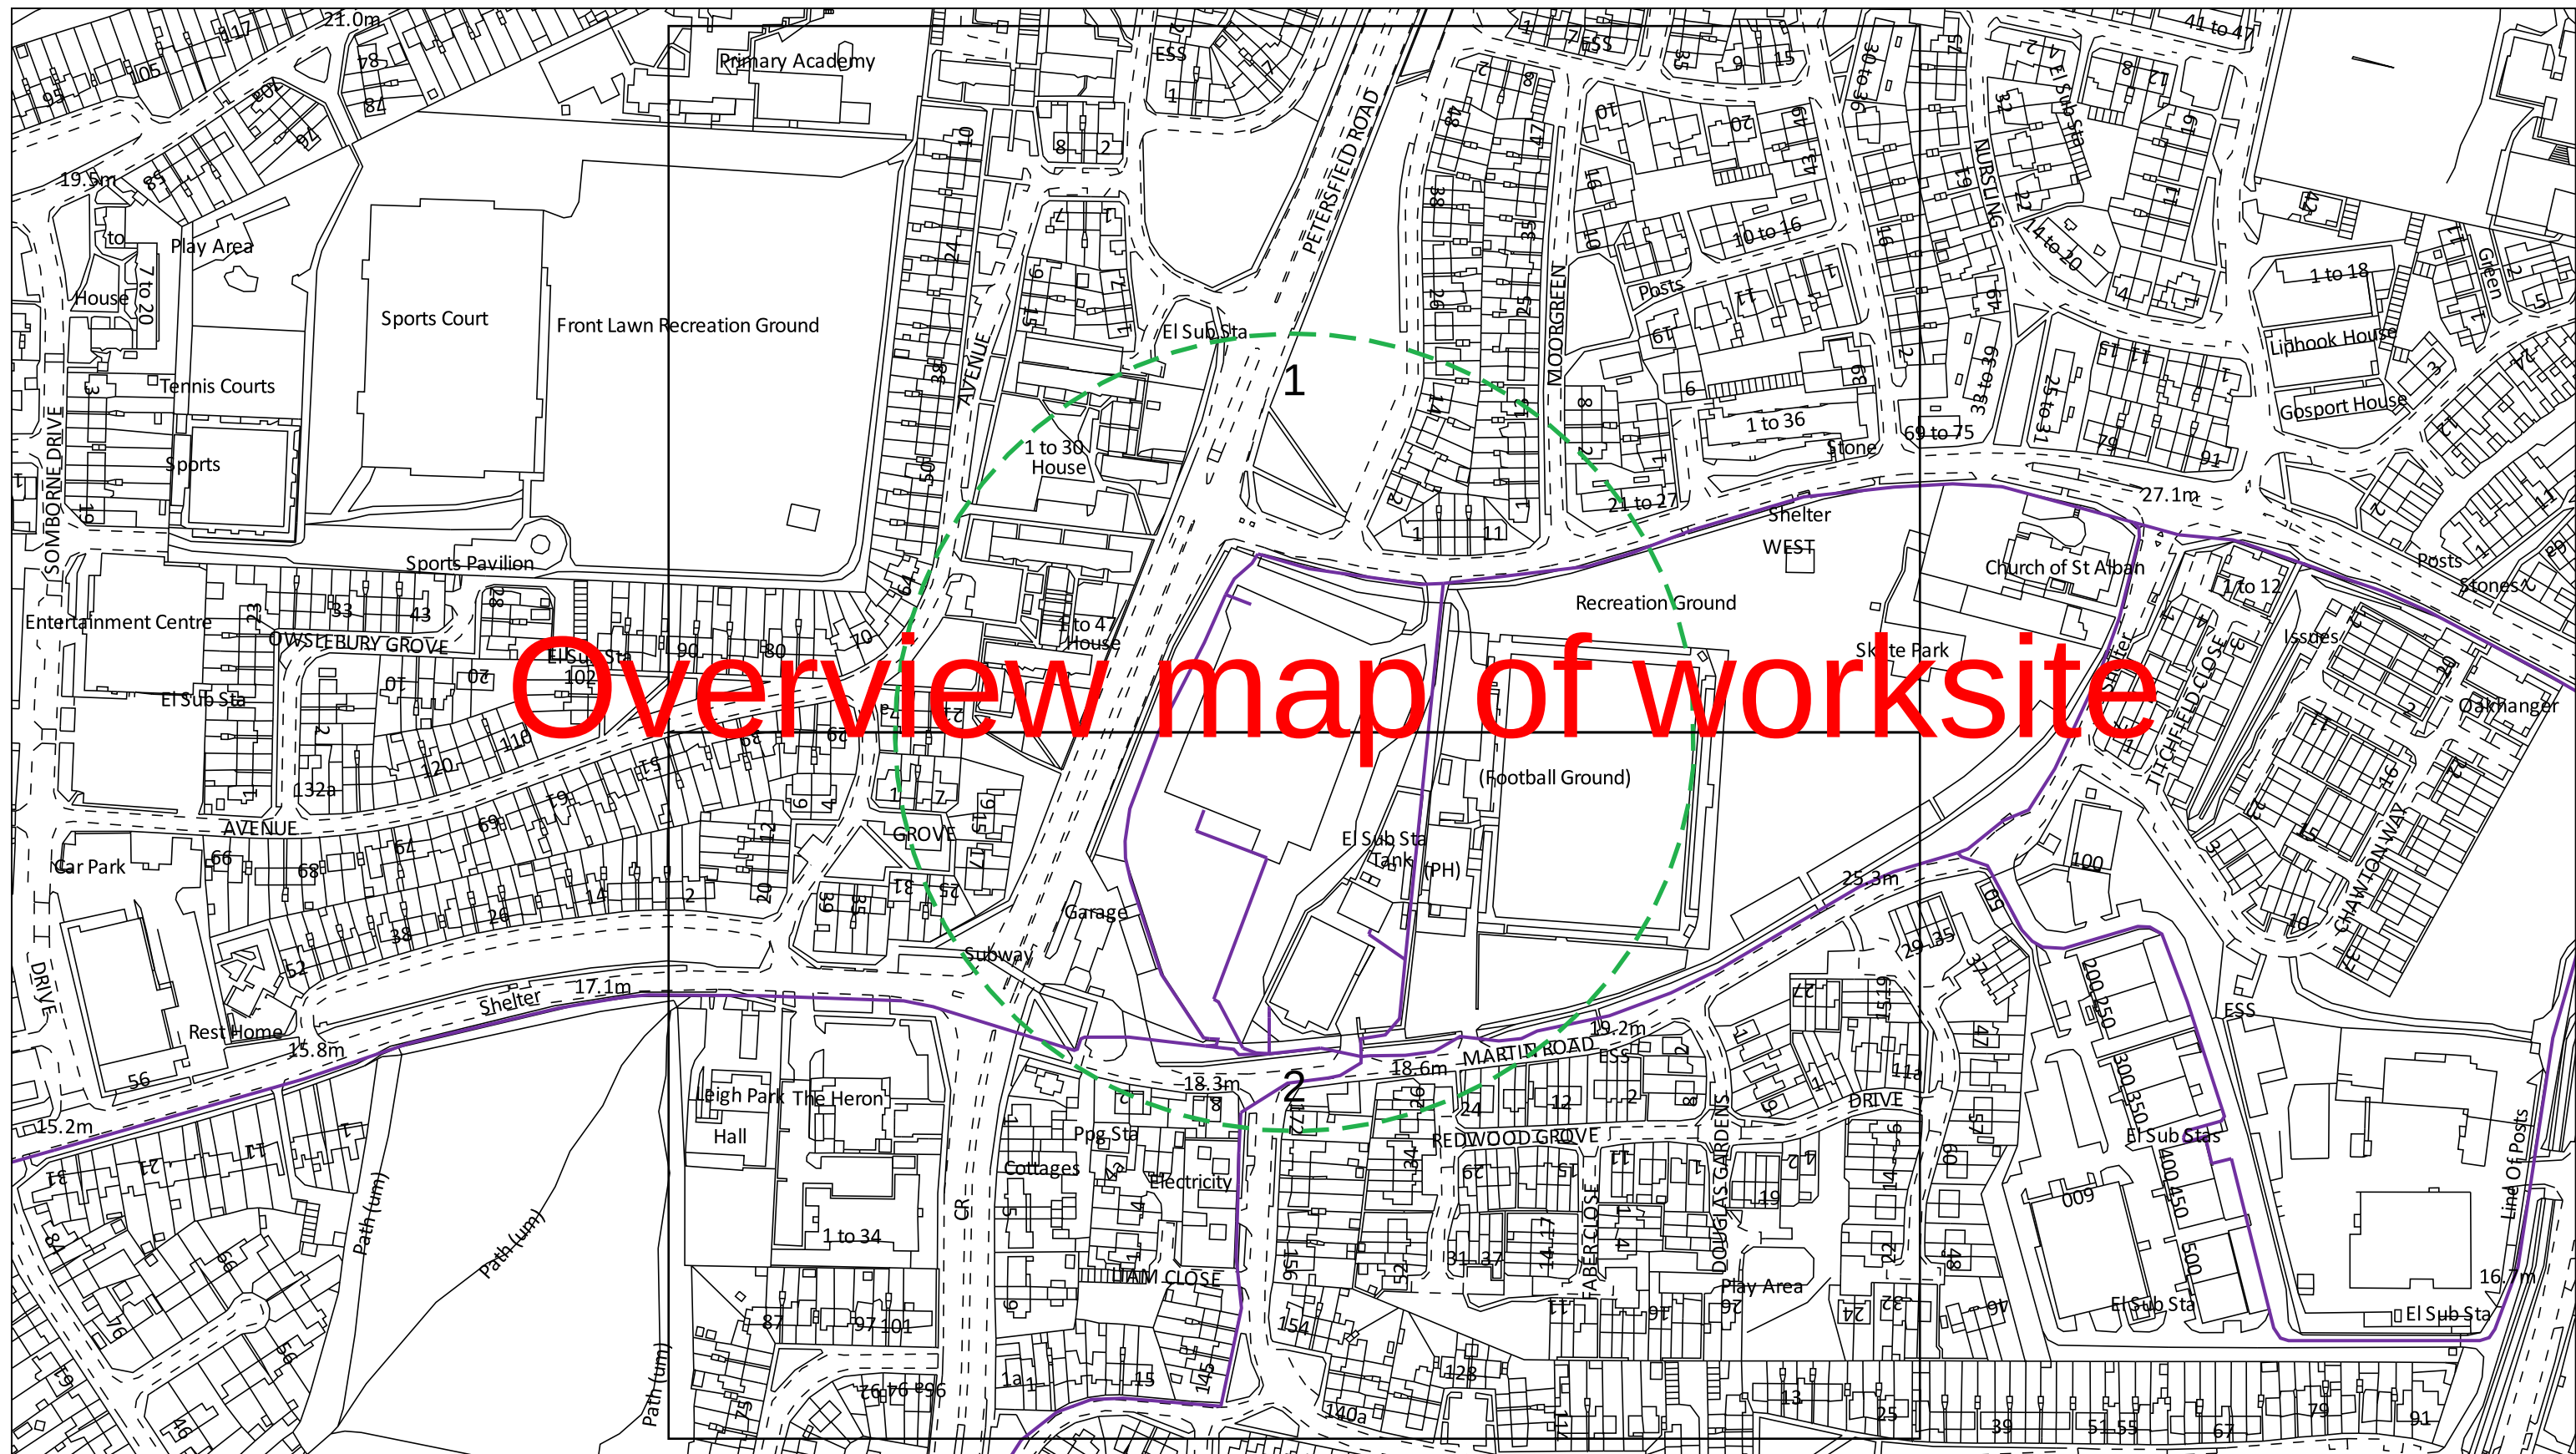

Dig Sites Area:  Line: 

The quality and accuracy of any print will depend on your printer, your computer and its print settings. Measurements scaled from this plan may not match measurements between the same points on the ground.

Date Requested: 13/03/2025
Job Reference: 36616240
Site Location: 472167 108026

Requested by:
Mr TDS Southern
Your Scheme/Reference: SBL.U.01

The information on this document is proprietary and shall not be used, copied, reproduced or disclosed in whole or in part without written consent of Neos Networks. Approximate location only is shown. To determine exact location a trial hole must be dug. Before excavation, please refer to HSG47. Neos Networks accept no liability for errors or omissions.

Scale: 1:2562 (When plotted at A3)

Neos Network Underground Route

Emergency Number: 0345 305 3337



Registered Office:

Inveralmond House,
200 Dunkeld Road,
Perth, PH1 3AQ

Some of the material on this plot has been reproduced from an Ordnance Survey map with permission of the Controller of Her Majesty's Stationery Office, © Crown Copyright. Licence No. 0100048661
Warning: PDF designed for colour print only with no page scaling. This Information is given as a guide only and its accuracy cannot be guaranteed
Plans generated by DigSAFE Pro™ software provided by LinesearchbeforeUdig.



bitmap_layout select_raster

LEGEND

- EXISTING PLANT
- EXISTING PLANT

bitmap_layout select_raster

Head Office
CityFibre Holdings Ltd
15 Bedford Street,
London,
WC2E 9HE
Tel: 0845 293 0774
Web: www.cityfibre.com

Asset Office
CityFibre Holdings Ltd,
Rutherford House,
Birchwood,
Warrington,
WA3 6ZH
Email: asset.team@cityfibre.com

Disclaimer:
Information shown on this plan is for general guidance only.
No warranty is made as to its accuracy.
This plan must not be solely relied upon in the event of
excavation or other works being carried out in the vicinity
of Cityfibre plant.
No liability of any kind is accepted by Cityfibre, its agents or
servants for any error, omission, discrepancy or
deviation. This information is valid for the date printed.


Project
Plant Enquiry

Drawing
Existing Plant

Drawn by:
smallworld
Date: 26/06/2024

Drawing No.
CFH_EP_000001
Revision
001



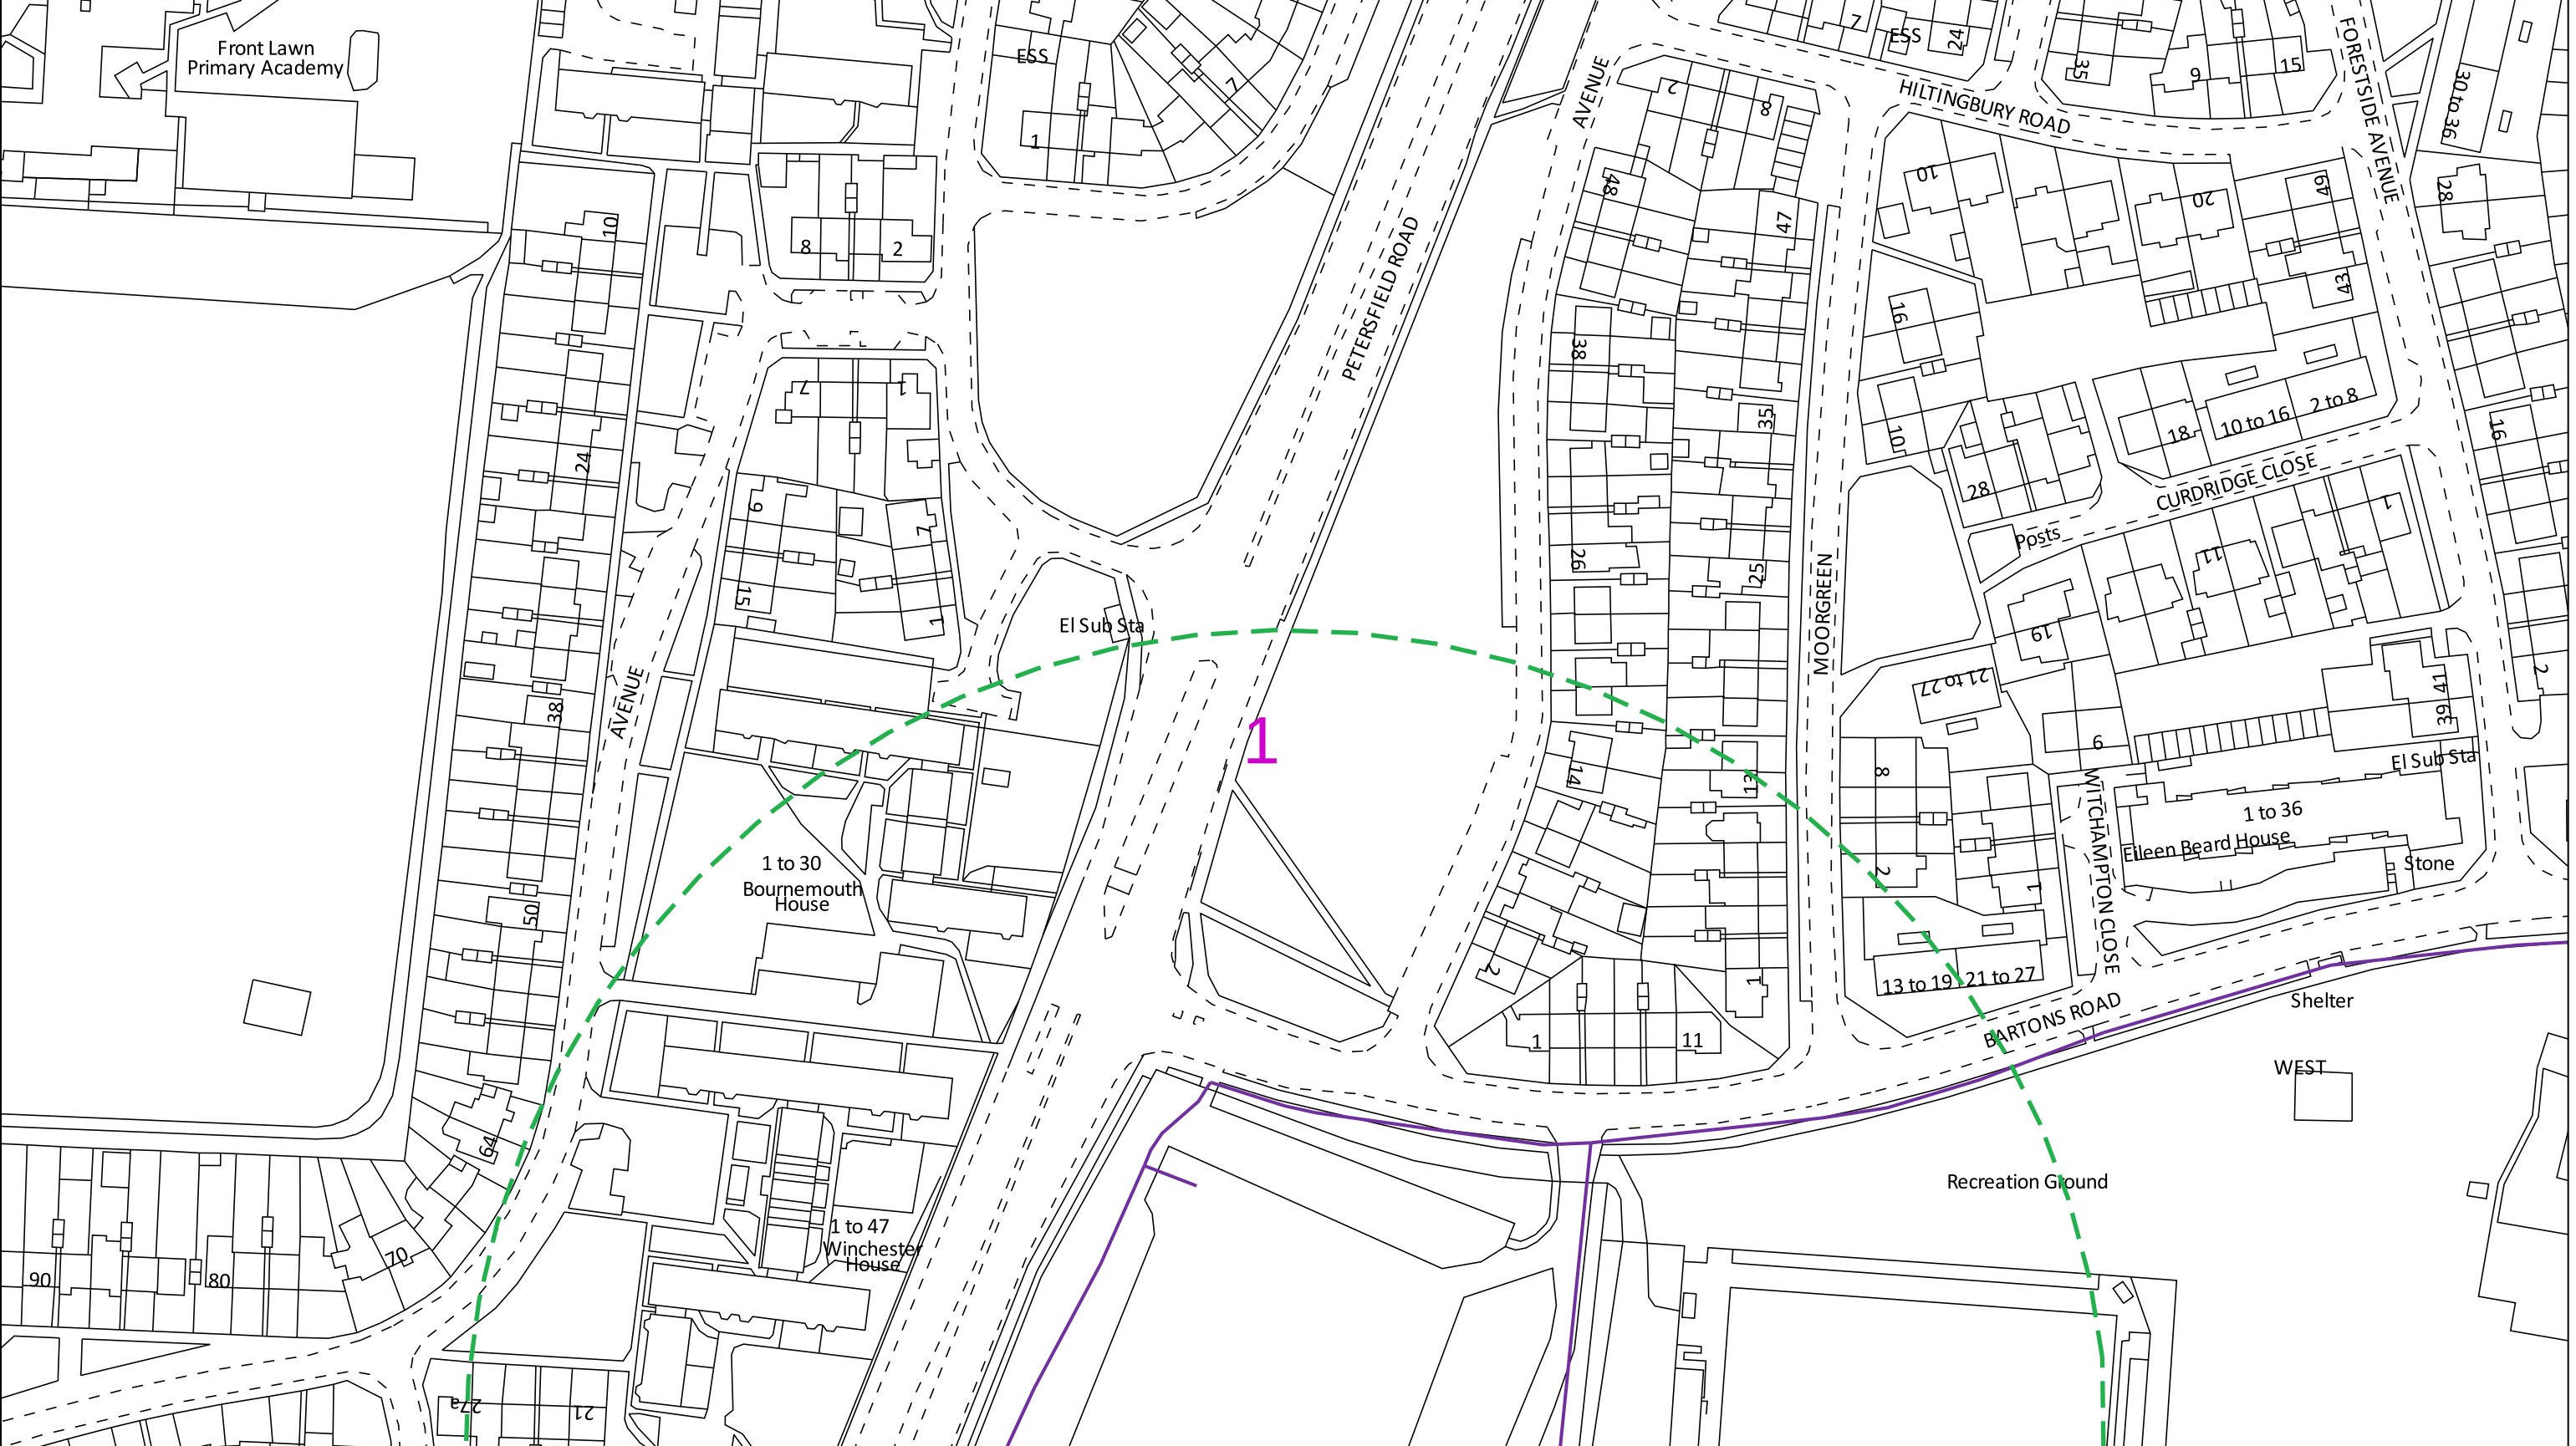

0 100 m

Date Requested: 13/03/2025
Job Reference: 36616240
Site Location: 472167 108026

Requested by:
Mr TDS Southern
Your Scheme/Reference: SBL.U.01

Scale: 1:1250 (When plotted at A3)

The information on this document is proprietary and shall not be used, copied, reproduced or disclosed in whole or in part without written consent of Neos Networks. Approximate location only is shown. To determine exact location a trial hole must be dug. Before excavation, please refer to HSG47. Neos Networks accept no liability for errors or omissions.

Registered Office:


Inveralmond House,
200 Dunkeld Road,
Perth, PH1 3AQ

Dig Sites Area: Line:

Neos Network Underground Route

Emergency Number: 0345 305 3337

Some of the material on this plot has been reproduced from an Ordnance Survey map with permission of the Controller of Her Majesty's Stationery Office, © Crown Copyright. Licence No. 0100048661
Warning: PDF designed for colour print only with no page scaling. This information is given as a guide only and its accuracy cannot be guaranteed
Plans generated by DigSAFE Pro™ software provided by LinesearchbeforeUdig.

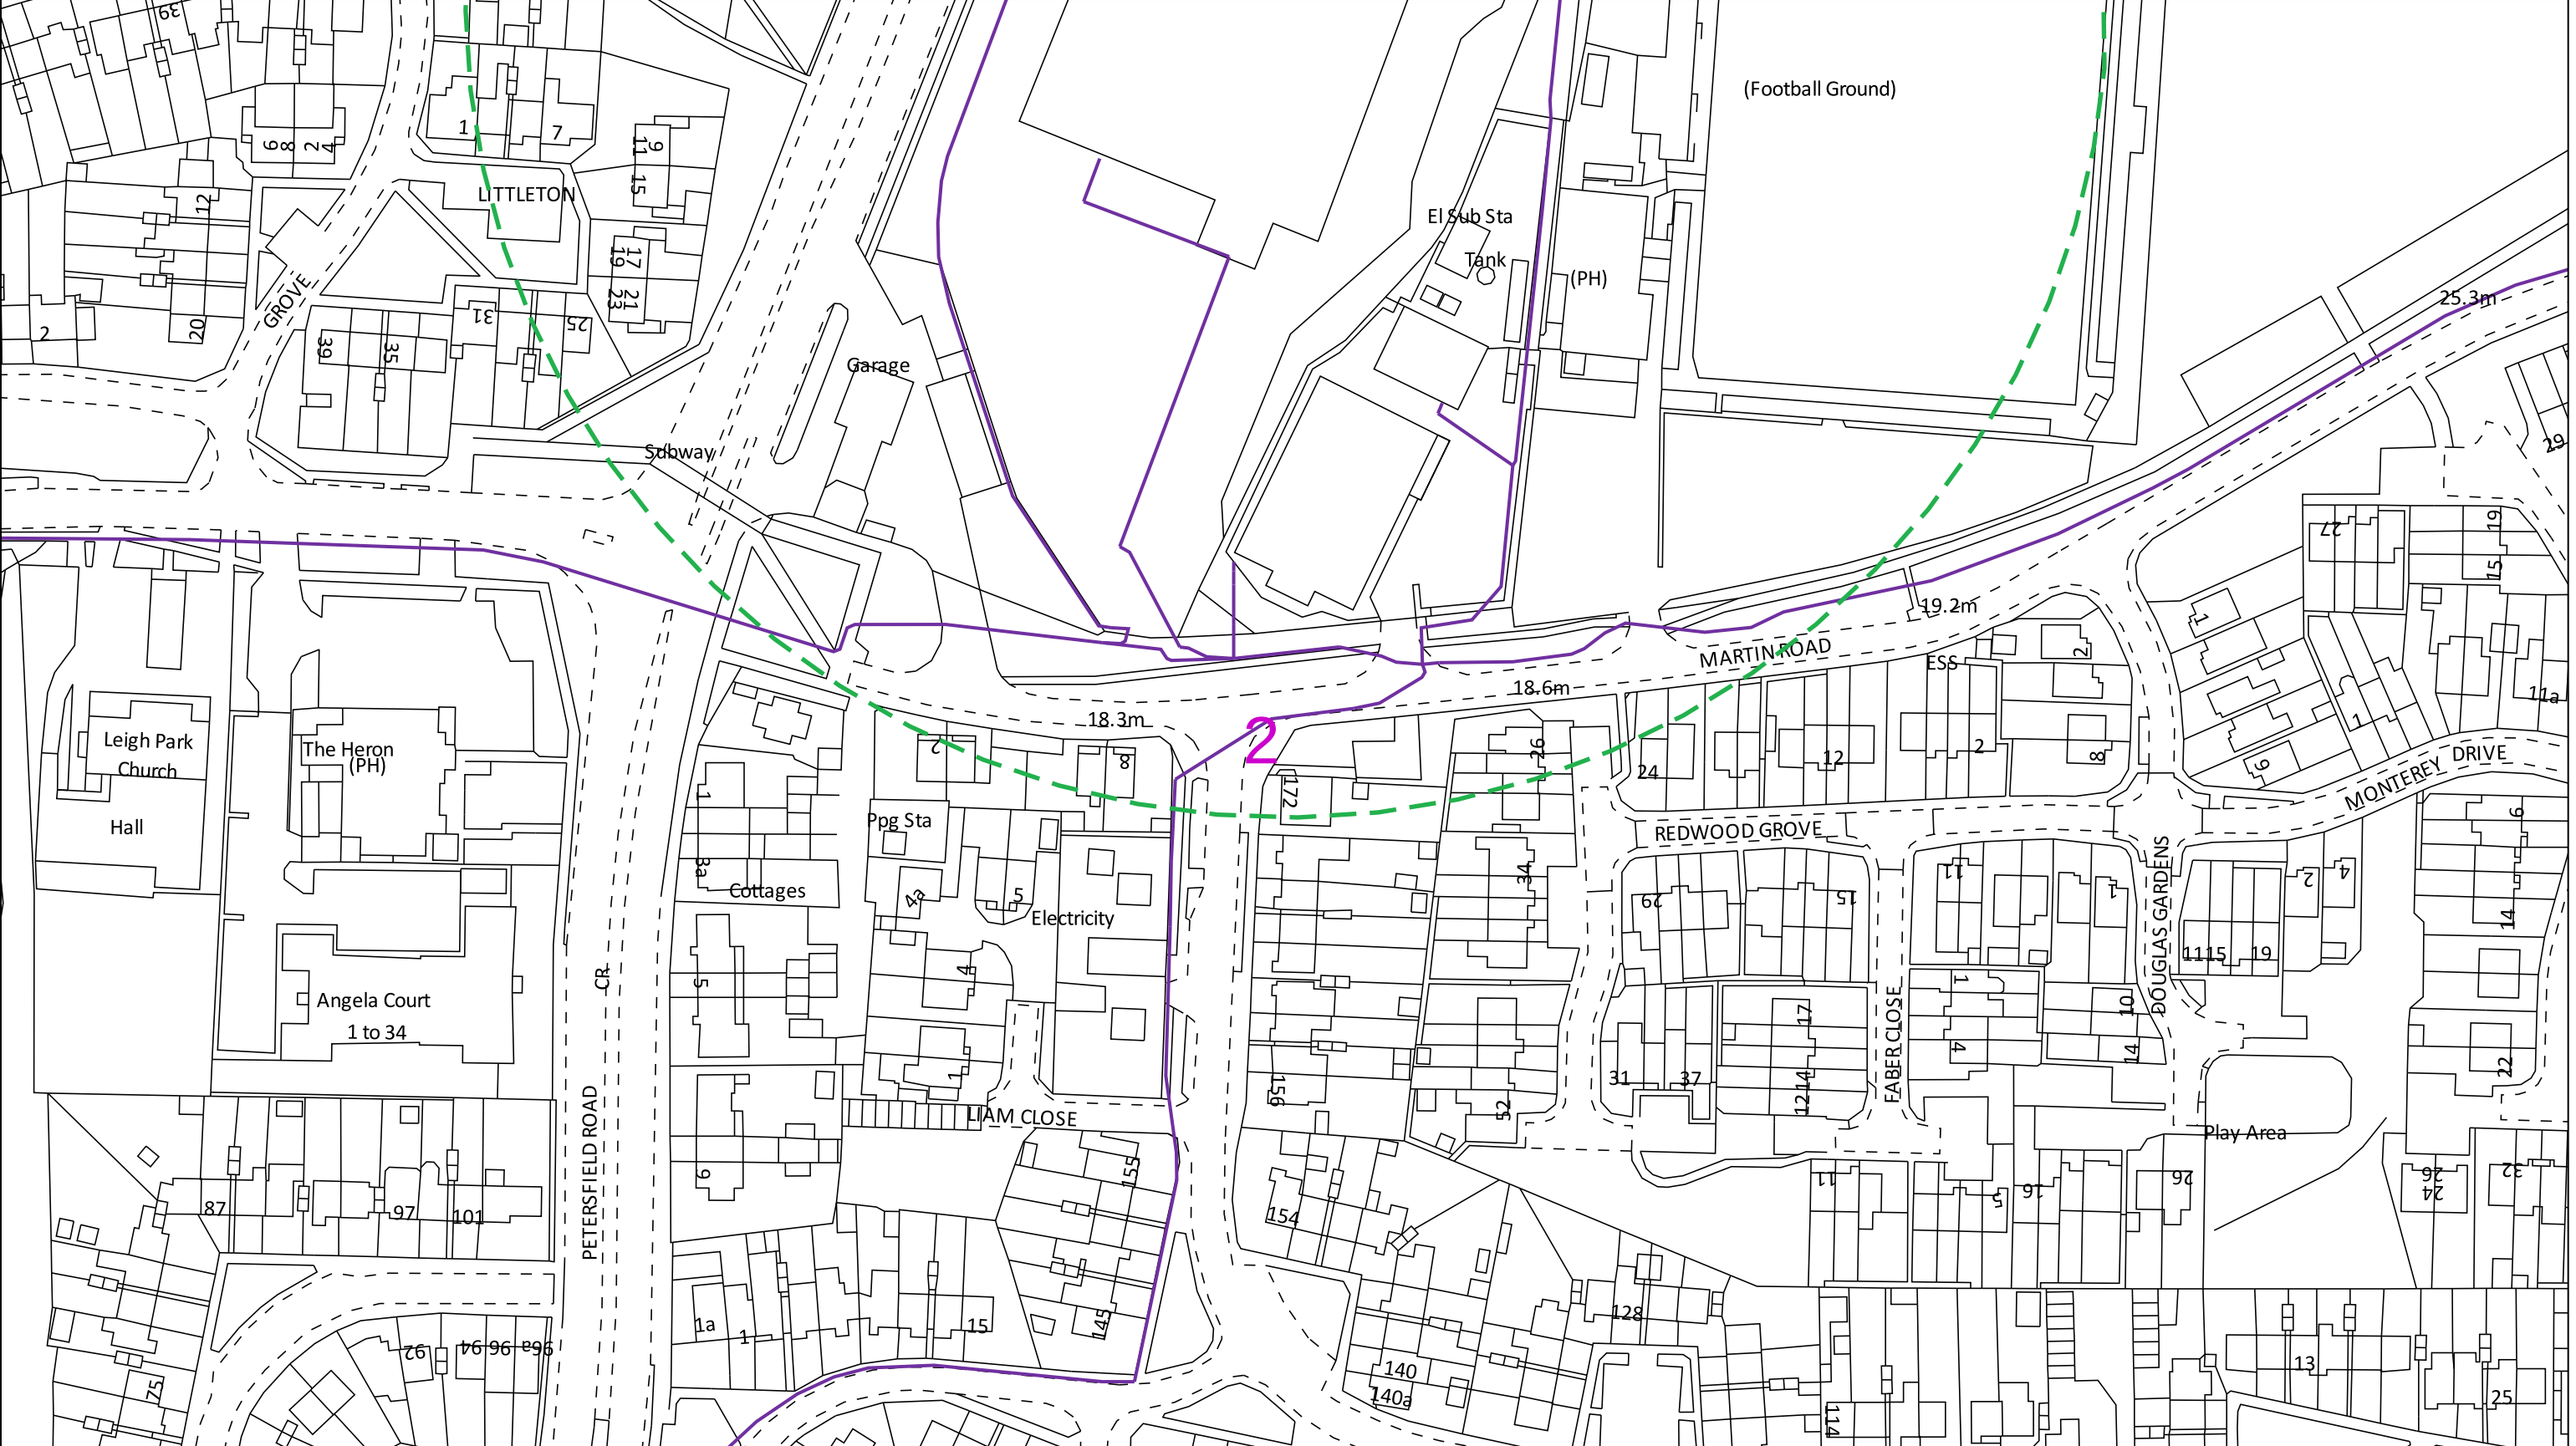

0100m

Date Requested: 13/03/2025

Job Reference: 36616240

Site Location: 472167 108026

Requested by:

Mr TDS Southern

Your Scheme/Reference: SBL.U.01

Scale: 1:1250 (When plotted at A3)

The information on this document is proprietary and shall not be used, copied, reproduced or disclosed in whole or in part without written consent of Neos Networks. Approximate location only is shown. To determine exact location a trial hole must be dug. Before excavation, please refer to HSG47. Neos Networks accept no liability for errors or omissions.

Neos Network Underground Route

Emergency Number: 0345 305 3337

N

E

S

W

NEOS

NETWORKS

Registered Office:

Inveralmond House,

200 Dunkeld Road,

Perth, PH1 3AQ

The quality and accuracy of any print will depend on your printer, your computer and its print settings. Measurements scaled from this plan may not match measurements between the same points on the ground.

Some of the material on this plot has been reproduced from an Ordnance Survey map with permission of the Controller of Her Majesty's Stationery Office, © Crown Copyright. Licence No. 0100048661

Warning: PDF designed for colour print only with no page scaling. This information is given as a guide only and its accuracy cannot be guaranteed

Plans generated by DigSAFE Pro™ software provided by LinesearchbeforeUdig.

Technical & Development Services (Southern) Ltd
Hillreed House,
54 Queen Street
Horsham
West Sussex RH13 5AD

01403 276 888
southern@t-d-s.com
www.t-d-s-com



Part of Technical & Development Services Group Ltd. Registered in England & Wales No. 5284938.
Registered Office: Venture Court, 2 Debdale Road, Wellingborough, Northants NN8 5AA