


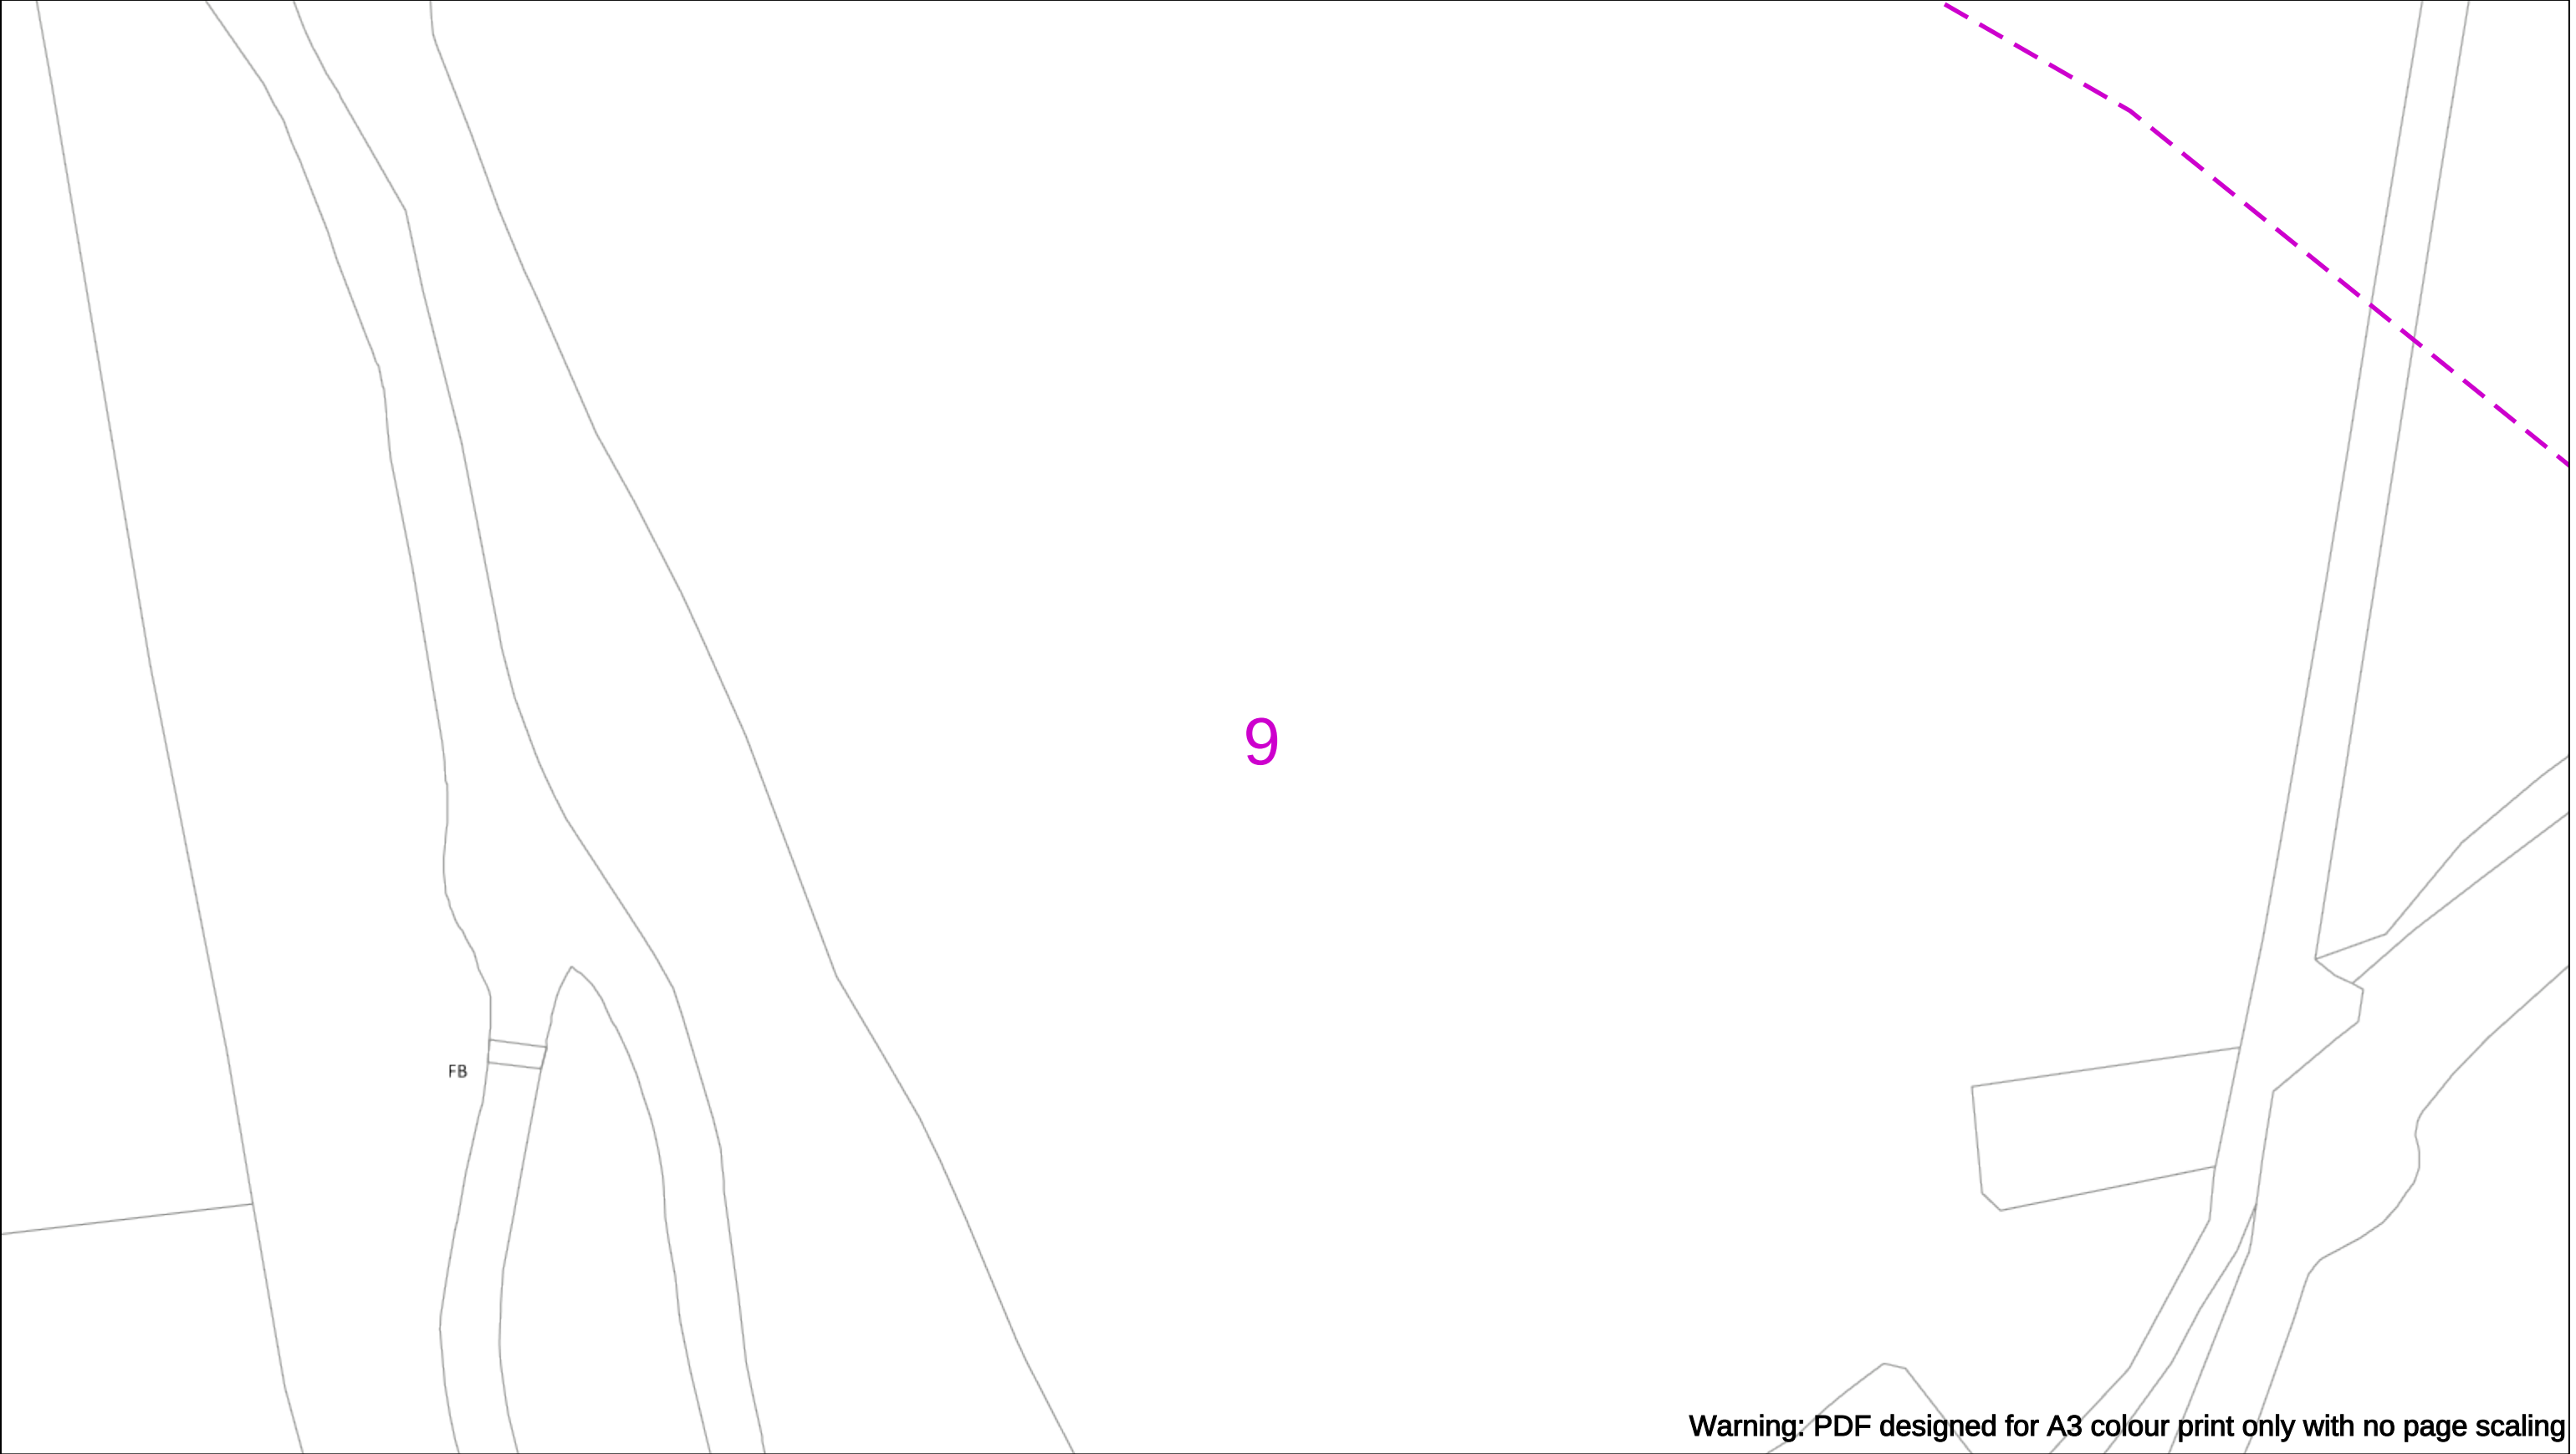

Warning: PDF designed for A3 colour print only with no page scaling

050m

Dig Sites

Area:

Line:

Extra High Voltage cables in vicinity

Date Requested: 03/09/2021

Job Reference: 23169206

Site Location: 471818 104822

Requested by:

Miss Rebecca Dabbs

Your Scheme/Reference: 736036

Langstone Flood & Coastal

WARNING

There may have been subsequent alteration to the surface levels. Trial holes must be undertaken to determine position and depths of cables. HS (G) 47 Booklet from the Health and Safety Executive – Avoiding Danger from Buried Cables – should be consulted before commencing excavation work.

WHEN WORKING IN THE VICINITY OF OVERHEAD LINES THE HEALTH AND SAFETY GUIDANCE NOTES GS6 SHOULD BE CONSULTED (AVAILABLE FROM THE HSE WEBSITE)

Voltages (V)				
LV (Low Voltage) and Services	Up to 1,000V			
HV (High Voltage)	Over 1,000V to 11,000V			
EHV (Extra High Voltage)	22,000V to 132,000V			
Transmission	275,000V and 400,000V			

NORMAL DEPTH TO THE TOP OF THE CABLE WHEN LAID				
Services	LV	HV	EHV	
Footpath/Unmade	0.45m	0.45m	0.6m	0.8m
Road Crossing	0.6m	0.6m	0.75m	0.9m
Agricultural	1m	1m	1m	1.1m

Legend

Service Cable

LV Mains

2-33kV

66kV

132kV

220kV

330kV

660kV

1320kV

275kV

400kV

Fibre Optic

Pilot Cable

Pole, Existing Location

Pole Structure, Existing Location - Single

Pole Structure, Existing Location - H

Duct Route

Cross Section Route

Southern Electric Power Distribution plc

Registered Office: No.1 Forbury Place

43 Forbury Road Reading RG1 3JH

Registered In England & Wales No.04094290

If you're unsure & need to seek advice before commencing excavations please contact:

General Enquiries: 0800 048 3516

Subject to revision – Master held by SSEN Asset Data Team:


Asset.Data@sse.com

01256 337 294

Scale: 1:500 (When plotted at A3)

BASED UPON THE ORDNANCE SURVEY MAP WITH THE SANCTION OF THE CONTROLLER OF H.M STATIONERY OFFICE CROWN COPYRIGHT RESERVED.

This copy has been made by or with the authority of Scottish and Southern Energy Power Distribution Ltd. Pursuant to section 47 of the Copyright, Designs and Patents Act 1988 ('The Act'). Unless the Act provides a relevant exception to copyright the copy must not be copied without prior permission of the copyright owner. Plans generated by DigSAFE Pro™ software provided by LinesearchbeforeUdig.

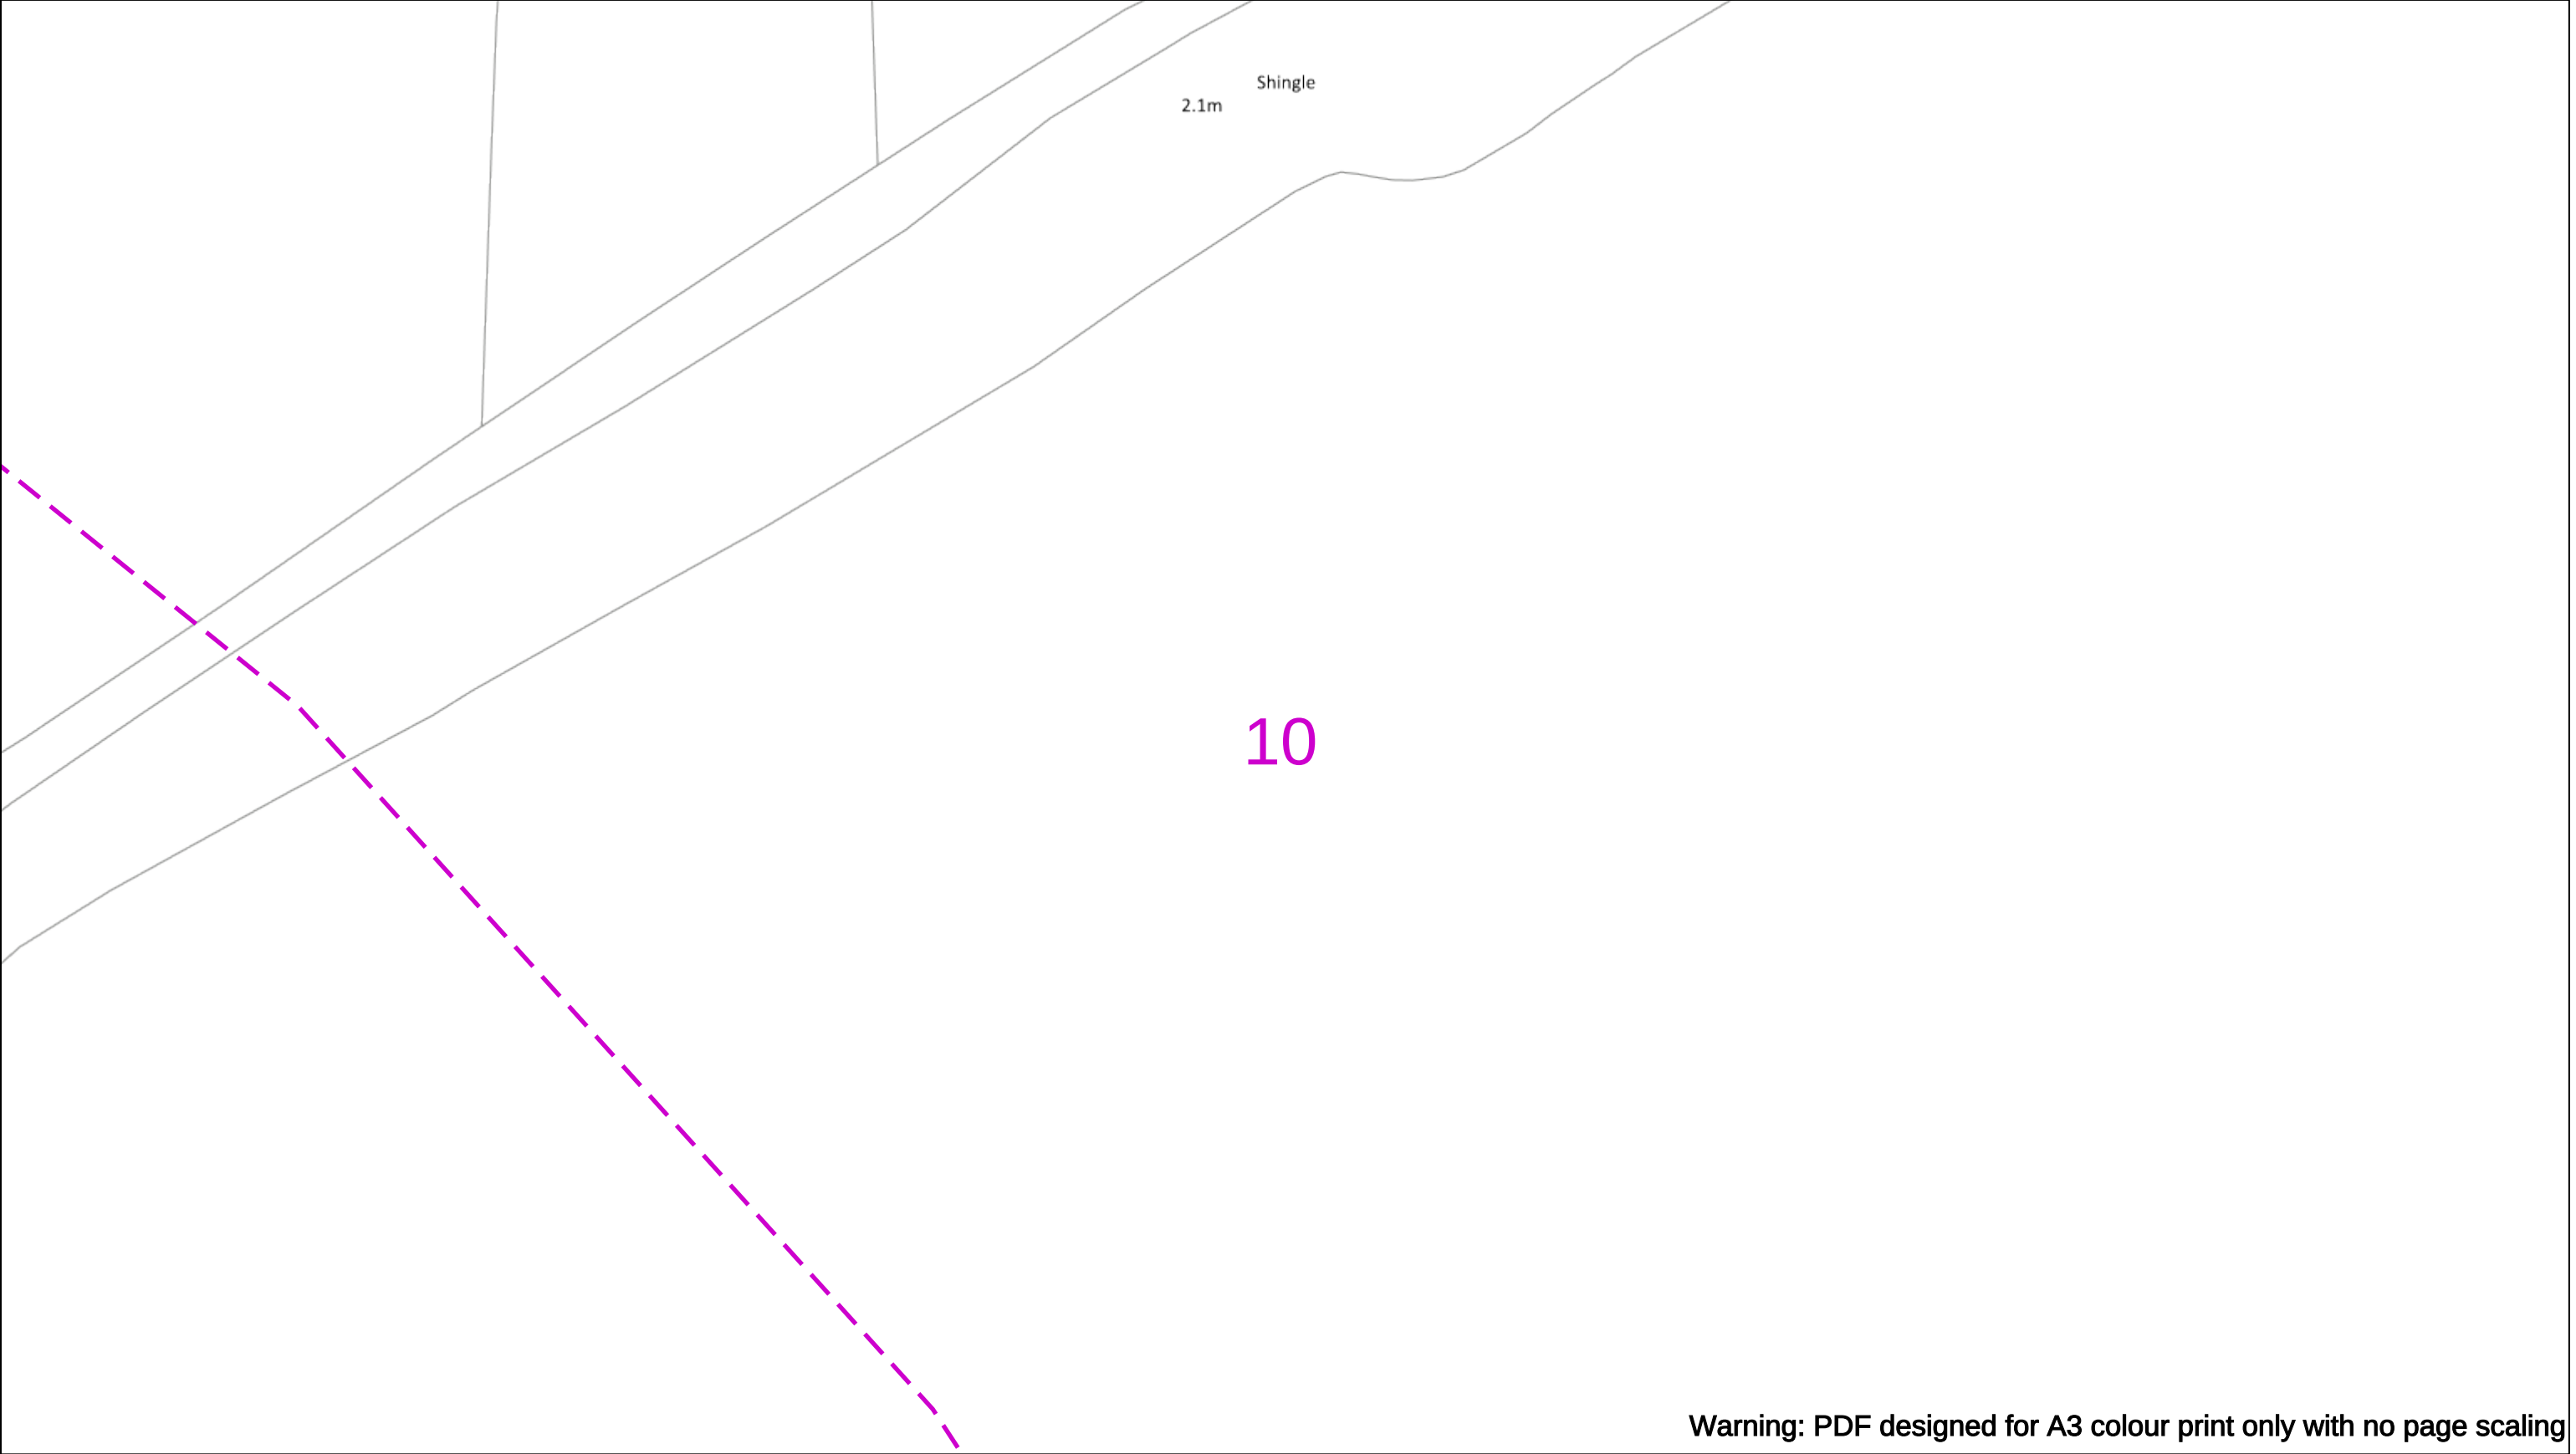

Warning: PDF designed for A3 colour print only with no page scaling

050m

Dig Sites

Area:

Line:

Extra High Voltage cables in vicinity

Date Requested: 03/09/2021

Job Reference: 23169206

Site Location: 471818 104822

Requested by:
Miss Rebecca Dabbs

Your Scheme/Reference: 736036

Langstone Flood & Coastal

WARNING

There may have been subsequent alteration to the surface levels. Trial holes must be undertaken to determine position and depths of cables. HS (G) 47 Booklet from the Health and Safety Executive – Avoiding Danger from Buried Cables – should be consulted before commencing excavation work.

WHEN WORKING IN THE VICINITY OF OVERHEAD LINES THE HEALTH AND SAFETY GUIDANCE NOTES GS6 SHOULD BE CONSULTED (AVAILABLE FROM THE HSE WEBSITE)

Voltages (V)				
LV (Low Voltage) and Services	Up to 1,000V			
HV (High Voltage)	Over 1,000V to 11,000V			
EHV (Extra High Voltage)	22,000V to 132,000V			
Transmission	275,000V and 400,000V			

NORMAL DEPTH TO THE TOP OF THE CABLE WHEN LAID				
	Services	LV	HV	EHV
Footpath/Unmade	0.45m	0.45m	0.6m	0.8m
Road Crossing	0.6m	0.6m	0.75m	0.9m
Agricultural	1m	1m	1m	1.1m

Legend

Service Cable

10/ Mains

2 – 33kV

6.6kV

13kV

23kV

33kV

66kV

132kV

275kV

400kV

Fibre Optic

Pilot Cable

Distribution Structures [Electric]

Pole, Existing Location

Pole Structure, Existing Location – Single

Pole Structure, Existing Location – H

Duct Route

Cross Section Route

Southern Electric Power Distribution plc

Registered Office: No.1 Forbury Place

43 Forbury Road Reading RG1 3JH

Registered In England & Wales No.04094290

If you're unsure & need to seek advice before commencing excavations please contact:

General Enquiries: 0800 048 3516

Subject to revision – Master held by SSEN Asset Data Team:

 
Asset.Data@sse.com


01256 337 294

Scale: 1:500 (When plotted at A3)

BASED UPON THE ORDNANCE SURVEY MAP WITH THE SANCTION OF THE CONTROLLER OF H.M STATIONERY OFFICE CROWN COPYRIGHT RESERVED.

This copy has been made by or with the authority of Scottish and Southern Energy Power Distribution Ltd. Pursuant to section 47 of the Copyright, Designs and Patents Act 1988 ('The Act'). Unless the Act provides a relevant exception to copyright the copy must not be copied without prior permission of the copyright owner. Plans generated by DigSAFE Pro™ software provided by LinesearchbeforeUdig.



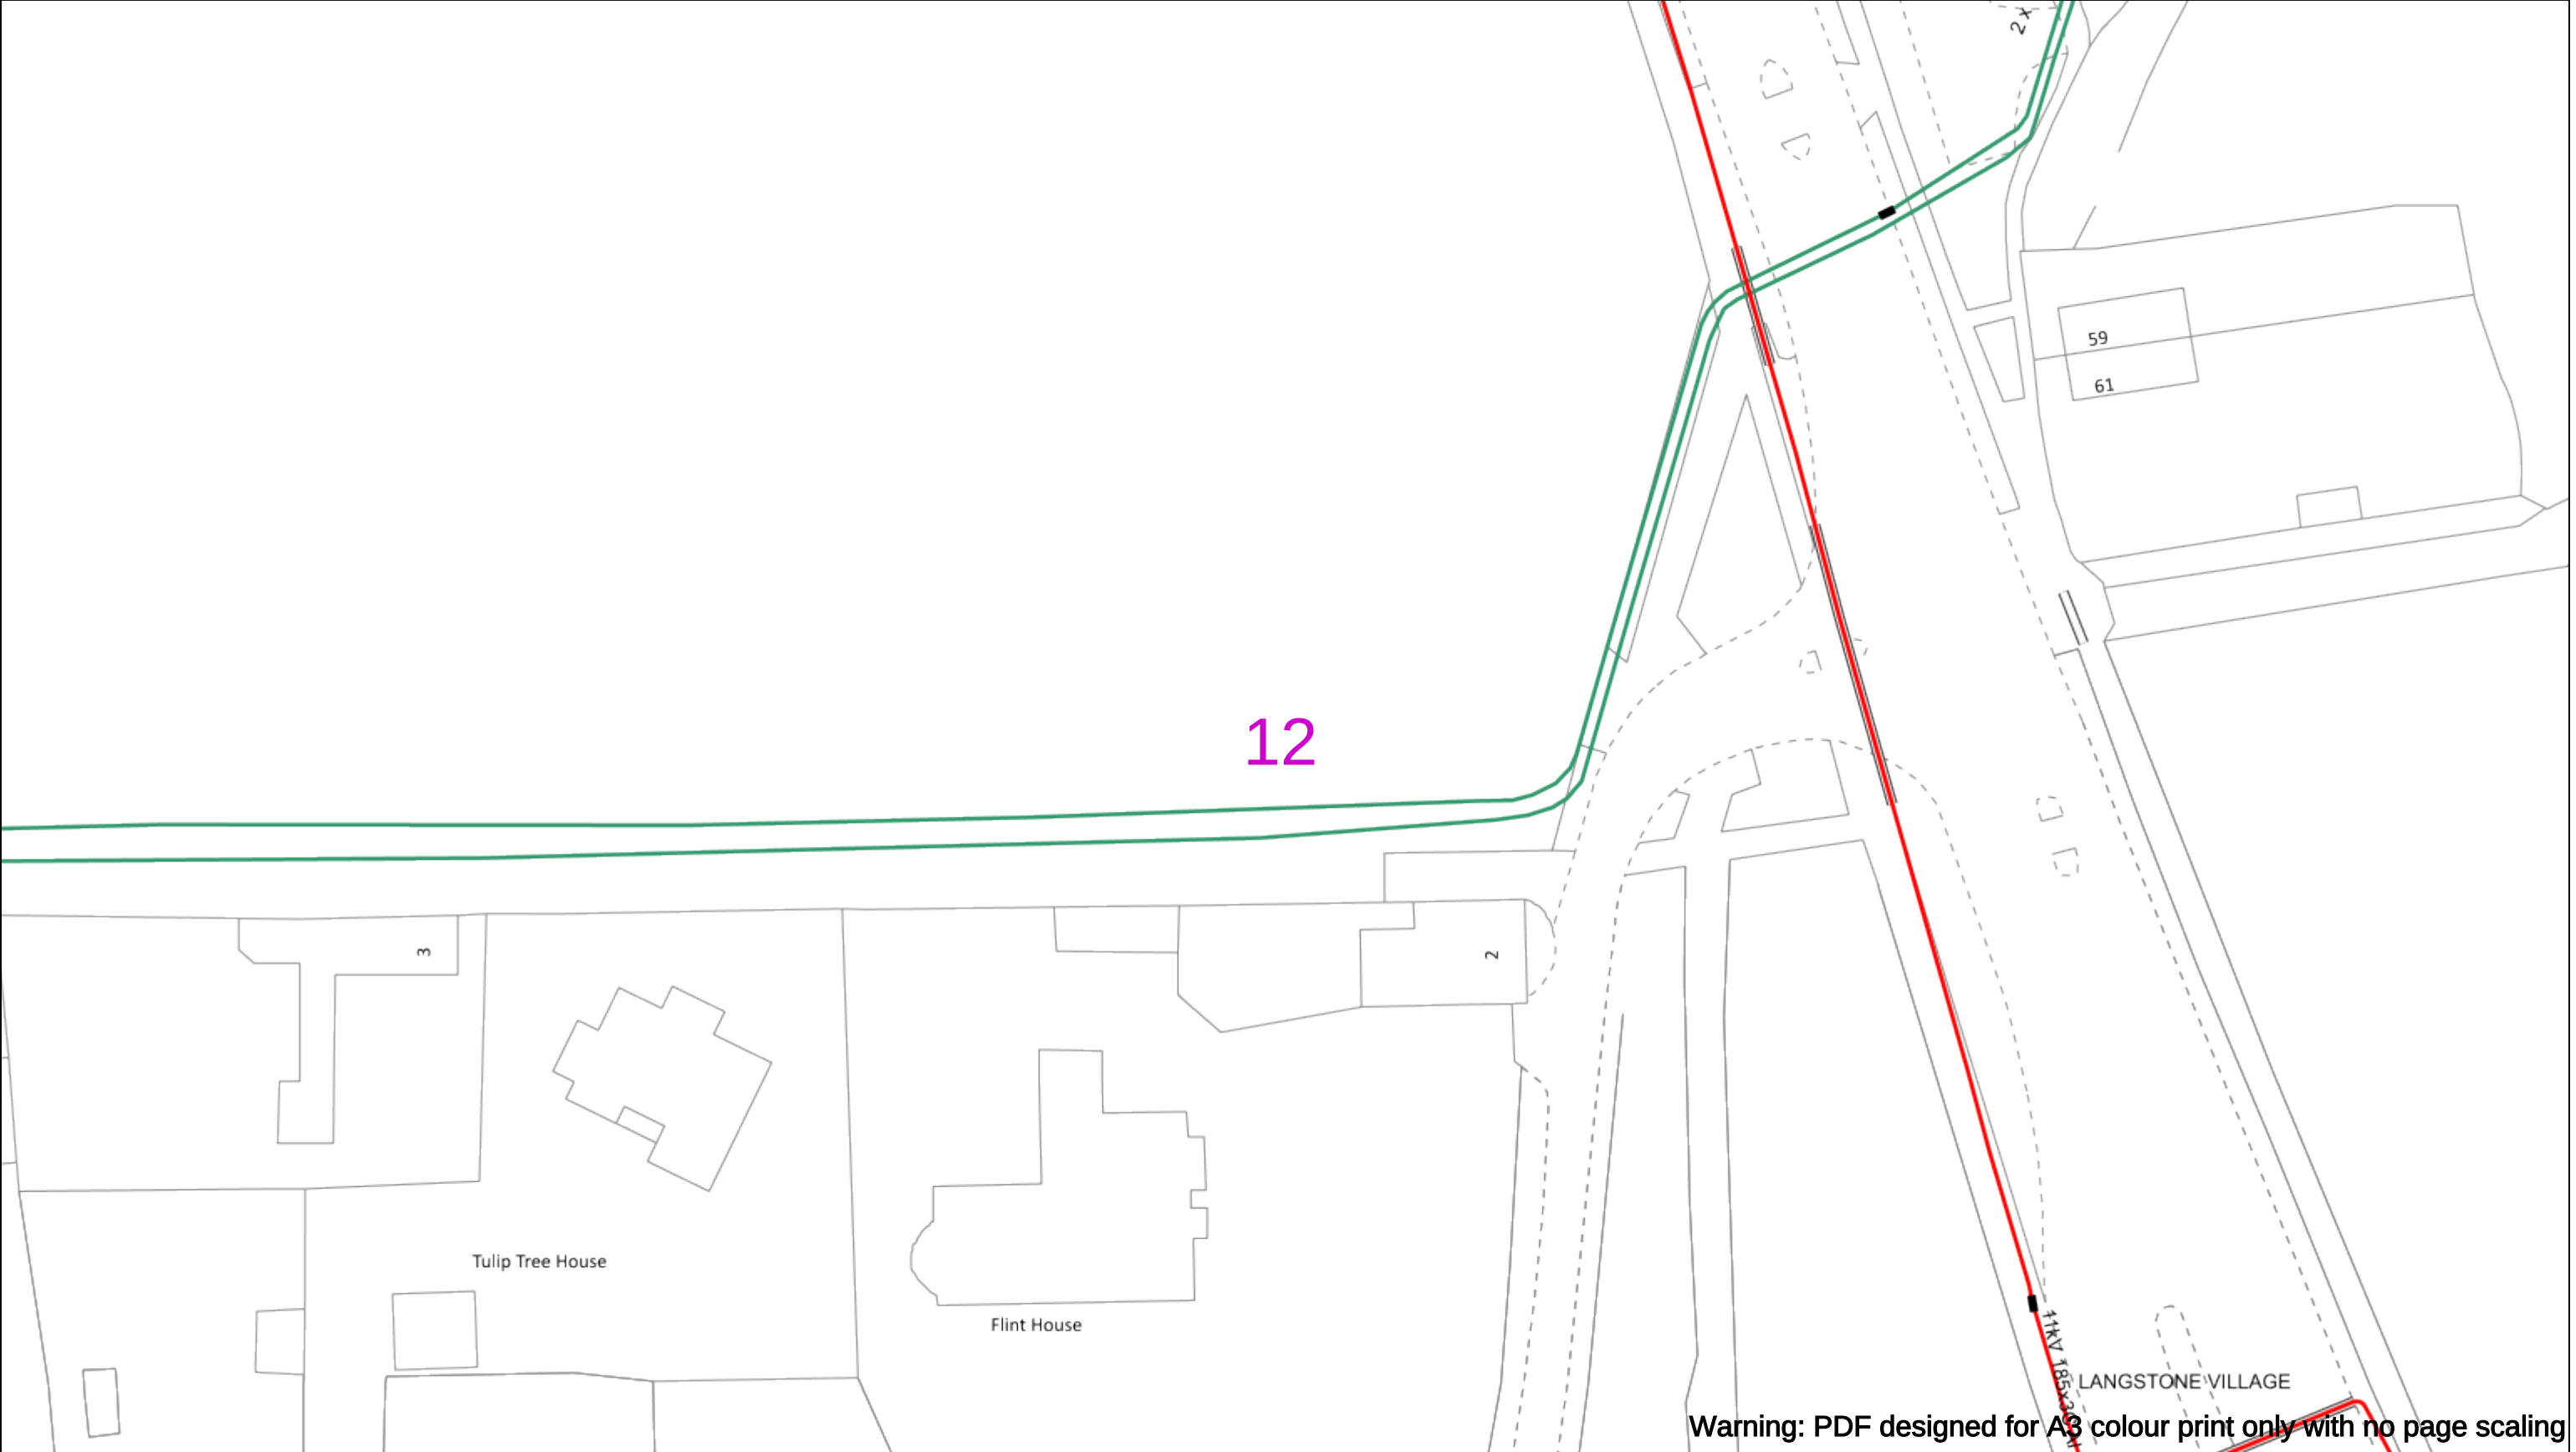

Warning: PDF designed for A3 colour print only with no page scaling

050m

Dig Sites

Area:

Line:

Extra High Voltage cables in vicinity

Date Requested: 03/09/2021
Job Reference: 23169206
Site Location: 471818 104822
Requested by:
Miss Rebecca Dabbs
Your Scheme/Reference: 736036
Langstone Flood & Coastal

WARNING

There may have been subsequent alteration to the surface levels. Trial holes must be undertaken to determine position and depths of cables. HS (G) 47 Booklet from the Health and Safety Executive – Avoiding Danger from Buried Cables – should be consulted before commencing excavation work.

WHEN WORKING IN THE VICINITY OF OVERHEAD LINES THE HEALTH AND SAFETY GUIDANCE NOTES GS6 SHOULD BE CONSULTED (AVAILABLE FROM THE HSE WEBSITE)

	Voltages (V)			
LV (Low Voltage) and Services	Up to 1,000V			
HV (High Voltage)	Over 1,000V to 11,000V			
EHV (Extra High Voltage)	22,000V to 132,000V			
Transmission	275,000V and 400,000V			

	NORMAL DEPTH TO THE TOP OF THE CABLE WHEN LAID			
	Services	LV	HV	EHV
Footpath/Unmade	0.45m	0.45m	0.6m	0.8m
Road Crossing	0.6m	0.6m	0.75m	0.9m
Agricultural	1m	1m	1m	1.1m

Legend

Service Cable

0V Mains

2-33kV

66kV

132kV

220kV

330kV

660kV

1320kV

275kV

400kV

Fibre Optic

Pilot Cable

Distribution Structures (Electric)

Pole, Existing Location

Pole Structure, Existing Location - Single

Pole Structure, Existing Location - H

Duct Route

Cross Section Route


Southern Electric Power Distribution plc

Registered Office: No.1 Forbury Place
43 Forbury Road Reading RG1 3JH
Registered In England & Wales No.04094290

If you're unsure & need to seek advice before commencing excavations please contact:
General Enquiries: 0800 048 3516

Subject to revision – Master held by SSEN Asset Data Team:
Asset.Data@sse.com
01256 337 294

BASED UPON THE ORDNANCE SURVEY MAP WITH THE SANCTION OF THE CONTROLLER OF H.M STATIONERY OFFICE CROWN COPYRIGHT RESERVED.
This copy has been made by or with the authority of Scottish and Southern Energy Power Distribution Ltd. Pursuant to section 47 of the Copyright, Designs and Patents Act 1988 ('The Act'). Unless the Act provides a relevant exception to copyright the copy must not be copied without prior permission of the copyright owner. Plans generated by DigSAFE Pro™ software provided by LinesearchbeforeUdig.

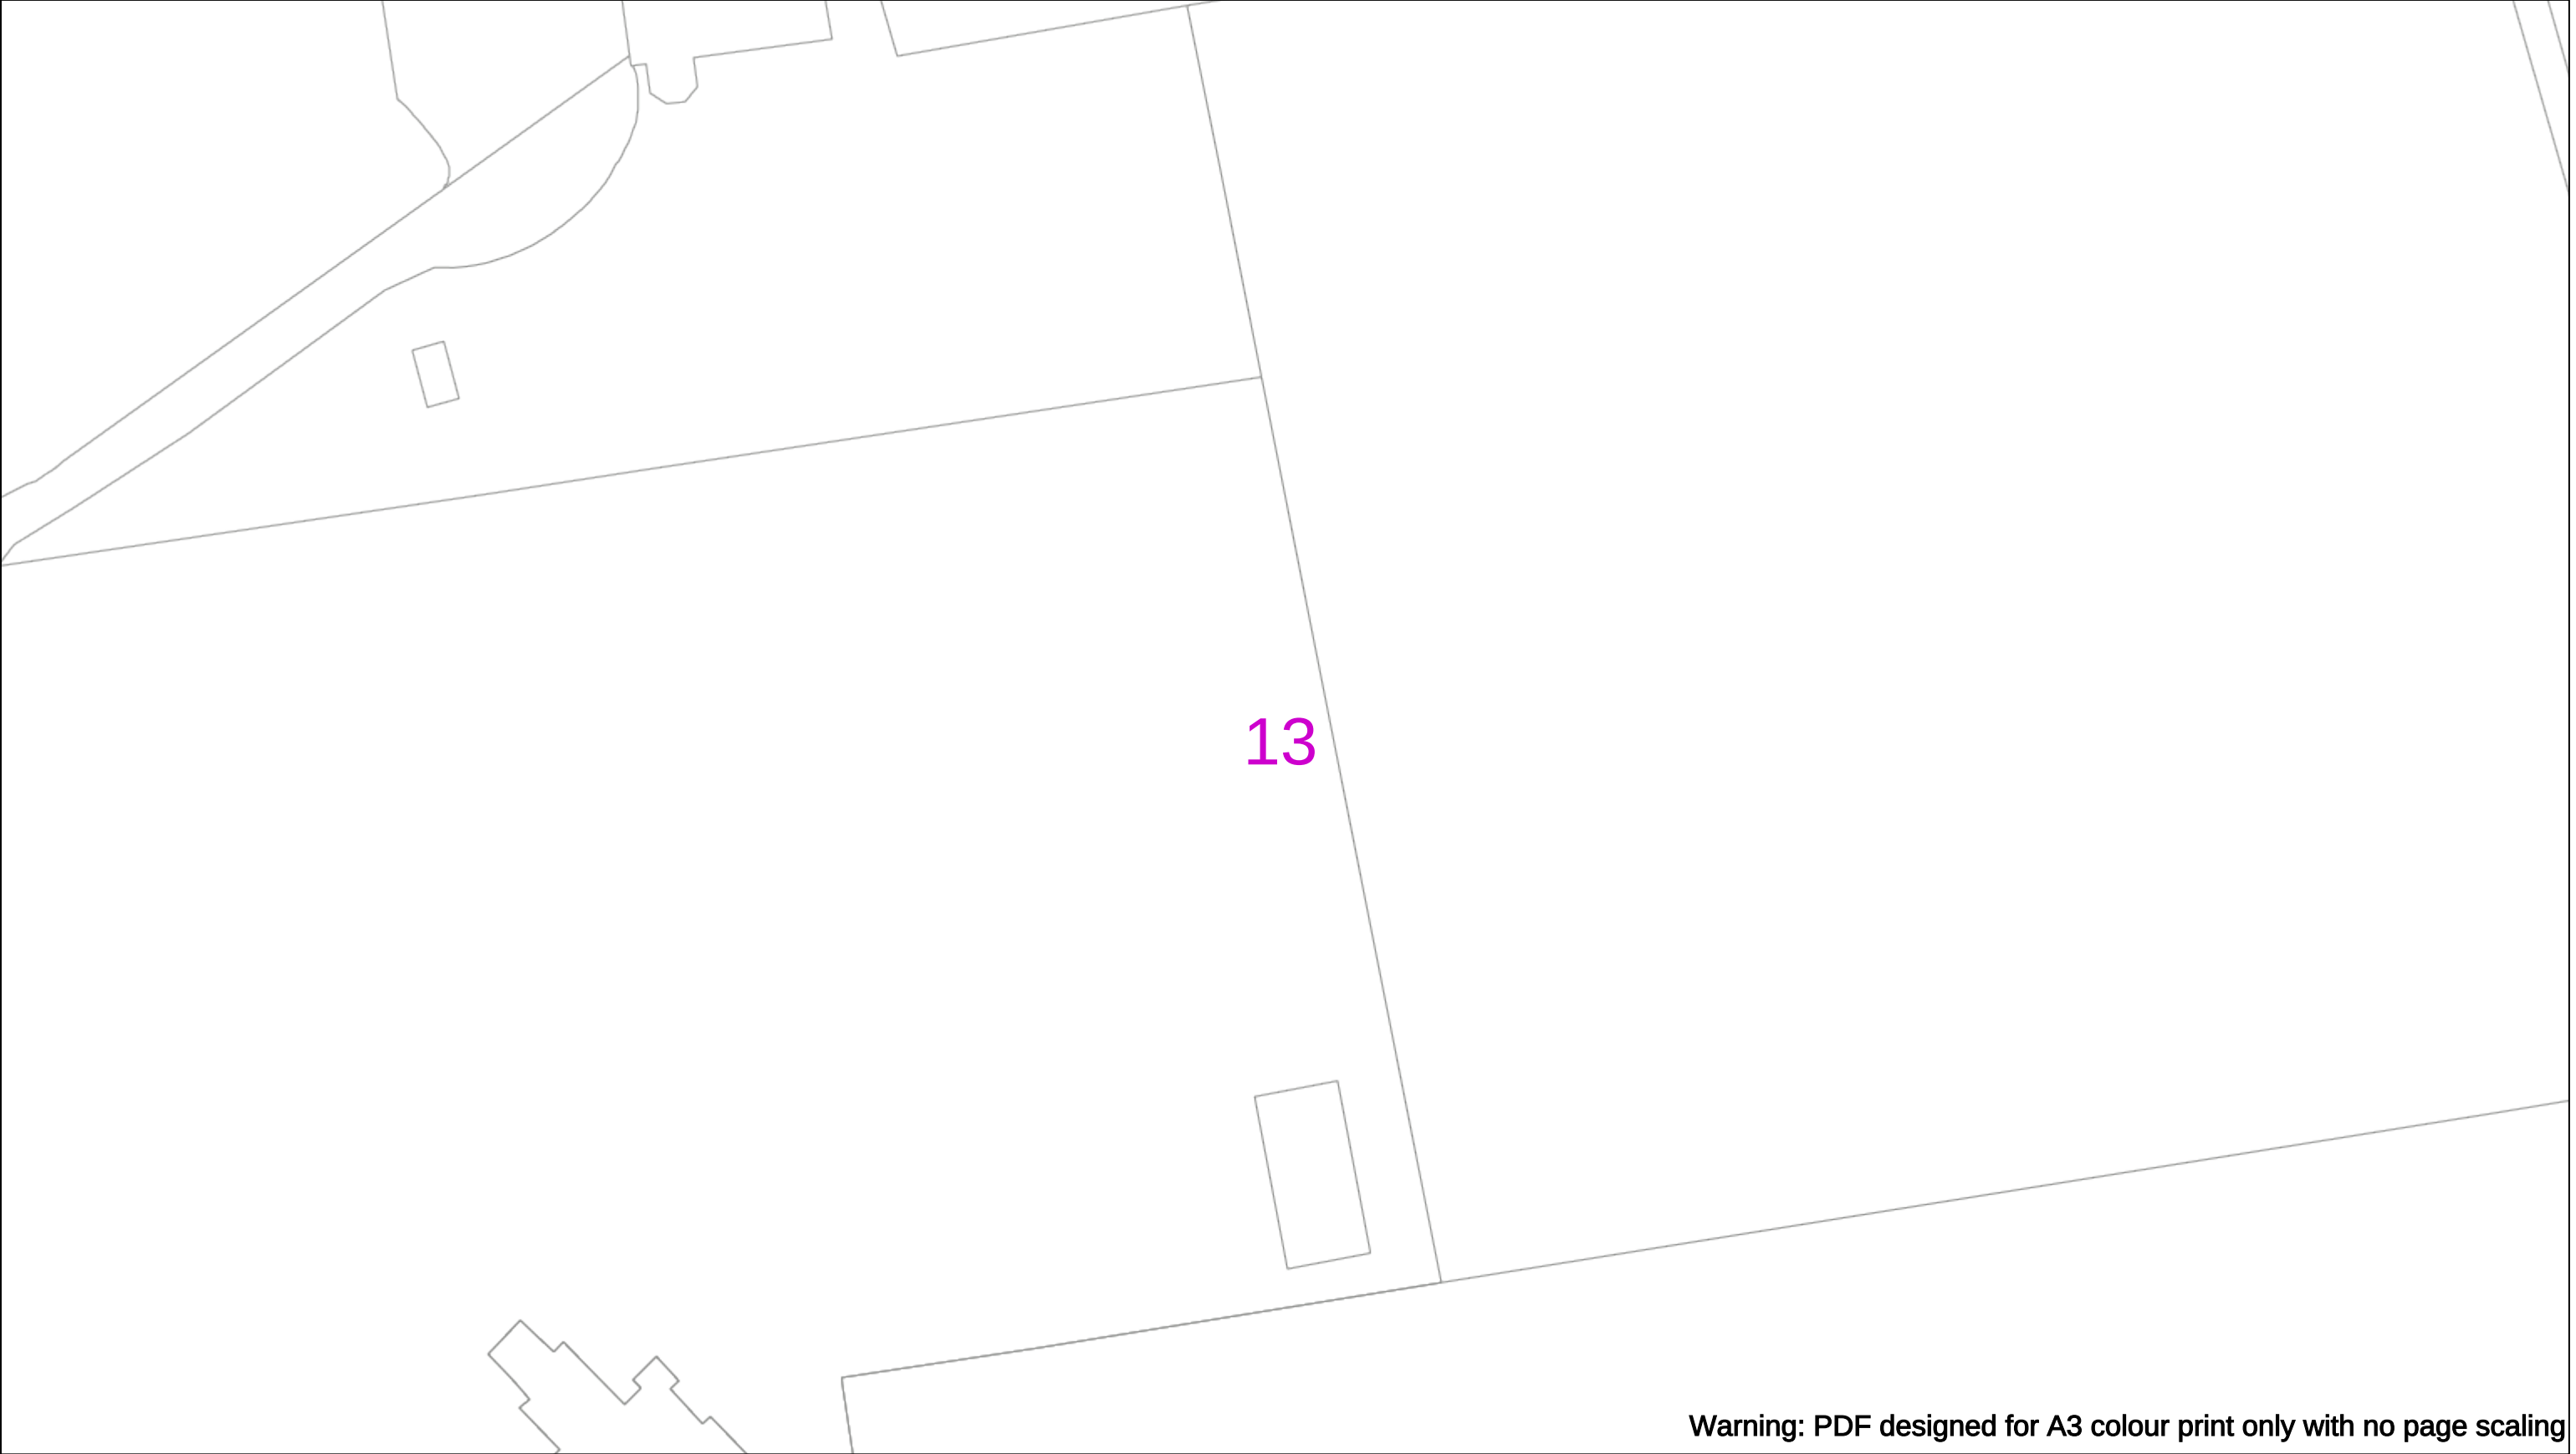

Warning: PDF designed for A3 colour print only with no page scaling

050m

Dig Sites

Area:

Line:

Extra High Voltage cables in vicinity

Date Requested: 03/09/2021

Job Reference: 23169206

Site Location: 471818 104822

Requested by:
Miss Rebecca Dabbs

Your Scheme/Reference: 736036

Langstone Flood & Coastal

WARNING

There may have been subsequent alteration to the surface levels. Trial holes must be undertaken to determine position and depths of cables. HS (G) 47 Booklet from the Health and Safety Executive – Avoiding Danger from Buried Cables – should be consulted before commencing excavation work.

WHEN WORKING IN THE VICINITY OF OVERHEAD LINES THE HEALTH AND SAFETY GUIDANCE NOTES GS6 SHOULD BE CONSULTED (AVAILABLE FROM THE HSE WEBSITE)

Voltages (V)				
LV (Low Voltage) and Services	Up to 1,000V			
HV (High Voltage)	Over 1,000V to 11,000V			
EHV (Extra High Voltage)	22,000V to 132,000V			
Transmission	275,000V and 400,000V			

NORMAL DEPTH TO THE TOP OF THE CABLE WHEN LAID				
Services	LV	HV	EHV	
Footpath/Unmade	0.45m	0.45m	0.6m	0.8m
Road Crossing	0.6m	0.6m	0.75m	0.9m
Agricultural	1m	1m	1m	1.1m

Legend

Service Cable

10/ Mains

2-3.3kV

6.6kV

11kV

22kV

33kV

66kV

132kV

275kV

400kV

Fibre Optic

Pilot Cable

Distribution Structures [Electric]

Pole, Existing Location

Pole Structure, Existing Location - Single

Pole Structure, Existing Location - H

Duct Route

Cross Section Route

Southern Electric Power Distribution plc

Registered Office: No.1 Forbury Place

43 Forbury Road Reading RG1 3JH

Registered In England & Wales No.04094290

If you're unsure & need to seek advice before commencing excavations please contact:

General Enquiries: 0800 048 3516


Subject to revision – Master held by SSEN Asset Data Team:

Asset.Data@sse.com


01256 337 294


BASED UPON THE ORDNANCE SURVEY MAP WITH THE SANCTION OF THE CONTROLLER OF H.M STATIONERY OFFICE CROWN COPYRIGHT RESERVED.

This copy has been made by or with the authority of Scottish and Southern Energy Power Distribution Ltd. Pursuant to section 47 of the Copyright, Designs and Patents Act 1988 ('The Act'). Unless the Act provides a relevant exception to copyright the copy must not be copied without prior permission of the copyright owner. Plans generated by DigSAFE Pro™ software provided by LinesearchbeforeUdig.

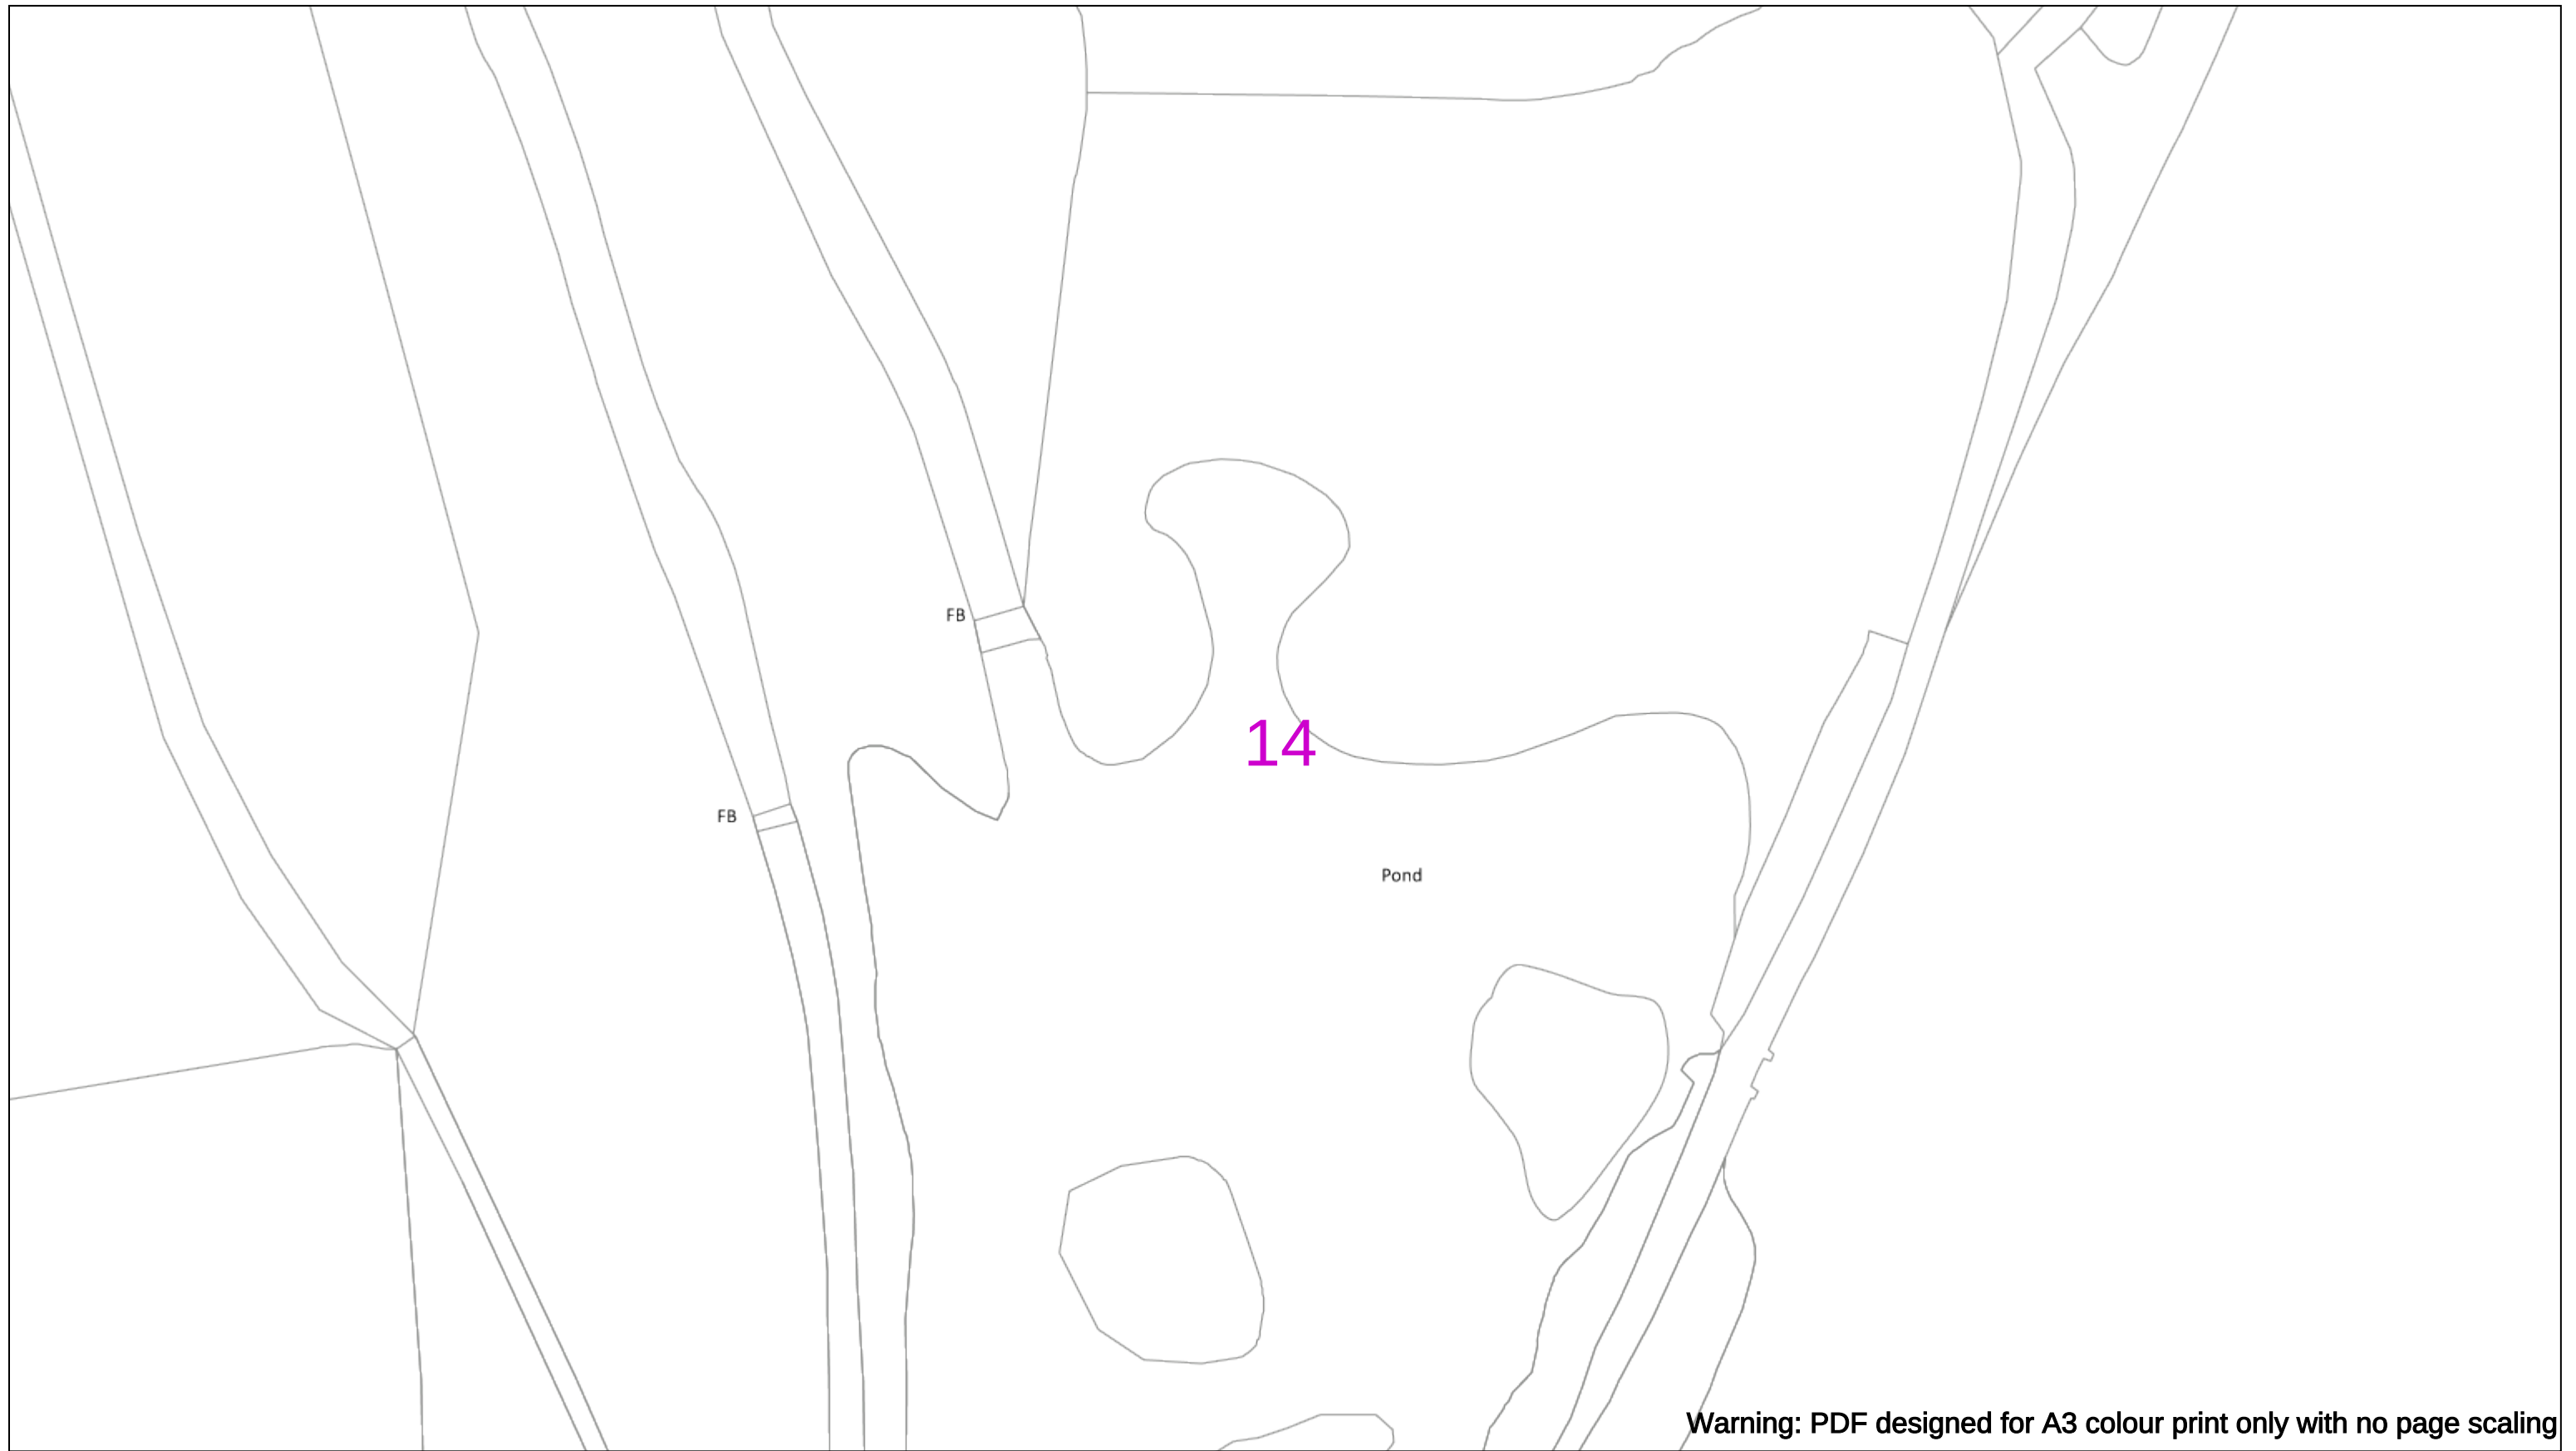

Warning: PDF designed for A3 colour print only with no page scaling

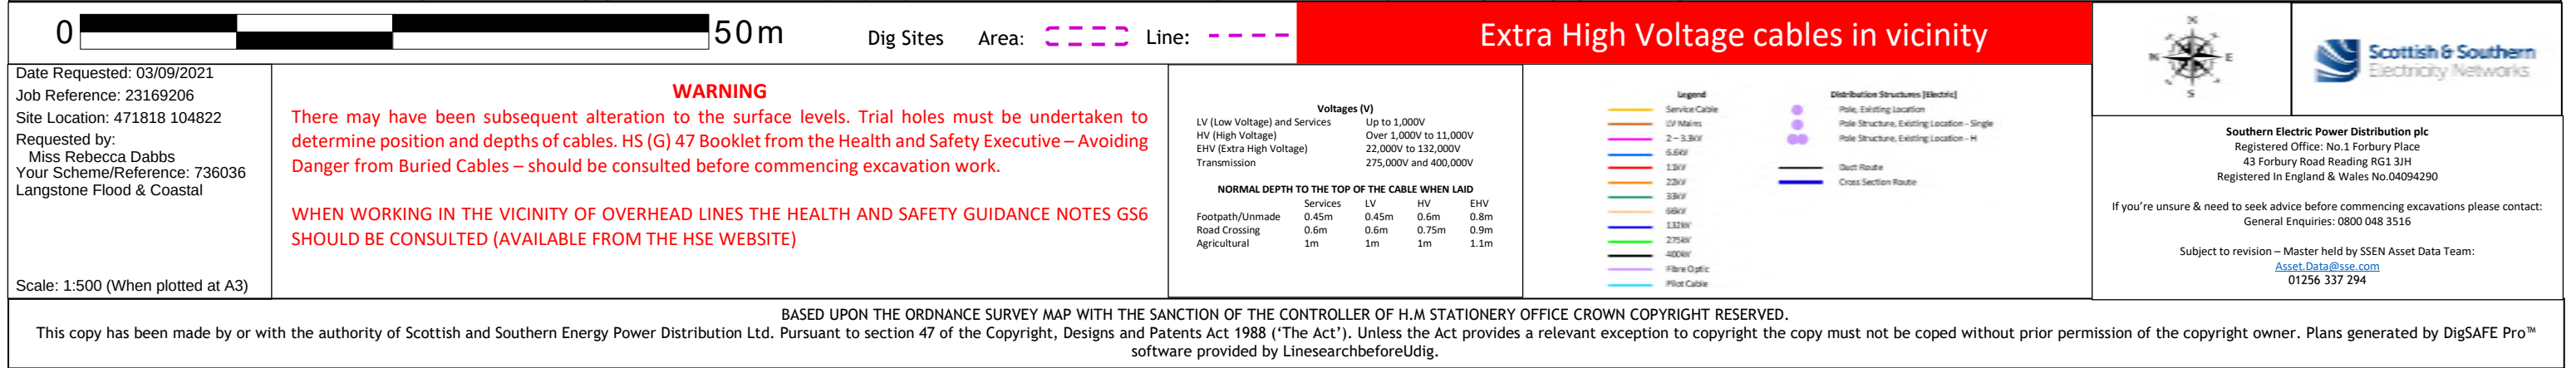

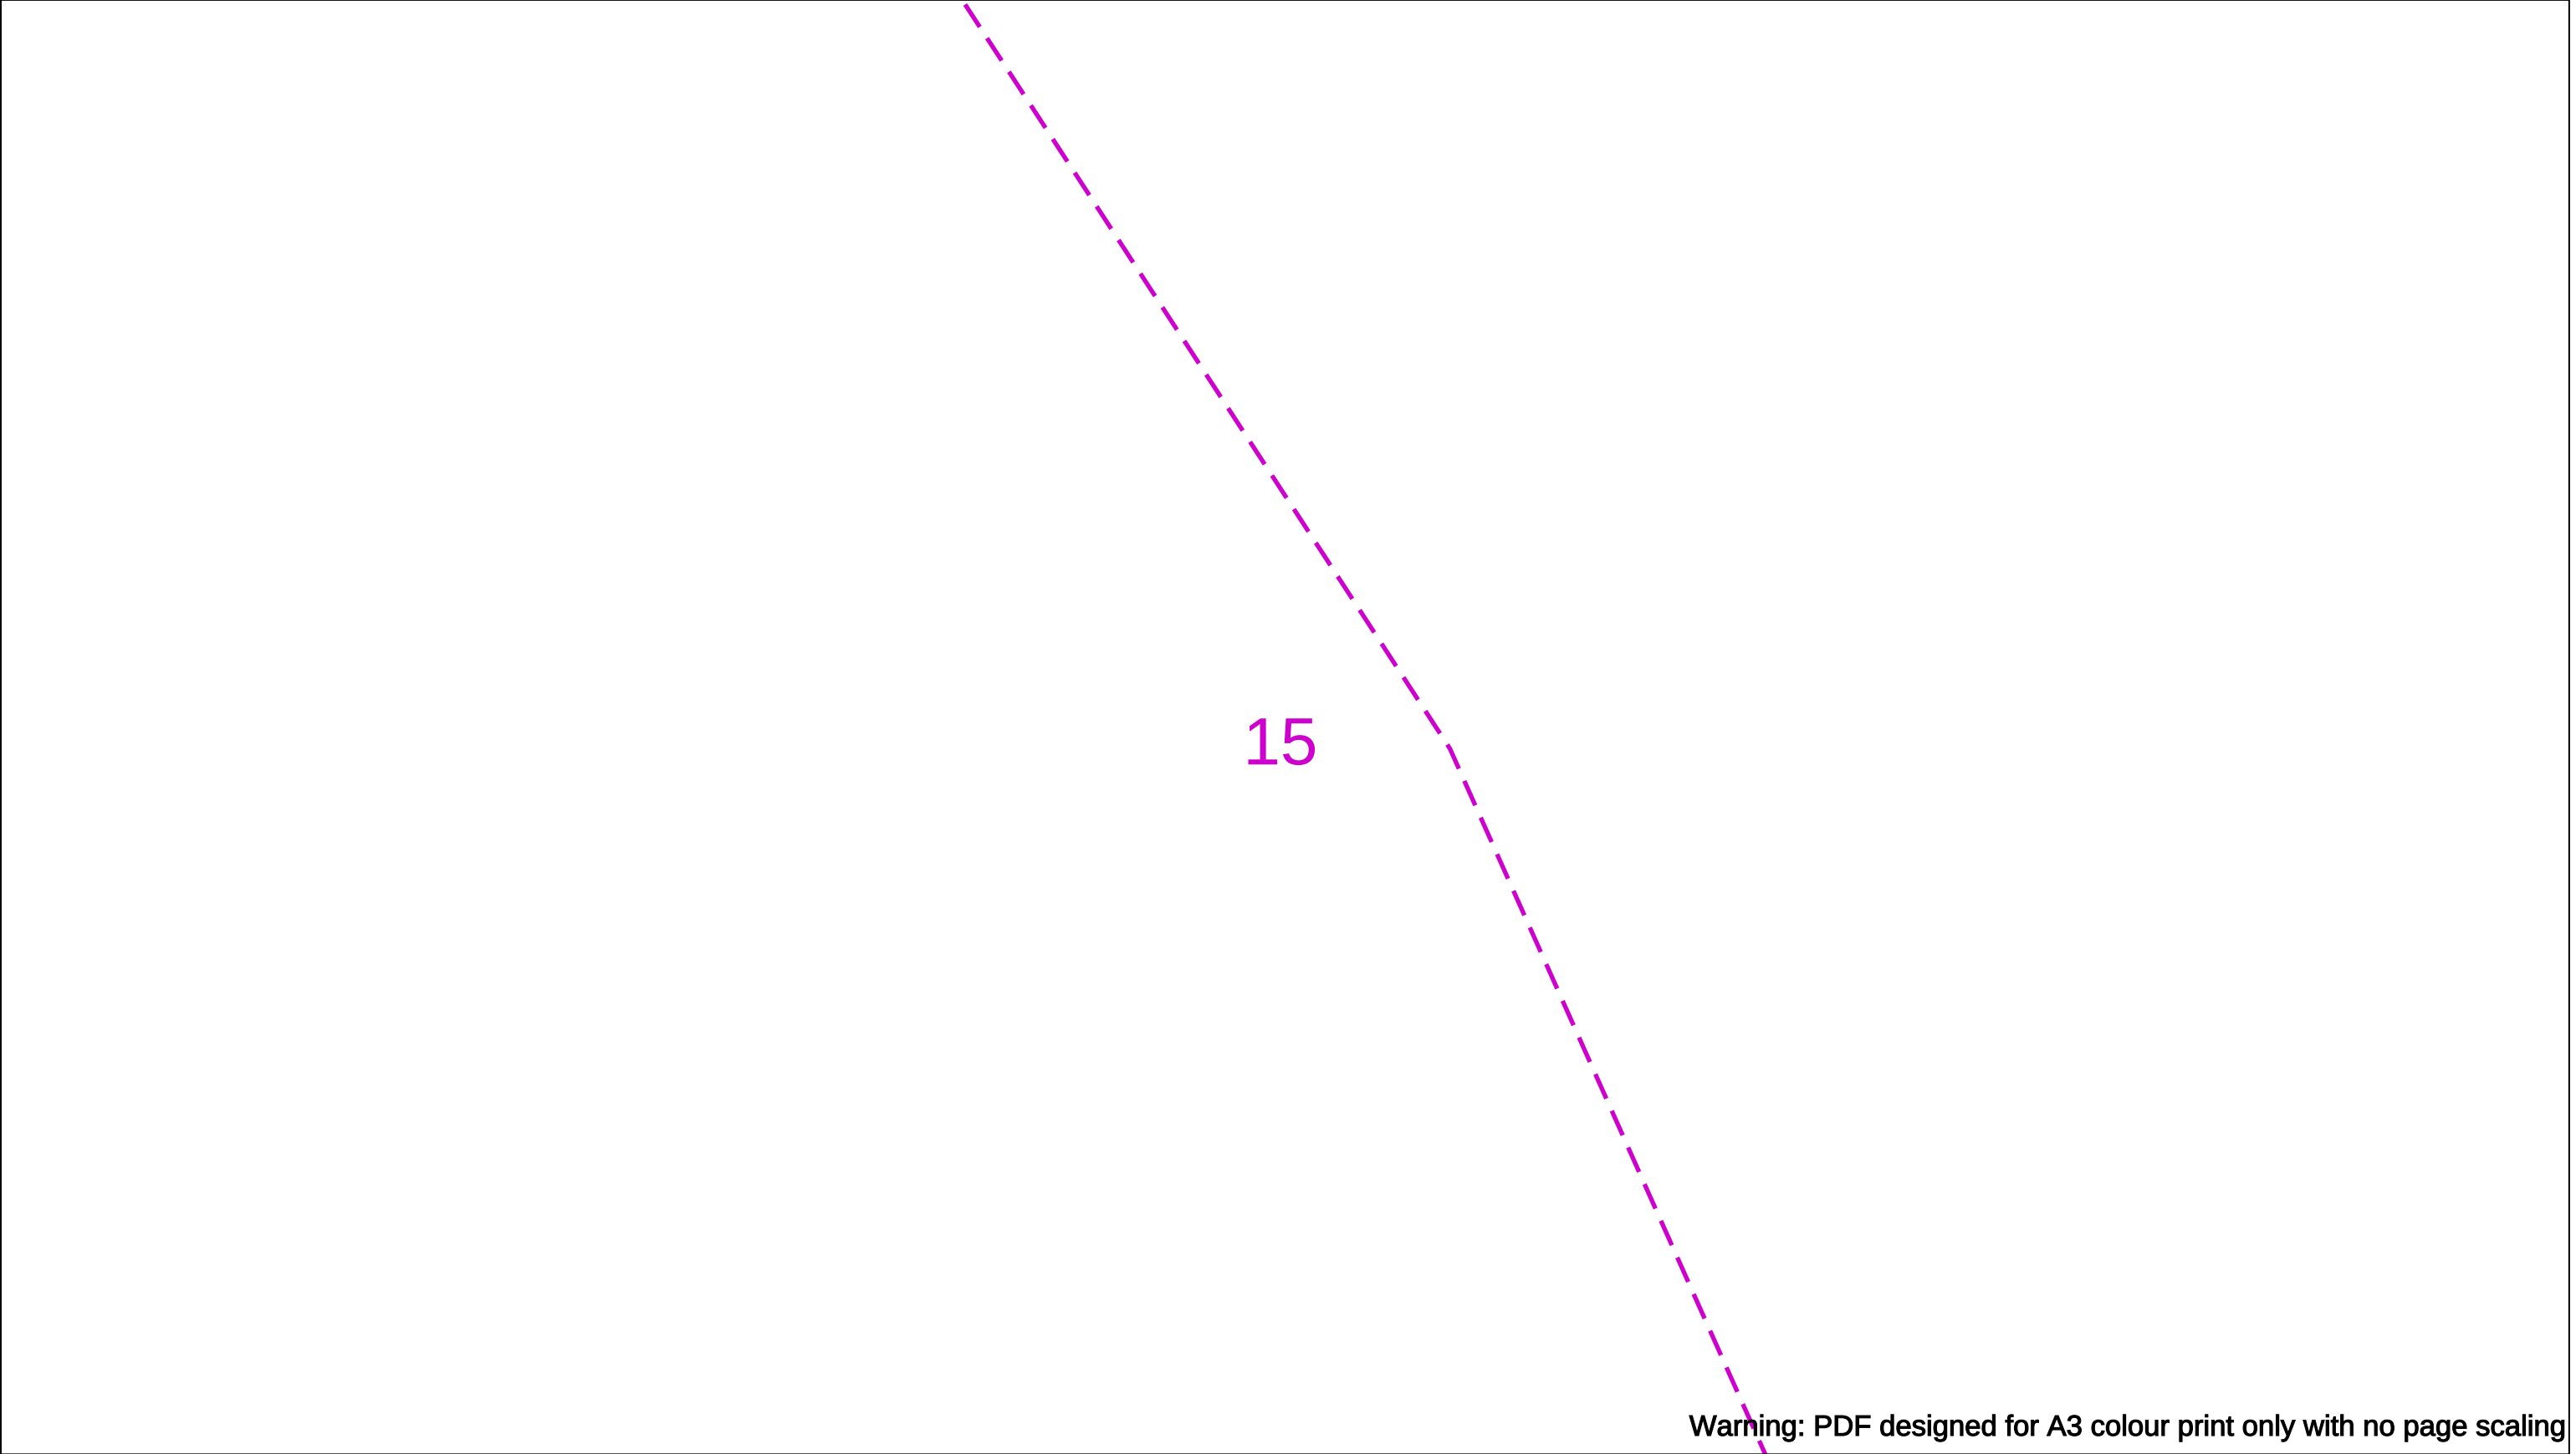

Warning: PDF designed for A3 colour print only with no page scaling

050m

Dig Sites

Area:

Line:

Extra High Voltage cables in vicinity

Date Requested: 03/09/2021

Job Reference: 23169206

Site Location: 471818 104822

Requested by:
Miss Rebecca Dabbs

Your Scheme/Reference: 736036

Langstone Flood & Coastal

WARNING

There may have been subsequent alteration to the surface levels. Trial holes must be undertaken to determine position and depths of cables. HS (G) 47 Booklet from the Health and Safety Executive – Avoiding Danger from Buried Cables – should be consulted before commencing excavation work.

WHEN WORKING IN THE VICINITY OF OVERHEAD LINES THE HEALTH AND SAFETY GUIDANCE NOTES GS6 SHOULD BE CONSULTED (AVAILABLE FROM THE HSE WEBSITE)

Voltages (V)				
LV (Low Voltage) and Services	Up to 1,000V			
HV (High Voltage)	Over 1,000V to 11,000V			
EHV (Extra High Voltage)	22,000V to 132,000V			
Transmission	275,000V and 400,000V			

NORMAL DEPTH TO THE TOP OF THE CABLE WHEN LAID				
Services	LV	HV	EHV	
Footpath/Unmade	0.45m	0.45m	0.6m	0.8m
Road Crossing	0.6m	0.6m	0.75m	0.9m
Agricultural	1m	1m	1m	1.1m

Legend

Service Cable

10/ Mains

2 – 3.3kV

6.6kV

11kV

22kV

33kV

66kV

132kV

275kV

400kV

Fibre Optic

Pilot Cable

Distribution Structures [Electric]

Pole, Existing Location

Pole Structure, Existing Location – Single

Pole Structure, Existing Location – H

Duct Route

Cross Section Route

Southern Electric Power Distribution plc

Registered Office: No.1 Forbury Place

43 Forbury Road Reading RG1 3JH

Registered In England & Wales No.04094290

If you're unsure & need to seek advice before commencing excavations please contact:

General Enquiries: 0800 048 3516


Subject to revision – Master held by SSEN Asset Data Team:

Asset.Data@sse.com

01256 337 294

BASED UPON THE ORDNANCE SURVEY MAP WITH THE SANCTION OF THE CONTROLLER OF H.M STATIONERY OFFICE CROWN COPYRIGHT RESERVED.

This copy has been made by or with the authority of Scottish and Southern Energy Power Distribution Ltd. Pursuant to section 47 of the Copyright, Designs and Patents Act 1988 ('The Act'). Unless the Act provides a relevant exception to copyright the copy must not be copied without prior permission of the copyright owner. Plans generated by DigSAFE Pro™ software provided by LinesearchbeforeUdig.

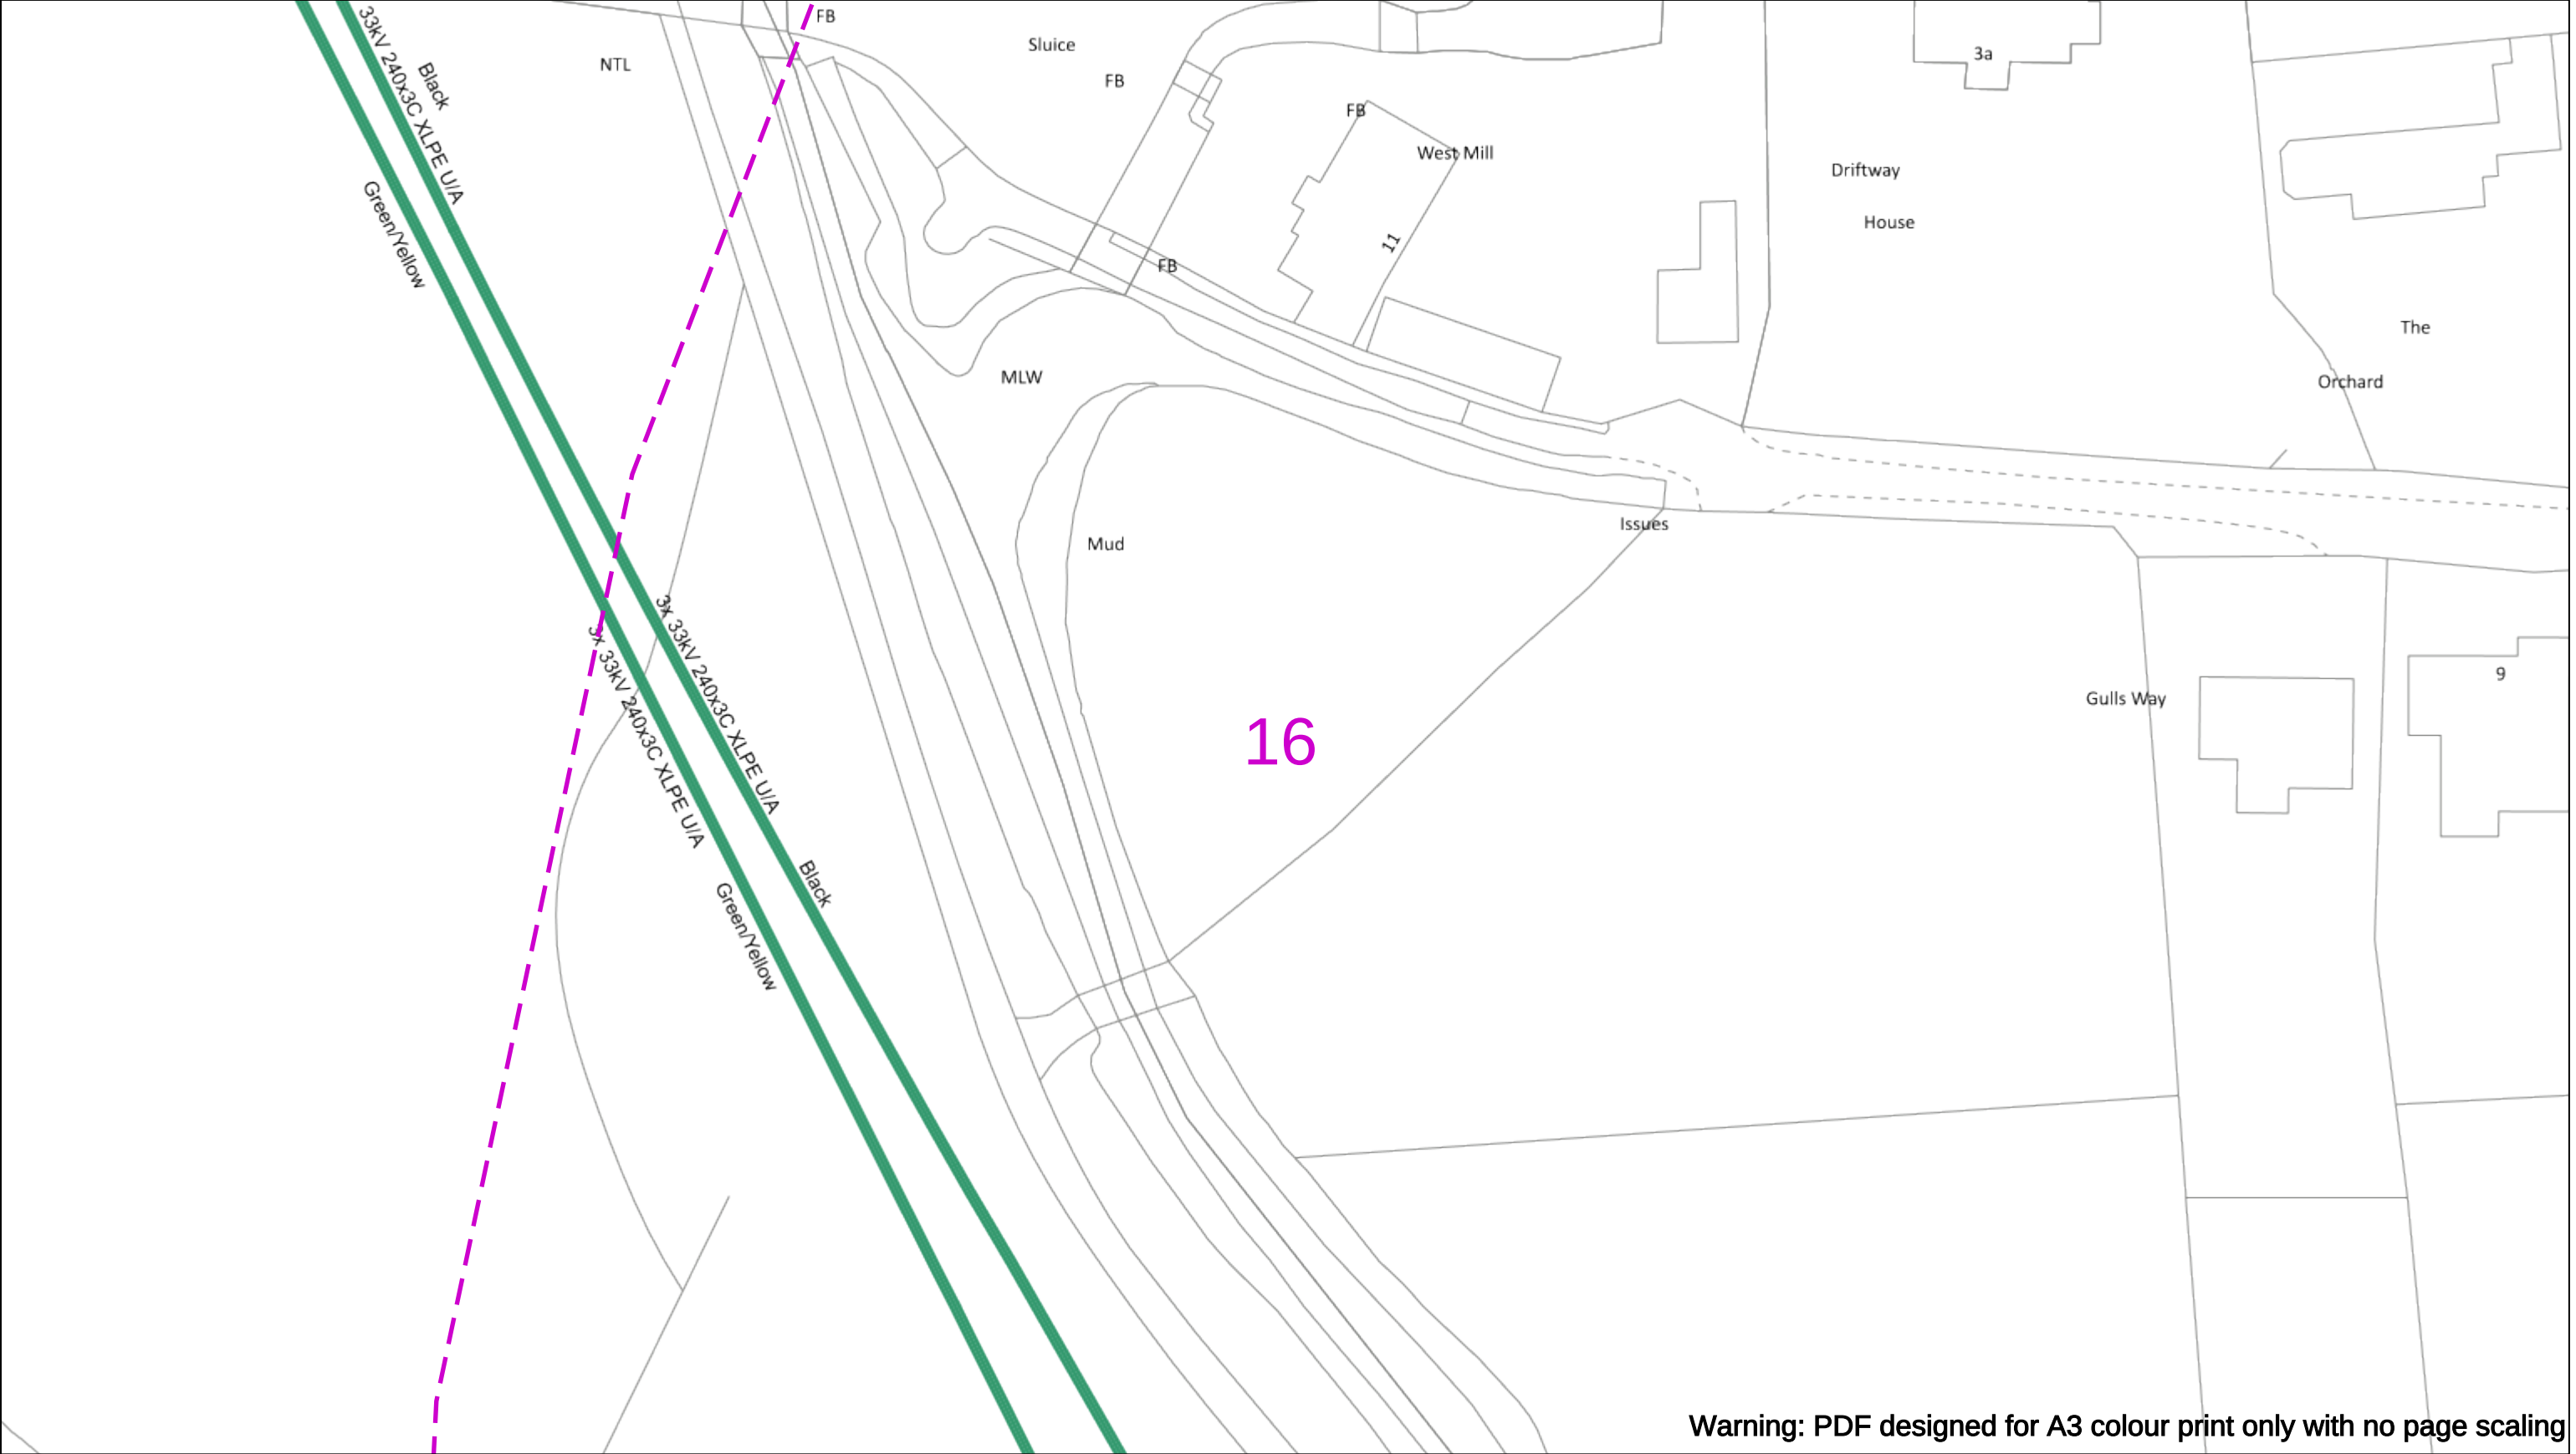

Warning: PDF designed for A3 colour print only with no page scaling

050m

Dig Sites

Area:

Line:

Extra High Voltage cables in vicinity

Date Requested: 03/09/2021

Job Reference: 23169206

Site Location: 471818 104822

Requested by:

Miss Rebecca Dabbs

Your Scheme/Reference: 736036

Langstone Flood & Coastal

WARNING

There may have been subsequent alteration to the surface levels. Trial holes must be undertaken to determine position and depths of cables. HS (G) 47 Booklet from the Health and Safety Executive – Avoiding Danger from Buried Cables – should be consulted before commencing excavation work.

WHEN WORKING IN THE VICINITY OF OVERHEAD LINES THE HEALTH AND SAFETY GUIDANCE NOTES GS6 SHOULD BE CONSULTED (AVAILABLE FROM THE HSE WEBSITE)

	Voltages (V)			
LV (Low Voltage) and Services	Up to 1,000V			
HV (High Voltage)	Over 1,000V to 11,000V			
EHV (Extra High Voltage)	22,000V to 132,000V			
Transmission	275,000V and 400,000V			

	NORMAL DEPTH TO THE TOP OF THE CABLE WHEN LAID			
	Services	LV	HV	EHV
Footpath/Unmade	0.45m	0.45m	0.6m	0.8m
Road Crossing	0.6m	0.6m	0.75m	0.9m
Agricultural	1m	1m	1m	1.1m

Legend

Service Cable

10/ Mains

2 – 3.3kV

6.6kV

11kV

22kV

33kV

66kV

132kV

275kV

400kV

Fibre Optic

Pilot Cable

Distribution Structures [Electric]

Pole, Existing Location

Pole Structure, Existing Location – Single

Pole Structure, Existing Location – H

Duct Route

Cross Section Route

Southern Electric Power Distribution plc

Registered Office: No.1 Forbury Place

43 Forbury Road Reading RG1 3JH

Registered In England & Wales No.04094290

If you're unsure & need to seek advice before commencing excavations please contact:

General Enquiries: 0800 048 3516

Subject to revision – Master held by SSEN Asset Data Team:


Asset.Data@sse.com

01256 337 294

Scale: 1:500 (When plotted at A3)

BASED UPON THE ORDNANCE SURVEY MAP WITH THE SANCTION OF THE CONTROLLER OF THE STATIONERY OFFICE CROWN COPYRIGHT RESERVED.

This copy has been made by or with the authority of Scottish and Southern Energy Power Distribution Ltd. Pursuant to section 47 of the Copyright, Designs and Patents Act 1988 ('The Act'). Unless the Act provides a relevant exception to copyright the copy must not be copied without prior permission of the copyright owner. Plans generated by DigSAFE Pro™ software provided by LinesearchbeforeUdig.

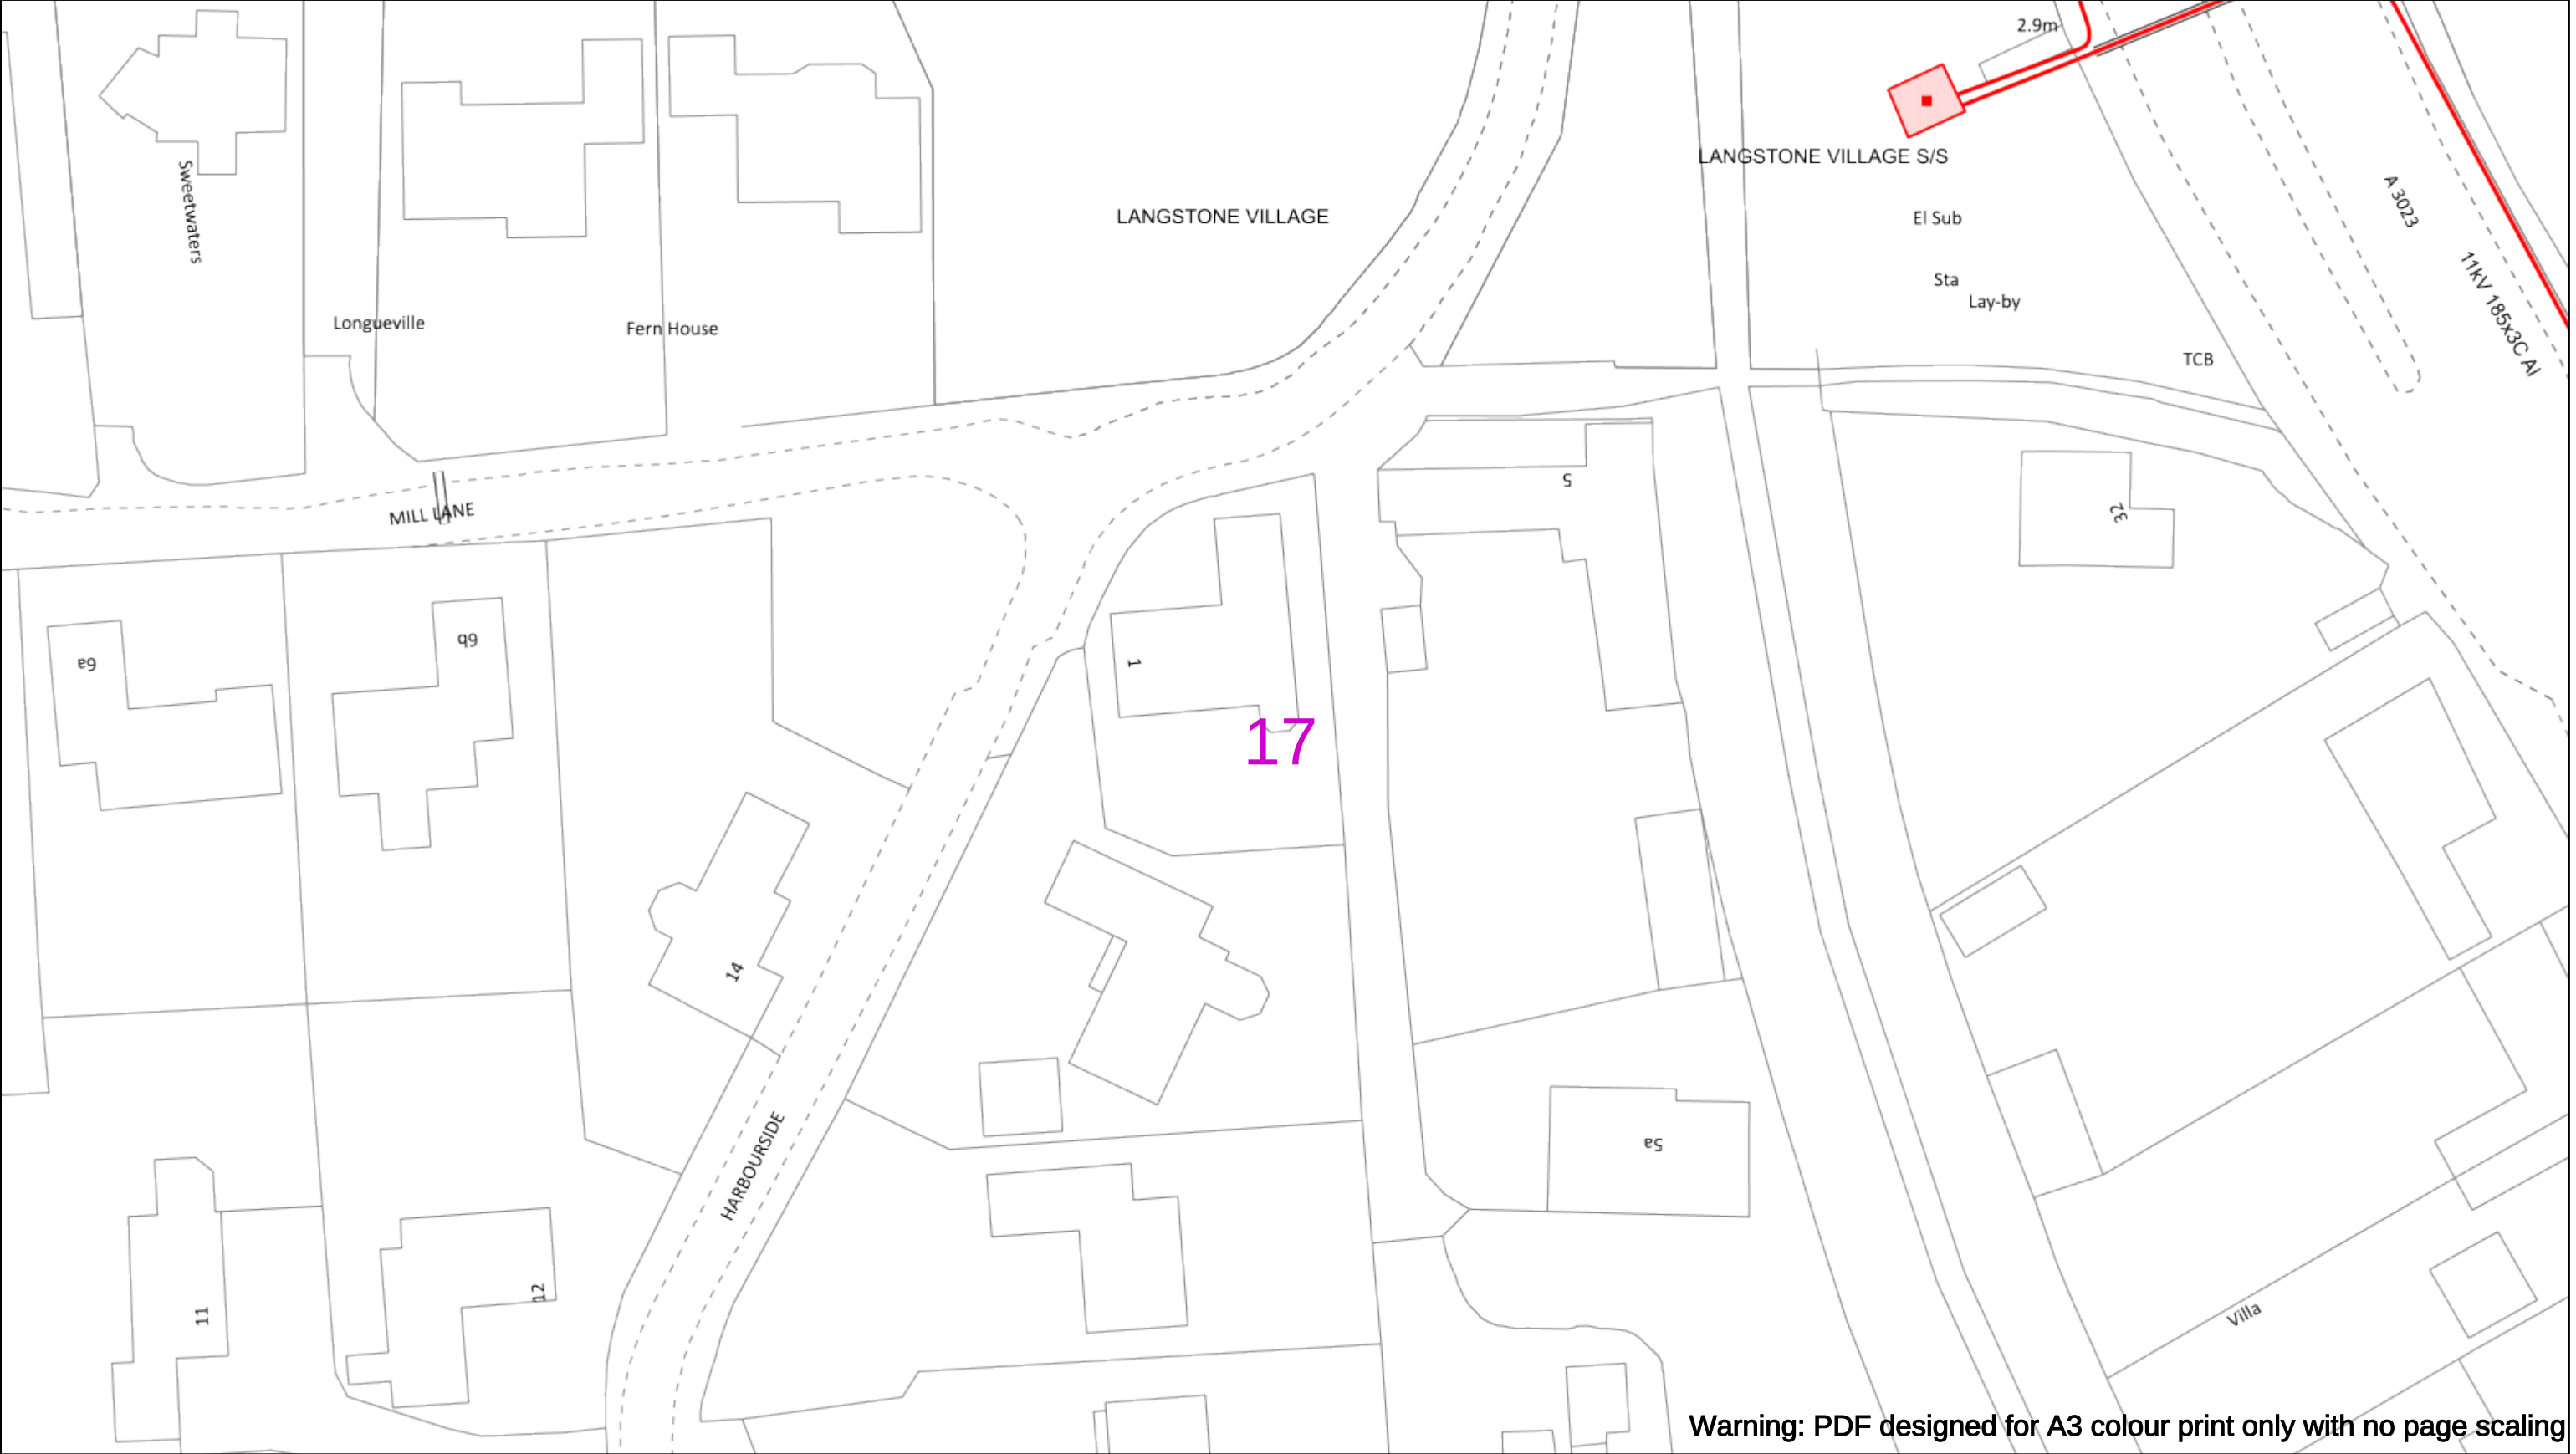

Warning: PDF designed for A3 colour print only with no page scaling

050m

Dig Sites

Area:

Line:

Extra High Voltage cables in vicinity

Date Requested: 03/09/2021

Job Reference: 23169206

Site Location: 471818 104822

Requested by:

Miss Rebecca Dabbs

Your Scheme/Reference: 736036

Langstone Flood & Coastal

WARNING

There may have been subsequent alteration to the surface levels. Trial holes must be undertaken to determine position and depths of cables. HS (G) 47 Booklet from the Health and Safety Executive – Avoiding Danger from Buried Cables – should be consulted before commencing excavation work.

WHEN WORKING IN THE VICINITY OF OVERHEAD LINES THE HEALTH AND SAFETY GUIDANCE NOTES GS6 SHOULD BE CONSULTED (AVAILABLE FROM THE HSE WEBSITE)

Voltages (V)				
LV (Low Voltage) and Services	Up to 1,000V			
HV (High Voltage)	Over 1,000V to 11,000V			
EHV (Extra High Voltage)	22,000V to 132,000V			
Transmission	275,000V and 400,000V			

NORMAL DEPTH TO THE TOP OF THE CABLE WHEN LAID				
	Services	LV	HV	EHV
Footpath/Unmade	0.45m	0.45m	0.6m	0.8m
Road Crossing	0.6m	0.6m	0.75m	0.9m
Agricultural	1m	1m	1m	1.1m

Legend

Service Cable

0V Mains

2-3.3kV

6.6kV

11kV

22kV

33kV

66kV

132kV

275kV

400kV

Fibre Optic

Pilot Cable

Distribution Structures [Electric]

Pole, Existing Location

Pole Structure, Existing Location - Single

Pole Structure, Existing Location - H

Duct Route

Cross Section Route

Southern Electric Power Distribution plc

Registered Office: No.1 Forbury Place

43 Forbury Road Reading RG1 3JH

Registered In England & Wales No.04094290

If you're unsure & need to seek advice before commencing excavations please contact:

General Enquiries: 0800 048 3516

Subject to revision – Master held by SSEN Asset Data Team:


Asset.Data@sse.com

01256 337 294

Scale: 1:500 (When plotted at A3)

BASED UPON THE ORDNANCE SURVEY MAP WITH THE SANCTION OF THE CONTROLLER OF H.M STATIONERY OFFICE CROWN COPYRIGHT RESERVED.

This copy has been made by or with the authority of Scottish and Southern Energy Power Distribution Ltd. Pursuant to section 47 of the Copyright, Designs and Patents Act 1988 ('The Act'). Unless the Act provides a relevant exception to copyright the copy must not be copied without prior permission of the copyright owner. Plans generated by DigSAFE Pro™ software provided by LinesearchbeforeUdig.

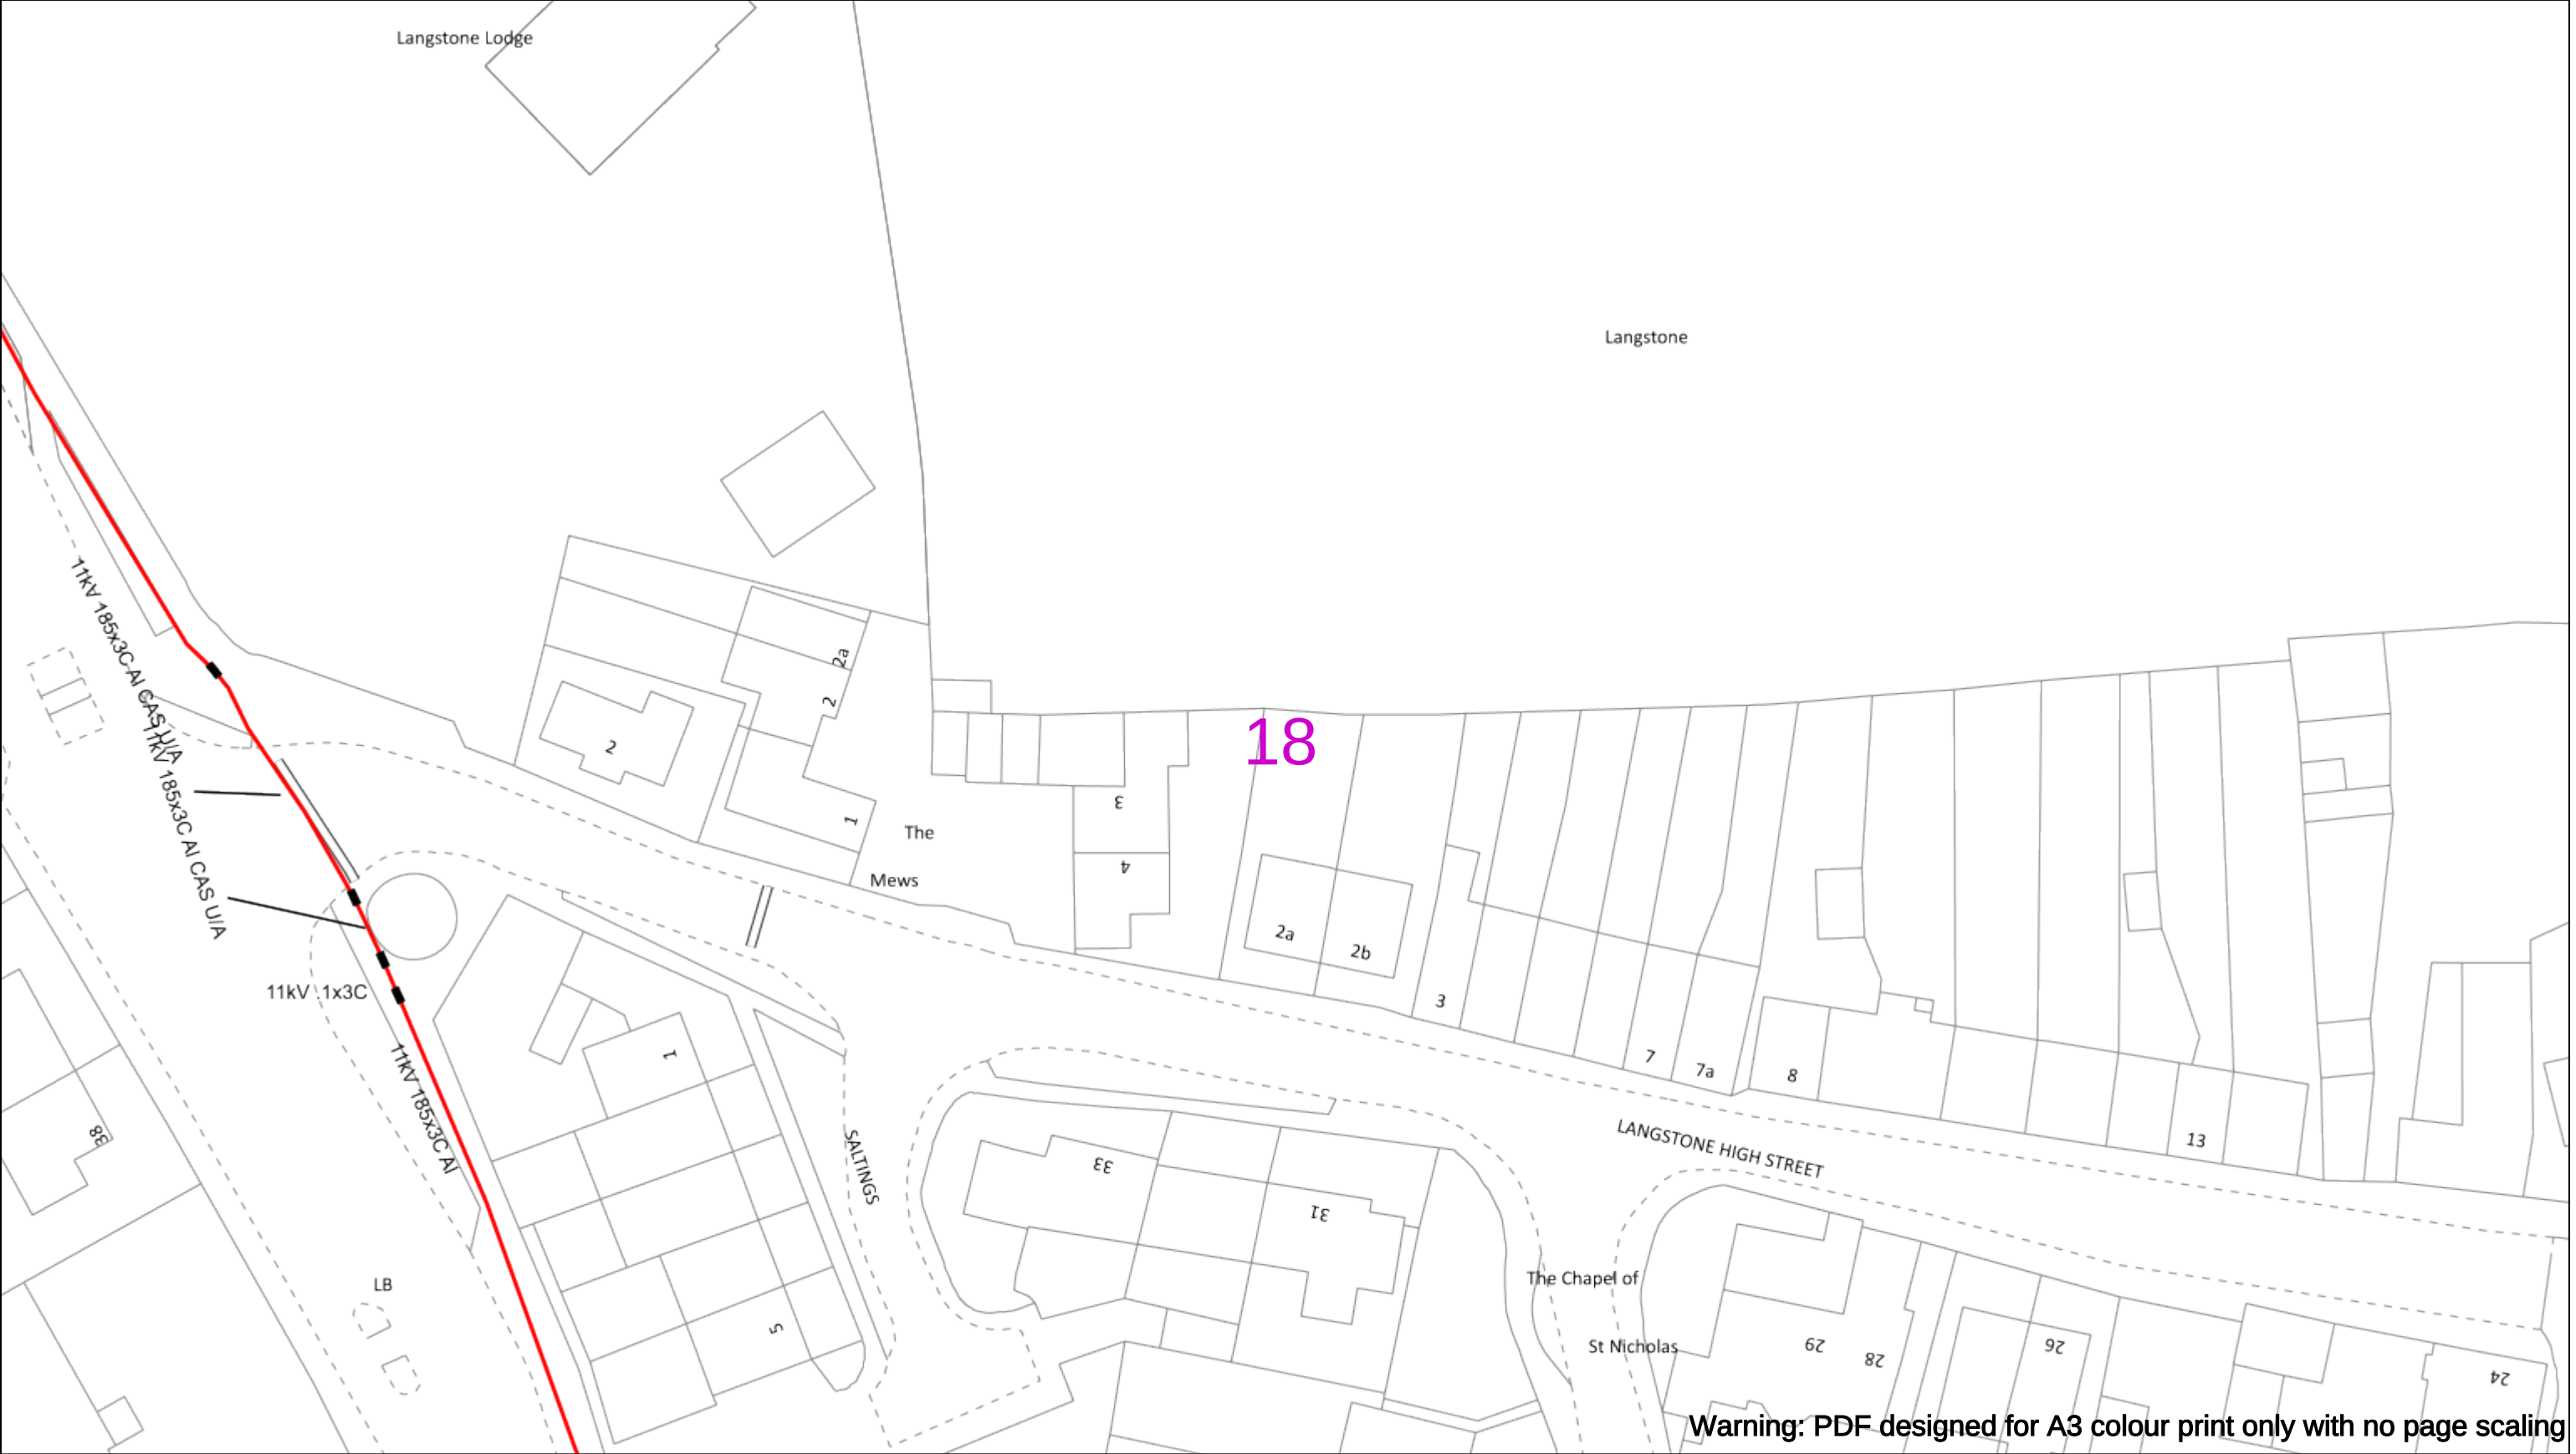

Warning: PDF designed for A3 colour print only with no page scaling

050m

Dig Sites

Area:

Line:

Extra High Voltage cables in vicinity

Date Requested: 03/09/2021

Job Reference: 23169206

Site Location: 471818 104822

Requested by:
Miss Rebecca Dabbs

Your Scheme/Reference: 736036

Langstone Flood & Coastal

WARNING

There may have been subsequent alteration to the surface levels. Trial holes must be undertaken to determine position and depths of cables. HS (G) 47 Booklet from the Health and Safety Executive – Avoiding Danger from Buried Cables – should be consulted before commencing excavation work.

WHEN WORKING IN THE VICINITY OF OVERHEAD LINES THE HEALTH AND SAFETY GUIDANCE NOTES GS6 SHOULD BE CONSULTED (AVAILABLE FROM THE HSE WEBSITE)

	Voltages (V)			
LV (Low Voltage) and Services	Up to 1,000V			
HV (High Voltage)	Over 1,000V to 11,000V			
EHV (Extra High Voltage) Transmission	22,000V to 132,000V			
	275,000V and 400,000V			

	NORMAL DEPTH TO THE TOP OF THE CABLE WHEN LAID			
	Services	LV	HV	EHV
Footpath/Unmade	0.45m	0.45m	0.6m	0.8m
Road Crossing	0.6m	0.6m	0.75m	0.9m
Agricultural	1m	1m	1m	1.1m

Legend

Service Cable

0V Mains

2-3.3kV

6.6kV

11kV

22kV

33kV

66kV

132kV

275kV

400kV

Fibre Optic

Pilot Cable

Pole, Existing Location

Pole Structure, Existing Location - Single

Pole Structure, Existing Location - H

Duct Route

Cross Section Route

Southern Electric Power Distribution plc

Registered Office: No.1 Forbury Place

43 Forbury Road Reading RG1 3JH

Registered In England & Wales No.04094290

If you're unsure & need to seek advice before commencing excavations please contact:


General Enquiries: 0800 048 3516

Subject to revision – Master held by SSEN Asset Data Team:

Asset.Data@sse.com

01256 337 294

BASED UPON THE ORDNANCE SURVEY MAP WITH THE SANCTION OF THE CONTROLLER OF H.M STATIONERY OFFICE CROWN COPYRIGHT RESERVED.
This copy has been made by or with the authority of Scottish and Southern Energy Power Distribution Ltd. Pursuant to section 47 of the Copyright, Designs and Patents Act 1988 ('The Act'). Unless the Act provides a relevant exception to copyright the copy must not be copied without prior permission of the copyright owner. Plans generated by DigSAFE Pro™ software provided by LinesearchbeforeUdig.

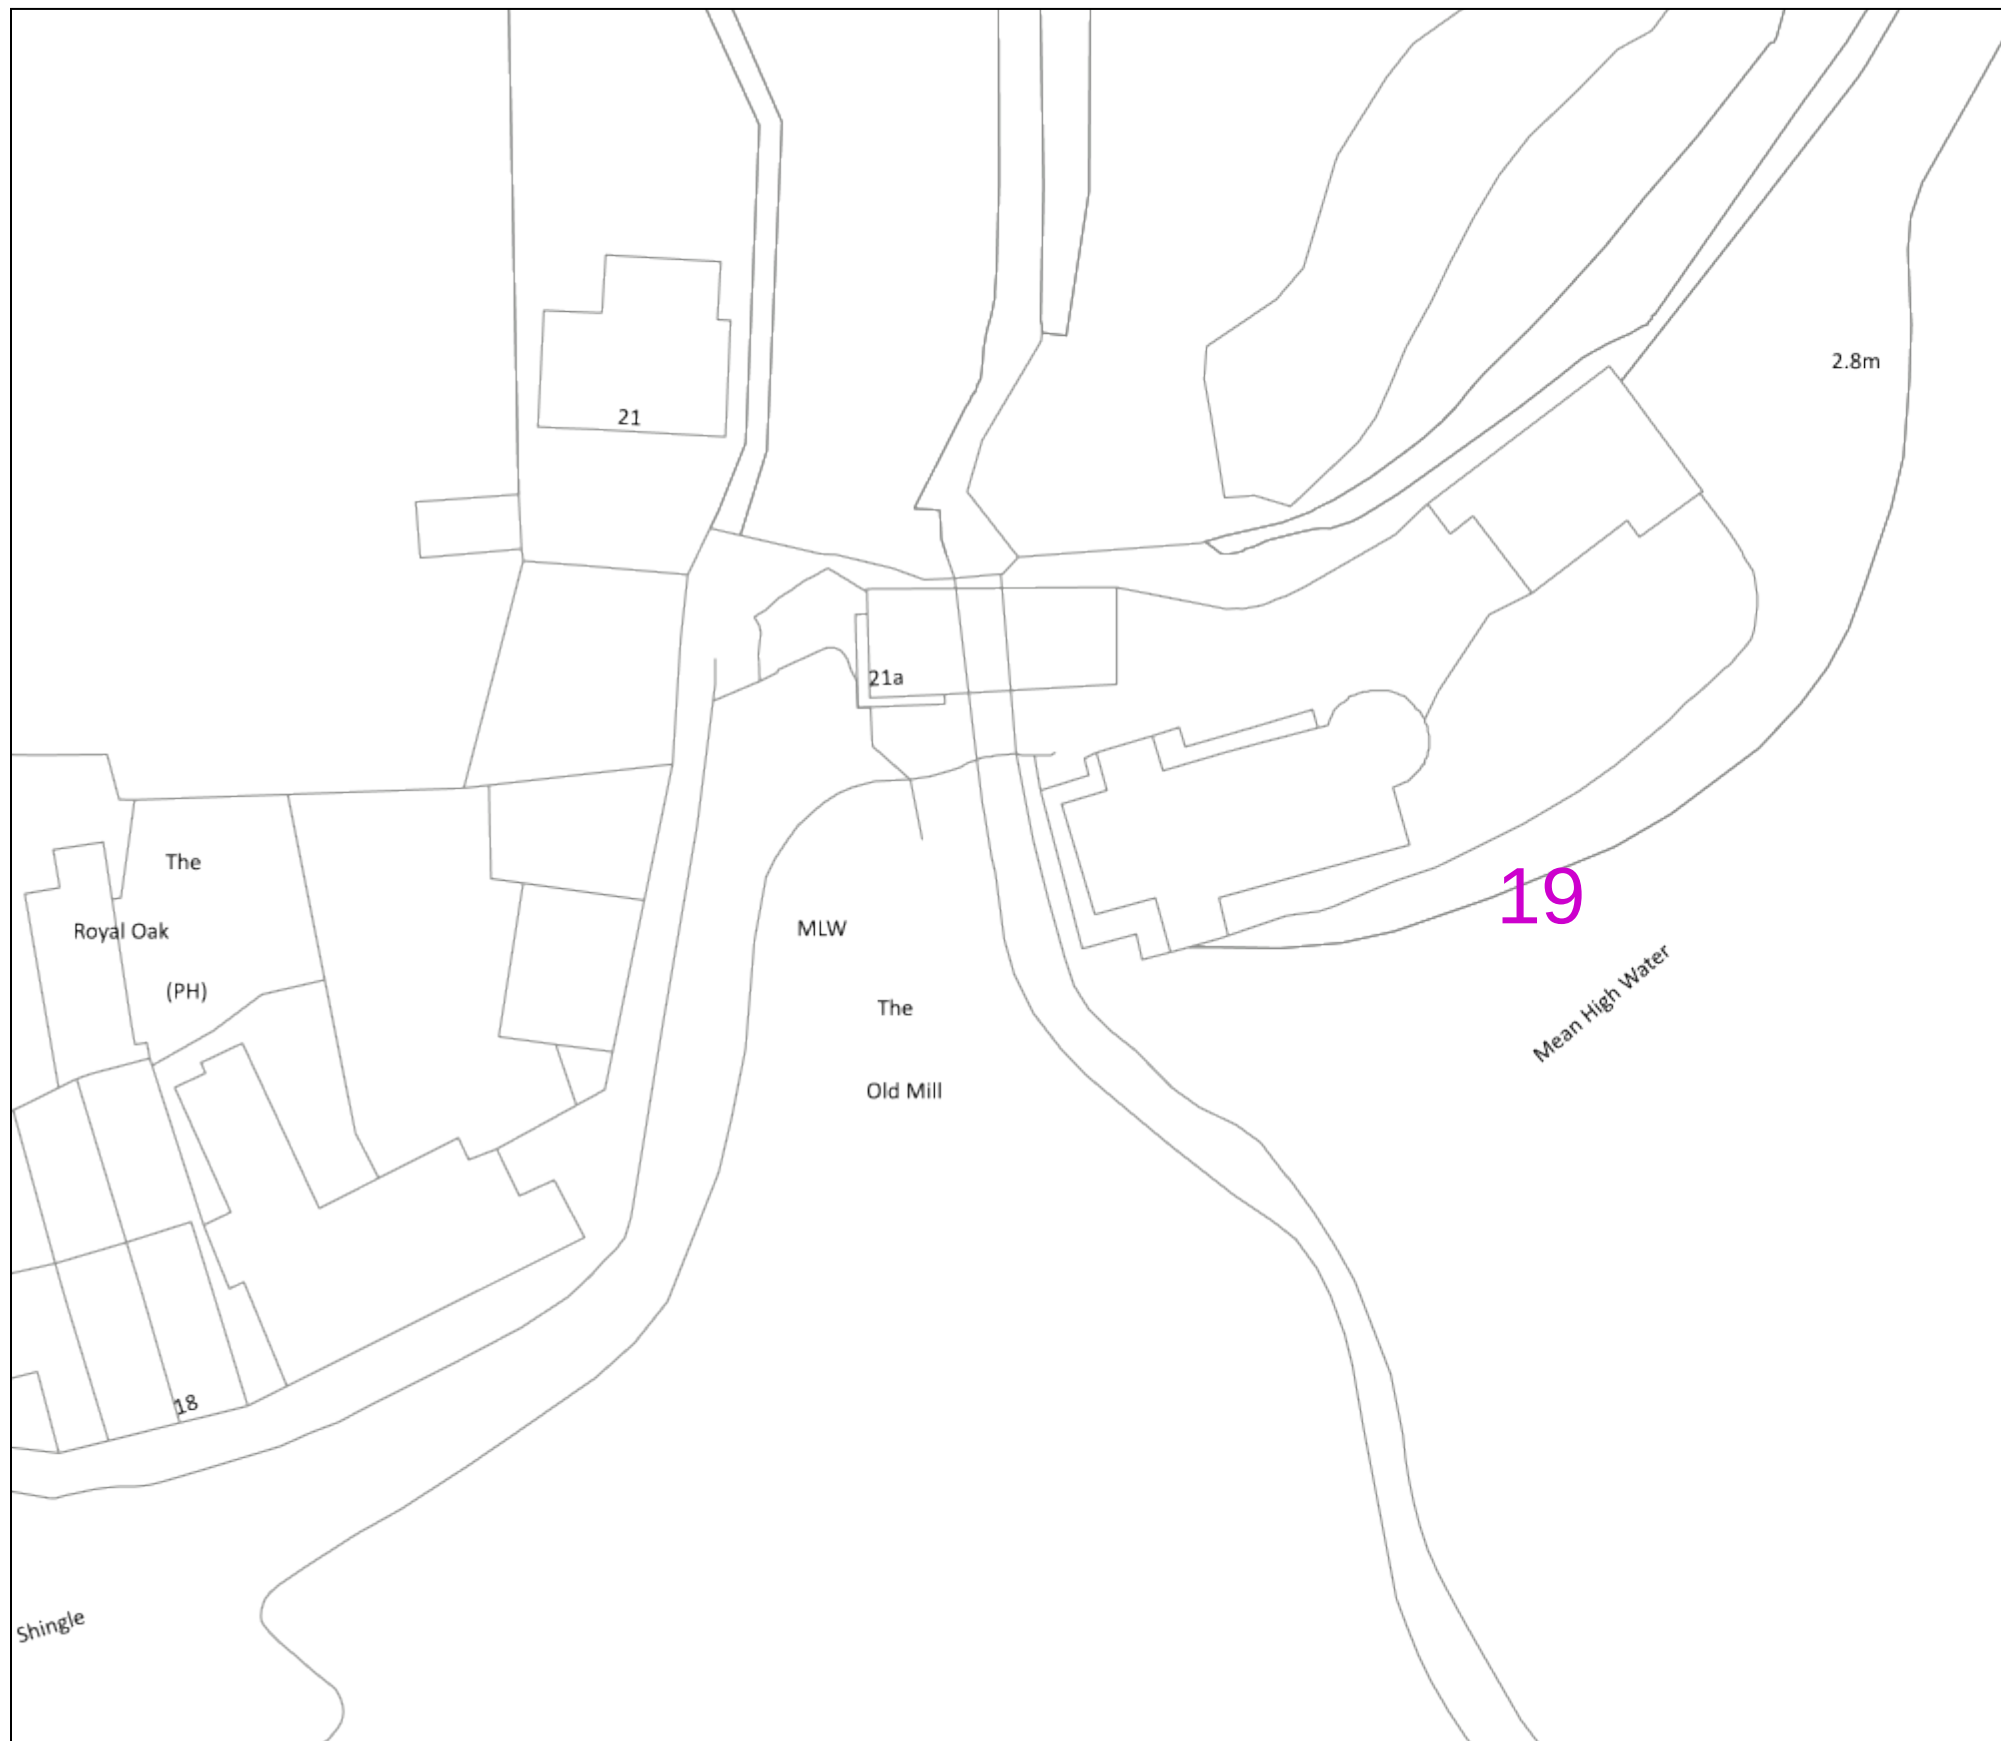

Warning: PDF designed for A3 colour print only with no page scaling



Dig Sites

Area:

— — — — —

Extra High Voltage cables in vicinity



Date Requested: 03/09/2021
Job Reference: 23169206
Site Location: 471818 104822

Requested by:
Miss Rebecca Dabbs
Your Scheme/Reference: 736036
Langstone Flood & Coastal

WARNING

There may have been subsequent alteration to the surface levels. Trial holes must be undertaken to determine position and depths of cables. HS (G) 47 Booklet from the Health and Safety Executive – Avoiding Danger from Buried Cables – should be consulted before commencing excavation work.

WHEN WORKING IN THE VICINITY OF OVERHEAD LINES THE HEALTH AND SAFETY GUIDANCE NOTES GS6 SHOULD BE CONSULTED (AVAILABLE FROM THE HSE WEBSITE)

Voltages (V)				
LV (Low Voltage) and Services		Up to 1,000V		
HV (High Voltage)		Over 1,000V to 11,000V		
EHV (Extra High Voltage)		22,000V to 132,000V		
Transmission		275,000V and 400,000V		
NORMAL DEPTH TO THE TOP OF THE CABLE WHEN LAID				
	Services	LV	HV	EHV
Footpath/Unmade	0.45m	0.45m	0.6m	0.9m
Road Crossing	0.6m	0.6m	0.75m	0.9m
Agricultural	1m	1m	1m	1.2m

Southern Electric Power Distribution plc
Registered Office: No.1 Forbury Place
43 Forbury Road Reading RG1 3JH
Registered In England & Wales No.04094290

If you're unsure & need to seek advice before commencing excavations please contact:
General Enquiries: 0800 048 3516

Subject to revision – Master held by SSEN Asset Data Team:
Asset.Data@sse.com
 01256 337 294

Scale: 1:500 (When plotted at A3)

BASED UPON THE ORDNANCE SURVEY MAP WITH THE SANCTION OF THE CONTROLLER OF H.M STATIONERY OFFICE CROWN COPYRIGHT RESERVED.

This copy has been made by or with the authority of Scottish and Southern Energy Power Distribution Ltd. Pursuant to section 47 of the Copyright, Designs and Patents Act 1988 ('The Act'). Unless the Act provides a relevant exception to copyright the copy must not be copied without prior permission of the copyright owner. Plans generated by DigSAFE Pro™ software provided by LinesearchbeforeUdig.

20

Warning: PDF designed for A3 colour print only with no page scaling



Date Requested: 03/09/2021
Job Reference: 23169206
Site Location: 471818 104822
Requested by:
Miss Rebecca Dabbs
Your Scheme/Reference: 736036
Langstone Flood & Coastal

There may have been subsequent alteration to the surface levels. Trial holes must be undertaken to determine position and depths of cables. HS (G) 47 Booklet from the Health and Safety Executive – Avoiding Danger from Buried Cables – should be consulted before commencing excavation work.

WHEN WORKING IN THE VICINITY OF OVERHEAD LINES THE HEALTH AND SAFETY GUIDANCE NOTES GS6 SHOULD BE CONSULTED (AVAILABLE FROM THE HSE WEBSITE)

Voltages (V)			
LV (Low Voltage) and Services		Up to 1,000V	
HV (High Voltage)		Over 1,000V to 11,000V	
EHV (Extra High Voltage)		22,000V to 132,000V	
Transmission		275,000V and 400,000V	
NORMAL DEPTH TO THE TOP OF THE CABLE WHEN LAID			
	Services	LV	HV
Footpath/Unmade	0.45m	0.45m	0.6m
Road Crossing	0.6m	0.6m	0.75m
Agricultural	1m	1m	1m

Legend

- Service Cable
- UV Mains
- 2-33kV
- 6.6kV
- 13kV
- 23kV
- 33kV
- 66kV
- 132kV
- 275kV
- 400kV
- Fibre Optic
- Pilot Cable

Distribution Structures (Electric)


- Pole, Existing Location
- Pole Structure, Existing Location
- Pole Structure, Existing Location
- Duct Route
- Cross Section Route

If you're unsure & need to seek advice before commencing excavations please contact:
General Enquiries: 0800 048 3516

Subject to revision – Master held by SSEN Asset Data Team:
Asset.Data@sse.com
01256 337 294

Scale: 1:500 (When plotted at A3)

This copy has been made by or with the authority of Scottish and Southern Energy Power Distribution Ltd. Pursuant to section 47 of the Copyright, Designs and Patents Act 1988 ('The Act'). Unless the Act provides a relevant exception to copyright the copy must not be copied without prior permission of the copyright owner. Plans generated by DigSAFE Pro™ software provided by LinesearchbeforeUdig.

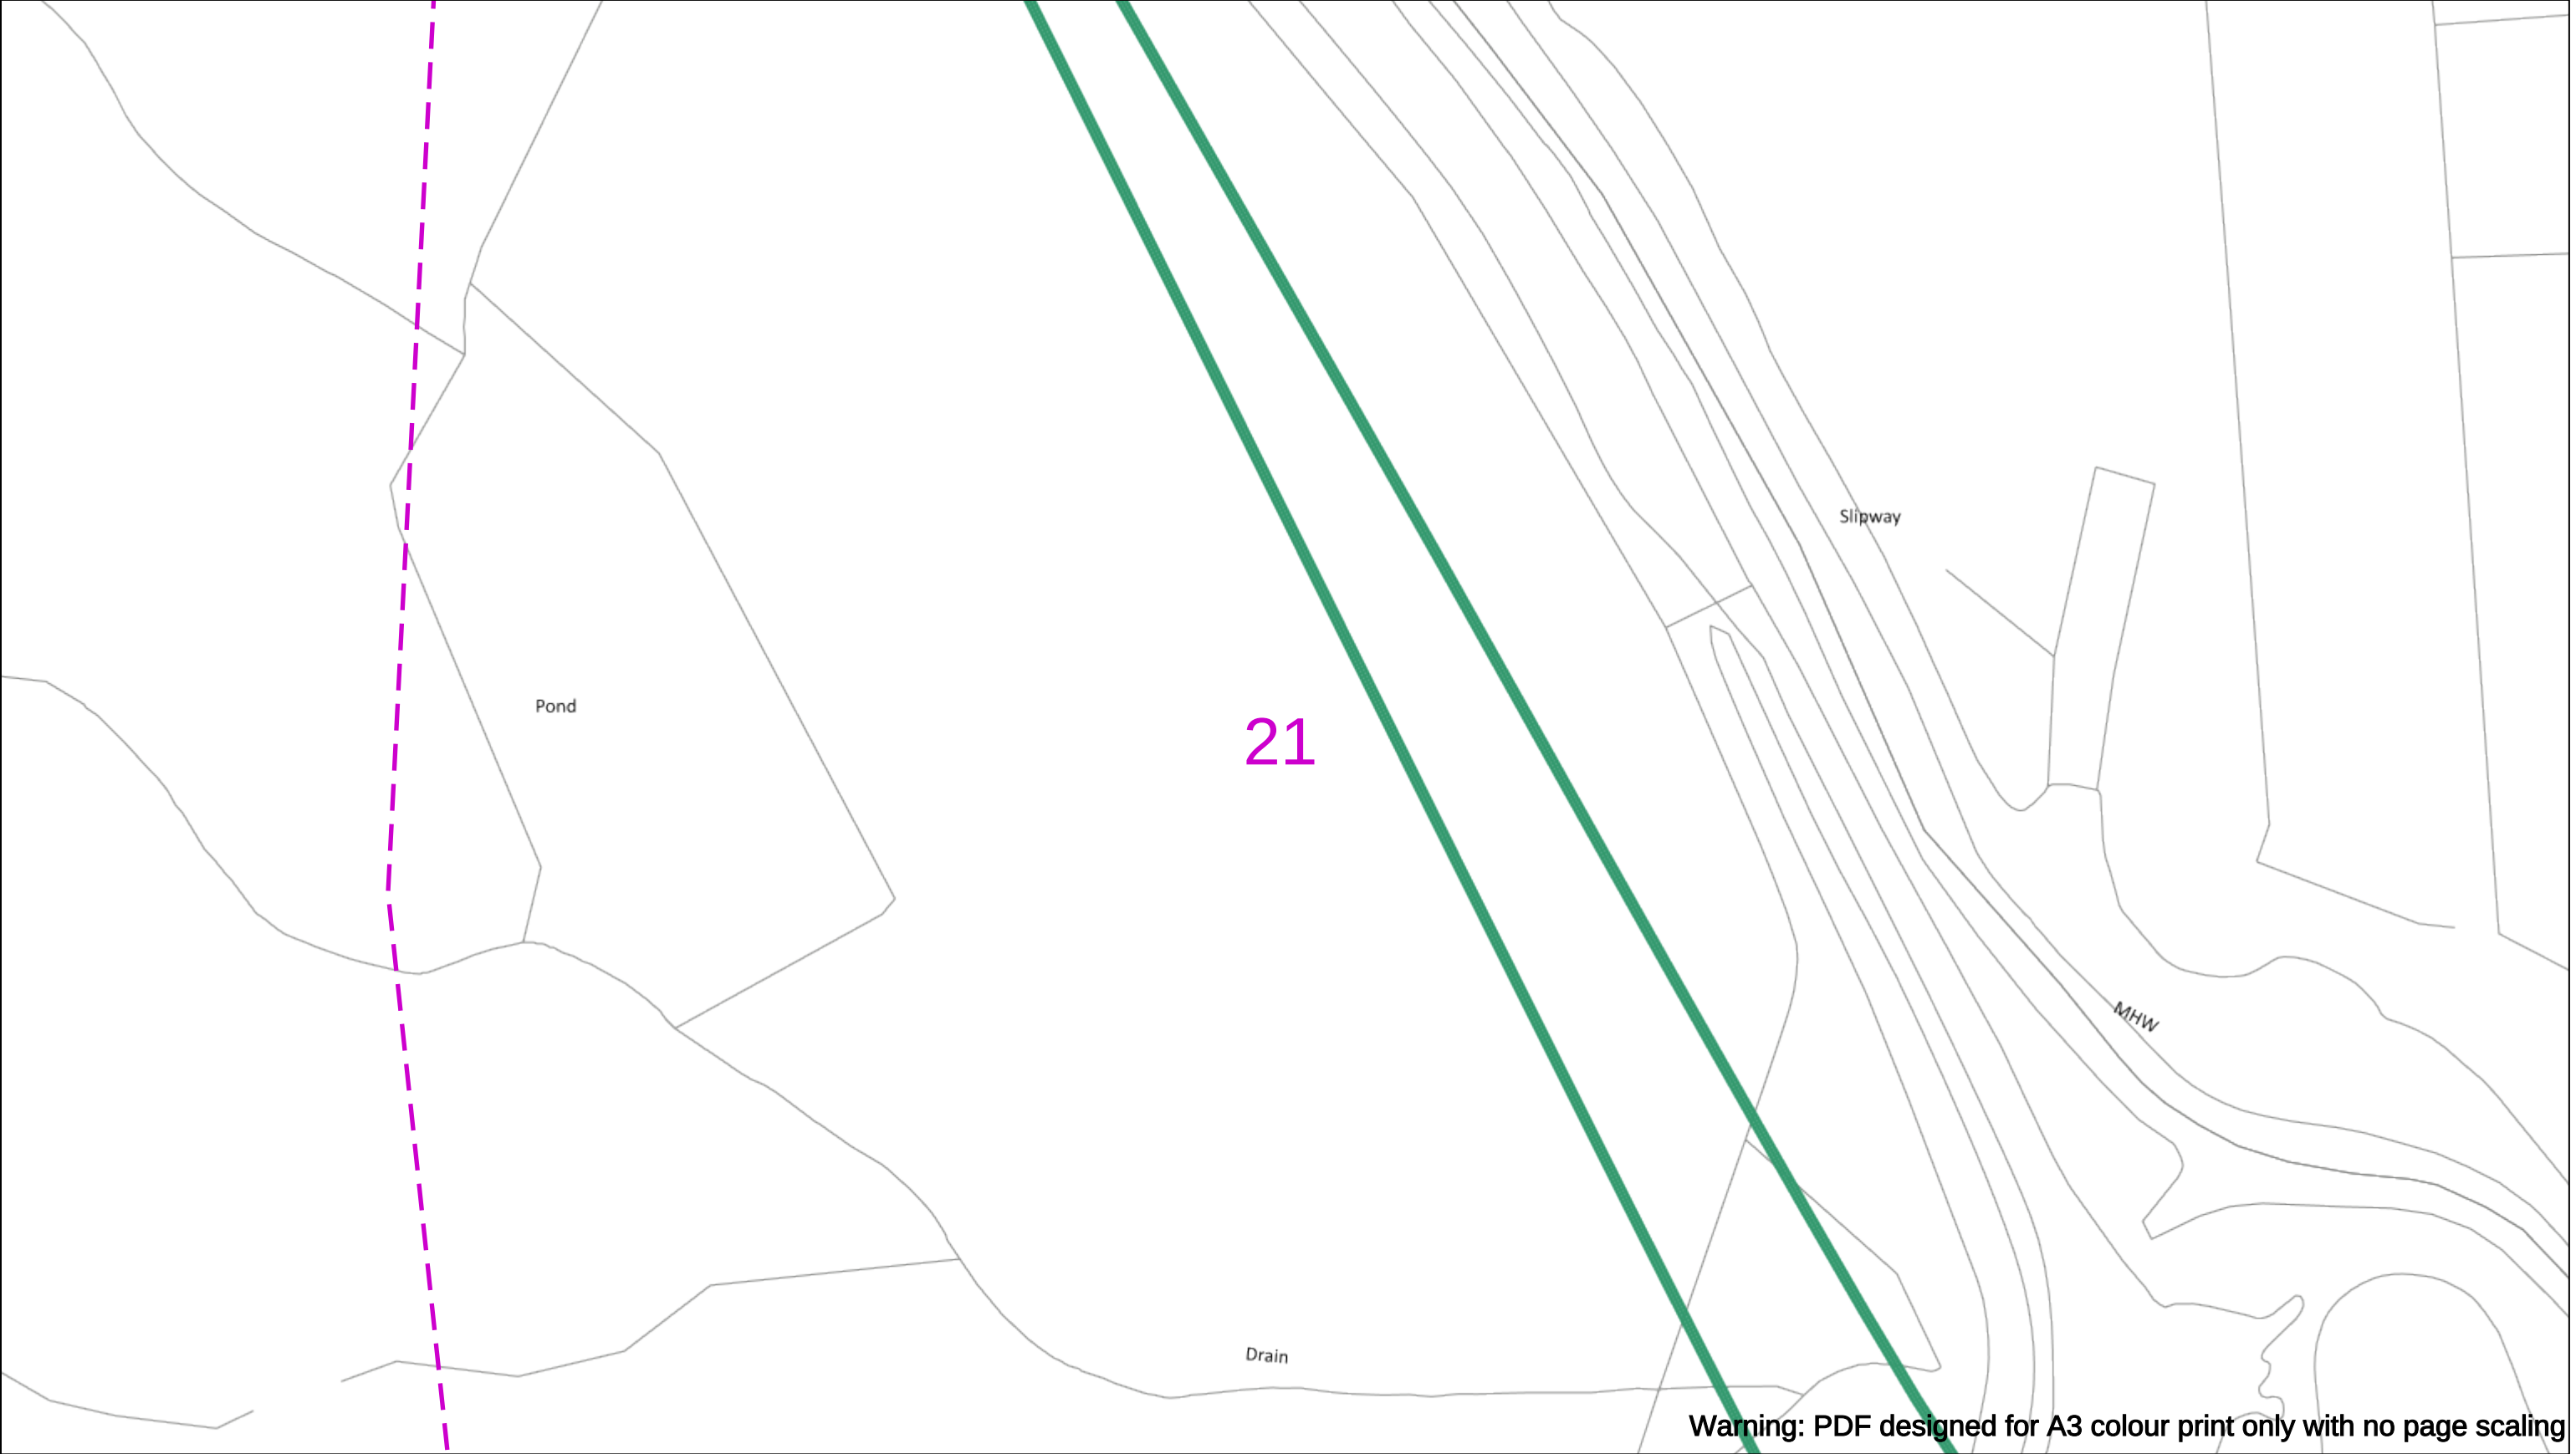

Warning: PDF designed for A3 colour print only with no page scaling

050m

Dig Sites

Area:

Line:

Extra High Voltage cables in vicinity

Date Requested: 03/09/2021

Job Reference: 23169206

Site Location: 471818 104822

Requested by:
Miss Rebecca Dabbs

Your Scheme/Reference: 736036

Langstone Flood & Coastal

WARNING

There may have been subsequent alteration to the surface levels. Trial holes must be undertaken to determine position and depths of cables. HS (G) 47 Booklet from the Health and Safety Executive – Avoiding Danger from Buried Cables – should be consulted before commencing excavation work.

WHEN WORKING IN THE VICINITY OF OVERHEAD LINES THE HEALTH AND SAFETY GUIDANCE NOTES GS6 SHOULD BE CONSULTED (AVAILABLE FROM THE HSE WEBSITE)

Voltages (V)				
LV (Low Voltage) and Services	Up to 1,000V			
HV (High Voltage)	Over 1,000V to 11,000V			
EHV (Extra High Voltage)	22,000V to 132,000V			
Transmission	275,000V and 400,000V			

NORMAL DEPTH TO THE TOP OF THE CABLE WHEN LAID				
	Services	LV	HV	EHV
Footpath/Unmade	0.45m	0.45m	0.6m	0.8m
Road Crossing	0.6m	0.6m	0.75m	0.9m
Agricultural	1m	1m	1m	1.1m

Legend

Service Cable

LV Mains

2-33kV

66kV

132kV

220kV

330kV

660kV

132kV

275kV

400kV

Fibre Optic

Pilot Cable

Distribution Structures (Electric)

Pole, Existing Location

Pole Structure, Existing Location - Single

Pole Structure, Existing Location - H

Duct Route

Cross Section Route

Southern Electric Power Distribution plc

Registered Office: No.1 Forbury Place

43 Forbury Road Reading RG1 3JH

Registered In England & Wales No.04094290

If you're unsure & need to seek advice before commencing excavations please contact:

General Enquiries: 0800 048 3516

Subject to revision – Master held by SSEN Asset Data Team:


Asset.Data@sse.com

01256 337 294

Scale: 1:500 (When plotted at A3)

BASED UPON THE ORDNANCE SURVEY MAP WITH THE SANCTION OF THE CONTROLLER OF THE STATIONERY OFFICE CROWN COPYRIGHT RESERVED.

This copy has been made by or with the authority of Scottish and Southern Energy Power Distribution Ltd. Pursuant to section 47 of the Copyright, Designs and Patents Act 1988 ('The Act'). Unless the Act provides a relevant exception to copyright the copy must not be copied without prior permission of the copyright owner. Plans generated by DigSAFE Pro™ software provided by LinesearchbeforeUdig.

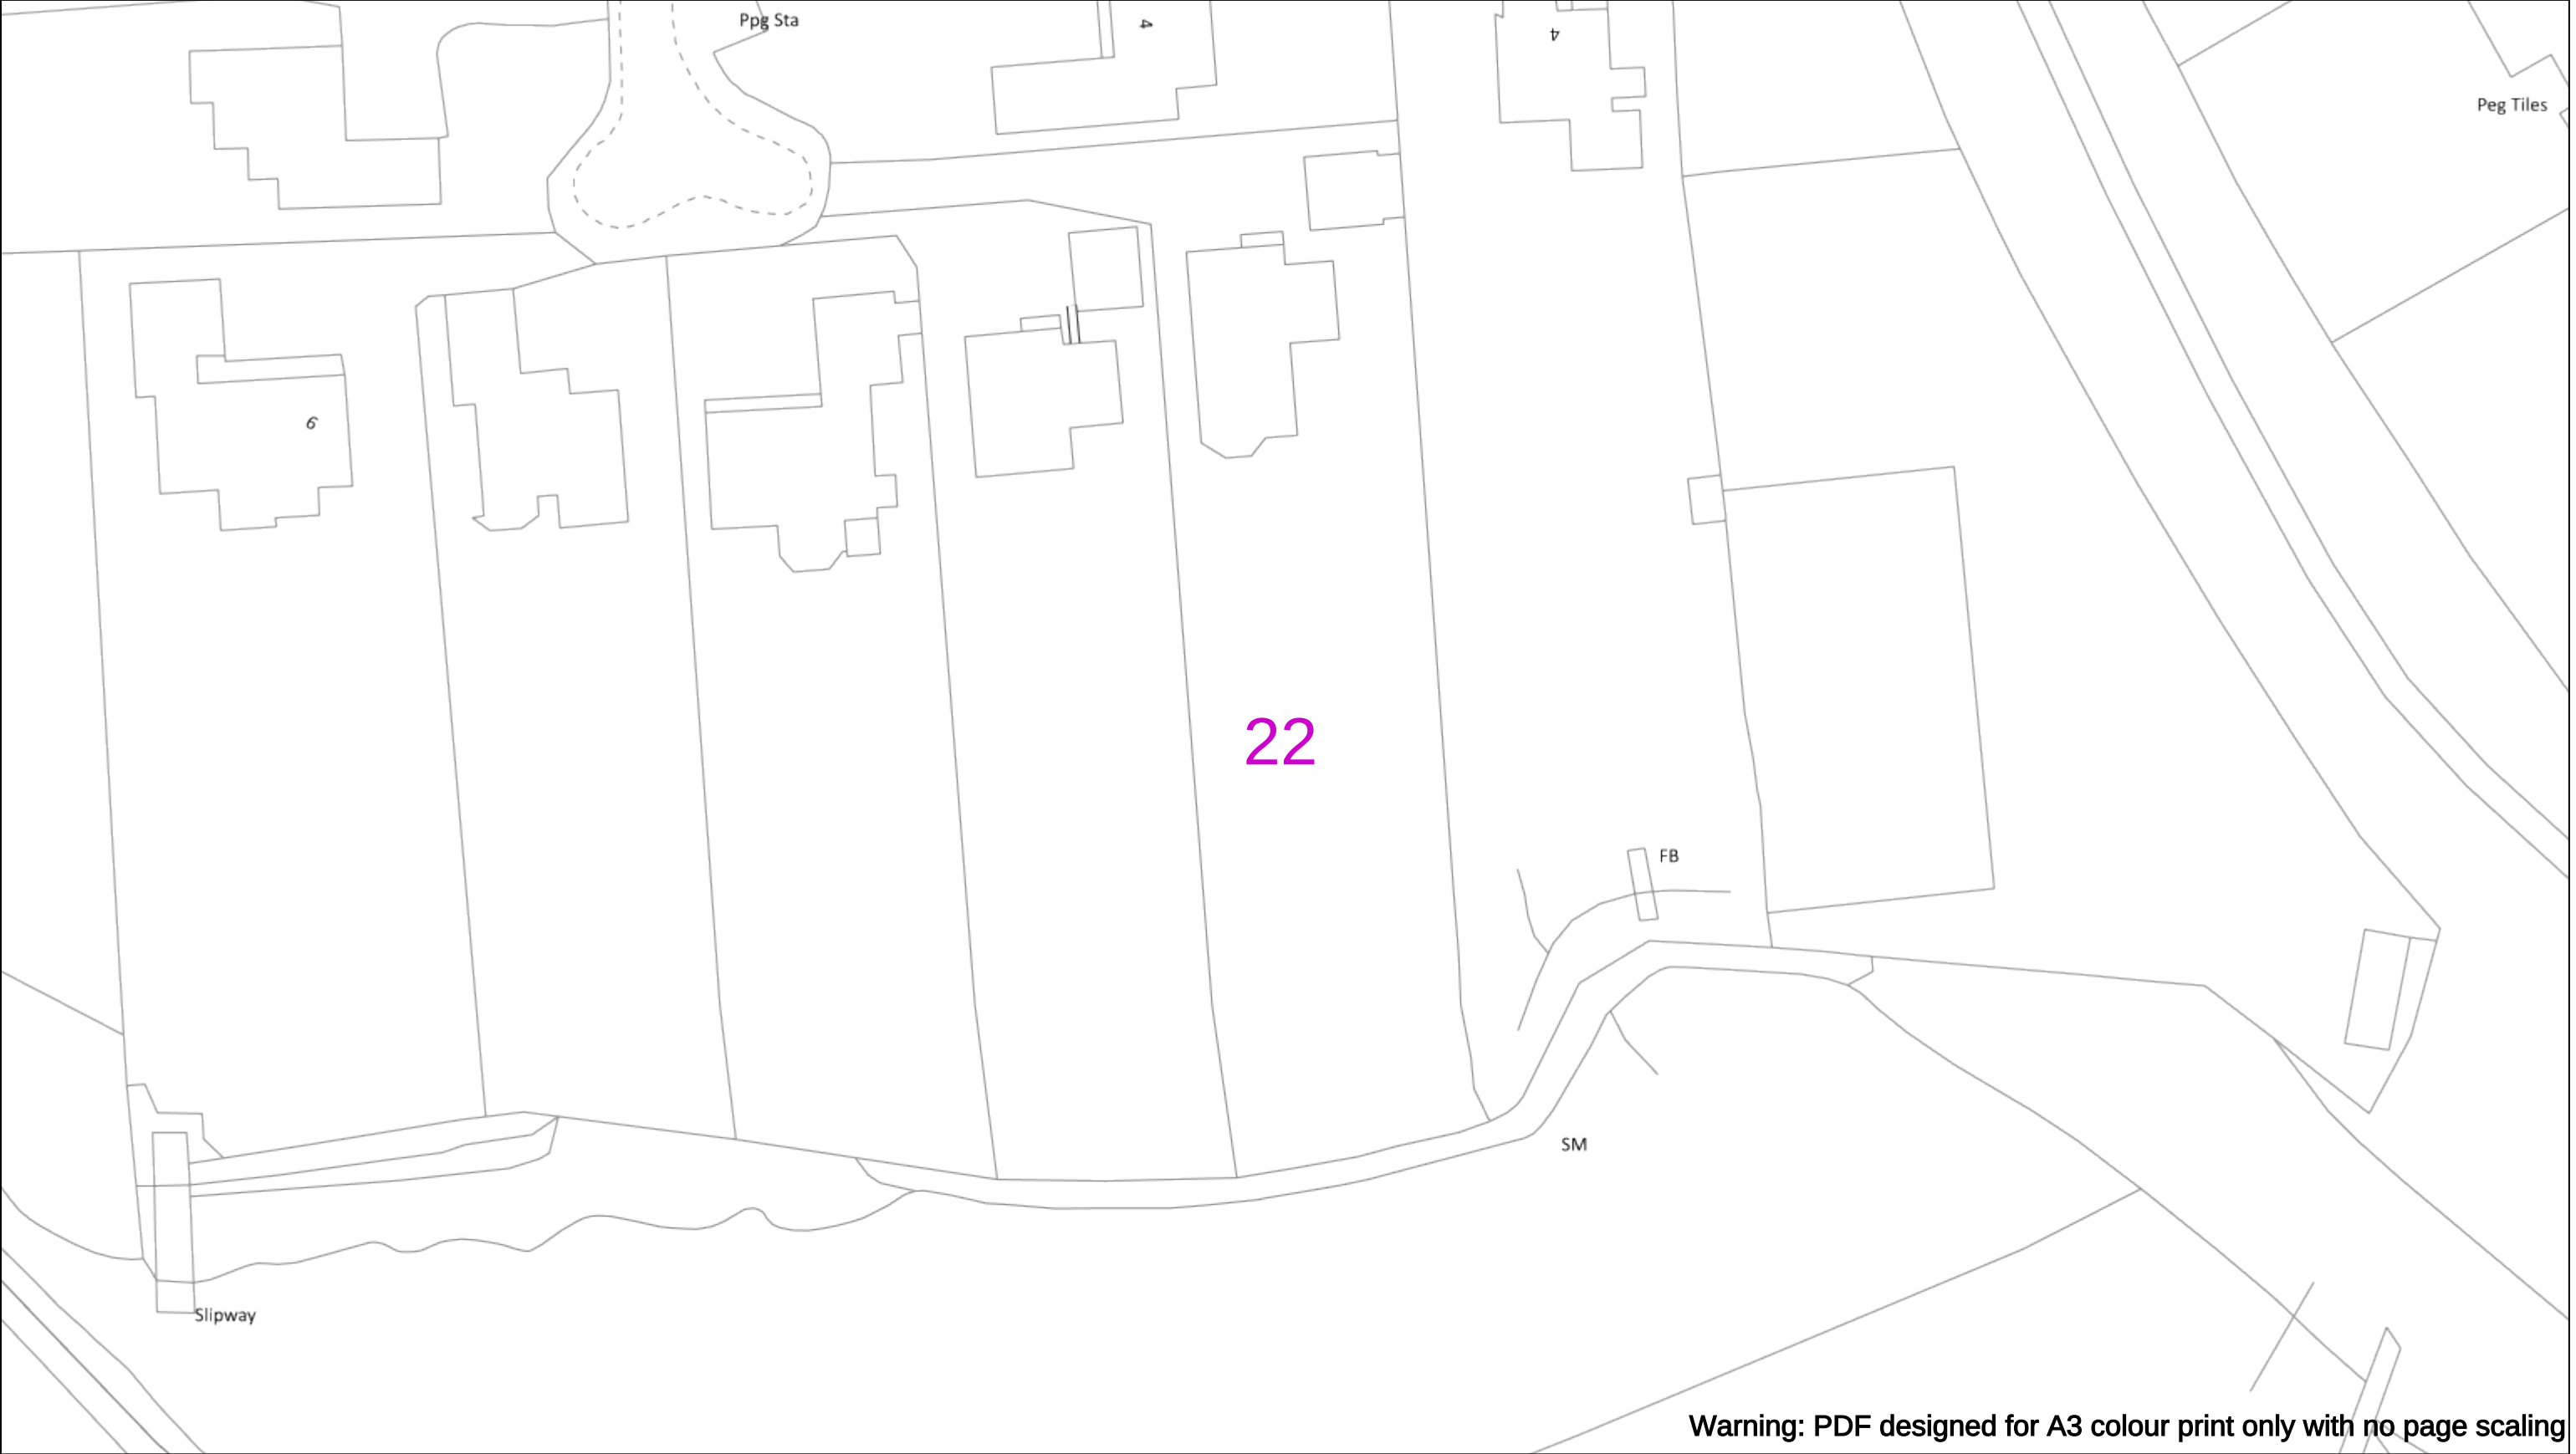

Warning: PDF designed for A3 colour print only with no page scaling

050m

Dig Sites

Area:

Line:

Extra High Voltage cables in vicinity

Date Requested: 03/09/2021

Job Reference: 23169206

Site Location: 471818 104822

Requested by:

Miss Rebecca Dabbs

Your Scheme/Reference: 736036

Langstone Flood & Coastal

WARNING

There may have been subsequent alteration to the surface levels. Trial holes must be undertaken to determine position and depths of cables. HS (G) 47 Booklet from the Health and Safety Executive – Avoiding Danger from Buried Cables – should be consulted before commencing excavation work.

WHEN WORKING IN THE VICINITY OF OVERHEAD LINES THE HEALTH AND SAFETY GUIDANCE NOTES GS6 SHOULD BE CONSULTED (AVAILABLE FROM THE HSE WEBSITE)

	Voltages (V)			
LV (Low Voltage) and Services	Up to 1,000V			
HV (High Voltage)	Over 1,000V to 11,000V			
EHV (Extra High Voltage)	22,000V to 132,000V			
Transmission	275,000V and 400,000V			

	NORMAL DEPTH TO THE TOP OF THE CABLE WHEN LAID			
	Services	LV	HV	EHV
Footpath/Unmade	0.45m	0.45m	0.6m	0.8m
Road Crossing	0.6m	0.6m	0.75m	0.9m
Agricultural	1m	1m	1m	1.1m

Legend

Service Cable

10/ Mains

2-3.3kV

6.6kV

13kV

23kV

33kV

66kV

132kV

275kV

400kV

Fibre Optic

Pilot Cable

Distribution Structures [Electric]

Pole, Existing Location

Pole Structure, Existing Location - Single

Pole Structure, Existing Location - H

Duct Route

Cross Section Route

Southern Electric Power Distribution plc

Registered Office: No.1 Forbury Place

43 Forbury Road Reading RG1 3JH

Registered In England & Wales No.04094290

If you're unsure & need to seek advice before commencing excavations please contact:

General Enquiries: 0800 048 3516

Subject to revision – Master held by SSEN Asset Data Team:


Asset.Data@sse.com

01256 337 294

Scale: 1:500 (When plotted at A3)

BASED UPON THE ORDNANCE SURVEY MAP WITH THE SANCTION OF THE CONTROLLER OF THE STATIONERY OFFICE CROWN COPYRIGHT RESERVED.

This copy has been made by or with the authority of Scottish and Southern Energy Power Distribution Ltd. Pursuant to section 47 of the Copyright, Designs and Patents Act 1988 ('The Act'). Unless the Act provides a relevant exception to copyright the copy must not be copied without prior permission of the copyright owner. Plans generated by DigSAFE Pro™ software provided by LinesearchbeforeUdig.

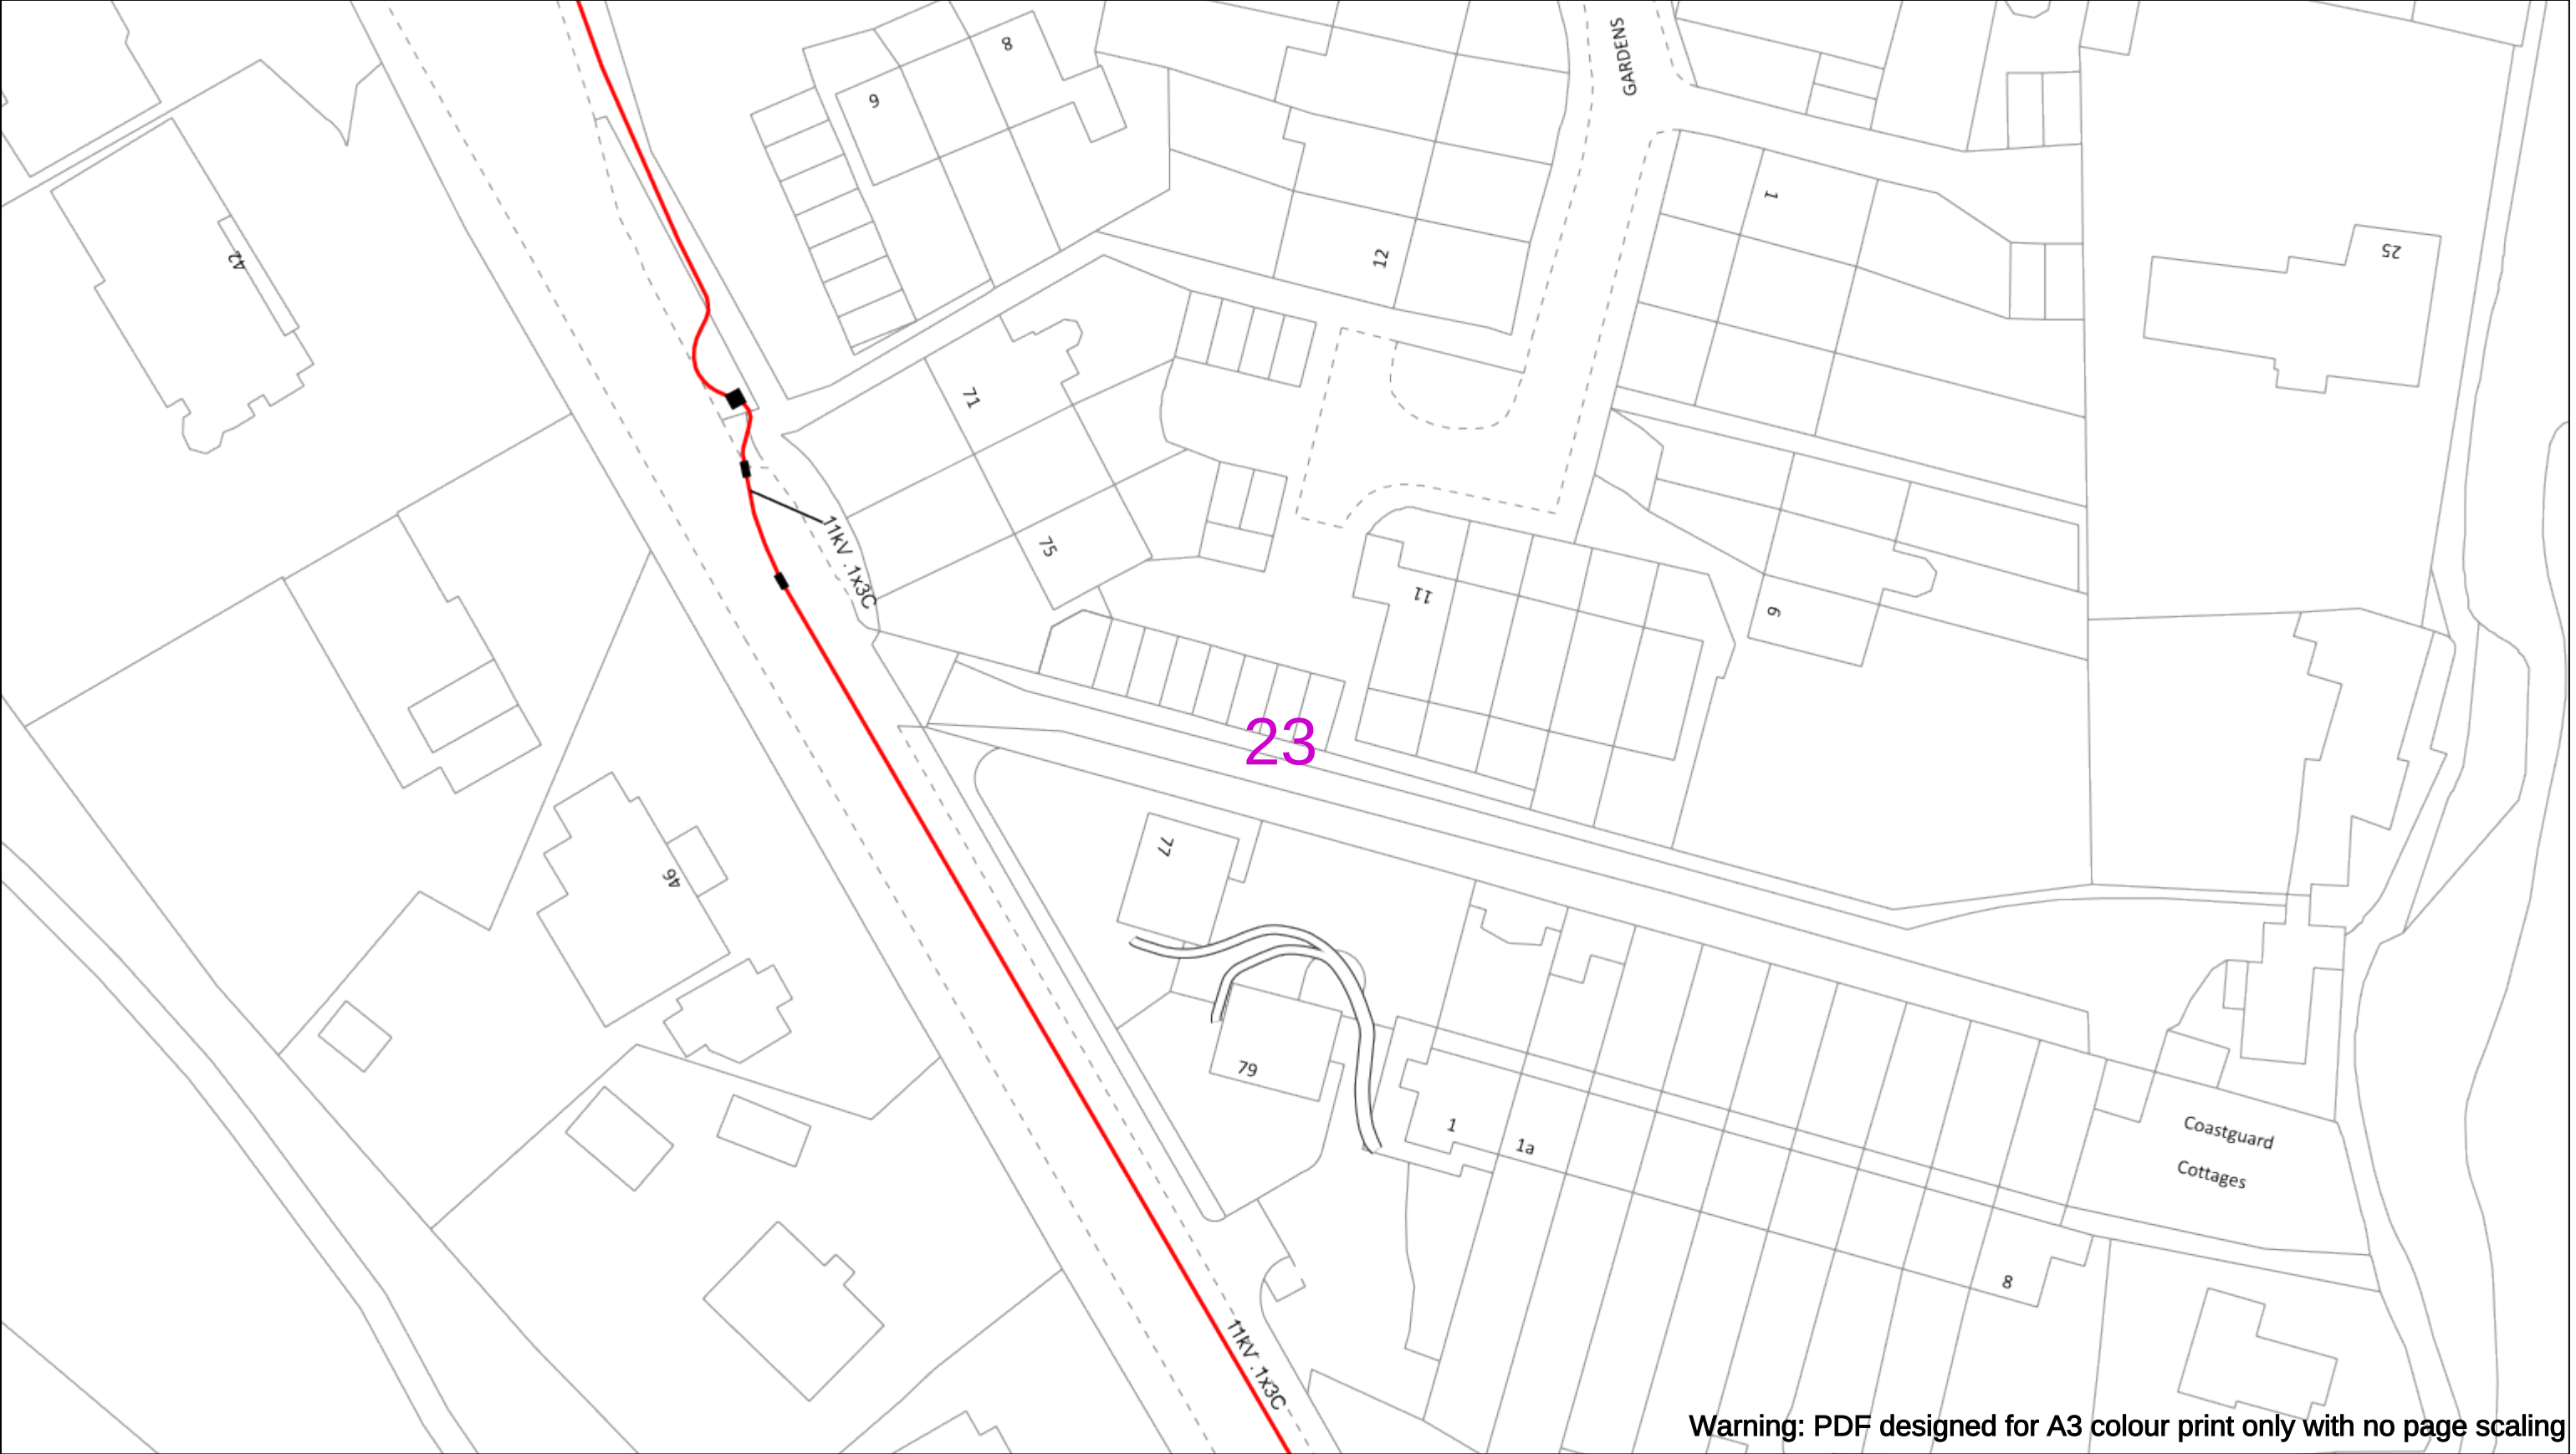

Warning: PDF designed for A3 colour print only with no page scaling

050m

Dig Sites

Area:

Line:

Extra High Voltage cables in vicinity

Date Requested: 03/09/2021

Job Reference: 23169206

Site Location: 471818 104822

Requested by:

Miss Rebecca Dabbs

Your Scheme/Reference: 736036

Langstone Flood & Coastal

WARNING

There may have been subsequent alteration to the surface levels. Trial holes must be undertaken to determine position and depths of cables. HS (G) 47 Booklet from the Health and Safety Executive – Avoiding Danger from Buried Cables – should be consulted before commencing excavation work.

WHEN WORKING IN THE VICINITY OF OVERHEAD LINES THE HEALTH AND SAFETY GUIDANCE NOTES GS6 SHOULD BE CONSULTED (AVAILABLE FROM THE HSE WEBSITE)

	Voltages (V)			
LV (Low Voltage) and Services	Up to 1,000V			
HV (High Voltage)	Over 1,000V to 11,000V			
EHV (Extra High Voltage)	22,000V to 132,000V			
Transmission	275,000V and 400,000V			

	NORMAL DEPTH TO THE TOP OF THE CABLE WHEN LAID			
	Services	LV	HV	EHV
Footpath/Unmade	0.45m	0.45m	0.6m	0.8m
Road Crossing	0.6m	0.6m	0.75m	0.9m
Agricultural	1m	1m	1m	1.1m

Legend

Service Cable

0V Mains

2-3.3kV

6.6kV

11kV

22kV

33kV

66kV

132kV

275kV

400kV

Fibre Optic

Pilot Cable

Distribution Structures (Electric)

Pole, Existing Location

Pole Structure, Existing Location - Single

Pole Structure, Existing Location - H

Duct Route

Cross Section Route

Southern Electric Power Distribution plc

Registered Office: No.1 Forbury Place

43 Forbury Road Reading RG1 3JH

Registered In England & Wales No.04094290

If you're unsure & need to seek advice before commencing excavations please contact:

General Enquiries: 0800 048 3516

Subject to revision – Master held by SSEN Asset Data Team:


Asset.Data@sse.com

01256 337 294

Scale: 1:500 (When plotted at A3)


BASED UPON THE ORDNANCE SURVEY MAP WITH THE SANCTION OF THE CONTROLLER OF THE STATIONERY OFFICE CROWN COPYRIGHT RESERVED.

This copy has been made by or with the authority of Scottish and Southern Energy Power Distribution Ltd. Pursuant to section 47 of the Copyright, Designs and Patents Act 1988 ('The Act'). Unless the Act provides a relevant exception to copyright the copy must not be copied without prior permission of the copyright owner. Plans generated by DigSAFE Pro™ software provided by LinesearchbeforeUdig.

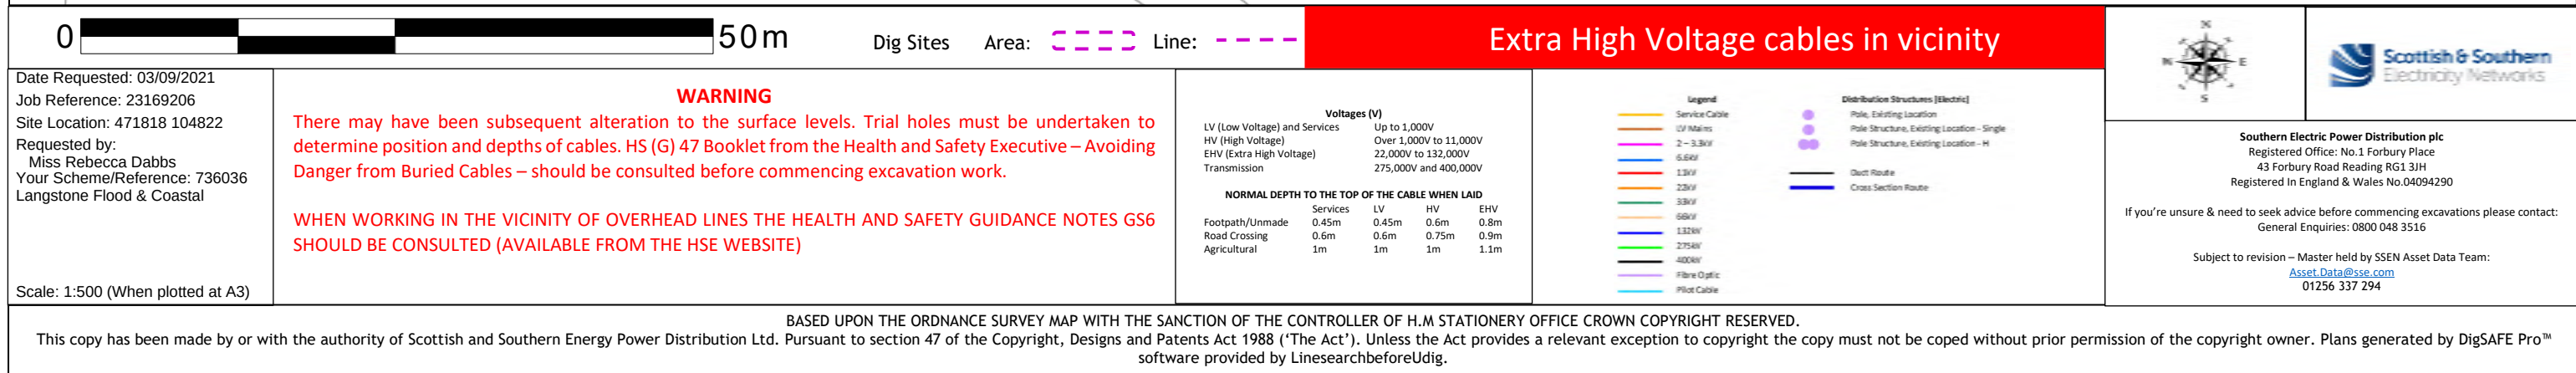

25

 Warning: PDF designed for A3 colour print only with no page scaling

0  50m Dig Sites Area:  Line:  Extra High Voltage cables in vicinity  



WARNING

There may have been subsequent alteration to the surface levels. Trial holes must be undertaken to determine position and depths of cables. HS (G) 47 Booklet from the Health and Safety Executive – Avoiding Danger from Buried Cables – should be consulted before commencing excavation work.

WHEN WORKING IN THE VICINITY OF OVERHEAD LINES THE HEALTH AND SAFETY GUIDANCE NOTES GS6 SHOULD BE CONSULTED (AVAILABLE FROM THE HSE WEBSITE)

Legend


- Service Cable
- LV Mains
- 2-3.3kV
- 6.6kV
- 13kV
- 22kV
- 33kV
- 66kV
- 132kV
- 275kV
- 400kV
- Fibre Optic
- Pilot Cable

Distribution Structures [Electric]

- Pole, Existing Location
- Pole Structure, Existing Location - S
- Pole Structure, Existing Location - H
- Duct Route
- Cross Section Route

Scale: 1:500 (When plotted at A3)

This copy has been made by or with the authority of Scottish and Southern Energy Power Distribution Ltd. Pursuant to section 47 of the Copyright, Designs and Patents Act 1988 ('The Act'). Unless the Act provides a relevant exception to copyright the copy must not be copied without prior permission of the copyright owner. Plans generated by DigSAFE Pro™ software provided by LinesearchbeforeUdig.

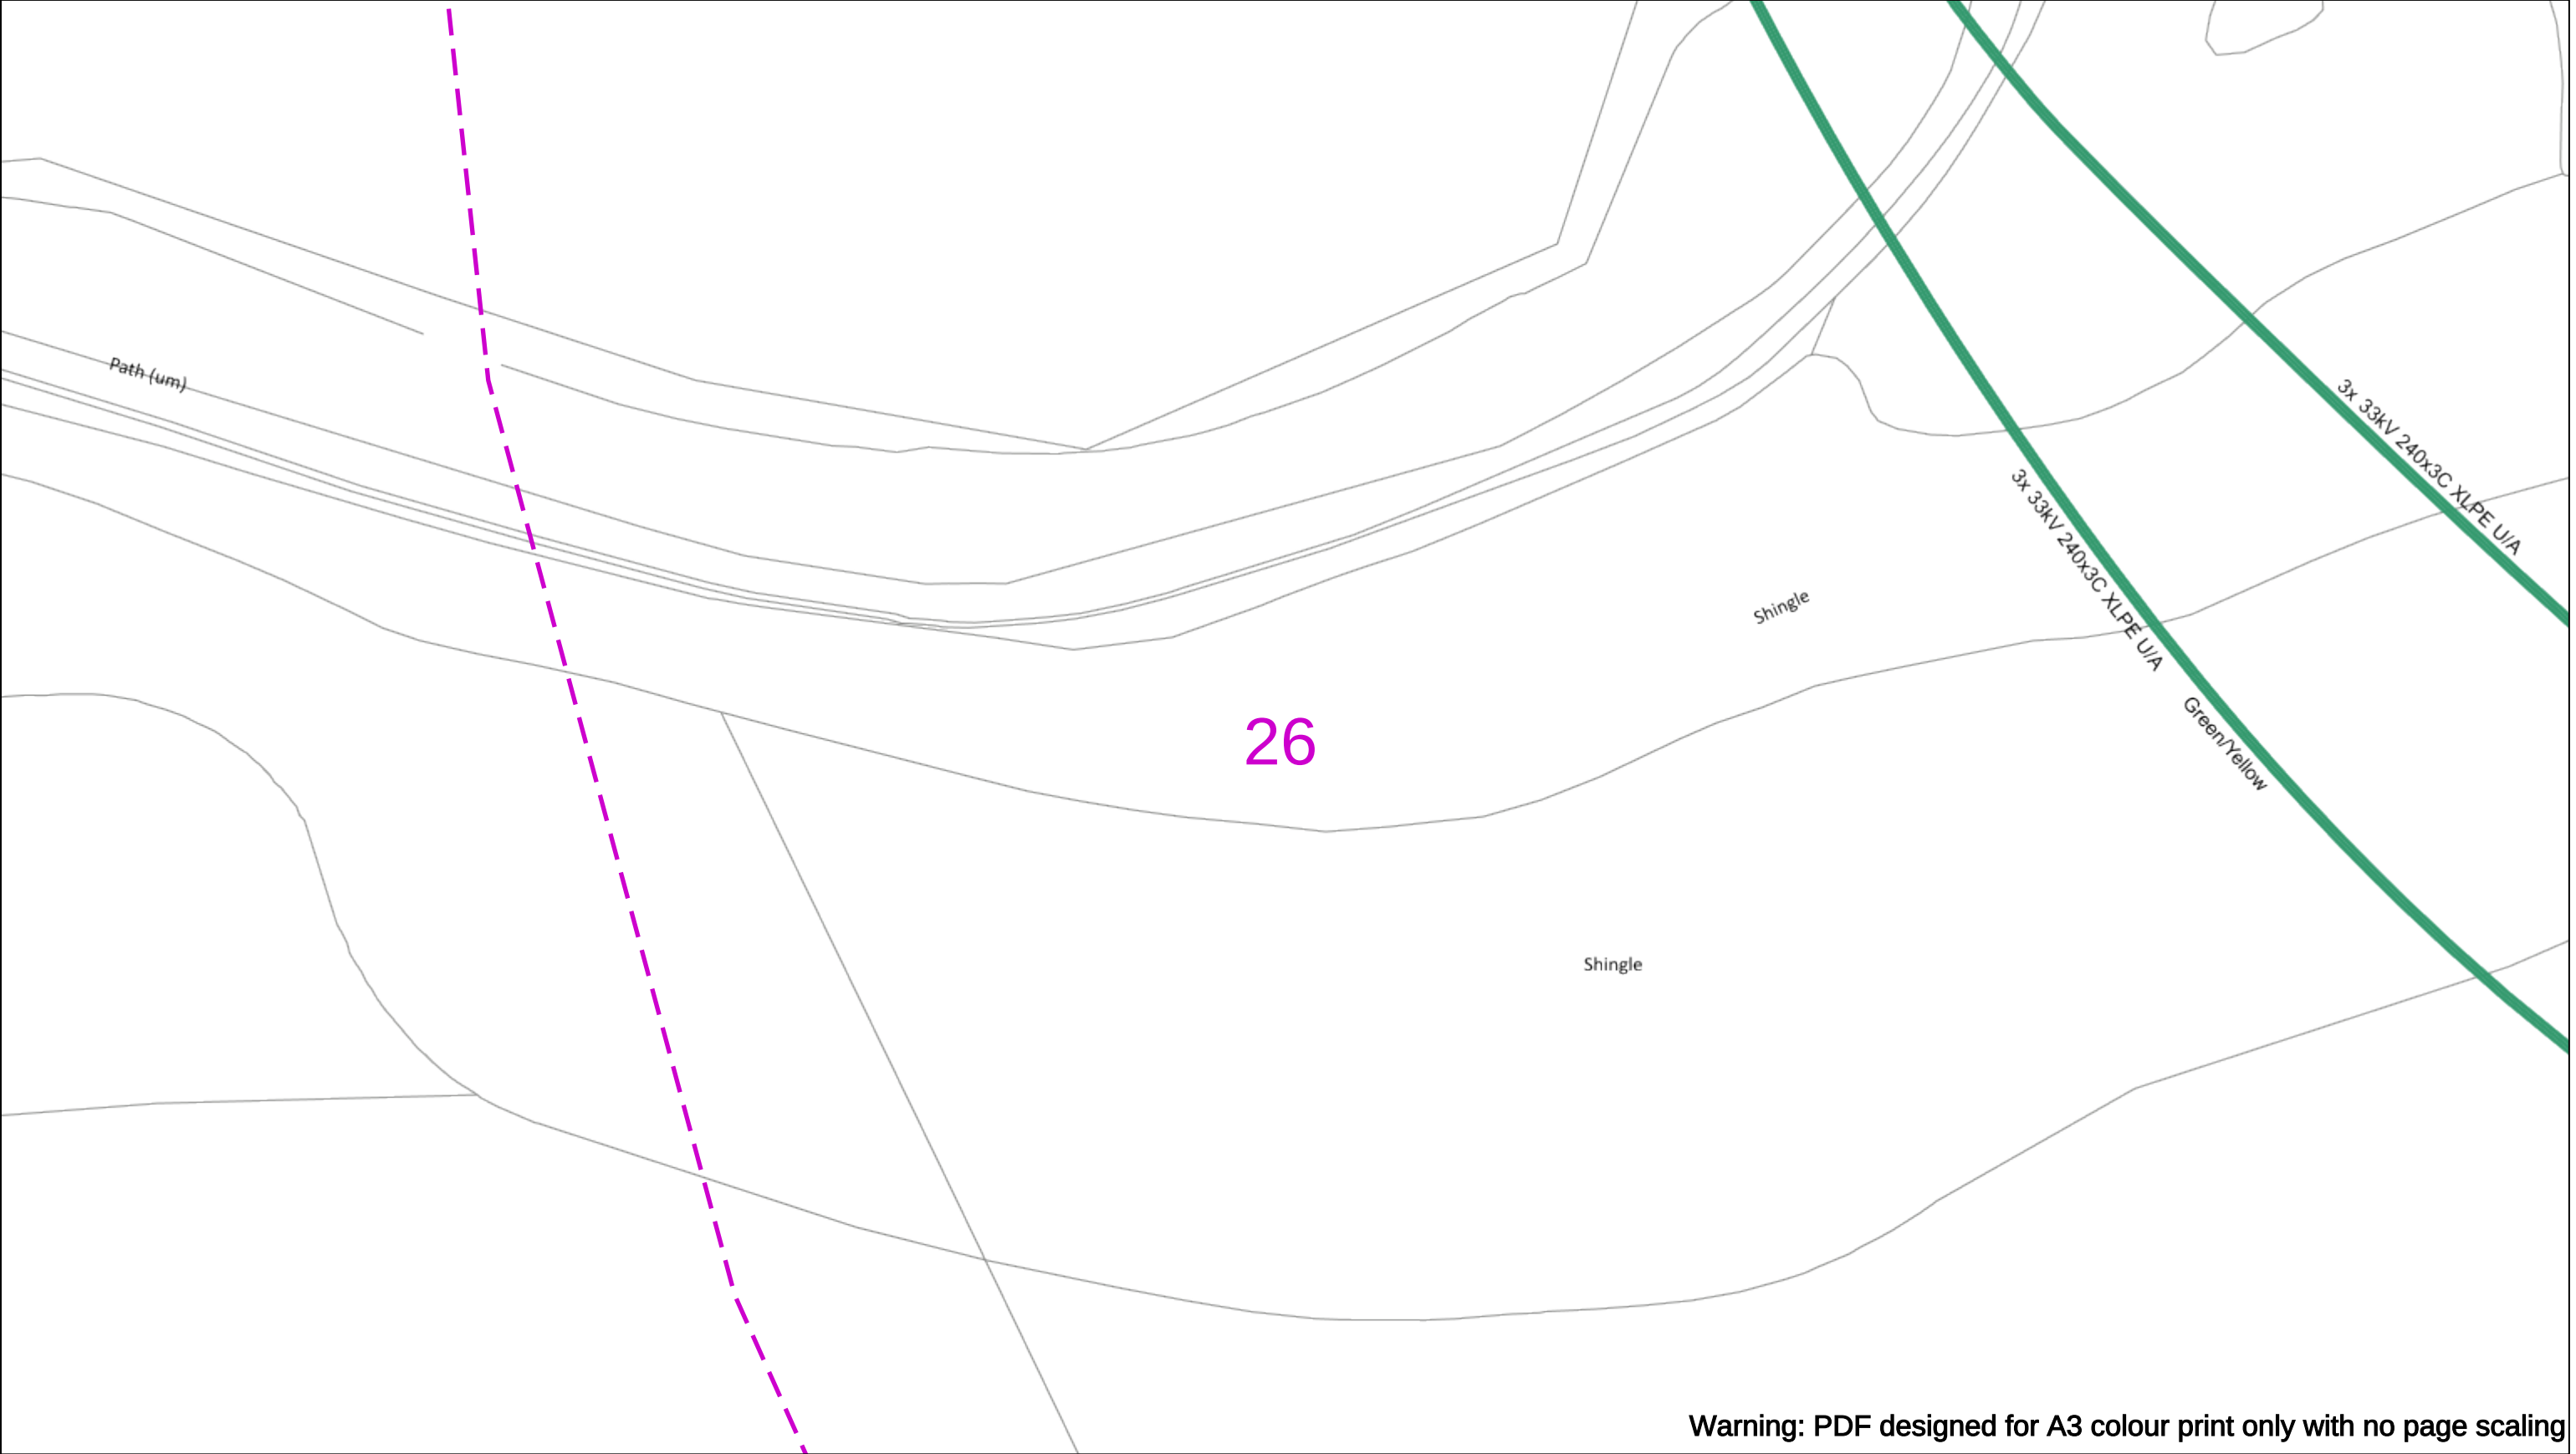

Warning: PDF designed for A3 colour print only with no page scaling

050m

Dig SitesArea: Line:

Extra High Voltage cables in vicinity

Date Requested: 03/09/2021

Job Reference: 23169206

Site Location: 471818 104822

Requested by:
Miss Rebecca Dabbs

Your Scheme/Reference: 736036

Langstone Flood & Coastal

WARNING

There may have been subsequent alteration to the surface levels. Trial holes must be undertaken to determine position and depths of cables. HS (G) 47 Booklet from the Health and Safety Executive – Avoiding Danger from Buried Cables – should be consulted before commencing excavation work.

WHEN WORKING IN THE VICINITY OF OVERHEAD LINES THE HEALTH AND SAFETY GUIDANCE NOTES GS6 SHOULD BE CONSULTED (AVAILABLE FROM THE HSE WEBSITE)

Voltages (V)

LV (Low Voltage) and ServicesUp to 1,000V

HV (High Voltage)Over 1,000V to 11,000V

EHV (Extra High Voltage)22,000V to 132,000V

Transmission275,000V and 400,000V

NORMAL DEPTH TO THE TOP OF THE CABLE WHEN LAID

	Services	LV	HV	EHV
Footpath/Unmade	0.45m	0.45m	0.6m	0.8m
Road Crossing	0.6m	0.6m	0.75m	0.9m
Agricultural	1m	1m	1m	1.1m

Legend

Service Cable

10/ Mains

2 – 33kV

6.6kV

13kV

23kV

33kV

66kV

132kV

275kV

400kV

Fibre Optic

Pilot Cable

Distribution Structures [Electric]

Pole, Existing Location

Pole Structure, Existing Location – Single

Pole Structure, Existing Location – H

Duct Route

Cross Section Route

Southern Electric Power Distribution plc

Registered Office: No.1 Forbury Place

43 Forbury Road Reading RG1 3JH

Registered In England & Wales No.04094290

If you're unsure & need to seek advice before commencing excavations please contact:

General Enquiries: 0800 048 3516

Subject to revision – Master held by SSEN Asset Data Team:


Asset.Data@sse.com

01256 337 294

Scale: 1:500 (When plotted at A3)

BASED UPON THE ORDNANCE SURVEY MAP WITH THE SANCTION OF THE CONTROLLER OF THE STATIONERY OFFICE CROWN COPYRIGHT RESERVED.

This copy has been made by or with the authority of Scottish and Southern Energy Power Distribution Ltd. Pursuant to section 47 of the Copyright, Designs and Patents Act 1988 ('The Act'). Unless the Act provides a relevant exception to copyright the copy must not be copied without prior permission of the copyright owner. Plans generated by DigSAFE Pro™ software provided by LinesearchbeforeUdig.

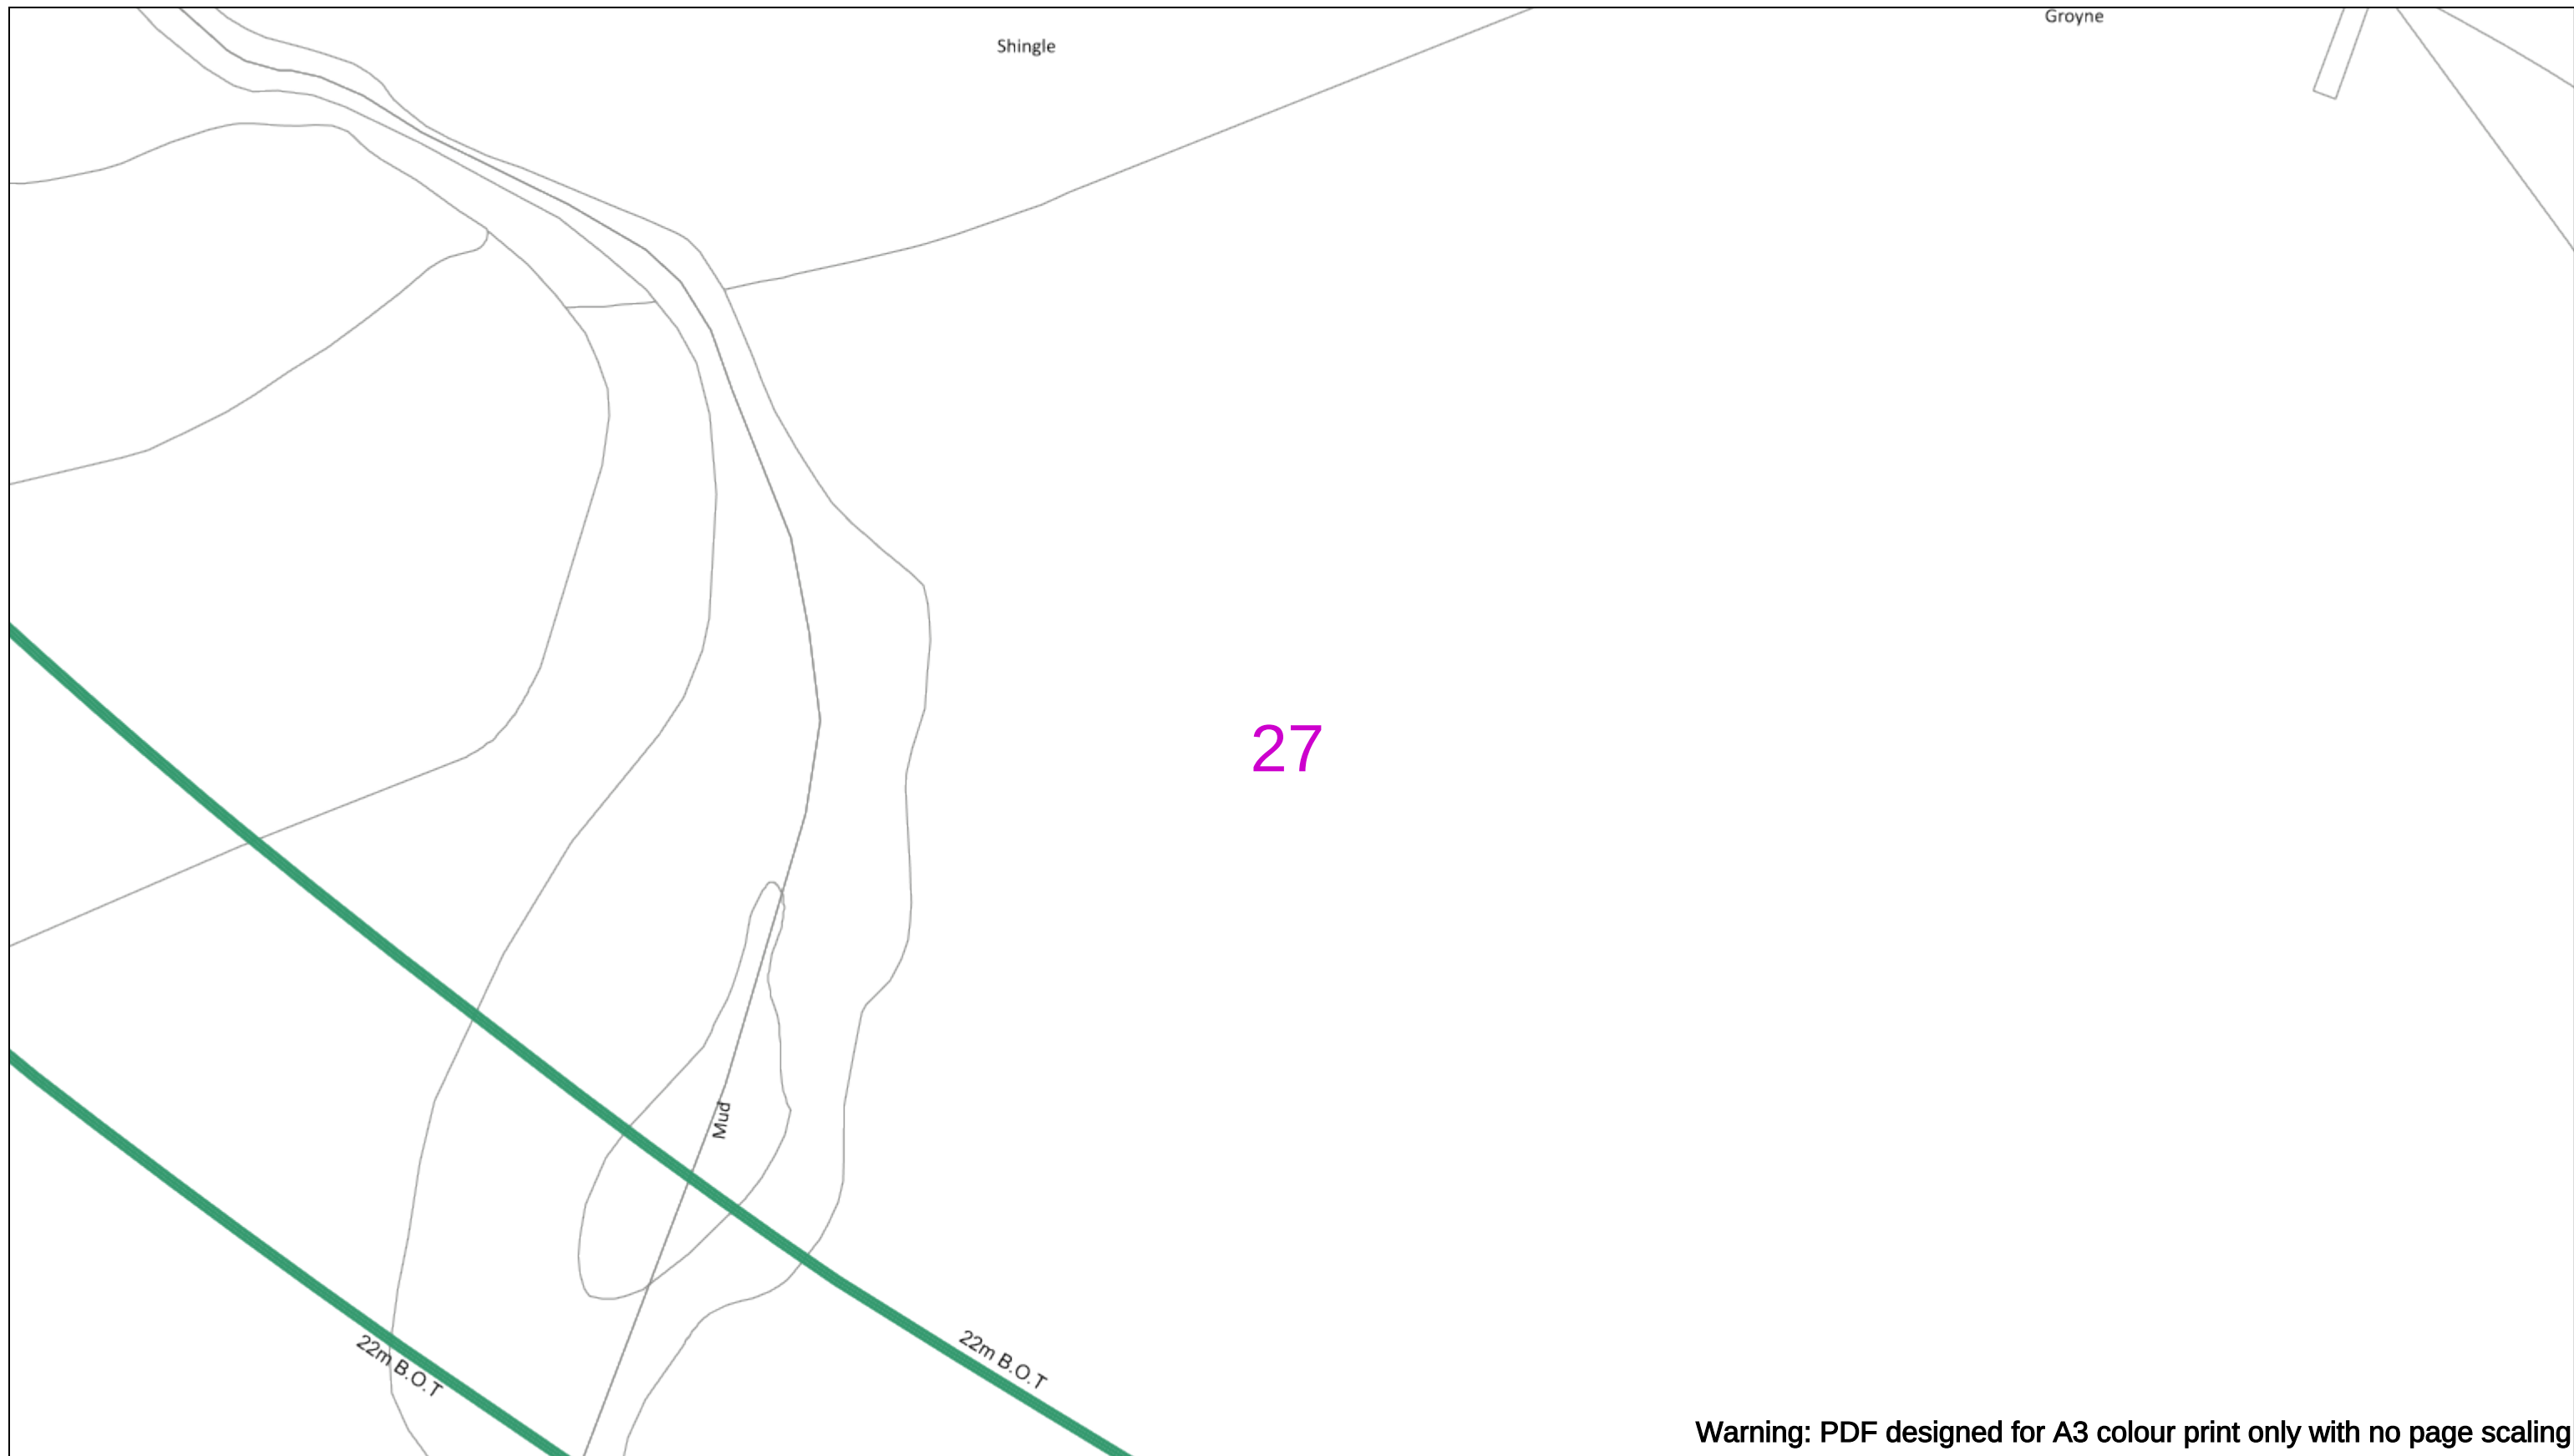

Warning: PDF designed for A3 colour print only with no page scaling



Dig Sites Area: Line:

Extra High Voltage cables in vicinity



Date Requested: 03/09/2021
Job Reference: 23169206
Site Location: 471818 104822
Requested by:
Miss Rebecca Dabbs
Your Scheme/Reference: 736036
Langstone Flood & Coastal

WARNING

There may have been subsequent alteration to the surface levels. Trial holes must be undertaken to determine position and depths of cables. HS (G) 47 Booklet from the Health and Safety Executive – Avoiding Danger from Buried Cables – should be consulted before commencing excavation work.

WHEN WORKING IN THE VICINITY OF OVERHEAD LINES THE HEALTH AND SAFETY GUIDANCE NOTES GS6 SHOULD BE CONSULTED (AVAILABLE FROM THE HSE WEBSITE)

Voltages (V)				
LV (Low Voltage) and Services		Up to 1,000V		
HV (High Voltage)		Over 1,000V to 11,000V		
EHV (Extra High Voltage)		22,000V to 132,000V		
Transmission		275,000V and 400,000V		
NORMAL DEPTH TO THE TOP OF THE CABLE WHEN LAID				
	Services	LV	HV	EHV
Footpath/Unmade	0.45m	0.45m	0.6m	0.7m
Road Crossing	0.6m	0.6m	0.75m	0.7m
Agricultural	1m	1m	1m	1.1m

Legend

- Service Cable
- UV Mats
- 2 - 3.3kV
- 6.6kV
- 13kV
- 23kV
- 38kV
- 69kV
- 132kV
- 275kV
- 400kV
- Fibre Optic
- Pilot Cable

Distribution Structures [Electric]

- Pole, Existing Location
- Pole Structure, Existing Location - Single
- Pole Structure, Existing Location - H
- Duct Route
- Cross Section Route

Southern Electric Power Distribution plc
Registered Office: No.1 Forbury Place
43 Forbury Road Reading RG1 3JH
Registered In England & Wales No.04094290


If you're unsure & need to seek advice before commencing excavations please contact:
General Enquiries: 0800 048 3516

Subject to revision – Master held by SSEN Asset Data Team:
Asset.Data@sse.com
 01256 337 294

Scale: 1:500 (When plotted at A3)

BASED UPON THE ORDNANCE SURVEY MAP WITH THE SANCTION OF THE CONTROLLER OF H.M STATIONERY OFFICE CROWN COPYRIGHT RESERVED.

This copy has been made by or with the authority of Scottish and Southern Energy Power Distribution Ltd. Pursuant to section 47 of the Copyright, Designs and Patents Act 1988 ('The Act'). Unless the Act provides a relevant exception to copyright the copy must not be copied without prior permission of the copyright owner. Plans generated by DigSAFE Pro™ software provided by LinesearchbeforeUdig.

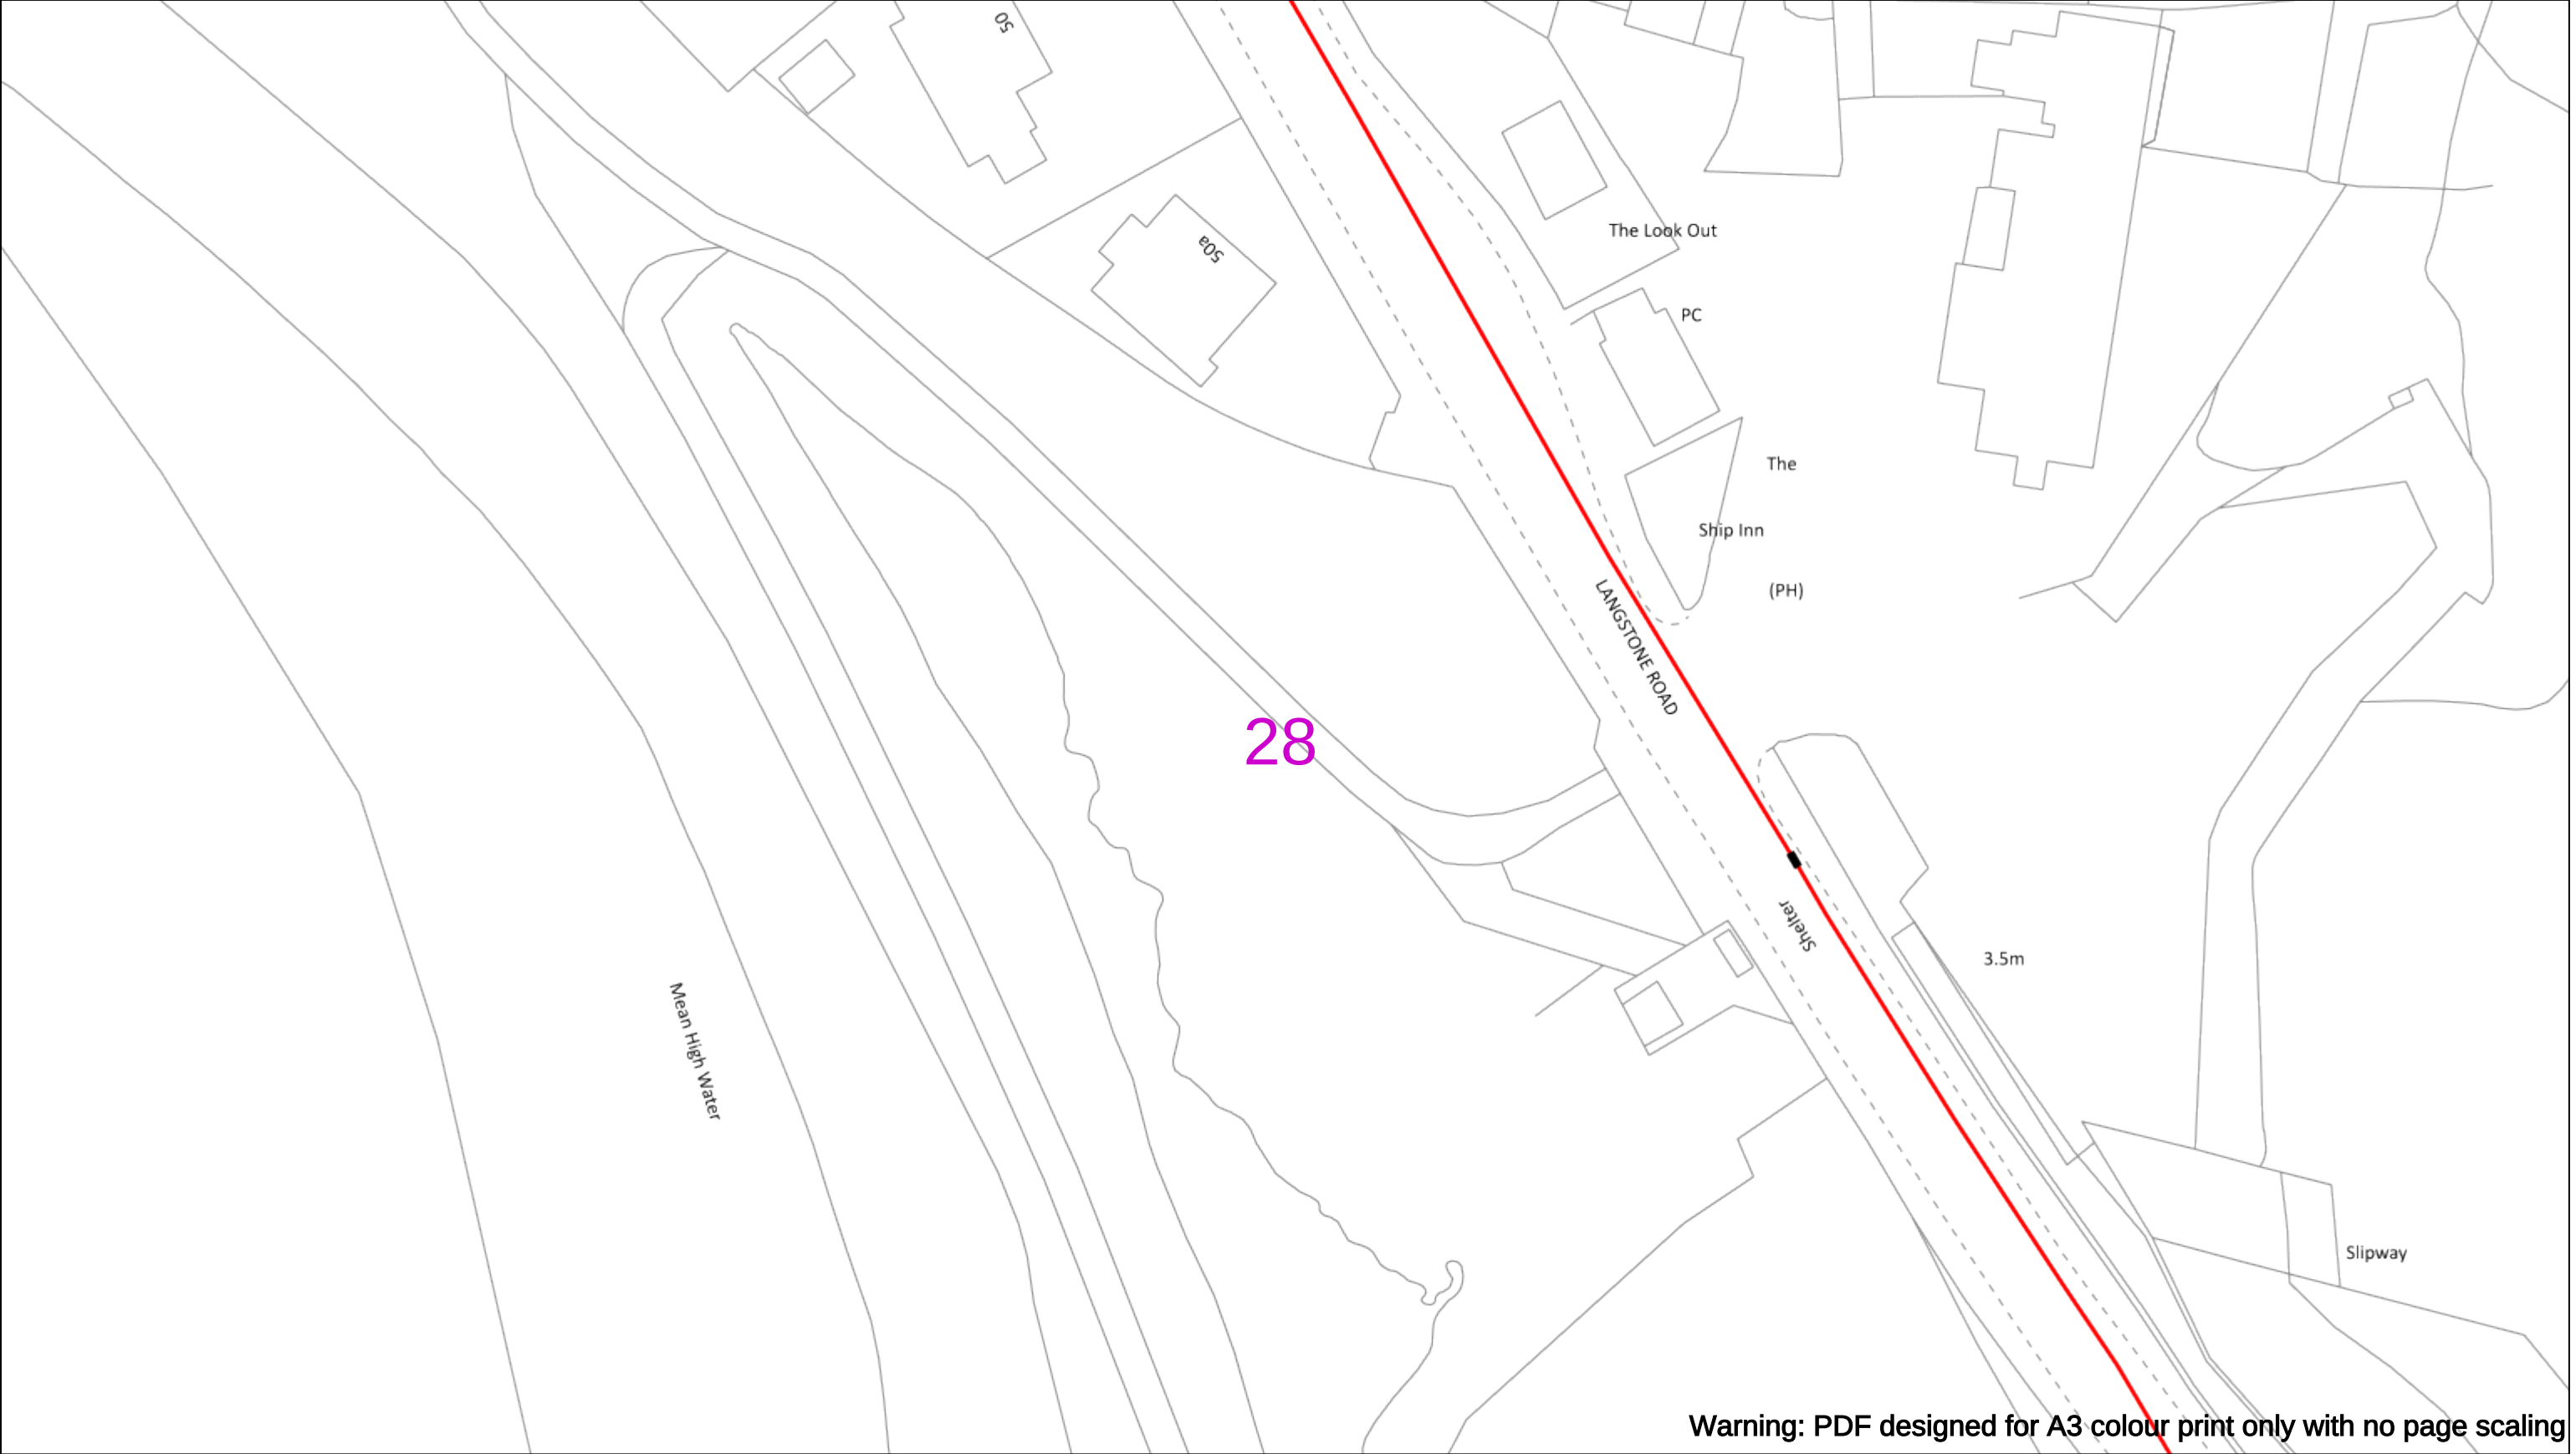

Warning: PDF designed for A3 colour print only with no page scaling

050m

Dig Sites

Area:

Line:

Extra High Voltage cables in vicinity

Date Requested: 03/09/2021

Job Reference: 23169206

Site Location: 471818 104822

Requested by:

Miss Rebecca Dabbs

Your Scheme/Reference: 736036

Langstone Flood & Coastal

WARNING

There may have been subsequent alteration to the surface levels. Trial holes must be undertaken to determine position and depths of cables. HS (G) 47 Booklet from the Health and Safety Executive – Avoiding Danger from Buried Cables – should be consulted before commencing excavation work.

WHEN WORKING IN THE VICINITY OF OVERHEAD LINES THE HEALTH AND SAFETY GUIDANCE NOTES GS6 SHOULD BE CONSULTED (AVAILABLE FROM THE HSE WEBSITE)

	Voltages (V)			
LV (Low Voltage) and Services	Up to 1,000V			
HV (High Voltage)	Over 1,000V to 11,000V			
EHV (Extra High Voltage)	22,000V to 132,000V			
Transmission	275,000V and 400,000V			

	NORMAL DEPTH TO THE TOP OF THE CABLE WHEN LAID			
	Services	LV	HV	EHV
Footpath/Unmade	0.45m	0.45m	0.6m	0.8m
Road Crossing	0.6m	0.6m	0.75m	0.9m
Agricultural	1m	1m	1m	1.1m

Legend

Service Cable

0V Mains

2 – 3.3kV

6.6kV

11kV

22kV

33kV

66kV

132kV

275kV

400kV

Fibre Optic

Pilot Cable

Distribution Structures (Electric)

Pole, Existing Location

Pole Structure, Existing Location – Single

Pole Structure, Existing Location – H

Duct Route

Cross Section Route

Southern Electric Power Distribution plc

Registered Office: No.1 Forbury Place

43 Forbury Road Reading RG1 3JH

Registered In England & Wales No.04094290

If you're unsure & need to seek advice before commencing excavations please contact:

General Enquiries: 0800 048 3516

Subject to revision – Master held by SSEN Asset Data Team:


Asset.Data@sse.com


01256 337 294

Scale: 1:500 (When plotted at A3)

BASED UPON THE ORDNANCE SURVEY MAP WITH THE SANCTION OF THE CONTROLLER OF THE STATIONERY OFFICE CROWN COPYRIGHT RESERVED.

This copy has been made by or with the authority of Scottish and Southern Energy Power Distribution Ltd. Pursuant to section 47 of the Copyright, Designs and Patents Act 1988 ('The Act'). Unless the Act provides a relevant exception to copyright the copy must not be copied without prior permission of the copyright owner. Plans generated by DigSAFE Pro™ software provided by LinesearchbeforeUdig.

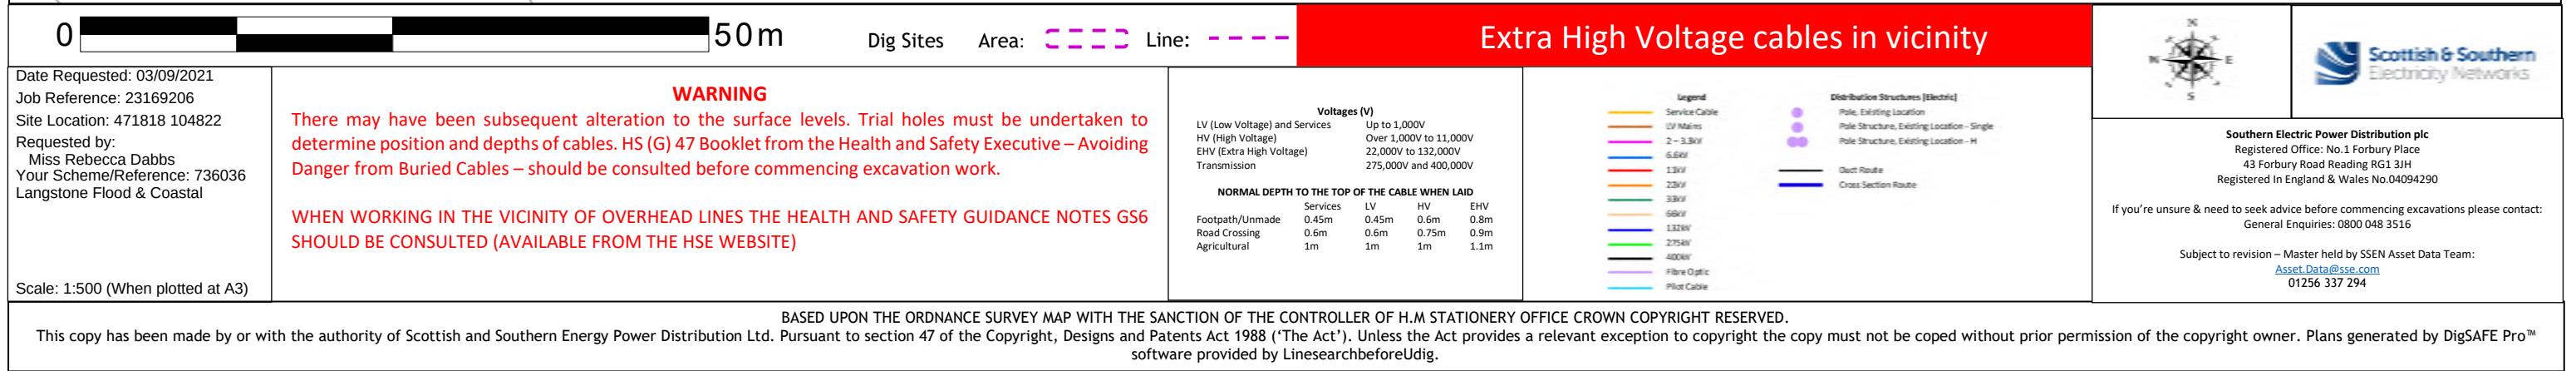

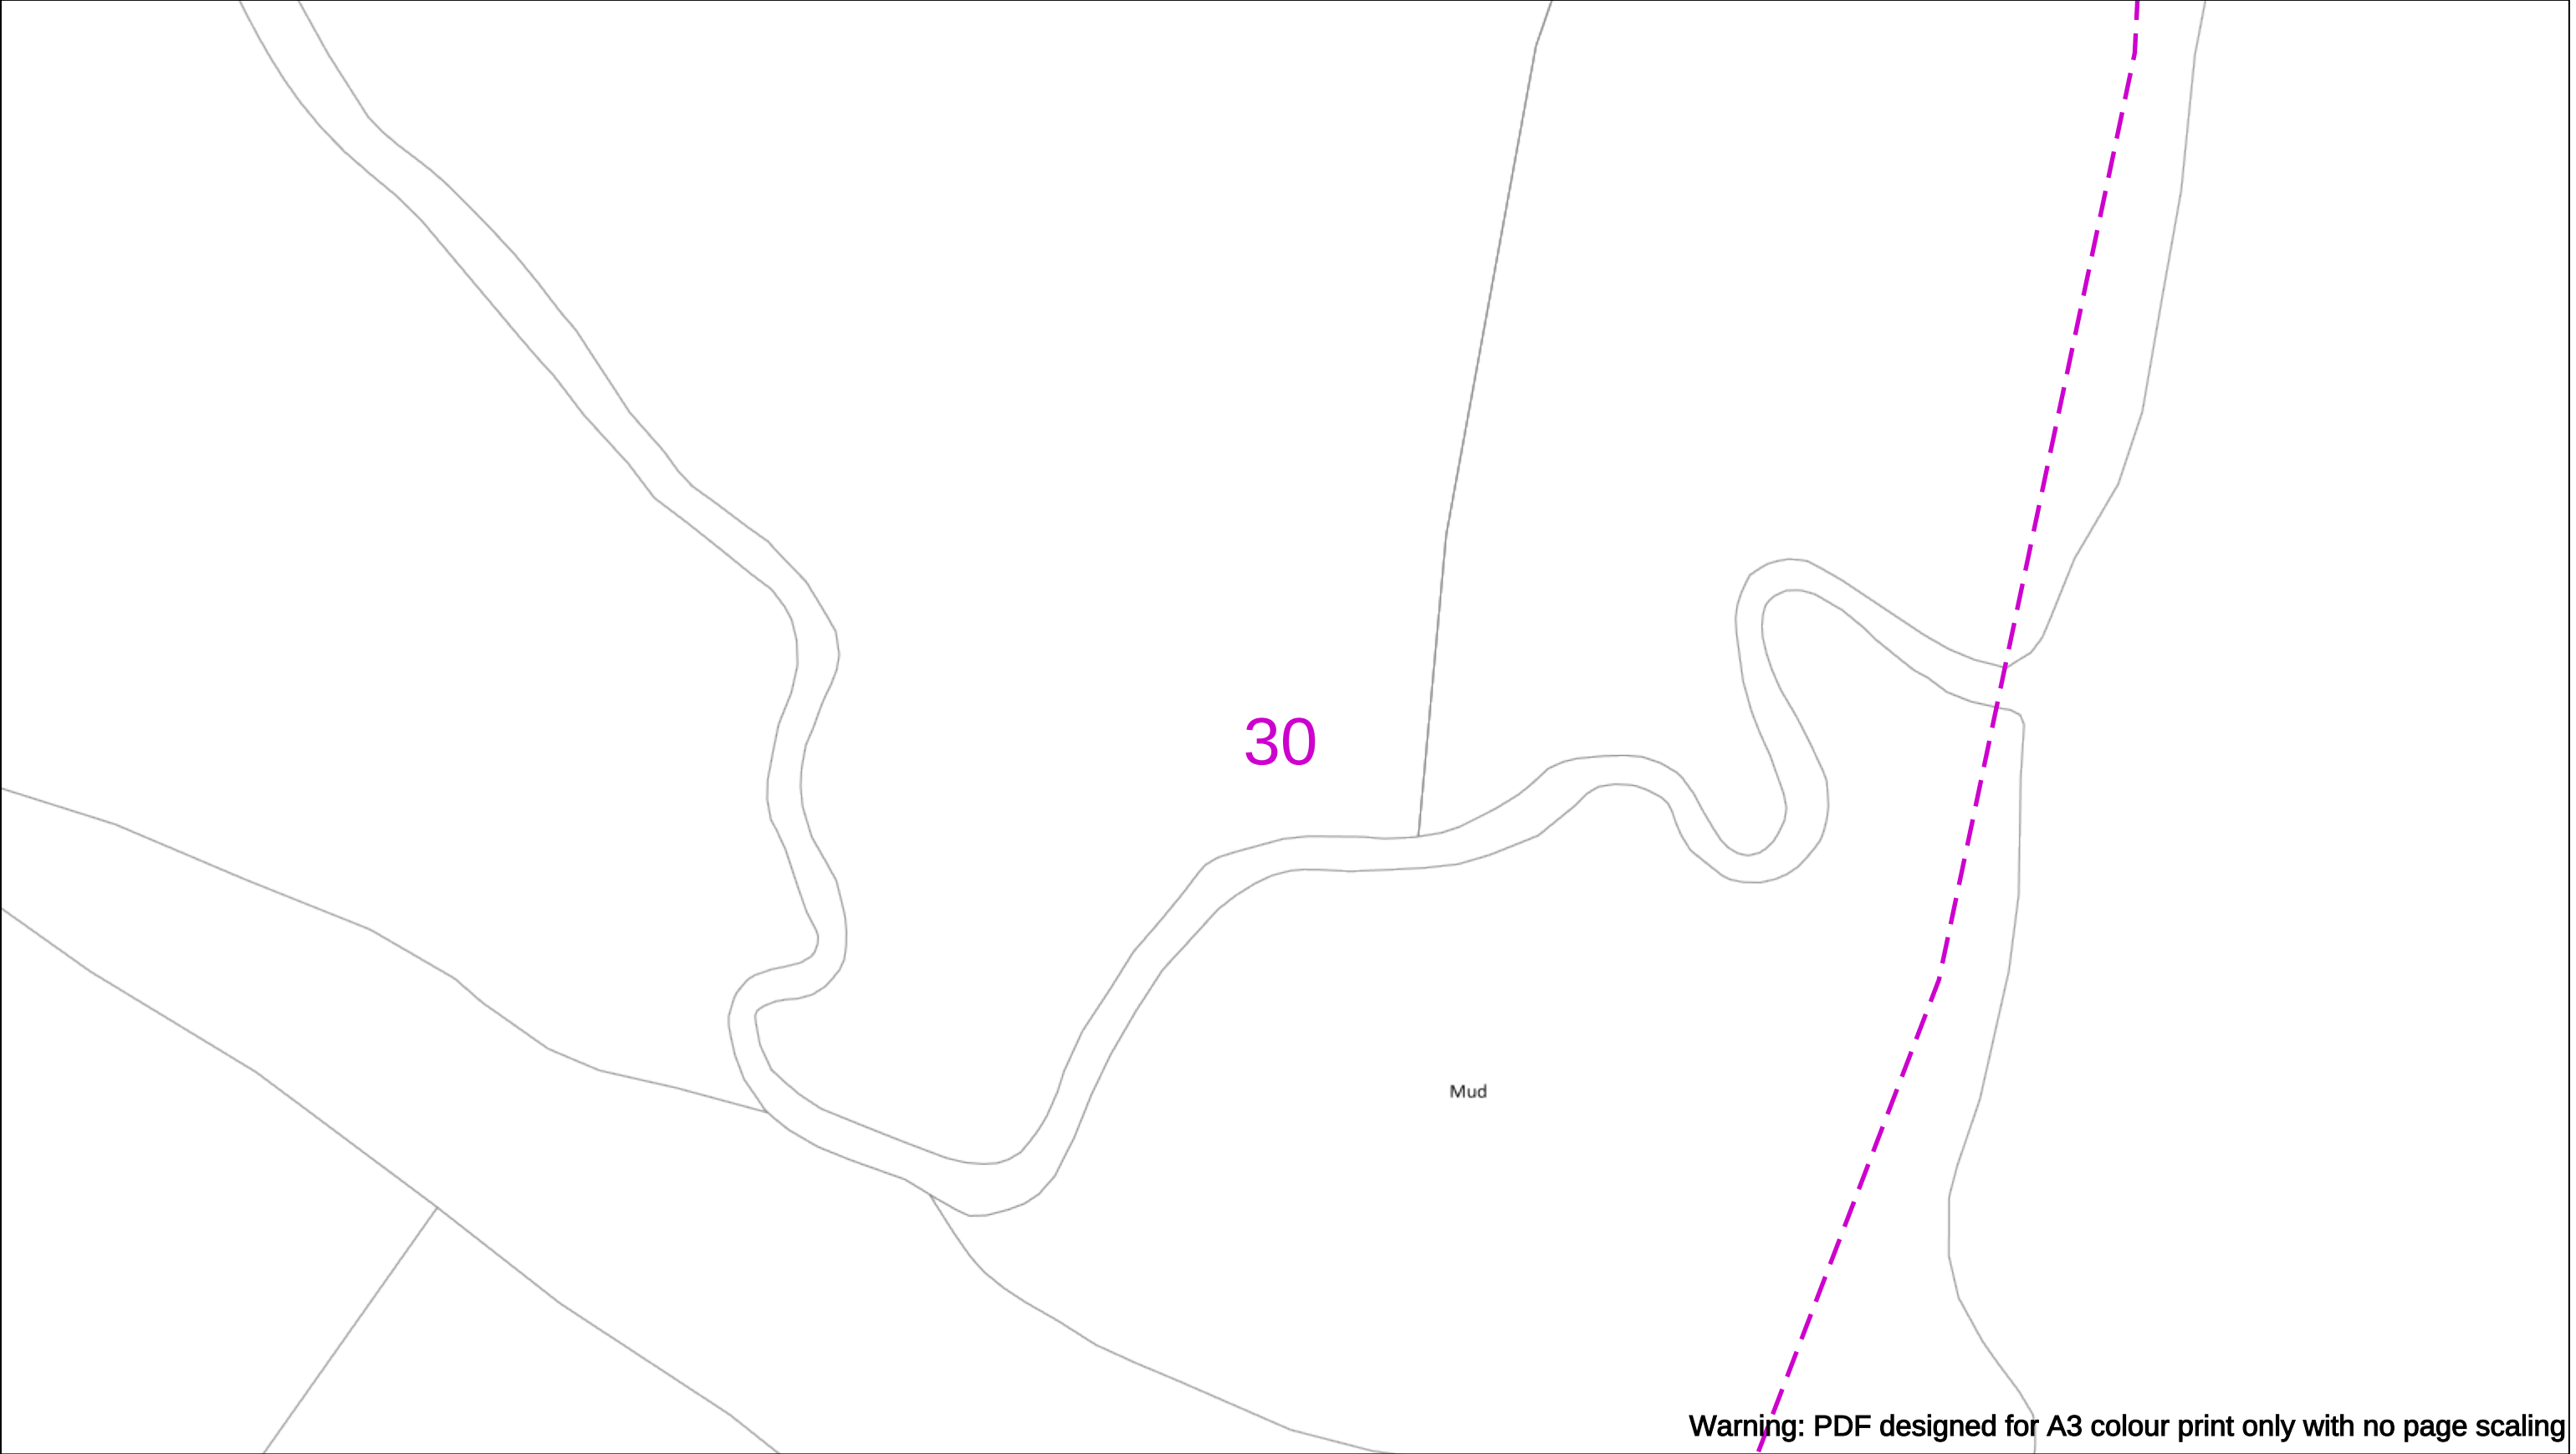

Warning: PDF designed for A3 colour print only with no page scaling

050m

Dig Sites

Area:

Line:

Extra High Voltage cables in vicinity

Date Requested: 03/09/2021

Job Reference: 23169206

Site Location: 471818 104822

Requested by:
Miss Rebecca Dabbs

Your Scheme/Reference: 736036

Langstone Flood & Coastal

WARNING

There may have been subsequent alteration to the surface levels. Trial holes must be undertaken to determine position and depths of cables. HS (G) 47 Booklet from the Health and Safety Executive – Avoiding Danger from Buried Cables – should be consulted before commencing excavation work.

WHEN WORKING IN THE VICINITY OF OVERHEAD LINES THE HEALTH AND SAFETY GUIDANCE NOTES GS6 SHOULD BE CONSULTED (AVAILABLE FROM THE HSE WEBSITE)

	Voltages (V)			
LV (Low Voltage) and Services	Up to 1,000V			
HV (High Voltage)	Over 1,000V to 11,000V			
EHV (Extra High Voltage)	22,000V to 132,000V			
Transmission	275,000V and 400,000V			

	NORMAL DEPTH TO THE TOP OF THE CABLE WHEN LAID			
	Services	LV	HV	EHV
Footpath/Unmade	0.45m	0.45m	0.6m	0.8m
Road Crossing	0.6m	0.6m	0.75m	0.9m
Agricultural	1m	1m	1m	1.1m

Legend

Service Cable

10/ Mains

2 – 3.3kV

6.6kV

11kV

22kV

33kV

66kV

132kV

275kV

400kV

Fibre Optic

Pilot Cable

Distribution Structures [Electric]

Pole, Existing Location

Pole Structure, Existing Location – Single

Pole Structure, Existing Location – H

Duct Route

Cross Section Route

Southern Electric Power Distribution plc

Registered Office: No.1 Forbury Place

43 Forbury Road Reading RG1 3JH

Registered In England & Wales No.04094290

If you're unsure & need to seek advice before commencing excavations please contact:

General Enquiries: 0800 048 3516

Subject to revision – Master held by SSEN Asset Data Team:


Asset.Data@sse.com

01256 337 294

Scale: 1:500 (When plotted at A3)

BASED UPON THE ORDNANCE SURVEY MAP WITH THE SANCTION OF THE CONTROLLER OF THE STATIONERY OFFICE CROWN COPYRIGHT RESERVED.

This copy has been made by or with the authority of Scottish and Southern Energy Power Distribution Ltd. Pursuant to section 47 of the Copyright, Designs and Patents Act 1988 ('The Act'). Unless the Act provides a relevant exception to copyright the copy must not be copied without prior permission of the copyright owner. Plans generated by DigSAFE Pro™ software provided by LinesearchbeforeUdig.

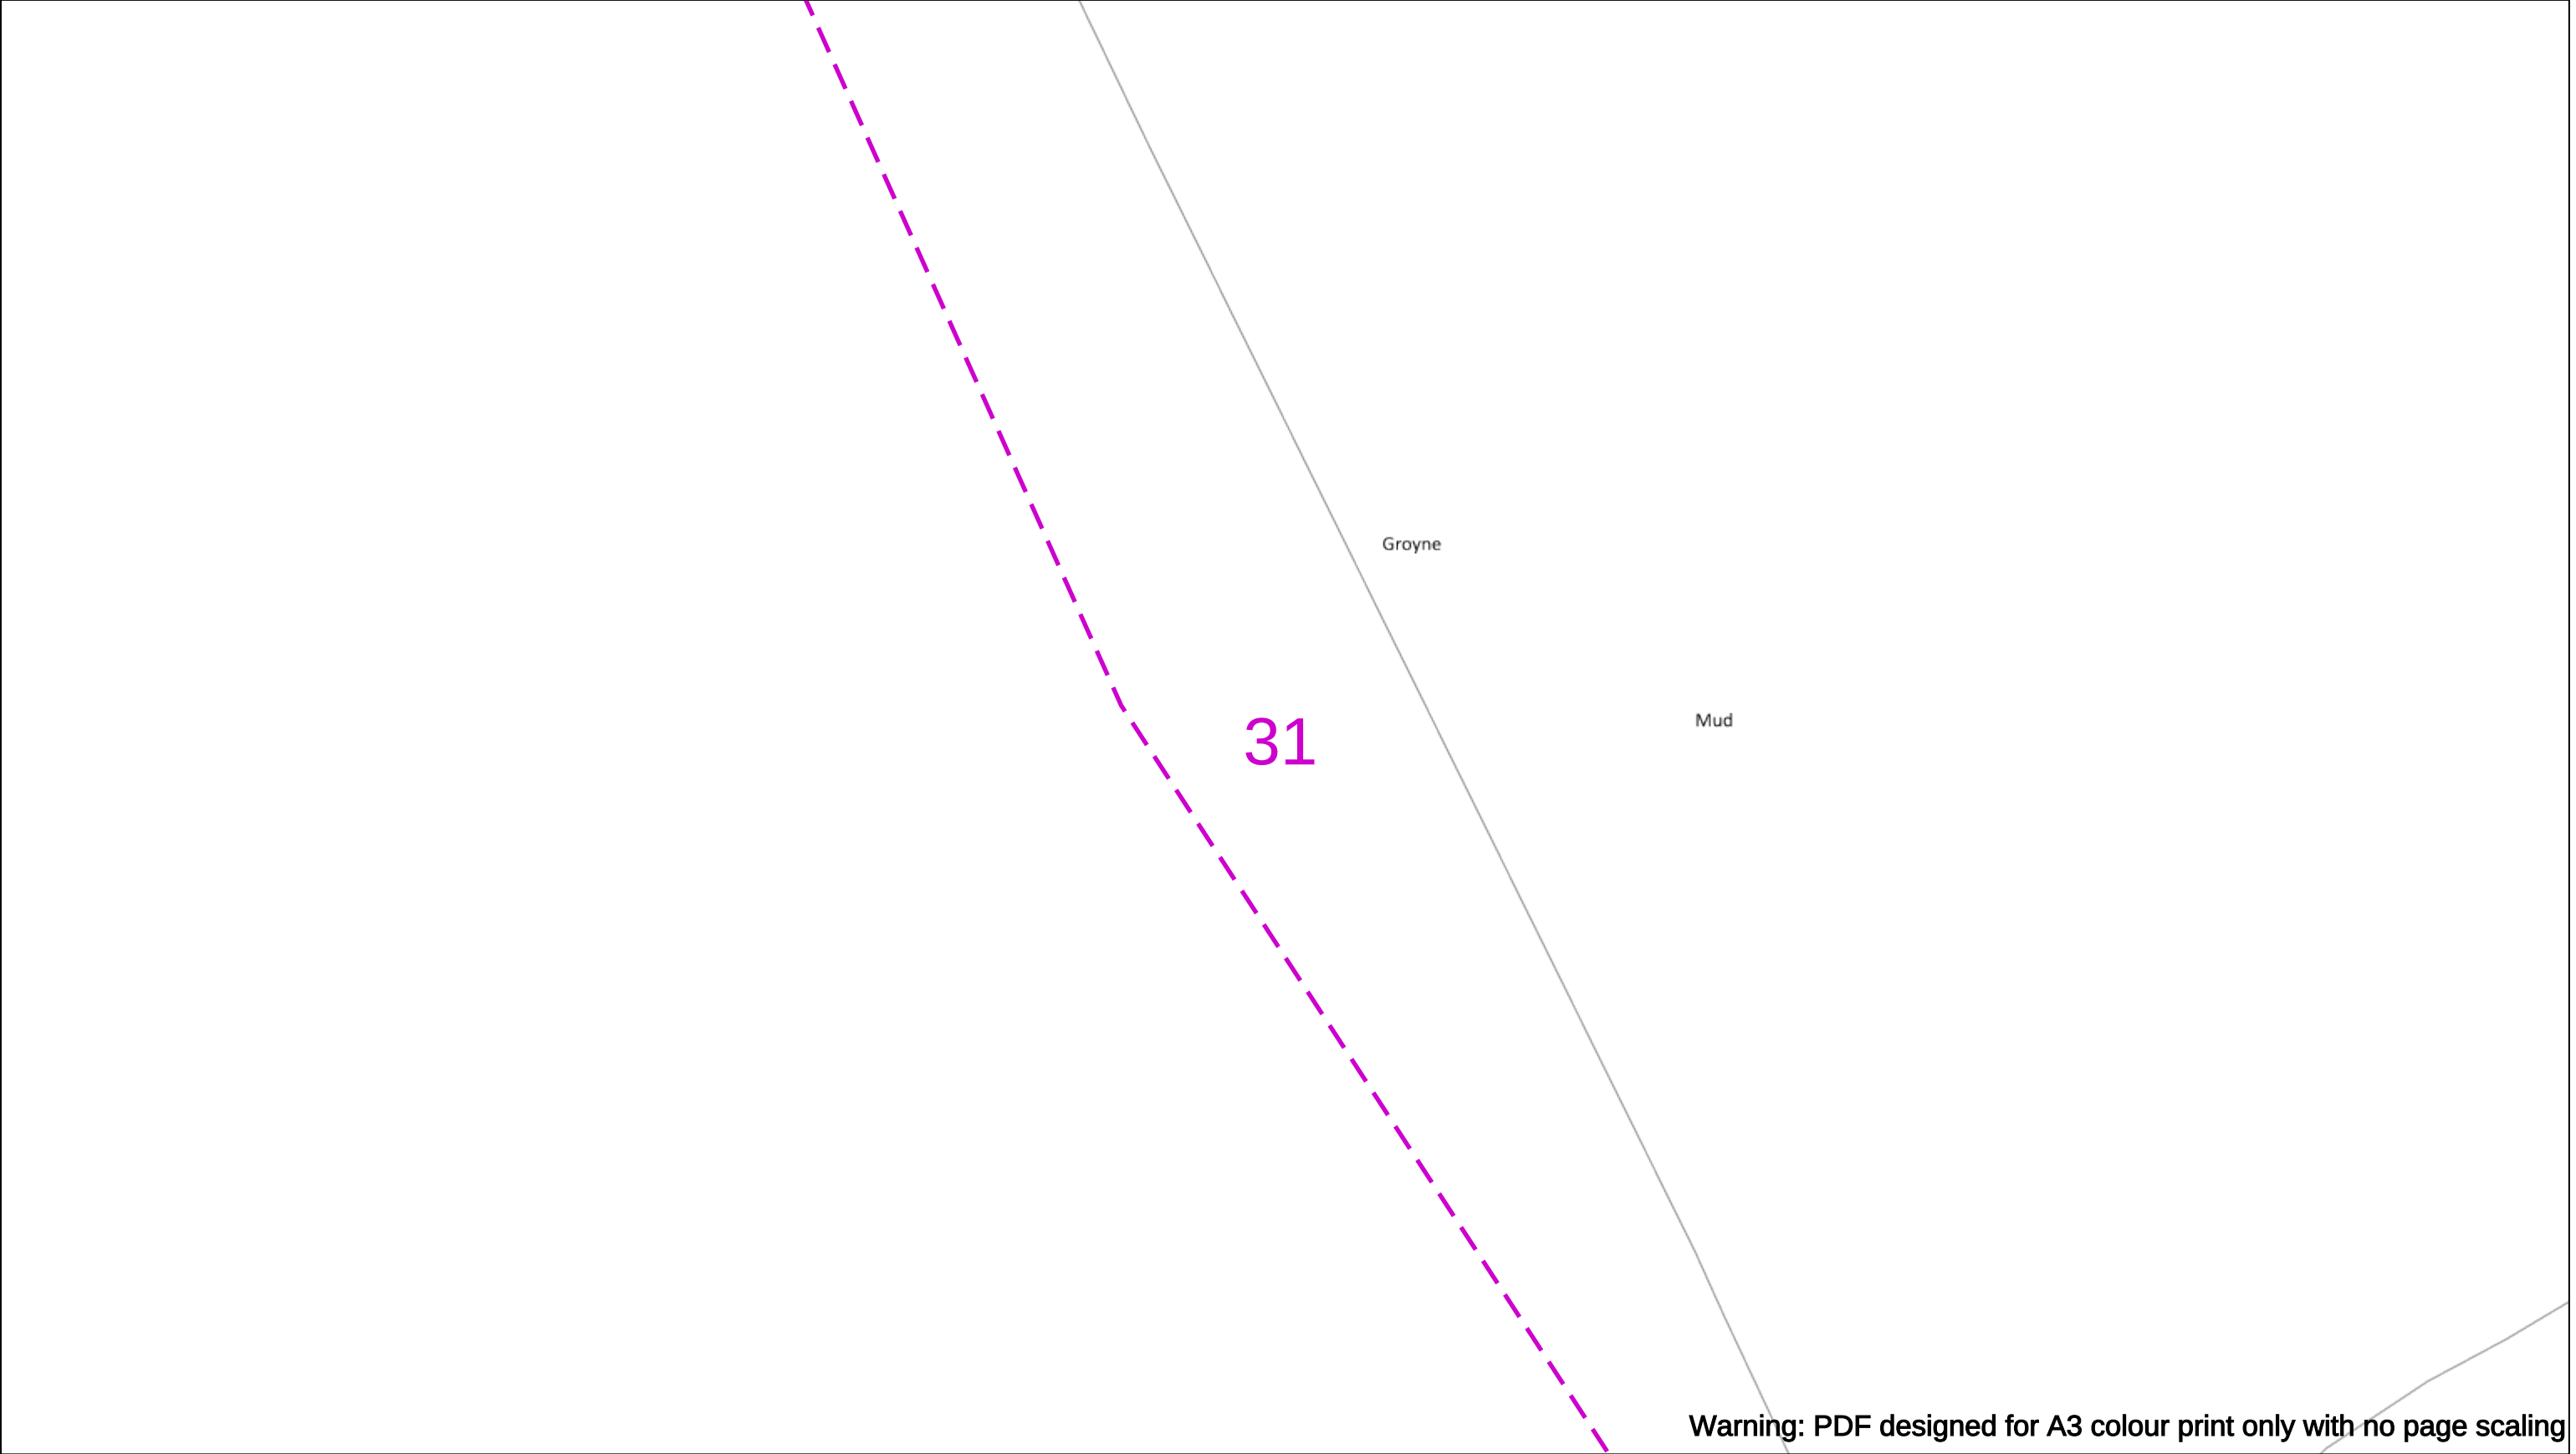

050m

Dig Sites

Area:

Line:

Extra High Voltage cables in vicinity

Date Requested: 03/09/2021

Job Reference: 23169206

Site Location: 471818 104822

Requested by:
Miss Rebecca Dabbs

Your Scheme/Reference: 736036

Langstone Flood & Coastal

WARNING

There may have been subsequent alteration to the surface levels. Trial holes must be undertaken to determine position and depths of cables. HS (G) 47 Booklet from the Health and Safety Executive – Avoiding Danger from Buried Cables – should be consulted before commencing excavation work.

WHEN WORKING IN THE VICINITY OF OVERHEAD LINES THE HEALTH AND SAFETY GUIDANCE NOTES GS6 SHOULD BE CONSULTED (AVAILABLE FROM THE HSE WEBSITE)

Voltages (V)				
LV (Low Voltage) and Services	Up to 1,000V			
HV (High Voltage)	Over 1,000V to 11,000V			
EHV (Extra High Voltage)	22,000V to 132,000V			
Transmission	275,000V and 400,000V			

NORMAL DEPTH TO THE TOP OF THE CABLE WHEN LAID				
Services	LV	HV	EHV	
Footpath/Unmade	0.45m	0.45m	0.6m	0.8m
Road Crossing	0.6m	0.6m	0.75m	0.9m
Agricultural	1m	1m	1m	1.1m

Legend

Service Cable

10/ Mains

2 – 3.3kV

6.6kV

11kV

22kV

33kV

66kV

132kV

275kV

400kV

Fibre Optic

Pilot Cable

Distribution Structures [Electric]

Pole, Existing Location

Pole Structure, Existing Location – Single

Pole Structure, Existing Location – H

Duct Route

Cross Section Route

Southern Electric Power Distribution plc

Registered Office: No.1 Forbury Place

43 Forbury Road Reading RG1 3JH

Registered In England & Wales No.04094290

If you're unsure & need to seek advice before commencing excavations please contact:

General Enquiries: 0800 048 3516


Subject to revision – Master held by SSEN Asset Data Team:

Asset.Data@sse.com

01256 337 294

BASED UPON THE ORDNANCE SURVEY MAP WITH THE SANCTION OF THE CONTROLLER OF THE STATIONERY OFFICE CROWN COPYRIGHT RESERVED.

This copy has been made by or with the authority of Scottish and Southern Energy Power Distribution Ltd. Pursuant to section 47 of the Copyright, Designs and Patents Act 1988 ('The Act'). Unless the Act provides a relevant exception to copyright the copy must not be copied without prior permission of the copyright owner. Plans generated by DigSAFE Pro™ software provided by LinesearchbeforeUdig.

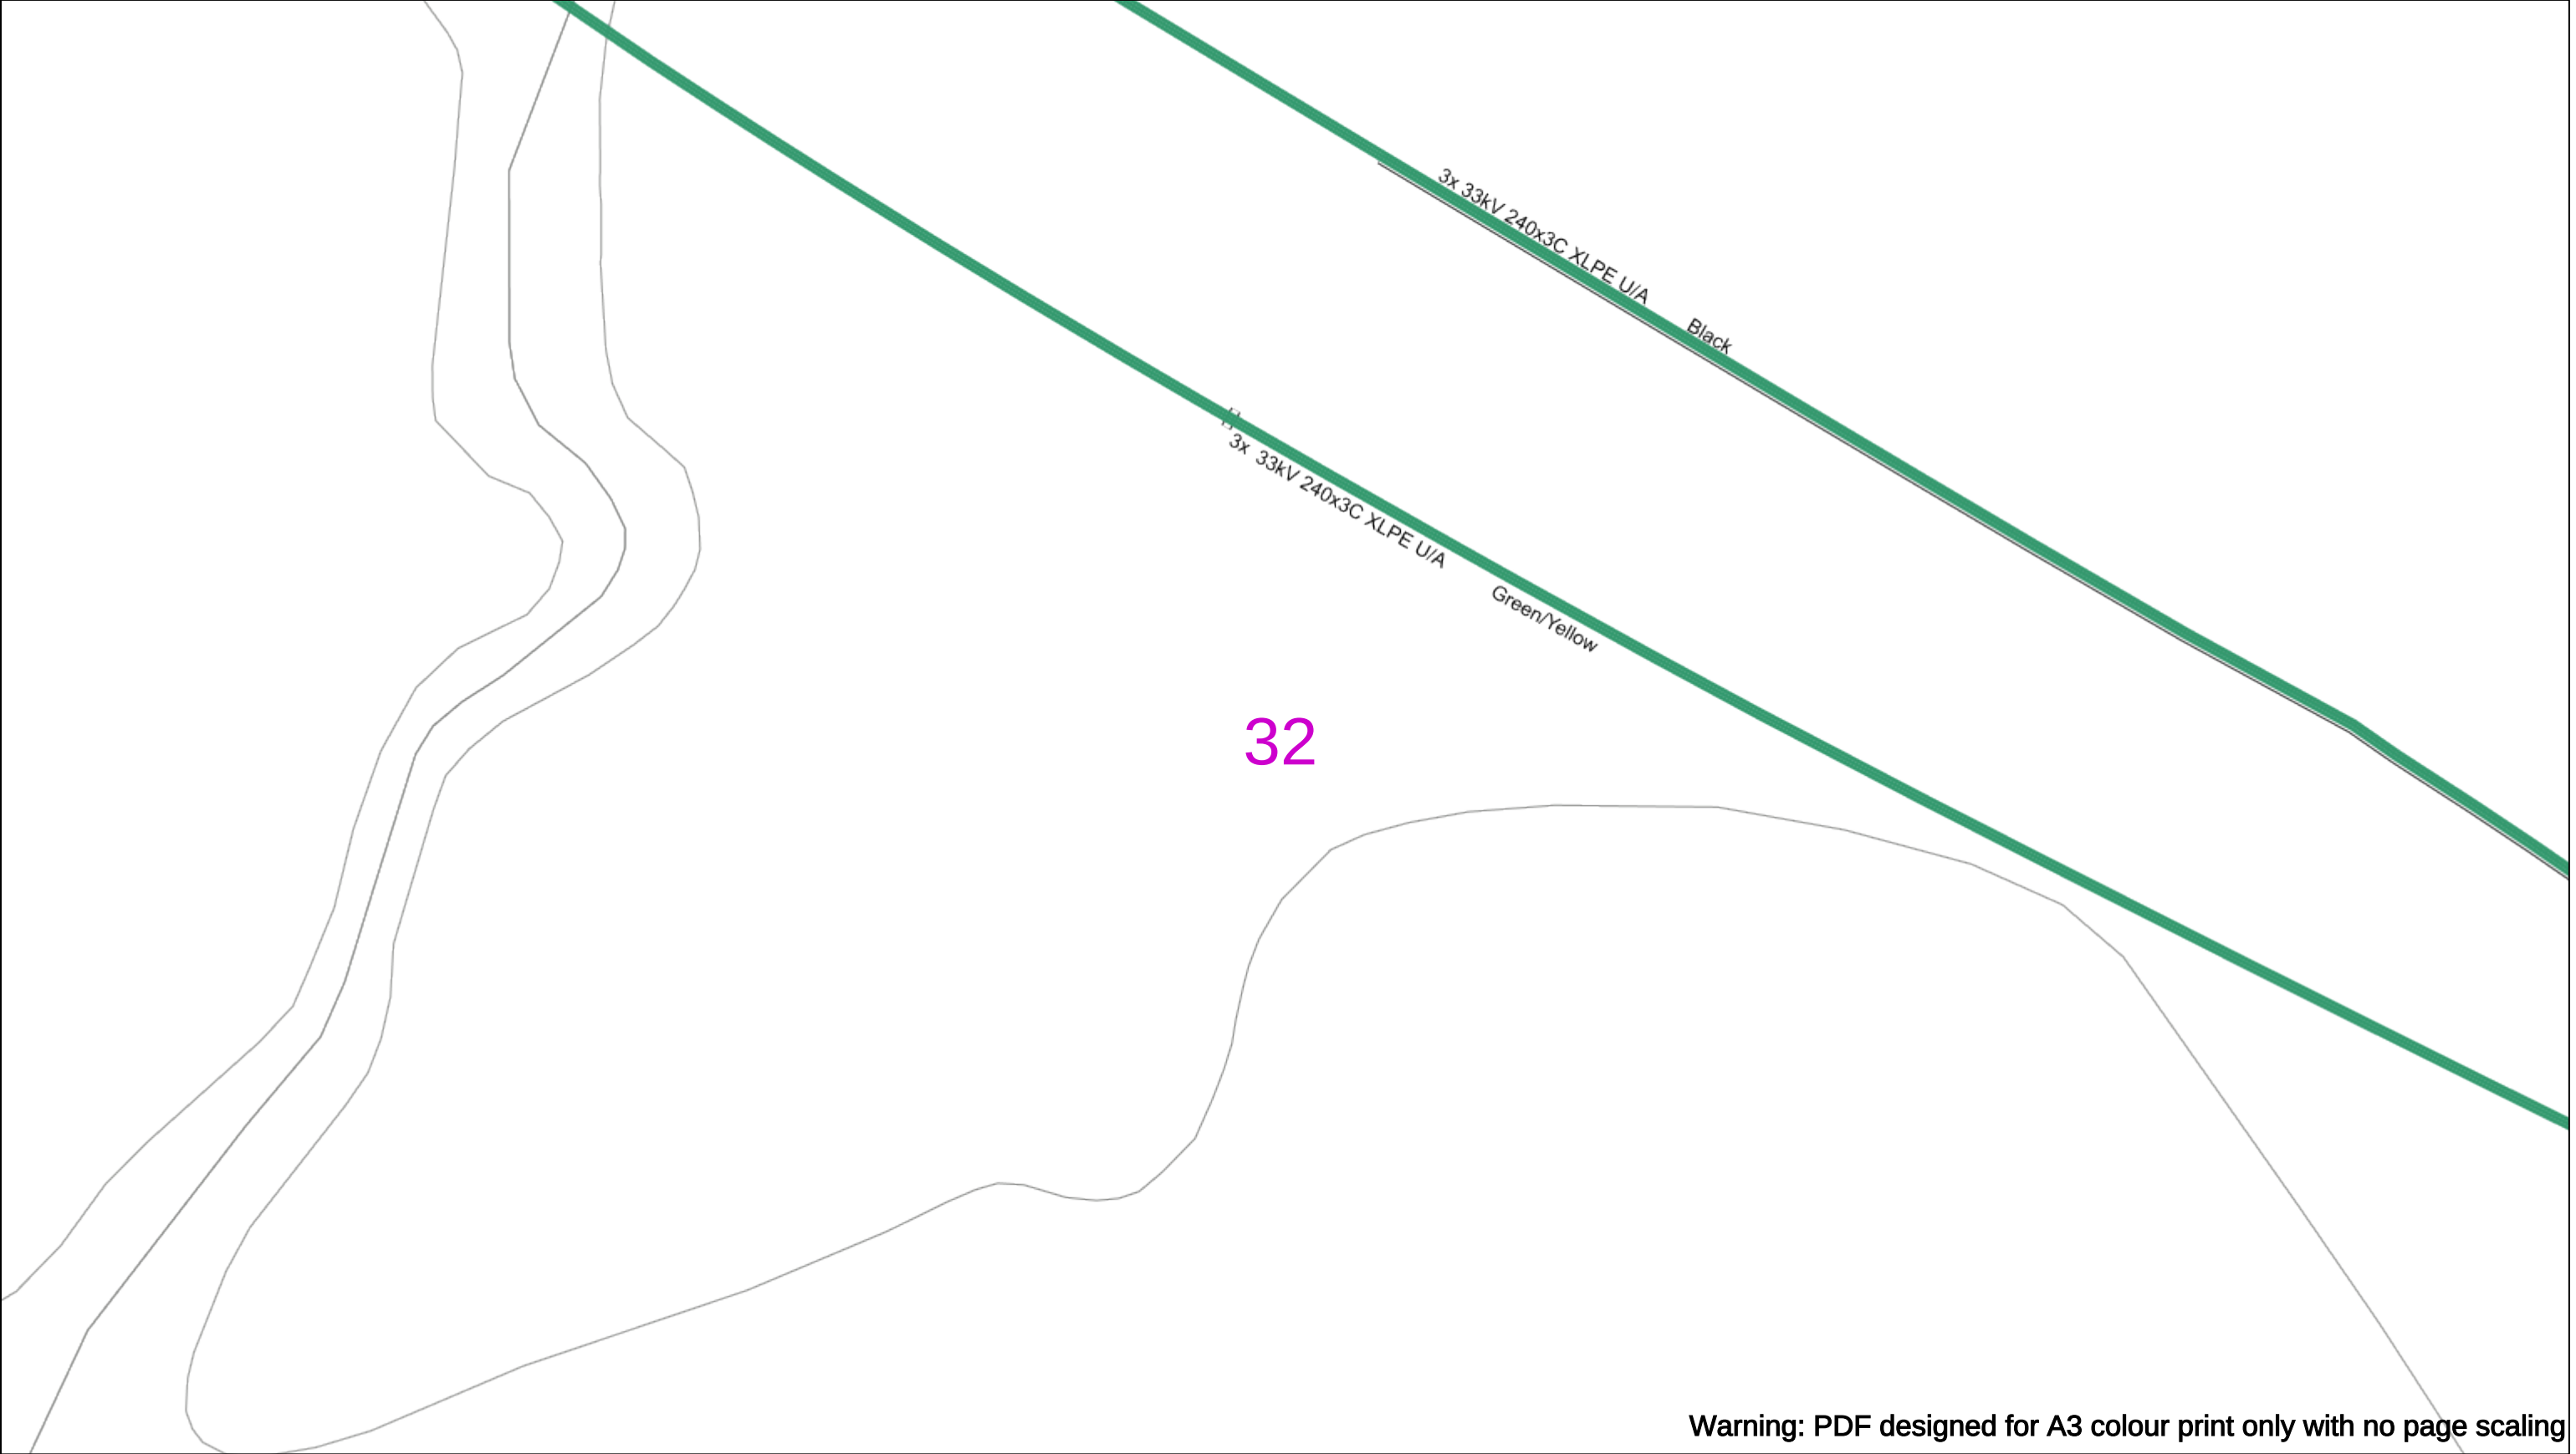

Warning: PDF designed for A3 colour print only with no page scaling

050m

Dig Sites

Area:

Line:

Extra High Voltage cables in vicinity

Date Requested: 03/09/2021

Job Reference: 23169206

Site Location: 471818 104822

Requested by:

Miss Rebecca Dabbs

Your Scheme/Reference: 736036

Langstone Flood & Coastal

WARNING

There may have been subsequent alteration to the surface levels. Trial holes must be undertaken to determine position and depths of cables. HS (G) 47 Booklet from the Health and Safety Executive – Avoiding Danger from Buried Cables – should be consulted before commencing excavation work.

WHEN WORKING IN THE VICINITY OF OVERHEAD LINES THE HEALTH AND SAFETY GUIDANCE NOTES GS6 SHOULD BE CONSULTED (AVAILABLE FROM THE HSE WEBSITE)

	Voltages (V)			
LV (Low Voltage) and Services	Up to 1,000V			
HV (High Voltage)	Over 1,000V to 11,000V			
EHV (Extra High Voltage)	22,000V to 132,000V			
Transmission	275,000V and 400,000V			

	NORMAL DEPTH TO THE TOP OF THE CABLE WHEN LAID			
	Services	LV	HV	EHV
Footpath/Unmade	0.45m	0.45m	0.6m	0.8m
Road Crossing	0.6m	0.6m	0.75m	0.9m
Agricultural	1m	1m	1m	1.1m

Legend

Service Cable

LV Mains

2-33kV

66kV

132kV

275kV

330kV

660kV

1320kV

2750kV

4000kV

Fibre Optic

Pilot Cable

Pole, Existing Location

Pole Structure, Existing Location - Single

Pole Structure, Existing Location - H

Duct Route

Cross Section Route

Southern Electric Power Distribution plc

Registered Office: No.1 Forbury Place

43 Forbury Road Reading RG1 3JH

Registered In England & Wales No.04094290

If you're unsure & need to seek advice before commencing excavations please contact:

General Enquiries: 0800 048 3516

Subject to revision – Master held by SSEN Asset Data Team:


Asset.Data@sse.com

01256 337 294

Scale: 1:500 (When plotted at A3)

BASED UPON THE ORDNANCE SURVEY MAP WITH THE SANCTION OF THE CONTROLLER OF THE STATIONERY OFFICE CROWN COPYRIGHT RESERVED.

This copy has been made by or with the authority of Scottish and Southern Energy Power Distribution Ltd. Pursuant to section 47 of the Copyright, Designs and Patents Act 1988 ('The Act'). Unless the Act provides a relevant exception to copyright the copy must not be copied without prior permission of the copyright owner. Plans generated by DigSAFE Pro™ software provided by LinesearchbeforeUdig.

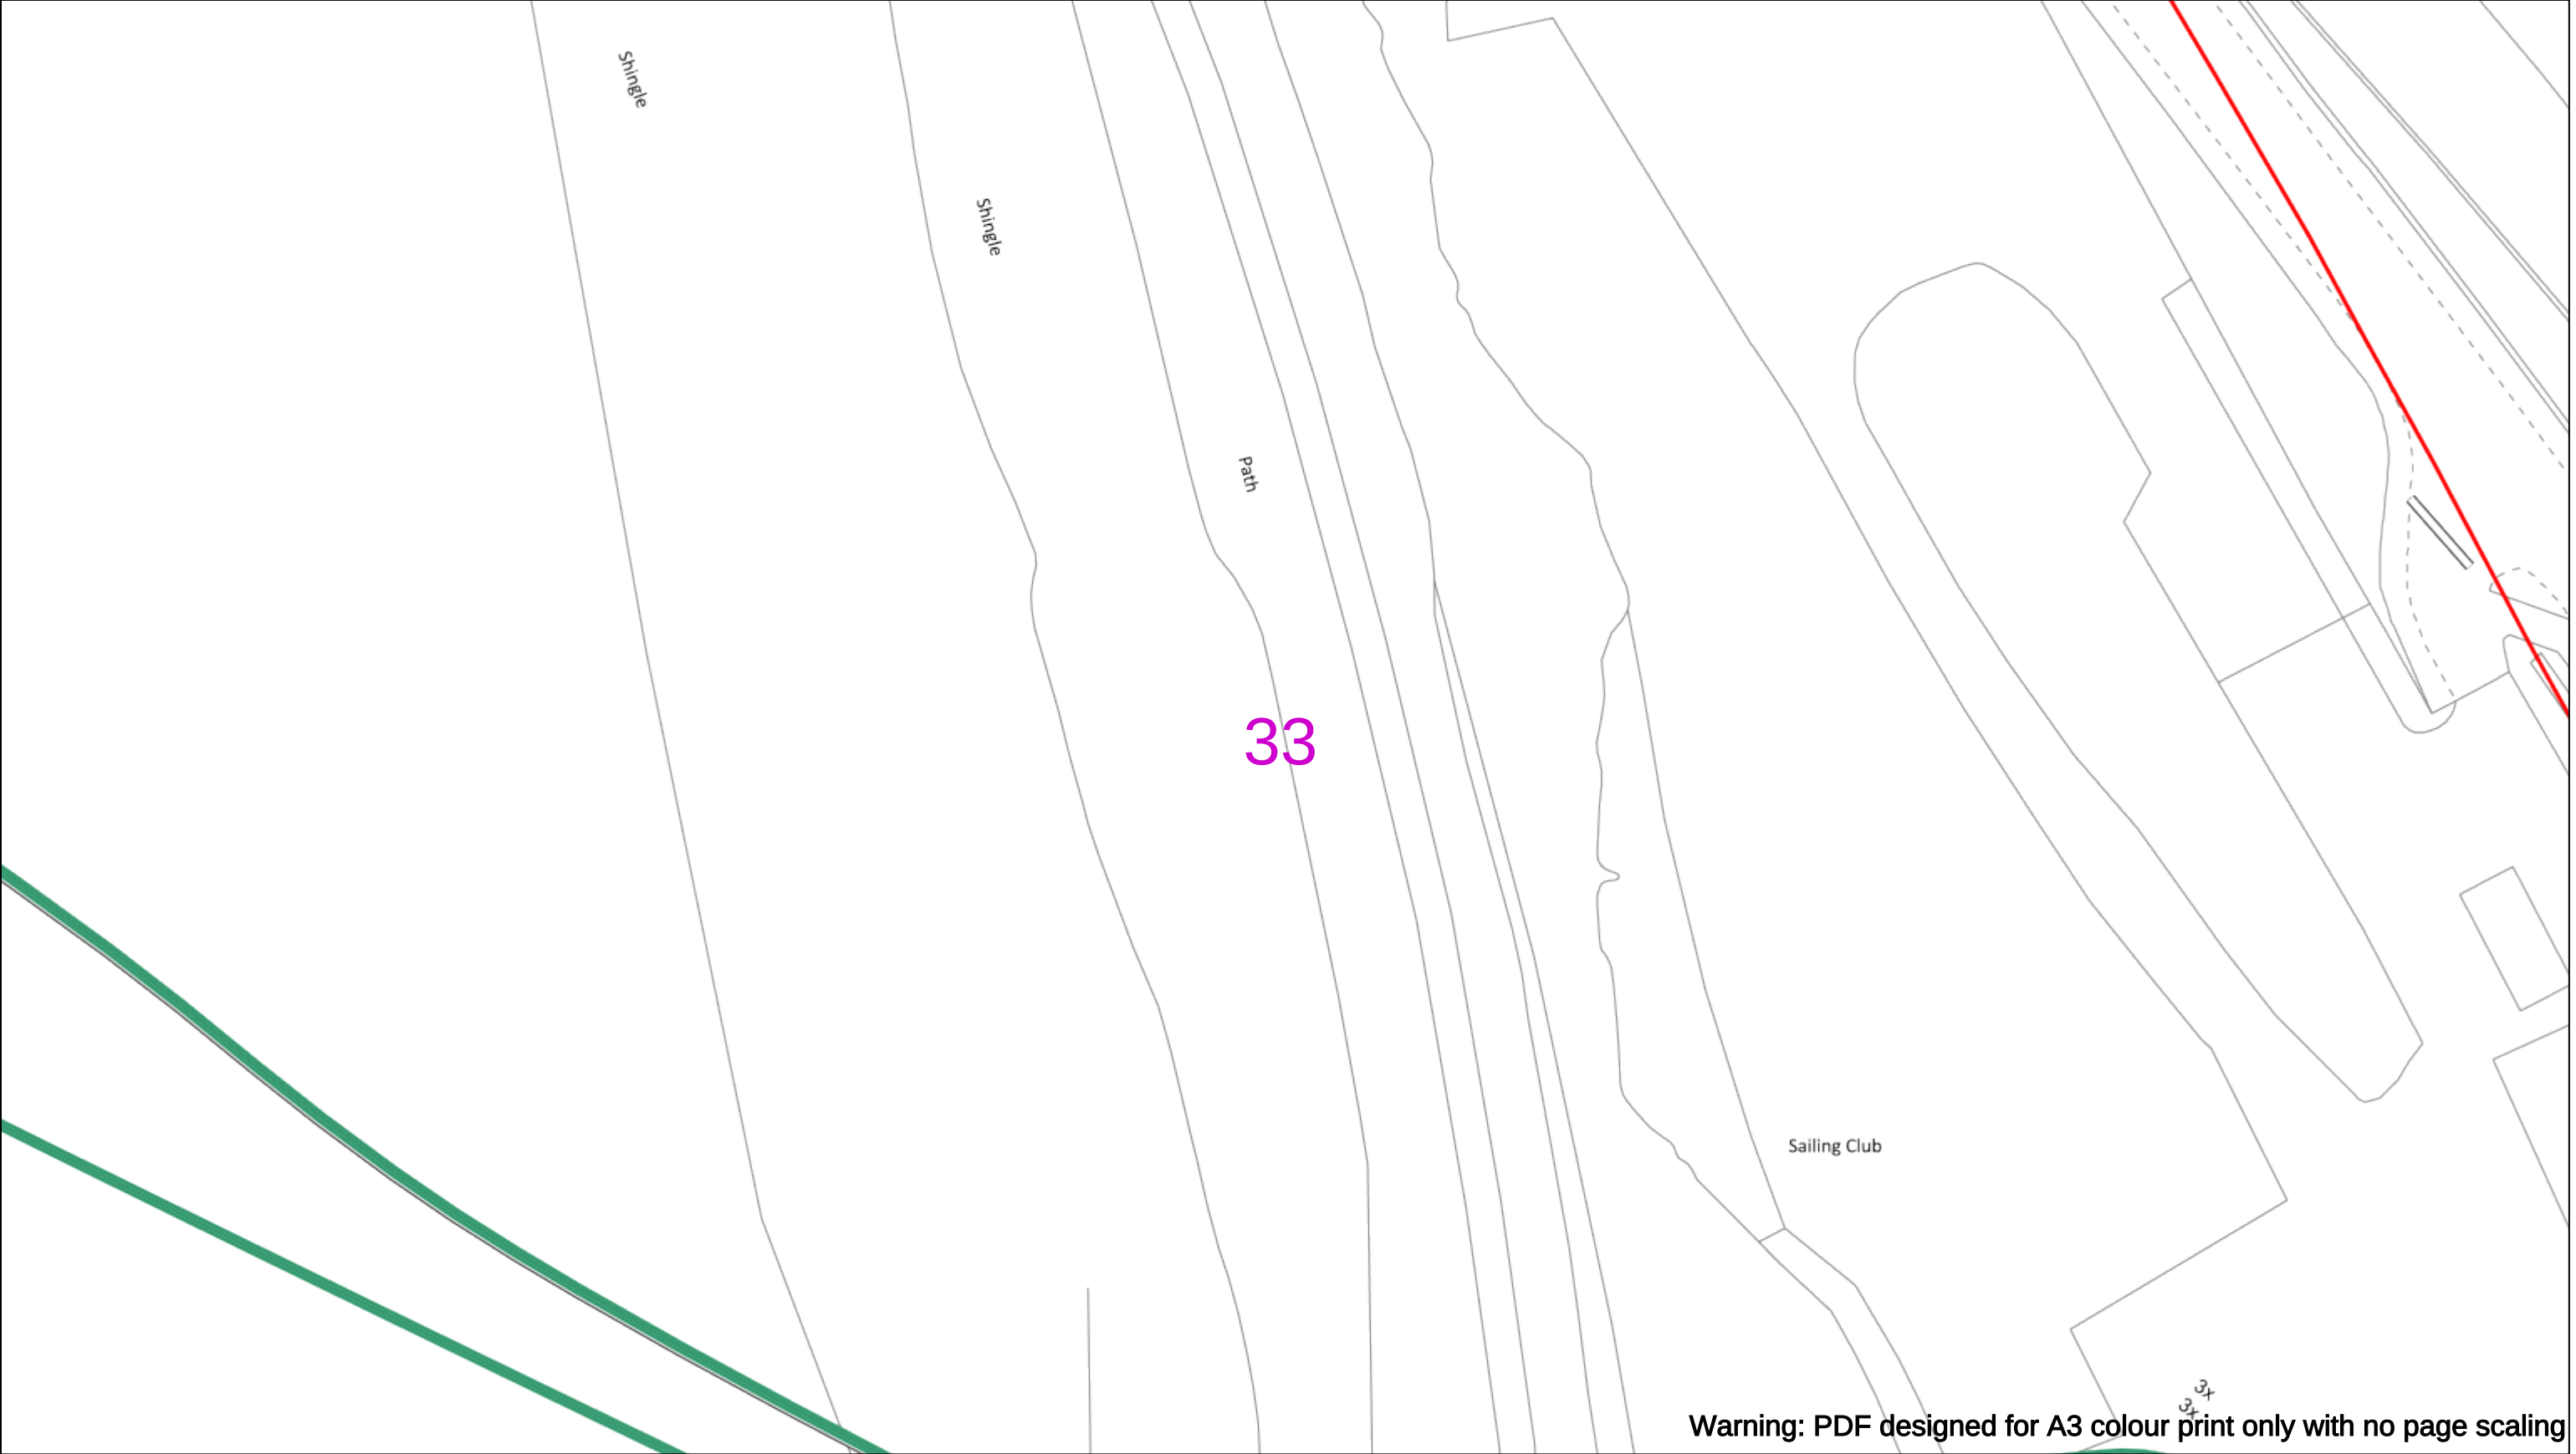

050m

Dig Sites

Area:

Line:

Extra High Voltage cables in vicinity

Southern Electric Power Distribution plc
Registered Office: No.1 Forbury Place
43 Forbury Road Reading RG1 3JH
Registered In England & Wales No.04094290

If you're unsure & need to seek advice before commencing excavations please contact:
General Enquiries: 0800 048 3516

Subject to revision – Master held by SSEN Asset Data Team:
Asset.Data@sse.com
01256 337 294

Date Requested: 03/09/2021
Job Reference: 23169206
Site Location: 471818 104822
Requested by:
Miss Rebecca Dabbs
Your Scheme/Reference: 736036
Langstone Flood & Coastal

Scale: 1:500 (When plotted at A3)

WARNING

There may have been subsequent alteration to the surface levels. Trial holes must be undertaken to determine position and depths of cables. HS (G) 47 Booklet from the Health and Safety Executive – Avoiding Danger from Buried Cables – should be consulted before commencing excavation work.

WHEN WORKING IN THE VICINITY OF OVERHEAD LINES THE HEALTH AND SAFETY GUIDANCE NOTES GS6 SHOULD BE CONSULTED (AVAILABLE FROM THE HSE WEBSITE)

	Voltages (V)			
LV (Low Voltage) and Services	Up to 1,000V			
HV (High Voltage)	Over 1,000V to 11,000V			
EHV (Extra High Voltage)	22,000V to 132,000V			
Transmission	275,000V and 400,000V			

	NORMAL DEPTH TO THE TOP OF THE CABLE WHEN LAID			
	Services	LV	HV	EHV
Footpath/Unmade	0.45m	0.45m	0.6m	0.8m
Road Crossing	0.6m	0.6m	0.75m	0.9m
Agricultural	1m	1m	1m	1.1m

Legend


- Service Cable
- 10/ Mains
- 2-3.3kV
- 6.6kV
- 13kV
- 23kV
- 33kV
- 66kV
- 132kV
- 275kV
- 400kV
- Fibre Optic
- Pilot Cable

Distribution Structures [Electric]

- Pole, Existing Location
- Pole Structure, Existing Location - Single
- Pole Structure, Existing Location - H
- Duct Route
- Cross Section Route

BASED UPON THE ORDNANCE SURVEY MAP WITH THE SANCTION OF THE CONTROLLER OF H.M STATIONERY OFFICE CROWN COPYRIGHT RESERVED.

This copy has been made by or with the authority of Scottish and Southern Energy Power Distribution Ltd. Pursuant to section 47 of the Copyright, Designs and Patents Act 1988 ('The Act'). Unless the Act provides a relevant exception to copyright the copy must not be copied without prior permission of the copyright owner. Plans generated by DigSAFE Pro™ software provided by LinesearchbeforeUdig.

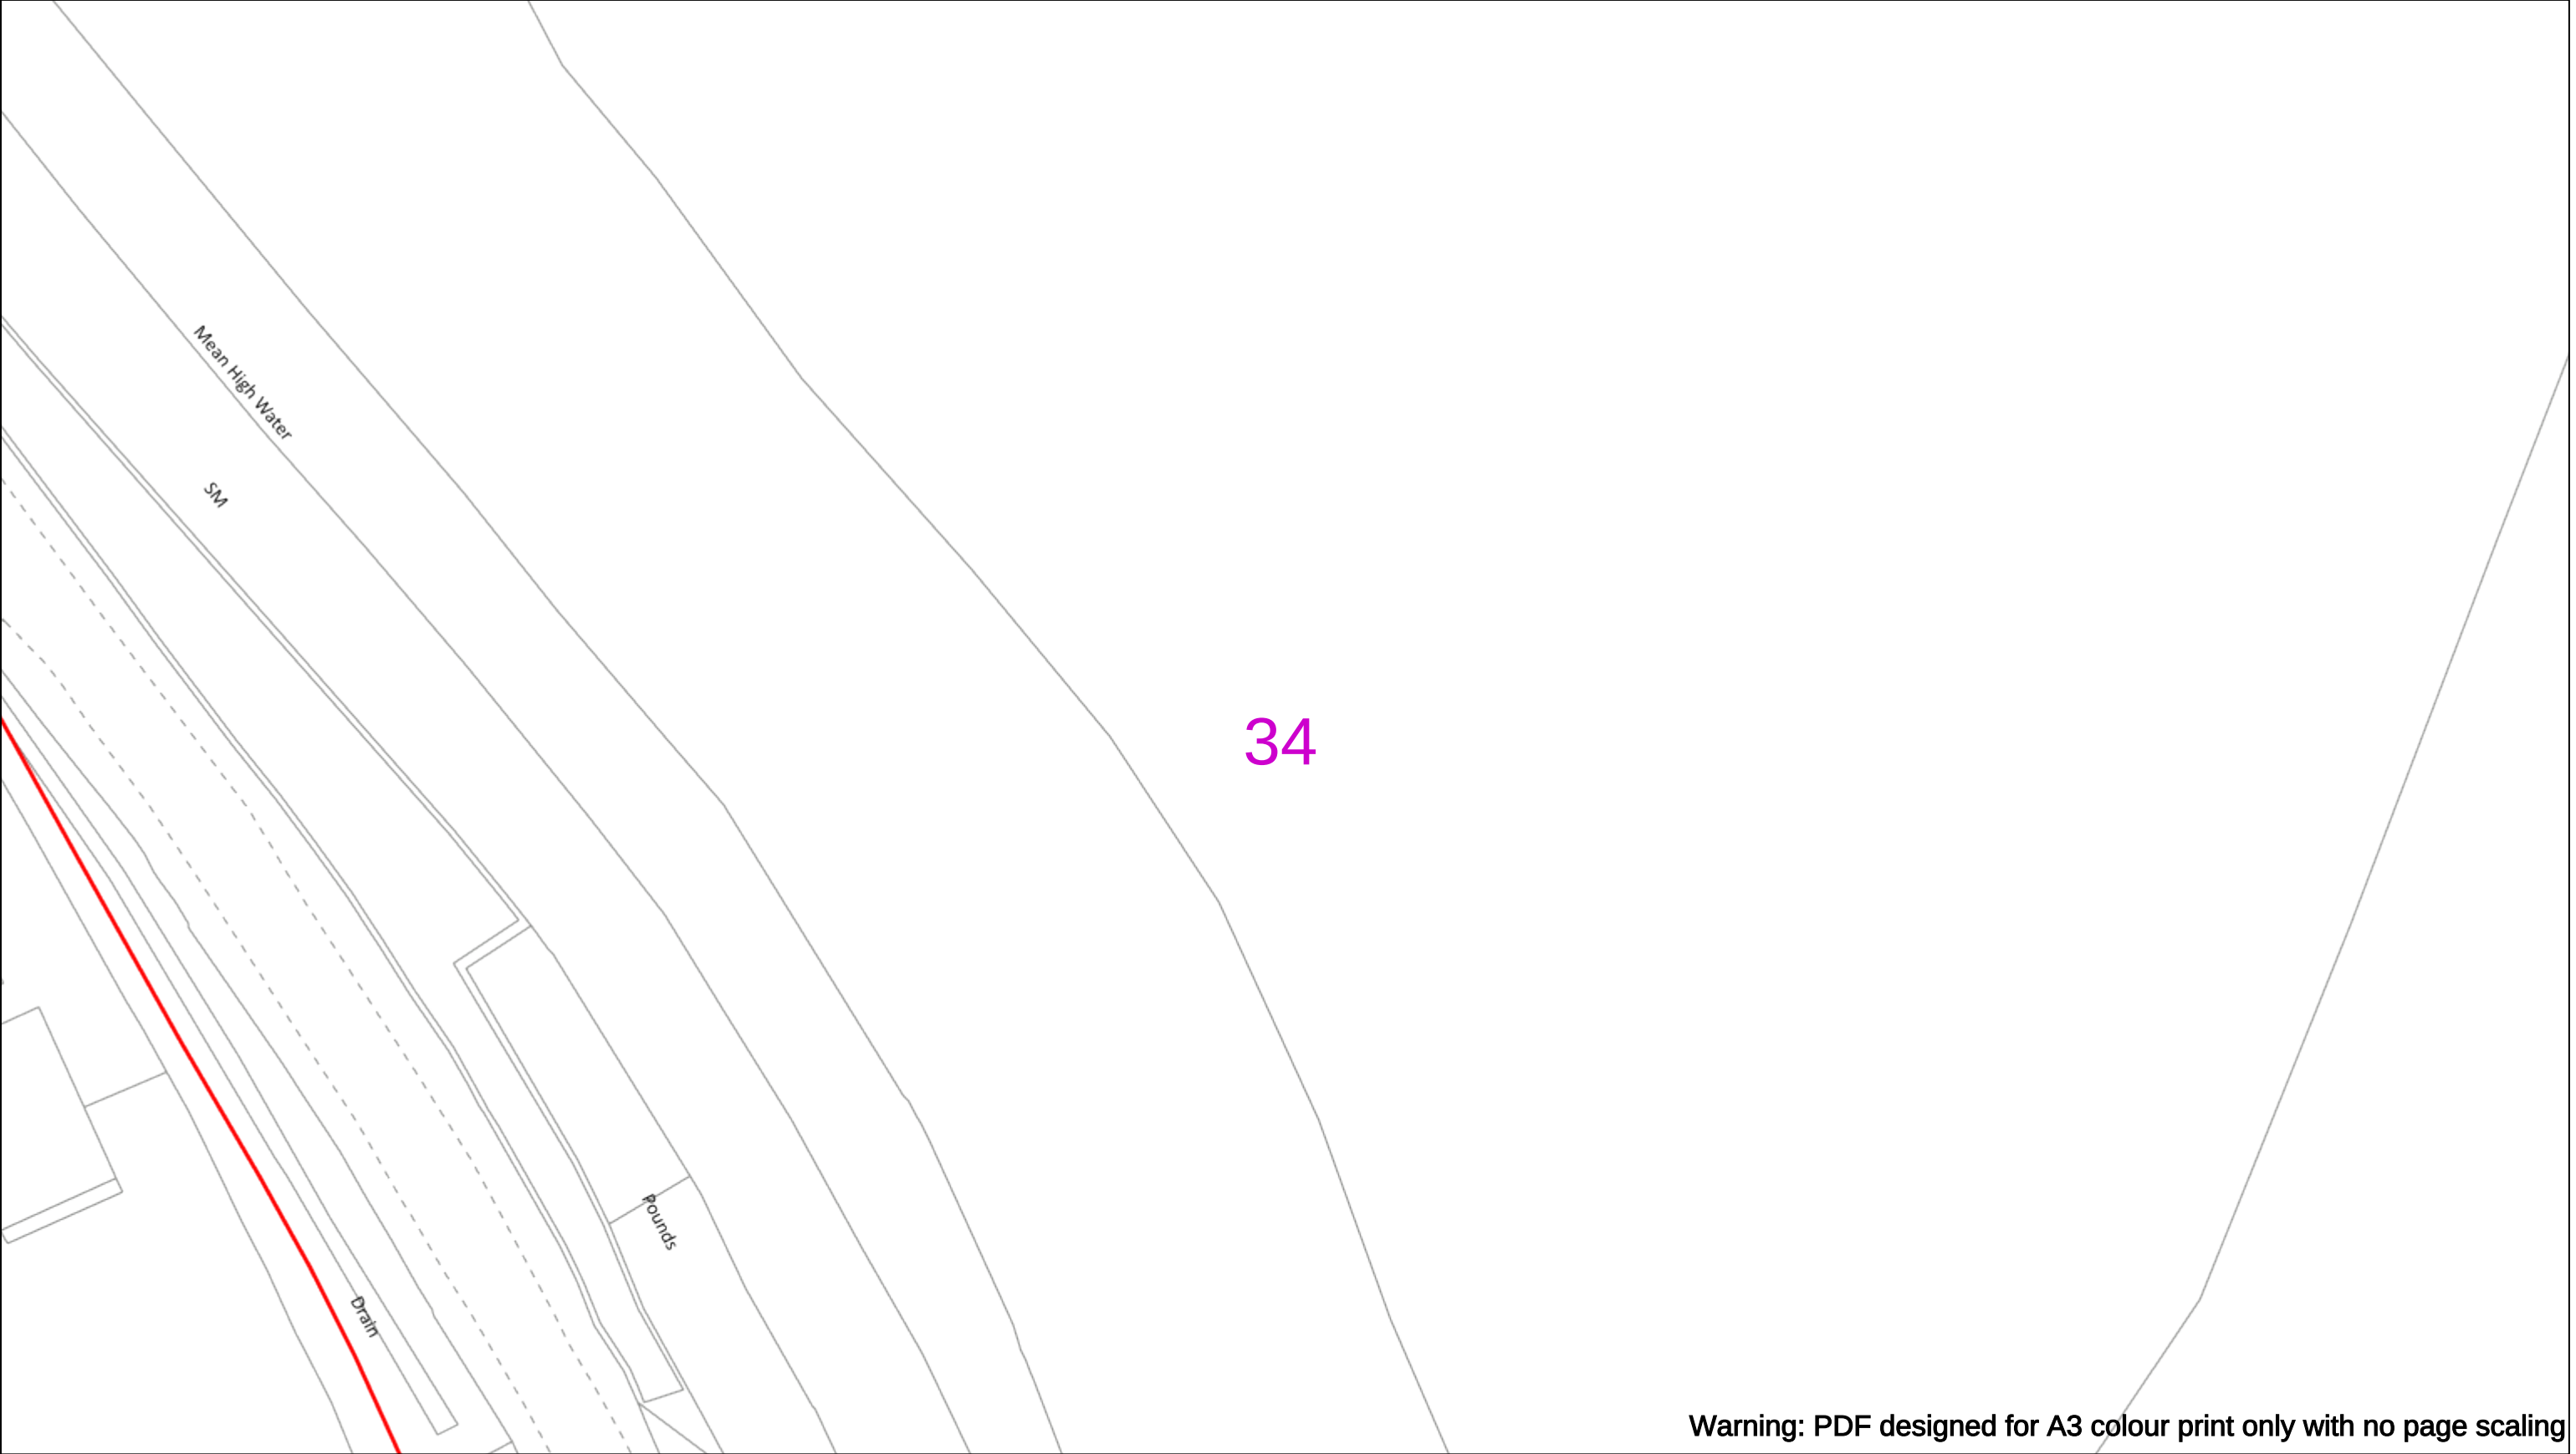

Warning: PDF designed for A3 colour print only with no page scaling

050m

Dig Sites

Area: 

Line: 

Extra High Voltage cables in vicinity



Date Requested: 03/09/2021

Job Reference: 23169206

Site Location: 471818 104822

Requested by:

Miss Rebecca Dabbs

Your Scheme/Reference: 736036

Langstone Flood & Coastal

WARNING

There may have been subsequent alteration to the surface levels. Trial holes must be undertaken to determine position and depths of cables. HS (G) 47 Booklet from the Health and Safety Executive – Avoiding Danger from Buried Cables – should be consulted before commencing excavation work.

WHEN WORKING IN THE VICINITY OF OVERHEAD LINES THE HEALTH AND SAFETY GUIDANCE NOTES GS6 SHOULD BE CONSULTED (AVAILABLE FROM THE HSE WEBSITE)

	Voltages (V)			
LV (Low Voltage) and Services	Up to 1,000V			
HV (High Voltage)	Over 1,000V to 11,000V			
EHV (Extra High Voltage)	22,000V to 132,000V			
Transmission	275,000V and 400,000V			

	NORMAL DEPTH TO THE TOP OF THE CABLE WHEN LAID			
	Services	LV	HV	EHV
Footpath/Unmade	0.45m	0.45m	0.6m	0.8m
Road Crossing	0.6m	0.6m	0.75m	0.9m
Agricultural	1m	1m	1m	1.1m

Legend

 Service Cable

 0V Mains

 2 – 3.3kV

 6.6kV

 11kV

 22kV

 33kV

 66kV

 132kV

 275kV

 400kV

 Fibre Optic

 Pilot Cable

Distribution Structures [Electric]

 Pole, Existing Location

 Pole Structure, Existing Location – Single

 Pole Structure, Existing Location – H

 Duct Route

 Cross Section Route

Southern Electric Power Distribution plc

Registered Office: No.1 Forbury Place

43 Forbury Road Reading RG1 3JH

Registered In England & Wales No.04094290

If you're unsure & need to seek advice before commencing excavations please contact:

General Enquiries: 0800 048 3516

Subject to revision – Master held by SSEN Asset Data Team:

 
Asset.Data@sse.com


01256 337 294

Scale: 1:500 (When plotted at A3)

BASED UPON THE ORDNANCE SURVEY MAP WITH THE SANCTION OF THE CONTROLLER OF H.M STATIONERY OFFICE CROWN COPYRIGHT RESERVED.

This copy has been made by or with the authority of Scottish and Southern Energy Power Distribution Ltd. Pursuant to section 47 of the Copyright, Designs and Patents Act 1988 ('The Act'). Unless the Act provides a relevant exception to copyright the copy must not be copied without prior permission of the copyright owner. Plans generated by DigSAFE Pro™ software provided by LinesearchbeforeUdig.



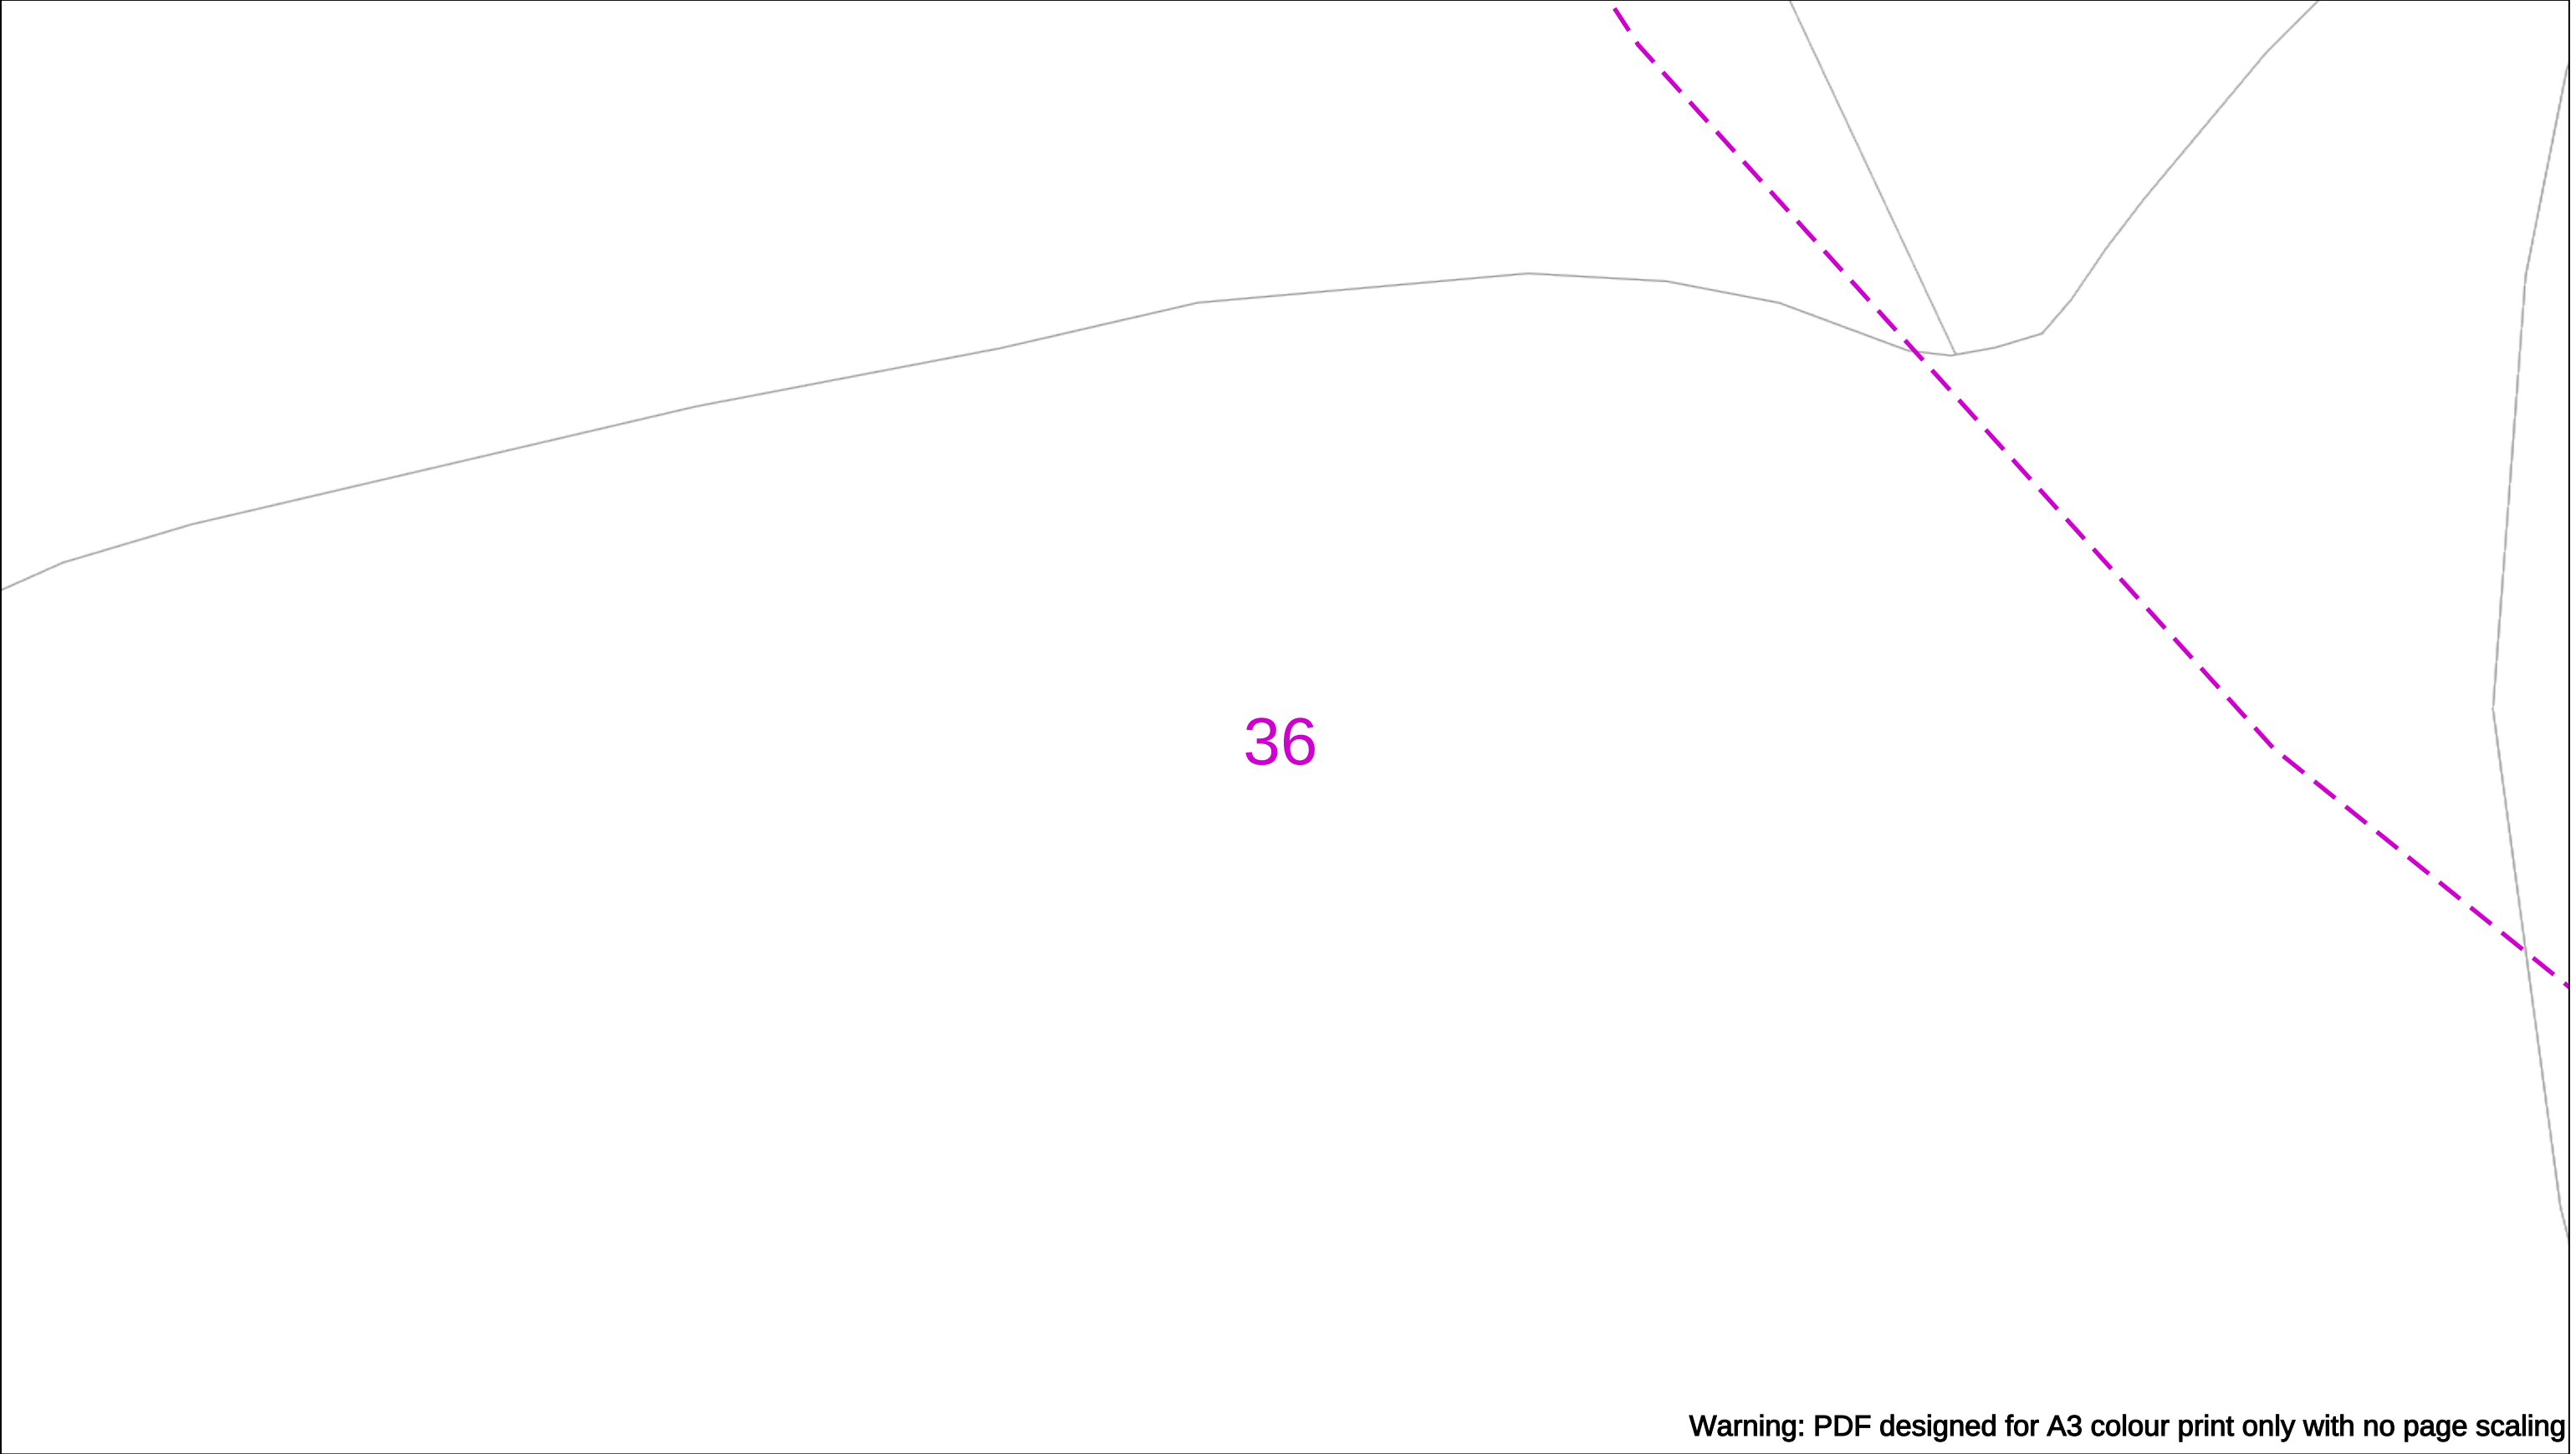

Warning: PDF designed for A3 colour print only with no page scaling

050m

Dig SitesArea: Line:

Extra High Voltage cables in vicinity

Date Requested: 03/09/2021
Job Reference: 23169206
Site Location: 471818 104822
Requested by:
Miss Rebecca Dabbs
Your Scheme/Reference: 736036
Langstone Flood & Coastal

WARNING

There may have been subsequent alteration to the surface levels. Trial holes must be undertaken to determine position and depths of cables. HS (G) 47 Booklet from the Health and Safety Executive – Avoiding Danger from Buried Cables – should be consulted before commencing excavation work.

WHEN WORKING IN THE VICINITY OF OVERHEAD LINES THE HEALTH AND SAFETY GUIDANCE NOTES GS6 SHOULD BE CONSULTED (AVAILABLE FROM THE HSE WEBSITE)

Voltages (V)				
LV (Low Voltage) and Services	Up to 1,000V			
HV (High Voltage)	Over 1,000V to 11,000V			
EHV (Extra High Voltage)	22,000V to 132,000V			
Transmission	275,000V and 400,000V			

NORMAL DEPTH TO THE TOP OF THE CABLE WHEN LAID				
	Services	LV	HV	EHV
Footpath/Unmade	0.45m	0.45m	0.6m	0.8m
Road Crossing	0.6m	0.6m	0.75m	0.9m
Agricultural	1m	1m	1m	1.1m

Legend

Service Cable

10/ Mains

2 – 3.3kV

6.6kV

11kV

22kV

33kV

66kV

132kV

275kV

400kV

Fibre Optic

Pilot Cable

Distribution Structures [Electric]

Pole, Existing Location

Pole Structure, Existing Location – Single

Pole Structure, Existing Location – H

Duct Route

Cross Section Route

Southern Electric Power Distribution plc

Registered Office: No.1 Forbury Place
43 Forbury Road Reading RG1 3JH
Registered In England & Wales No.04094290

If you're unsure & need to seek advice before commencing excavations please contact:
General Enquiries: 0800 048 3516

Subject to revision – Master held by SSEN Asset Data Team:
Asset.Data@sse.com
01256 337 294

BASED UPON THE ORDNANCE SURVEY MAP WITH THE SANCTION OF THE CONTROLLER OF H.M STATIONERY OFFICE CROWN COPYRIGHT RESERVED.

This copy has been made by or with the authority of Scottish and Southern Energy Power Distribution Ltd. Pursuant to section 47 of the Copyright, Designs and Patents Act 1988 ('The Act'). Unless the Act provides a relevant exception to copyright the copy must not be copied without prior permission of the copyright owner. Plans generated by DigSAFE Pro™ software provided by LinesearchbeforeUdig.

[illegible]

The image shows a blank white page. In the bottom-left corner, there is a faint, dashed purple line extending diagonally upwards towards the center. In the bottom-right corner, there is a small, black, sans-serif text string that reads "Warning: PDF designed for A3 colour print only with no page scaling".

The image shows a blank white page. In the bottom-left corner, there is a faint, dashed purple line extending diagonally upwards towards the center. In the bottom-right corner, there is a small, black, sans-serif text string that reads "Warning: PDF designed for A3 colour print only with no page scaling".



0 50m Dig Sites Area: 333 Line: --- Extra High Voltage cables in vicinity

0 50m Dig Sites Area: 333 Line: --- Extra High Voltage cables in vicinity



Date Requested: 03/09/2021
Job Reference: 23169206
Site Location: 471818 104822
Requested by:
Miss Rebecca Dabbs
Your Scheme/Reference: 736036
Langstone Flood & Coastal

Scale: 1:500 (When plotted at A3)

WARNING

There may have been subsequent alteration to the surface levels. Trial holes must be undertaken to determine position and depths of cables. HS (G) 47 Booklet from the Health and Safety Executive – Avoiding Danger from Buried Cables – should be consulted before commencing excavation work.

WHEN WORKING IN THE VICINITY OF OVERHEAD LINES THE HEALTH AND SAFETY GUIDANCE NOTES GS6 SHOULD BE CONSULTED (AVAILABLE FROM THE HSE WEBSITE)

WARNING

There may have been subsequent alteration to the surface levels. Trial holes must be undertaken to determine position and depths of cables. HS (G) 47 Booklet from the Health and Safety Executive – Avoiding Danger from Buried Cables – should be consulted before commencing excavation work.

WHEN WORKING IN THE VICINITY OF OVERHEAD LINES THE HEALTH AND SAFETY GUIDANCE NOTES GS6 SHOULD BE CONSULTED (AVAILABLE FROM THE HSE WEBSITE)

WARNING

There may have been subsequent alteration to the surface levels. Trial holes must be undertaken to determine position and depths of cables. HS (G) 47 Booklet from the Health and Safety Executive – Avoiding Danger from Buried Cables – should be consulted before commencing excavation work.

WHEN WORKING IN THE VICINITY OF OVERHEAD LINES THE HEALTH AND SAFETY GUIDANCE NOTES GS6 SHOULD BE CONSULTED (AVAILABLE FROM THE HSE WEBSITE)

Voltages (V)			
LV (Low Voltage) and Services	Up to 1,000V		
HV (High Voltage)	Over 1,000V to 11,000V		
EHV (Extra High Voltage)	22,000V to 132,000V		
Transmission	275,000V and 400,000V		

NORMAL DEPTH TO THE TOP OF THE CABLE WHEN LAID				
	Services	LV	HV	EHV
Footpath/Unmade	0.45m	0.45m	0.6m	0.8m
Road Crossing	0.6m	0.6m	0.75m	0.9m
Agricultural	1m	1m	1m	1.1m

Legend

- Service Cable
- CV Mains
- 2 - 3.3kV
- 6.6kV
- 11kV
- 22kV
- 33kV
- 66kV
- 132kV
- 275kV
- 400kV
- Fibre Optic
- Pilot Cable

Distribution Structures [Electric]

- Pole, Existing Location
- Pole Structure, Existing Location - Single
- Pole Structure, Existing Location - H
- Dead Route
- Cross Section Route

Southern Electric Power Distribution plc
Registered Office: No.1 Forbury Place
43 Forbury Road Reading RG1 3JH
Registered in England & Wales No.04094290

If you're unsure & need to seek advice before commencing excavations please contact:
General Enquiries: 0800 048 3516

Subject to revision – Master held by SSEN Asset Data Team:
[Asset_Data@sse.com](#)
01256 337 294

Southern Electric Power Distribution plc
Registered Office: No.1 Forbury Place
43 Forbury Road Reading RG1 3JH
Registered in England & Wales No.04094290

If you're unsure & need to seek advice before commencing excavations please contact:
General Enquiries: 0800 048 3516

Subject to revision – Master held by SSEN Asset Data Team:
[Asset_Data@sse.com](#)
01256 337 294

Southern Electric Power Distribution plc
Registered Office: No.1 Forbury Place
43 Forbury Road Reading RG1 3JH
Registered in England & Wales No.04094290

If you're unsure & need to seek advice before commencing excavations please contact:
General Enquiries: 0800 048 3516

Subject to revision – Master held by SSEN Asset Data Team:
[Asset_Data@sse.com](#)
01256 337 294

 
This copy has been made by or with the assistance of


BASED UPON THE ORDNANCE SURVEY MAP WITH THE SANCTION OF THE CONTROLLER OF H.M STATIONERY OFFICE CROWN COPYRIGHT RESERVED.

This copy has been made by or with the authority of Scottish and Southern Energy Power Distribution Ltd. Pursuant to section 47 of the Copyright, Designs and Patents Act 1988 ('The Act'). Unless the Act provides a relevant exception to copyright the copy must not be copied without prior permission of the copyright owner. Plans generated by DigSAFE Pro™ software provided by LineSearchbeforeUdig.

BASED UPON THE ORDNANCE SURVEY MAP WITH THE SANCTION OF THE CONTROLLER OF H.M STATIONERY OFFICE CROWN COPYRIGHT RESERVED.

This copy has been made by or with the authority of Scottish and Southern Energy Power Distribution Ltd. Pursuant to section 47 of the Copyright, Designs and Patents Act 1988 ('The Act'). Unless the Act provides a relevant exception to copyright the copy must not be copied without prior permission of the copyright owner. Plans generated by DigSAFE Pro™ software provided by LineSearchbeforeUdig.



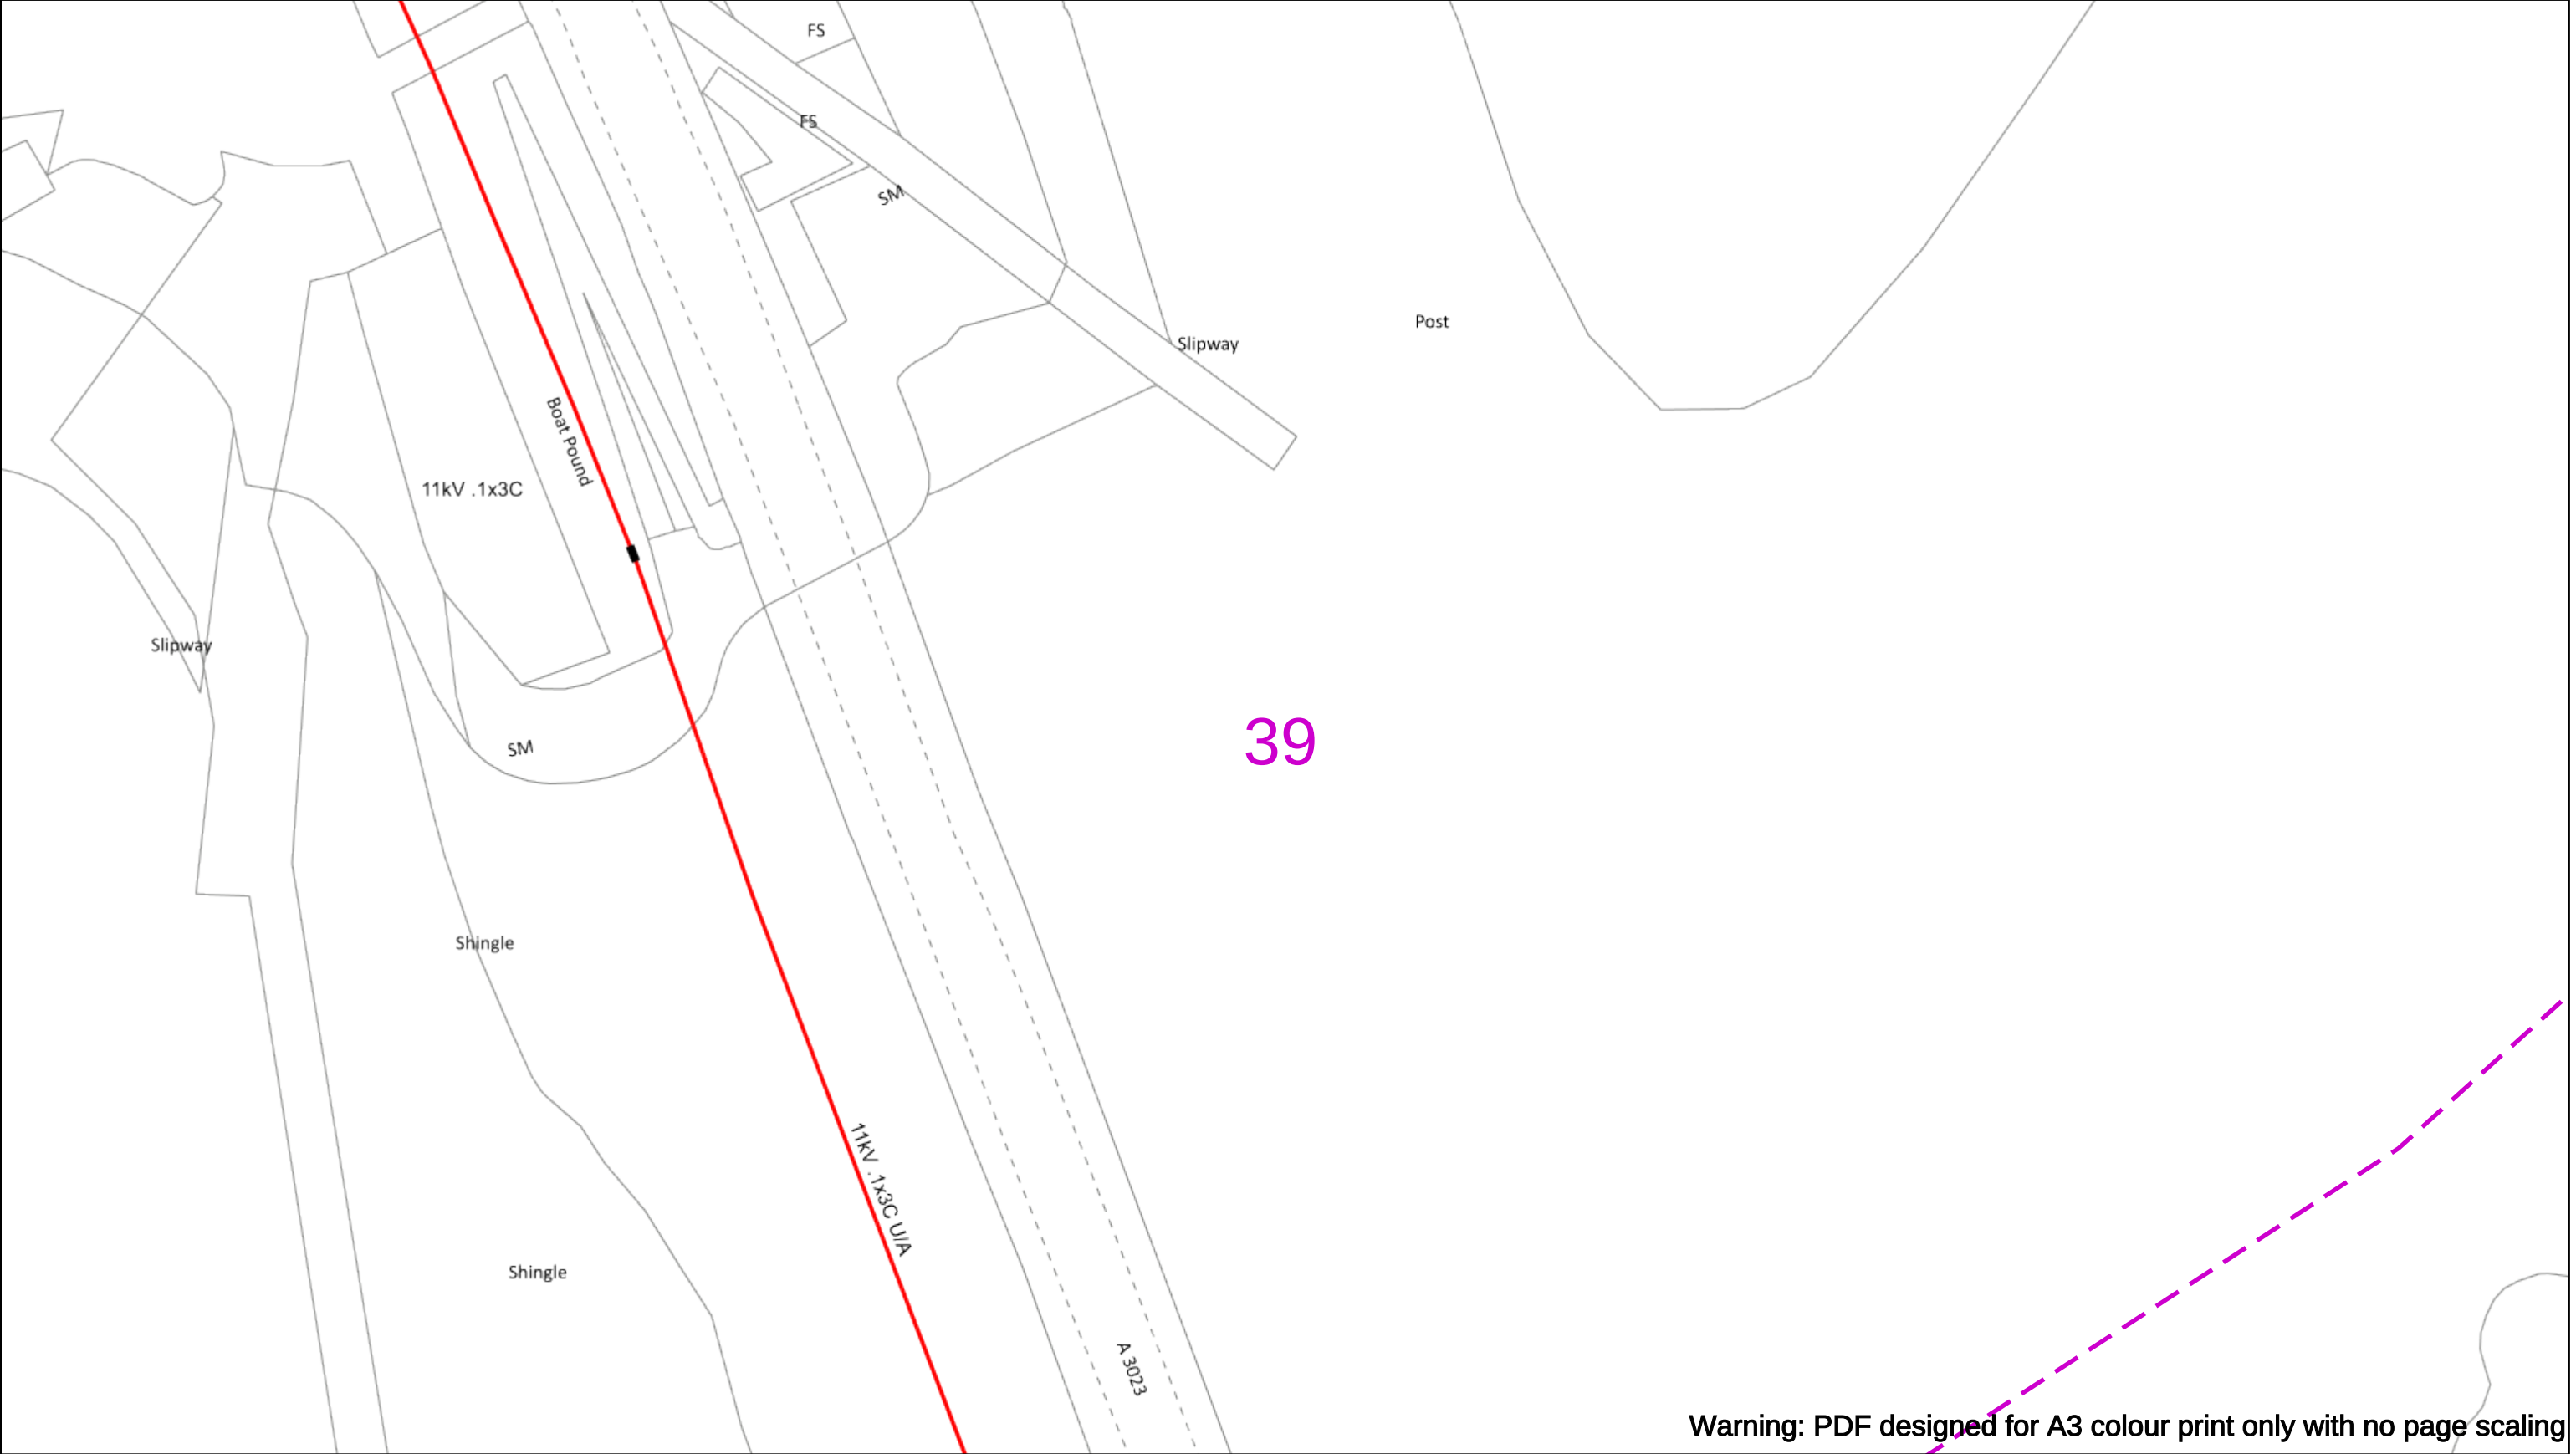

050m

Dig Sites

Area:

Line:

Extra High Voltage cables in vicinity

Date Requested: 03/09/2021

Job Reference: 23169206

Site Location: 471818 104822

Requested by:

Miss Rebecca Dabbs

Your Scheme/Reference: 736036

Langstone Flood & Coastal

WARNING

There may have been subsequent alteration to the surface levels. Trial holes must be undertaken to determine position and depths of cables. HS (G) 47 Booklet from the Health and Safety Executive – Avoiding Danger from Buried Cables – should be consulted before commencing excavation work.

WHEN WORKING IN THE VICINITY OF OVERHEAD LINES THE HEALTH AND SAFETY GUIDANCE NOTES GS6 SHOULD BE CONSULTED (AVAILABLE FROM THE HSE WEBSITE)

	Voltages (V)			
LV (Low Voltage) and Services	Up to 1,000V			
HV (High Voltage)	Over 1,000V to 11,000V			
EHV (Extra High Voltage)	22,000V to 132,000V			
Transmission	275,000V and 400,000V			

	NORMAL DEPTH TO THE TOP OF THE CABLE WHEN LAID			
	Services	LV	HV	EHV
Footpath/Unmade	0.45m	0.45m	0.6m	0.8m
Road Crossing	0.6m	0.6m	0.75m	0.9m
Agricultural	1m	1m	1m	1.1m

Legend

Service Cable

0V Mains

2-3.3kV

6.6kV

11kV

22kV

33kV

66kV

132kV

275kV

400kV

Fibre Optic

Pilot Cable

Pole, Existing Location

Pole Structure, Existing Location - Single

Pole Structure, Existing Location - H

Duct Route

Cross Section Route

Southern Electric Power Distribution plc

Registered Office: No.1 Forbury Place

43 Forbury Road Reading RG1 3JH

Registered In England & Wales No.04094290

If you're unsure & need to seek advice before commencing excavations please contact:

General Enquiries: 0800 048 3516

Subject to revision – Master held by SSEN Asset Data Team:

 
Asset.Data@sse.com

01256 337 294

Scale: 1:500 (When plotted at A3)

BASED UPON THE ORDNANCE SURVEY MAP WITH THE SANCTION OF THE CONTROLLER OF H.M STATIONERY OFFICE CROWN COPYRIGHT RESERVED.

This copy has been made by or with the authority of Scottish and Southern Energy Power Distribution Ltd. Pursuant to section 47 of the Copyright, Designs and Patents Act 1988 ('The Act'). Unless the Act provides a relevant exception to copyright the copy must not be copied without prior permission of the copyright owner. Plans generated by DigSAFE Pro™ software provided by LinesearchbeforeUdig.



Langstone Harbour

41

Warning: PDF designed for A3 colour print only with no page scaling

050m

Dig SitesArea: Line:

Extra High Voltage cables in vicinity



Date Requested: 03/09/2021

Job Reference: 23169206

Site Location: 471818 104822

Requested by:
Miss Rebecca Dabbs

Your Scheme/Reference: 736036

Langstone Flood & Coastal

WARNING

There may have been subsequent alteration to the surface levels. Trial holes must be undertaken to determine position and depths of cables. HS (G) 47 Booklet from the Health and Safety Executive – Avoiding Danger from Buried Cables – should be consulted before commencing excavation work.

WHEN WORKING IN THE VICINITY OF OVERHEAD LINES THE HEALTH AND SAFETY GUIDANCE NOTES GS6 SHOULD BE CONSULTED (AVAILABLE FROM THE HSE WEBSITE)

Voltages (V)

LV (Low Voltage) and ServicesUp to 1,000V

HV (High Voltage)Over 1,000V to 11,000V

EHV (Extra High Voltage)22,000V to 132,000V

Transmission275,000V and 400,000V

NORMAL DEPTH TO THE TOP OF THE CABLE WHEN LAID

	Services	LV	HV	EHV
Footpath/Unmade	0.45m	0.45m	0.6m	0.8m
Road Crossing	0.6m	0.6m	0.75m	0.9m
Agricultural	1m	1m	1m	1.1m

Legend

Service Cable

10/ Mains

2 – 3.3kV

6.6kV

11kV

22kV

33kV

66kV

132kV

275kV

400kV

Fibre Optic

Pilot Cable

Distribution Structures [Electric]

Pole, Existing Location

Pole Structure, Existing Location – Single

Pole Structure, Existing Location – H

Duct Route

Cross Section Route

Southern Electric Power Distribution plc

Registered Office: No.1 Forbury Place

43 Forbury Road Reading RG1 3JH

Registered In England & Wales No.04094290

If you're unsure & need to seek advice before commencing excavations please contact:

General Enquiries: 0800 048 3516

Subject to revision – Master held by SSEN Asset Data Team:


Asset.Data@sse.com

01256 337 294

Scale: 1:500 (When plotted at A3)

BASED UPON THE ORDNANCE SURVEY MAP WITH THE SANCTION OF THE CONTROLLER OF H.M STATIONERY OFFICE CROWN COPYRIGHT RESERVED.

This copy has been made by or with the authority of Scottish and Southern Energy Power Distribution Ltd. Pursuant to section 47 of the Copyright, Designs and Patents Act 1988 ('The Act'). Unless the Act provides a relevant exception to copyright the copy must not be copied without prior permission of the copyright owner. Plans generated by DigSAFE Pro™ software provided by LinesearchbeforeUdig.

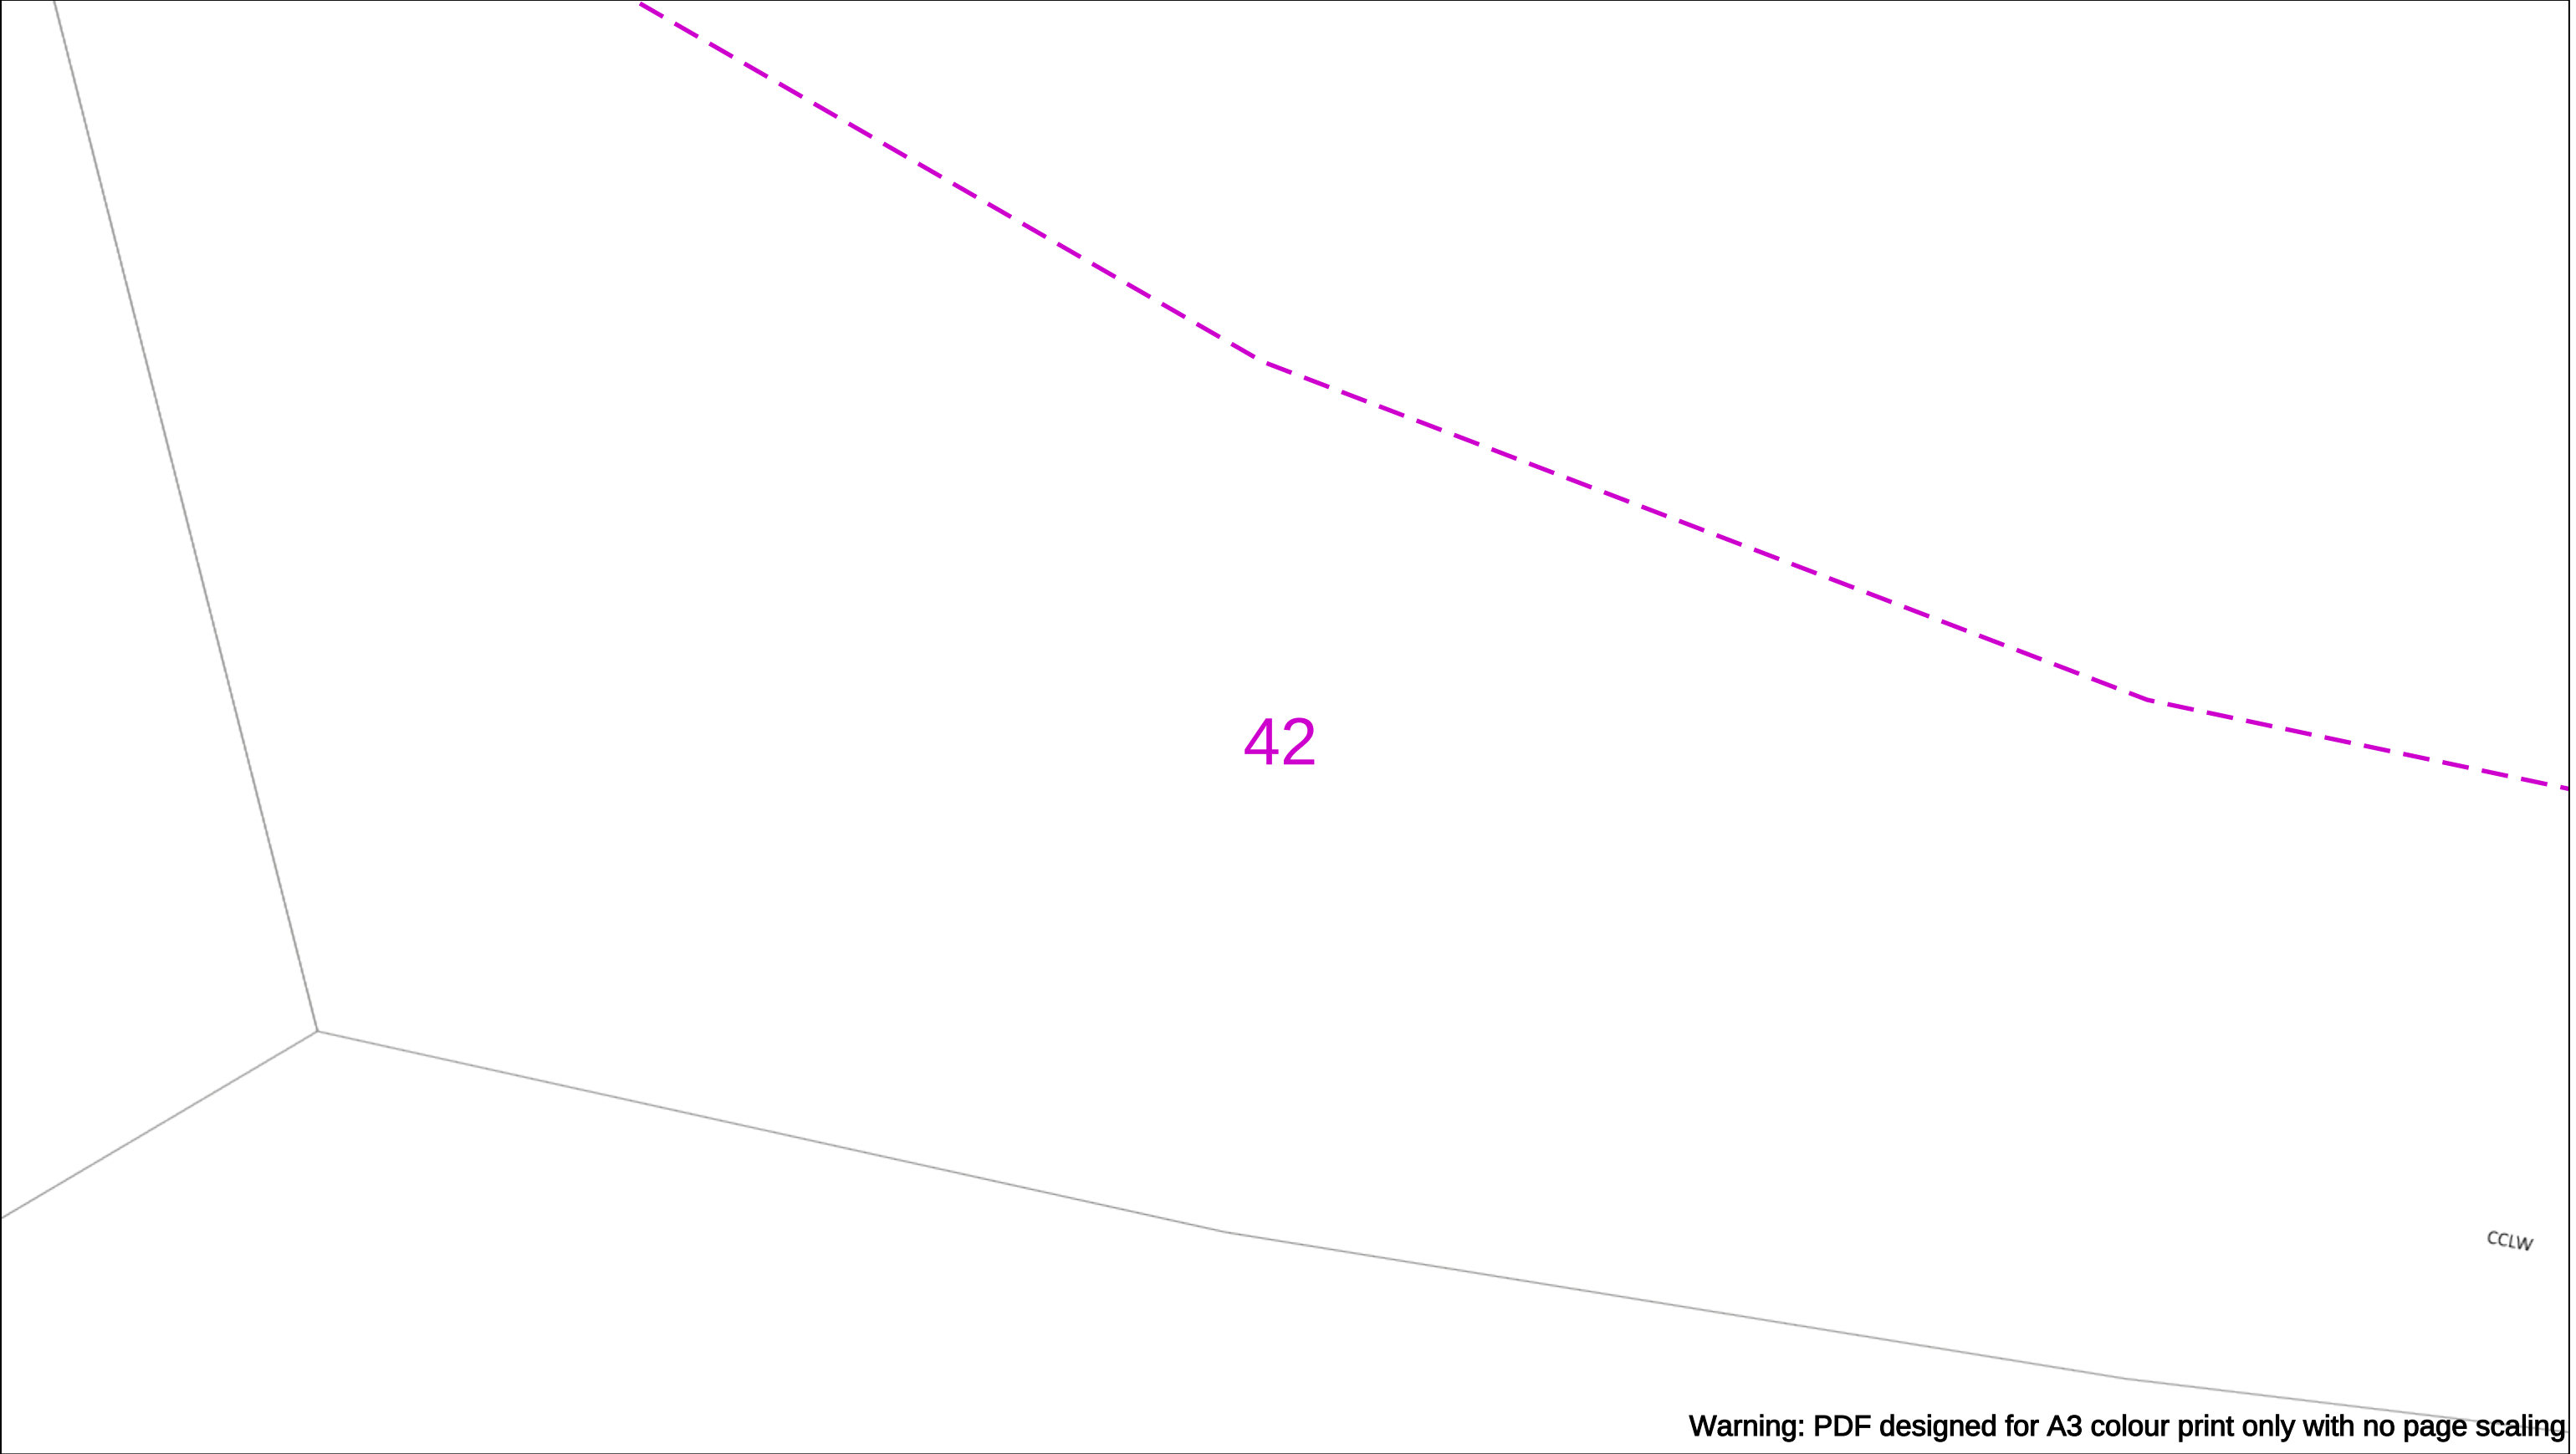

CCLW

Warning: PDF designed for A3 colour print only with no page scaling

050m

Dig Sites

Area:

Line:

Extra High Voltage cables in vicinity

Date Requested: 03/09/2021

Job Reference: 23169206

Site Location: 471818 104822

Requested by:
Miss Rebecca Dabbs

Your Scheme/Reference: 736036

Langstone Flood & Coastal

WARNING

There may have been subsequent alteration to the surface levels. Trial holes must be undertaken to determine position and depths of cables. HS (G) 47 Booklet from the Health and Safety Executive – Avoiding Danger from Buried Cables – should be consulted before commencing excavation work.

WHEN WORKING IN THE VICINITY OF OVERHEAD LINES THE HEALTH AND SAFETY GUIDANCE NOTES GS6 SHOULD BE CONSULTED (AVAILABLE FROM THE HSE WEBSITE)

Voltages (V)

LV (Low Voltage) and ServicesUp to 1,000V

HV (High Voltage)Over 1,000V to 11,000V

EHV (Extra High Voltage)22,000V to 132,000V

Transmission275,000V and 400,000V

NORMAL DEPTH TO THE TOP OF THE CABLE WHEN LAID

Services	LV	HV	EHV	
Footpath/Unmade	0.45m	0.45m	0.6m	0.8m
Road Crossing	0.6m	0.6m	0.75m	0.9m
Agricultural	1m	1m	1m	1.1m

Legend

Service Cable

10/ Mains

2 – 3.3kV

6.6kV

11kV

22kV

33kV

66kV

132kV

275kV

400kV

Fibre Optic

Pilot Cable

Distribution Structures [Electric]

Pole, Existing Location

Pole Structure, Existing Location – Single

Pole Structure, Existing Location – H

Duct Route

Cross Section Route

Southern Electric Power Distribution plc

Registered Office: No.1 Forbury Place

43 Forbury Road Reading RG1 3JH

Registered In England & Wales No.04094290

If you're unsure & need to seek advice before commencing excavations please contact:

General Enquiries: 0800 048 3516

Subject to revision – Master held by SSEN Asset Data Team:


Asset.Data@sse.com

01256 337 294

Scale: 1:500 (When plotted at A3)

BASED UPON THE ORDNANCE SURVEY MAP WITH THE SANCTION OF THE CONTROLLER OF H.M STATIONERY OFFICE CROWN COPYRIGHT RESERVED.

This copy has been made by or with the authority of Scottish and Southern Energy Power Distribution Ltd. Pursuant to section 47 of the Copyright, Designs and Patents Act 1988 ('The Act'). Unless the Act provides a relevant exception to copyright the copy must not be copied without prior permission of the copyright owner. Plans generated by DigSAFE Pro™ software provided by LinesearchbeforeUdig.

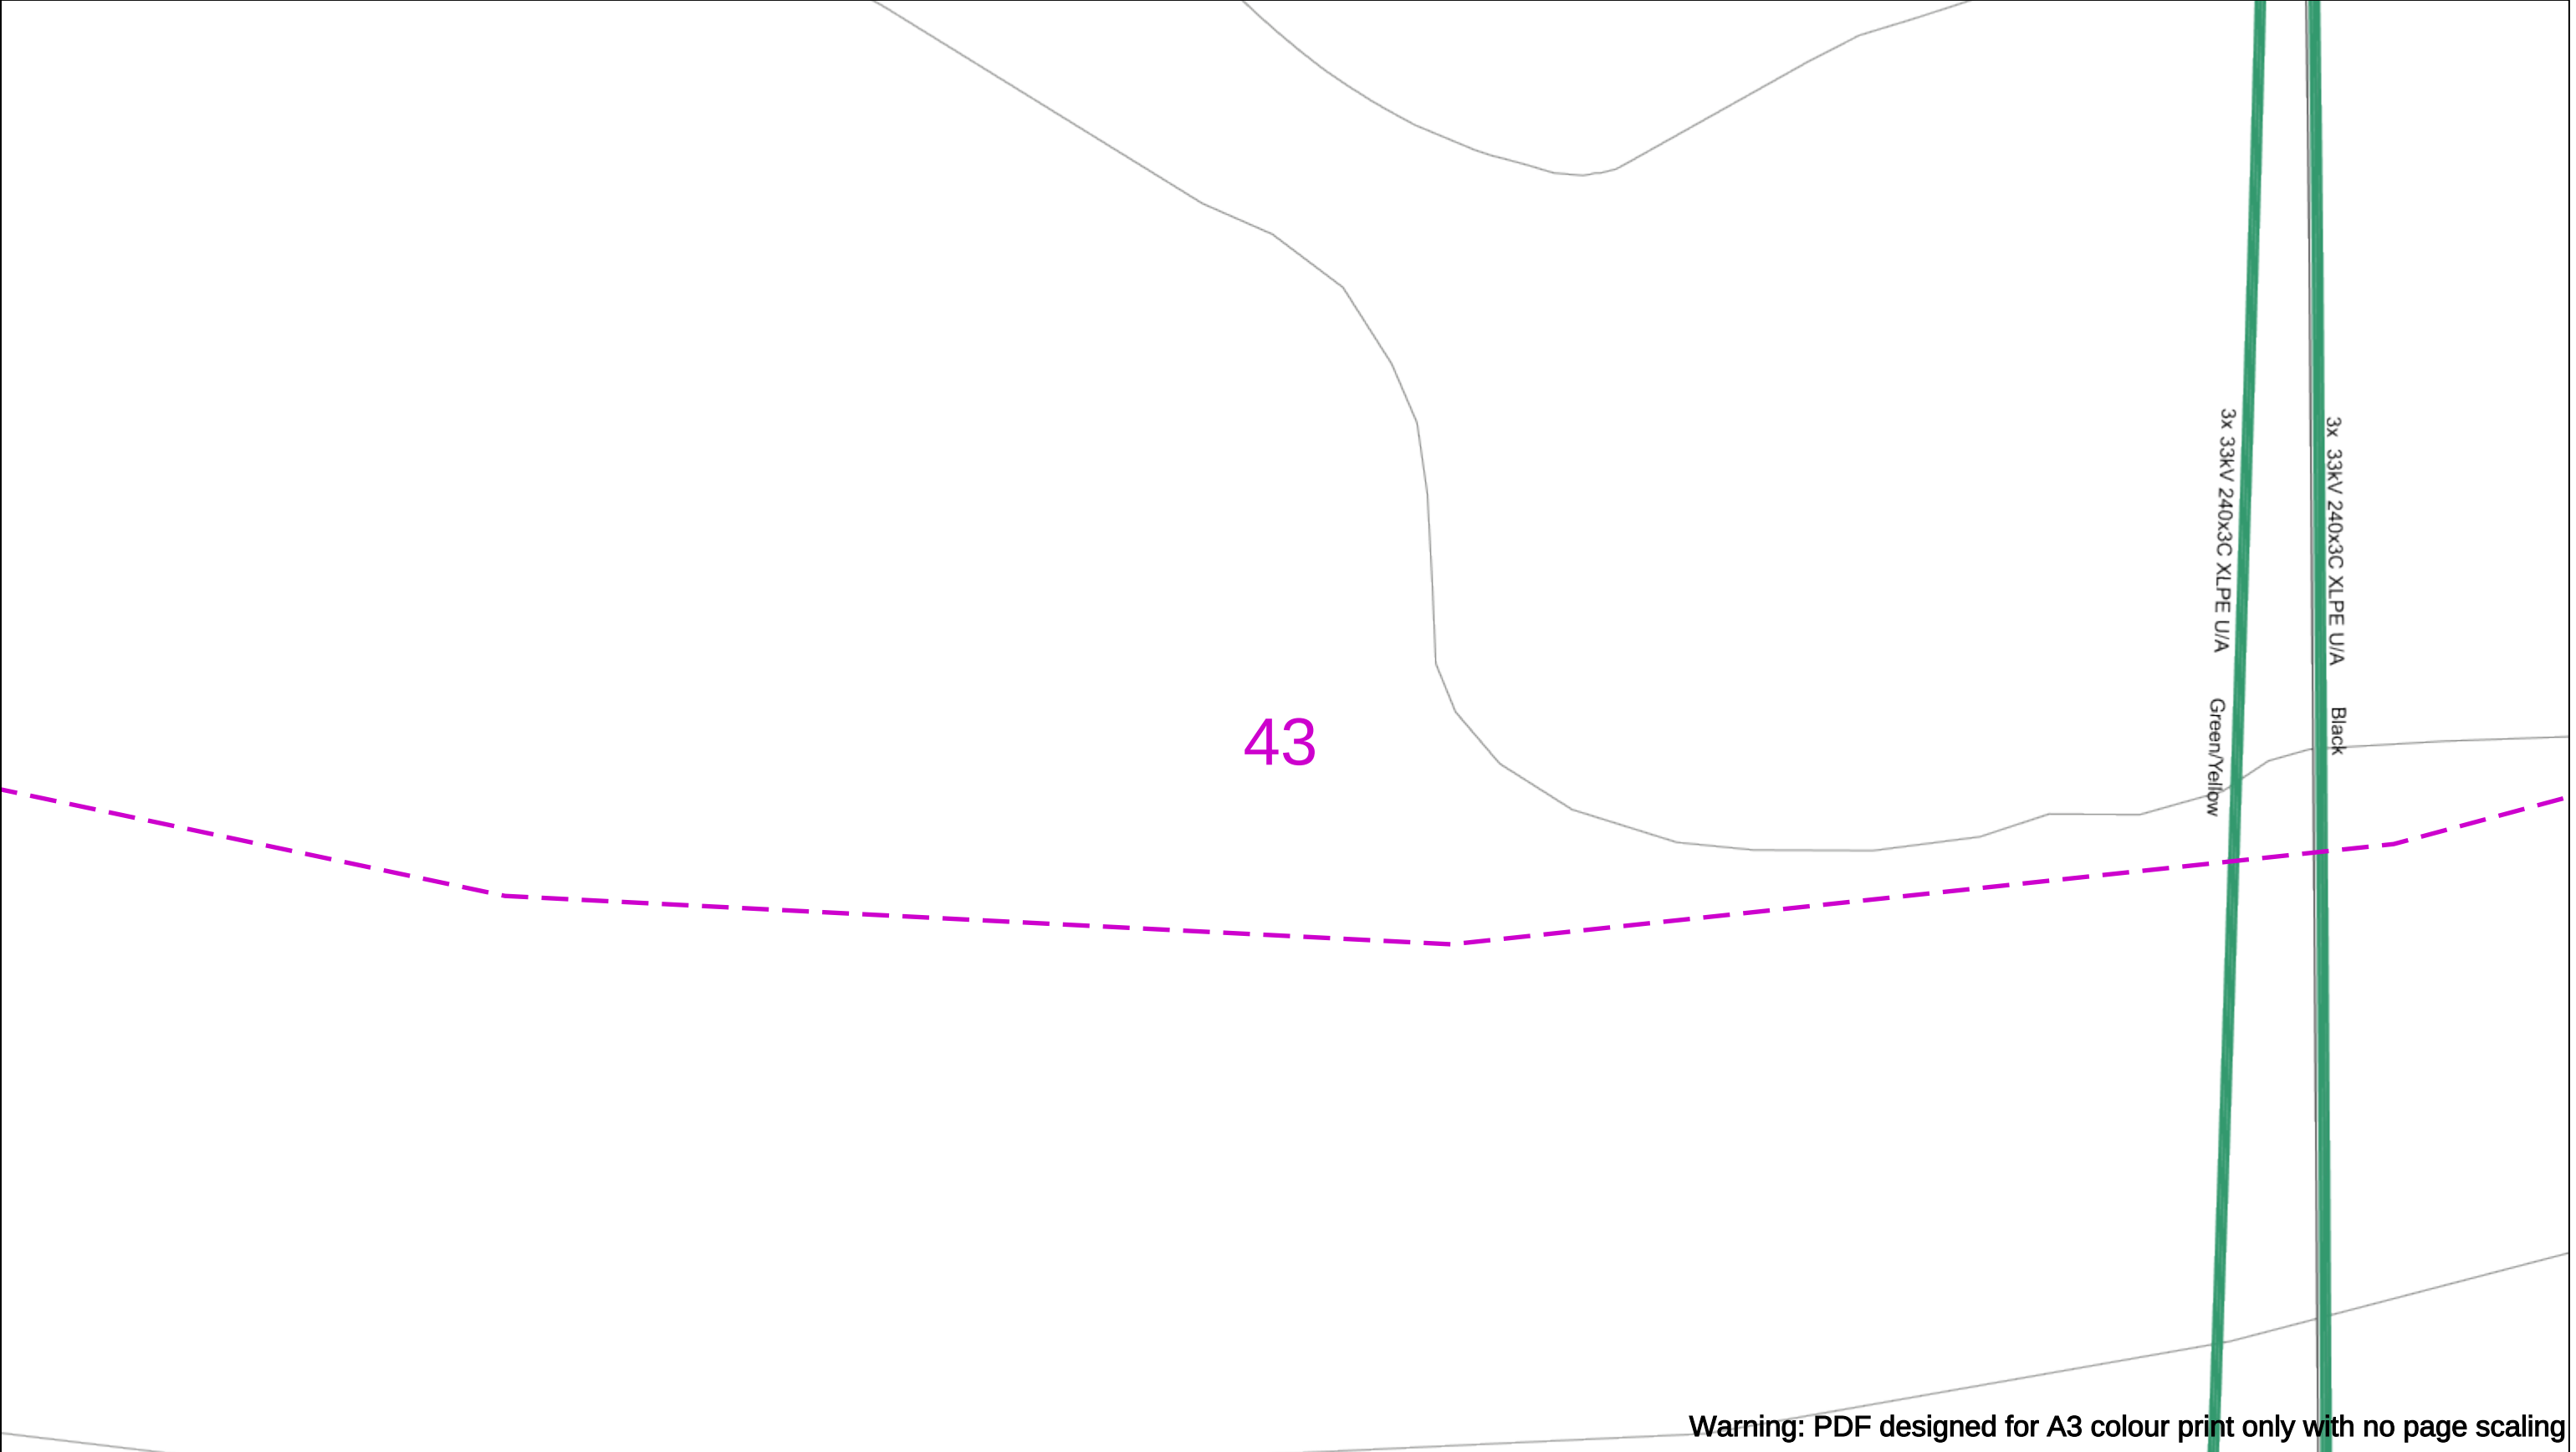

Warning: PDF designed for A3 colour print only with no page scaling

0

50m

Dig Sites

Area:

Line:

Extra High Voltage cables in vicinity

Date Requested: 03/09/2021

Job Reference: 23169206

Site Location: 471818 104822

Requested by:
Miss Rebecca Dabbs

Your Scheme/Reference: 736036

Langstone Flood & Coastal

WARNING

There may have been subsequent alteration to the surface levels. Trial holes must be undertaken to determine position and depths of cables. HS (G) 47 Booklet from the Health and Safety Executive – Avoiding Danger from Buried Cables – should be consulted before commencing excavation work.

WHEN WORKING IN THE VICINITY OF OVERHEAD LINES THE HEALTH AND SAFETY GUIDANCE NOTES GS6 SHOULD BE CONSULTED (AVAILABLE FROM THE HSE WEBSITE)

Voltages (V)				
LV (Low Voltage) and Services	Up to 1,000V			
HV (High Voltage)	Over 1,000V to 11,000V			
EHV (Extra High Voltage)	22,000V to 132,000V			
Transmission	275,000V and 400,000V			

NORMAL DEPTH TO THE TOP OF THE CABLE WHEN LAID				
	Services	LV	HV	EHV
Footpath/Unmade	0.45m	0.45m	0.6m	0.8m
Road Crossing	0.6m	0.6m	0.75m	0.9m
Agricultural	1m	1m	1m	1.1m

Legend

Service Cable

10/ Mains

2 – 33kV

66kV

132kV

275kV

400kV

Fibre Optic

Pilot Cable

Distribution Structures [Electric]

Pole, Existing Location

Pole Structure, Existing Location – Single

Pole Structure, Existing Location – H

Duct Route

Cross Section Route

Scottish & Southern

Electricity Networks

Southern Electric Power Distribution plc

Registered Office: No.1 Forbury Place

43 Forbury Road Reading RG1 3JH

Registered In England & Wales No.04094290

If you're unsure & need to seek advice before commencing excavations please contact:

General Enquiries: 0800 048 3516

Subject to revision – Master held by SSEN Asset Data Team:


Asset.Data@sse.com

01256 337 294

Scale: 1:500 (When plotted at A3)

BASED UPON THE ORDNANCE SURVEY MAP WITH THE SANCTION OF THE CONTROLLER OF THE STATIONERY OFFICE CROWN COPYRIGHT RESERVED.

This copy has been made by or with the authority of Scottish and Southern Energy Power Distribution Ltd. Pursuant to section 47 of the Copyright, Designs and Patents Act 1988 ('The Act'). Unless the Act provides a relevant exception to copyright the copy must not be copied without prior permission of the copyright owner. Plans generated by DigSAFE Pro™ software provided by LinesearchbeforeUdig.

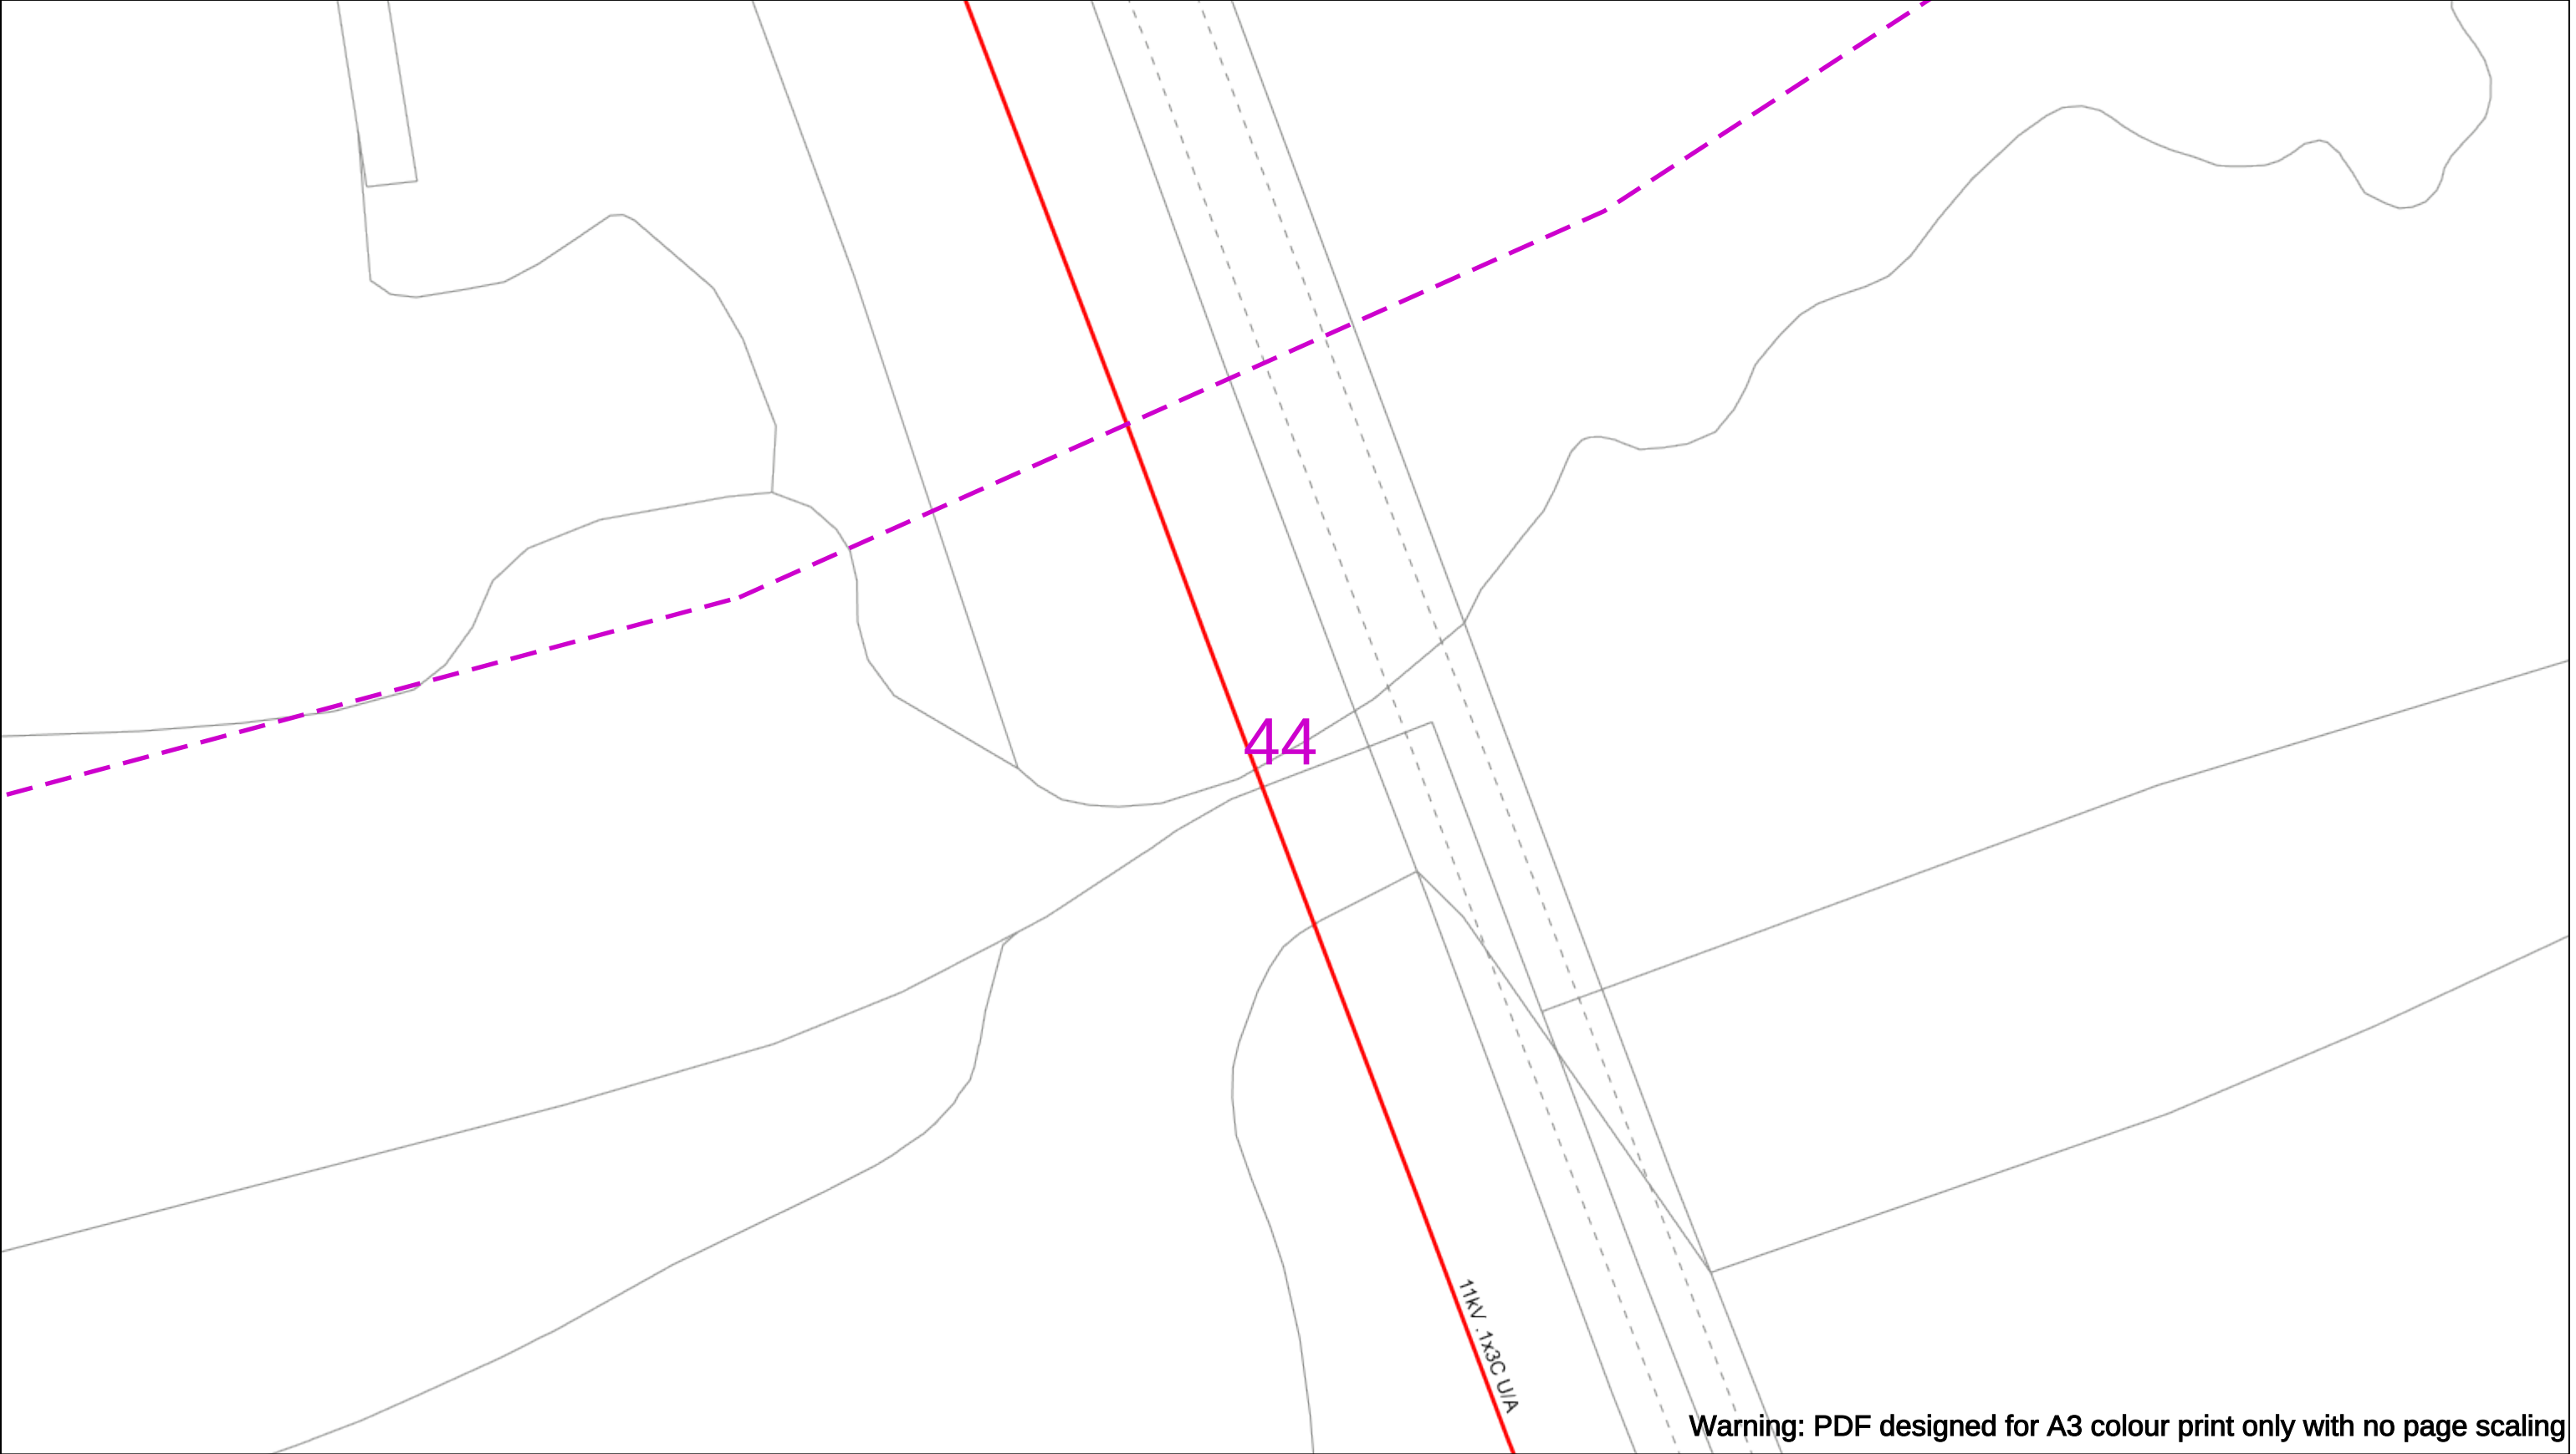

Warning: PDF designed for A3 colour print only with no page scaling

0

50m

Dig Sites

Area:

Line:

Extra High Voltage cables in vicinity

Date Requested: 03/09/2021

Job Reference: 23169206

Site Location: 471818 104822

Requested by:
Miss Rebecca Dabbs

Your Scheme/Reference: 736036

Langstone Flood & Coastal

WARNING

There may have been subsequent alteration to the surface levels. Trial holes must be undertaken to determine position and depths of cables. HS (G) 47 Booklet from the Health and Safety Executive – Avoiding Danger from Buried Cables – should be consulted before commencing excavation work.

WHEN WORKING IN THE VICINITY OF OVERHEAD LINES THE HEALTH AND SAFETY GUIDANCE NOTES GS6 SHOULD BE CONSULTED (AVAILABLE FROM THE HSE WEBSITE)

Voltages (V)				
LV (Low Voltage) and Services	Up to 1,000V			
HV (High Voltage)	Over 1,000V to 11,000V			
EHV (Extra High Voltage)	22,000V to 132,000V			
Transmission	275,000V and 400,000V			

NORMAL DEPTH TO THE TOP OF THE CABLE WHEN LAID				
	Services	LV	HV	EHV
Footpath/Unmade	0.45m	0.45m	0.6m	0.8m
Road Crossing	0.6m	0.6m	0.75m	0.9m
Agricultural	1m	1m	1m	1.1m

Legend

Service Cable

0V Mains

2-3.3kV

6.6kV

11kV

22kV

33kV

66kV

132kV

275kV

400kV

Fibre Optic

Pilot Cable

Distribution Structures [Electric]

Pole, Existing Location

Pole Structure, Existing Location - Single

Pole Structure, Existing Location - H

Duct Route

Cross Section Route

Southern Electric Power Distribution plc

Registered Office: No.1 Forbury Place

43 Forbury Road Reading RG1 3JH

Registered In England & Wales No.04094290

If you're unsure & need to seek advice before commencing excavations please contact:

General Enquiries: 0800 048 3516


Subject to revision – Master held by SSEN Asset Data Team:

Asset.Data@sse.com

01256 337 294

BASED UPON THE ORDNANCE SURVEY MAP WITH THE SANCTION OF THE CONTROLLER OF THE STATIONERY OFFICE CROWN COPYRIGHT RESERVED.

This copy has been made by or with the authority of Scottish and Southern Energy Power Distribution Ltd. Pursuant to section 47 of the Copyright, Designs and Patents Act 1988 ('The Act'). Unless the Act provides a relevant exception to copyright the copy must not be copied without prior permission of the copyright owner. Plans generated by DigSAFE Pro™ software provided by LinesearchbeforeUdig.

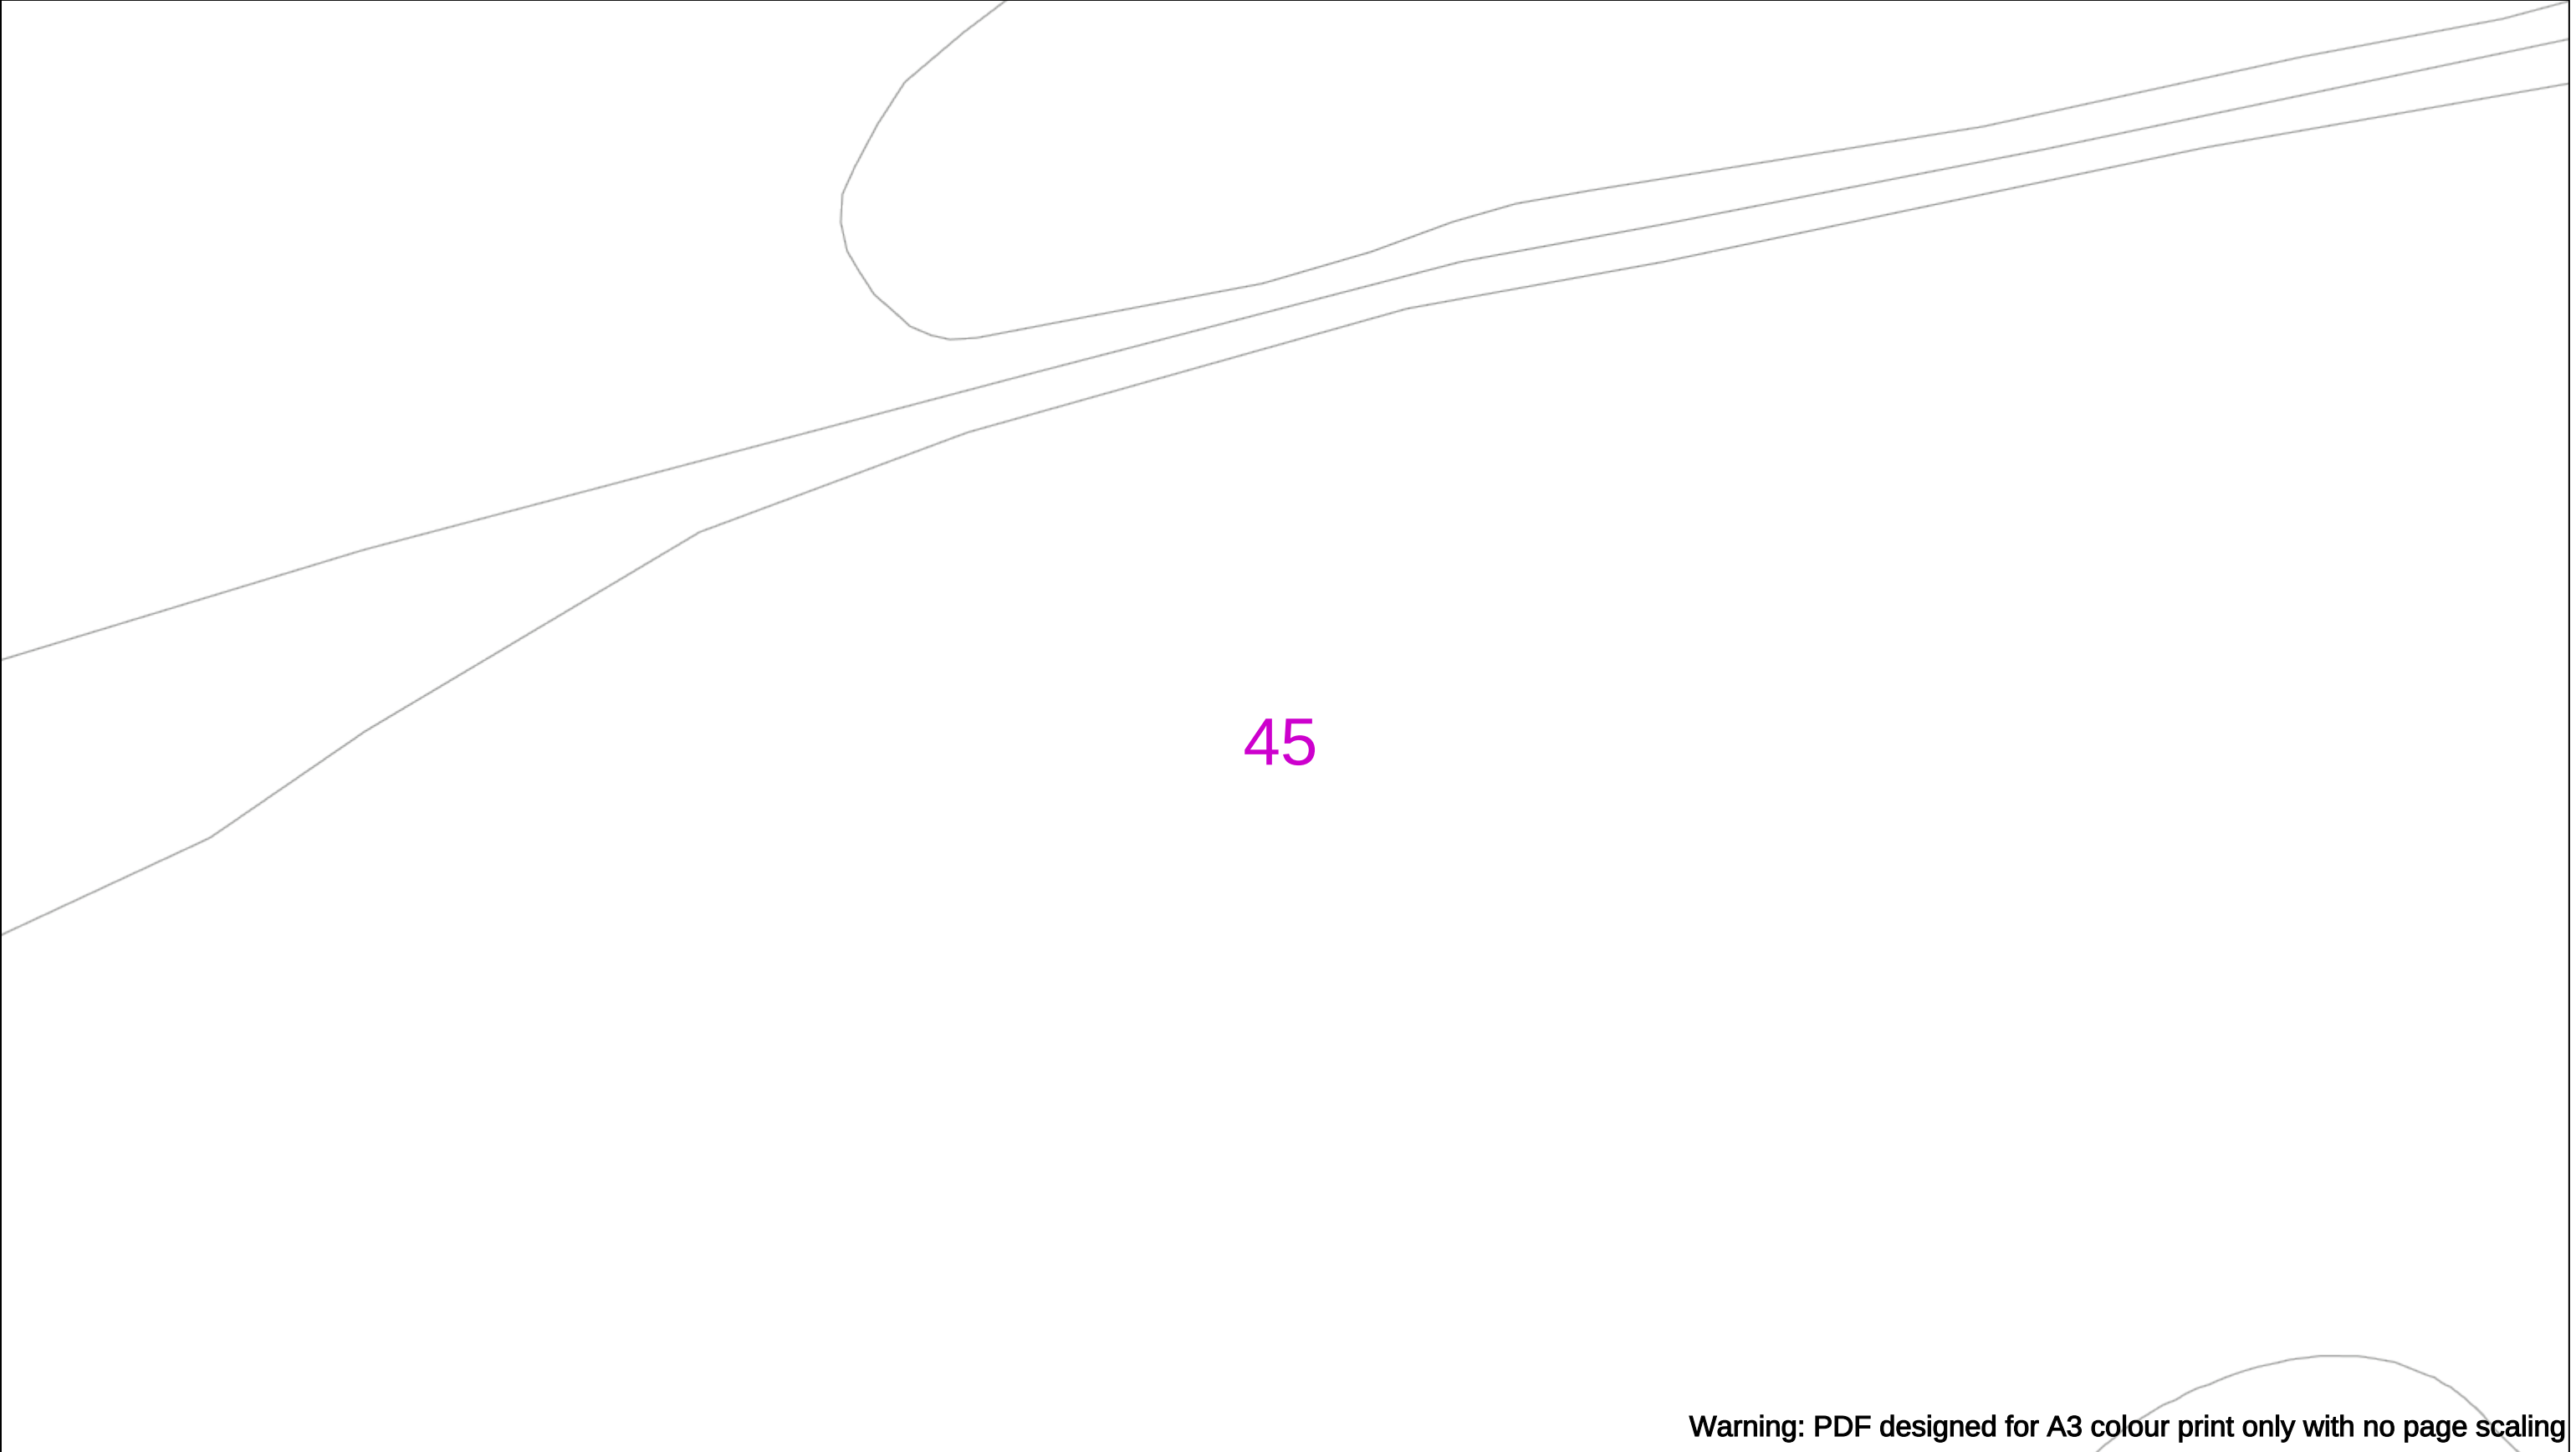

Warning: PDF designed for A3 colour print only with no page scaling

050m

Dig SitesArea: Line:

Extra High Voltage cables in vicinity

Date Requested: 03/09/2021

Job Reference: 23169206

Site Location: 471818 104822

Requested by:
Miss Rebecca Dabbs

Your Scheme/Reference: 736036

Langstone Flood & Coastal

WARNING

There may have been subsequent alteration to the surface levels. Trial holes must be undertaken to determine position and depths of cables. HS (G) 47 Booklet from the Health and Safety Executive – Avoiding Danger from Buried Cables – should be consulted before commencing excavation work.

WHEN WORKING IN THE VICINITY OF OVERHEAD LINES THE HEALTH AND SAFETY GUIDANCE NOTES GS6 SHOULD BE CONSULTED (AVAILABLE FROM THE HSE WEBSITE)

Voltages (V)				
LV (Low Voltage) and Services	Up to 1,000V			
HV (High Voltage)	Over 1,000V to 11,000V			
EHV (Extra High Voltage)	22,000V to 132,000V			
Transmission	275,000V and 400,000V			

NORMAL DEPTH TO THE TOP OF THE CABLE WHEN LAID				
	Services	LV	HV	EHV
Footpath/Unmade	0.45m	0.45m	0.6m	0.8m
Road Crossing	0.6m	0.6m	0.75m	0.9m
Agricultural	1m	1m	1m	1.1m

Legend

Service Cable

10/ Mains

2-3.3kV

6.6kV

11kV

22kV

33kV

66kV

132kV

275kV

400kV

Fibre Optic

Pilot Cable

Distribution Structures [Electric]

Pole, Existing Location

Pole Structure, Existing Location - Single

Pole Structure, Existing Location - H

Duct Route

Cross Section Route

Southern Electric Power Distribution plc

Registered Office: No.1 Forbury Place

43 Forbury Road Reading RG1 3JH

Registered In England & Wales No.04094290

If you're unsure & need to seek advice before commencing excavations please contact:

General Enquiries: 0800 048 3516

Subject to revision – Master held by SSEN Asset Data Team:

Asset.Data@sse.com

01256 337 294

BASED UPON THE ORDNANCE SURVEY MAP WITH THE SANCTION OF THE CONTROLLER OF H.M STATIONERY OFFICE CROWN COPYRIGHT RESERVED.

This copy has been made by or with the authority of Scottish and Southern Energy Power Distribution Ltd. Pursuant to section 47 of the Copyright, Designs and Patents Act 1988 ('The Act'). Unless the Act provides a relevant exception to copyright the copy must not be copied without prior permission of the copyright owner. Plans generated by DigSAFE Pro™ software provided by LinesearchbeforeUdig.

Safety Advice - Valves




Guidance when undertaking work near gas valves in our network areas

SGN manages the network that distributes gas to 5.8 million homes and businesses across Scotland and the south of England.

Due to a manufacturing issue, we are currently replacing or upgrading certain valve types that are at risk of bolt failure. In extreme cases, this can lead to gas escapes. This is a safety hazard and we have produced this guide to ensure you undertake adequate safety precautions when working near gas valves.

Identifying gas valves

The images below are an illustration of typical gas valves. Please note, valves come in various colours, shapes and sizes, and you may come across a valve that looks different to those found in the images.

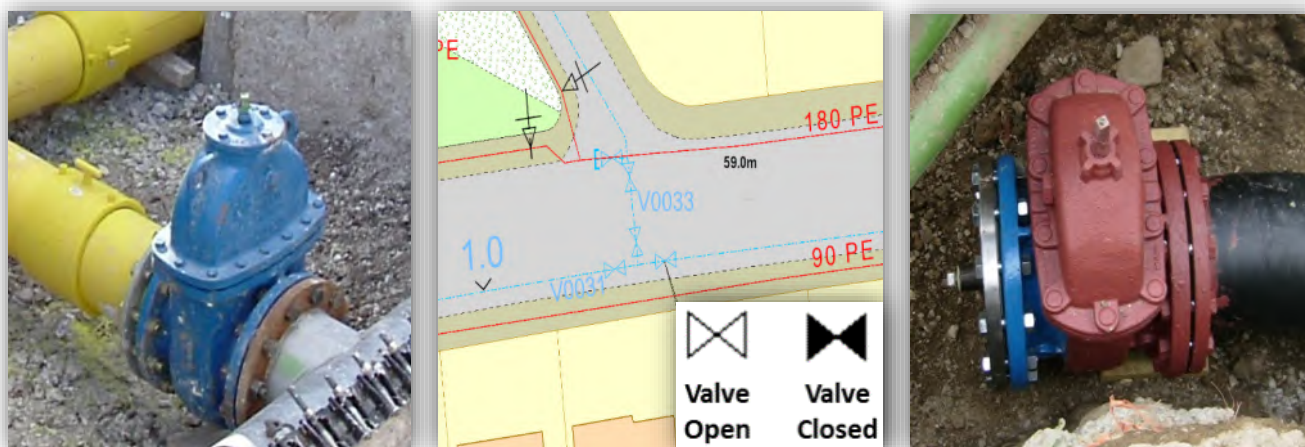

What should you do?

When planning to work in our network areas, please observe the following points:


1. You must contact us before starting any work activity within **3.0m** of a gas valve identified on our maps.
2. If an unexpected gas valve is exposed you must immediately stop excavation works and report this to us.
3. To protect yourself against the risks associated with exposing a valve, we advise that you contact us when in doubt.

Contact details

If you require further information or need assistance please contact us:

Safety Admin Team: **0800 912 1722**
plantlocation@sgn.co.uk

Valve enquiries will be forwarded to a local engineer who will provide further safety information.

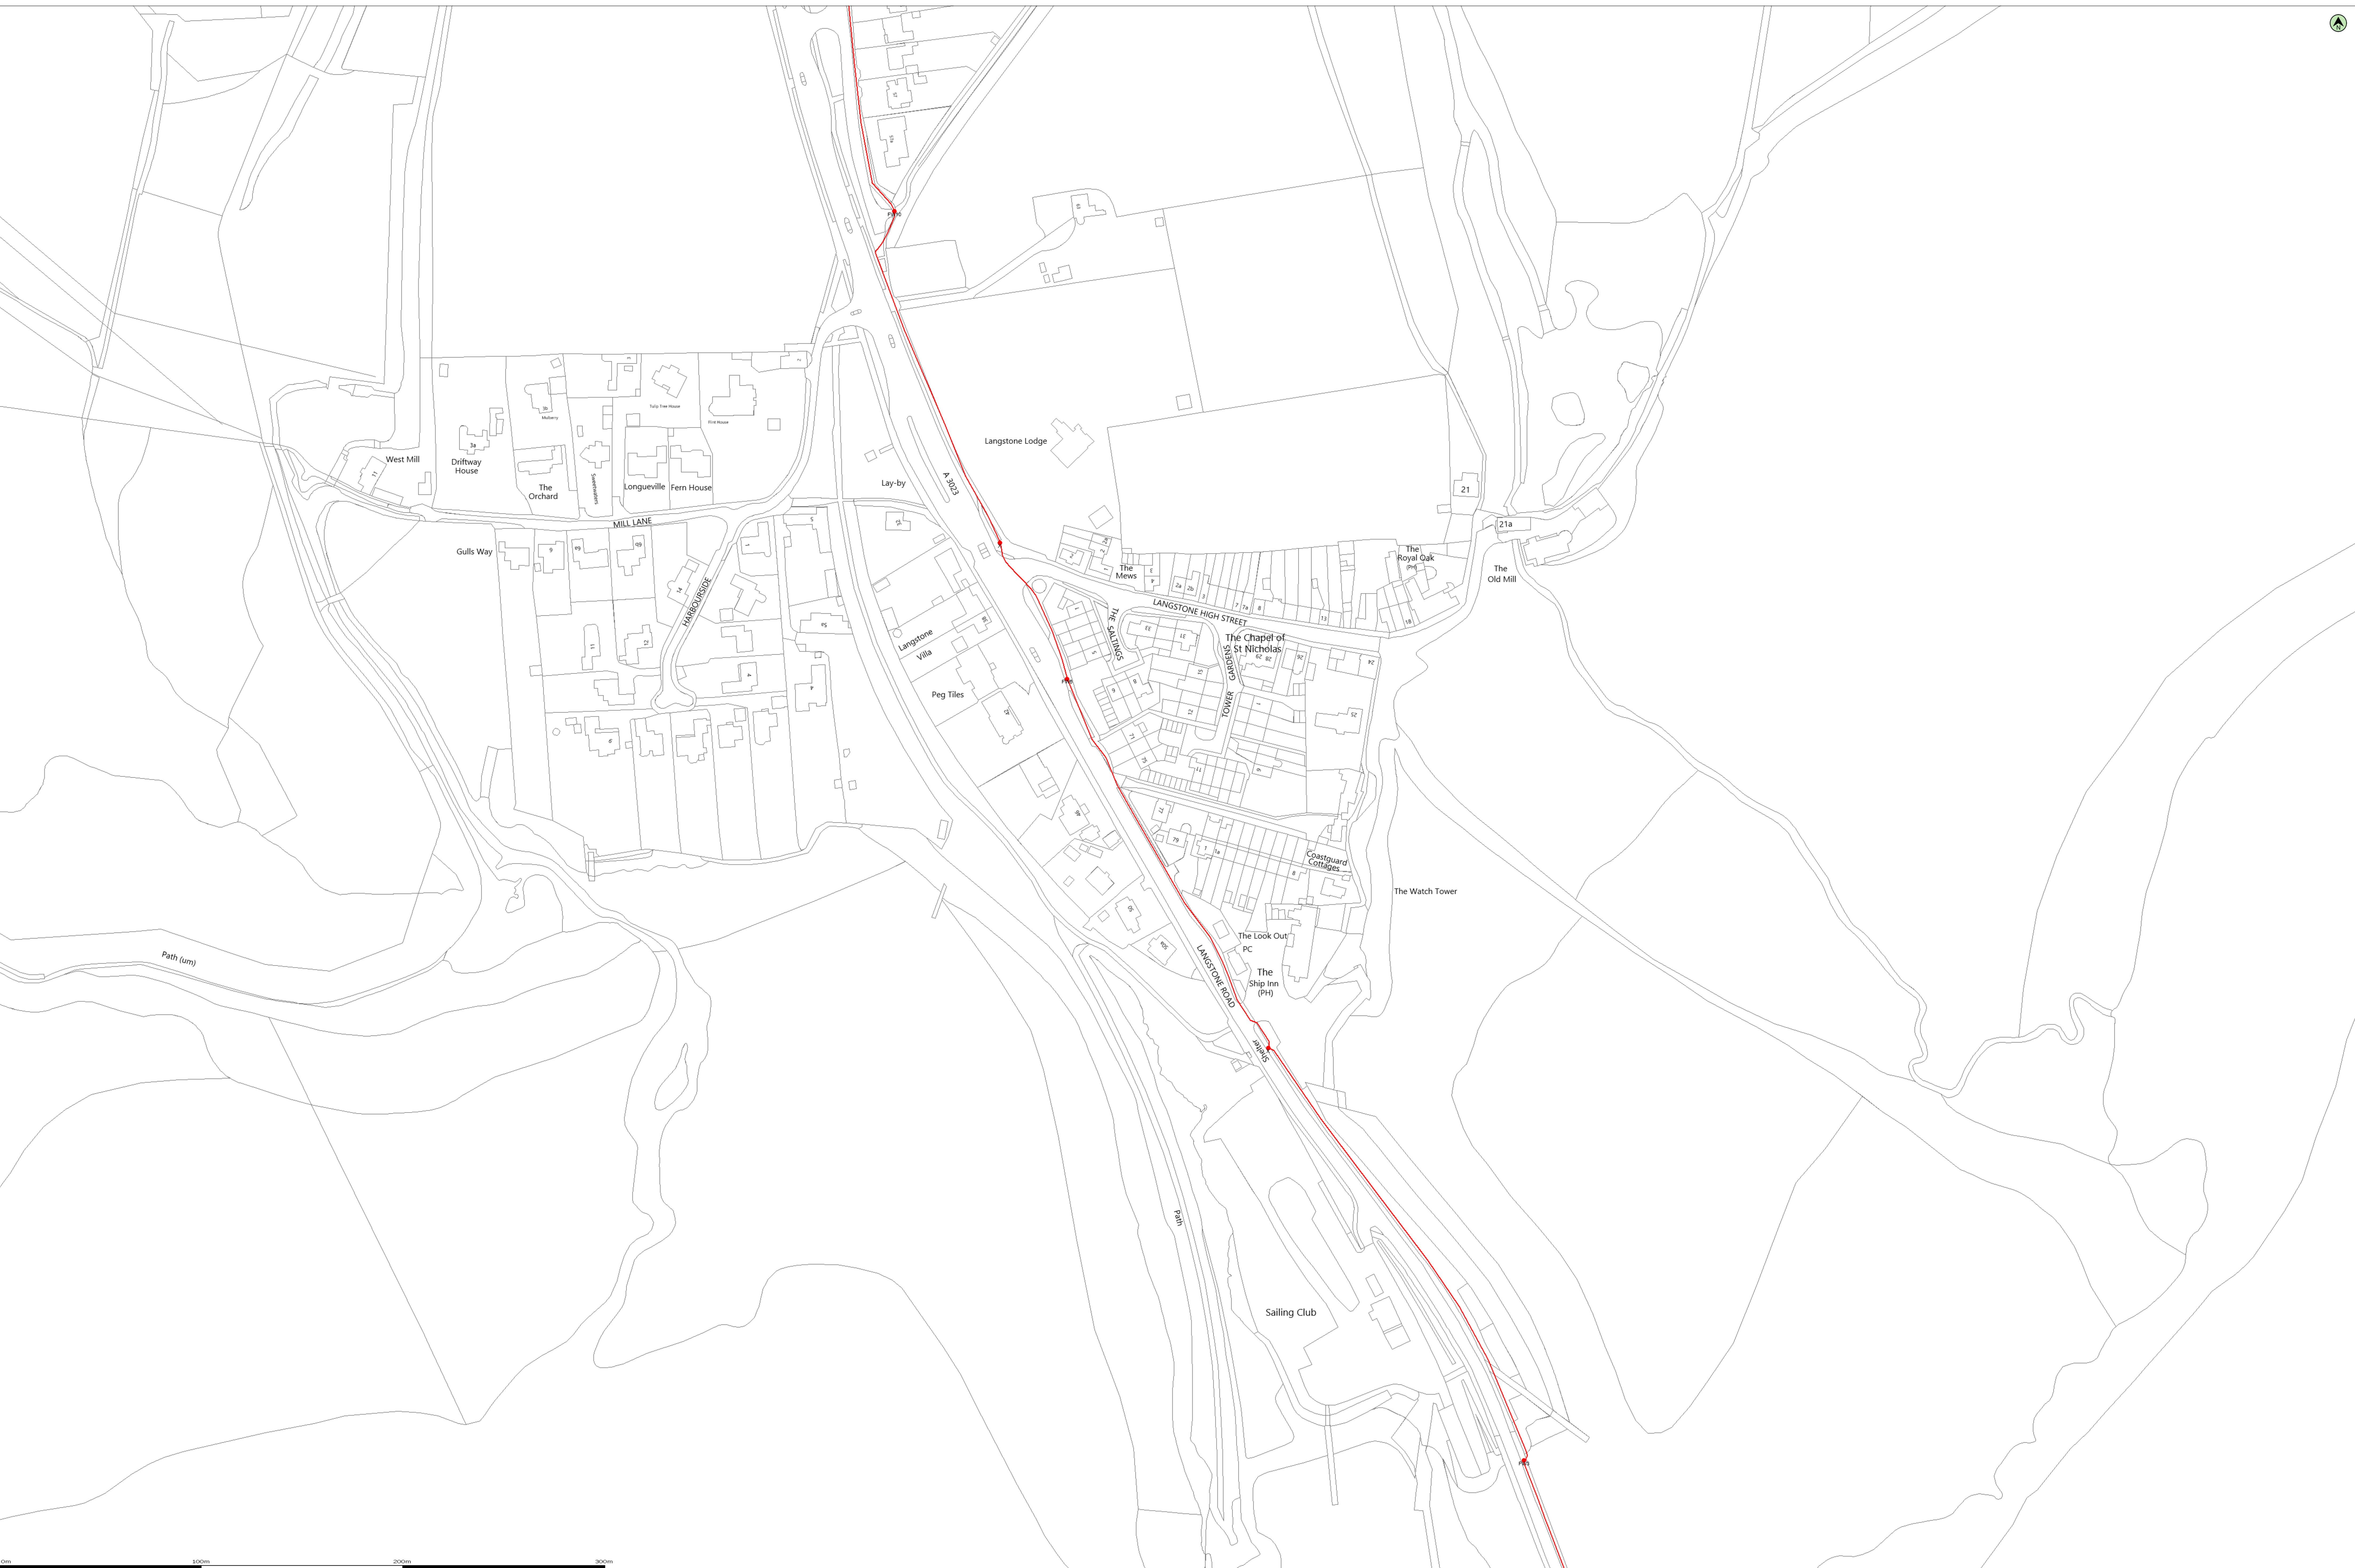

0m 100m 200m 300m


(c) Crown copyright and database rights 2021 Ordnance Survey 100019209 Date: 03/09/21 Scale: 1:1000 Map Centre: 471818.104822 Data updated: 01/08/21 Our Ref: 640395 - 1 Telecoms Plan A0

Important information - please read The purpose of this plan is to identify Virgin Media apparatus. We have tried to make it as accurate as possible but we cannot warrant its accuracy. In addition, we caution that within Virgin Media apparatus there may be interfaces where mains voltage power cables have been placed inside green earth this should during further details can be found using the 'Advanced' button below. Which can be downloaded from this website. Therefore, you must not rely solely on this plan if you are carrying out any excavation or other works in the vicinity of Virgin Media apparatus. The actual location of any underground service may be marked by cable detection equipment, etc. will be established or not before any mechanical plant is used. Accordingly, unless it is due to the negligence of Virgin Media, its employees or agents, Virgin Media will not have any liability for any omissions or inaccuracies in the plan or for any loss or damage caused or arising from the use of and/or any reliance on this plan. This plan is provided by Virgin Media Limited (c) Crown copyright and database rights 2021 Ordnance Survey 100019209

Duct, Trench
Chamber
Cabinet

726036



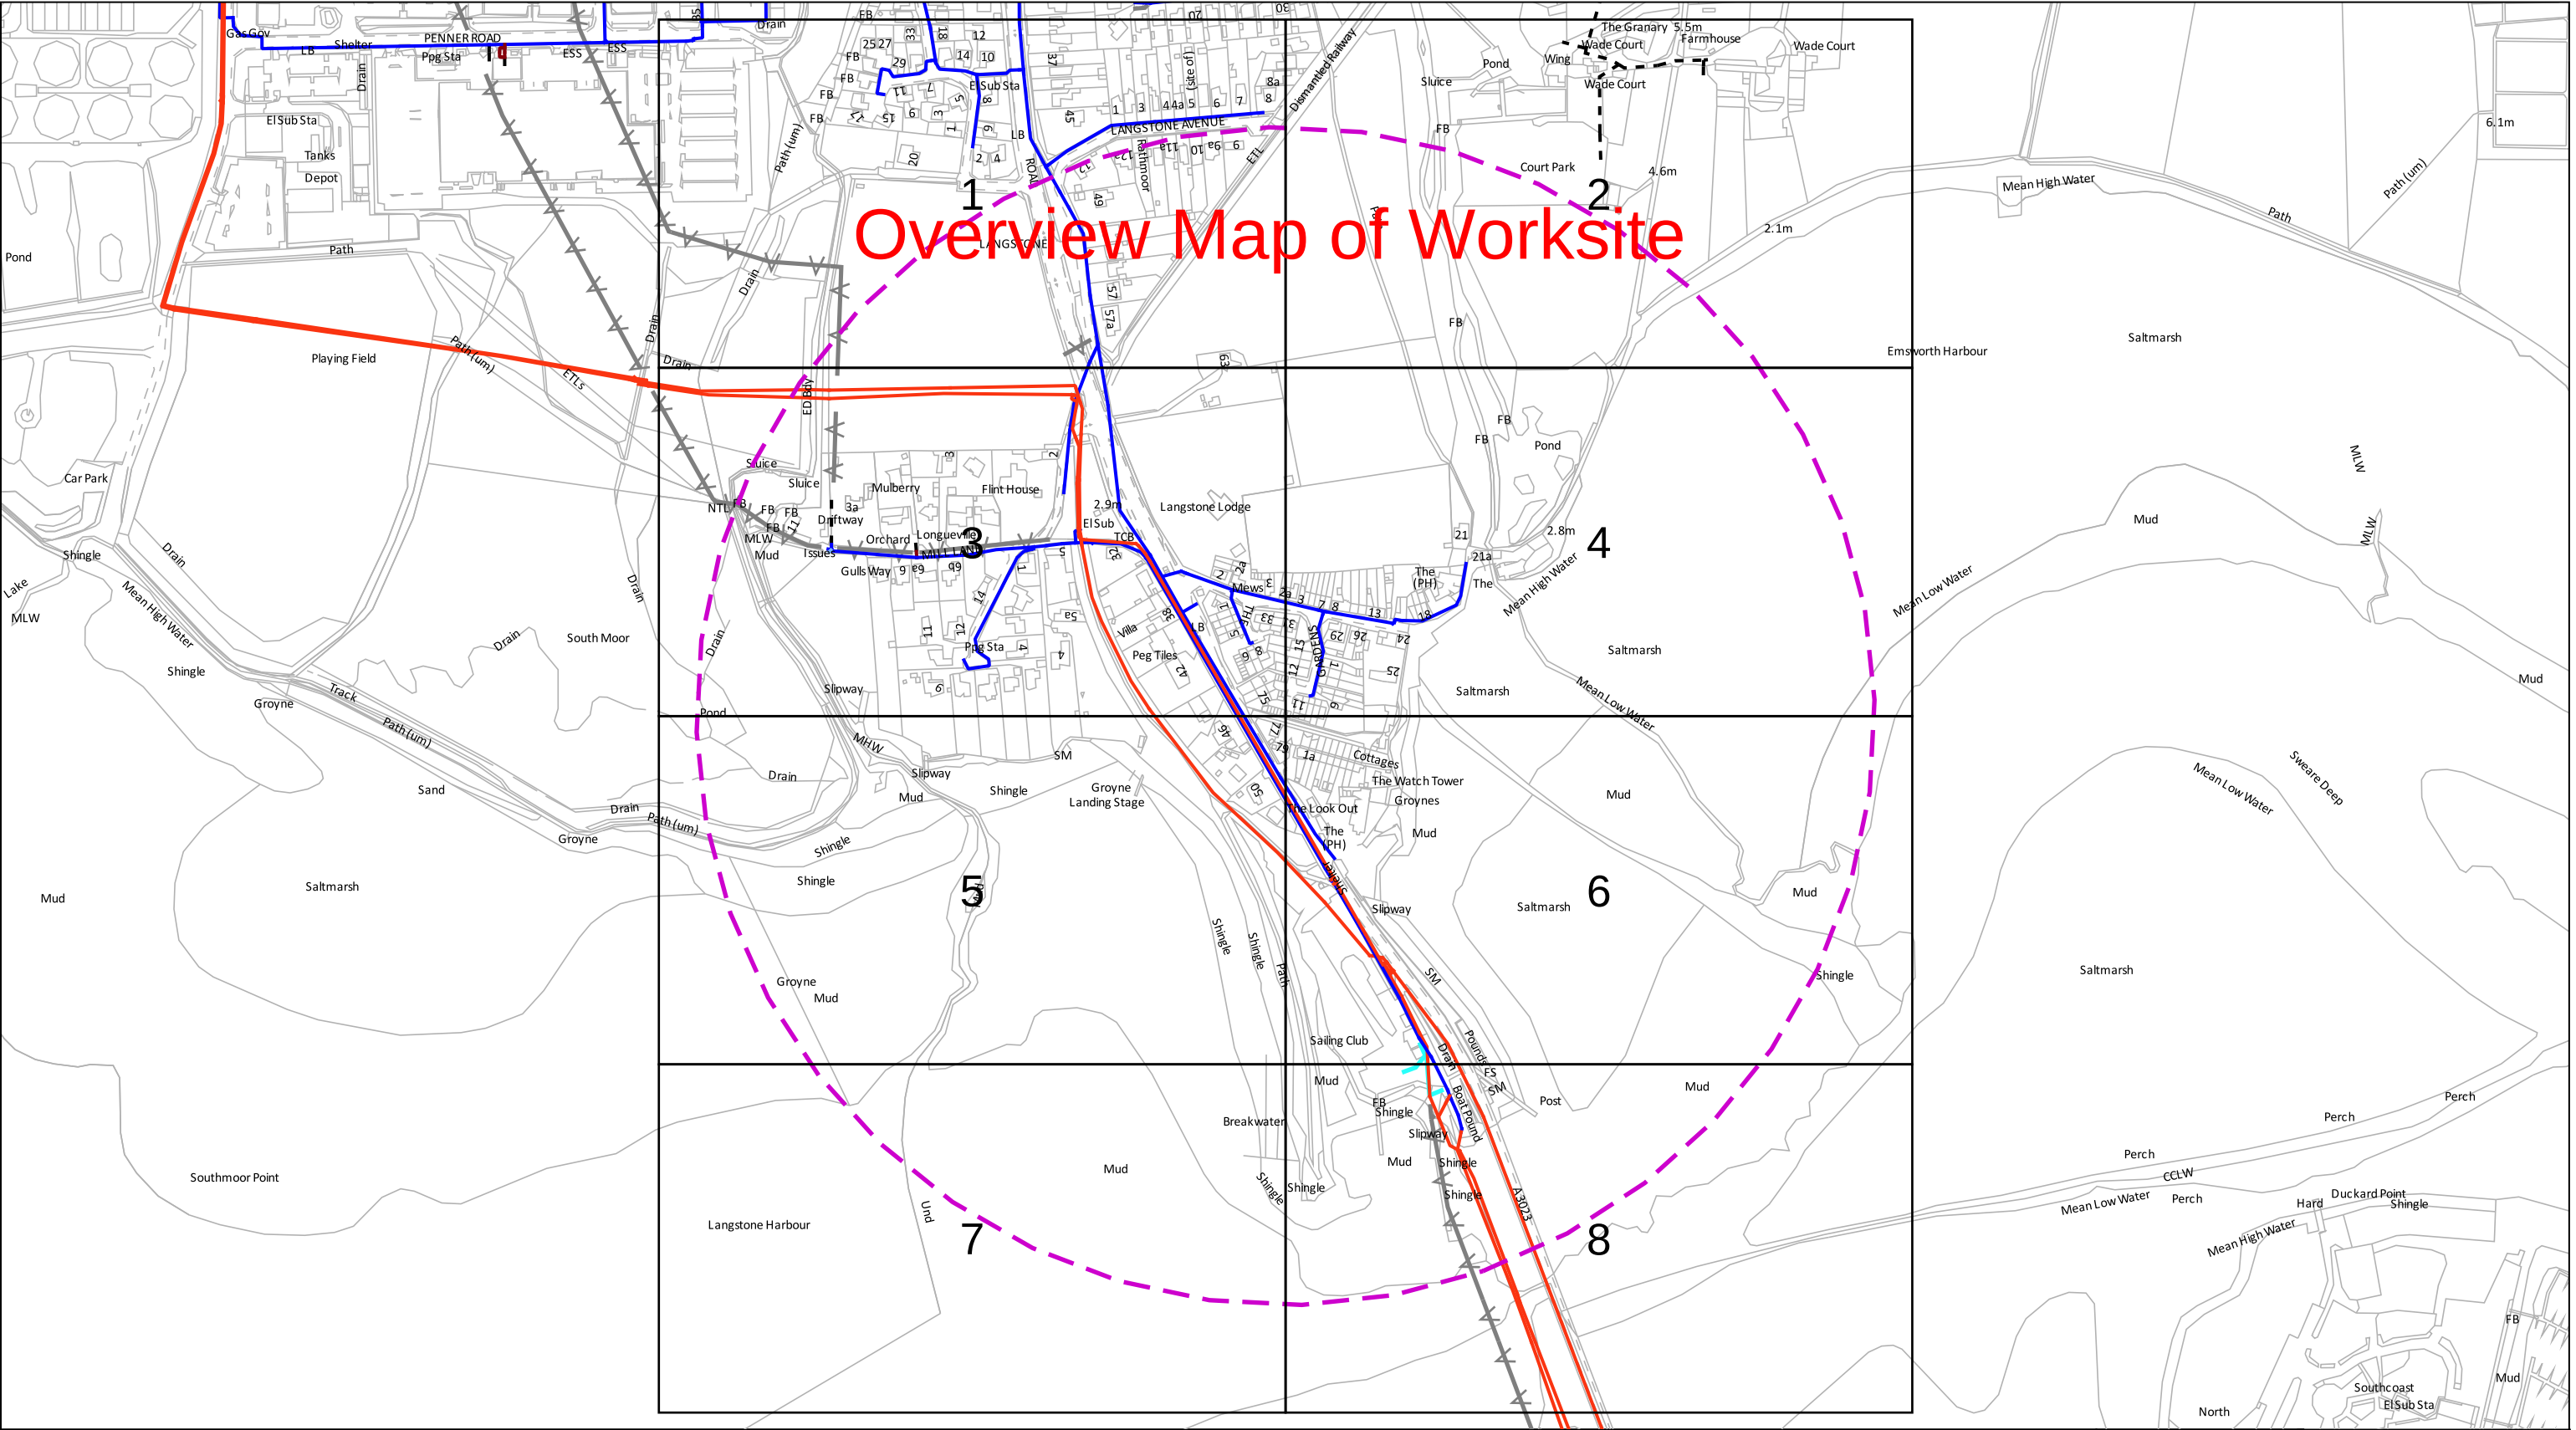

Date Requested: 03/09/2021

Job Reference: 23169206

Site Location: 471818 104822

Requested by:
Miss Rebecca Dabbs

Your Scheme/Reference: 736036

Langstone Flood & Coastal

Scale: 1:5125 (When plotted at A3)

Dig Sites

Area:

Line:

Measurements scaled from this plan may not match measurements between the same points on the ground.

Distribution Mains

Raw Water Main

Fire Main

Abandoned Mains

Communication Pipe

Trunk Main

Private Mains

Cable

The information supplied is given in good faith as a guide to locating underground apparatus. Its accuracy cannot be guaranteed, nor does it include comprehensive information about the existence or location of service pipes or cables to individual premises. The responsibility for locating and avoiding damage to apparatus on site shall be that of the person proposing to excavate in the street who shall be liable to the apparatus owner and any third party who may be affected in any way for any loss or damage caused by their failure to do so.

Registered Office

P.O. BOX NO. 8, West Street, Havant,

Hampshire. PO9 1LG.

Registered in England No. 2536455

Telephone: (023) 9249 9888


Fax: (023) 9245 3632

Website: www.portsmouthwater.co.uk

© Crown copyright and database rights 2020. Ordnance Survey Licence Number 100018036.

Warning: PDF designed for colour print only with no page scaling. This information is given as a guide only and its accuracy cannot be guaranteed

Plans generated by DigSAFE Pro™ software provided by LinesearchbeforeUdig.

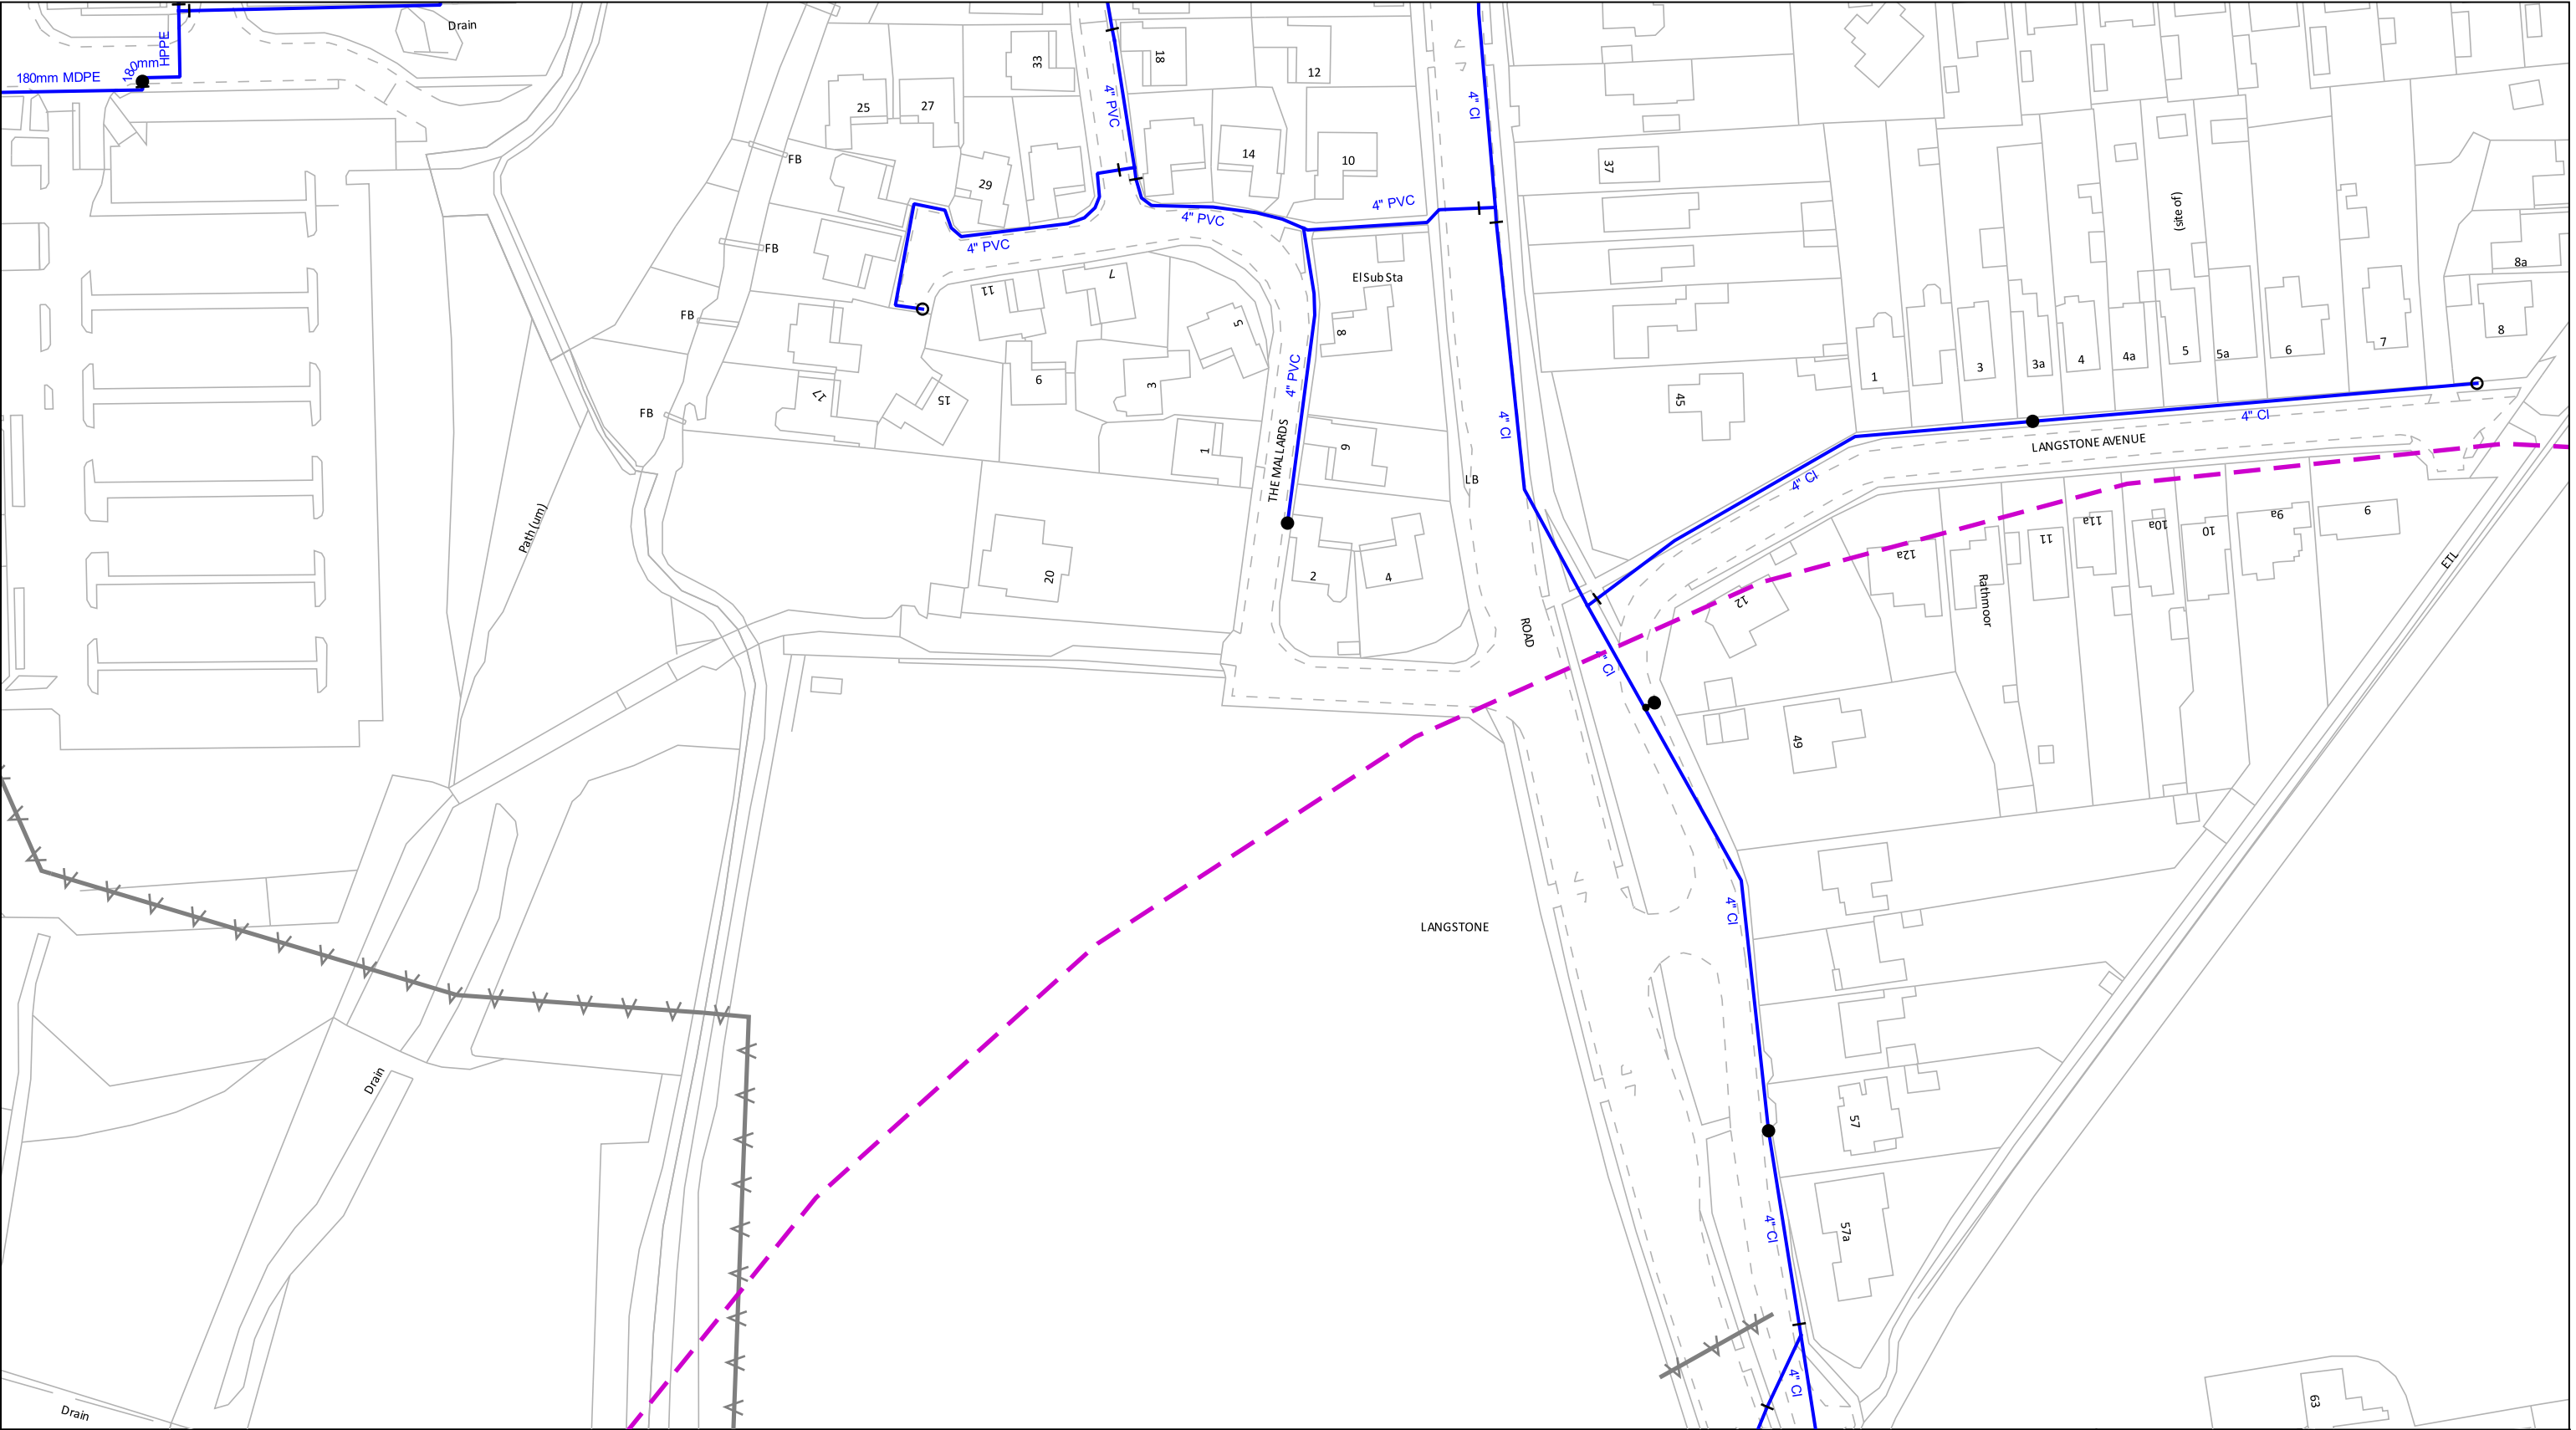

0100 m

Date Requested: 03/09/2021
Job Reference: 23169206
Site Location: 471818 104822
Requested by:
Miss Rebecca Dabbs

Your Scheme/Reference: 736036
Langstone Flood & Coastal

Scale: 1:1250 (When plotted at A3)

Distribution Mains

Communication Pipe

Fire Main

Private Mains

Raw Water Main

Trunk Main

Abandoned Mains

Cable

Company Washout Hydrant (Single)

Company Washout Hydrant (Offset)

Fire Brigade Hydrant (Single)

Fire Brigade Washout Hydrant

Fire Brigade Hydrant (Offset)

Reflux Valve

Air Valve

Open Valve

Closed Valve

Capped End

Stop Cock

Butterfly Valve

Pressure Flow Valve

Meter

New Appointments & Variations


Assets within shaded area please contact:
Leep Utilities
Email: water@leeputilities.co.uk
Tel: 0345 122 6780

The information supplied is given in good faith as a guide to locating underground apparatus. Its accuracy cannot be guaranteed, nor does it include comprehensive information about the existence or location of service pipes or cables to individual premises. The responsibility for locating and avoiding damage to apparatus on site shall be that of the person proposing to excavate in the street who shall be liable to the apparatus owner and any third party who may be affected in any way for any loss or damage caused by their failure to do so.

Registered Office
P.O. BOX NO. 8, West Street, Havant,
Hampshire. PO9 1LG.
Registered in England No. 2536455
Telephone: (023) 9249 9888
Fax: (023) 9245 3632
Website: www.portsmouthwater.co.uk

© Crown copyright and database rights 2020. Ordnance Survey Licence Number 100018036.
Warning: PDF designed for colour print only with no page scaling. This information is given as a guide only and its accuracy cannot be guaranteed
Plans generated by DigSAFE Pro™ software provided by LinesearchbeforeUdig.

(Page 1)

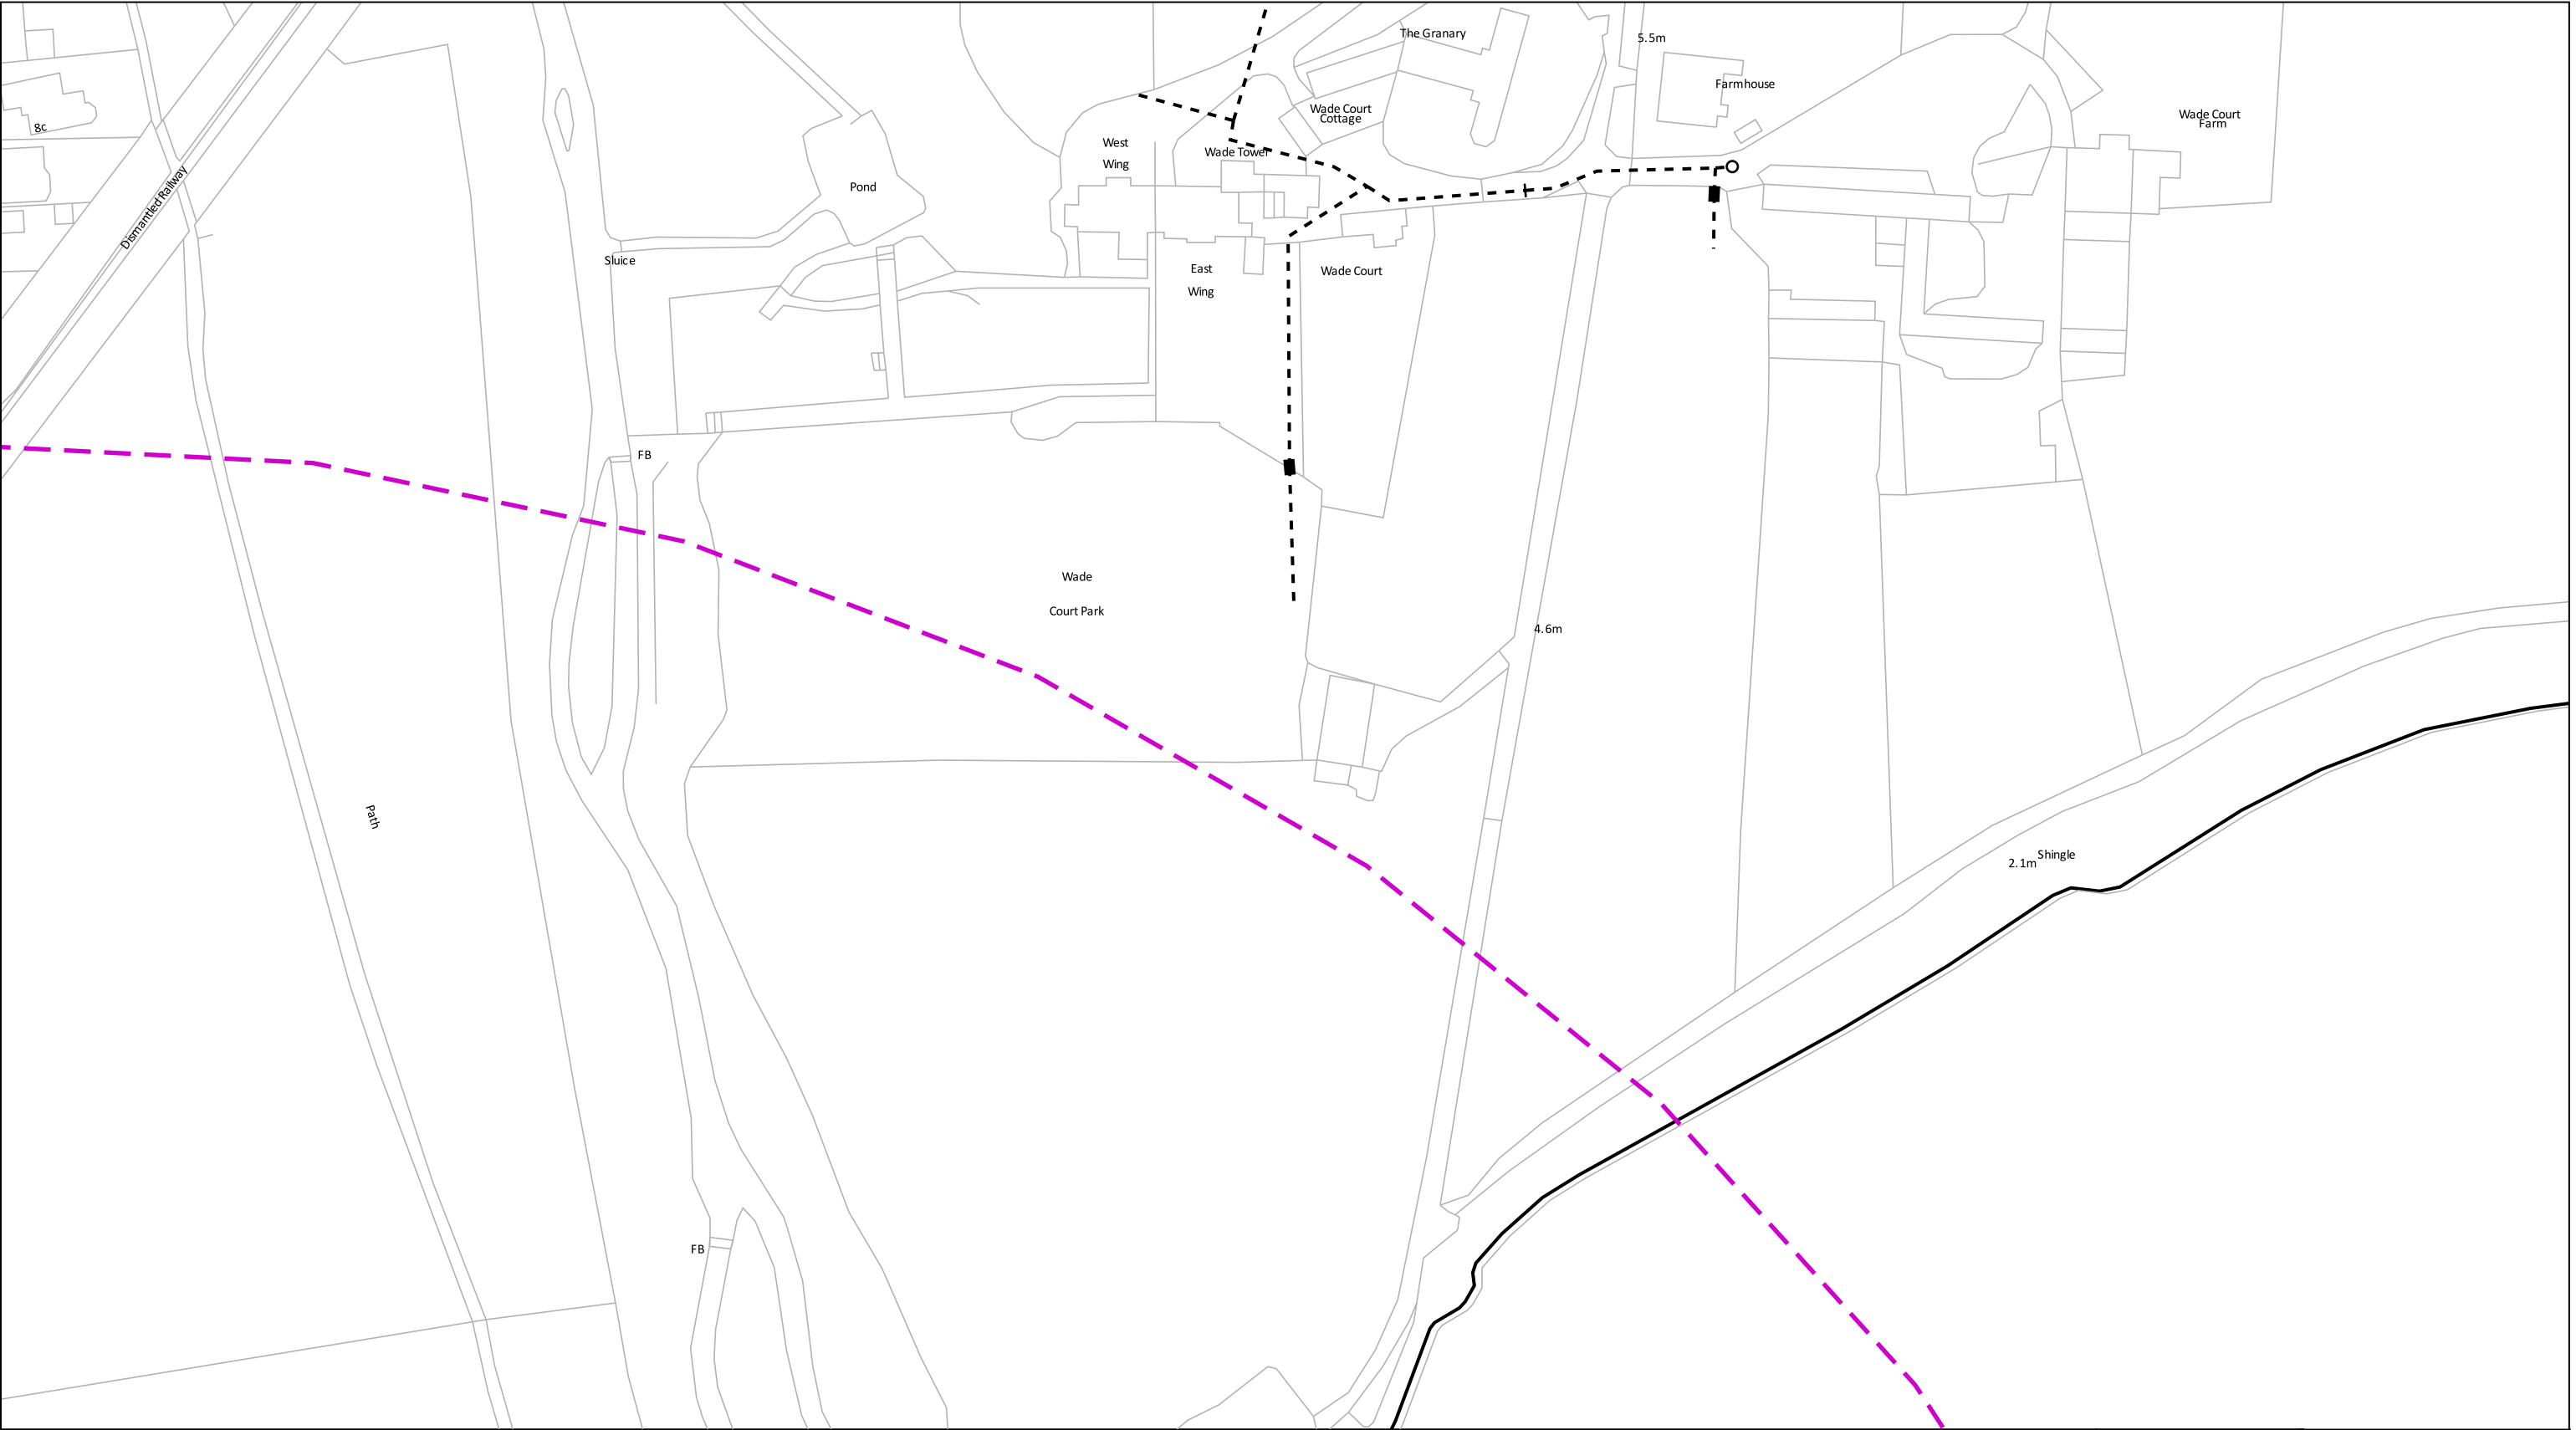

0100 m

Dig Sites

Area: ---- Line: ----

Measurements scaled from this plan may not match measurements between the same points on the ground.

Date Requested: 03/09/2021
Job Reference: 23169206
Site Location: 471818 104822
Requested by:
Miss Rebecca Dabbs

Your Scheme/Reference: 736036
Langstone Flood & Coastal

Distribution Mains

Communication Pipe

Fire Main

Private Mains

Raw Water Main

Trunk Main

Abandoned Mains

Cable

Company Washout Hydrant (Single)

Company Washout Hydrant (Offset)

Fire Brigade Hydrant (Single)

Fire Brigade Washout Hydrant

Fire Brigade Hydrant (Offset)

Reflux Valve

Air Valve

Open Valve

Closed Valve

Capped End

Stop Cock

Butterfly Valve

Pressure Flow Valve

Meter

New Appointments & Variations


Assets within shaded area please contact:
Leep Utilities
Email: water@leeputilities.co.uk
Tel: 0345 122 6780

The information supplied is given in good faith as a guide to locating underground apparatus. Its accuracy cannot be guaranteed, nor does it include comprehensive information about the existence or location of service pipes or cables to individual premises. The responsibility for locating and avoiding damage to apparatus on site shall be that of the person proposing to excavate in the street who shall be liable to the apparatus owner and any third party who may be affected in any way for any loss or damage caused by their failure to do so.

Registered Office
P.O. BOX NO. 8, West Street, Havant,
Hampshire. PO9 1LG.
Registered in England No. 2536455
Telephone: (023) 9249 9888
Fax: (023) 9245 3632
Website: www.portsmouthwater.co.uk

© Crown copyright and database rights 2020. Ordnance Survey Licence Number 100018036.
Warning: PDF designed for colour print only with no page scaling. This information is given as a guide only and its accuracy cannot be guaranteed
Plans generated by DigSAFE Pro™ software provided by LinesearchbeforeUdig.

(Page 2)

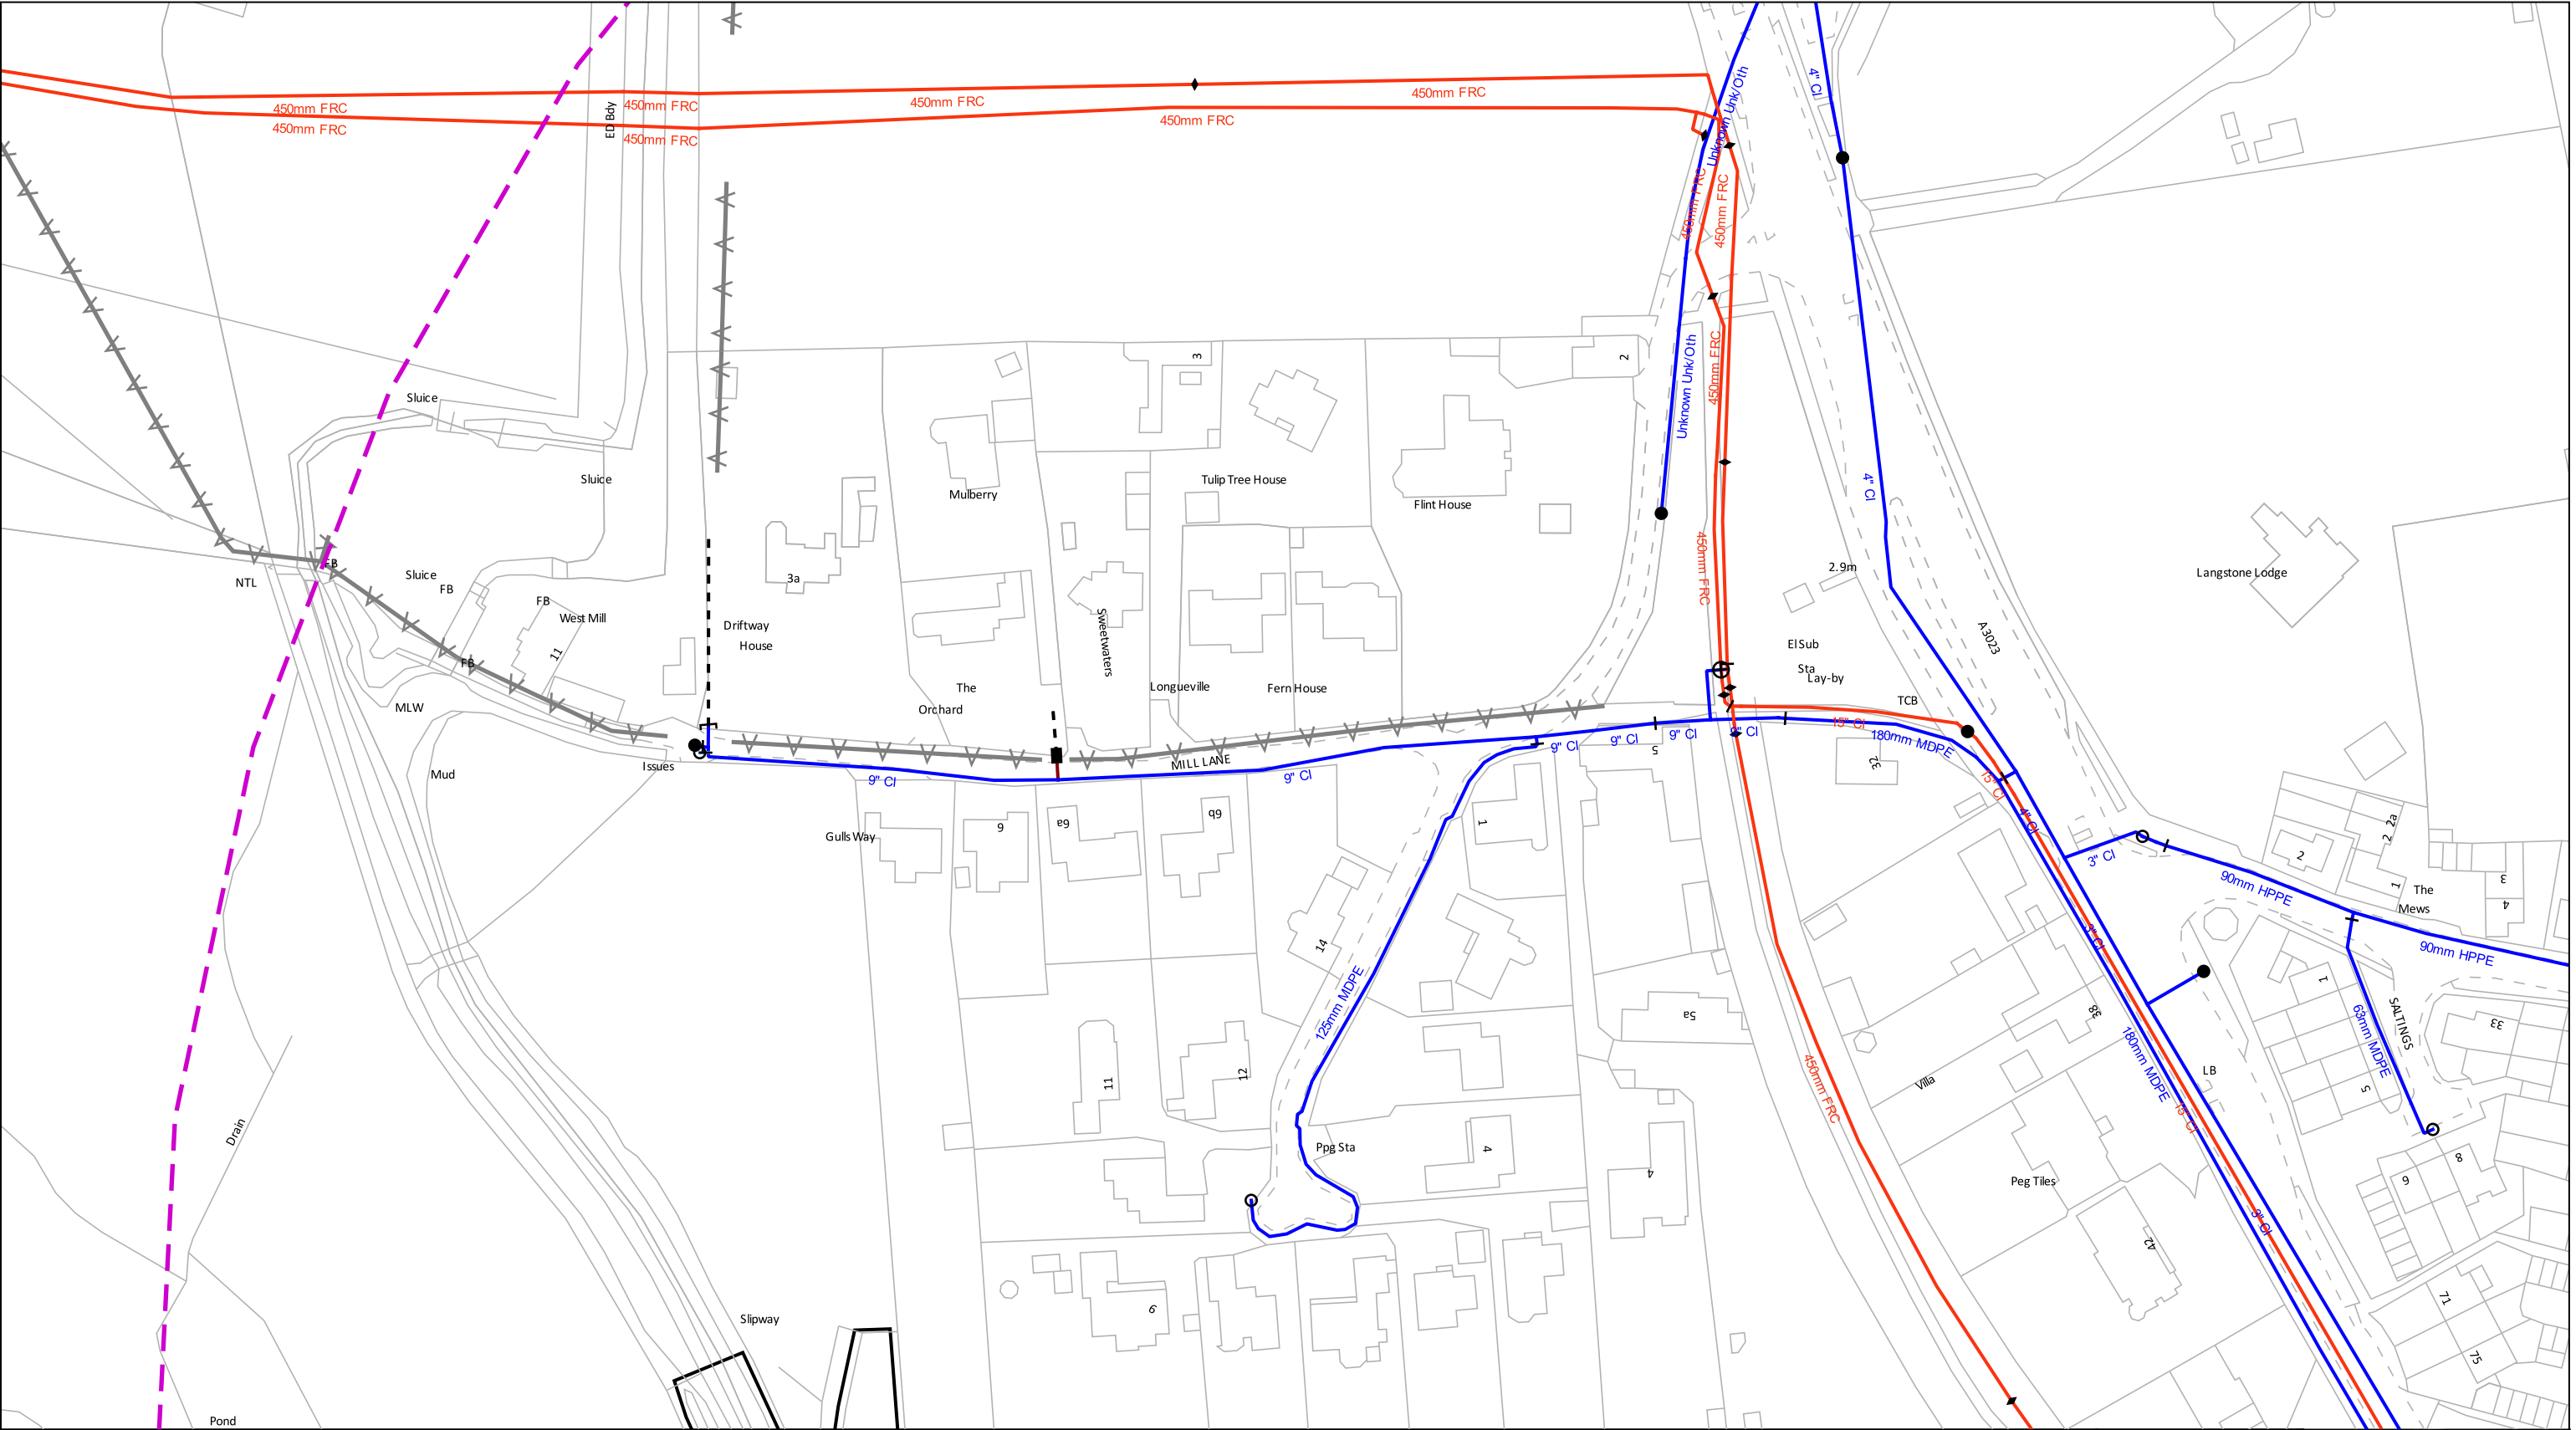

0100 m

Scale: 1:1250 (When plotted at A3)

Dig Sites

Area: Line:

Measurements scaled from this plan may not match measurements between the same points on the ground.

Date Requested: 03/09/2021

Job Reference: 23169206

Site Location: 471818 104822

Requested by:
Miss Rebecca Dabbs

Your Scheme/Reference: 736036

Langstone Flood & Coastal

Distribution Mains

Communication Pipe

Fire Main

Private Mains

Raw Water Main

Trunk Main

Abandoned Mains

Cable

Company Washout Hydrant (Single)

Company Washout Hydrant (Offset)

Fire Brigade Hydrant (Single)

Fire Brigade Washout Hydrant

Fire Brigade Hydrant (Offset)

Reflux Valve

Air Valve

Open Valve

Closed Valve

Capped End

Stop Cock

Butterfly Valve

Pressure Flow Valve

Meter

New Appointments & Variations

Assets within shaded area please contact:
Leep Utilities
Email: water@leeputilities.co.uk
Tel: 0345 122 6780


The information supplied is given in good faith as a guide to locating underground apparatus. Its accuracy cannot be guaranteed, nor does it include comprehensive information about the existence or location of service pipes or cables to individual premises. The responsibility for locating and avoiding damage to apparatus on site shall be that of the person proposing to excavate in the street who shall be liable to the apparatus owner and any third party who may be affected in any way for any loss or damage caused by their failure to do so.

Portsmouth Water

Registered Office
P.O. BOX NO. 8, West Street, Havant,
Hampshire. PO9 1LG.
Registered in England No. 2536455
Telephone: (023) 9249 9888
Fax: (023) 9245 3632
Website: www.portsmouthwater.co.uk

© Crown copyright and database rights 2020. Ordnance Survey Licence Number 100018036.
Warning: PDF designed for colour print only with no page scaling. This information is given as a guide only and its accuracy cannot be guaranteed
Plans generated by DigSAFE Pro™ software provided by LinesearchbeforeUdig.

(Page 3)

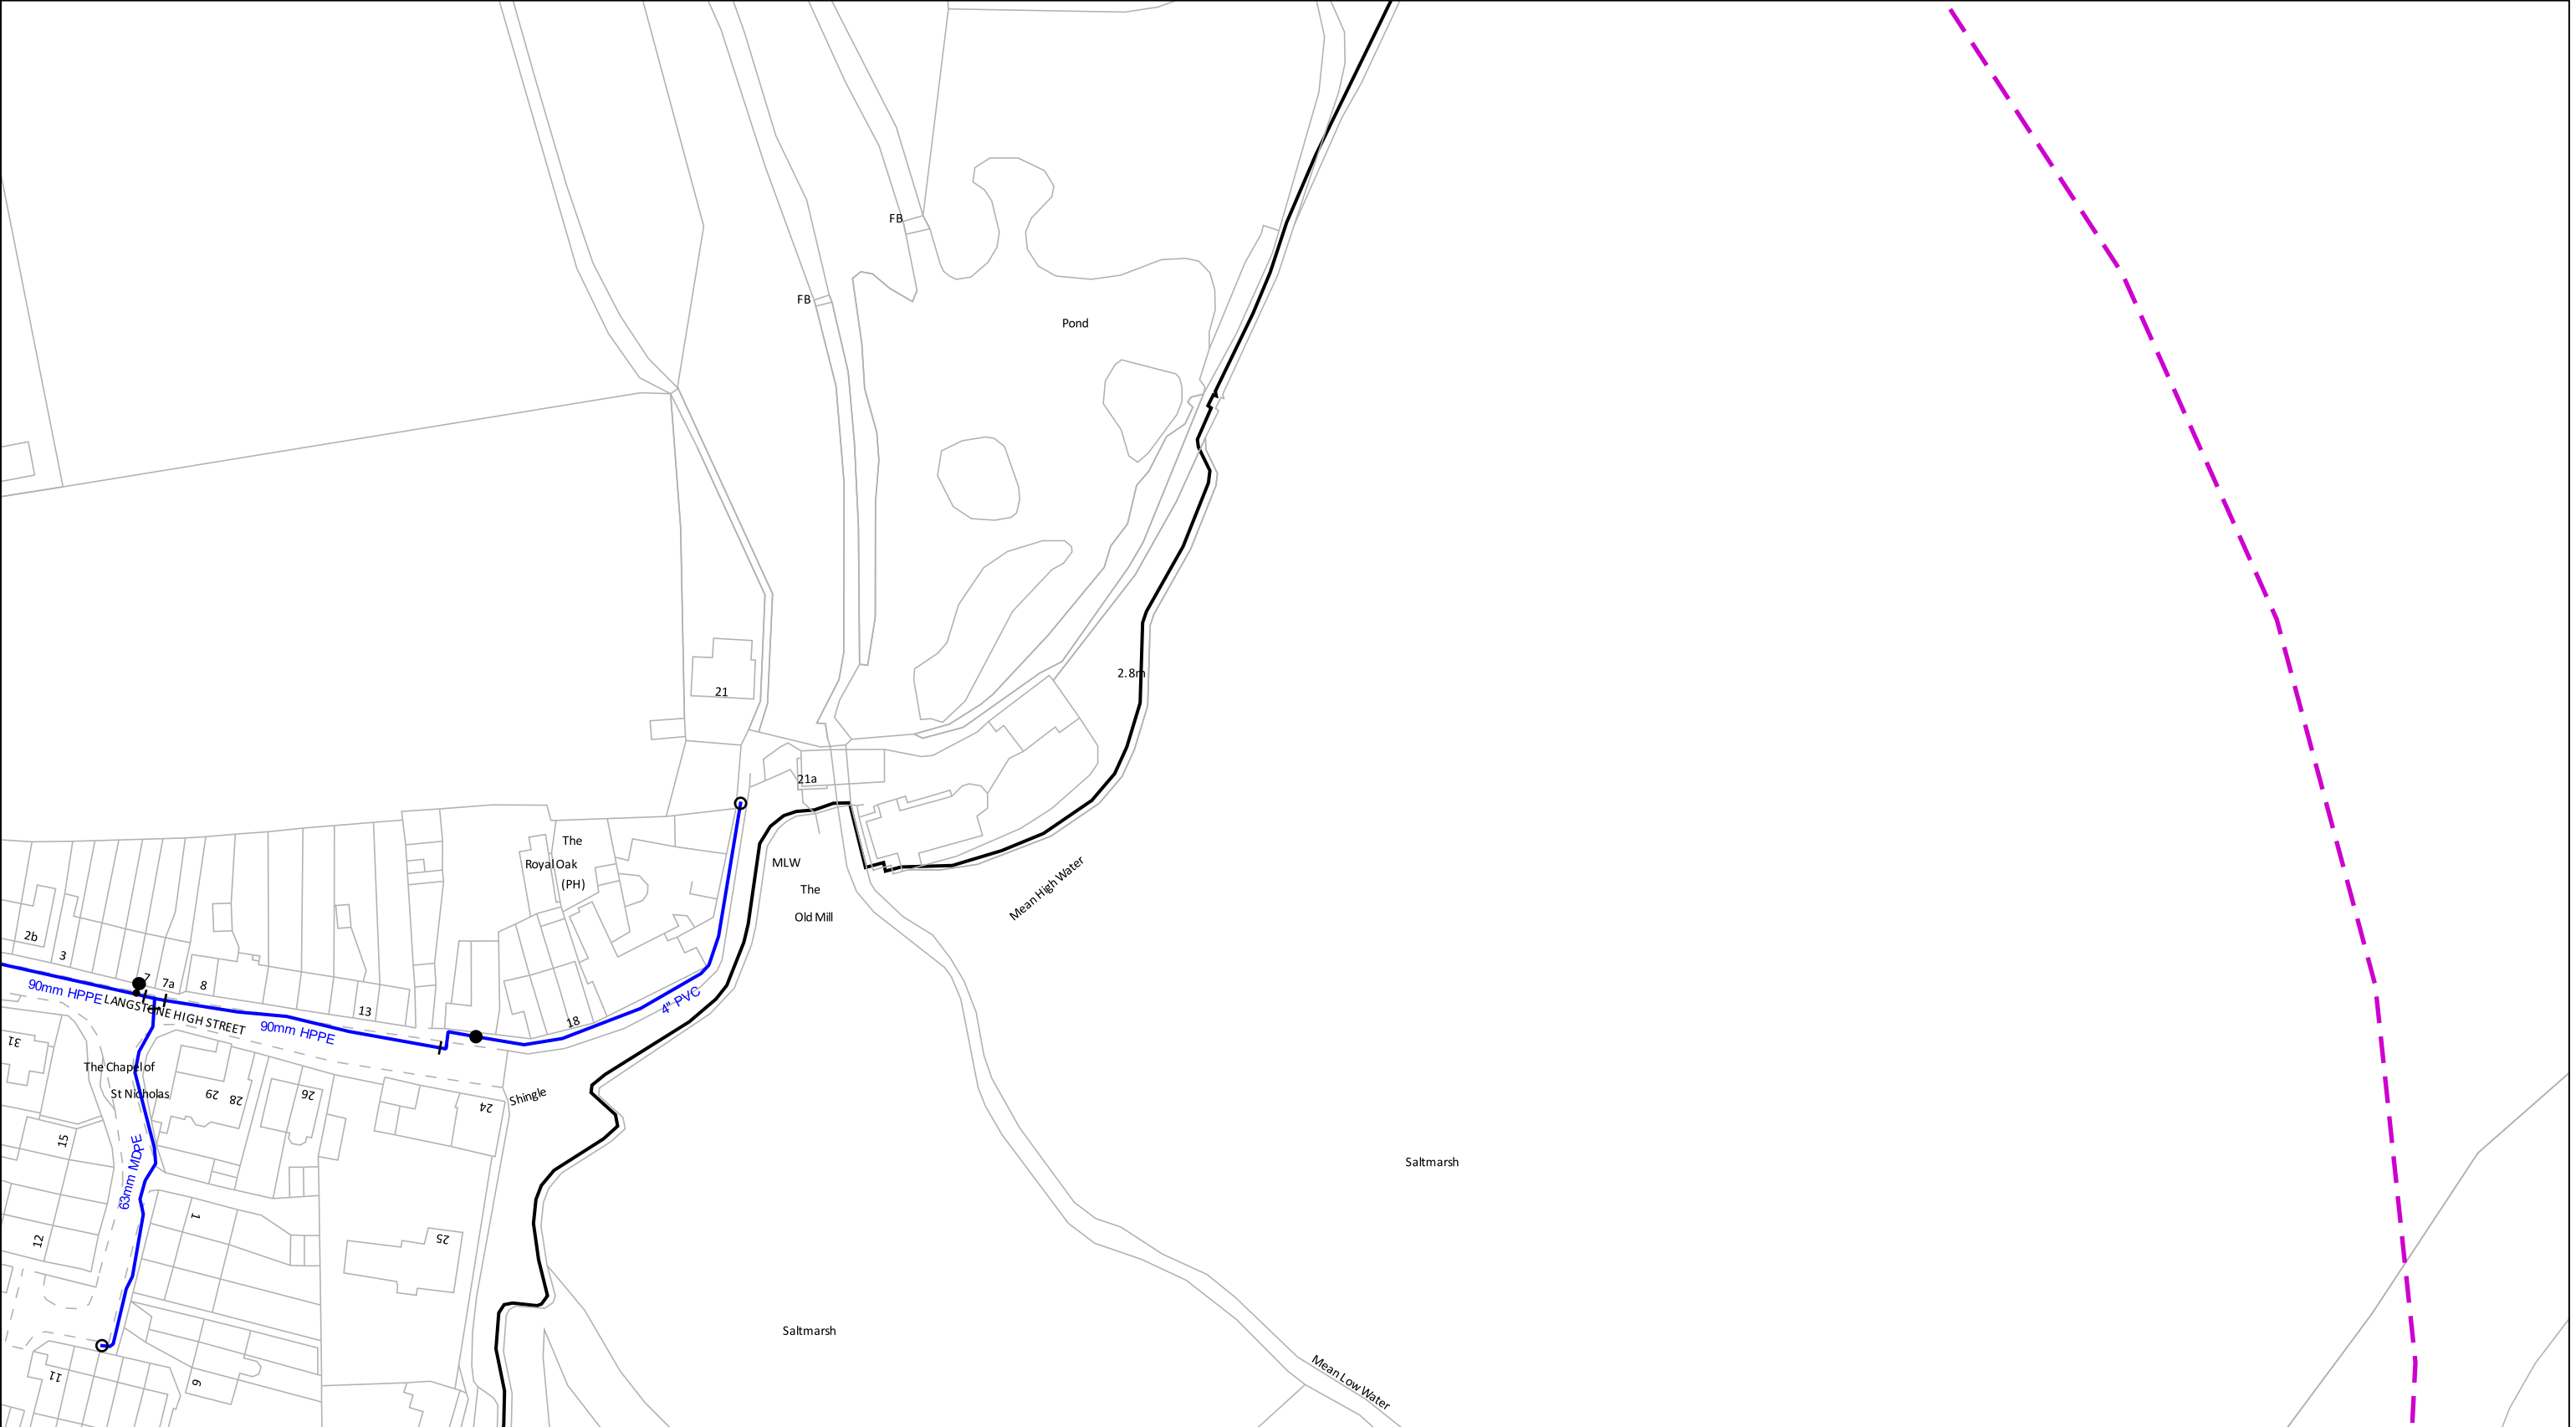

0100 m

Scale: 1:1250 (When plotted at A3)

Dig Sites

Area: Line:

Measurements scaled from this plan may not match measurements between the same points on the ground.

Distribution Mains

Communication Pipe

Fire Main

Private Mains

Raw Water Main

Trunk Main

Abandoned Mains

Cable

Company Washout Hydrant (Single)

Company Washout Hydrant (Offset)

Fire Brigade Hydrant (Single)

Fire Brigade Washout Hydrant

Fire Brigade Hydrant (Offset)

Reflex Valve

Air Valve

Open Valve

Closed Valve

Capped End

Stop Cock

Butterfly Valve

Pressure Flow Valve

Meter

New Appointments & Variations

Assets within shaded area please contact:
Leep Utilities
Email: water@leeputilities.co.uk
Tel: 0345 122 6780

Registered Office
P.O. BOX NO. 8, West Street, Havant,
Hampshire. PO9 1LG.
Registered in England No. 2536455
Telephone: (023) 9249 9888
Fax: (023) 9245 3632
Website: www.portsmouthwater.co.uk

Date Requested: 03/09/2021
Job Reference: 23169206
Site Location: 471818 104822
Requested by:
Miss Rebecca Dabbs

Your Scheme/Reference: 736036
Langstone Flood & Coastal

The information supplied is given in good faith as a guide to locating underground apparatus. Its accuracy cannot be guaranteed, nor does it include comprehensive information about the existence or location of service pipes or cables to individual premises. The responsibility for locating and avoiding damage to apparatus on site shall be that of the person proposing to excavate in the street who shall be liable to the apparatus owner and any third party who may be affected in any way for any loss or damage caused by their failure to do so.

© Crown copyright and database rights 2020. Ordnance Survey Licence Number 100018036.
Warning: PDF designed for colour print only with no page scaling. This Information is given as a guide only and its accuracy cannot be guaranteed
Plans generated by DigSAFE Pro™ software provided by LinesearchbeforeUdig.

(Page 4)



0100 m

Dig Sites

Area: Line:

Measurements scaled from this plan may not match measurements between the same points on the ground.

Date Requested: 03/09/2021

Job Reference: 23169206

Site Location: 471818 104822

Requested by:
Miss Rebecca Dabbs

Your Scheme/Reference: 736036

Langstone Flood & Coastal

Distribution Mains

Communication Pipe

Fire Main

Private Mains

Raw Water Main

Trunk Main

Abandoned Mains

Cable

Company Washout Hydrant (Single)

Company Washout Hydrant (Offset)

Fire Brigade Hydrant (Single)

Fire Brigade Washout Hydrant

Fire Brigade Hydrant (Offset)

Reflux Valve

Air Valve

Open Valve

Closed Valve

Capped End

Stop Cock

Butterfly Valve

Pressure Flow Valve

Meter

New Appointments & Variations


Assets within shaded area please contact:
Leep Utilities
Email: water@leeputilities.co.uk
Tel: 0345 122 6780

The information supplied is given in good faith as a guide to locating underground apparatus. Its accuracy cannot be guaranteed, nor does it include comprehensive information about the existence or location of service pipes or cables to individual premises. The responsibility for locating and avoiding damage to apparatus on site shall be that of the person proposing to excavate in the street who shall be liable to the apparatus owner and any third party who may be affected in any way for any loss or damage caused by their failure to do so.

Registered Office
P.O. BOX NO. 8, West Street, Havant,
Hampshire. PO9 1LG.
Registered in England No. 2536455
Telephone: (023) 9249 9888
Fax: (023) 9245 3632
Website: www.portsmouthwater.co.uk

© Crown copyright and database rights 2020. Ordnance Survey Licence Number 100018036.
Warning: PDF designed for colour print only with no page scaling. This Information is given as a guide only and its accuracy cannot be guaranteed
Plans generated by DigSAFE Pro™ software provided by LinesearchbeforeUdig.

(Page 5)

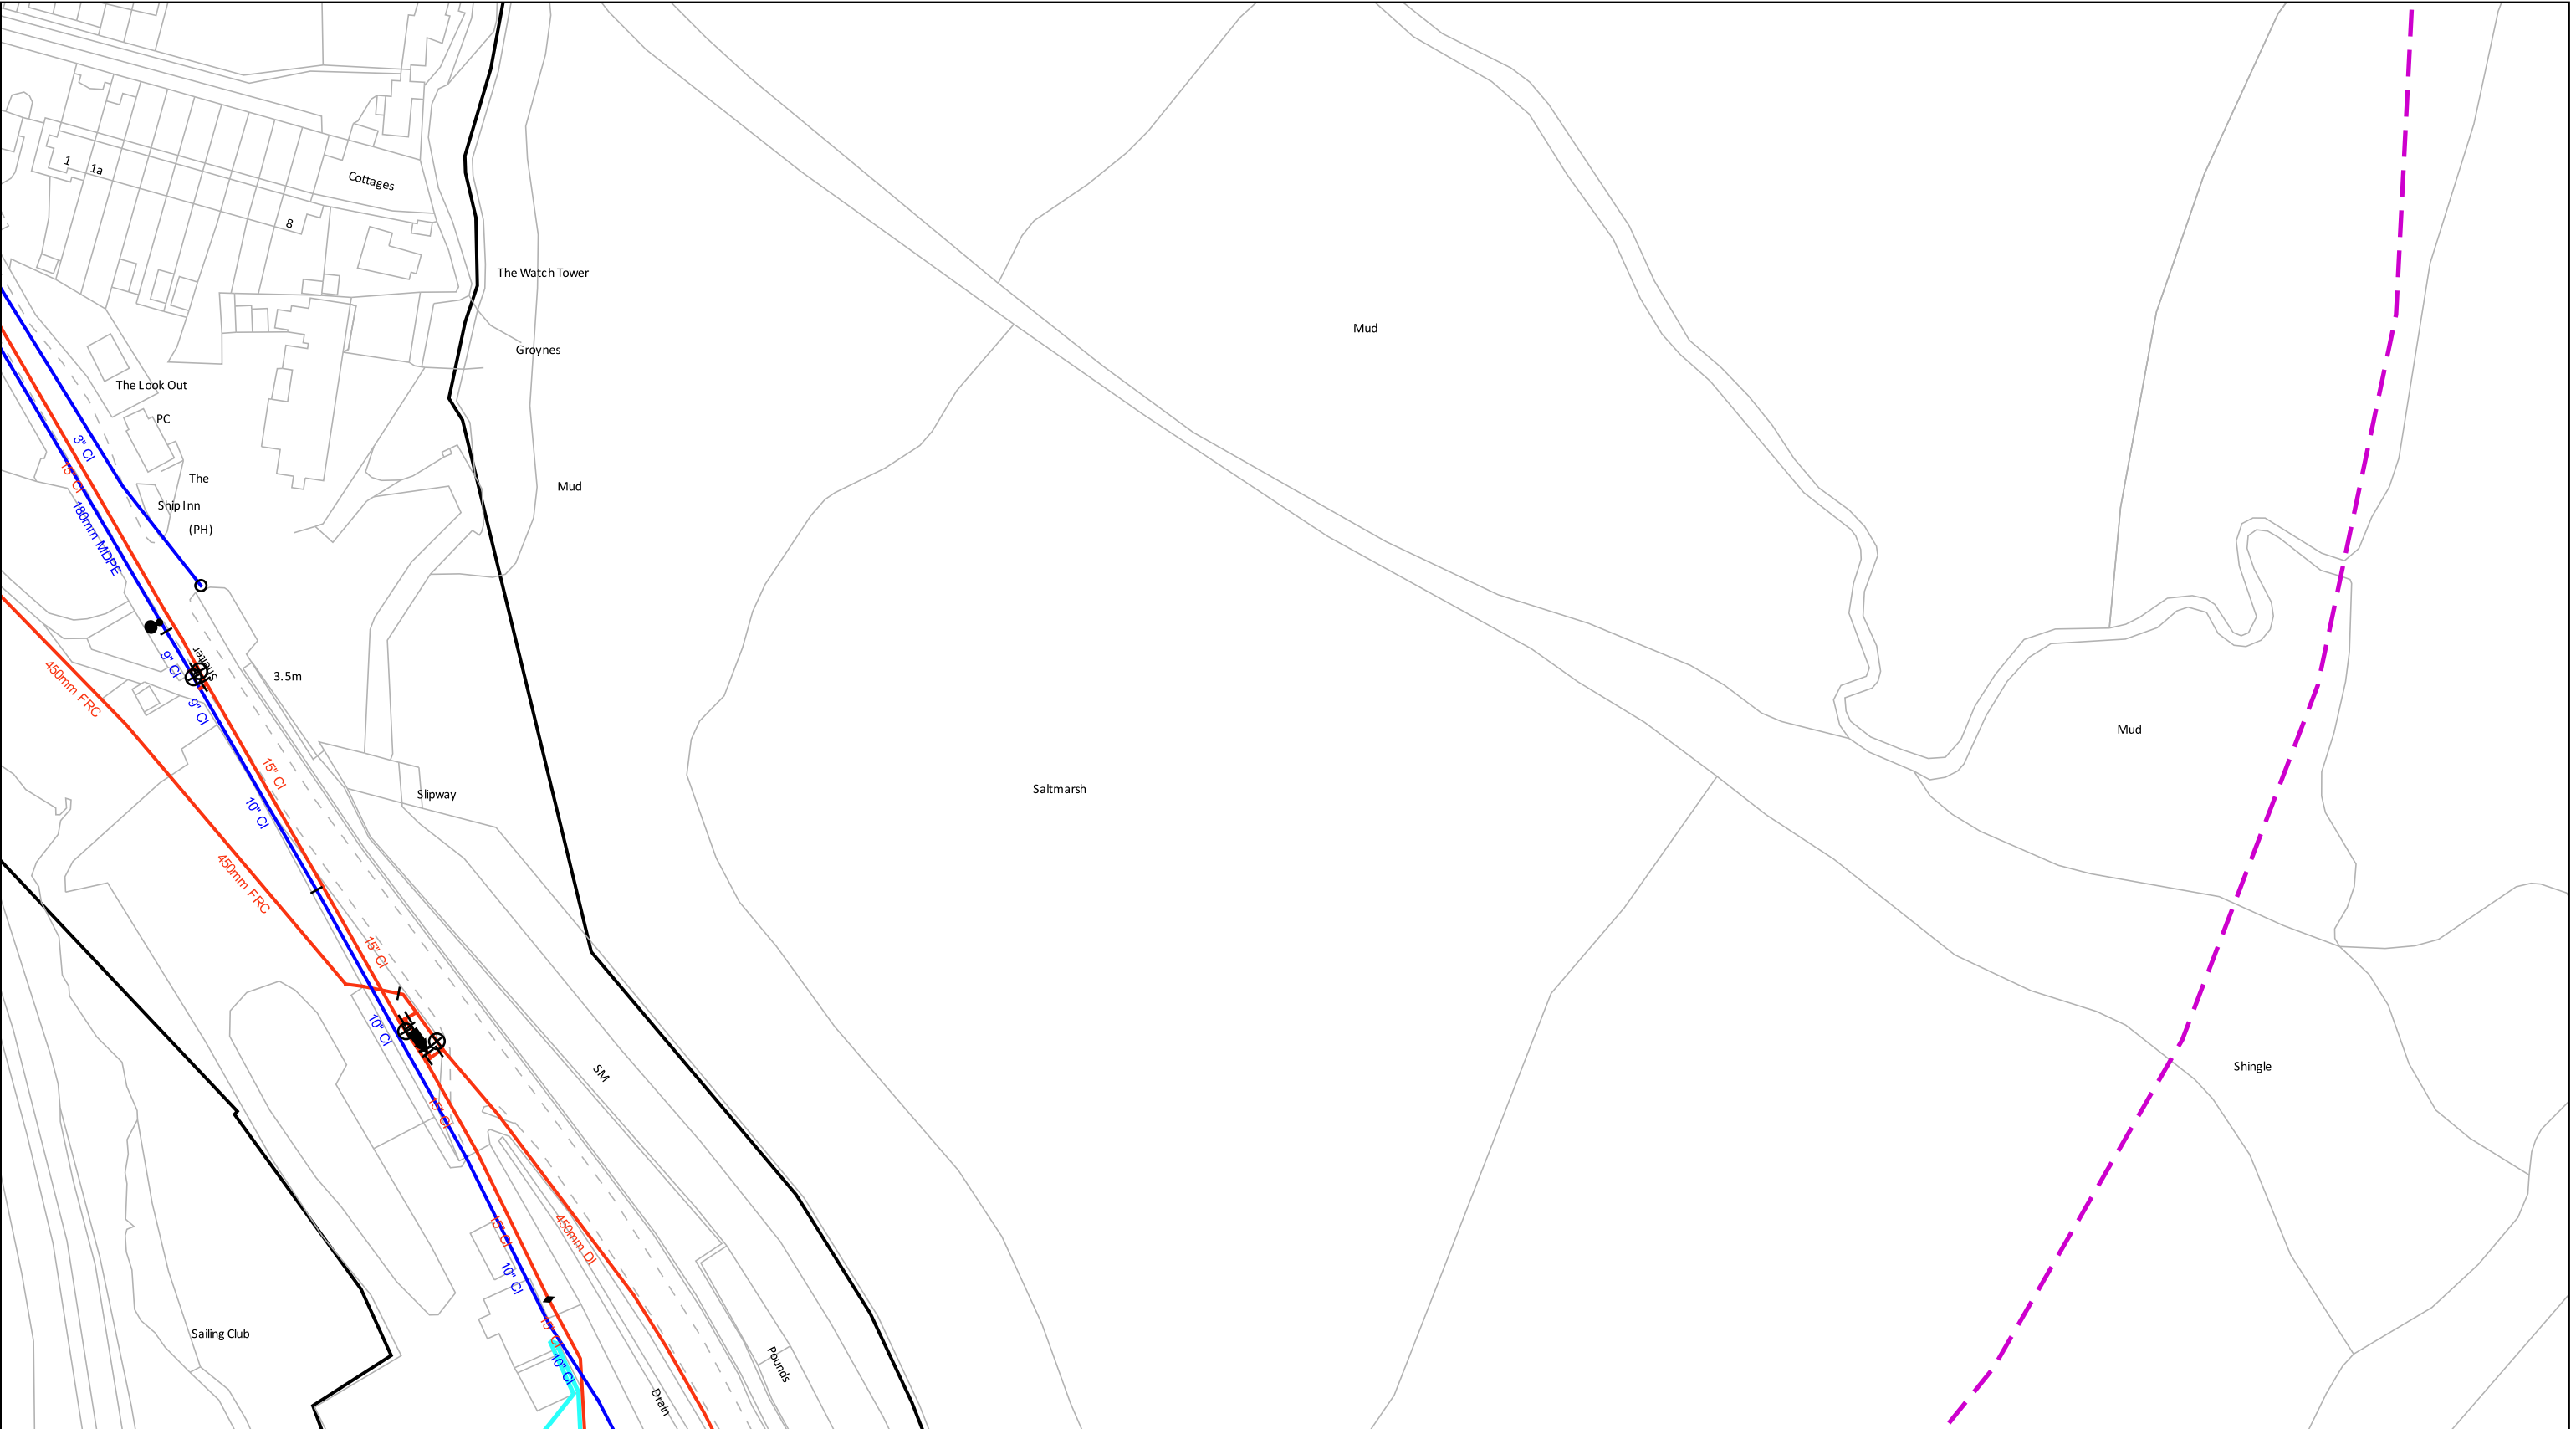

0100 m

Date Requested: 03/09/2021

Job Reference: 23169206

Site Location: 471818 104822

Requested by:
Miss Rebecca Dabbs

Your Scheme/Reference: 736036

Langstone Flood & Coastal

Scale: 1:1250 (When plotted at A3)

Distribution Mains

Communication Pipe

Fire Main

Private Mains

Raw Water Main

Trunk Main

Abandoned Mains

Cable

Company Washout Hydrant (Single)

Company Washout Hydrant (Offset)

Fire Brigade Hydrant (Single)

Fire Brigade Washout Hydrant

Fire Brigade Hydrant (Offset)

Reflux Valve

Air Valve

Open Valve

Closed Valve

Capped End

Stop Cock

Butterfly Valve

Pressure Flow Valve


Meter

New Appointments & Variations

Assets within shaded area please contact:
Leep Utilities
Email: water@leeputilities.co.uk
Tel: 0345 122 6780

The information supplied is given in good faith as a guide to locating underground apparatus. Its accuracy cannot be guaranteed, nor does it include comprehensive information about the existence or location of service pipes or cables to individual premises. The responsibility for locating and avoiding damage to apparatus on site shall be that of the person proposing to excavate in the street who shall be liable to the apparatus owner and any third party who may be affected in any way for any loss or damage caused by their failure to do so.

Measurements scaled from this plan may not match measurements between the same points on the ground.

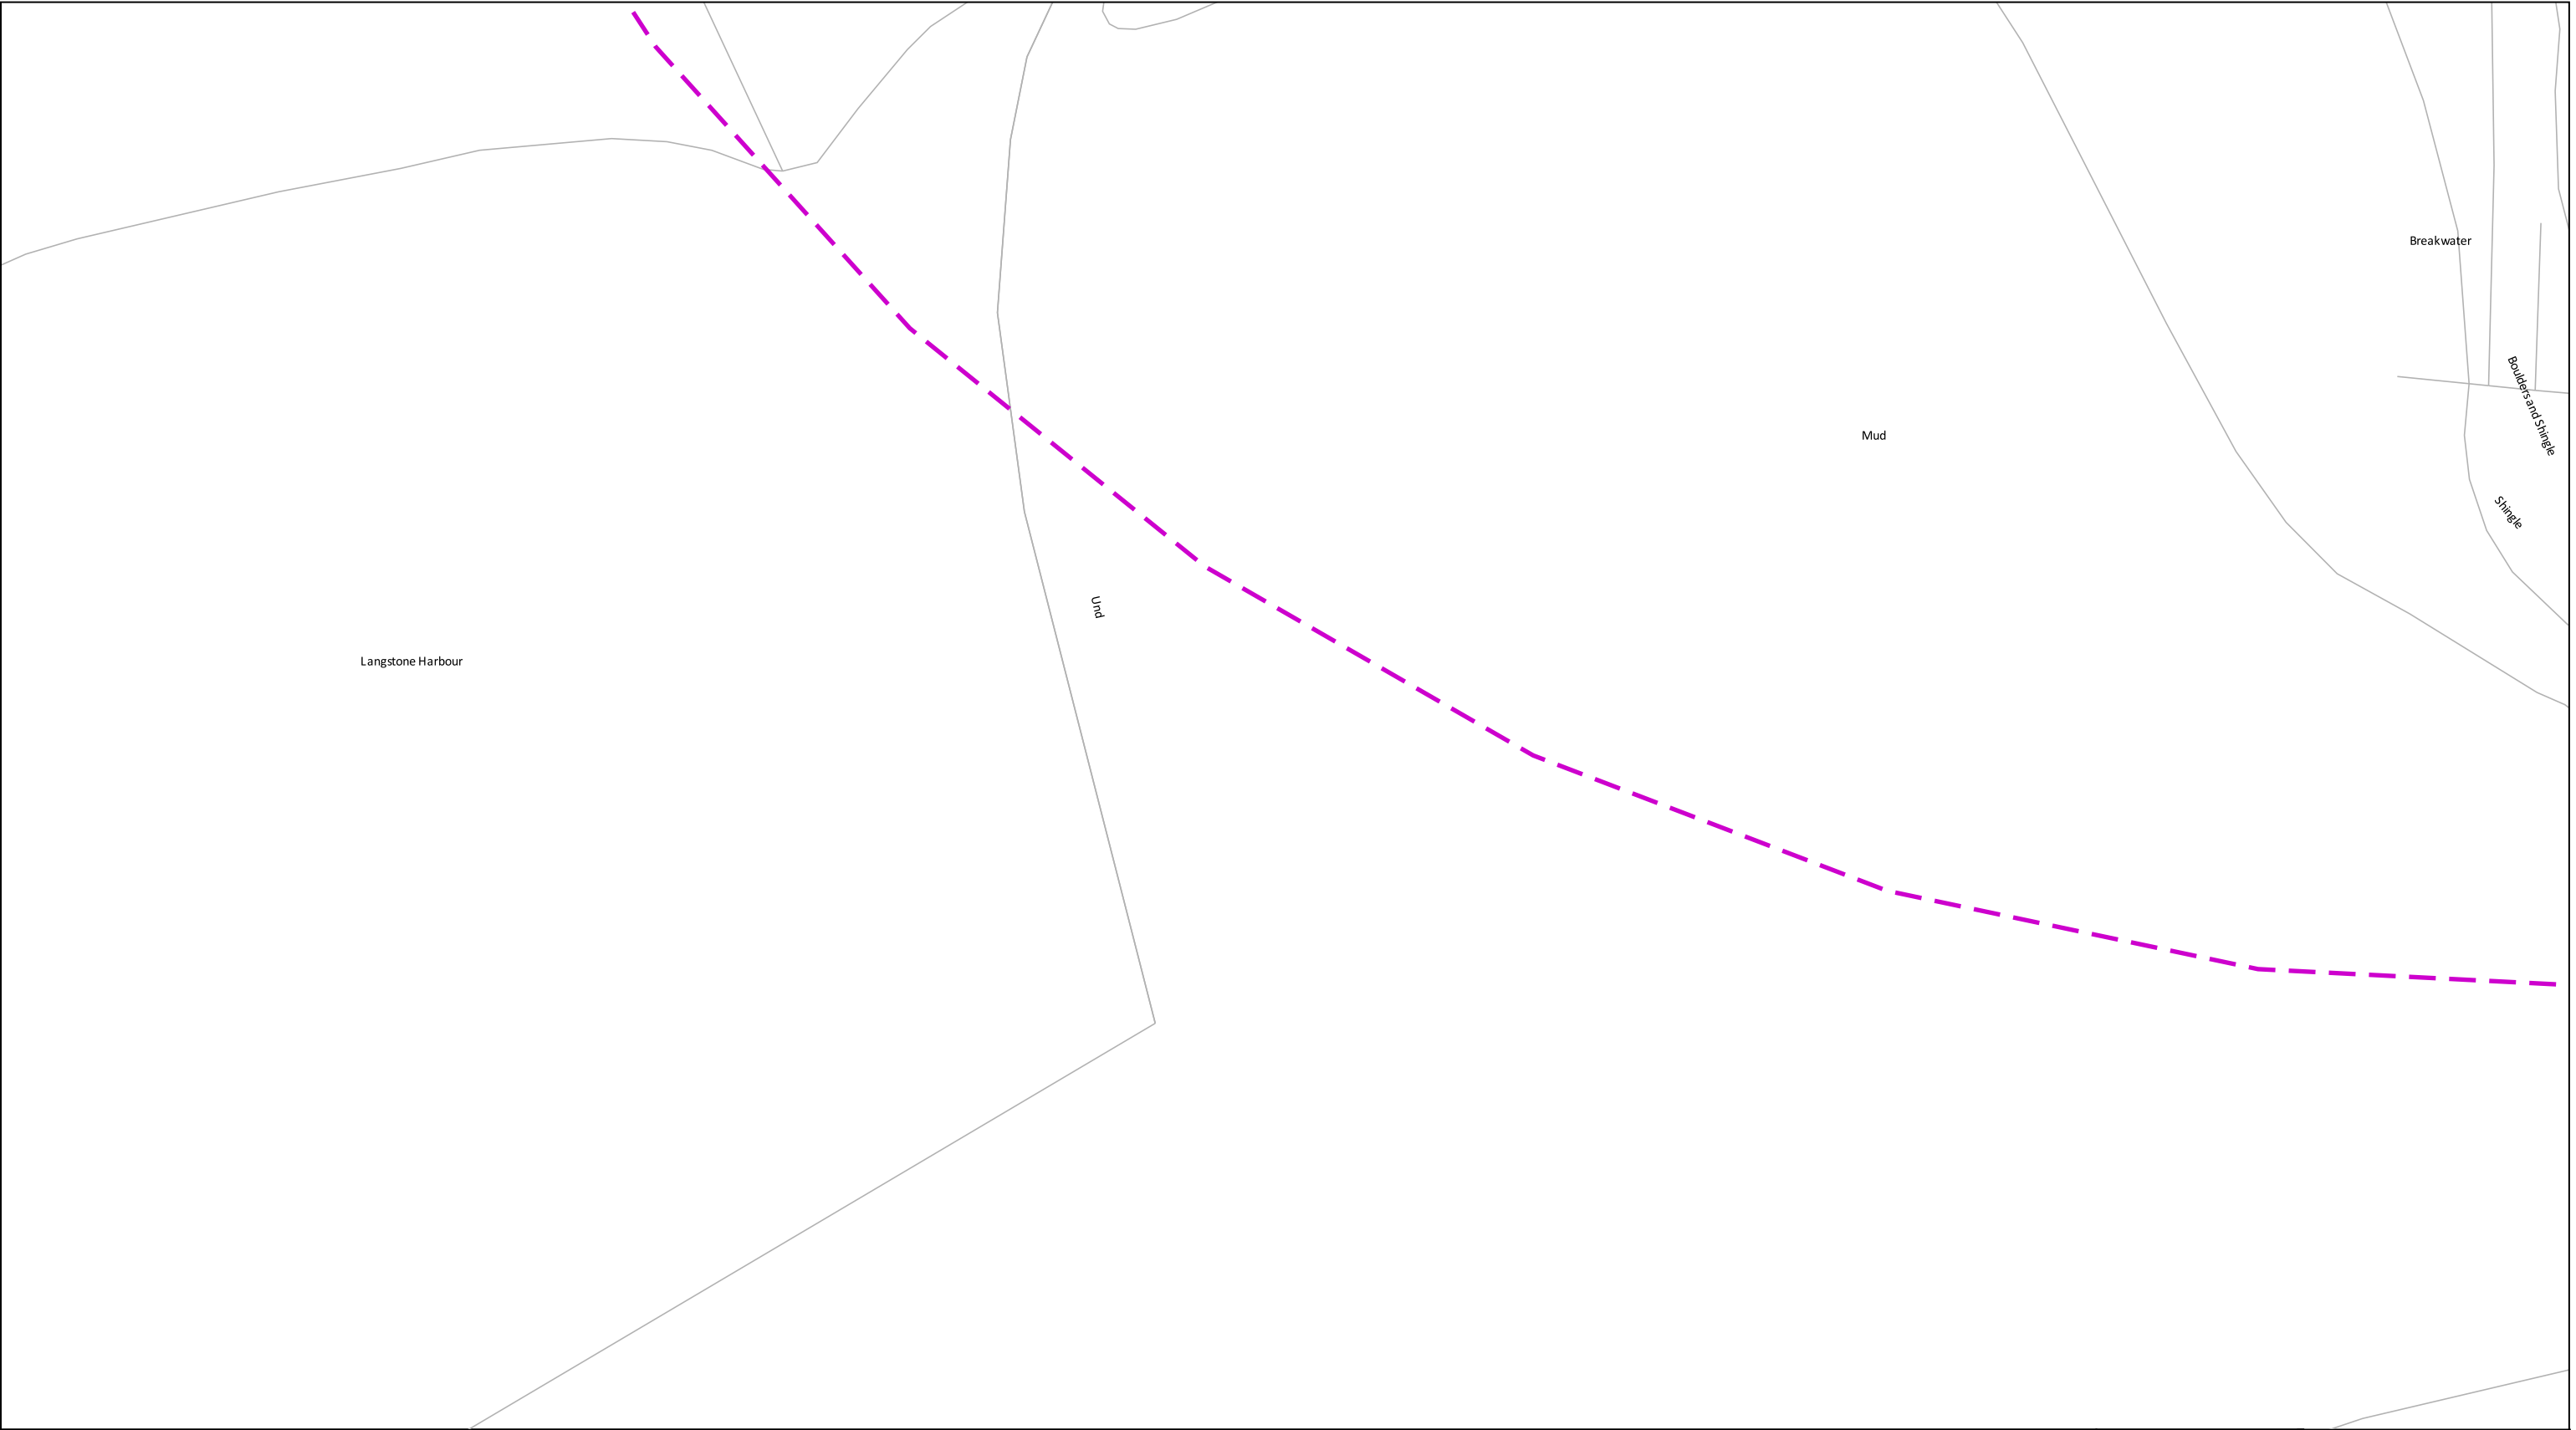

0100 m

Dig Sites

Area: Line:

Measurements scaled from this plan may not match measurements between the same points on the ground.

Date Requested: 03/09/2021

Job Reference: 23169206

Site Location: 471818 104822

Requested by:
Miss Rebecca Dabbs

Your Scheme/Reference: 736036

Langstone Flood & Coastal

Distribution Mains

Communication Pipe

Fire Main

Private Mains

Raw Water Main

Trunk Main

Abandoned Mains

Cable

Company Washout Hydrant (Single)

Company Washout Hydrant (Offset)

Fire Brigade Hydrant (Single)

Fire Brigade Washout Hydrant

Fire Brigade Hydrant (Offset)

Reflux Valve

Air Valve

Open Valve

Closed Valve

Capped End

Stop Cock

Butterfly Valve

Pressure Flow Valve

Meter

New Appointments & Variations

Assets within shaded area please contact:
Leep Utilities
Email: water@leeputilities.co.uk
Tel: 0345 122 6780

Registered Office

P.O. BOX NO. 8, West Street, Havant,
Hampshire. PO9 1LG.

Registered in England No. 2536455

Telephone: (023) 9249 9888

Fax: (023) 9245 3632

Website: www.portsmouthwater.co.uk

Scale: 1:1250 (When plotted at A3)


The information supplied is given in good faith as a guide to locating underground apparatus. Its accuracy cannot be guaranteed, nor does it include comprehensive information about the existence or location of service pipes or cables to individual premises. The responsibility for locating and avoiding damage to apparatus on site shall be that of the person proposing to excavate in the street who shall be liable to the apparatus owner and any third party who may be affected in any way for any loss or damage caused by their failure to do so.

© Crown copyright and database rights 2020. Ordnance Survey Licence Number 100018036.

Warning: PDF designed for colour print only with no page scaling. This Information is given as a guide only and its accuracy cannot be guaranteed

Plans generated by DigSAFE Pro™ software provided by LinesearchbeforeUdig.

(Page 7)

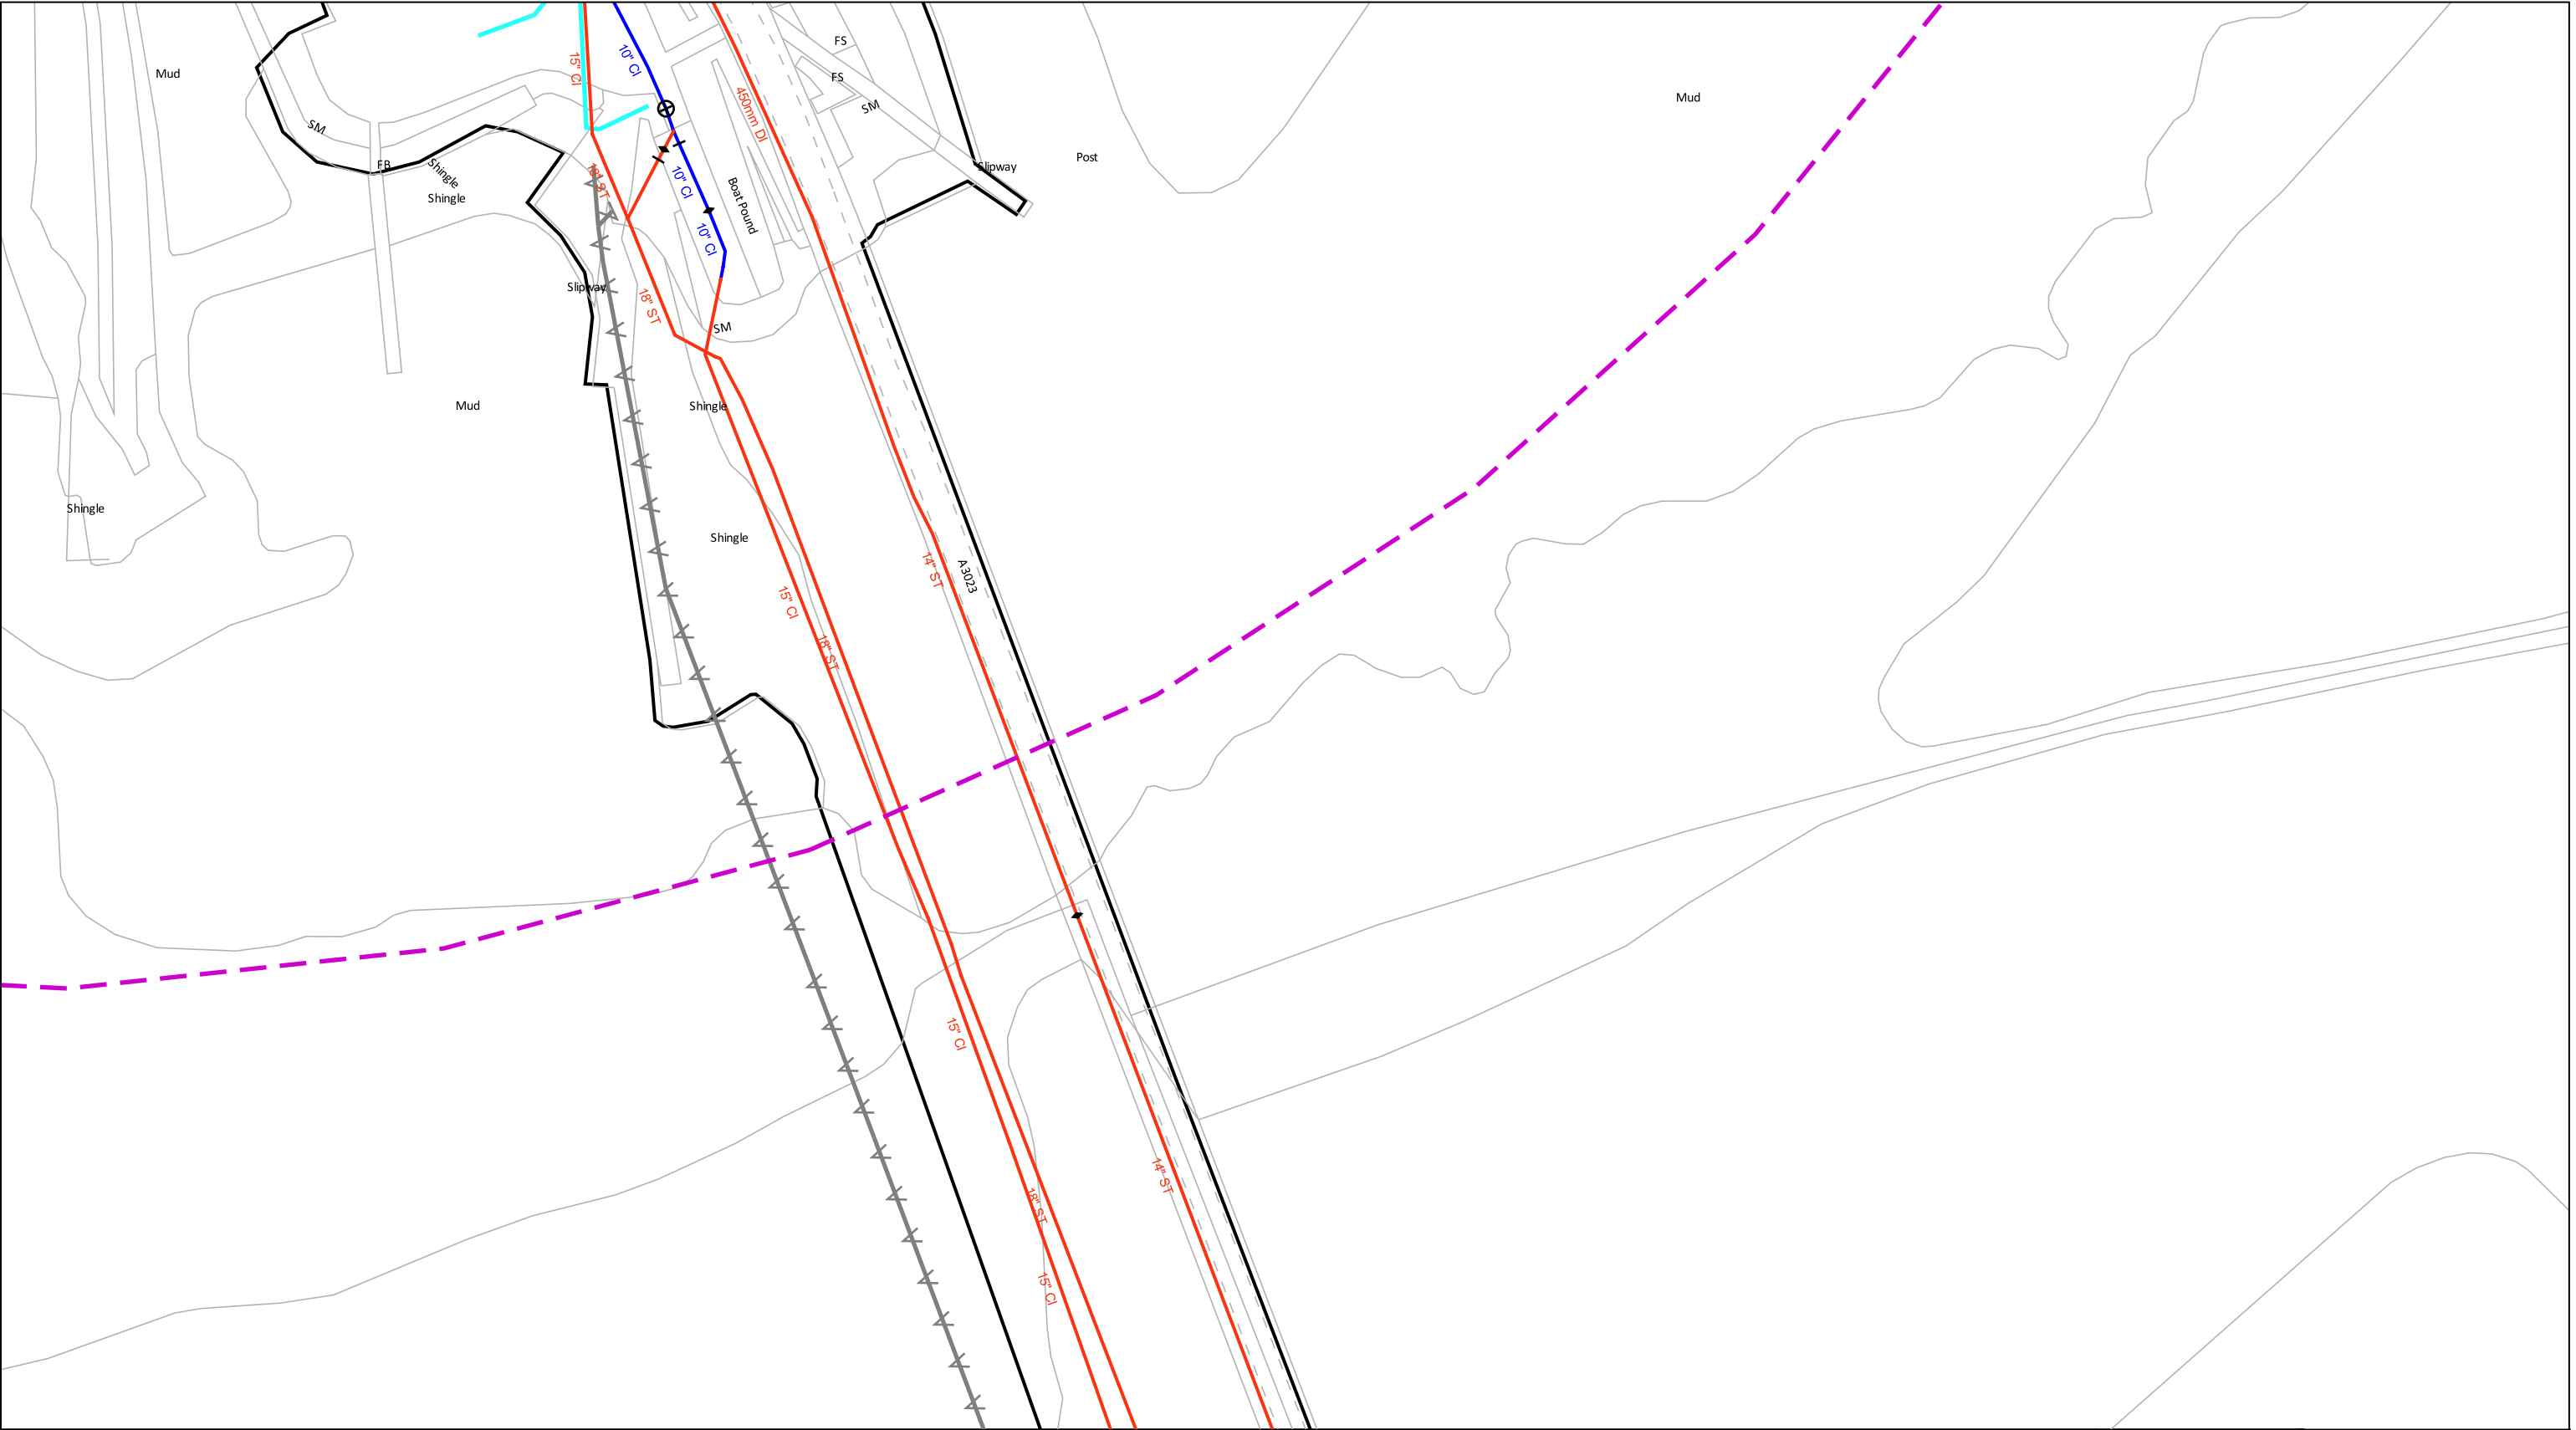

0100 m

Dig Sites

Area: Line:

Measurements scaled from this plan may not match measurements between the same points on the ground.

Date Requested: 03/09/2021

Job Reference: 23169206

Site Location: 471818 104822

Requested by:
Miss Rebecca Dabbs

Your Scheme/Reference: 736036

Langstone Flood & Coastal

Distribution Mains

Communication Pipe

Fire Main

Private Mains

Raw Water Main

Trunk Main

Abandoned Mains

Cable

Company Washout Hydrant (Single)

Company Washout Hydrant (Offset)

Fire Brigade Hydrant (Single)

Fire Brigade Washout Hydrant

Fire Brigade Hydrant (Offset)

Reflex Valve

Air Valve

Open Valve

Closed Valve

Capped End

Stop Cock

Butterfly Valve

Pressure Flow Valve

Meter

New Appointments & Variations

Assets within shaded area please contact:
Leep Utilities
Email: water@leeputilities.co.uk
Tel: 0345 122 6780

The information supplied is given in good faith as a guide to locating underground apparatus. Its accuracy cannot be guaranteed, nor does it include comprehensive information about the existence or location of service pipes or cables to individual premises. The responsibility for locating and avoiding damage to apparatus on site shall be that of the person proposing to excavate in the street who shall be liable to the apparatus owner and any third party who may be affected in any way for any loss or damage caused by their failure to do so.

Registered Office

P.O. BOX NO. 8, West Street, Havant,

Hampshire. PO9 1LG.

Registered in England No. 2536455

Telephone: (023) 9249 9888

Fax: (023) 9245 3632

Website: www.portsmouthwater.co.uk

Scale: 1:1250 (When plotted at A3)

© Crown copyright and database rights 2020. Ordnance Survey Licence Number 100018036.
Warning: PDF designed for colour print only with no page scaling. This Information is given as a guide only and its accuracy cannot be guaranteed
Plans generated by DigSAFE Pro™ software provided by LinesearchbeforeUdig.

(Page 8)



High Pressure Gas Pipes within this vicinity



SGN
Your gas. Our network.

Contact Us

Mapping Enquiries:
All areas

General Enquiries:
All areas

Date Requested: 03/09/2021
Job Reference: 23169206
Site Location: 471818 104822
Requested by:
Miss Rebecca Dabbs
Your Scheme/Reference:
736036 Langstone Flood & Coastal

This plan shows the location of those pipes owned by Scotia Gas Networks (SGN) by virtue of being a licensed Gas Transporter (GT). Gas pipes owned by other GTs or third parties may also be present in this area but are not shown on this plan. Information with regard to such pipes should be obtained from the relevant owners. No warranties are given with regard to the accuracy of the information shown on this plan. Service pipes, valves, siphons, sub-connections etc. are not shown but their presence should be anticipated. You should be aware that a small percentage of our pipes/assets may be undergoing review and will temporarily be highlighted in yellow. If your proposed works are close to one of these pipes, you should contact the SGN Safety Admin Team on 0800 912 1722 for advice. No liability of any kind whatsoever is accepted by SGN or its agents, servants or sub-contractors for any error or omission contained herein. Safe digging practices, in accordance with HS (G)47, must be used to verify and establish the actual position of mains, pipes, services and other apparatus on site before any mechanical plant is used. It is your responsibility to ensure that plant location information is provided to all persons (whether direct labour or sub-contractors) working for you on or near gas apparatus. Information included on this plan should not be referred to beyond a period of 28 days from the date of issue.

Report damage immediately – KEEP EVERYONE AWAY FROM THE AREA
0800 111 999

Low Pressure Mains

Medium Pressure Mains

Intermediate Pressure Mains

High Pressure Mains

LAs

GTs



SSSIs



Some Examples Of Plant Items

Valve



Syphon



Depth of Cover



Diameter Change



Material Change



Digsite:

Line:




Area:



This plan is reproduced from or based on the OS map by Scotia Gas Networks plc, with the sanction of the controller of HM Stationery Office. Crown Copyright Reserved. Southern Gas – 100044373 and Scotland Gas – 100044366.

Warning: PDF designed for A3 colour print only with no page scaling.

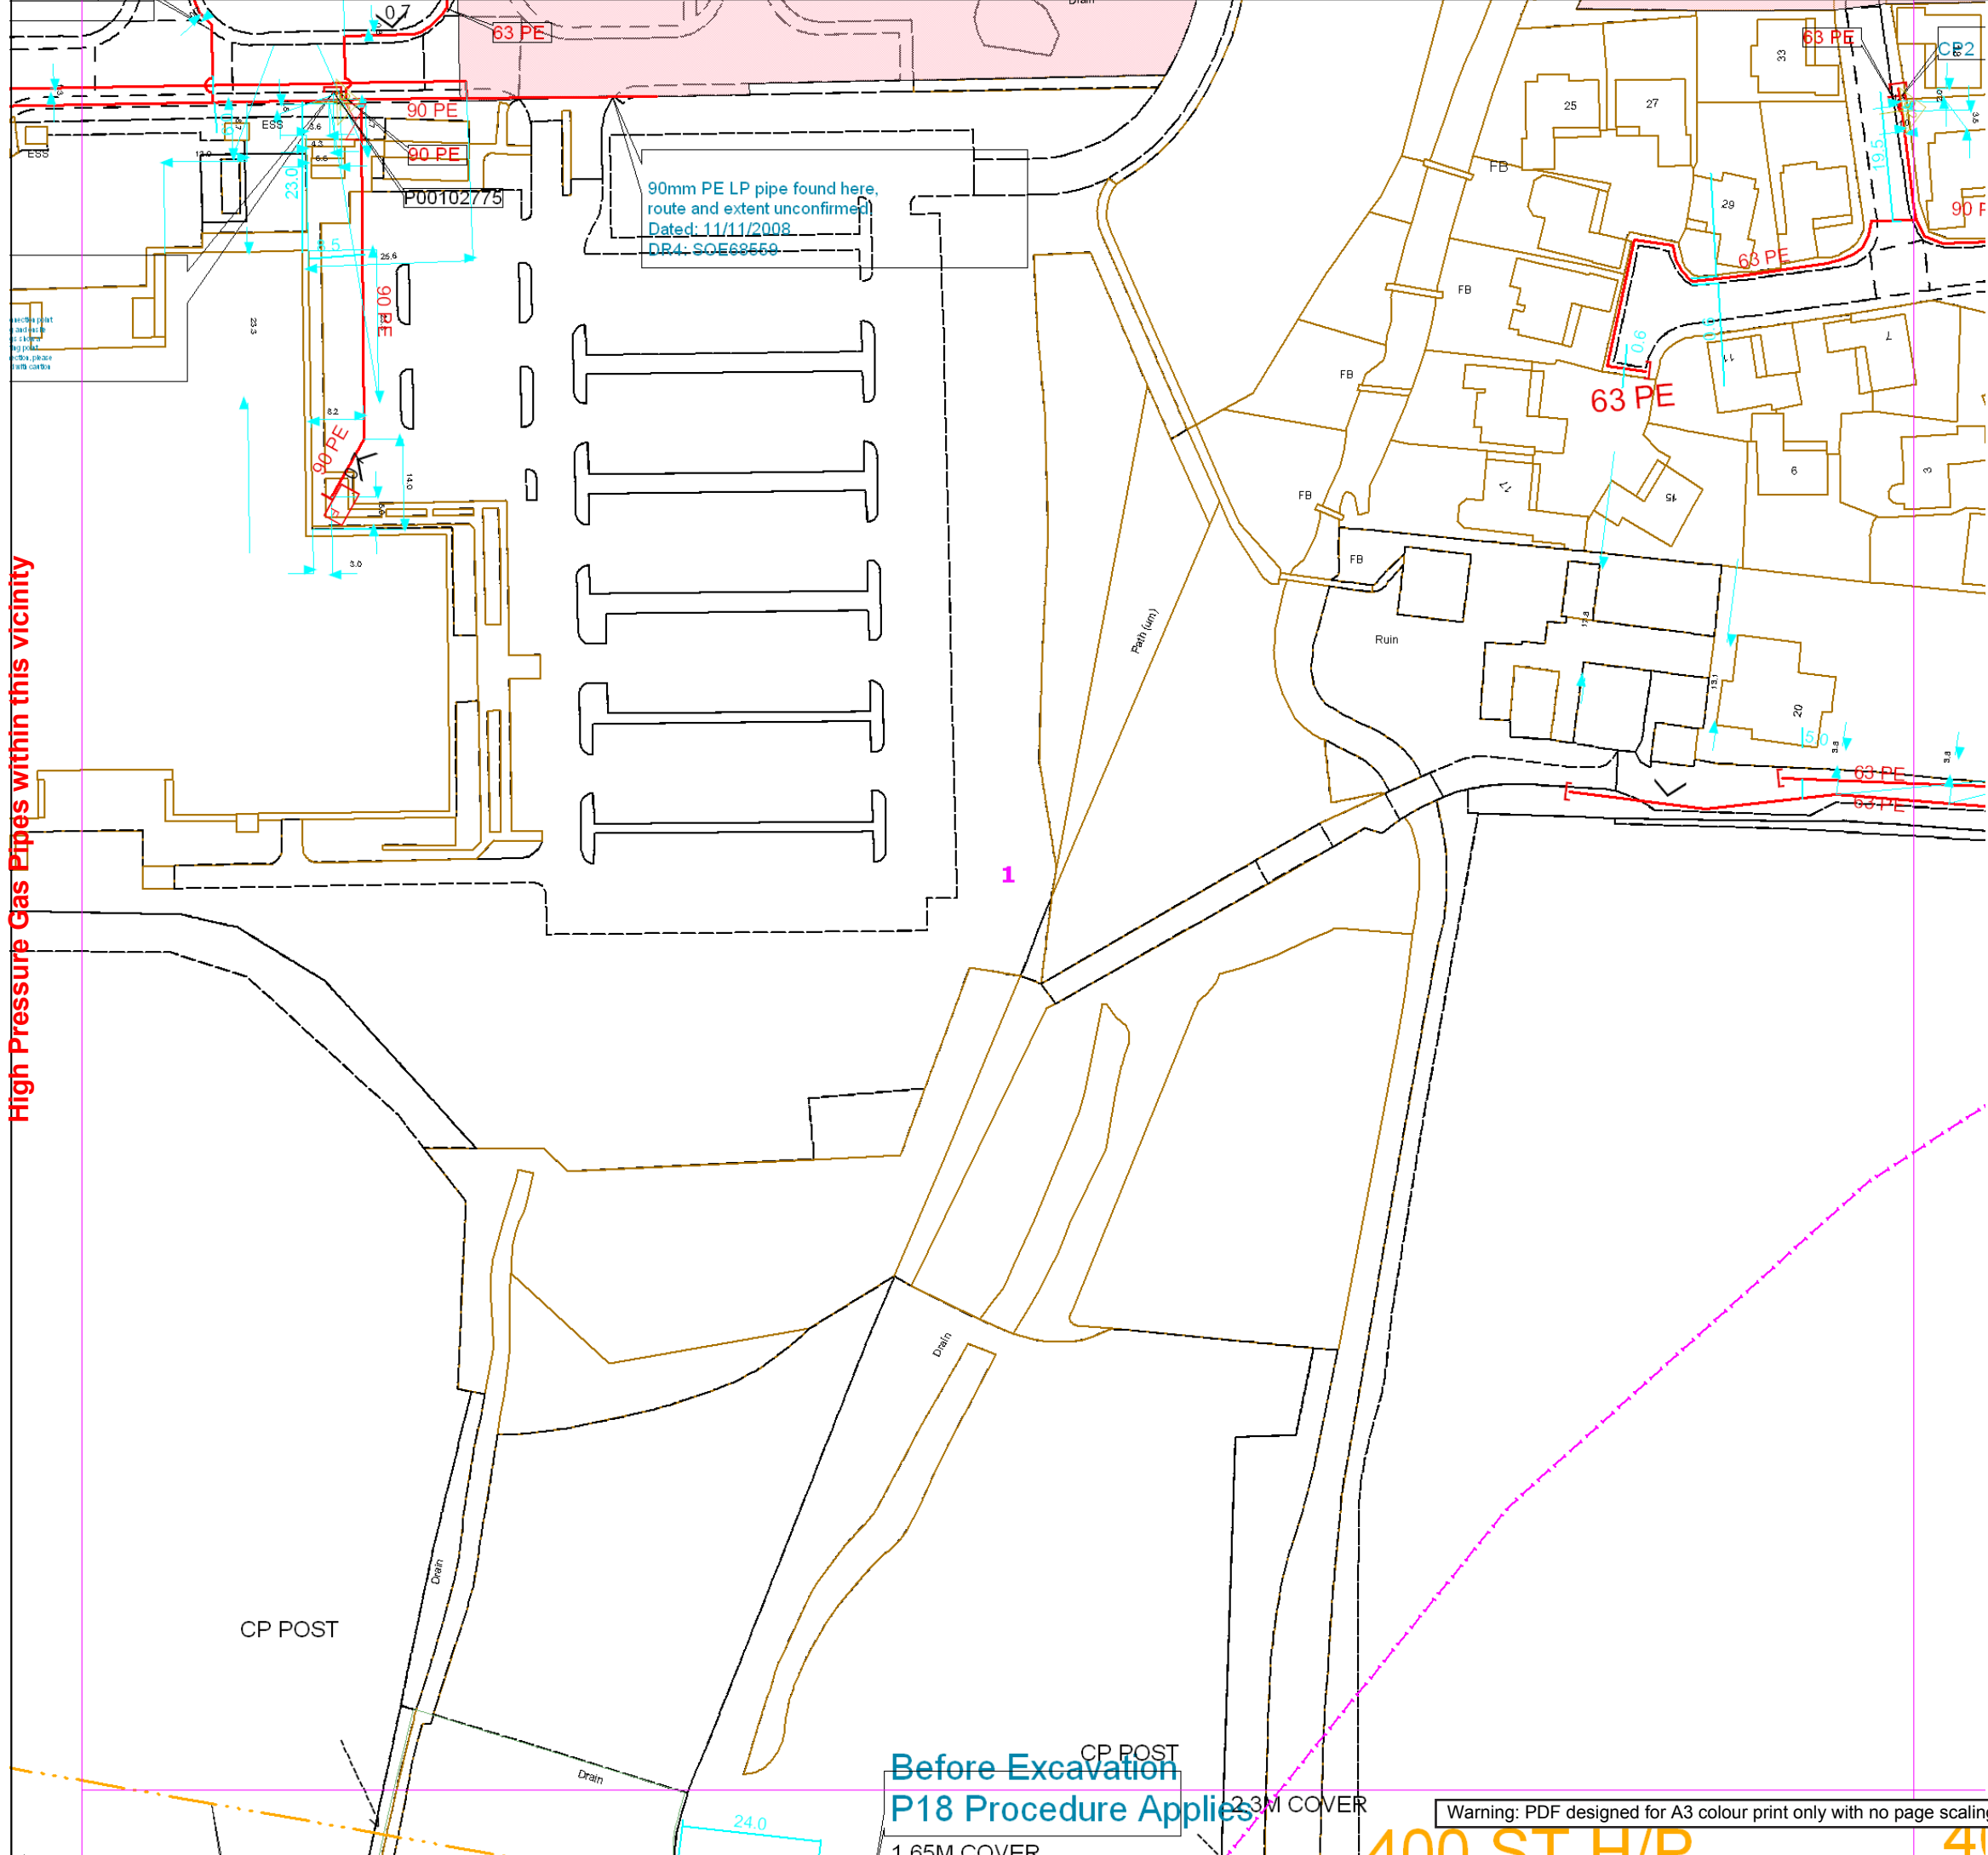

Contact Us
Mapping Enquiries:
 All areas

General Enquiries:
 All areas

Date Requested: 03/09/2021
 Job Reference: 23169206
 Site Location: 471818 104822
 Requested by:
 Miss Rebecca Dabbs
 Your Scheme/Reference:
 736036 Langstone Flood & CoastalCoastal
 Exact Scales:
 1:1000 Area or Circle dig site
 1:1000 Line dig site

This plan shows the location of those pipes owned by Scotia Gas Networks (SGN) by virtue of being a licensed Gas Transporter (GT). Gas pipes owned by other GTs or third parties may also be present in this area but are not shown on this plan. Information with regard to such pipes should be obtained from the relevant owners. No warranties are given with regard to the accuracy of the information shown on this plan. Service pipes, valves, siphons, sub-connections etc. are not shown but their presence should be anticipated. You should be aware that a small percentage of our pipes/assets may be undergoing review and will temporarily be highlighted in yellow. If your proposed works are close to one of these pipes, you should contact the SGN Safety Admin Team on 0800 912 1722 for advice. No liability of any kind whatsoever is accepted by SGN or its agents, servants or sub-contractors for any error or omission contained herein. Safe digging practices, in accordance with HS (G)47, must be used to verify and establish the actual position of mains, pipes, services and other apparatus on site before any mechanical plant is used. It is your responsibility to ensure that plant location information is provided to all persons (whether direct labour or sub-contractors) working for you on or near gas apparatus. Information included on this plan should not be referred to beyond a period of 28 days from the date of issue.

Report damage immediately – KEEP EVERYONE AWAY FROM THE AREA
0800 111 999

Low Pressure Mains
 Medium Pressure Mains
 Intermediate Pressure Mains
 High Pressure Mains
 LAs
 GTs

SSSIs


Some Examples Of Plant Items

Valve Syphon Depth of Cover Diameter Change Material Change

Digsite: Line: Area:



This plan is reproduced from or based on the OS map by Scotia Gas Networks plc, with the sanction of the controller of HM Stationery Office. Crown Copyright Reserved. Southern Gas – 100044373 and Scotland Gas – 100044366.

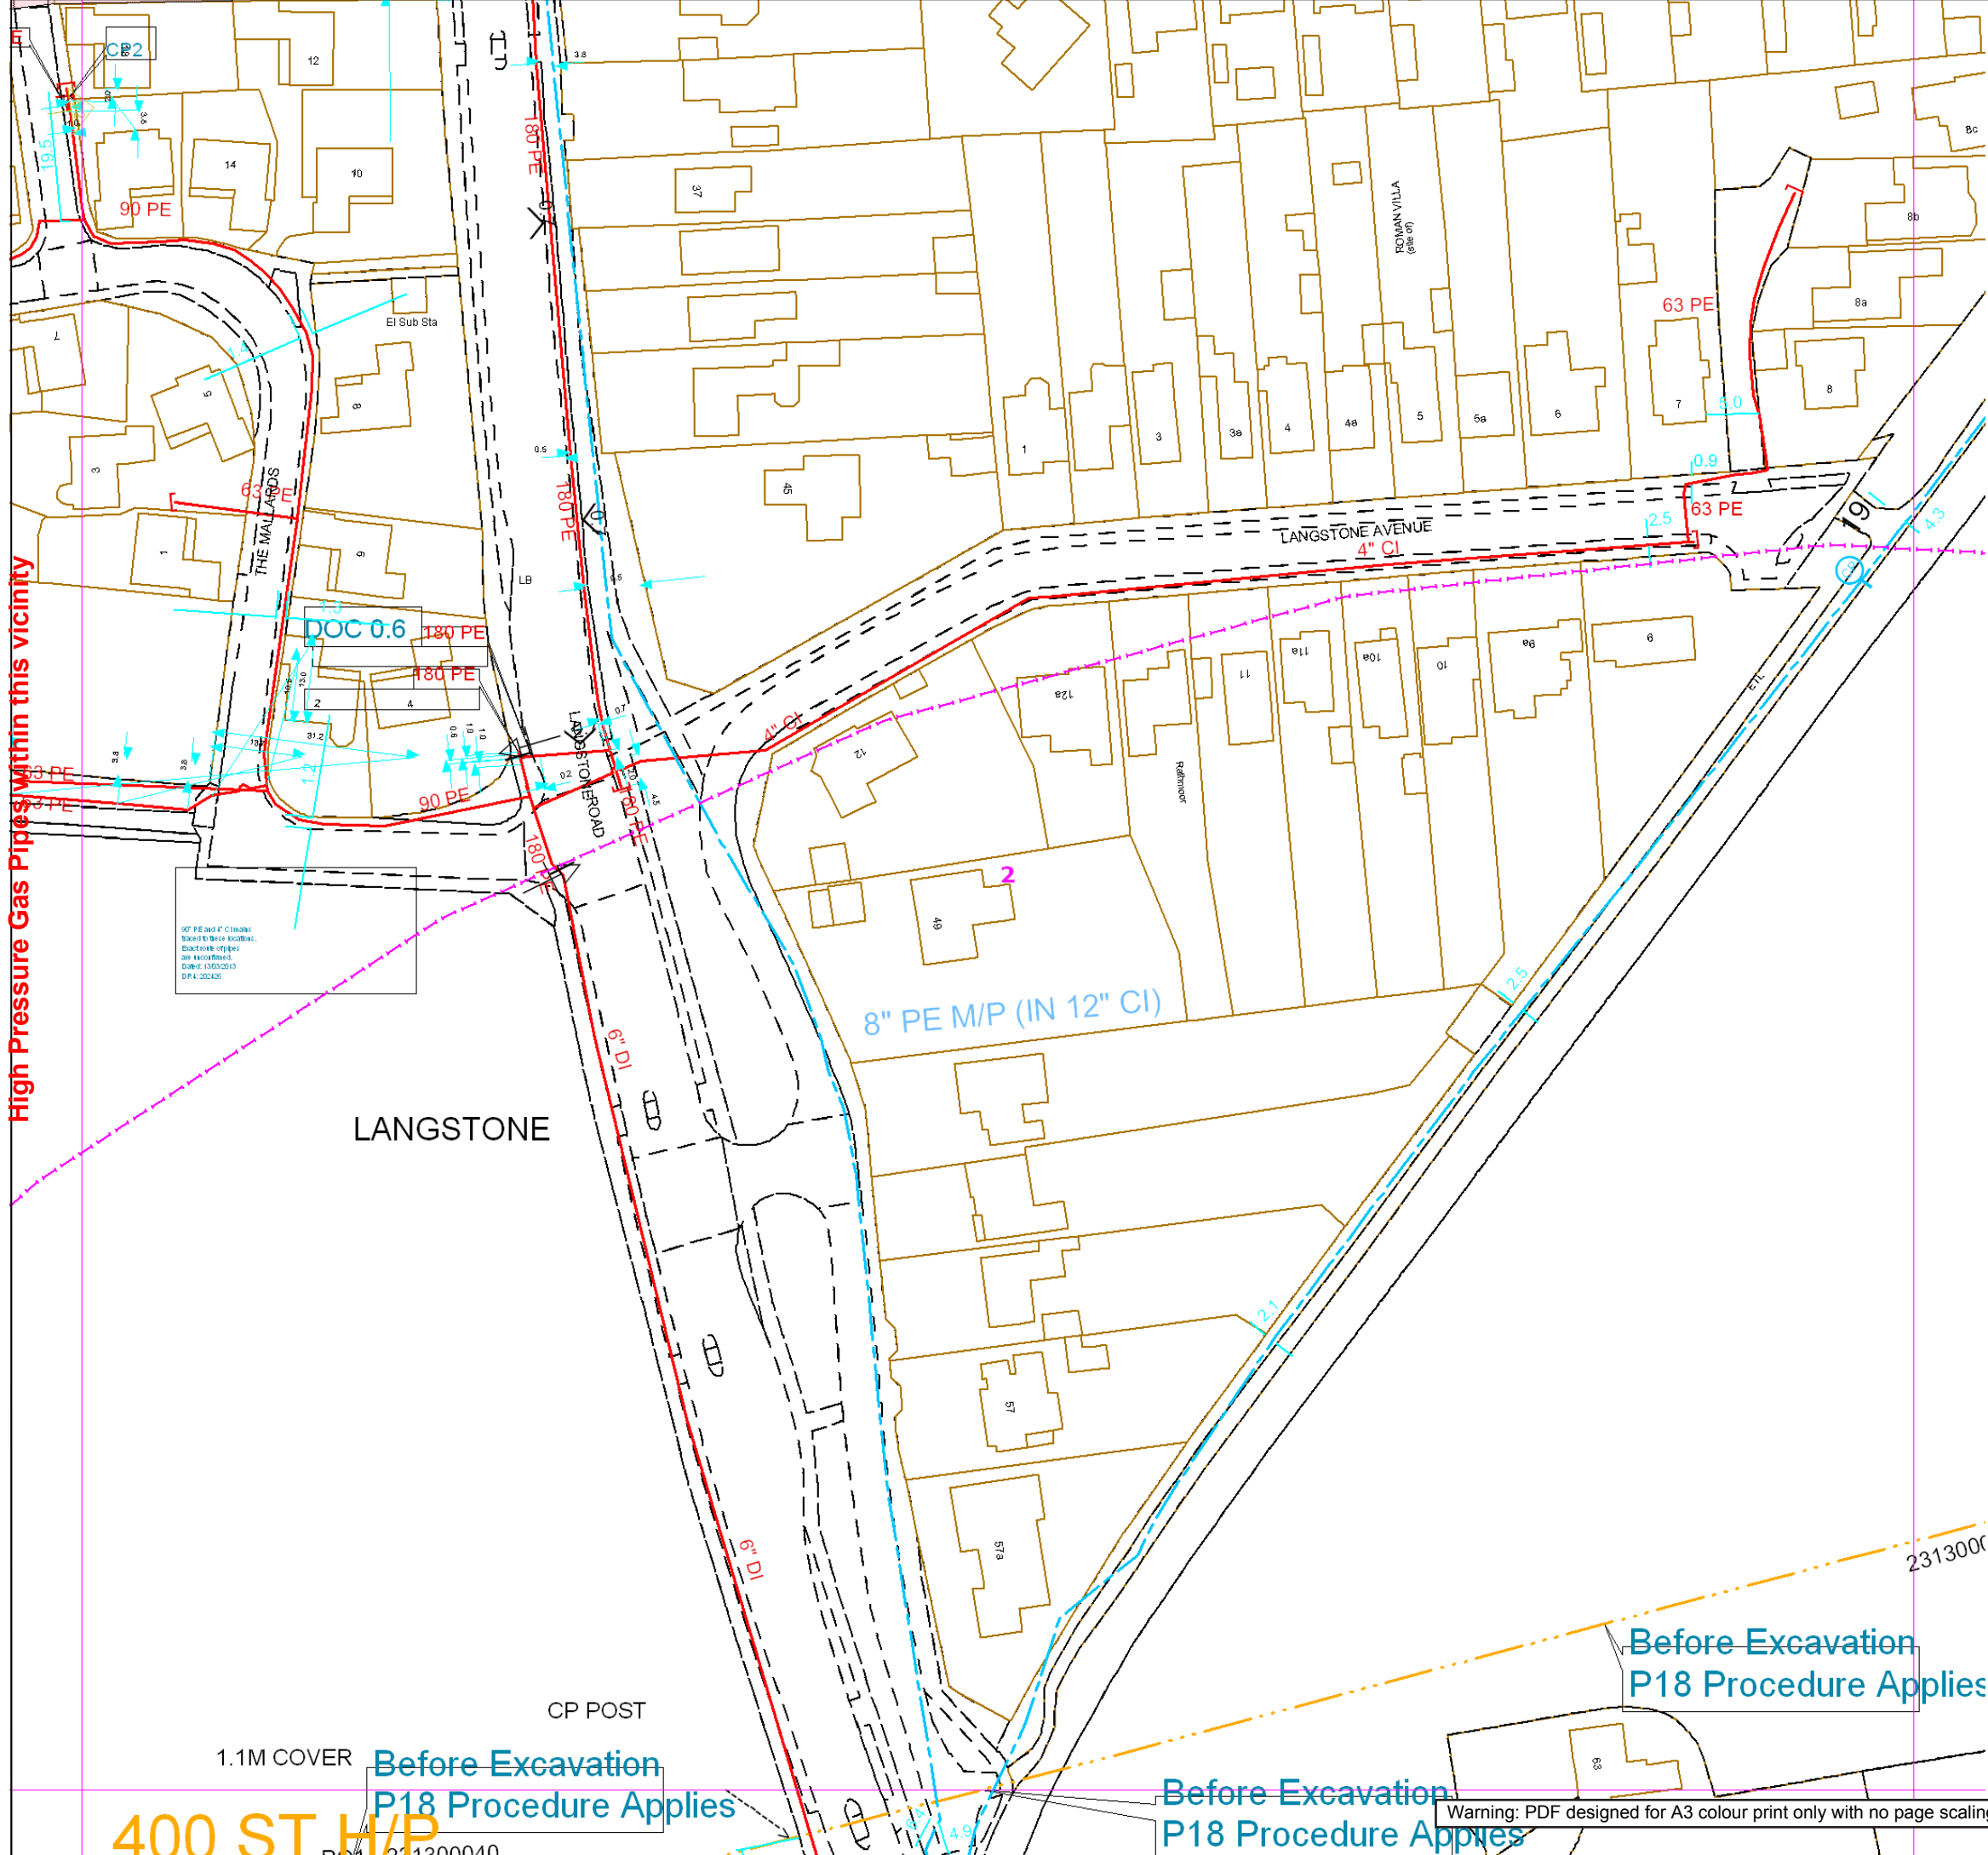



Contact Us
Mapping Enquiries:
All areas

General Enquiries:
All areas

Date Requested: 03/09/2021
Job Reference: 23169206
Site Location: 471818 104822
Requested by:
Miss Rebecca Dabbs
Your Scheme/Reference:
736036 Langstone Flood & CoastalCoastalCoastal
Exact Scales:
1:1000 Area or Circle dig site
1:1000 Line dig site

This plan shows the location of those pipes owned by Scotia Gas Networks (SGN) by virtue of being a licensed Gas Transporter (GT). Gas pipes owned by other GTs or third parties may also be present in this area but are not shown on this plan. Information with regard to such pipes should be obtained from the relevant owners. No warranties are given with regard to the accuracy of the information shown on this plan. Service pipes, valves, siphons, sub-connections etc. are not shown but their presence should be anticipated. You should be aware that a small percentage of our pipes/assets may be undergoing review and will temporarily be highlighted in yellow. If your proposed works are close to one of these pipes, you should contact the SGN Safety Admin Team on 0800 912 1722 for advice. No liability of any kind whatsoever is accepted by SGN or its agents, servants or sub-contractors for any error or omission contained herein. Safe digging practices, in accordance with HS (G)47, must be used to verify and establish the actual position of mains, pipes, services and other apparatus on site before any mechanical plant is used. It is your responsibility to ensure that plant location information is provided to all persons (whether direct labour or sub-contractors) working for you on or near gas apparatus. Information included on this plan should not be referred to beyond a period of 28 days from the date of issue.

Report damage immediately – KEEP EVERYONE AWAY FROM THE AREA
0800 111 999

Low Pressure Mains

Medium Pressure Mains

Intermediate Pressure Mains

High Pressure Mains

LAs

GTs

SSSIs

Some Examples Of Plant Items

Valve

Syphon

Depth of Cover

Diameter Change

Material Change


Digsite:

Line:

Area:



This plan is reproduced from or based on the OS map by Scotia Gas Networks plc, with the sanction of the controller of HM Stationery Office. Crown Copyright Reserved. Southern Gas – 100044373 and Scotland Gas – 100044366.

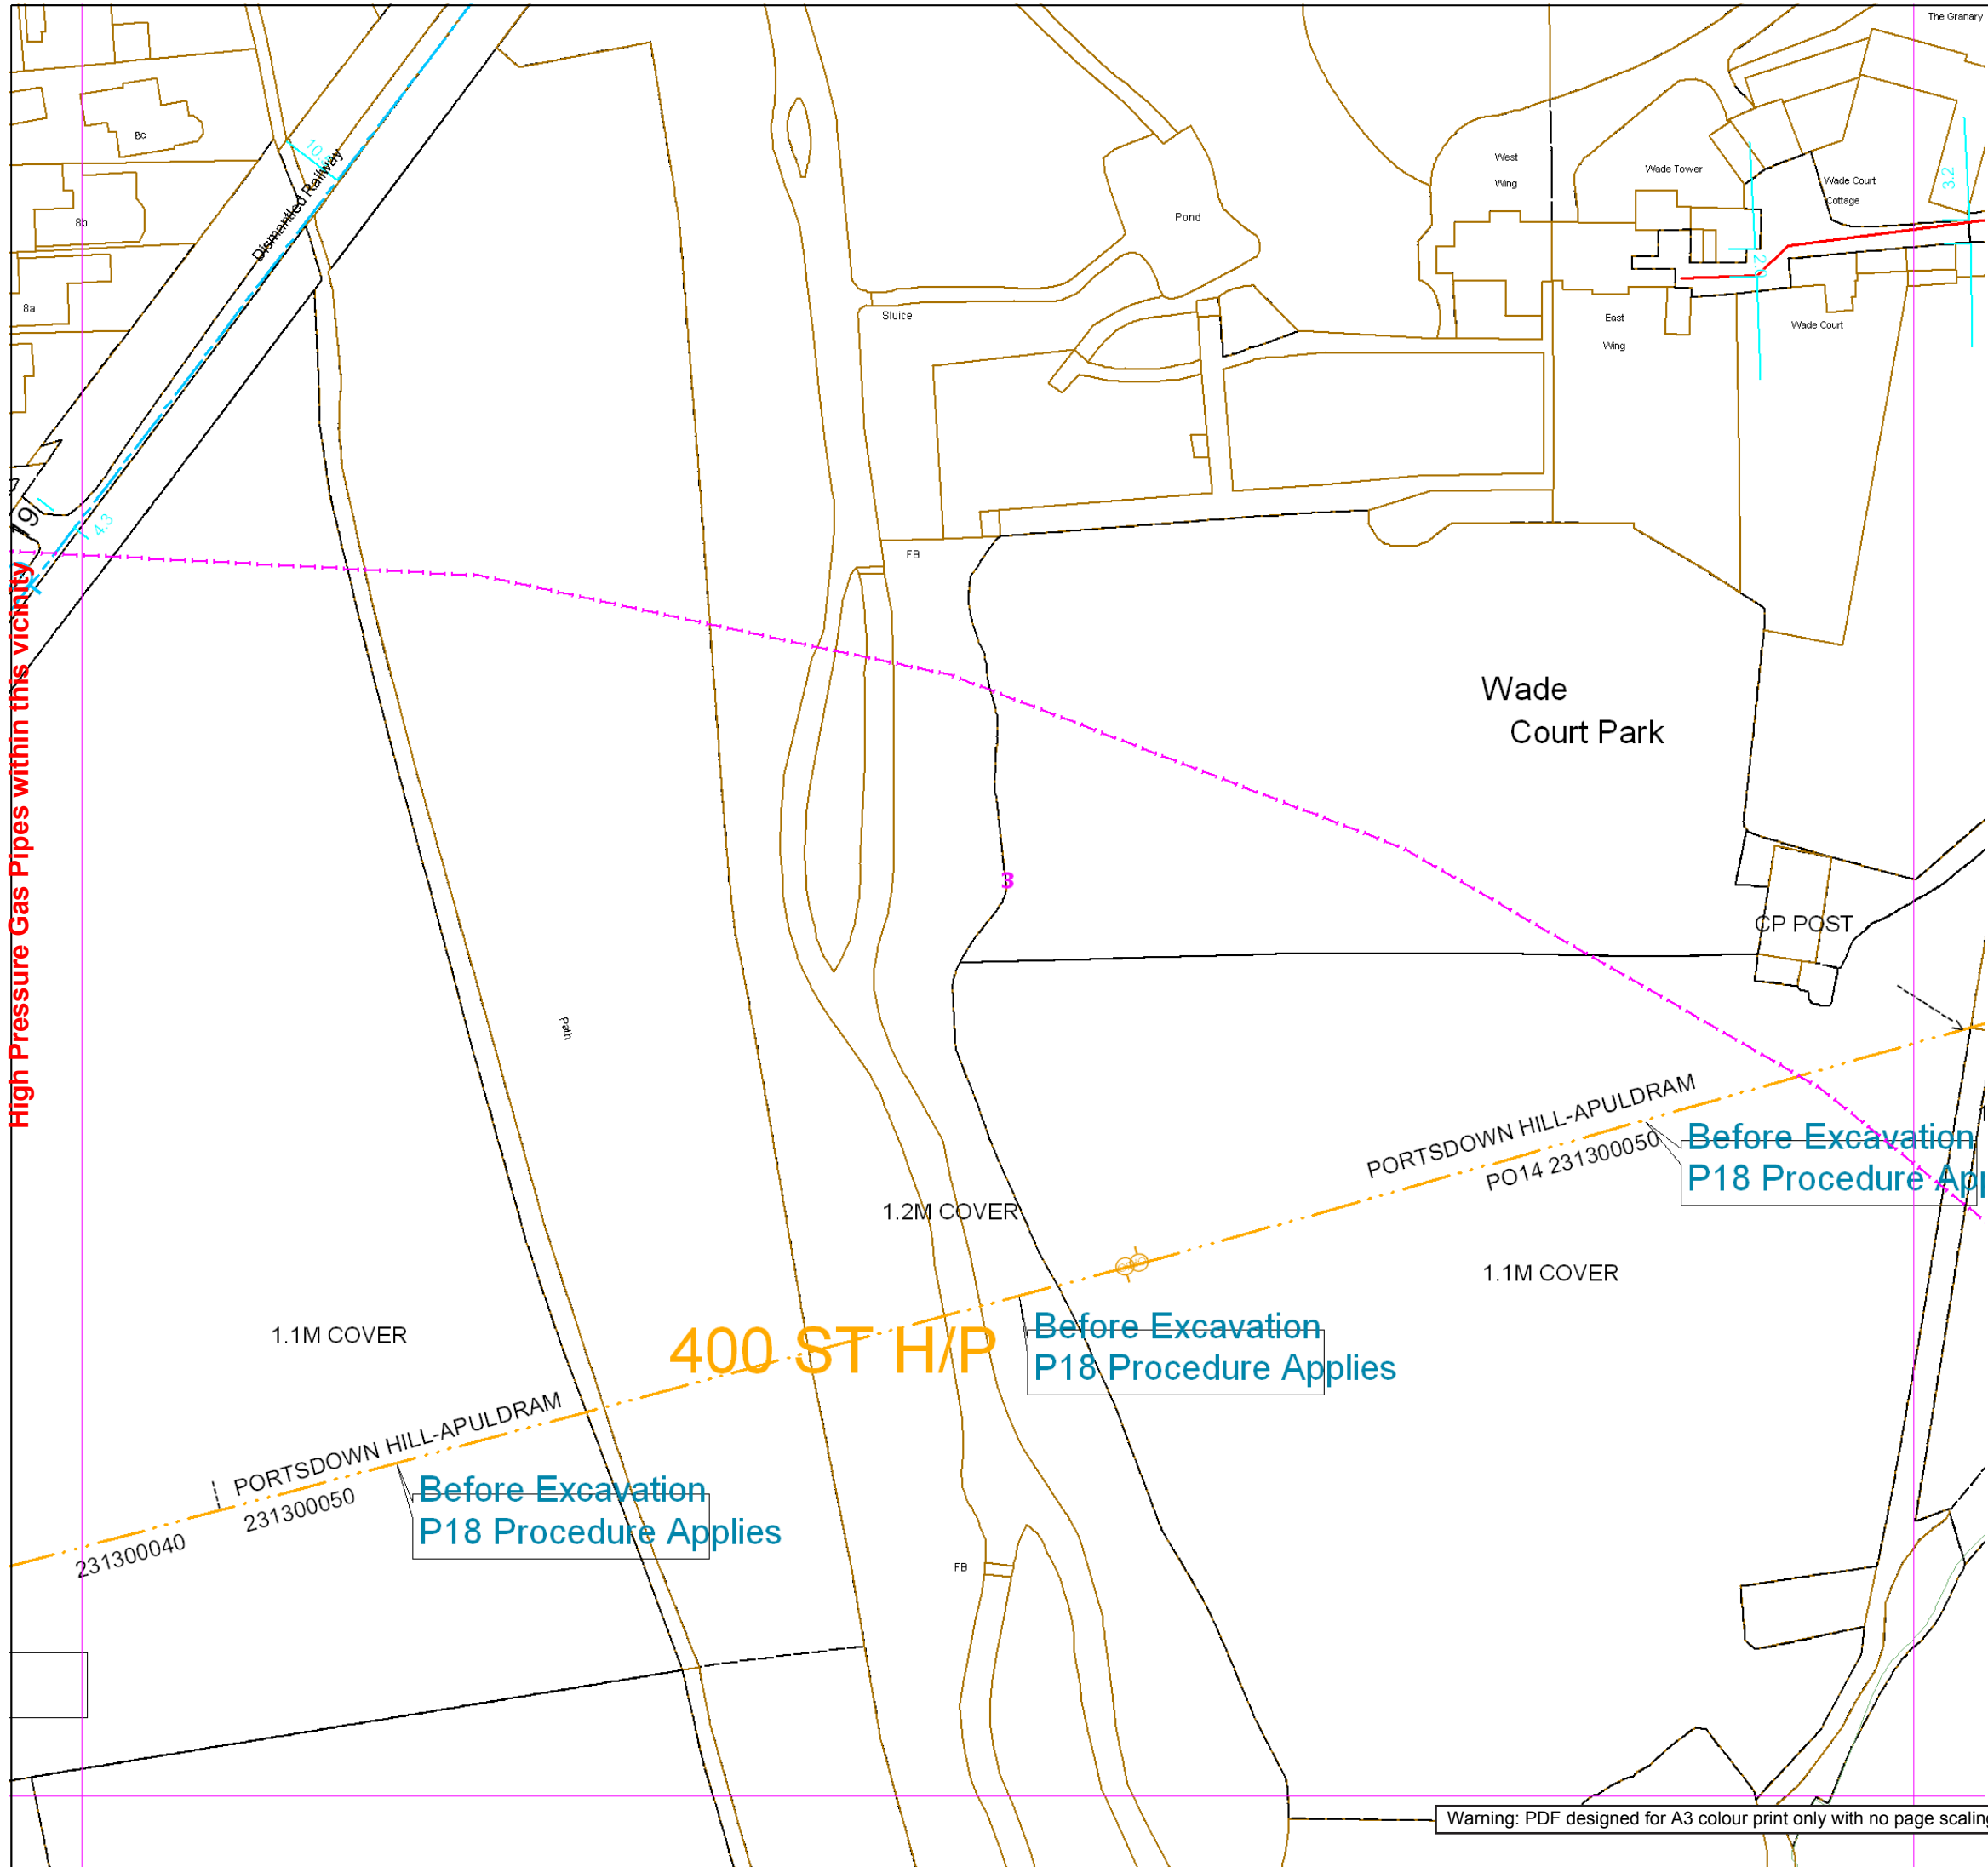



Contact Us
Mapping Enquiries:
All areas

General Enquiries:
All areas

Date Requested: 03/09/2021
Job Reference: 23169206
Site Location: 471818 104822
Requested by:
Miss Rebecca Dabbs
Your Scheme/Reference:
736036 Langstone Flood & CoastalCoastalCoastalCoastal
Exact Scales:
1:1000 Area or Circle dig site
1:1000 Line dig site

This plan shows the location of those pipes owned by Scotia Gas Networks (SGN) by virtue of being a licensed Gas Transporter (GT). Gas pipes owned by other GTs or third parties may also be present in this area but are not shown on this plan. Information with regard to such pipes should be obtained from the relevant owners. No warranties are given with regard to the accuracy of the information shown on this plan. Service pipes, valves, siphons, sub-connections etc. are not shown but their presence should be anticipated. You should be aware that a small percentage of our pipes/assets may be undergoing review and will temporarily be highlighted in yellow. If your proposed works are close to one of these pipes, you should contact the SGN Safety Admin Team on 0800 912 1722 for advice. No liability of any kind whatsoever is accepted by SGN or its agents, servants or sub-contractors for any error or omission contained herein. Safe digging practices, in accordance with HS (G)47, must be used to verify and establish the actual position of mains, pipes, services and other apparatus on site before any mechanical plant is used. It is your responsibility to ensure that plant location information is provided to all persons (whether direct labour or sub-contractors) working for you on or near gas apparatus. Information included on this plan should not be referred to beyond a period of 28 days from the date of issue.

Report damage immediately – KEEP EVERYONE AWAY FROM THE AREA
0800 111 999

Low Pressure Mains

Medium Pressure Mains

Intermediate Pressure Mains

High Pressure Mains

LAs

GTs

Valve

Syphon

Depth of Cover

Diameter Change


Material Change

SSSIs

Digsite: Line: Area:



This plan is reproduced from or based on the OS map by Scotia Gas Networks plc, with the sanction of the controller of HM Stationary Office. Crown Copyright Reserved. Southern Gas – 100044373 and Scotland Gas – 100044366.

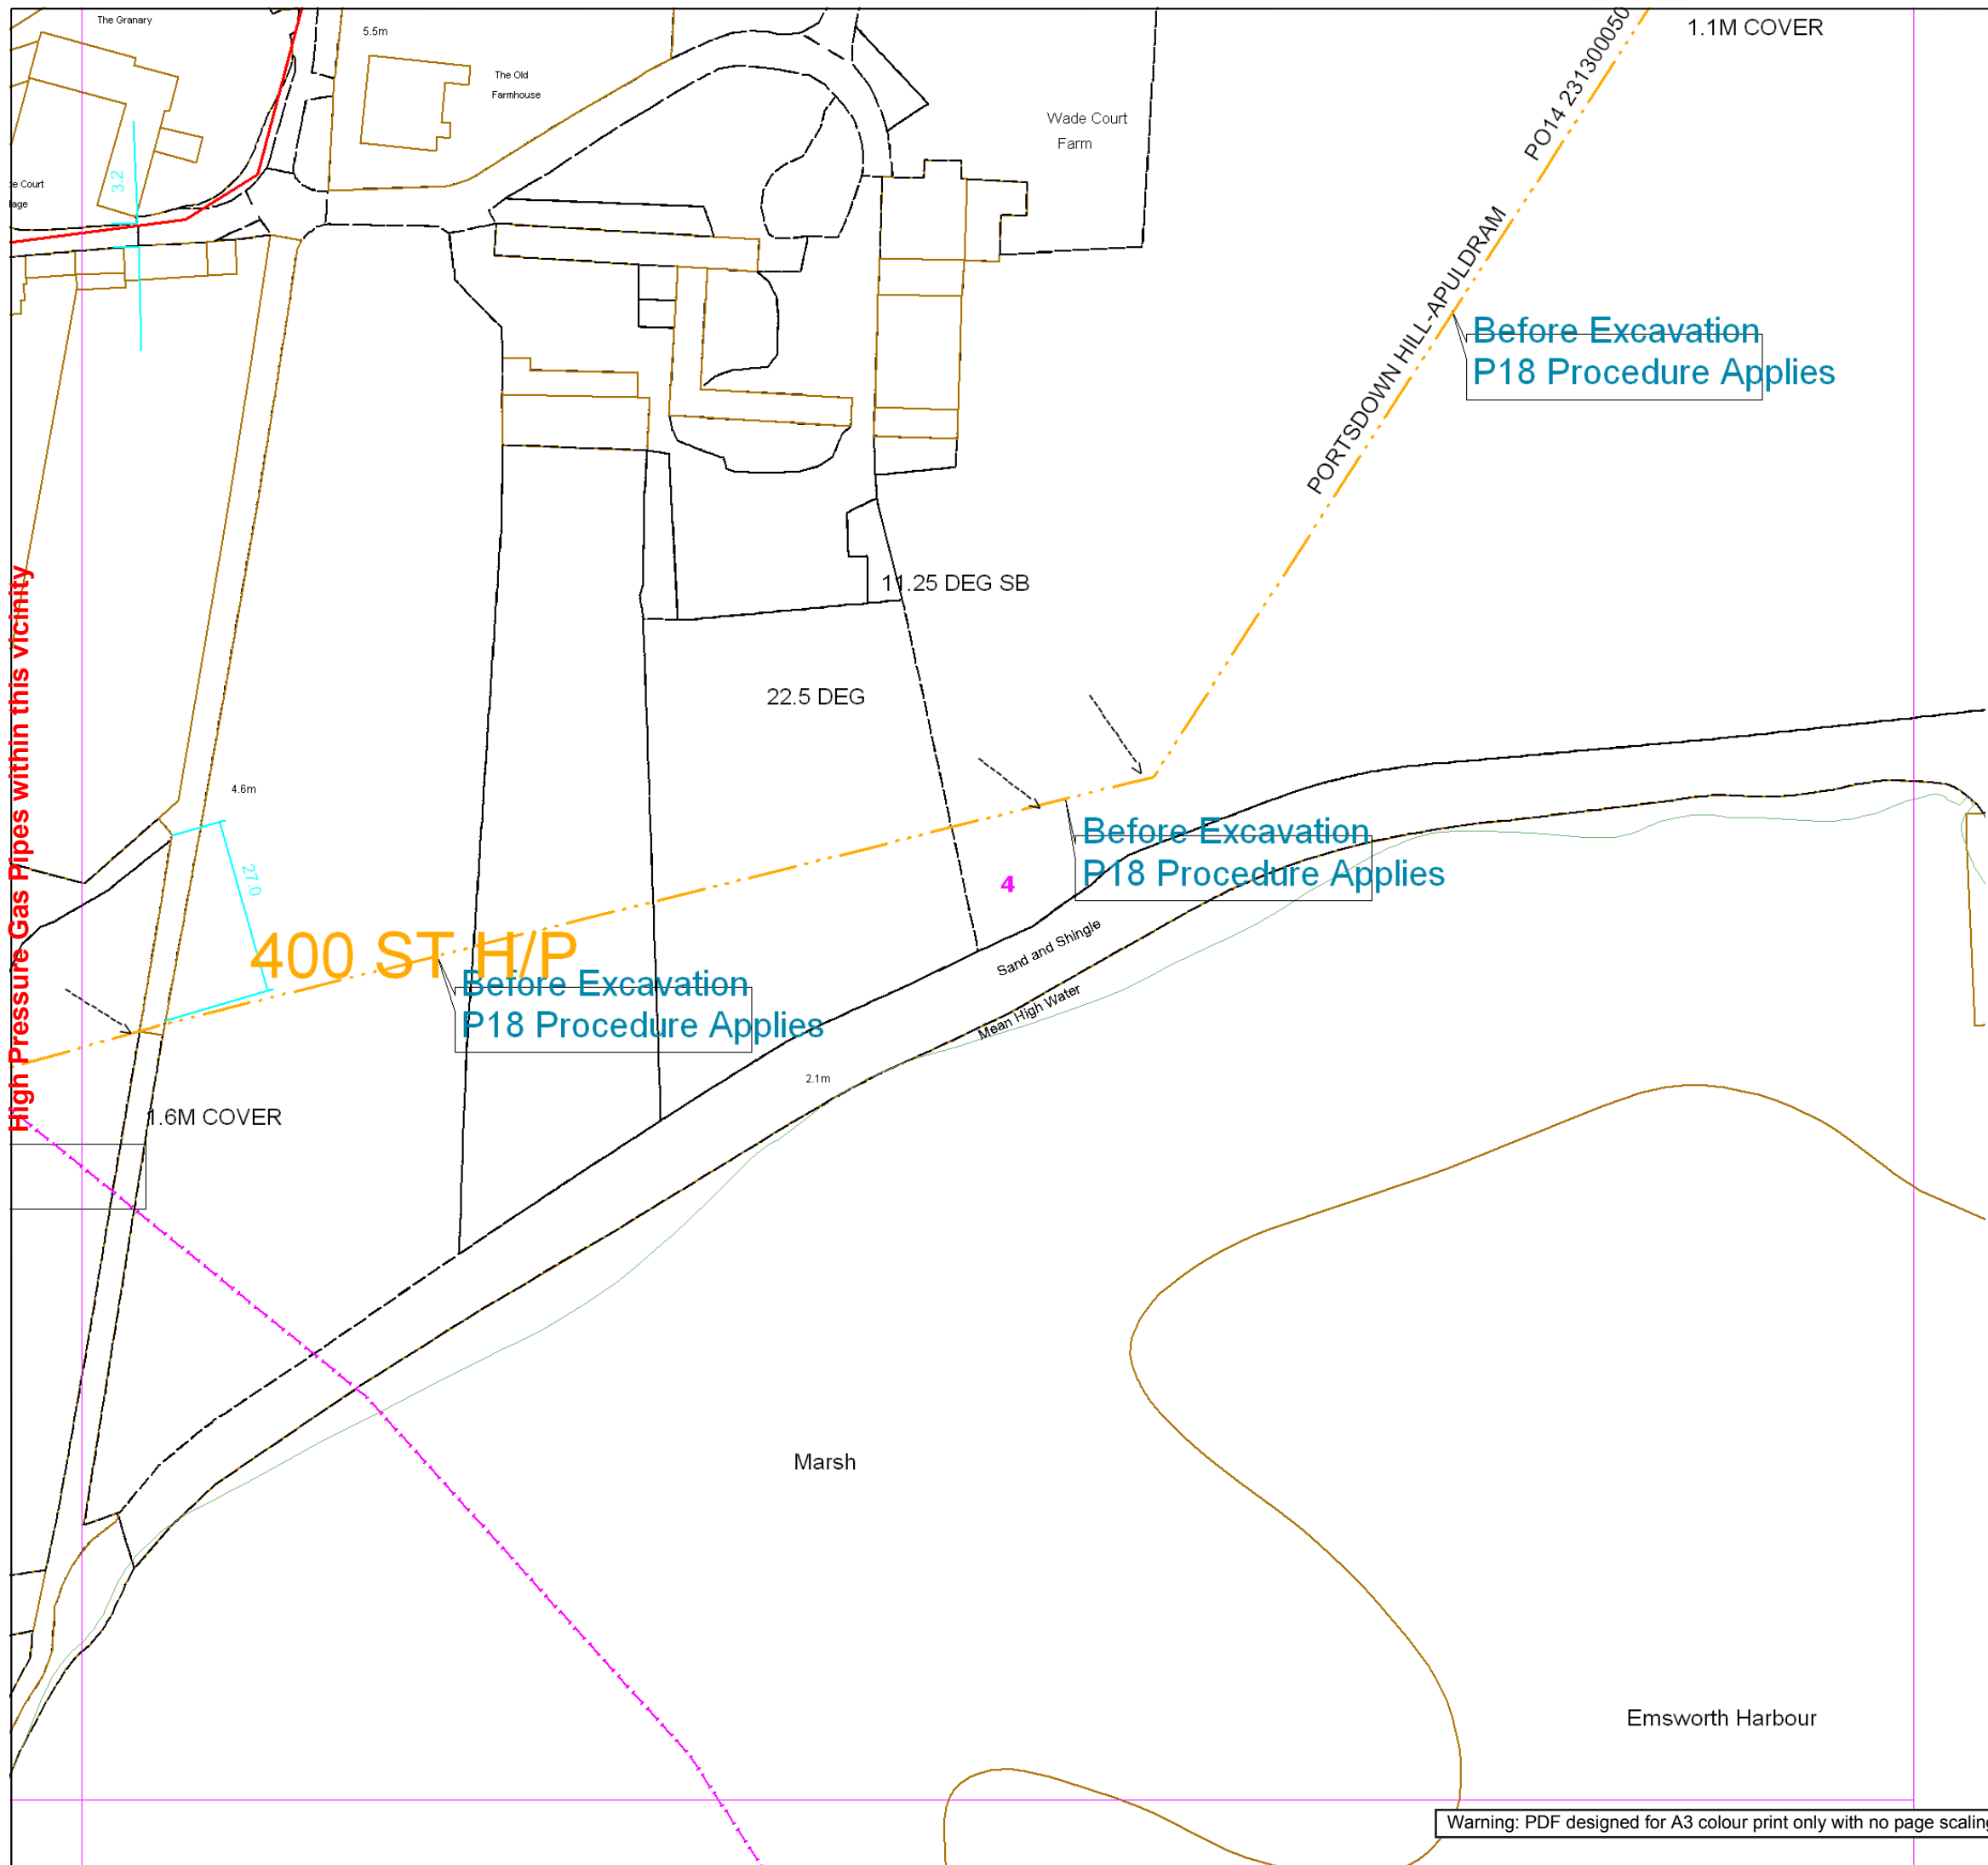

Contact Us
Mapping Enquiries:
All areas

General Enquiries:
All areas

Date Requested: 03/09/2021
Job Reference: 23169206
Site Location: 471818 104822
Requested by:
Miss Rebecca Dabbs
Your Scheme/Reference:
736036 Langstone Flood & CoastalCoastalCoastalCoastalCoastal
Exact Scales:
1:1000 Area or Circle dig site
1:1000 Line dig site

This plan shows the location of those pipes owned by Scotia Gas Networks (SGN) by virtue of being a licensed Gas Transporter (GT). Gas pipes owned by other GTs or third parties may also be present in this area but are not shown on this plan. Information with regard to such pipes should be obtained from the relevant owners. No warranties are given with regard to the accuracy of the information shown on this plan. Service pipes, valves, siphons, sub-connections etc. are not shown but their presence should be anticipated. You should be aware that a small percentage of our pipes/assets may be undergoing review and will temporarily be highlighted in yellow. If your proposed works are close to one of these pipes, you should contact the SGN Safety Admin Team on 0800 912 1722 for advice. No liability of any kind whatsoever is accepted by SGN or its agents, servants or sub-contractors for any error or omission contained herein. Safe digging practices, in accordance with HS (G)47, must be used to verify and establish the actual position of mains, pipes, services and other apparatus on site before any mechanical plant is used. It is your responsibility to ensure that plant location information is provided to all persons (whether direct labour or sub-contractors) working for you on or near gas apparatus. Information included on this plan should not be referred to beyond a period of 28 days from the date of issue.

Report damage immediately – KEEP EVERYONE AWAY FROM THE AREA
0800 111 999


Low Pressure Mains
Medium Pressure Mains
Intermediate Pressure Mains
High Pressure Mains
LAs
GTs

Some Examples Of Plant Items
Valve Syphon Depth of Cover Diameter Change Material Change

Digsite: Line: Area:



This plan is reproduced from or based on the OS map by Scotia Gas Networks plc, with the sanction of the controller of HM Stationery Office. Crown Copyright Reserved. Southern Gas – 100044373 and Scotland Gas – 100044366.

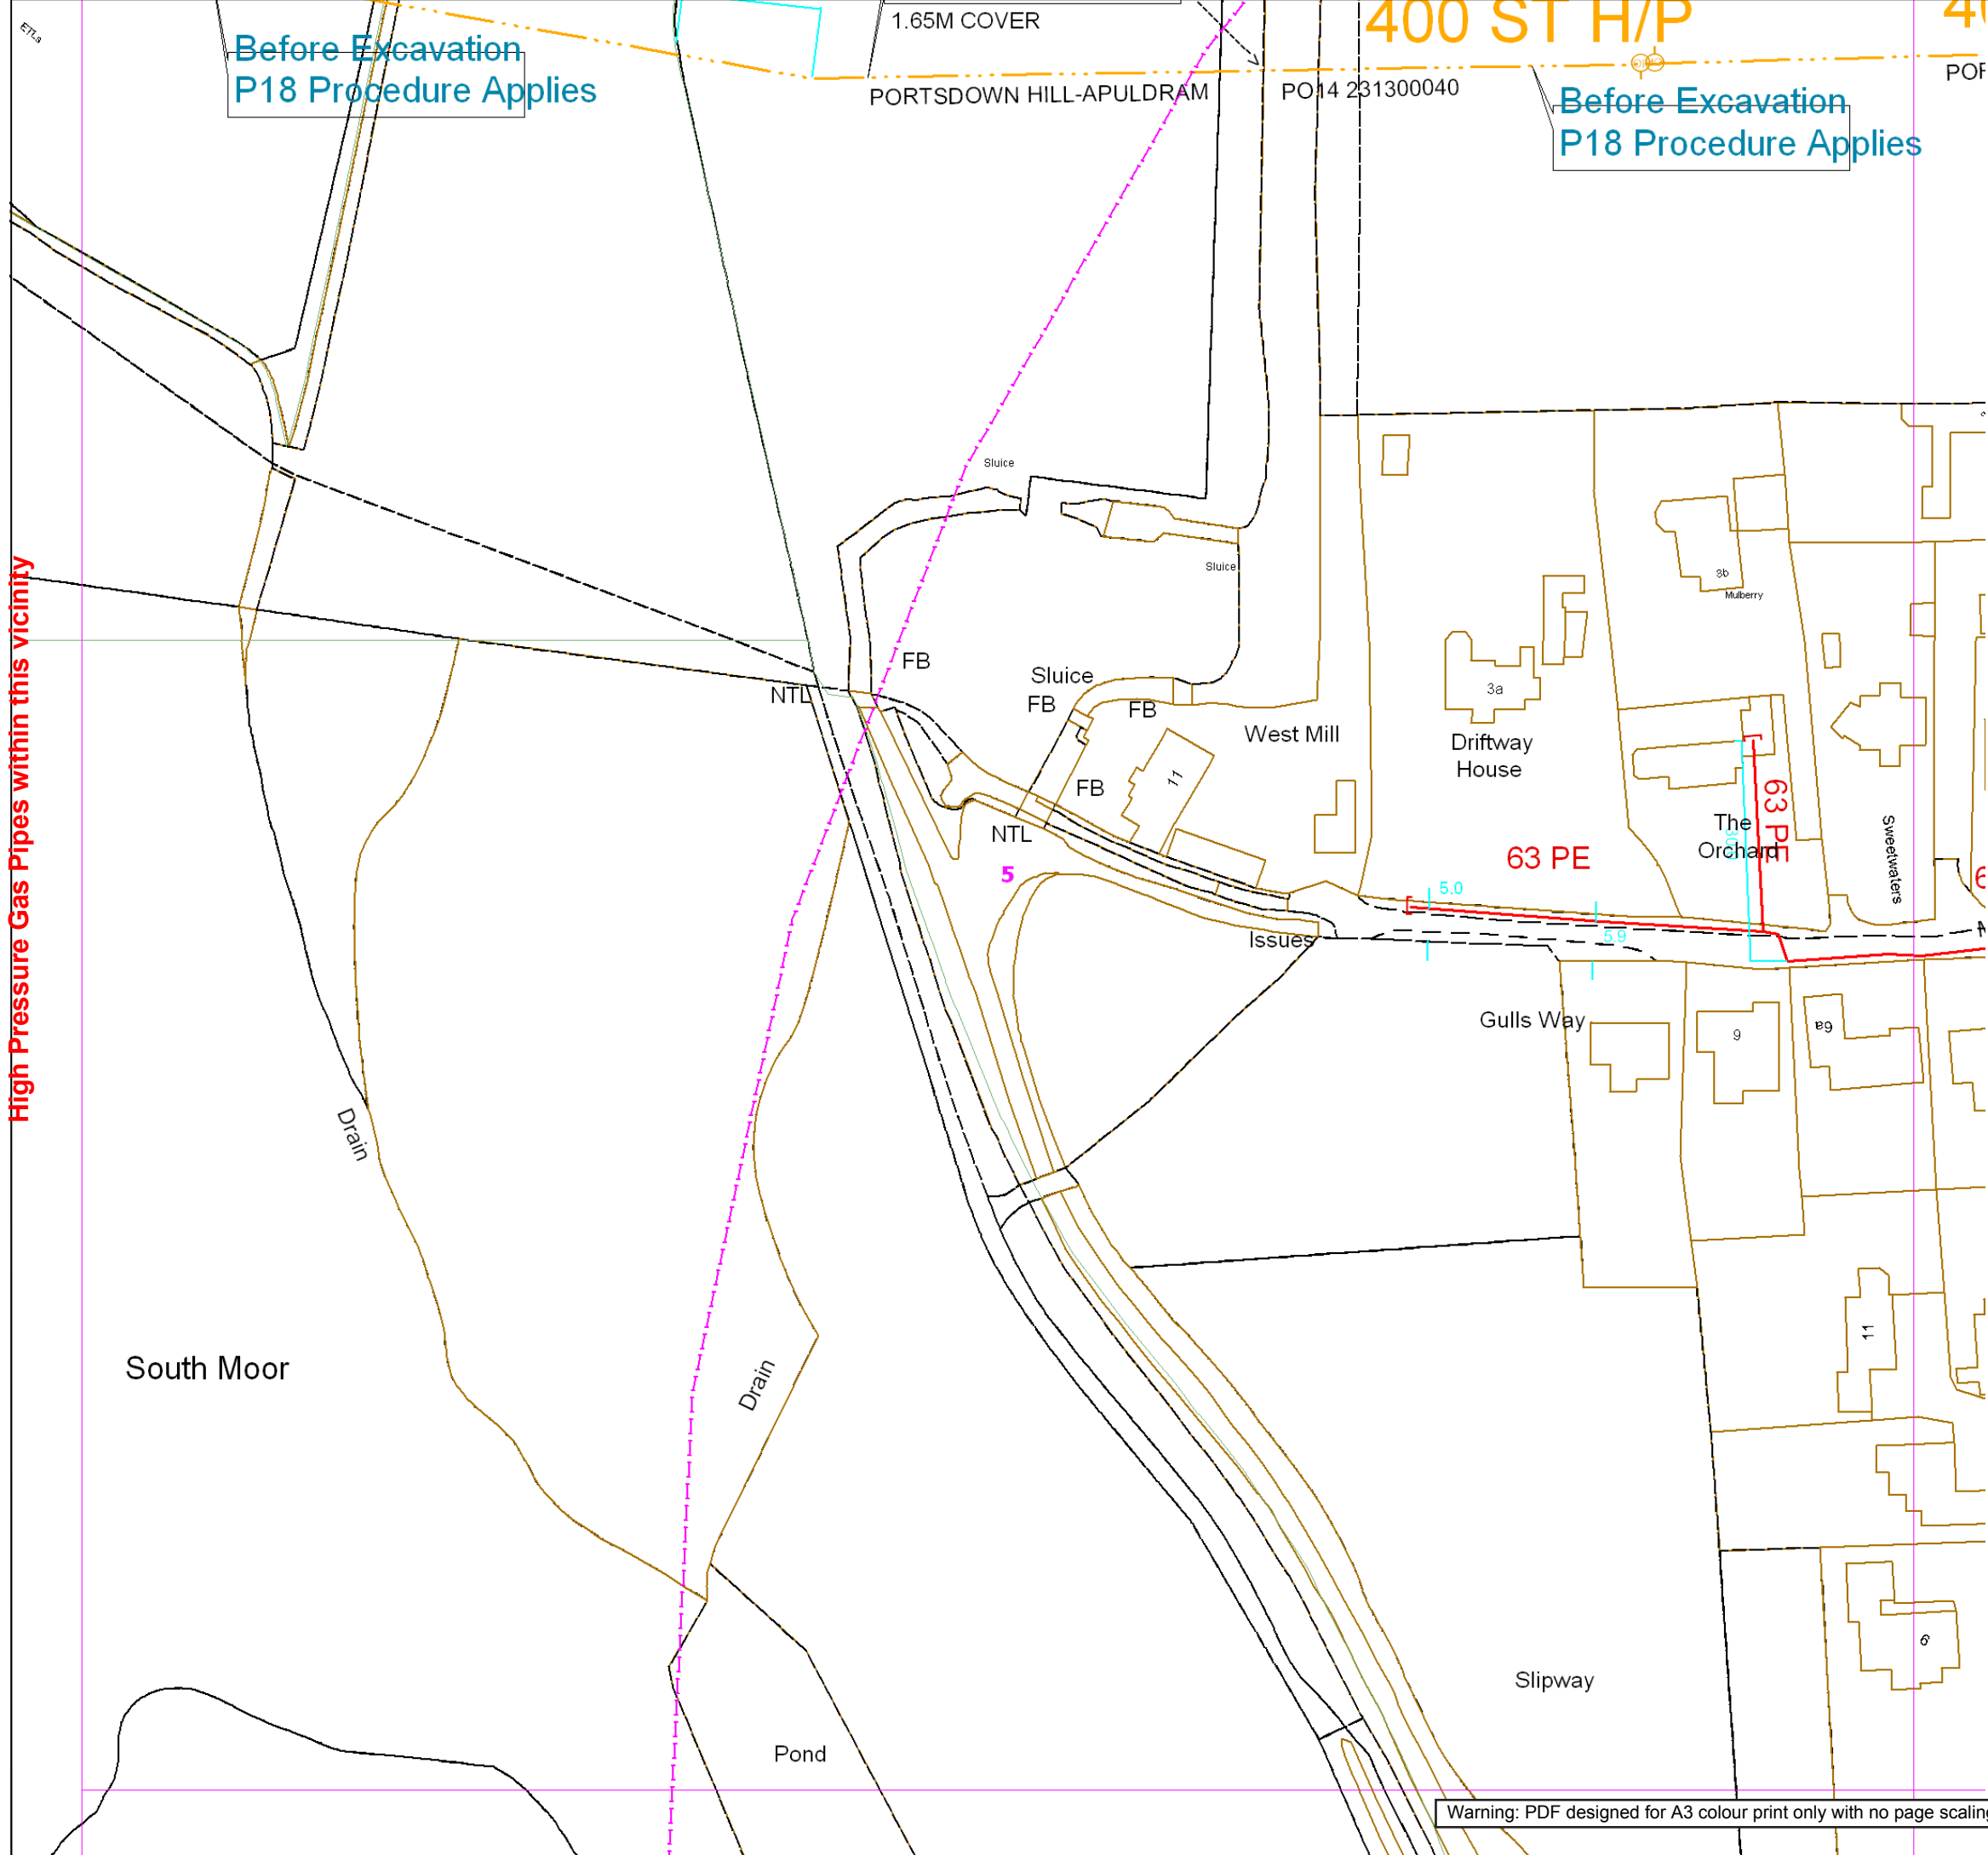

High Pressure Gas Pipes within this vicinity

Contact Us
Mapping Enquiries:
All areas

General Enquiries:
All areas

Date Requested: 03/09/2021
Job Reference: 23169206
Site Location: 471818 104822
Requested by:
Miss Rebecca Dabbs
Your Scheme/Reference:
736036 Langstone Flood & Coastal
Exact Scales:
1:1000 Area or Circle dig site
1:1000 Line dig site

This plan shows the location of those pipes owned by Scotia Gas Networks (SGN) by virtue of being a licensed Gas Transporter (GT). Gas pipes owned by other GTs or third parties may also be present in this area but are not shown on this plan. Information with regard to such pipes should be obtained from the relevant owners. No warranties are given with regard to the accuracy of the information shown on this plan. Service pipes, valves, siphons, sub-connections etc. are not shown but their presence should be anticipated. You should be aware that a small percentage of our pipes/assets may be undergoing review and will temporarily be highlighted in yellow. If your proposed works are close to one of these pipes, you should contact the SGN Safety Admin Team on 0800 912 1722 for advice. No liability of any kind whatsoever is accepted by SGN or its agents, servants or sub-contractors for any error or omission contained herein. Safe digging practices, in accordance with HS (G)47, must be used to verify and establish the actual position of mains, pipes, services and other apparatus on site before any mechanical plant is used. It is your responsibility to ensure that plant location information is provided to all persons (whether direct labour or sub-contractors) working for you on or near gas apparatus. Information included on this plan should not be referred to beyond a period of 28 days from the date of issue.

Report damage immediately – KEEP EVERYONE AWAY FROM THE AREA
0800 111 999

Low Pressure Mains

Medium Pressure Mains

Intermediate Pressure Mains

High Pressure Mains

LAs

GTs

SSSIs

Some Examples Of Plant Items

Valve

Syphon

Depth of Cover

Diameter Change

Material Change


Digsite:

Line:

Area:



This plan is reproduced from or based on the OS map by Scotia Gas Networks plc, with the sanction of the controller of HM Stationery Office. Crown Copyright Reserved. Southern Gas – 100044373 and Scotland Gas – 100044366.

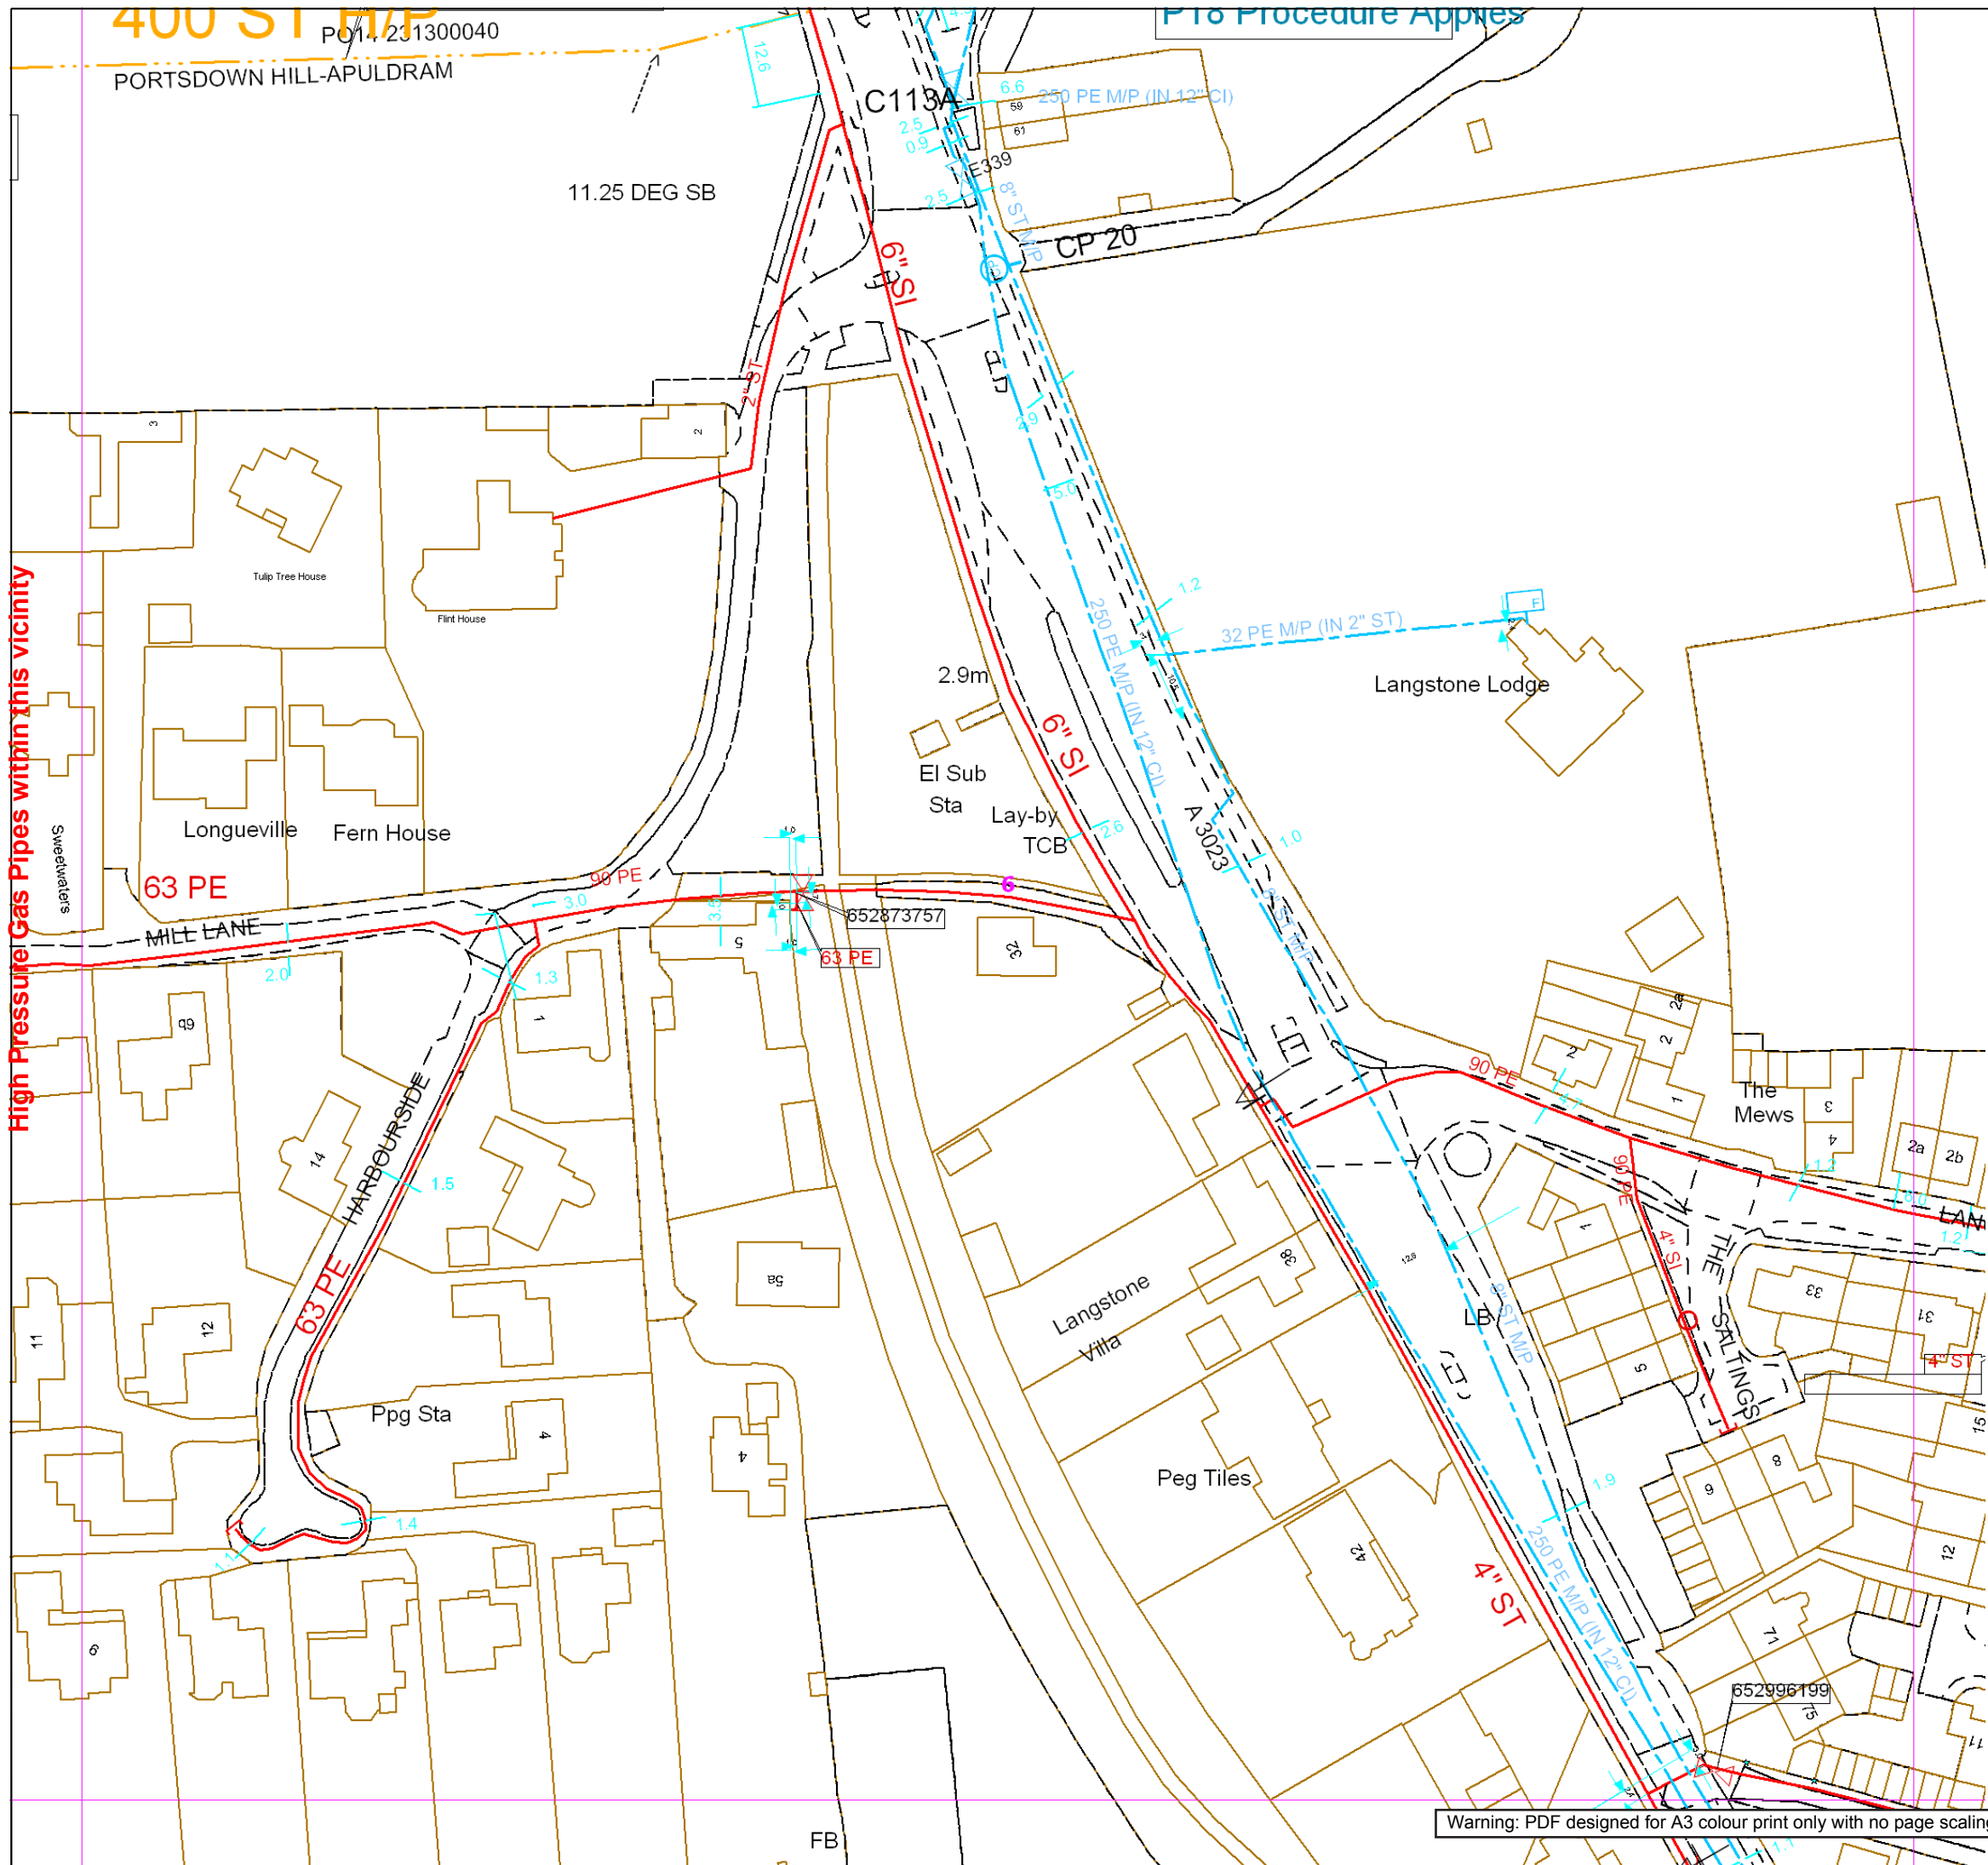



SGN
Your gas. Our network.

Contact Us
Mapping Enquiries:
All areas

General Enquiries:
All areas

Date Requested: 03/09/2021
Job Reference: 23169206
Site Location: 471818 104822
Requested by:
Miss Rebecca Dabbs
Your Scheme/Reference:
736036 Langstone Flood & Coastal
Exact Scales:
1:1000 Area or Circle dig site
1:1000 Line dig site

This plan shows the location of those pipes owned by Scotia Gas Networks (SGN) by virtue of being a licensed Gas Transporter (GT). Gas pipes owned by other GTs or third parties may also be present in this area but are not shown on this plan. Information with regard to such pipes should be obtained from the relevant owners. No warranties are given with regard to the accuracy of the information shown on this plan. Service pipes, valves, siphons, sub-connections etc. are not shown but their presence should be anticipated. You should be aware that a small percentage of our pipes/assets may be undergoing review and will temporarily be highlighted in yellow. If your proposed works are close to one of these pipes, you should contact the SGN Safety Admin Team on 0800 912 1722 for advice. No liability of any kind whatsoever is accepted by SGN or its agents, servants or sub-contractors for any error or omission contained herein. Safe digging practices, in accordance with HS (G)47, must be used to verify and establish the actual position of mains, pipes, services and other apparatus on site before any mechanical plant is used. It is your responsibility to ensure that plant location information is provided to all persons (whether direct labour or sub-contractors) working for you on or near gas apparatus. Information included on this plan should not be referred to beyond a period of 28 days from the date of issue.

Report damage immediately – KEEP EVERYONE AWAY FROM THE AREA
0800 111 999

Low Pressure Mains

Medium Pressure Mains

Intermediate Pressure Mains

High Pressure Mains

LAs

GTs

Some Examples Of Plant Items

Valve

Syphon

Depth of Cover

Diameter Change

Material Change

Digsite: Line:

Area:



This plan is reproduced from or based on the OS map by Scotia Gas Networks plc, with the sanction of the controller of HM Stationary Office. Crown Copyright Reserved. Southern Gas – 100044373 and Scotland Gas – 100044366.

Warning: PDF designed for A3 colour print only with no page scaling.



High Pressure Gas Pipes within this vicinity

Contact Us
Mapping Enquiries:
All areas

General Enquiries:
All areas

Date Requested: 03/09/2021
Job Reference: 23169206
Site Location: 471818 104822
Requested by:
Miss Rebecca Dabbs
Your Scheme/Reference:
736036 Langstone Flood & Coastal
Exact Scales:
1:1000 Area or Circle dig site
1:1000 Line dig site

This plan shows the location of those pipes owned by Scotia Gas Networks (SGN) by virtue of being a licensed Gas Transporter (GT). Gas pipes owned by other GTs or third parties may also be present in this area but are not shown on this plan. Information with regard to such pipes should be obtained from the relevant owners. No warranties are given with regard to the accuracy of the information shown on this plan. Service pipes, valves, siphons, sub-connections etc. are not shown but their presence should be anticipated. You should be aware that a small percentage of our pipes/assets may be undergoing review and will temporarily be highlighted in yellow. If your proposed works are close to one of these pipes, you should contact the SGN Safety Admin Team on 0800 912 1722 for advice. No liability of any kind whatsoever is accepted by SGN or its agents, servants or sub-contractors for any error or omission contained herein. Safe digging practices, in accordance with HS (G)47, must be used to verify and establish the actual position of mains, pipes, services and other apparatus on site before any mechanical plant is used. It is your responsibility to ensure that plant location information is provided to all persons (whether direct labour or sub-contractors) working for you on or near gas apparatus. Information included on this plan should not be referred to beyond a period of 28 days from the date of issue.

Report damage immediately – KEEP EVERYONE AWAY FROM THE AREA
0800 111 999

Low Pressure Mains

Medium Pressure Mains

Intermediate Pressure Mains

High Pressure Mains

LAs

GTs

Some Examples Of Plant Items

Valve

Syphon

Depth of Cover

Diameter Change

Material Change


Digsite: Line:

Area:



This plan is reproduced from or based on the OS map by Scotia Gas Networks plc, with the sanction of the controller of HM Stationery Office. Crown Copyright Reserved. Southern Gas – 100044373 and Scotland Gas – 100044366.

High Pressure Gas Pipes within this vicinity

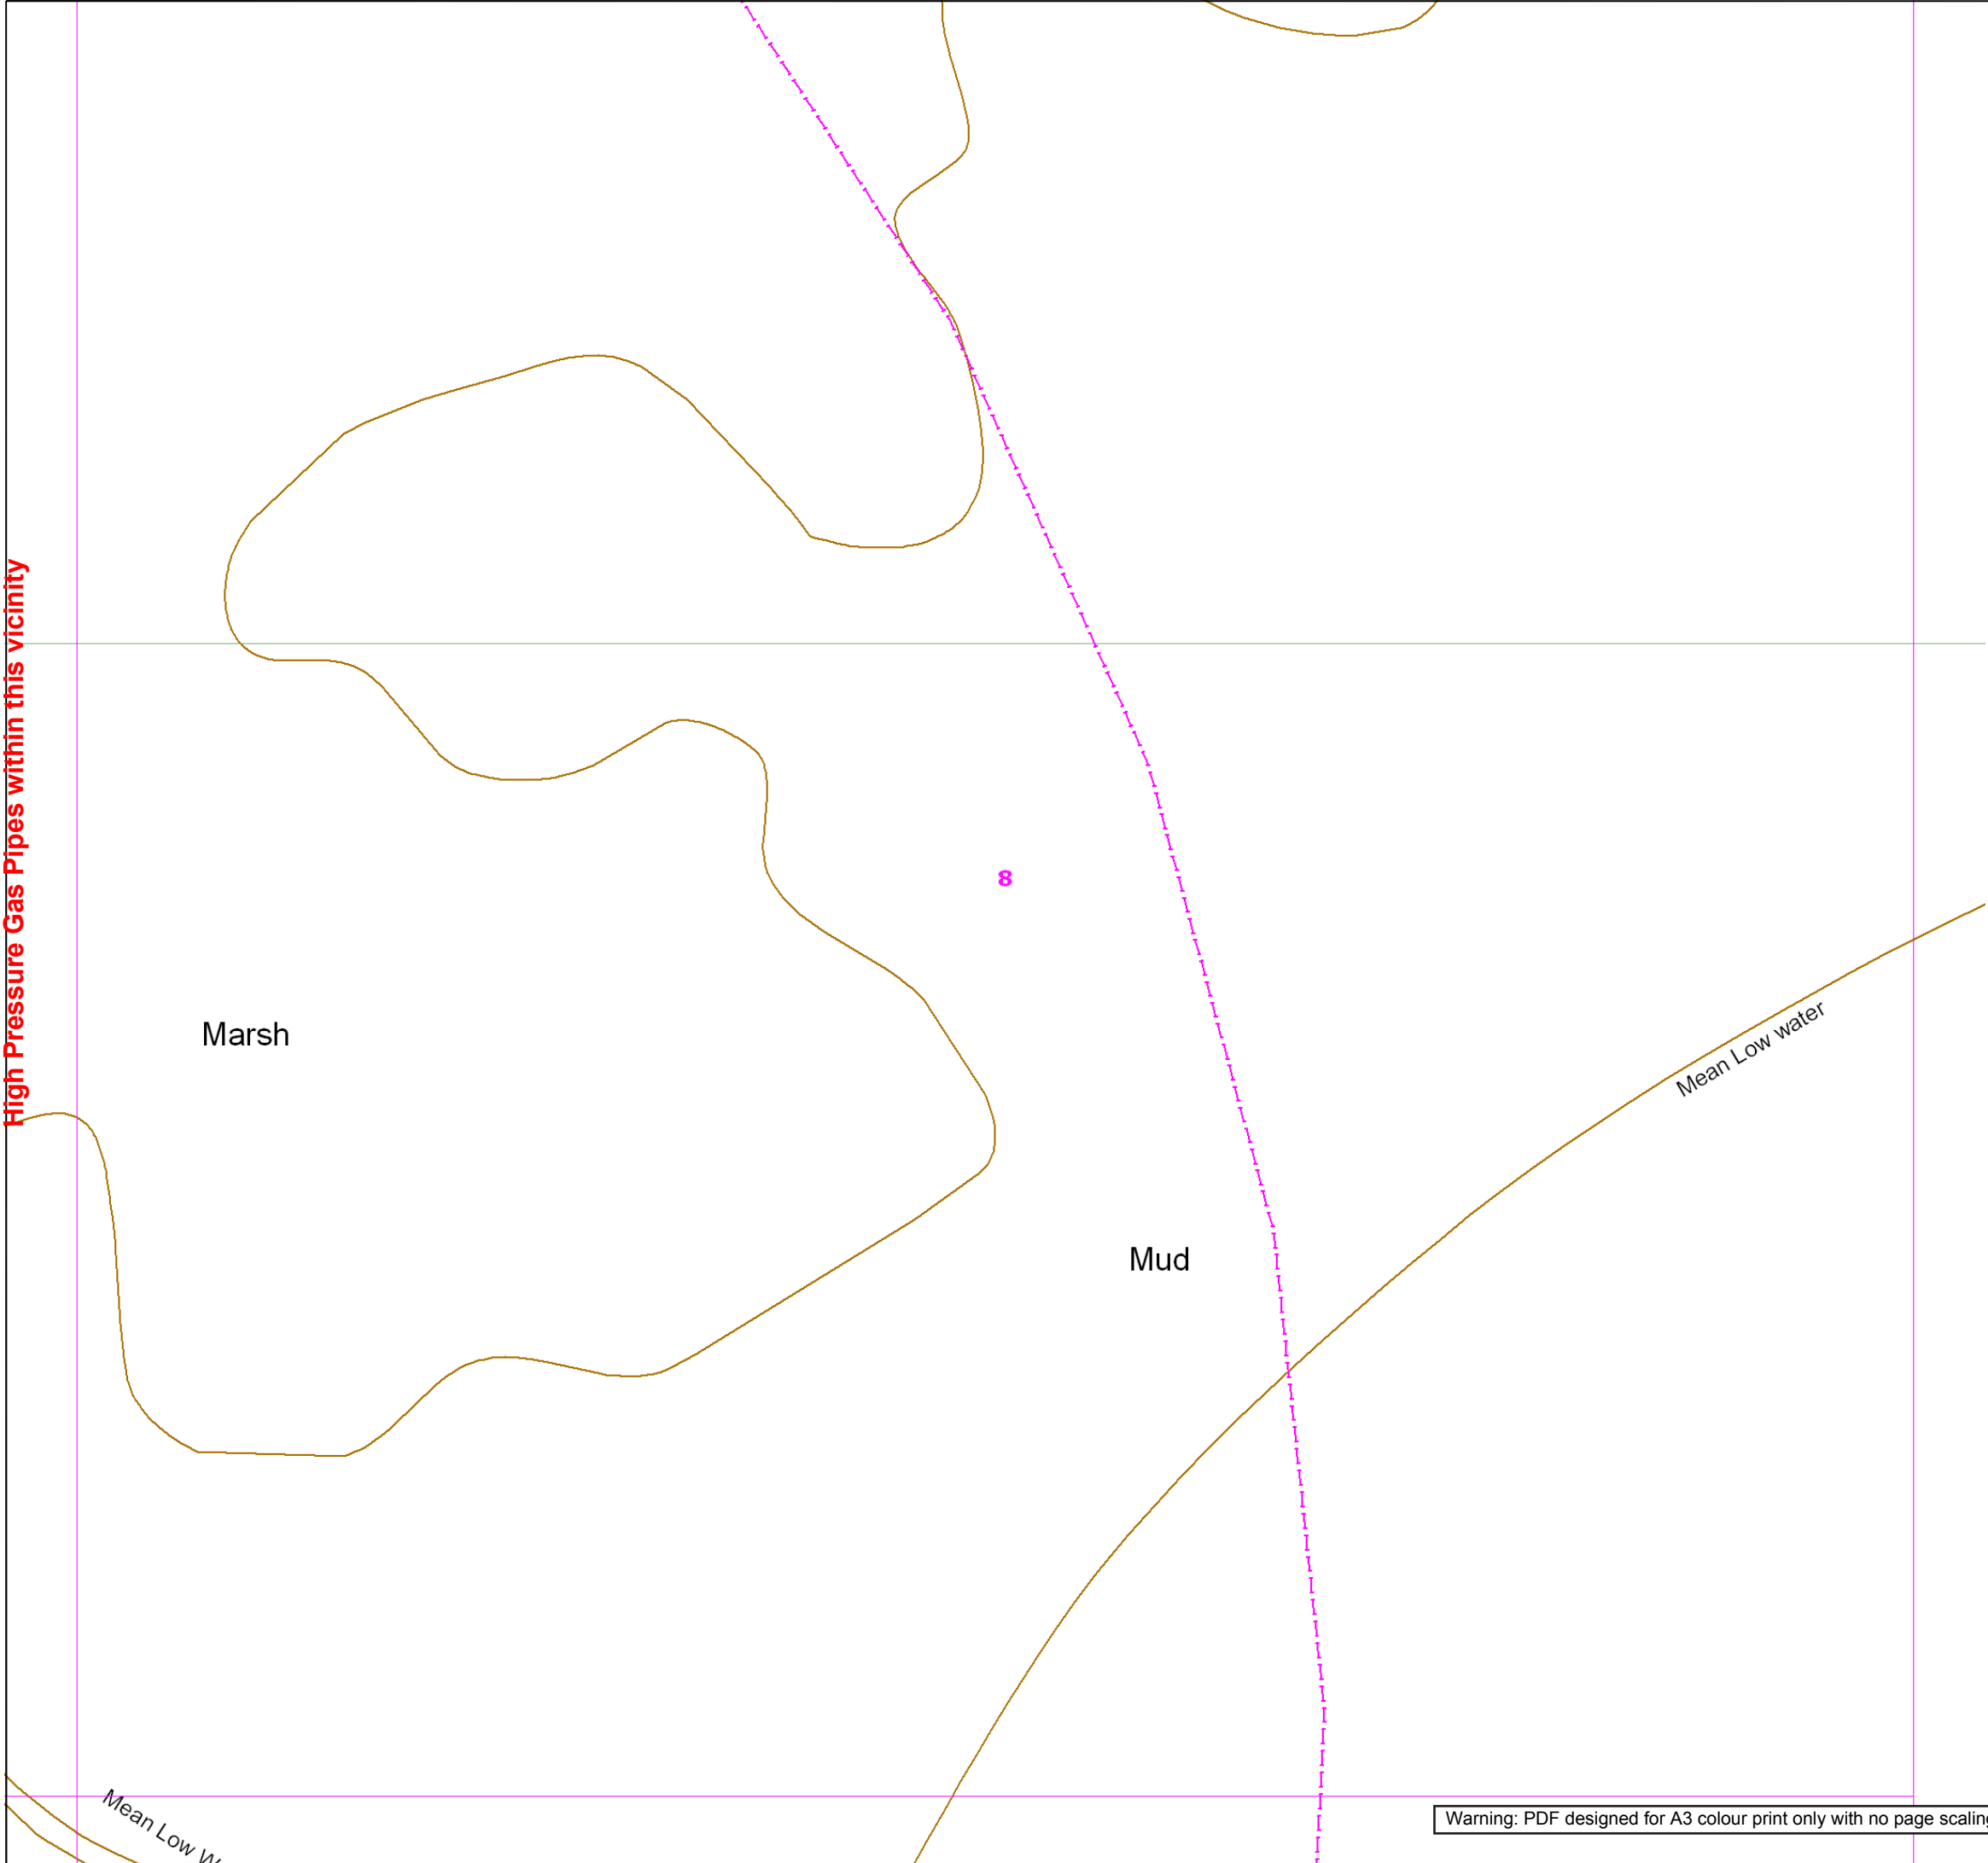

SGN
Your gas. Our network.

Contact Us

Mapping Enquiries:
All areas

General Enquiries:
All areas

Date Requested: 03/09/2021
Job Reference: 23169206
Site Location: 471818 104822
Requested by:
Miss Rebecca Dabbs
Your Scheme/Reference:
736036 Langstone Flood & CoastalCoastalCoastalCoastalCoastalCoastal
Exact Scales:
1:1000 Area or Circle dig site
1:1000 Line dig site

This plan shows the location of those pipes owned by Scotia Gas Networks (SGN) by virtue of being a licensed Gas Transporter (GT). Gas pipes owned by other GTs or third parties may also be present in this area but are not shown on this plan. Information with regard to such pipes should be obtained from the relevant owners. No warranties are given with regard to the accuracy of the information shown on this plan. Service pipes, valves, siphons, sub-connections etc. are not shown but their presence should be anticipated. You should be aware that a small percentage of our pipes/assets may be undergoing review and will temporarily be highlighted in yellow. If your proposed works are close to one of these pipes, you should contact the SGN Safety Admin Team on 0800 912 1722 for advice. No liability of any kind whatsoever is accepted by SGN or its agents, servants or sub-contractors for any error or omission contained herein. Safe digging practices, in accordance with HS (G)47, must be used to verify and establish the actual position of mains, pipes, services and other apparatus on site before any mechanical plant is used. It is your responsibility to ensure that plant location information is provided to all persons (whether direct labour or sub-contractors) working for you on or near gas apparatus. Information included on this plan should not be referred to beyond a period of 28 days from the date of issue.

Report damage immediately – KEEP EVERYONE AWAY FROM THE AREA
0800 111 999

Low Pressure Mains	
Medium Pressure Mains	
Intermediate Pressure Mains	
High Pressure Mains	
LAs	
GTs	
SSSIs	

Some Examples Of Plant Items


Valve		Syphon		Depth of Cover		Diameter Change		Material Change	
-------	--	--------	--	----------------	--	-----------------	--	-----------------	--

Digsite: Line: Area:



This plan is reproduced from or based on the OS map by Scotia Gas Networks plc, with the sanction of the controller of HM Stationery Office. Crown Copyright Reserved. Southern Gas – 100044373 and Scotland Gas – 100044366.

High Pressure Gas Pipes within this vicinity

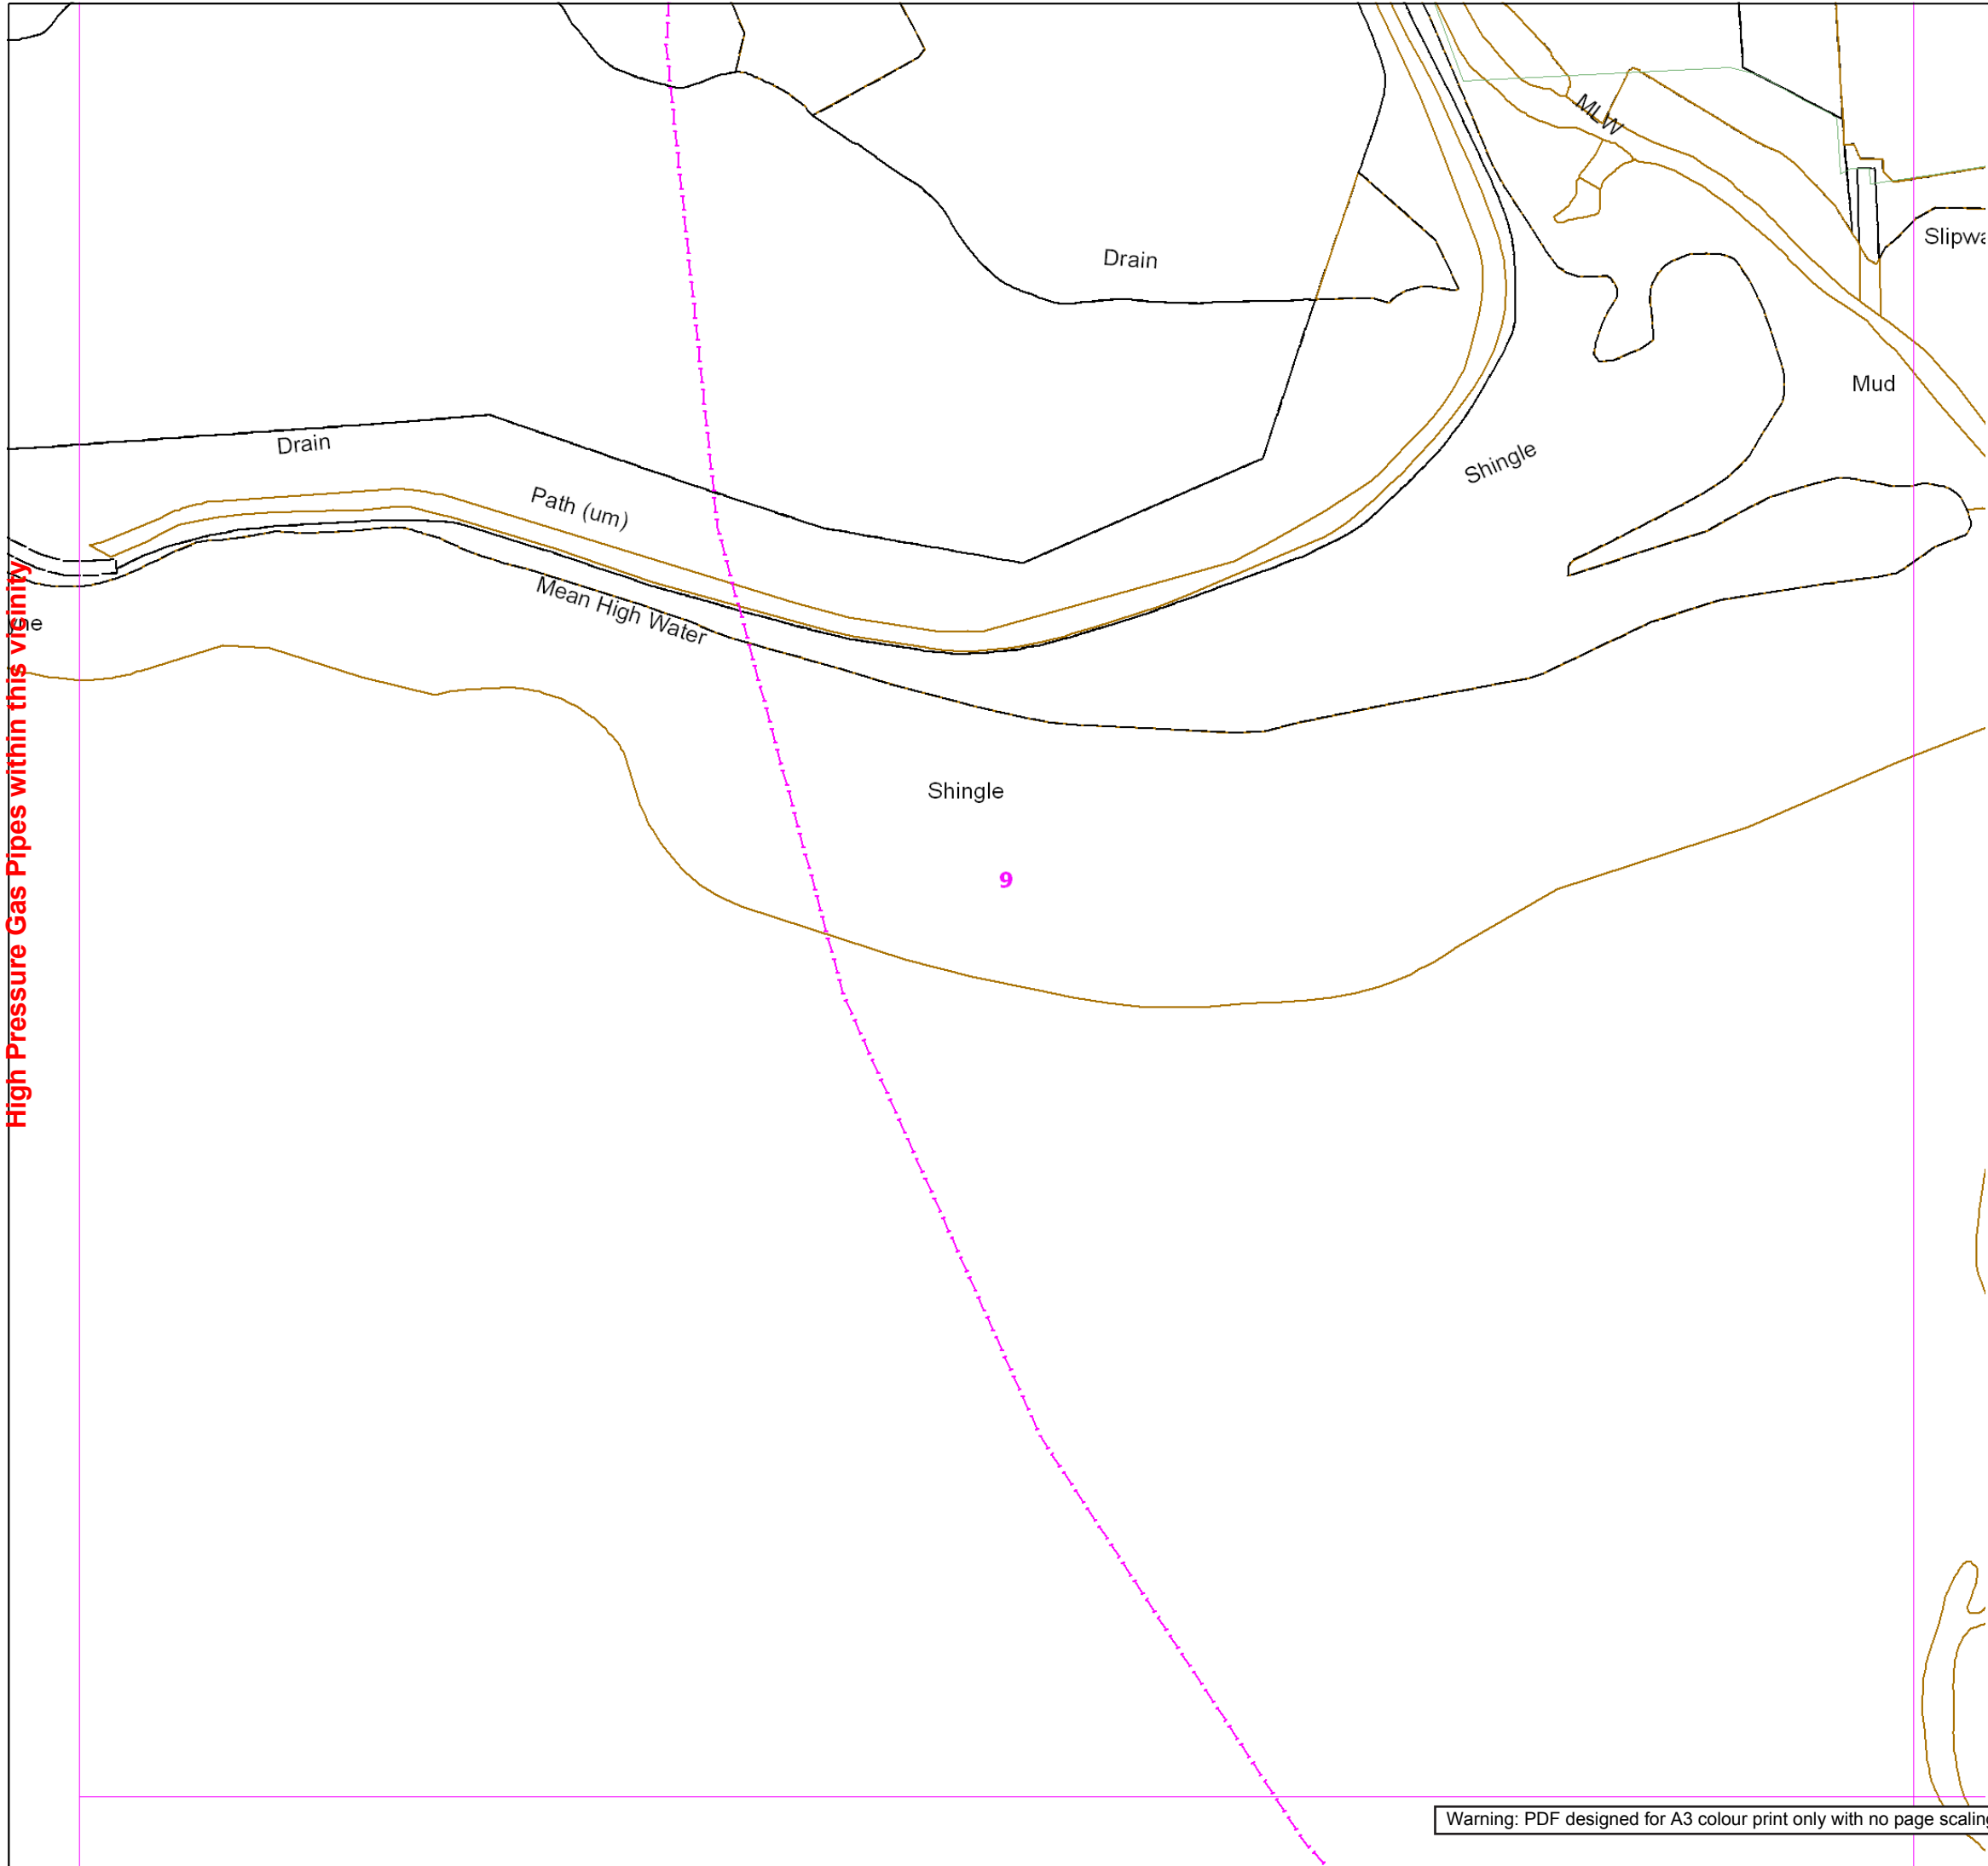

SGN
Your gas. Our network.

Contact Us

Mapping Enquiries:
All areas

General Enquiries:
All areas

Date Requested: 03/09/2021
Job Reference: 23169206
Site Location: 471818 104822
Requested by:
Miss Rebecca Dabbs
Your Scheme/Reference:
736036 Langstone Flood & Coastal
Exact Scales:
1:1000 Area or Circle dig site
1:1000 Line dig site

This plan shows the location of those pipes owned by Scotia Gas Networks (SGN) by virtue of being a licensed Gas Transporter (GT). Gas pipes owned by other GTs or third parties may also be present in this area but are not shown on this plan. Information with regard to such pipes should be obtained from the relevant owners. No warranties are given with regard to the accuracy of the information shown on this plan. Service pipes, valves, siphons, sub-connections etc. are not shown but their presence should be anticipated. You should be aware that a small percentage of our pipes/assets may be undergoing review and will temporarily be highlighted in yellow. If your proposed works are close to one of these pipes, you should contact the SGN Safety Admin Team on 0800 912 1722 for advice. No liability of any kind whatsoever is accepted by SGN or its agents, servants or sub-contractors for any error or omission contained herein. Safe digging practices, in accordance with HS (G)47, must be used to verify and establish the actual position of mains, pipes, services and other apparatus on site before any mechanical plant is used. It is your responsibility to ensure that plant location information is provided to all persons (whether direct labour or sub-contractors) working for you on or near gas apparatus. Information included on this plan should not be referred to beyond a period of 28 days from the date of issue.

Report damage immediately – KEEP EVERYONE AWAY FROM THE AREA
0800 111 999

Low Pressure Mains

Medium Pressure Mains

Intermediate Pressure Mains

High Pressure Mains

LAs

GTs



SSSIs



Some Examples Of Plant Items


Valve  Syphon  Depth of Cover  Diameter Change  Material Change 

Digsite: Line:  Area: 



This plan is reproduced from or based on the OS map by Scotia Gas Networks plc, with the sanction of the controller of HM Stationery Office. Crown Copyright Reserved. Southern Gas – 100044373 and Scotland Gas – 100044366.

Warning: PDF designed for A3 colour print only with no page scaling.

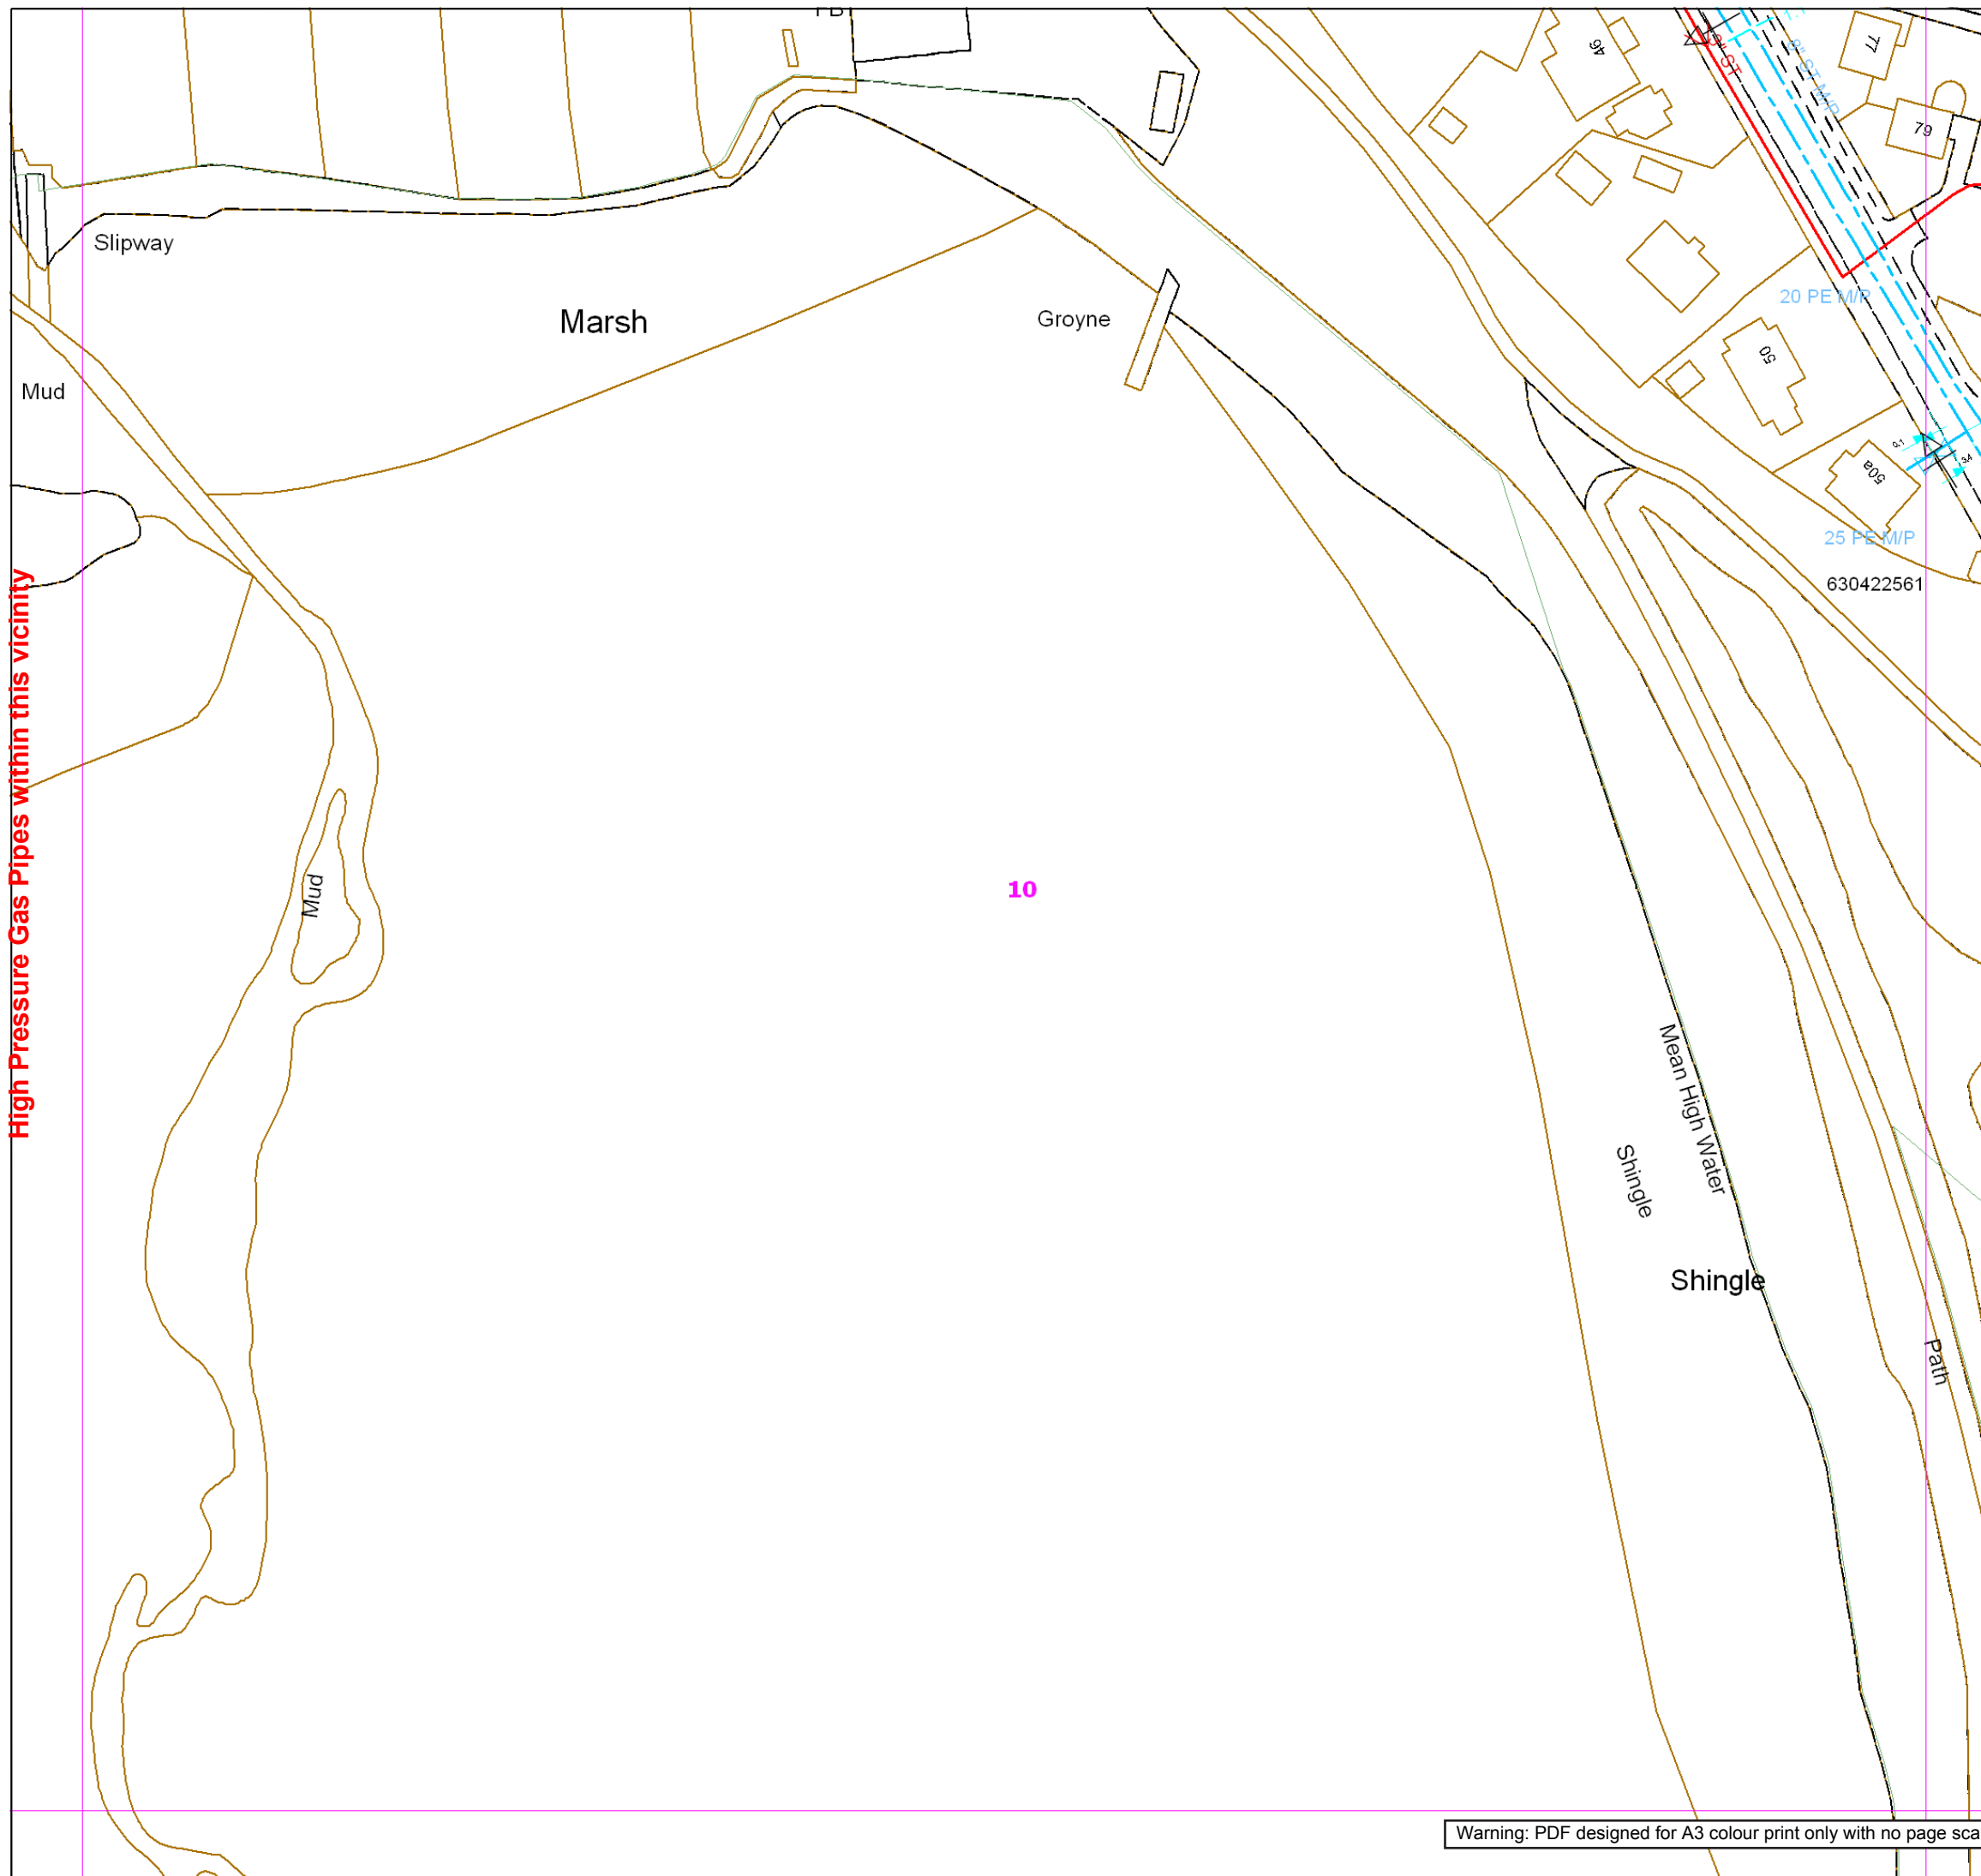

Your gas. Our network.

Contact Us

Mapping Enquiries:
All areas

General Enquiries:
All areas

Date Requested: 03/09/2021
Job Reference: 23169206
Site Location: 471818 104822
Requested by:
Miss Rebecca Dabbs
Your Scheme/Reference:
736036 Langstone Flood & Co
Exact Scales:
1:1000 Area or Circle dig site
1:1000 Line dig site

This plan shows the location of those pipes owned by Scotia Gas Networks (SGN) by virtue of being a licensed Gas Transporter (GT). Gas pipes owned by other GTs or third parties may also be present in this area but are not shown on this plan. Information with regard to such pipes should be obtained from the relevant owners. No warranties are given with regard to the accuracy of the information shown on this plan. Service pipes, valves, siphons, sub-connections etc. are not shown but their presence should be anticipated. You should be aware that a small percentage of our pipes/assets may be undergoing review and will temporarily be highlighted in yellow. If your proposed works are close to one of these pipes, you should contact the SGN Safety Admin Team on 0800 912 1722 for advice. No liability of any kind whatsoever is accepted by SGN or its agents, servants or sub-contractors for any error or omission contained herein. Safe digging practices, in accordance with HS (G)47, must be used to verify and establish the actual position of mains, pipes, services and other apparatus on site before any mechanical plant is used. It is your responsibility to ensure that plant location information is provided to all persons (whether direct labour or sub-contractors) working for you on or near gas apparatus. Information included on this plan should not be referred to beyond a period of 28 days from the date of issue.

Report damage immediately – KEEP EVERYONE AWAY FROM THE AREA
0800 111 999

Low Pressure Mains

Medium Pressure Mains

Intermediate Pressure Mains

High Pressure Mains

LAS

GTs

SSSIs

Some Examples Of Plant Items

Valve  Syphon  Depth of Cover  Diameter Change  Material Change


Digsite: Line:  Area: 



before **u**dic

This plan is reproduced from or based on the OS map by Scotia Gas Networks plc, with the sanction of the controller of HM Stationery Office. Crown Copyright Reserved. Southern Gas – 100044373 and Scotland Gas – 100044366.

Warning: PDF designed for A3 colour print only with no page scaling.

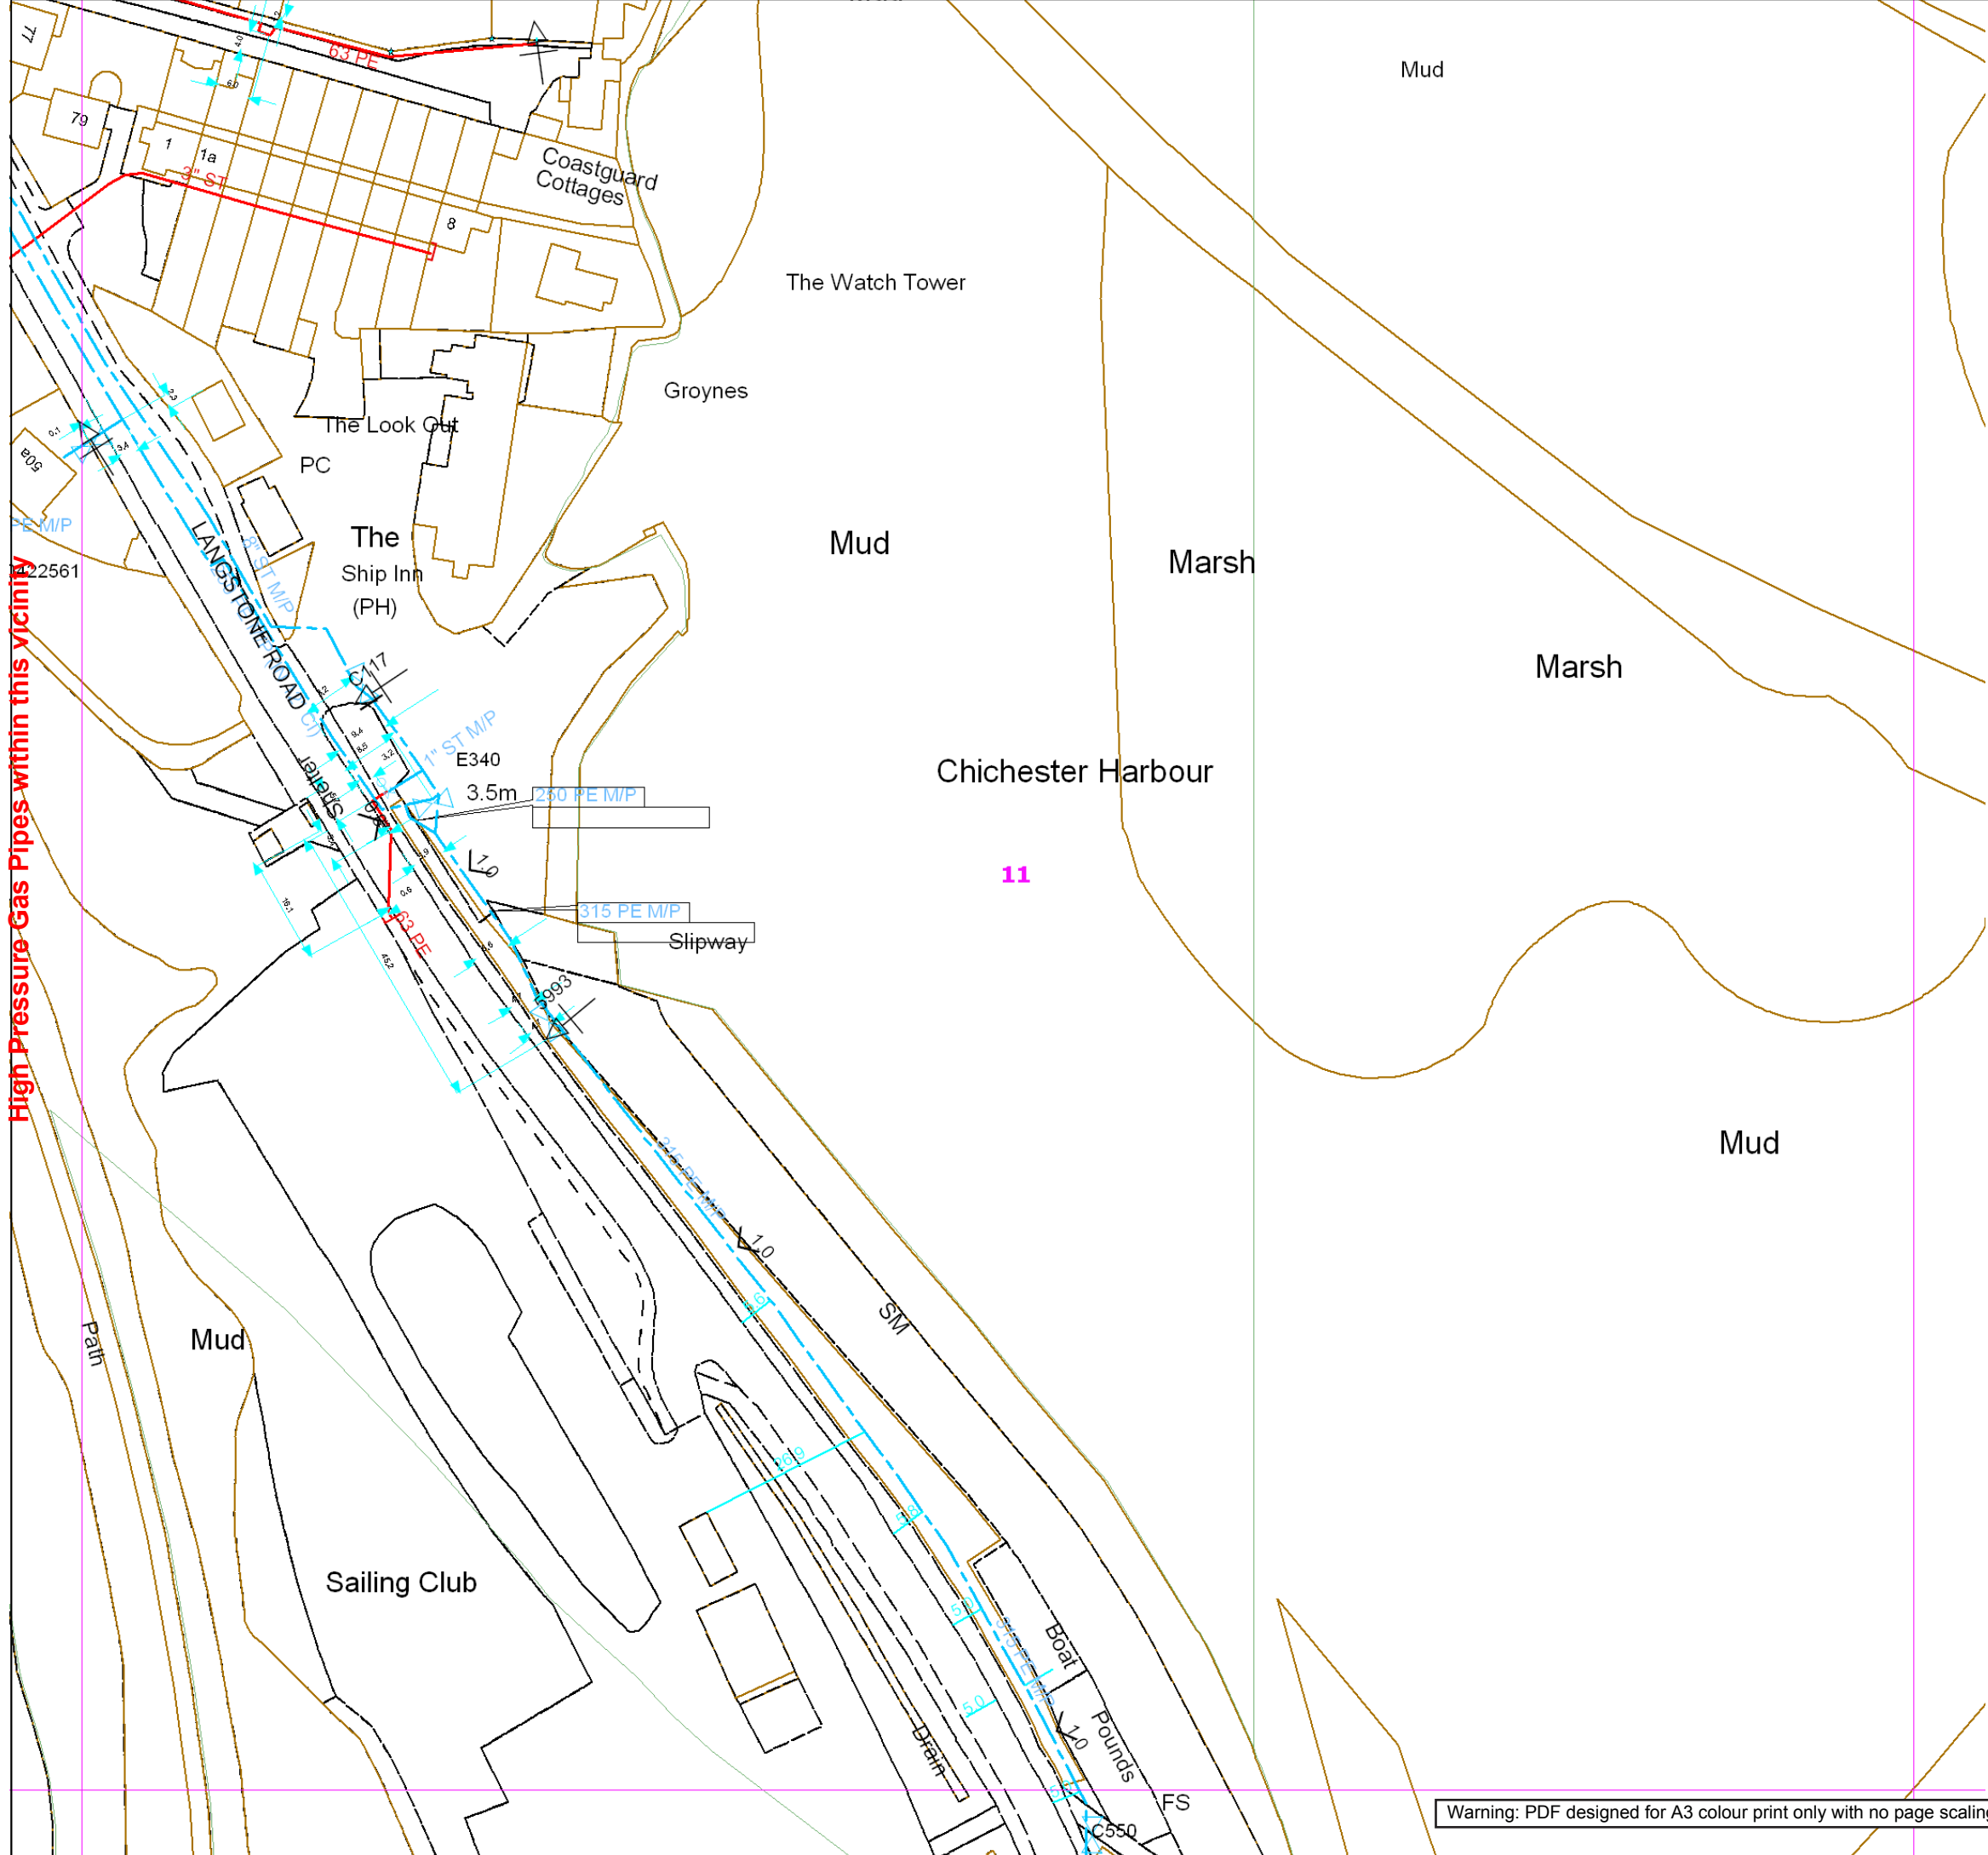



Contact Us
Mapping Enquiries:
All areas

General Enquiries:
All areas

Date Requested: 03/09/2021
Job Reference: 23169206
Site Location: 471818 104822
Requested by:
Miss Rebecca Dabbs
Your Scheme/Reference:
736036 Langstone Flood & Coastal
Exact Scales:
1:1000 Area or Circle dig site
1:1000 Line dig site

This plan shows the location of those pipes owned by Scotia Gas Networks (SGN) by virtue of being a licensed Gas Transporter (GT). Gas pipes owned by other GTs or third parties may also be present in this area but are not shown on this plan. Information with regard to such pipes should be obtained from the relevant owners. No warranties are given with regard to the accuracy of the information shown on this plan. Service pipes, valves, siphons, sub-connections etc. are not shown but their presence should be anticipated. You should be aware that a small percentage of our pipes/assets may be undergoing review and will temporarily be highlighted in yellow. If your proposed works are close to one of these pipes, you should contact the SGN Safety Admin Team on 0800 912 1722 for advice. No liability of any kind whatsoever is accepted by SGN or its agents, servants or sub-contractors for any error or omission contained herein. Safe digging practices, in accordance with HS (G)47, must be used to verify and establish the actual position of mains, pipes, services and other apparatus on site before any mechanical plant is used. It is your responsibility to ensure that plant location information is provided to all persons (whether direct labour or sub-contractors) working for you on or near gas apparatus. Information included on this plan should not be referred to beyond a period of 28 days from the date of issue.

Report damage immediately – KEEP EVERYONE AWAY FROM THE AREA
0800 111 999

Low Pressure Mains

Medium Pressure Mains


Intermediate Pressure Mains

High Pressure Mains

LAs

GTs

SSSIs

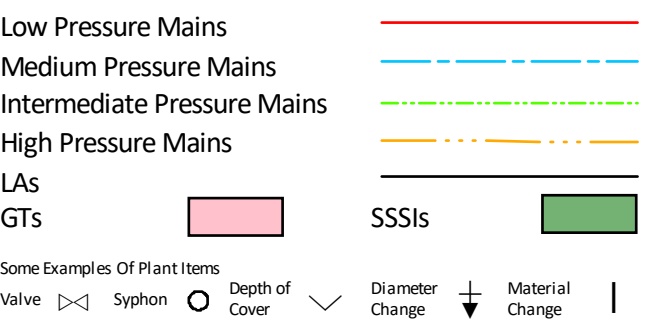

Some Examples Of Plant Items
Valve  Syphon  Depth of Cover  Diameter Change  Material Change 

Digsite: Line:  Area: 



This plan is reproduced from or based on the OS map by Scotia Gas Networks plc, with the sanction of the controller of HM Stationary Office. Crown Copyright Reserved. Southern Gas – 100044373 and Scotland Gas – 100044366.

High Pressure Gas Pipes within this vicinity

Mud

Langstone Harbour

13

Mud

Mud



SGN
Your gas. Our network.

Contact Us

Mapping Enquiries:
All areas

General Enquiries:
All areas

Date Requested: 03/09/2021
Job Reference: 23169206
Site Location: 471818 104822
Requested by:
Miss Rebecca Dabbs
Your Scheme/Reference:
736036 Langstone Flood & Coastal
Exact Scales:
1:1000 Area or Circle dig site
1:1000 Line dig site

This plan shows the location of those pipes owned by Scotia Gas Networks (SGN) by virtue of being a licensed Gas Transporter (GT). Gas pipes owned by other GTs or third parties may also be present in this area but are not shown on this plan. Information with regard to such pipes should be obtained from the relevant owners. No warranties are given with regard to the accuracy of the information shown on this plan. Service pipes, valves, siphons, sub-connections etc. are not shown but their presence should be anticipated. You should be aware that a small percentage of our pipes/assets may be undergoing review and will temporarily be highlighted in yellow. If your proposed works are close to one of these pipes, you should contact the SGN Safety Admin Team on 0800 912 1722 for advice. No liability of any kind whatsoever is accepted by SGN or its agents, servants or sub-contractors for any error or omission contained herein. Safe digging practices, in accordance with HS (G)47, must be used to verify and establish the actual position of mains, pipes, services and other apparatus on site before any mechanical plant is used. It is your responsibility to ensure that plant location information is provided to all persons (whether direct labour or sub-contractors) working for you on or near gas apparatus. Information included on this plan should not be referred to beyond a period of 28 days from the date of issue.

Report damage immediately – KEEP EVERYONE AWAY FROM THE AREA
0800 111 999

Low Pressure Mains

Medium Pressure Mains

Intermediate Pressure Mains

High Pressure Mains

LAs

GTs



SSSIs



Some Examples Of Plant Items

Valve



Syphon



Depth of Cover



Diameter Change



Material Change



Digsite:

Line:




Area:



Lineasearch
before u dig

This plan is reproduced from or based on the OS map by Scotia Gas Networks plc, with the sanction of the controller of HM Stationery Office. Crown Copyright Reserved. Southern Gas – 100044373 and Scotland Gas – 100044366.

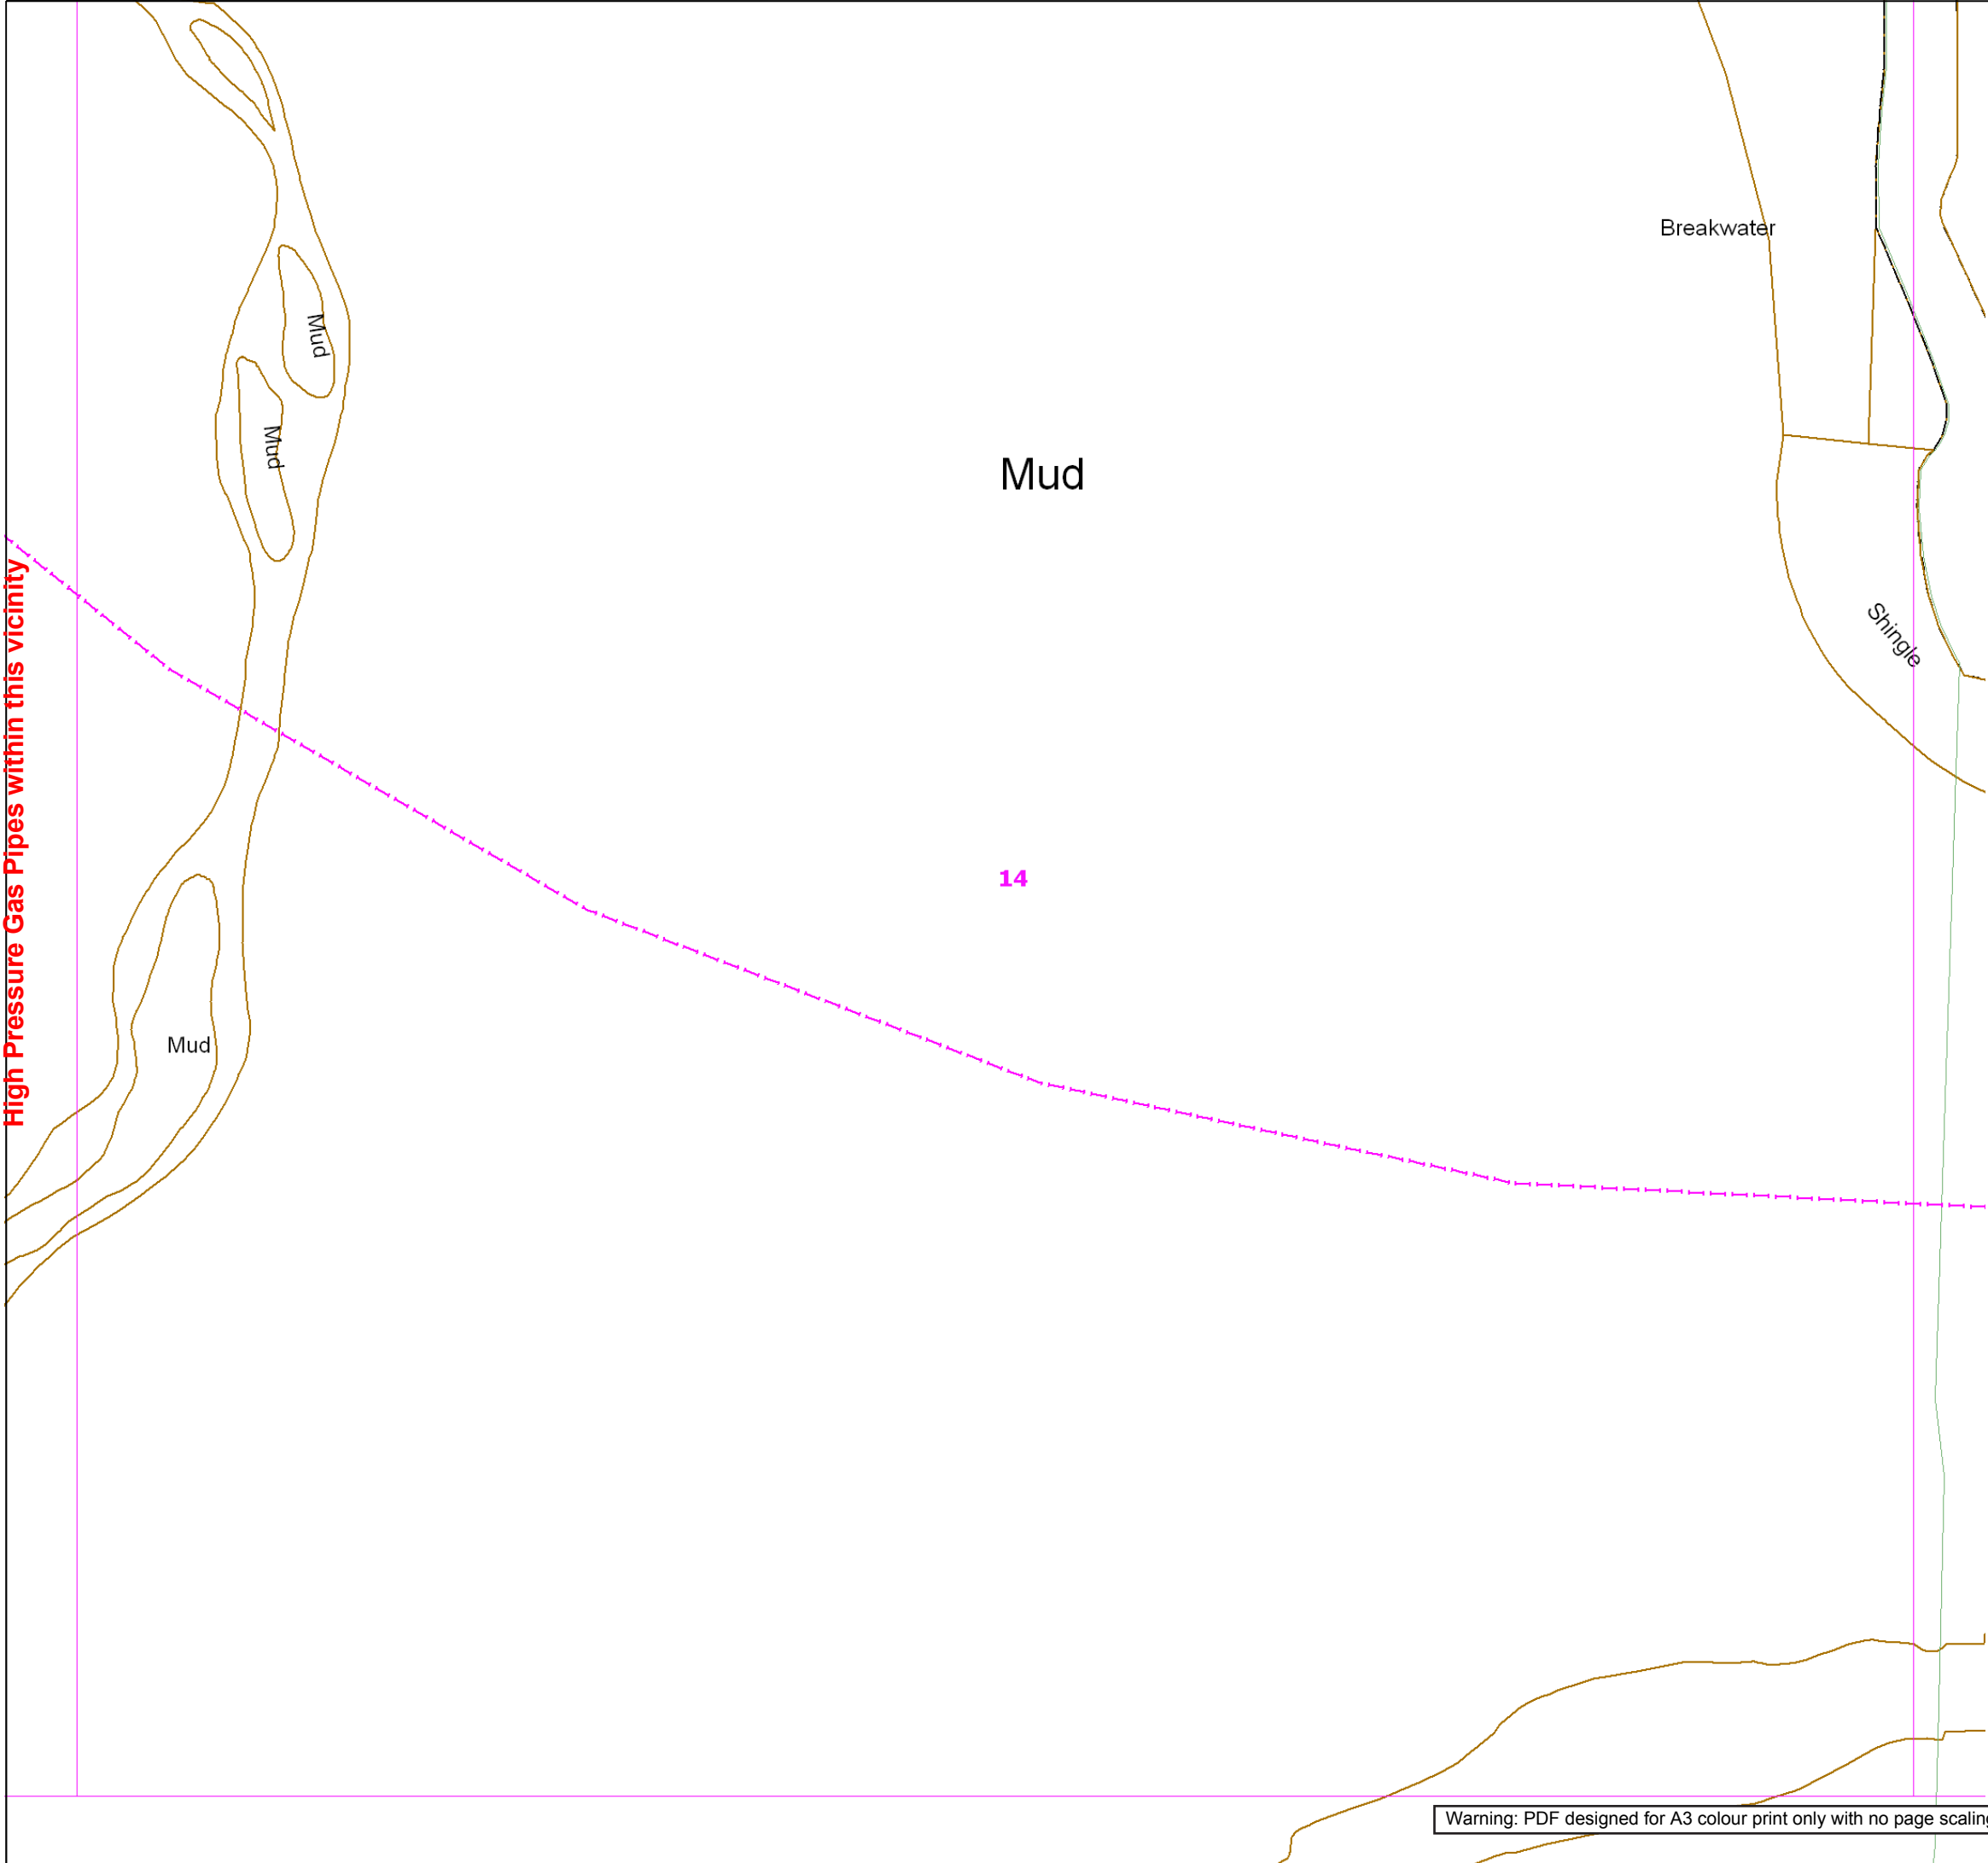

SGN

Your gas. Our network.

Contact Us
Mapping Enquiries:
All areas

General Enquiries:
All areas

Date Requested: 03/09/2021
Job Reference: 23169206
Site Location: 471818 104822
Requested by:
Miss Rebecca Dabbs
Your Scheme/Reference:
736036 Langstone Flood & Coastal
Exact Scales:
1:1000 Area or Circle dig site
1:1000 Line dig site

This plan shows the location of those pipes owned by Scotia Gas Networks (SGN) by virtue of being a licensed Gas Transporter (GT). Gas pipes owned by other GTs or third parties may also be present in this area but are not shown on this plan. Information with regard to such pipes should be obtained from the relevant owners. No warranties are given with regard to the accuracy of the information shown on this plan. Service pipes, valves, siphons, sub-connections etc. are not shown but their presence should be anticipated. You should be aware that a small percentage of our pipes/assets may be undergoing review and will temporarily be highlighted in yellow. If your proposed works are close to one of these pipes, you should contact the SGN Safety Admin Team on 0800 912 1722 for advice. No liability of any kind whatsoever is accepted by SGN or its agents, servants or sub-contractors for any error or omission contained herein. Safe digging practices, in accordance with HS (G)47, must be used to verify and establish the actual position of mains, pipes, services and other apparatus on site before any mechanical plant is used. It is your responsibility to ensure that plant location information is provided to all persons (whether direct labour or sub-contractors) working for you on or near gas apparatus. Information included on this plan should not be referred to beyond a period of 28 days from the date of issue.

Report damage immediately – KEEP EVERYONE AWAY FROM THE AREA
0800 111 999

Low Pressure Mains

Medium Pressure Mains

Intermediate Pressure Mains

High Pressure Mains

LAs

GTs

SSSIs

Some Examples Of Plant Items

Valve

Syphon

Depth of Cover

Diameter Change


Material Change

Digsite: Line:

Area:



This plan is reproduced from or based on the OS map by Scotia Gas Networks plc, with the sanction of the controller of HM Stationary Office. Crown Copyright Reserved. Southern Gas – 100044373 and Scotland Gas – 100044366.

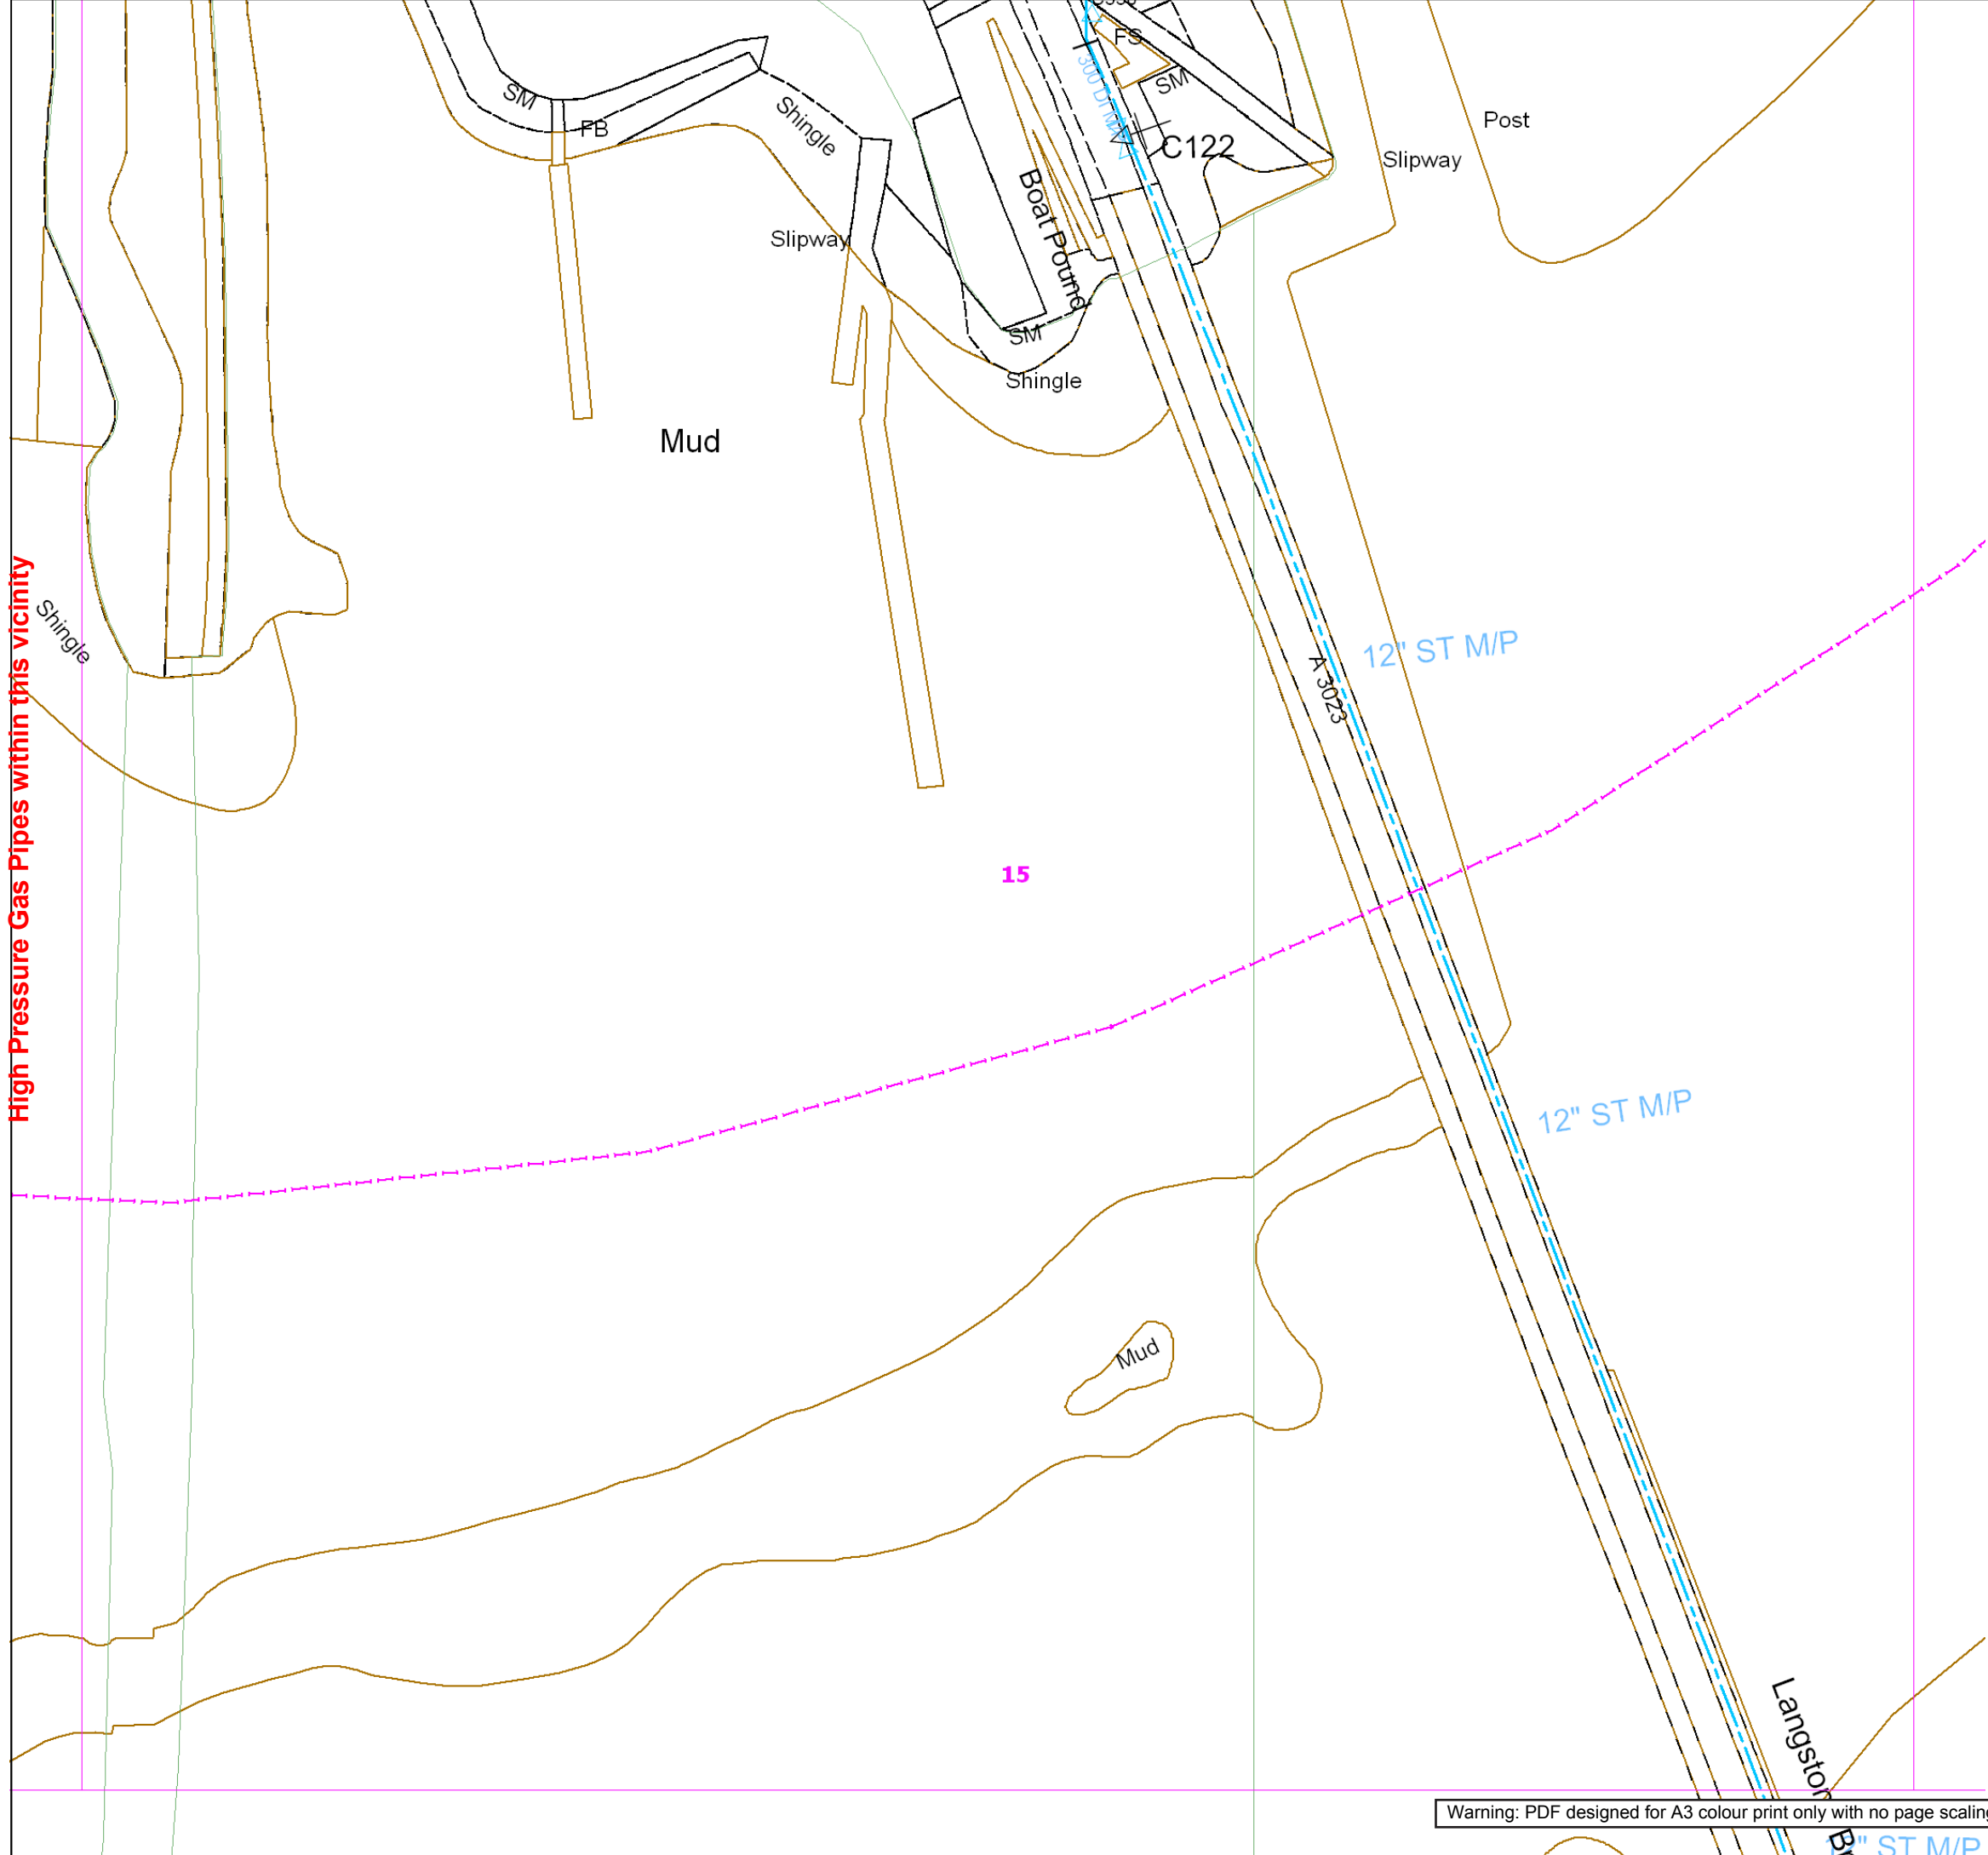

High Pressure Gas Pipes within this vicinity



Contact Us
Mapping Enquiries:
All areas

General Enquiries:
All areas

Date Requested: 03/09/2021
Job Reference: 23169206
Site Location: 471818 104822
Requested by:
Miss Rebecca Dabbs
Your Scheme/Reference:
736036 Langstone Flood & Coastal
Exact Scales:
1:1000 Area or Circle dig site
1:1000 Line dig site

This plan shows the location of those pipes owned by Scotia Gas Networks (SGN) by virtue of being a licensed Gas Transporter (GT). Gas pipes owned by other GTs or third parties may also be present in this area but are not shown on this plan. Information with regard to such pipes should be obtained from the relevant owners. No warranties are given with regard to the accuracy of the information shown on this plan. Service pipes, valves, siphons, sub-connections etc. are not shown but their presence should be anticipated. You should be aware that a small percentage of our pipes/assets may be undergoing review and will temporarily be highlighted in yellow. If your proposed works are close to one of these pipes, you should contact the SGN Safety Admin Team on 0800 912 1722 for advice. No liability of any kind whatsoever is accepted by SGN or its agents, servants or sub-contractors for any error or omission contained herein. Safe digging practices, in accordance with HS (G)47, must be used to verify and establish the actual position of mains, pipes, services and other apparatus on site before any mechanical plant is used. It is your responsibility to ensure that plant location information is provided to all persons (whether direct labour or sub-contractors) working for you on or near gas apparatus. Information included on this plan should not be referred to beyond a period of 28 days from the date of issue.

Report damage immediately – KEEP EVERYONE AWAY FROM THE AREA
0800 111 999

Low Pressure Mains

Medium Pressure Mains

Intermediate Pressure Mains

High Pressure Mains

LAs

GTs

SSSIs

Some Examples Of Plant Items

Valve

Syphon

Depth of Cover

Diameter Change

Material Change

Digsite:

 
Line:

Area:



This plan is reproduced from or based on the OS map by Scotia Gas Networks plc, with the sanction of the controller of HM Stationary Office. Crown Copyright Reserved. Southern Gas – 100044373 and Scotland Gas – 100044366.

2" ST M/P



Date Requested: 03/09/2021
Job Reference: 23169206
Site Location: 471818 104822
Requested by:
Miss Rebecca Dabbs
Your Scheme/Reference:
736036 Langstone Flood & CoastalCoastalCoastalCoastalCoastal
Exact Scales:
1:1000 Area or Circle dig site
1:1000 Line dig site

This plan shows the location of those pipes owned by Scotia Gas Networks (SGN) by virtue of being a licensed Gas Transporter (GT). Gas pipes owned by other GTs or third parties may also be present in this area but are not shown on this plan. Information with regard to such pipes should be obtained from the relevant owners. No warranties are given with regard to the accuracy of the information shown on this plan. Service pipes, valves, siphons, sub-connections etc. are not shown but their presence should be anticipated. You should be aware that a small percentage of our pipes/assets may be undergoing review and will temporarily be highlighted in yellow. If your proposed works are close to one of these pipes, you should contact the SGN Safety Admin Team on 0800 912 1722 for advice. No liability of any kind whatsoever is accepted by SGN or its agents, servants or sub-contractors for any error or omission contained herein. Safe digging practices, in accordance with HS (G)47, must be used to verify and establish the actual position of mains, pipes, services and other apparatus on site before any mechanical plant is used. It is your responsibility to ensure that plant location information is provided to all persons (whether direct labour or sub-contractors) working for you on or near gas apparatus. Information included on this plan should not be referred to beyond a period of 28 days from the date of issue.

Report damage immediately – KEEP EVERYONE AWAY FROM THE AREA
0800 111 999

Low Pressure Mains
 Medium Pressure Mains
 Intermediate Pressure Mains
 High Pressure Mains
 LAS
 GTs

SSSIs

Some Examples Of Plant Items

Valve		Syphon		Depth of Cover		Diameter Change		Material Change	
-------	---	--------	---	----------------	---	-----------------	---	-----------------	---

Digsite: Line:  Area: 



This plan is reproduced from or based on the OS map by Scotia Gas Networks plc, with the sanction of the controller of HM Stationery Office. Crown Copyright Reserved. Southern Gas – 100044373 and Scotland Gas – 100044366.

Warning: PDF designed for A3 colour print only with no page scaling.

Rebecca Dabbs

From: plantenquiryservice@gtc-uk.co.uk
Sent: 03 September 2021 14:37
To: Rebecca Dabbs
Subject: GTC Plant Enquiry - Ref- 2026718
Attachments: 2026718.png

GTC Apparatus Not Found In Search Area

Our Plant Enquiry Service Ref: 2026718

Your Enquiry Ref: 736036

Dear Rebecca,

Thank you for your enquiry concerning apparatus in the vicinity of your proposed work. GTC can confirm that we have no apparatus in the vicinity but please note that other asset owners may have and ensure all utility owners have been consulted. For your records, the search area is shown in the attached map.

Please note our assets now include those owned and operated by:

- GTC Pipelines Limited
- Independent Pipelines Limited
- Quadrant Pipelines Limited
- Electricity Network Company Limited
- Independent Power Networks Limited
- Independent Water Networks Limited
- Open Fibre Networks Limited
- Independent Community Heating Limited

If you have any queries or require any further information please do not hesitate to contact us.

Your sincerely,

GTC Plant Enquiry Service.

GTC
Synergy House
Woolpit Business Park
Woolpit
Bury St Edmunds
Suffolk, IP30 9UP
Tel: 01359 240363
plant.enquiries@gtc-uk.co.uk

NOTE:

This E-Mail originates from GTC, Synergy House, Woolpit Business Park, Woolpit, Bury St Edmunds, Suffolk, IP30 9UP

VAT Number: GB688 8971 40. Registered No: 029431.

DISCLAIMER

The information in this E-Mail and in any attachments is confidential and may be privileged. If you are not the intended recipient, please destroy this message, delete any copies held on your system and notify the sender immediately. You

should not retain, copy or use this E-Mail for any purpose, nor disclose all or any part of its content to any other person. Whilst we run antivirus software on Internet E-Mails, we are not liable for any loss or damage. The recipient is advised to run their own up to date antivirus software.

Thank you [WARNING: This email originated outside of RSK. DO NOT CLICK links, attachments or respond unless you recognise the sender and are certain that the content is safe]

These general notes and precautions are guidance for contractors or other third party organisations and apply when working adjacent to Portsmouth Waters distribution assets.

They don't replace or change any rights held by the Company by virtue of the Water Industry Act 1991 or any deed of grant of easement for the length concerned.

If requested Portsmouth Water will provide approximate locations of water mains according to our records. Our records do not usually show positions of water service pipes from the water main to properties. They may not be accurate or complete and no company or person will be given dispensation from liability for damaging our apparatus for the reason of the actual positions or depths being different from those indicated on plans. Portsmouth Water staff or contractors will visit any site, given reasonable notice to help in the location of our apparatus, and can offer advice on precautions that we may require to avoid any damage.

To satisfy safe working conditions adjacent to any of our apparatus you should comply with the following guidance:

All our water apparatus must be located by hand digging before the use of any mechanical plant to excavate.

- As construction work progresses where heavy plant may have to cross the line of a water main, and that water main is not under an adequate standard of carriageway, crossing points should be sufficiently reinforced with sleepers or some other suitable material as necessary. All crossing points must be clearly indicated and other places where crossings could be made should be prevented. This is more apparent where our water mains cross rural areas.
- If you propose to use piling within 20m of any water pipe, Portsmouth Water must be consulted so that we can survey the area.
- Where any excavations adjacent to any water pipe affects the support, that pipe must be adequately supported to our satisfaction.
- Any backfilled trenches parallel to or crossing a pipe must be compacted sufficiently to prevent any subsidence which could cause damage to the main. In some instances permanent support may be required to support a pipe exposed over an excessive length prior to backfilling. We do not allow concrete backfill to come into contact with any pipe.
- A minimum clearance of 300mm must be provided between any plant being installed to allow repair and maintenance, whether the plant be parallel or crossing the water pipe. No manholes or chambers will be built over or round our apparatus or pipes.
- Where Portsmouth Waters apparatus is damaged, even any special wrapping you must notify us so we are able to make the damage good, no matter how minor that damage is. All damage repairs will be charged to the person or company responsible. Leave the trench open so we are able to repair our apparatus speedily.
- If leakage is found or caused you must inform Portsmouth Water immediately, leave the trench open so we may repair the damaged apparatus.
- Where your proposed work will involve altering existing levels over our water mains you must inform us. We will require specific locations and details of the changes to ground levels. This may require a diversion of our apparatus for which there will be a charge. In some circumstances we may require that our apparatus remains where it is. Any surface boxes must be either lowered or raised accordingly. We may give you permission to compete this work. Under no circumstances are our boxes to be left buried or raised above the finished ground level. If any damage occurs as a result of your work, the repairs will be fully rechargeable back to you.

Tree planting near our Water Mains.

- Cherry, willow and poplar trees have extensive tree root systems and must not be planted within 10m of any water main.
- Other various species of trees such as evergreen, ash, beech, birch, elm, horse chestnut, lime, oak, sycamore may be allowed to be planted slightly nearer, however they must not be planted within 5m of our apparatus. More general advice can be obtained from contacting us.
- We must have a clear path maintained for inspection, repairs and maintenance, therefore we do not recommend the planting of shrubs and bushes within one meter of the pipeline.
- In instances where plants are to be used for screening purposes you should contact our office for advice. Consideration will be given to shallow rooting species such as elder, hazel, privet etc. Soft fruit such as black currant, raspberries and gooseberries will also be considered.

Contact Us;

Portsmouth Water Limited, PO Box 8, West Street, Havant, Hampshire, PO9 1LG.
e-mail us at: asset.enquiries@portsmouthwater.co.uk
call us on; (023) 9249 9888 or, (023) 9244 9082

Our normal hours of business Monday to Friday 8:30am – 4:30

In an emergency contact our 24 hour Emergency Operations Centre on 023 9247 7999.

These conditions are guidance for contractors or other third party organisations in order to reduce the risk of damage to any trunk water mains and the following liability for such damage.

They don't replace or change any rights held by the Company by virtue of the Water Industry Act 1991 or any deed of grant of easement for the length concerned.

No work whatsoever shall commence on or adjacent to any trunk water main before full consent has been granted by Portsmouth Water regarding the process in which the work shall be progressed and completed.

At least 10 working days' notice will be given of any intention of such works.

Our normal hours of business Monday to Friday 8:30am – 4:30

In an emergency contact our 24 hour Emergency Operations Centre on 023 9247 7999.

No building of any description shall be erected on or adjacent to the pipeline. No materials including spoil shall be stored on or adjacent to the pipeline and access to and along the route of the pipeline shall be kept clear and unrestricted at all times. No trees shall be planted or allowed to grow on or adjacent to the route of the pipeline.

Any pipes, drains or sewers crossing over the pipeline shall be laid in steel or ductile iron (or other suitable material) and shall cross as near as possible to 90° to the line of the main. A minimum of 300mm (12") of clearance must be given to any crossing above or below the pipeline.

Excavation around or beneath the conduit or pipeline must be completed by hand and great care exercised to ensure that any protective wrapping is not damaged. Excavations shall be fully supported and shall be backfilled to the satisfaction of Portsmouth Water. The Company reserves the right to stop all work on or adjacent to the pipeline which, in the opinion of its Officers, places the main or its employees at risk. As a consequence of such action, the Company will not accept any claims for damage.

Fences crossing the route of the pipeline should be as near as possible to 90° to the line of the main. Proposals for new fence crossings shall be submitted to the Company for approval, any such work shall not commence until approval granted.

Any proposed alterations to existing ground levels on or adjacent to the pipeline must be agreed and approved by Portsmouth Water.

The movement of vehicles and plant of a total weight exceeding 6 tonnes across the unprotected pipeline is forbidden. The repetitive movement of vehicles or plant of any weight over the unprotected main is forbidden. Where access is required at agreed positions the following protection shall be provided:

For axle loads exceeding 3 tonnes but not exceeding 10 tonnes

Vehicle crossing points over the route of the pipeline shall consist of substantial timber baulks 200mm (8") minimum section capable of spanning the pipeline, supported on timber baulks laid parallel with the aqueduct and placed not less than 2.5 metres (8ft) on each side of the centreline. (Other agreed protection may be considered). In the case of multiple pipelines, the timber baulks shall be additionally supported on timbers 300mm (12") minimum section laid in parallel to and between each pipeline. (Other agreed suitable protection may be considered).

For axle loads exceeding 10 tonnes.

Where heavy plant or vehicles with axle loads exceeding 10 tonnes require to cross the pipeline, special consideration must be given to the circumstances of each individual case. Where necessary, a single span bridge of the Bailey type will be required to span the pipeline.

All crossings must be securely fenced on each side so that access is limited to the protected areas.

Any permanent access crossing the pipeline shall be in a position approved by the Company and shall be adequately reinforced to prevent any damage.

Persons or their contractors working on or adjacent to the pipeline will be required to indemnify the Company for the full cost of any damage caused to its installations and for any costs, charges and expenses resulting from these operations.

Contact Us;

Portsmouth Water Limited, PO Box 8, West Street, Havant, Hampshire, PO9 1LG.

e-mail us at: asset.enquiries@portsmouthwater.co.uk

call us on; **(023) 9249 9888 or, (023) 9244 9082**

Our normal hours of business Monday to Friday 8:30am – 4:30

Our Ref: 23169206 Your Ref: 736036 Langstone Flood & Coastal

Friday, 03 September 2021

Rebecca Dabbs
18 Frogmore Road
Hemel Hempstead
Hertfordshire
HP3 9RT

Dear Rebecca Dabbs

Thank you for your enquiry dated Friday, 03 September 2021

Please find an extract from our mains records for your proposed work area, any SGN assets are described in the map legend.

There are high pressure pipelines in the vicinity of your proposed works. We have sent a copy of your correspondence to our local engineer who will be in contact within the next ten working days. For your safety, it is essential that no work or crossing of this high pressure pipeline is carried out until a detailed consultation has taken place.

This mains record only shows the pipes owned by SGN in our role as a Licensed Gas Transporter (GT). Please note that privately owned gas pipes or ones owned by other GTs may be present in this area and information regarding those pipes needs to be requested from the owners. If we know of any other pipes in the area we will note them on the plans as a shaded area and/or a series of x's.

The information shown on this plan is given without obligation or warranty and the accuracy cannot be guaranteed. Service pipes, valves, siphons, stub connections etc. are not shown but their presence should be anticipated. Your attention is drawn to the information and disclaimer on these plans. The information included on the plan is only valid for 28 days.

Please note there may be additional gas pipes (low pressure, medium pressure, etc.) shown on the mains record. There should be no mechanical excavations taking place above or near the gas main. You should confirm the exact position of the main using hand dug trial holes.

A colour copy of these plans and the gas safety advice booklet enclosed should be passed to the senior person on site in order to prevent damage to our plant and potential direct or consequential costs to your organisation.

Safe digging practices in accordance with HSE publication HSG47 "Avoiding Danger from Underground Services" must be used to verify and establish the actual position of the mains, pipes, services and other apparatus on site before any mechanical plant is used. It is your responsibility to ensure that this information is provided to all relevant people (direct labour or contractors) working for you on or near gas pipes.

It must be stressed that both direct and consequential damage to gas plant can be dangerous for your employees and the general public and repairs to any such damage will incur a charge. Your works should be carried out in such a manner that we are able to gain access to our apparatus throughout the duration of your operations.



For Planning applications – There are high pressure pipelines in the vicinity of your proposed work area. SGN formally object to this planning application until such time as a detail consultation has taken place.

If you require any further information please do not hesitate to contact us.

Yours sincerely,

The Safety Admin Team

For more information, visit our Dig Safely pages on sgn.co.uk

Tel: 0800 912 1722

Enquirer

Name	Miss Rebecca Dabbs	Phone	01442 416652
Company	RSK Environmental Ltd	Mobile	Not Supplied
Address	18 Frogmore Road Hemel Hempstead Hertfordshire HP3 9RT		
Email	rcdabbs@rsk.co.uk		

Enquiry Details

Scheme/Reference	736036 Langstone Flood & Coastal		
Enquiry type	Planned Works	Work category	Utility Works
Start date	22/09/2021	Work type	Single excavations site (1.5m or st
End date	22/09/2021	Site size	955 metres diameter
Searched location	PO9 1RF	Work type buffer*	25 metres
Confirmed location	471818 104822		
Site Contact Name	Not Supplied	Site Phone No	Not Supplied
Description of Works			

* The WORK TYPE BUFFER is a distance added to your search area based on the Work type you have chosen.

Site Map


Asset Owners

Terms and Conditions. Please note that this enquiry is subject always to our standard terms and conditions available at www.lineasearchbeforeudig.co.uk ("Terms of Use") and the disclaimer at the end of this document. Please note that in the event of any conflict or ambiguity between the terms of this Enquiry Confirmation and the Terms of Use, the Terms of Use shall take precedence.

Notes. Please ensure your contact details are correct and up to date on the system in case the LSBUD Members need to contact you.

Validity and search criteria. The results of this enquiry are based on the confirmed information you entered and are valid only as at the date of the enquiry. It is your responsibility to ensure that the Enquiry Details are correct, and LineasearchbeforeUdig accepts no responsibility for any errors or omissions in the Enquiry Details or any consequences thereof. LSBUD Members update their asset information on a regular basis so you are advised to consider this when undertaking any works. It is your responsibility to choose the period of time after which you need to resubmit any enquiry but the maximum time (after which your enquiry will no longer be dealt with by the LSBUD Helpdesk and LSBUD Members) is 28 days. If any details of the enquiry change, particularly including, but not limited to, the location of the work, then a further enquiry must be made.

Asset Owners & Responses. Please note the enquiry results include the following:

1. "LSBUD Members" who are asset owners who have registered their assets on the LSBUD service.
2. "Non LSBUD Members" are asset owners who have not registered their assets on the LSBUD service but LSBUD is aware of their existence. Please note that there could be other asset owners within your search area.

Below are three lists of asset owners:

1. LSBUD Members who have assets registered within your search area. ("Affected")
 - a. These LSBUD Members will either:
 - i. Ask for further information ("Email Additional Info" noted in status). The additional information includes: Site contact name and number, Location plan, Detailed plan (minimum scale 1:2500), Cross sectional drawings (if available), Work Specification.
 - ii. Respond directly to you ("Await Response"). In this response they may either send plans directly to you or ask for further information before being able to do so, particularly if any payments or authorisations are required.
2. LSBUD Members who do not have assets registered within your search area. ("Not Affected")
3. Non LSBUD Members who may have assets within your search area. Please note that this list is not exhaustive and all details are provided as a guide only. It is your responsibility to identify and consult with all asset owners before proceeding.

LSBUD Members who have assets registered on the LSBUD service within the vicinity of your search area.

List of affected LSBUD members

Asset Owner	Phone/Email	Emergency Only	Status
Portsmouth Water	02392499888	02392477999	Await response
Scottish and Southern Electricity Networks	08000483516	08000727282	Await response
SGN	08009121722	0800111999	Await response

LSBUD Members who do not have assets registered on the LSBUD service within the vicinity of your search area. Please be aware that LSBUD Members make regular changes to their assets and this list may vary for new enquiries in the same area.

List of not affected LSBUD members

AWE Pipeline	Balfour Beatty Investments Limited	BOC Limited (A Member of the Linde Group)
Box Broadband	BP Exploration Operating Company Limited	BPA
Cadent Gas	Carrington Gas Pipeline	CATS Pipeline c/o Wood Group PSN
Cemex	Centrica Storage Ltd	CNG Services Ltd
Concept Solutions People Ltd	ConocoPhillips (UK) Teesside Operator Ltd	Diamond Transmission Corporation
DIO (MOD Abandoned Pipelines)	DIO (MOD Live Pipelines)	E.ON UK CHP Limited
EirGrid	Electricity North West Limited	ENI & Himor c/o Penspen Ltd
EnQuest NNS Limited	EP Langage Limited	ESP Utilities Group
ESSAR	Esso Petroleum Company Limited	euNetworks Fiber UK Ltd
Exolum Pipeline System	Fulcrum Pipelines Limited	Gamma
Gas Networks Ireland (UK)	Gateshead Energy Company	Gigaclear Ltd
Gtt	Harbour Energy	Heathrow Airport LTD
Humbly Grove Energy	IGas Energy	INEOS FPS Pipelines
INEOS Manufacturing (Scotland and TSEP)	INOVYN ChlorVinyls Limited	INOVYN Enterprises Limited
Intergen (Coryton Energy or Spalding Energy)	Jurassic Fibre Ltd	Last Mile
Mainline Pipelines Limited	Manchester Jetline Limited	Manx Cable Company
Marchwood Power Ltd (Gas Pipeline)	Melbourn Solar Limited	Murphy Utility Assets
National Grid Electricity Transmission	National Grid Gas Transmission	Neos Networks
Northumbrian Water Group	NPower CHP Pipelines	NTT Global Data Centers EMEA UK Ltd
NYnet Ltd	Oikos Storage Limited	Ørsted
Palm Paper Ltd	Perenco UK Limited (Purbeck Southampton Pipeline)	Petroineos
Phillips 66	Premier Transmission Ltd (SNIP)	Redundant Pipelines - LPDA
RWE - Great Yarmouth Pipeline (Bacton to Great Yarmouth Power Station)	RWEpower (Little Barford and South Haven)	SABIC UK Petrochemicals
Scottish Power Generation	Seabank Power Ltd	SES Water
Shell	Shell NOP	SSE Generation Ltd
SSE Transmission	SSE Utility Solutions Limited	Tata Communications (c/o JSM Construction Ltd)
Total Colnbrook Pipelines	Total Finaline Pipelines	Transmission Capital

UK Power Networks	Uniper UK Ltd	University of Cambridge Granta Backbone Network
Vattenfall	Veolia ES SELCHP Limited	Veolia ES Sheffield Ltd
VPI Power Limited	Wales and West Utilities	West of Duddon Sands Transmission Ltd
Western Power Distribution	Westminster City Council	Zayo Group UK Ltd c/o JSM Group Ltd

The following Non-LSBUD Members may have assets in your search area. It is **YOUR RESPONSIBILITY** to contact them before proceeding. Please be aware this list is not exhaustive and it is your responsibility to identify and contact all asset owners within your search area.

Non-LSBUD members (Asset owners not registered on LSBUD)			
Asset Owner	Preferred contact method	Phone	Status
BT	https://www.swns.bt.com/pls/mbe/welcome.home	08000232023	Not Notified
CenturyLink Communications UK Limited	plantenquiries@instalcom.co.uk	02087314613	Not Notified
CityFibre	asset.team@cityfibre.com	033 3150 7282	Not Notified
Colt	plantenquiries@catelecomuk.com	01227768427	Not Notified
ENGIE	nrsua.uk@engie.com	01293 549944	Not Notified
GTC	https://pe.gtc-uk.co.uk/PlantEnqMembership	01359240363	Not Notified
Mobile Broadband Network Limited	mbnl.plant.enquiries@turntown.com	01212 621 100	Not Notified
Sky UK Limited	nrsua@sky.uk	02070323234	Not Notified
Sota	SOTA.plantenquiries@instalcom.co.uk		Not Notified
Southern Water	www.digdat.co.uk	08452700212	Not Notified
Utility assets Ltd	enquiries@utilityassets.co.uk		Not Notified
Verizon Business	osp-team@uk.verizonbusiness.com	01293611736	Not Notified
Virgin Media	http://www.digdat.co.uk	08708883116	Not Notified
Vodafone	osm.enquiries@atkinsglobal.com	01454662881	Not Notified

Disclaimer

Please refer to LineSearchbeforeUdig's Terms of Use for full terms of use available at www.linesearchbeforeudig.co.uk

The results of this Enquiry are personal to the Enquirer and shall not be shared with or relied upon by any other party. The asset information on which the Enquiry results are based has been provided by LSBUD Members, therefore LineSearchbeforeUdig will provide no guarantee that such information is accurate or reliable nor does it monitor such asset information for accuracy and reliability going forward. There may also be asset owners which do not participate in the enquiry service operated by LineSearchbeforeUdig, including but not exclusively those set out above. Therefore, LineSearchbeforeUdig cannot make any representation or give any guarantee or warranty as to the completeness of the information contained in the enquiry results or accept any responsibility for the accuracy of the mapping images used. LineSearchbeforeUdig and its employees, agents and consultants accept no liability (save that nothing in this Enquiry Confirmation excludes or limits our liability for death or personal injury arising from our negligence, or our fraud or fraudulent misrepresentation, or any other liability that cannot be excluded or limited by English law) arising in respect thereof or in any other way for errors or omissions including responsibility to any person by reason of negligence.

Map Symbols

						
VALVE OPEN	VALVE CLOSED	GOVERNOR	END CLOSURE	SYPHON	REDUCER	TEE
						
TEST POINT	CATHODIC PROTECTION	GENERAL REFERENCE	FLOW MEASURE	DIP POINT	MONO ETHYLENE GLYCOL	OILING POINT
						
FLOW STOP	PRESSURE MEASUREMENT	STAND PIPE	OFFICIAL MINISTRY RECORD	PURGE POINT	GAS CONDITIONER	DRAIN POINT
					LP MAINS	
SKETCH BUBBLE	DEPTH OF COVER	METER	MATERIAL CHANGE		MP MAINS	
					IP MAINS	
					LHP MAINS	
					HISTORY DATA	
					SSSI	
PIG TRAP	CROSSOVER CONNECTION	CHANGE OF DIAMETER	PIPE JOINT		CONTACT ZONE	
						LTS

Rebecca Dabbs

From: MBNLplantenquiries <mbnl.plant.enquiries@turntown.com>
Sent: 03 September 2021 15:24
To: DeskBasedUtilities
Subject: RE: 736036 Langstone Flood & Coastal Deskbased Utilities Search

Turner & Townsend Confidential

Dear Sir/Madam

Turner & Townsend Project Management are appointed on behalf of MBNL to conduct Plant (apparatus) Searches in accordance with the relevant NRSWA Act 1991- Diversionary Works legislation. These searches considered plant belonging to EE (T-Mobile and Orange sites) and the HG3 mobile telecommunication networks.

Further to your plant enquiry please see the response below to the NRSWA request submitted:

MBNL do not have any plant that would be affected by the proposed work. Should you have any further queries please use the contact details below.

PS: Please can you send all future Plant enquiries for EE or H3G to this email address:
mbnl.plant.enquiries@turntown.com

Thank you.

Kind regards,

MBNL SHQE Team

Turner & Townsend
t: 0121 262 3663 | www.turnerandtowntsend.com
Turner & Townsend Europe Limited
Registered office: Low Hall, Calverley Lane, Horsforth, Leeds LS18 4GH, United Kingdom | Registered in England and Wales | Registration No: 3514794

From: DeskBasedUtilities <DeskBasedUtilities@rsk.co.uk>
Sent: 03 September 2021 14:32
Subject: 736036 Langstone Flood & Coastal Deskbased Utilities Search

"Don't get caught out" - This email has come from an external source. Do not click on any links or open any attachments unless you are expecting them.

Good Afternoon

Our company is due to undertake a site investigation within the area detailed below, this includes intrusive works including borehole, window sampling and machine dug trial pitting. These intrusive works follow HSG47 guidelines and will be undertaken under a Permit to Dig safe system of work including a site walkover with the service plans, service detection, CAT & Genny sweeps, and hand dug pits to 1.2m depth where appropriate.

Our reference: **736036 Langstone Flood & Coastal**

Location of works: **Langstone High Street, Langstone Road, Bedhampton**
O.S. Grid Ref.: **471776, 104842**
Address/Nearest Postcode: **PO9 1RF**
Expected Start Date:
Expected Completion Date:

A plan of the site has been enclosed, please cover the entire area shown within the boundary on the attached map.

In order that all reasonable precautions may be taken to avoid the risk to health and safety through contacts with any of your existing apparatus during execution of the proposed works, please indicate the position and depth of all main statutory services and wayleaves on site and in the adjoining roads where applicable. In addition, please highlight any likely special problems that could arise in connection with your apparatus as a result of the proposed works.

We therefore request that you supply us with relevant plan information or written confirmation to declare that no apparatus is affected at your earliest convenience.

Rebecca Dabbs
Team Administrator

RSK

18 Frogmore Road, Hemel Hempstead, Hertfordshire, HP3 9RT, UK

Switchboard: +44 (0)1442 437500 · email: rcdabbs@rsk.co.uk

<http://www.rsk.co.uk> | RSK Geophysics [Download Geophysics Guide](#)



RSK Environment Ltd is registered in Scotland at 65 Sussex Street, Glasgow, Scotland, G41 1DX, UK
Registered number: 115530

This message contains confidential information and is intended only for the individual named. If you are not the named addressee, you should not disseminate, distribute or copy this e-mail. Please notify the sender immediately by e-mail if you have received this e-mail by mistake and delete this e-mail from your system. E-mail transmission cannot be guaranteed to be secure or error-free as information could be intercepted, corrupted, lost, destroyed, arrive late or incomplete, or contain viruses. The sender therefore does not accept liability for any errors or omissions in the contents of this message, which arise as a result of e-mail transmission. If verification is required, please request a hard-copy version.

Before printing think about your responsibility and commitment to the ENVIRONMENT!

Turner & Townsend Limited

For further information and registration details visit our website <http://www.turnerandtowntsend.com>

This email and any attachments ("the email") is confidential and may also be privileged, is subject to copyright and may be read, copied and used only by the intended recipient. The recipient is responsible for virus checking this email. If you are not the intended recipient please immediately notify us, delete and do not use, disclose, distribute, copy, print or rely on this email or any part of it. Turner & Townsend does not accept any liability for any loss or damage from your receipt or use of this email.

Please consider the environment before printing this email.

[WARNING: This email originated outside of RSK. DO NOT CLICK links, attachments or respond unless you recognise the sender and are certain that the content is safe]