


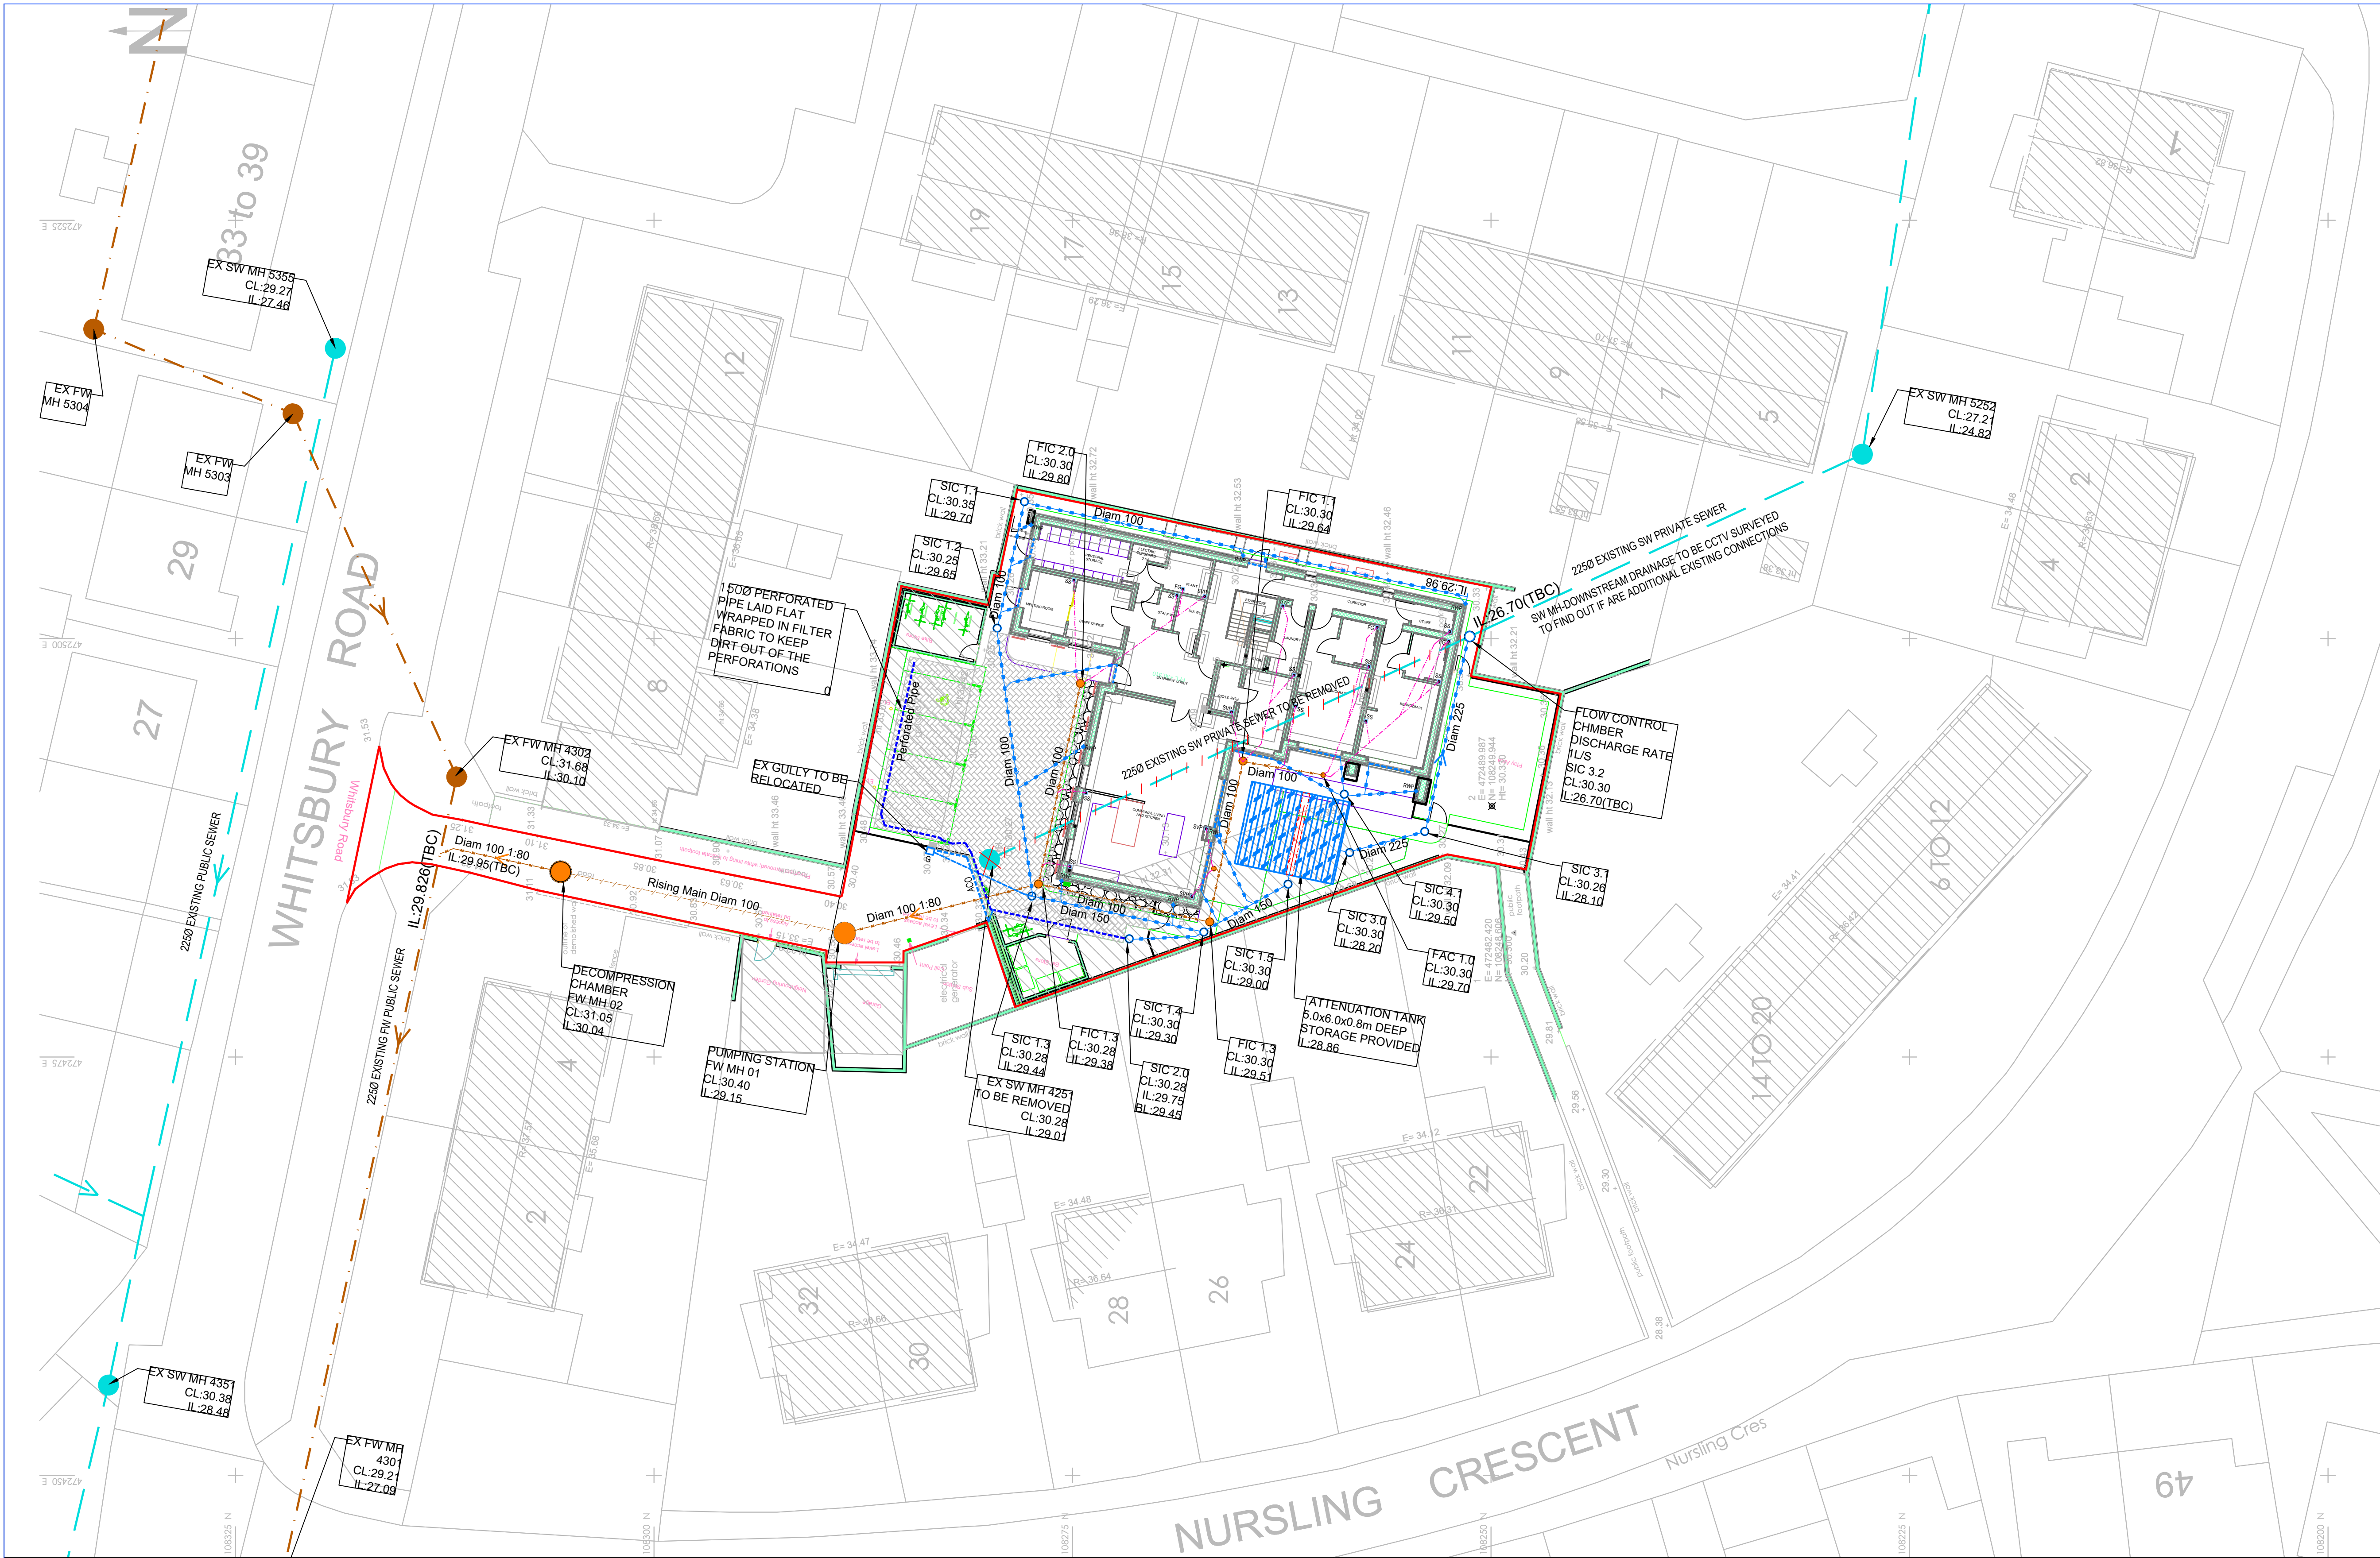

HEALTH & SAFETY

1. CONTRACTOR SHOULD BE AWARE OF GENERAL CONSTRUCTION RISKS TO PREVENT SLIPS, TRIPS AND FALLS AND TAKE NECESSARY PRECAUTIONS WITHOUT SPECIAL INSTRUCTION.
2. CONTRACTOR TO PROVIDE TRENCH SUPPORTS AS APPROPRIATE AND ENSURE THAT PLANT REMAINS A SAFE DISTANCE FROM TRENCHES PRIOR TO INSTALLING DRAINAGE.
3. THE TIME THAT EXCAVATIONS ARE OPEN ON SITE SHOULD BE KEPT TO A MINIMUM AND ALL TRENCHES SHOULD BE SURROUNDED BY A BARRIER.
4. CONNECTIONS TO EXISTING SEWERS TO BE MADE BY APPROVED CONTRACTOR ONLY.
5. CONTRACTOR TO MAKE OPERATIVES AWARE OF ASSOCIATED DANGERS TO HEALTH SUCH AS LEPTOSPIROSIS (WEIL'S DISEASE) AND RECOMMENDED PRECAUTIONS, ADEQUATE WELFARE FACILITIES AND PROTECTIVE CLOTHING TO BE PROVIDED AS REQUIRED.
6. UNFINISHED MANHOLES MUST BE COVERED WITH LOAD BEARING MATERIALS AND SURROUNDED WITH BARRIER.
7. CONTRACTOR TO OBTAIN ALL SERVICE RECORDS PRIOR TO WORKS COMMENCING.
8. SERVICE RECORDS TO BE REFERRED TO PRIOR TO WORK COMMENCING. CONTRACTOR TO PROCEED WITH CAUTION AND SERVICES TO BE LOCATED BY HAND DIG AND PROTECTED ACCORDINGLY.
9. CONTRACTOR TO ENSURE RELEVANT MEASURES ARE TAKEN TO KEEP PLANT AND PEOPLE A SAFE DISTANCE FROM STEEP SLOPES DURING THE WORKS.
10. CONTRACTOR TO ENSURE THAT PROCEDURES ARE IN PLACE TO KEEP PEOPLE A SAFE DISTANCE FROM WORKING PLANT WHERE NECESSARY.
11. CONTRACTOR TO REFER TO GROUND INVESTIGATION REPORT FOR CONTAMINATION TESTS AND TO PROVIDE ADEQUATE WELFARE FACILITIES AND PROTECTIVE CLOTHING AS REQUIRED.

KEY

- INDICATES SURFACE WATER SEWER
- INDICATES FOUL WATER SEWER
- INDICATES EXISTING MANHOLE AND FOUL WATER SEWER
- INDICATES EXISTING MANHOLE AND SURFACE WATER SEWER
- INDICATES EXISTING SURFACE WATER SEWER TO BE REMOVED
- INDICATES FOUL RISING MAIN
- INDICATES 1500 PERFORATED PIPE
- INDICATES ACO CHANNEL DRAIN
- INDICATES 450mm DIA PLASTIC CHAMBER SSG TYPE E OR 3 INSPECTION CHAMBER RANGE 450 BY WAVIN OR SIMILAR
- INDICATES 450mm DIA PLASTIC CHAMBER SSG TYPE E OR 3 INSPECTION CHAMBER RANGE 450 BY WAVIN OR SIMILAR
- INDICATES PROPOSED SURFACE WATER MANHOLE
- INDICATES PROPOSED FOUL WATER MANHOLE
- INDICATES PROPOSED ATTENUATION TANK
- INDICATES TANKED PERMEABLE PAVING

Notes:

SAFETY, HEALTH AND ENVIRONMENTAL INFORMATION

IN ADDITION TO THE HAZARDS/RISKS NORMALLY ASSOCIATED WITH THE TYPES OF WORK DETAILED ON THIS DRAWING, NOTE THE FOLLOWING CONSTRUCTION:

- Installation methodology to be incorporated into the design
- Where it has not been possible to mitigate the hazard by design then the residual hazard is highlighted on the relevant drawing with this symbol

MAINTENANCE / CLEANING:

- No special measures required

DECOMMISSIONING / DEMOLITION:

- Reverse of installation methodology

IT IS ASSUMED THAT ALL WORKS WILL BE CARRIED OUT BY A COMPETENT CONTRACTOR WORKING, WHERE APPROPRIATE, TO AN APPROVED METHOD STATEMENT

FOR GENERAL NOTES SEE DRAWING S-00

DRAINAGE

1. ALL DRAINAGE WORKS SHALL BE CARRIED OUT IN ACCORDANCE WITH THE WATER SERVICES ASSOCIATION "DESIGN AND CONSTRUCTION GUIDANCE" - CURRENT EDITION AND ADOPTING WATER AUTHORITY/SEWERAGE AGENCY REQUIREMENTS AND SPECIFICATIONS. ALL PRIVATE DRAINAGE WORKS SHALL BE CARRIED OUT IN ACCORDANCE WITH BUILDING REGULATIONS 2015 EDITION.
2. CONTRACTOR TO ESTABLISH POSITION, SIZE AND DEPTH OF ALL EXISTING SEWERS AND SERVICES PRIOR TO COMMENCEMENT ON SITE.
3. THE CONTRACTOR SHALL ALLOW FOR THE PROTECTION, TEMPORARY AND PERMANENT SUPPORT, AND TEMPORARY AND PERMANENT DIVERSION WORKS, AS NECESSARY TO ALL EXISTING SERVICES.
4. THE CONTRACTOR SHALL ALLOW FOR ALL TRAFFIC MANAGEMENT IN CONNECTION WITH ROAD AND SEWER WORKS.
5. THE CONTRACTOR SHALL ALLOW FOR KEEPING SEWER TRENCHES AND EXCAVATIONS AS DRY AS PRACTICABLE BY PUMPING FROM TEMPORARY SUMPS AND DEWATERING AS APPROPRIATE. THE POINT AND METHOD OF DISCHARGE TO BE AGREED WITH THE DRAINAGE AUTHORITY.
6. FOR PIPE SPECIFICATION PLEASE REFER TO ADDITIONAL NOTES.
7. VITRIFIED CLAY PIPES AND FITTINGS SHALL COMPLY WITH THE RELEVANT PROVISIONS OF BS EN295 AND BS 65 RESPECTIVELY AND BE KITEMARKED. ALL PIPES SHALL BE EXTRA STRENGTH TO BS 65 OR EQUIVALENT BS EN295 PIPE CRUSHING STRENGTH.
8. STRUCTURED WALL PLASTIC PIPES TO WIS 4-35-01 MAY BE USED FOR FOUL & SURFACE WATER DRAINAGE, SUBJECT TO ADOPTING AUTHORITY APPROVAL.
9. PRECAST CONCRETE PRODUCTS SHALL COMPLY WITH THE RELEVANT PROVISIONS OF BS 5911 AND BE KITEMARKED. CONCRETE PIPES TO BE CLASS 120 UNLESS NOTED OTHERWISE.
10. GULLY GRATES AND FRAMES SHALL COMPLY WITH THE RELEVANT PROVISIONS OF BS EN124 AND BE OF A NON-ROCKING DESIGN WITH CAPTIVE HINGE ACCESS AND BE KITEMARKED. LOAD CLASS D400 FOR ROADS AND SERVICE YARD AREAS. CLASS C250 TO BE USED IN CAR PARKING AREAS.
11. CLASS 2 BEDDING DETAIL SHALL BE PROVIDED WHERE COVER TO THE PIPE BARREL IS LESS THAN 1.2M IN VEHICULAR TRAFFICKED AREAS AND 0.9M ELSEWHERE, TO ALL ROAD GULLY CONNECTIONS AND WITHIN AREAS OF DEEP ROOTING VEGETATION.
12. WHERE CLASS 2 TRENCH BEDDING DETAIL IS USED, THE CONCRETE BED AND SURROUND SHALL BE DISCONTINUED AT EACH PIPE JOINT OVER THE FULL CROSS SECTION BY MEANS OF A SHAPED COMPRESSIBLE FILLER.
13. BACKFILLING AND REINSTATEMENT TO TRENCHES IN PUBLIC HIGHWAYS SHALL BE IN ACCORDANCE WITH THE REQUIREMENTS AND SPECIFICATIONS OF THE ADOPTING AUTHORITY, OR, IN THE ABSENCE OF SUCH, IN ACCORDANCE WITH THE REQUIREMENTS OF "THE STREET WORKS REGULATIONS 1992" AND RELEVANT PROVISIONS OF H.A.U.C. "SPECIFICATION FOR THE REINSTATEMENT OF OPENINGS IN HIGHWAYS" JUNE 1992, BOTH UNDER SECTION 71 OF THE NEW ROADS AND STREET WORKS ACT 1991.
14. ALL TRADITIONAL RAINWATER PIPE DOWNCOMERS TO DISCHARGE TO TRAPPED GULLIES.
15. ALL SIPHONIC DRAINAGE DOWNCOMERS TO MANUFACTURER SPECIFICATION.
16. ALL ROAD GULLIES ARE TO BE TRAPPED GULLIES.
17. ALL GULLY LEADS TO BE 150mm DIAMETER.
18. ALL REDUNDANT EXISTING DRAINAGE TO BE GRUBBED UP OR GROUTED. ANY EXISTING LIVE DRAINAGE SHOULD BE REPORTED TO THE ENGINEER AND RECONNECTED.
19. ALL ROAD GULLIES & LEADS TO BE CLEARED OF DEBRIS UPON COMPLETION OF WORKS.
20. ANY EXISTING DRAINAGE WHICH BECOMES UNDER TRAFFICKED AREAS IN THE NEW SCHEME SHOULD BE SUBJECT TO THE FOLLOWING REMEDIAL MEASURES: WHERE DEPTH OF COVER IS LESS THAN 1200MM, THE EXISTING PIPEWORK SHALL BE PROTECTED WITH 150MM CONCRETE AS CLASS "Z" BEDDING. WHERE THE EXISTING MANHOLE COVER & FRAME IS NOT AS MANHOLE DETAIL A OR B, OR TO BS497 GRADE A, OR EN124 CLASS D, THEN IT SHOULD BE CHANGED FOR SUCH.
21. THE CONTRACTOR MUST ENSURE THAT ANY OF THE EXISTING DRAINAGE WHICH IS LIVE IS KEPT CLEAR OF DEBRIS AND SHOULD ALLOW FOR JETTING THROUGH THE NEW & EXISTING DRAINAGE UPON COMPLETION.
22. CONTRACTOR TO TAKE MEASURES TO PROTECT HIS OPERATIVES WITH RESPECT TO THE PRESENCE OF GAS IN SEWER TRENCHES AND MANHOLES THROUGH THE USE OF GAS MONITORING EQUIPMENT AND BREATHING APPARATUS AS REQUIRED.
23. CONTRACTOR TO APPLY FOR SEWER PERMITS AND ROAD OPENING PERMITS AS NECESSARY FROM THE APPROPRIATE AUTHORITIES, PRIOR TO COMMENCING WORKS.

P4	Foul stacks position and connection updated, Level threshold drain added	RXT	11/02/26
P3	Drainage Plan Revised	RXT	10/02/26
P2	Amend SW sewer DESIGNATION	RT	09/01/26
P1	FIRST ISSUE	RXT	22/09/25
REV:	DESCRIPTION:	BY:	DATE:
STATUS:			

PRELIMINARY

CLIENT NAME:			
STOP DOMESTIC ABUSE			
SITE:			
WHITSBURY ROAD HAVANT			
TITLE:			
DRAINAGE PLAN			
SCALE AT A1:	DATE:	DRAWN:	CHECKED:
1:200	OCT'24	RXT	RXT
DRAWING NO:	00 TEC V1 XX DR C001	REVISION:	P4
Client No. Designer Name Lead Type Role Number			