




EXTERNAL CONDENSER SCHEDULE						
UNIT REF	MANUFACTURER REFERENCE INDOOR/OUTDOOR	CAPACITY KW Total/Sensible	NOISE LEVELS (SPL)	SOUND POWER (SWL)	CONDENSER SIZE & WEIGHT WxHxD / kg	ELECTRICAL DATA
CU01	AC120RXADKG/EU	12.9	56dB(A)	70dB(A)	940x998x330 81kg	17.7A 1ph
CU02	AC120RXADKG/EU	12.9	56dB(A)	70dB(A)	940x998x330 81kg	17.7A 1ph
CU03	AC120RXADKG/EU	12.9	56dB(A)	70dB(A)	940x998x330 81kg	17.7A 1ph

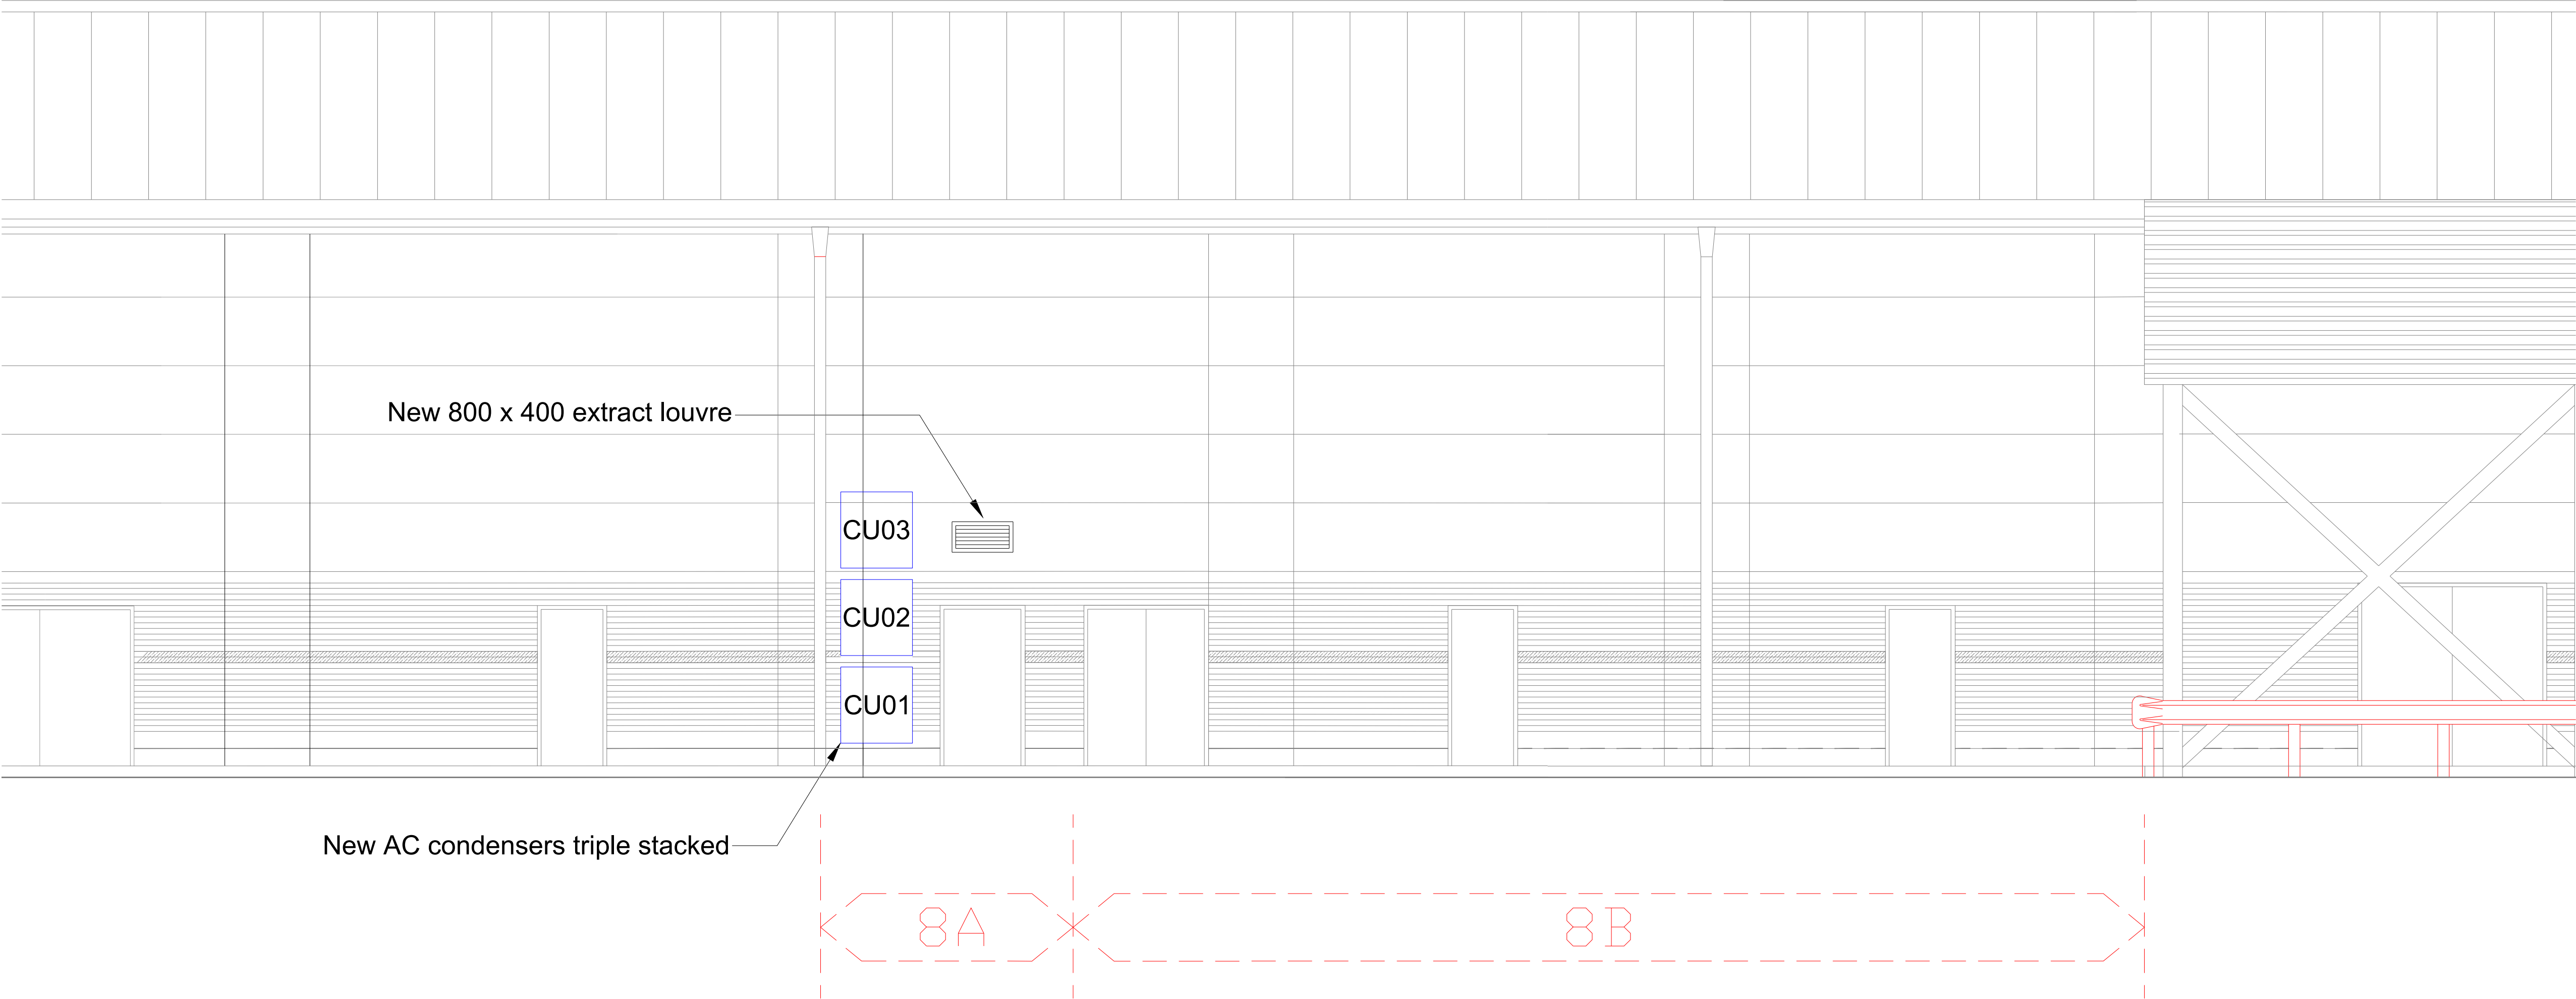

1 Proposed Rear Elevation of Mechanical Equipment and Louvre
Scale: 1 : 50

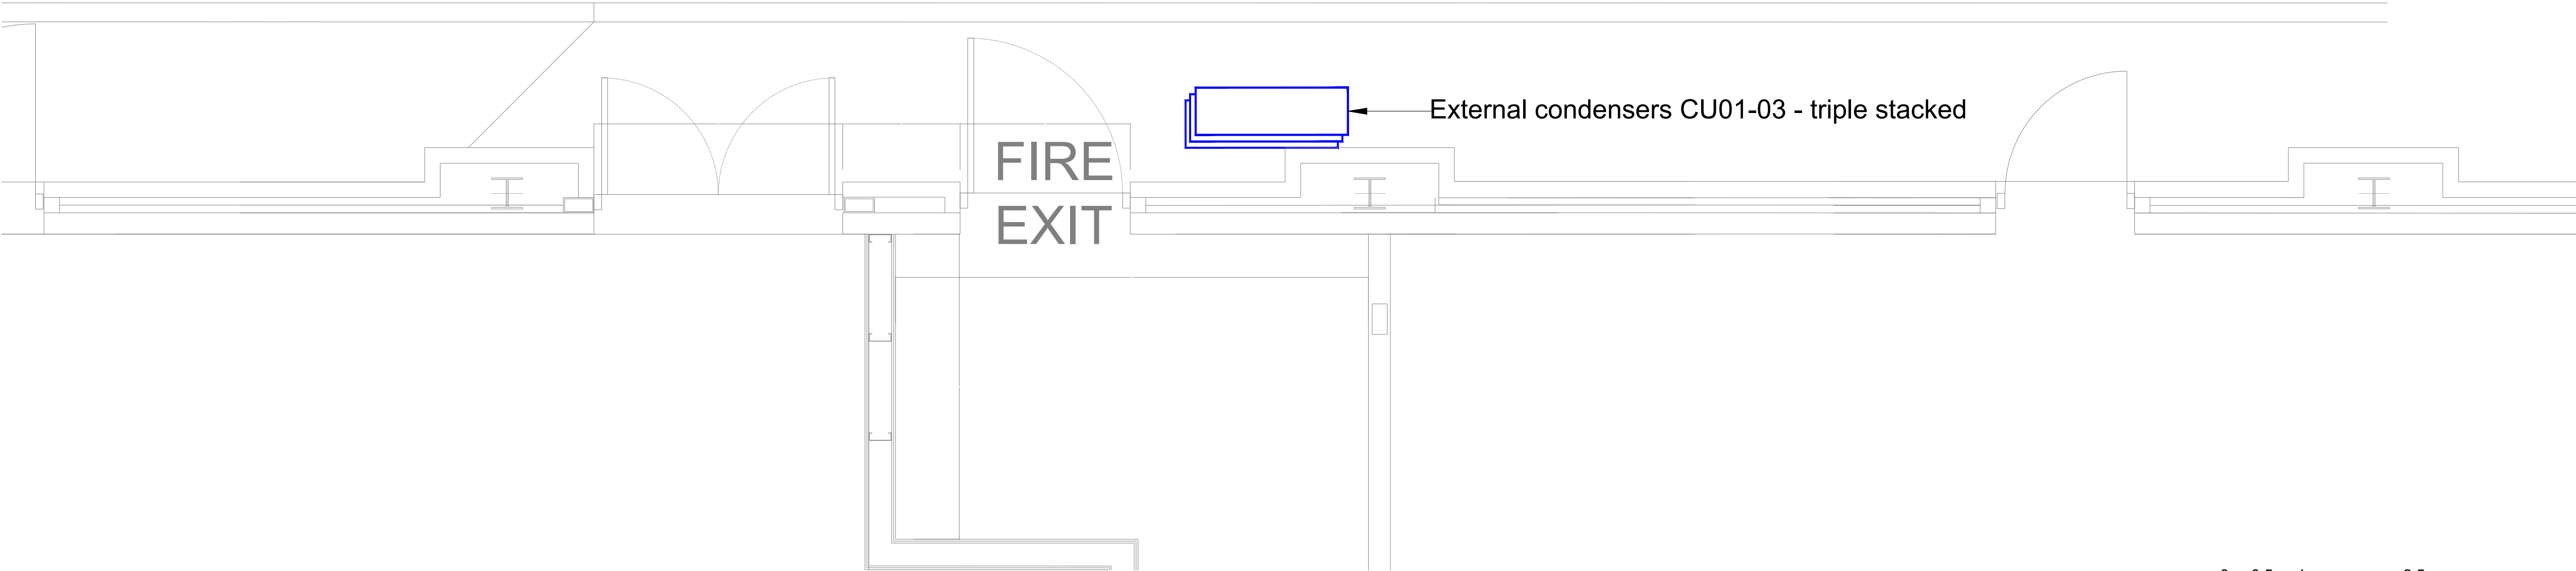

 2 Proposed Rear Plan of Mechanical Equipment
Scale: 1 : 25



CONSTRUCTION DRAWING SET



Starbucks Coffee Company
Building 4, Chiswick Park
566 Chiswick High Road
London, W4 5YE

These Drawings and Specifications are confidential and shall remain the sole property of Starbucks Corporation, which is the owner of the copyright in this work. They shall not be reproduced (in whole or in part), shared with third parties or used in any manner on other projects or extensions to this project without the prior written consent of Starbucks Corporation. These drawings and specifications are intended to express Design Intent for a prototypical Starbucks store (which is subject to change at anytime) and do not reflect actual site conditions. Neither party shall have any obligation nor liability to the other (except as stated above) until a written agreement is fully executed by both parties.

Engineer of Record
Unit J2, The Granary,
Bridge Farm,
Reading Road, Arborfield,
Berkshire, RG2 9HT
T:01189 773011
E:admin@designbrook.co.uk

SCAN QR CODE TO VIEW CURRENT
TECHNICAL MEP DATA SHEETS

Revision Schedule				
Rev	Date	By	Description	
1.0	23.04.26	JR	Added Plan View + Schedule	

Project Name:
WATERLOOVILLE - WELLINGTON RP

Project Address:
**10 HAMBLETON ROAD
WATERLOOVILLE
PO7 7FG
UNITED KINGDOM**

Store #:
89937

Project #:
7173

Concept:
Palette:
Issue Date:
22.04.26

Design Manager:
Project Designer:
Production Designer:
Checked by:

Sheet Title:
**Proposed Rear
Elevation & Plan**

Scale:
1 : 50

Sheet Number:
89937-U-1110 Rev 1.0