



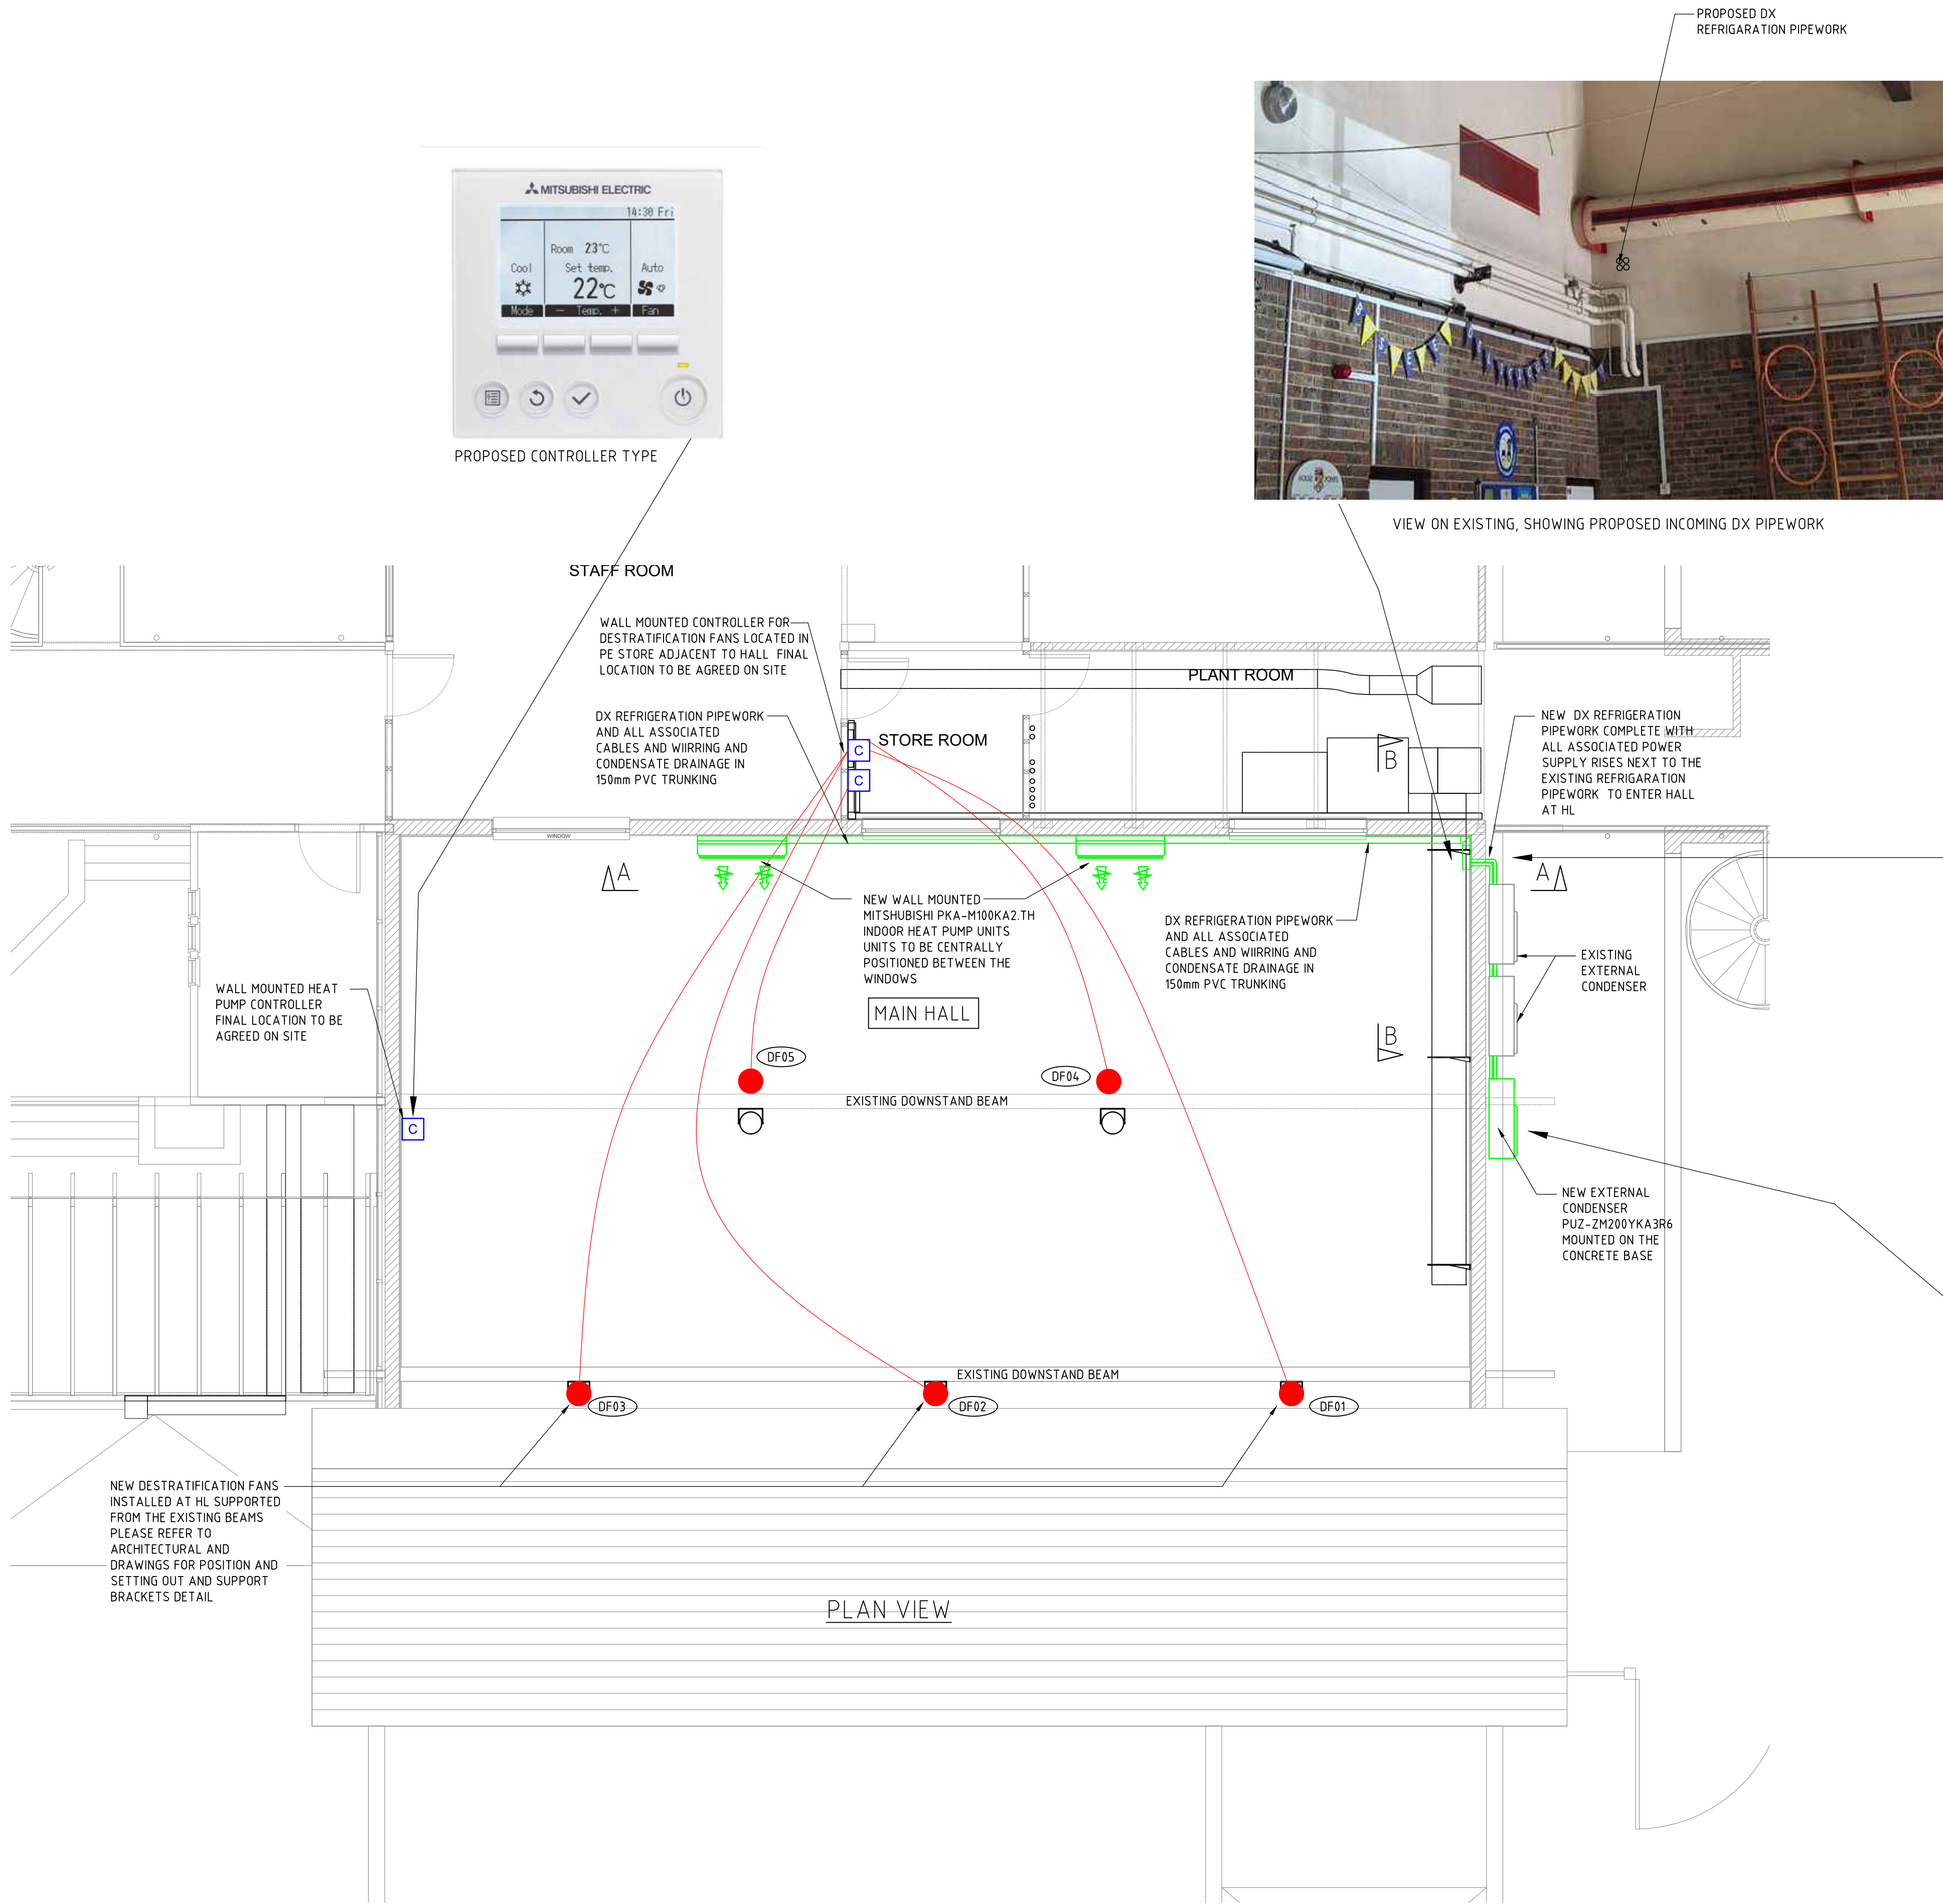

General Notes

- THIS DRAWING SHALL BE READ IN CONJUNCTION WITH ALL OTHER TENDER & CONTRACT DOCUMENTATION ISSUED FOR THIS PROJECT.
- DO NOT SCALE THIS DRAWING. ALL DIMENSIONS ARE IN MILLIMETRES UNLESS STATED OTHERWISE & SHALL BE CHECKED & VERIFIED ON SITE BEFORE CONSTRUCTION. FOR WALL SETTING OUT DIMENSIONS REFER TO ARCHITECTS DRAWINGS.
- THE INSTALLATION SHALL BE CARRIED OUT IN STRICT ACCORDANCE WITH THE PROJECT TENDER DRAWINGS, PARTICULAR REQUIREMENTS & STANDARD SPECIFICATIONS 7 THE CURRENT EDITION OF THE WIRING REGULATIONS (BS7671).
- FINAL POSITION OF ALL EQUIPMENT SHALL BE AGREED ON SITE WITH THE ENGINEER PRIOR TO INSTALLATION.
- THE CONTRACTOR SHALL CO-ORDINATE THE WORKS WITH ALL OTHER TRADES PRIOR TO COMMENCEMENT.
- WHERE ANY OF THE EXISTING INSTALLATION DETAILED TO BE RE-USED IS FOUND TO BE OF A DUBIOUS STANDARD, CLARIFYING INSTRUCTIONS SHALL BE SOUGHT FROM THE PROJECT ENGINEER.
- THE CONTRACTOR SHALL LIAISE & CO-ORDINATE WITH ALL SPECIALIST CONTRACTORS EMPLOYED FOR THE WORKS.
- ISOLATE, REMOVE & PROTECT ANY SERVICES TO ALLOW DEMOLITION WORKS TO TAKE PLACE IN ACCORDANCE WITH THE SCOPE OF WORKS.
- ALL ITEMS OF EQUIPMENT TO BE REMOVED & NOT RE-USED, SHALL BE OFFERED TO THE CLIENT'S REPRESENTATIVE & IF NOT REQUIRED, CONFIRMATION FOR THEIR DISPOSAL SHALL BE OBTAINED FROM THE PROJECT ENGINEER.
- THE CONTRACTOR SHALL ENSURE THE ACOUSTIC INTEGRITY & FIRE RATING OF WALLS & PARTITIONS, IS MAINTAINED WHERE SERVICES ARE REQUIRED TO PASS THROUGH.

Notes:

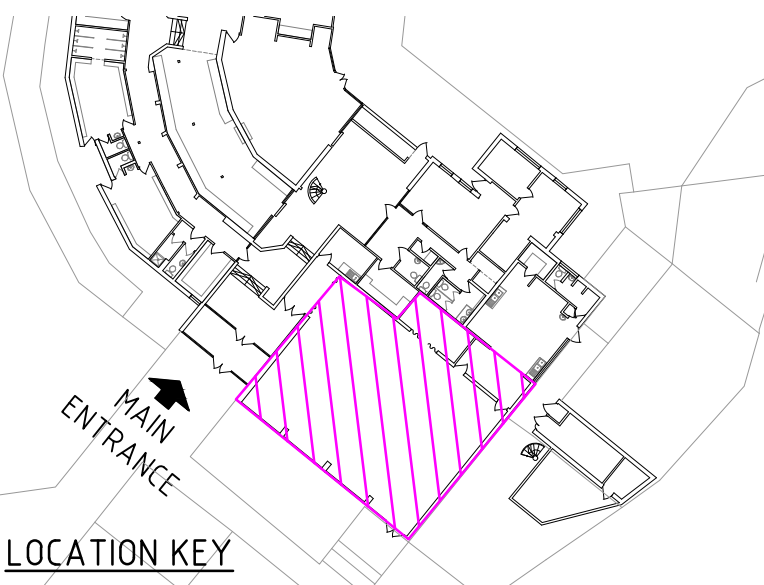

| Rev | Description       | Date    | By   |
|-----|-------------------|---------|------|
| T1  | ISSUED FOR TENDER | MAR '26 | CMcG |

The Castle  
Upper High Street  
Winchester  
SO23 8UJ



PROJECT NAME  
BOSMERE JUNIOR  
VENTILATION IMPROVEMENTS

SHEET NAME  
MECHANICAL ENGINEERING SERVICES  
PROPOSED NEW VENTILATION PLAN

SCALE  
1:50 @ A1

DRAWN  
CMcG

CHKD  
KK

APRV

DRAWING No.  
project code - originator - volume - level - type - role - number version  
P14865-HCC-00-DR-M-8800 P1

SUITABILITY  
code description