


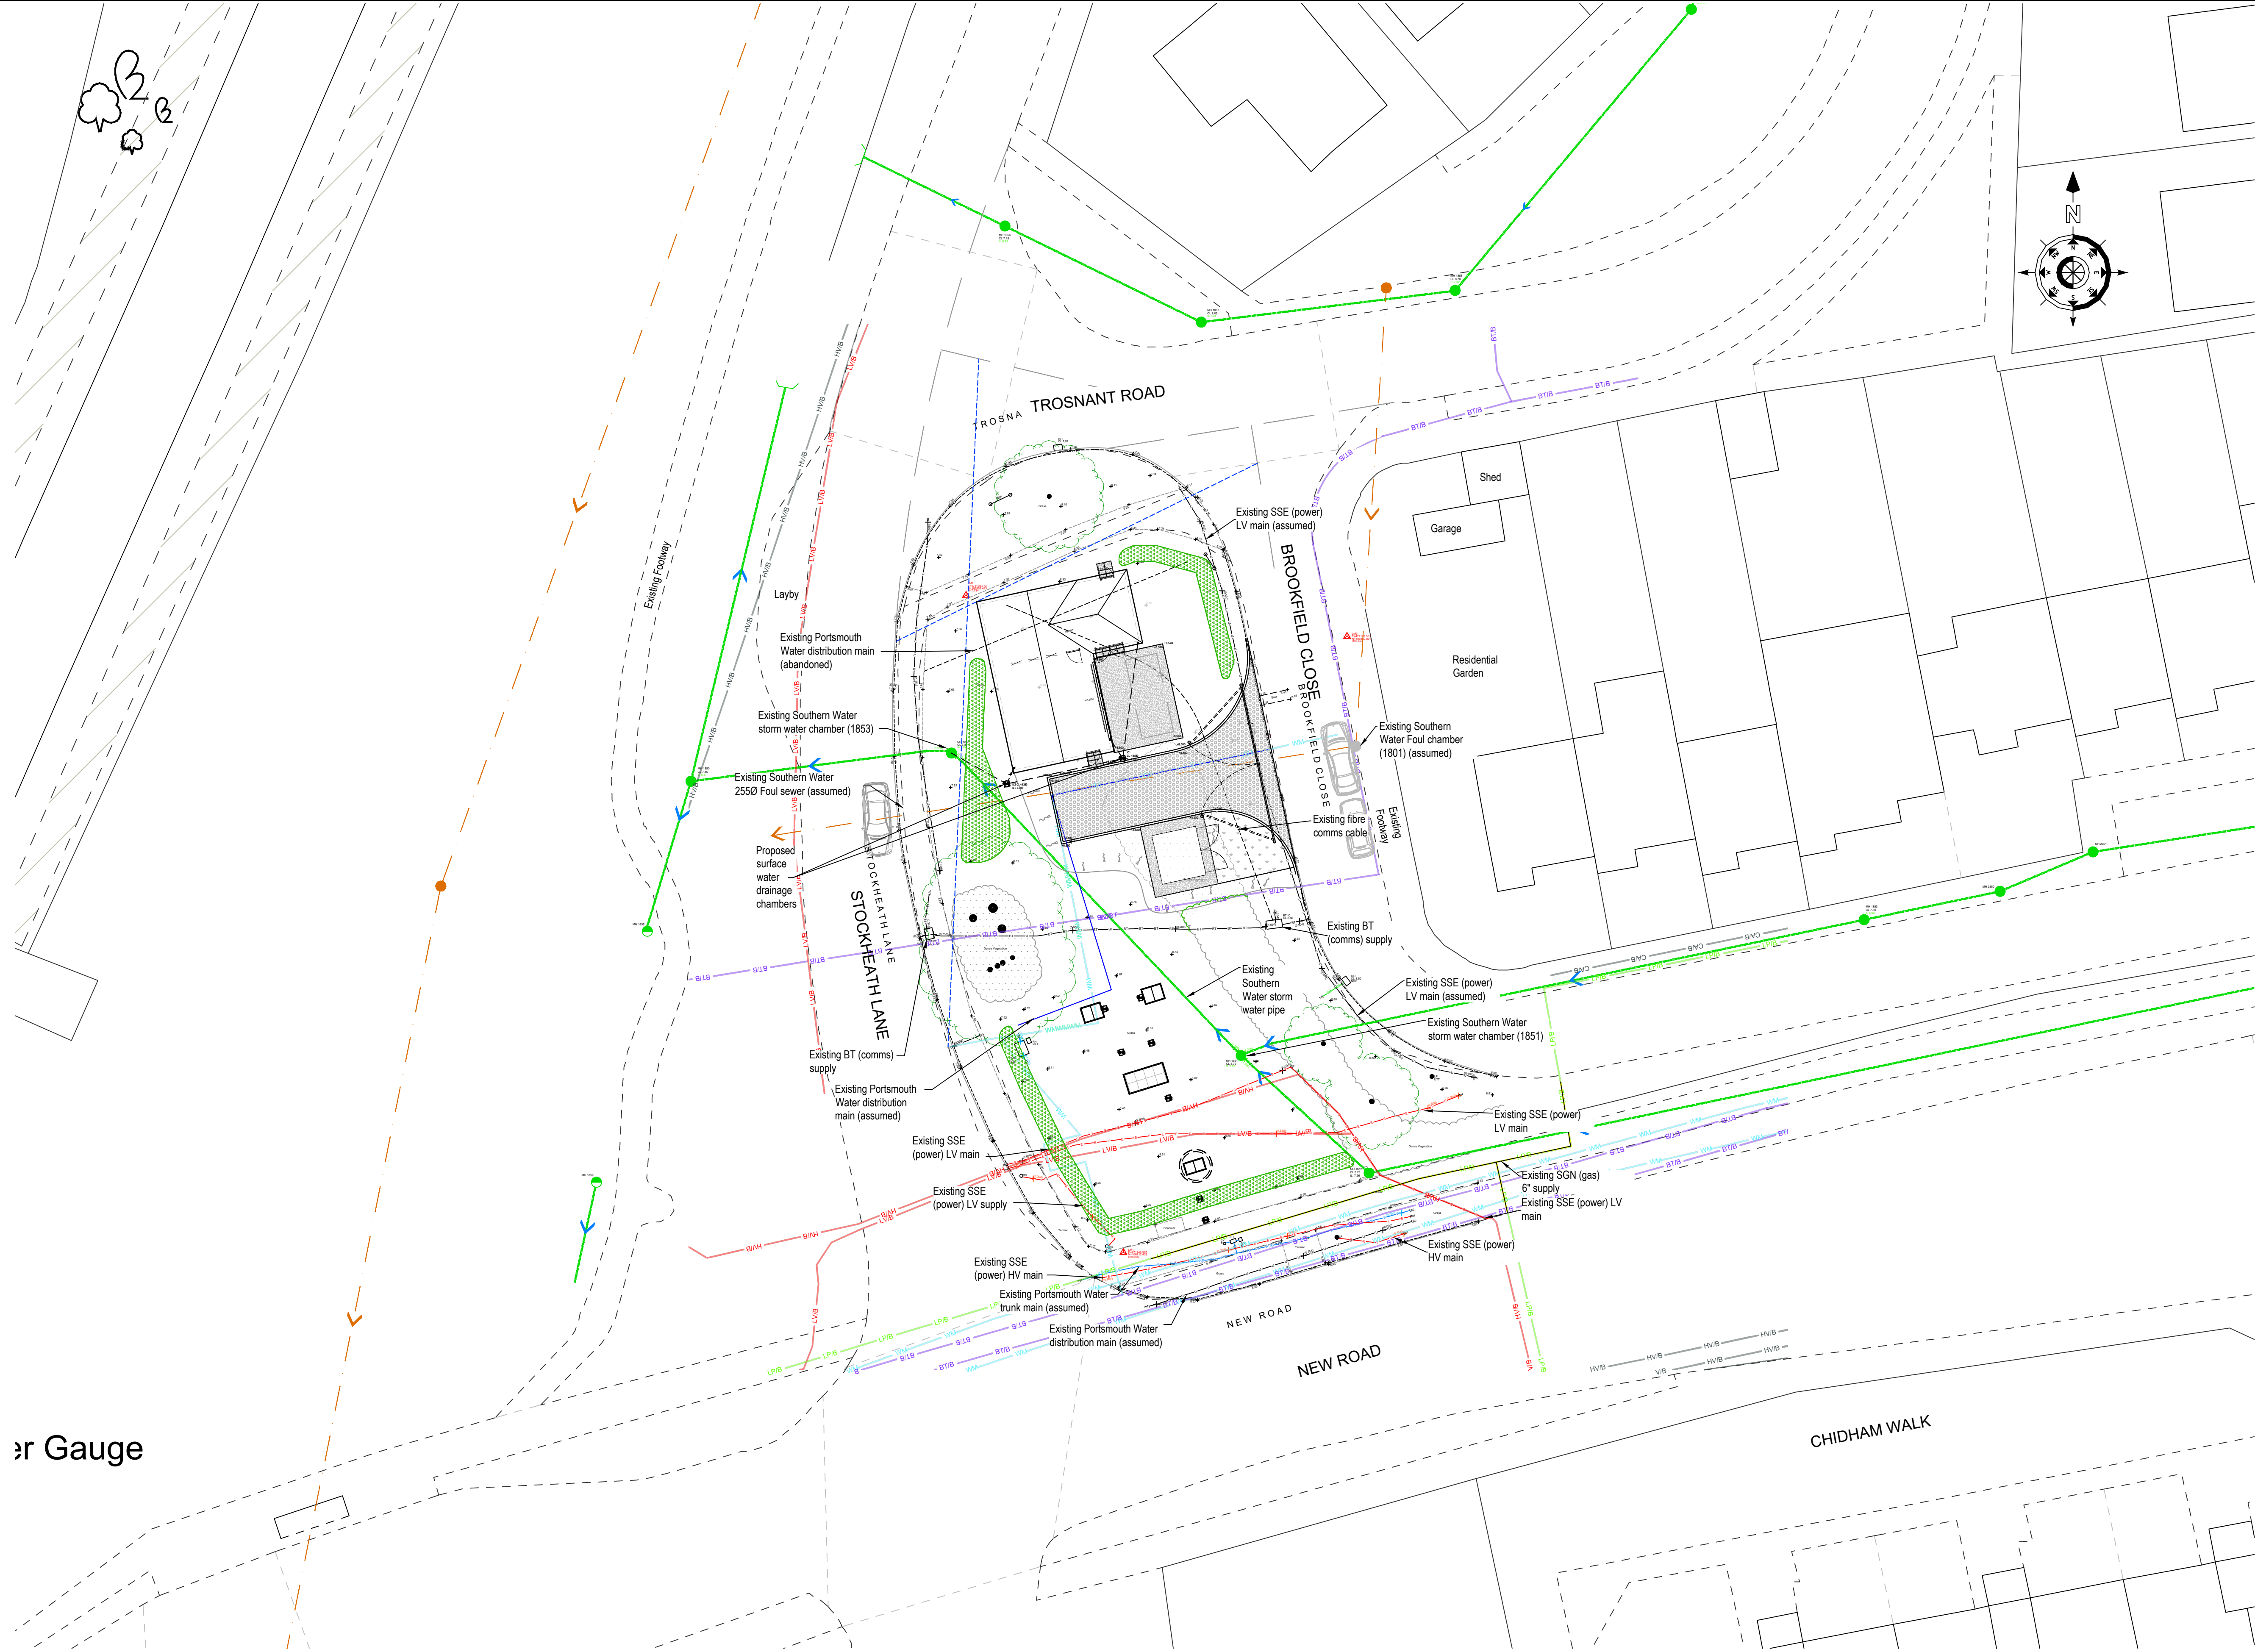

- Notes:
- ALL DIMENSIONS IN MILLIMETRES & ALL LEVELS IN METRES UNLESS SHOWN OTHERWISE.
 - SEE DRG. S847.11-IDS-PW-RT-DR-C-0013 FOR PROPOSED ROOF DRAINAGE DETAILS.


- LEGEND
- EXISTING SOUTHERN WATER SURFACE WATER SEWER
 - EXISTING SOUTHERN WATER SURFACE WATER MANHOLE
 - EXISTING SOUTHERN WATER CONTROL VALVE
 - EXISTING SOUTHERN WATER FOUL WATER SEWER
 - EXISTING SOUTHERN WATER FOUL WATER MANHOLE
 - PROPOSED ROOF DRAINAGE SYSTEM TO BE CONNECTED TO EXISTING SURFACE WATER NETWORK

Indicative Location of Underground Services

- | | |
|---------------------|------|
| Gas | LP/B |
| Electricity (LV/HV) | LV/B |
| Telecom | BT/B |
| Water Main | VW/B |
| Sewer, Storm Water | SW/B |
| Sewer, Foul Water | FS |

DRAWING REFERENCES

 - S847.11-IDS-PW-RT-DR-C-1000 SITE LOCATION PLAN
S847.11-IDS-PW-RT-DR-C-1001 EXISTING SITE PLAN
S847.11-IDS-PW-RT-DR-C-1002 PROPOSED SITE PLAN
S847.11-IDS-PW-RT-DR-C-1003 PROPOSED EQUIPMENT PLANS
S847.11-IDS-PW-RT-DR-C-1004 PROPOSED ELEVATIONS
S847.11-IDS-PW-RT-DR-C-1005 PROPOSED BUILDING ELEVATIONS
S847.11-IDS-PW-RT-DR-C-1006 PROPOSED LGV / SITE ACCESS / EGRESS
S847.11-IDS-PW-RT-DR-C-1007 PROPOSED HGV / SITE ACCESS / EGRESS
S847.11-IDS-PW-RT-DR-C-1008 PROPOSED EQUIPMENT BUILDING SECTIONS
S847.11-IDS-PW-RT-DR-C-1009 100 & 1000 YEAR FLOOD ZONE



CURRENT REVISION CHANGES

- PLANTING UPDATED ADJACENT TO STOCKHEATH LANE

P03	S3	MJS	JS	TM	KK	FOR REVIEW	21.05.26
P02	S3	MJS	JS	TM	KK	FOR REVIEW	14.05.26
P01	S3	MJS	JS	TM	KK	FOR REVIEW	27.04.26
Rev	Status Code	Dm By	Des By	Ckd By	App By	Description	Date

TRANT Engineering Ltd.
Head Office: Rushington House,
Rushington, Southampton
SO40 9LT.
Telephone: (023) 8066 5544
E-Mail: Engineering@trant.co.uk
www.trant.co.uk



Contractors Drawing Number:
S847.11-IDS-PW-RT-DR-C-1010

Telephone: Havant (023) 9249 9888
Fax: Havant (023) 9245 3832
Website: www.portsmouthwater.co.uk
Registered Office: PO Box 8 West Street
Havant Hampshire PO9 1LG
REGISTERED IN ENGLAND No. 2536455



PIN: S847.11 Scale: 1:200 Sheet Size: A1

Project Title:
RACTON BOOSTER TRANSFER PUMPING STATION

Drawing Title:
PROPOSED SURFACE WATER SEWER CONNECTION

Portsmouth Water Drawing Number: Rev: P03