


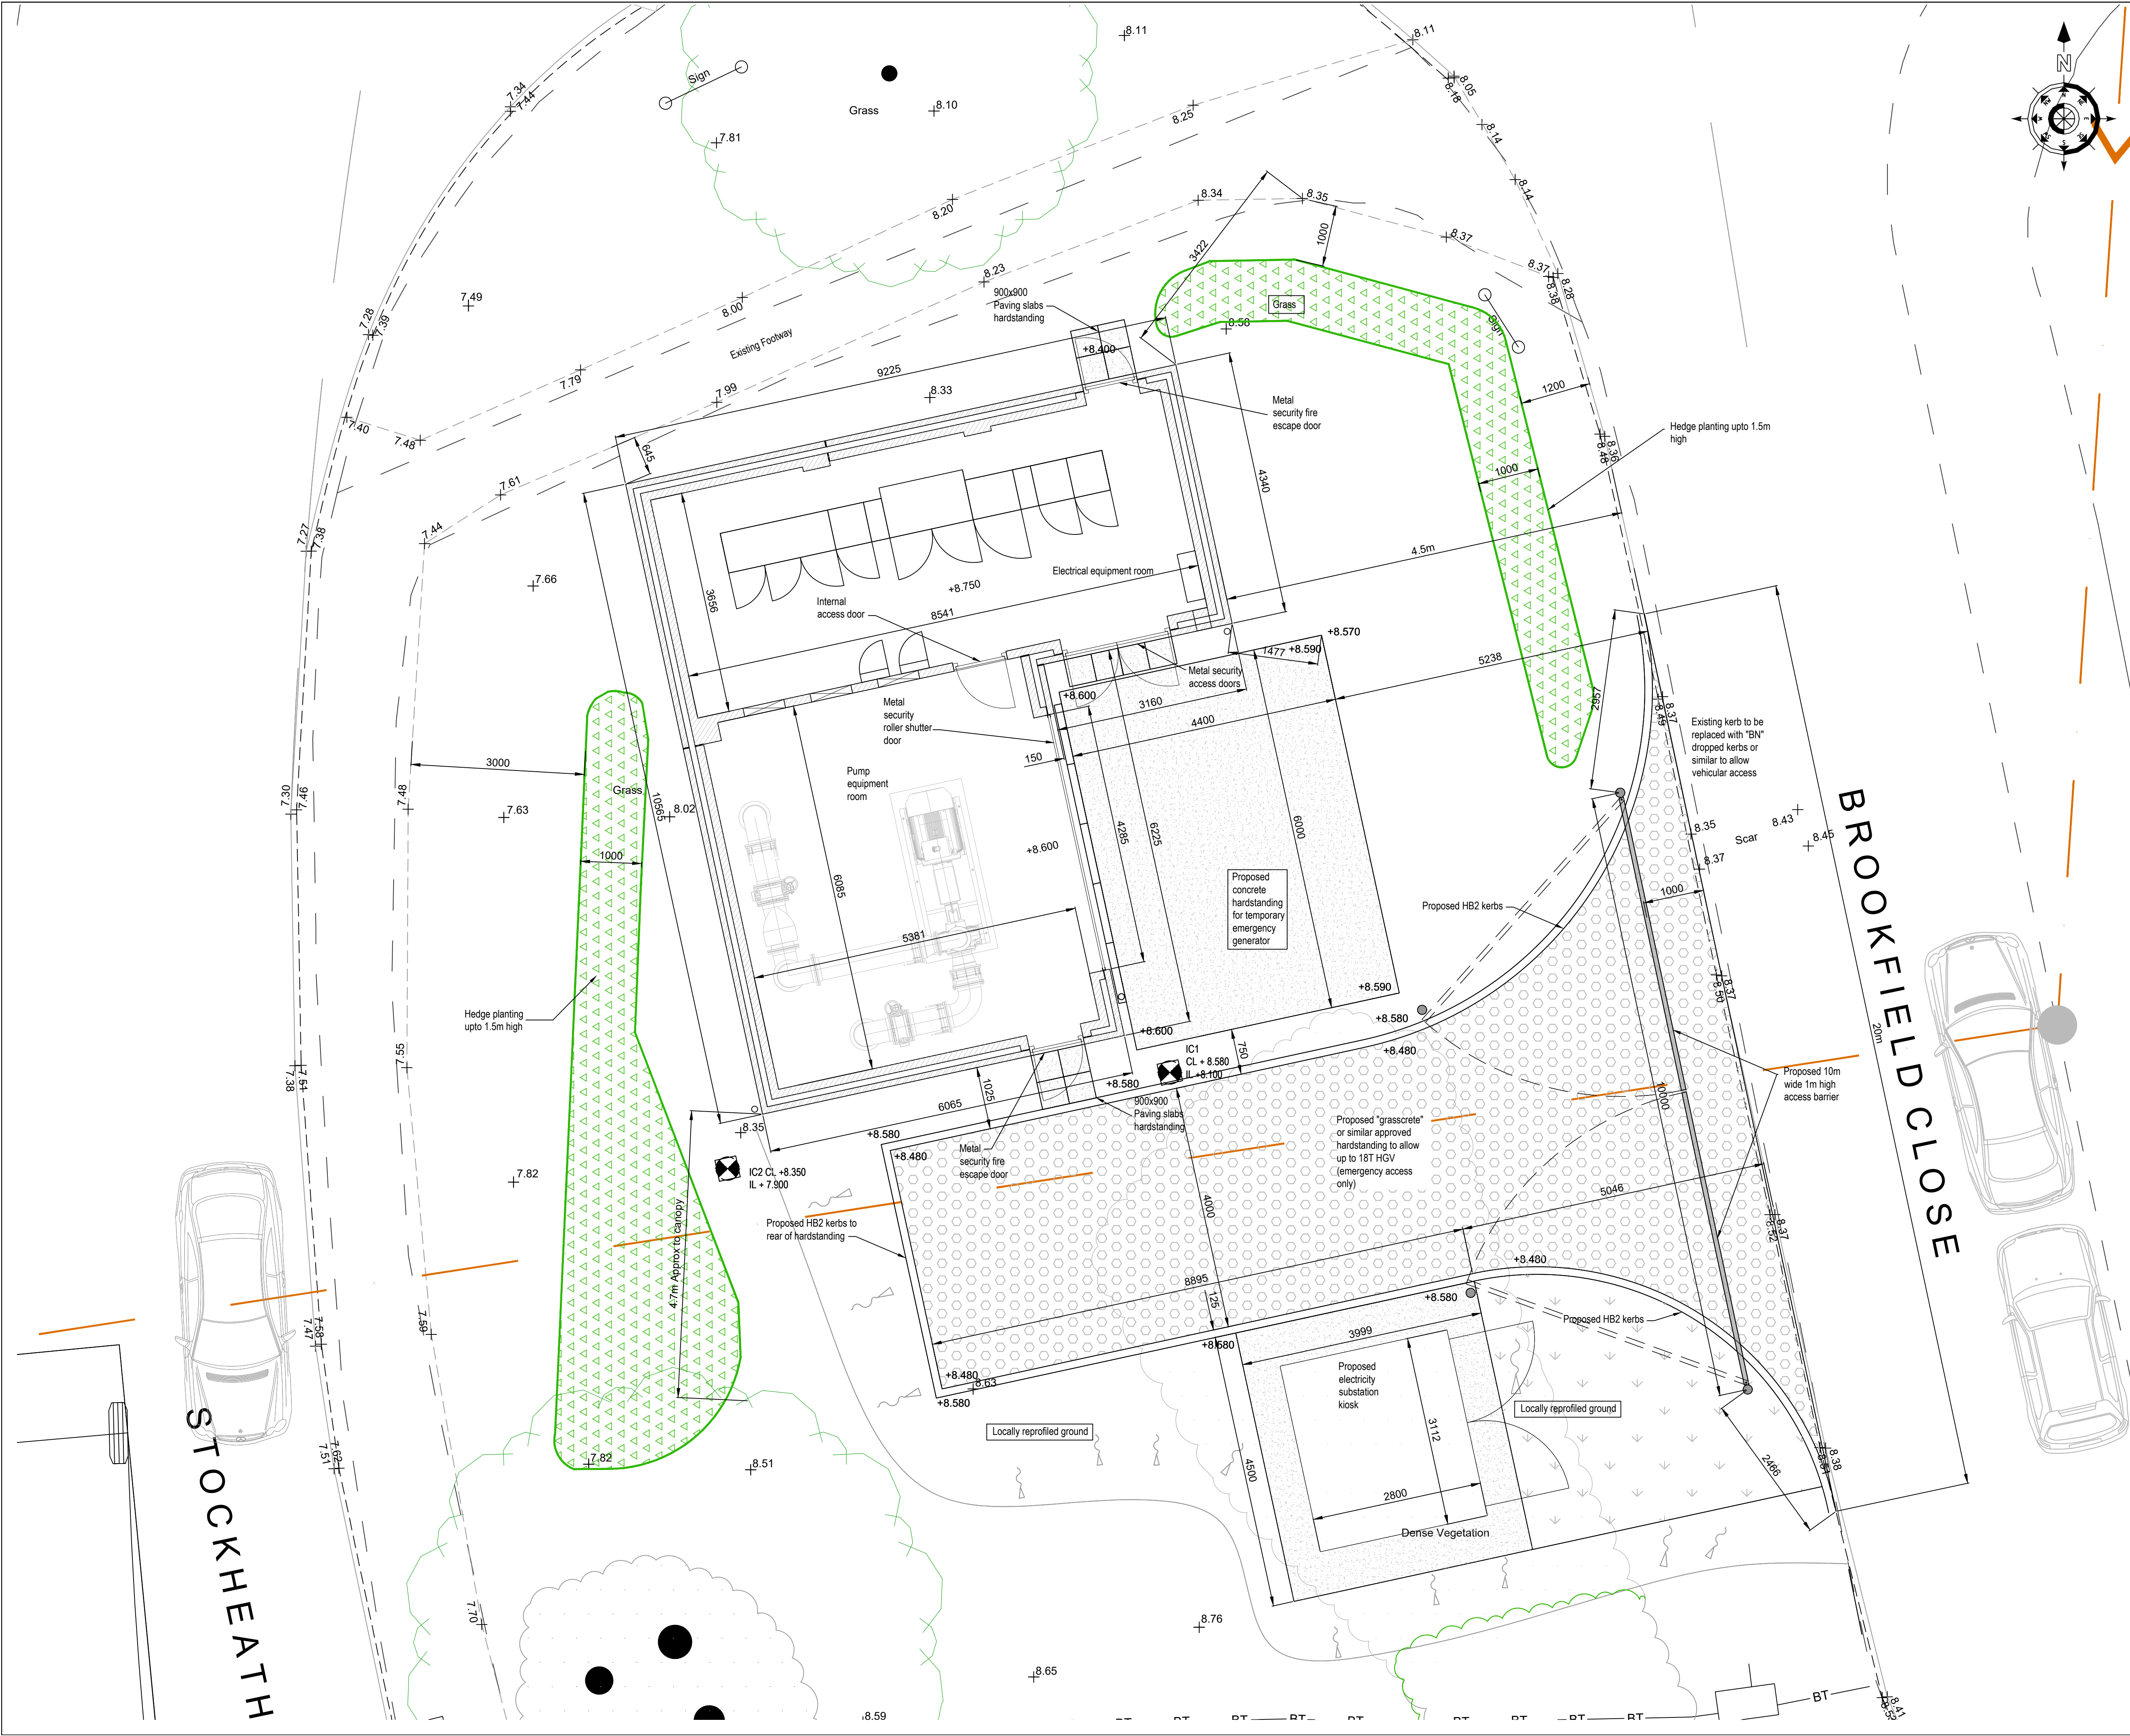

Notes:
1. ALL DIMENSIONS IN MILLIMETRES & ALL LEVELS IN METRES UNLESS SHOWN OTHERWISE.

 
LEGEND

PROPOSED PLANTING - COMPRISING OF :-
80% HAWTHORNE
20% NATIVE SPECIES

EXISTING SOUTHER WATER FOUL
SEWER ROUTE

DRAWING REFERENCES

S847.11-IDS-PW-RT-DR-C-1000 SITE LOCATION PLAN
S847.11-IDS-PW-RT-DR-C-1001 EXISTING SITE PLAN
S847.11-IDS-PW-RT-DR-C-1002 PROPOSED SITE PLAN
S847.11-IDS-PW-RT-DR-C-1003 PROPOSED EQUIPMENT PLANS
S847.11-IDS-PW-RT-DR-C-1004 PROPOSED ELEVATIONS
S847.11-IDS-PW-RT-DR-C-1005 PROPOSED BUILDING ELEVATIONS
S847.11-IDS-PW-RT-DR-C-1006 PROPOSED LGV / SITE ACCESS / EGRESS
S847.11-IDS-PW-RT-DR-C-1007 PROPOSED HGV / SITE ACCESS / EGRESS
S847.11-IDS-PW-RT-DR-C-1008 PROPOSED EQUIPMENT BUILDING SECTIONS
S847.11-IDS-PW-RT-DR-C-1009 100 & 1000 YEAR FLOOD ZONE



CURRENT REVISION CHANGES

1. PLANTING UPDATED ADJACENT TO STOCKHEATH LANE

P06	S2	MJS	MJS	TM	KK	FOR INFORMATION	21.05.26
P05	S2	MJS	MJS	TM	KK	FOR INFORMATION	14.05.26
P04	S2	MJS	MJS	TM	KK	FOR INFORMATION	27.04.26
P03	S2	MJS	MJS	TM	KK	FOR INFORMATION	05.03.26
P02	S2	MJS	KV	JS	KK	FOR INFORMATION	03.02.26
P01	S3	MJS	KV	JS	KK	FOR REVIEW	26.01.26
Rev	Status	Drn	Des	Ckd	App	Description	Date
	Code	By	By	By	By		

TRANT Engineering Ltd.
Head Office: Rushington House,
Rushington, Southampton
SO40 9LT.
Telephone: (023) 8066 5544
E-Mail: Engineering@trant.co.uk
www.trant.co.uk



Contractors Drawing Number:
S847.11-IDS-PW-RT-DR-C-1003

Telephone: Havant (023) 9249 9888
Fax: Havant (023) 9245 3632
Website: www.portsmouthwater.co.uk
Registered Office: PO Box 8 West Street
Havant Hampshire PO9 1LG
REGISTERED IN ENGLAND No. 2536455



PIN: S847.11 Scale: 1:50 Sheet Size: A1

Project Title:
RACTON BOOSTER TRANSFER
PUMPING STATION

Drawing Title:
EQUIPMENT / BUILDING & LAYOUT PLAN

Portsmouth Water Drawing Number: Rev: P06