



PROPOSED SINGLE STOREY SIDE EXTENSION
2 FORTUNES WAY
HAVANT

PROPOSED



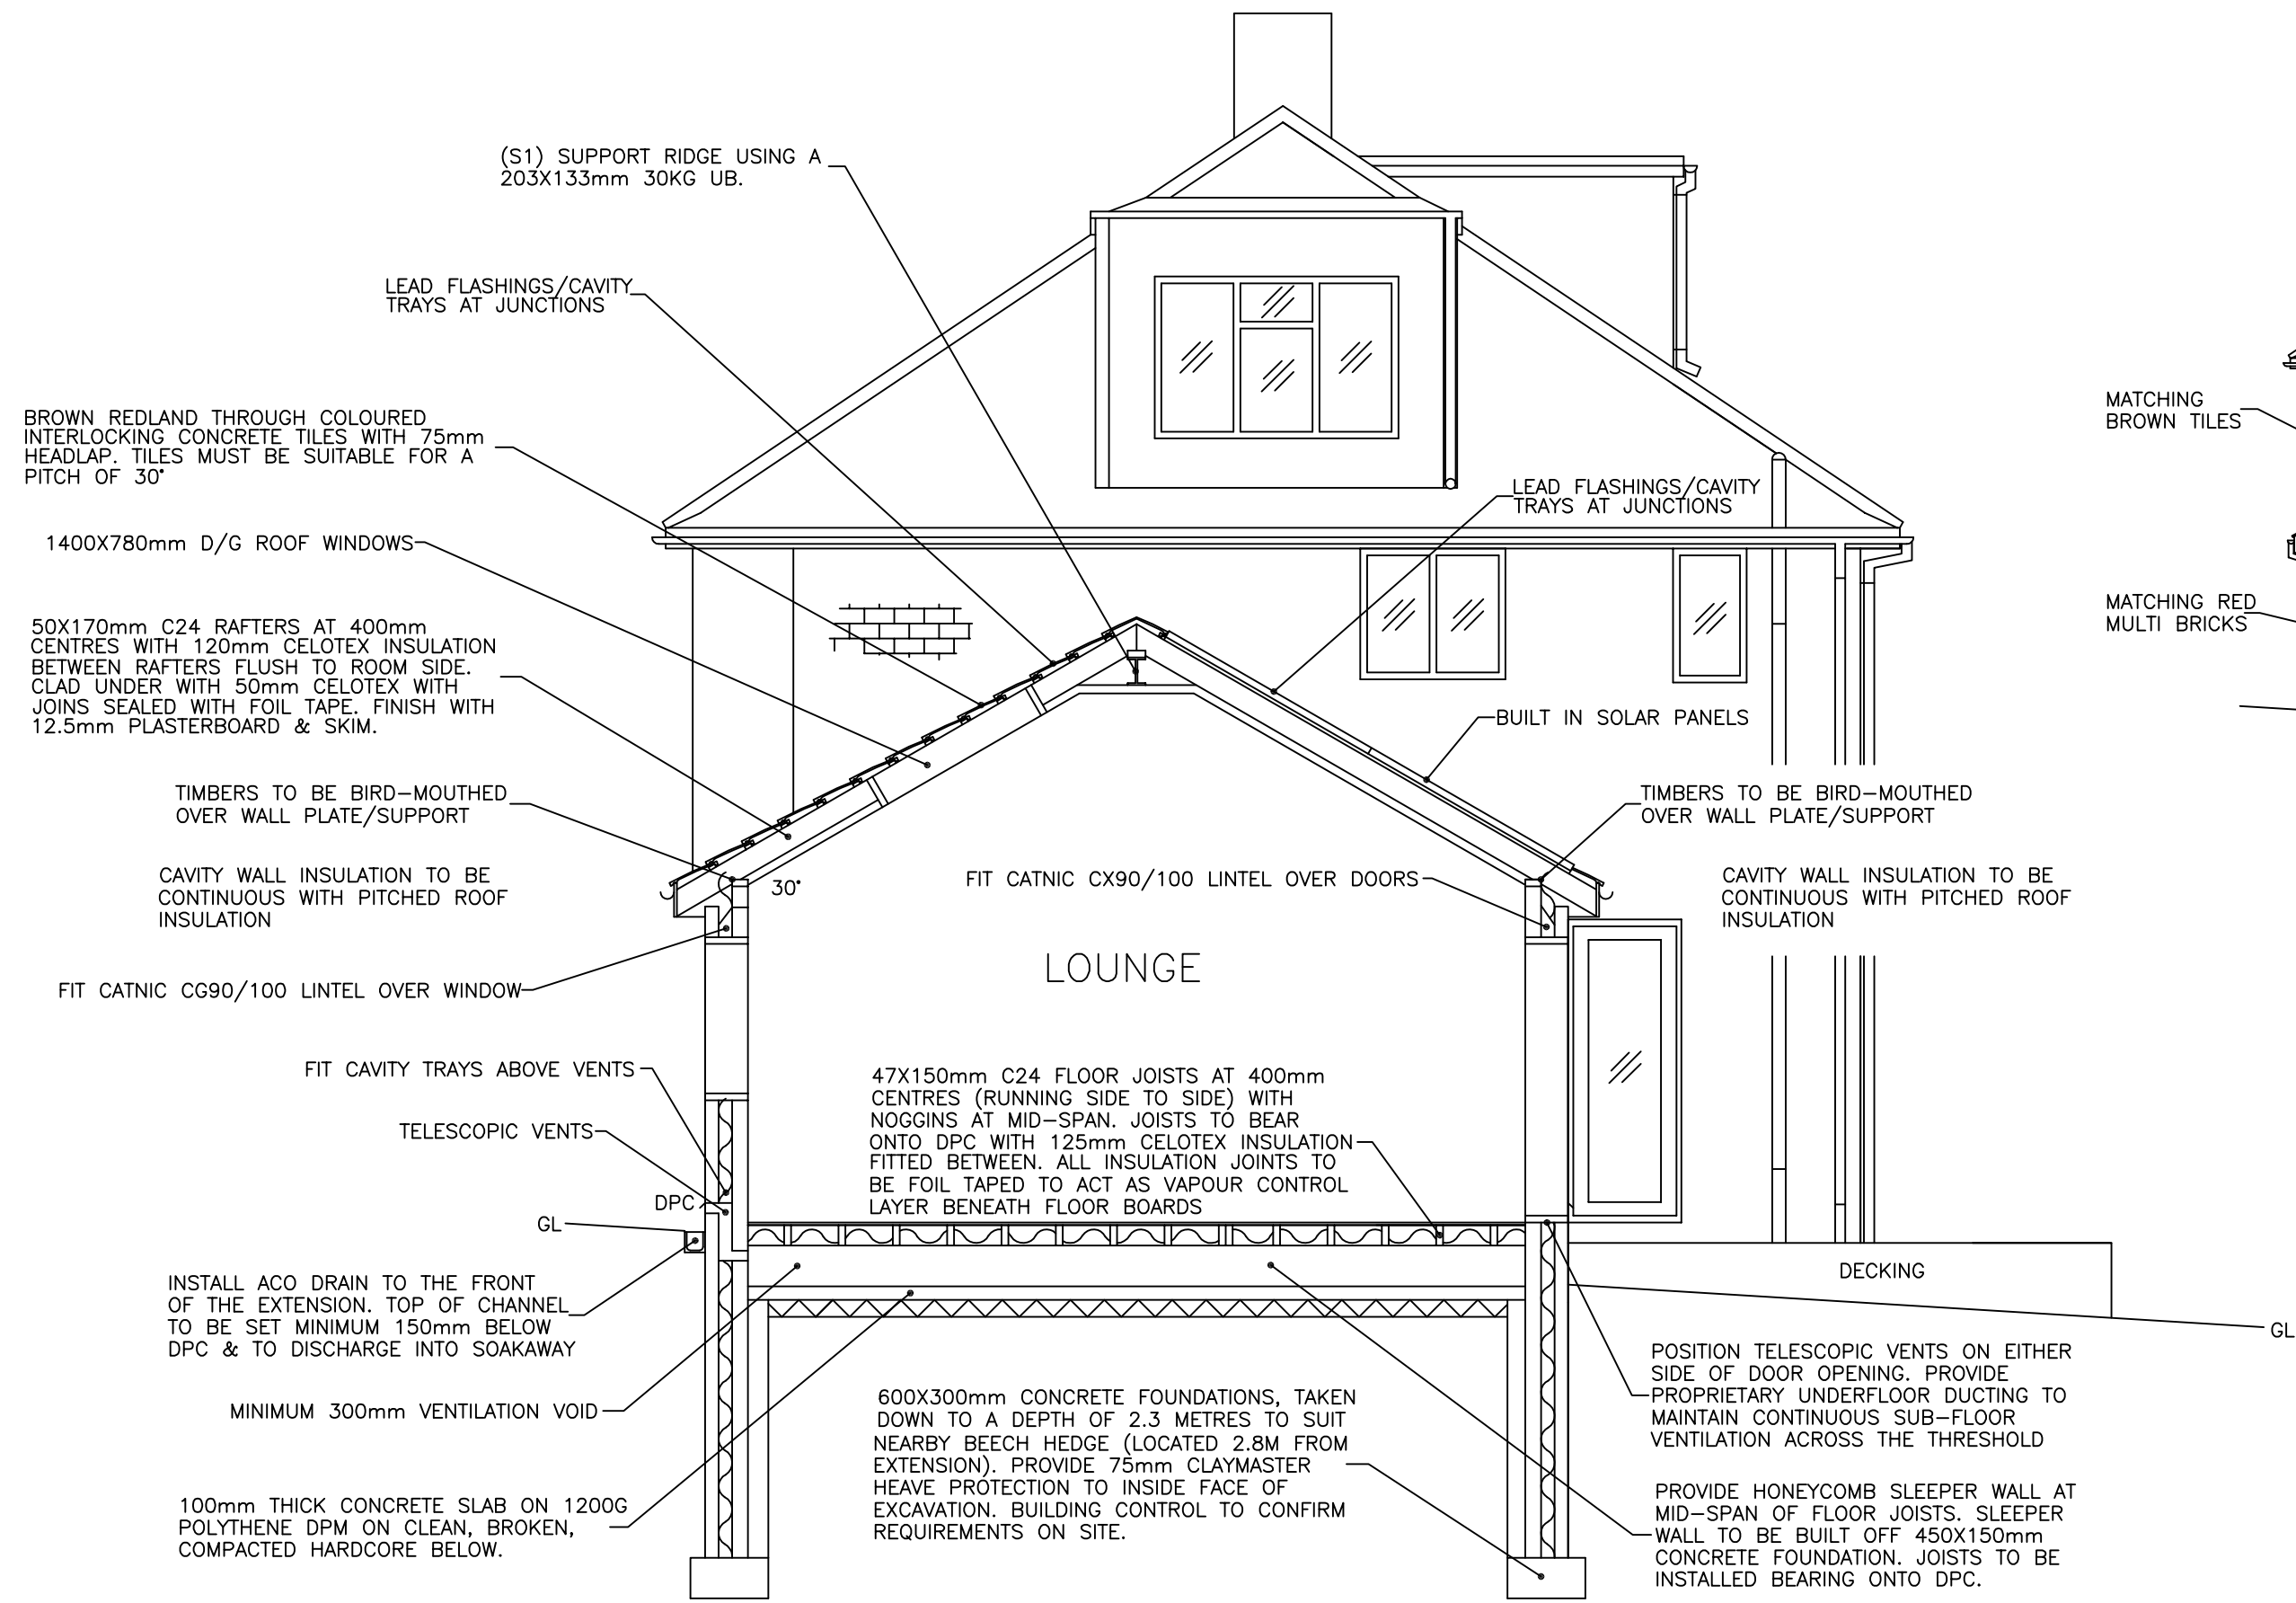


SIDE ELEVATION


FRONT ELEVATION

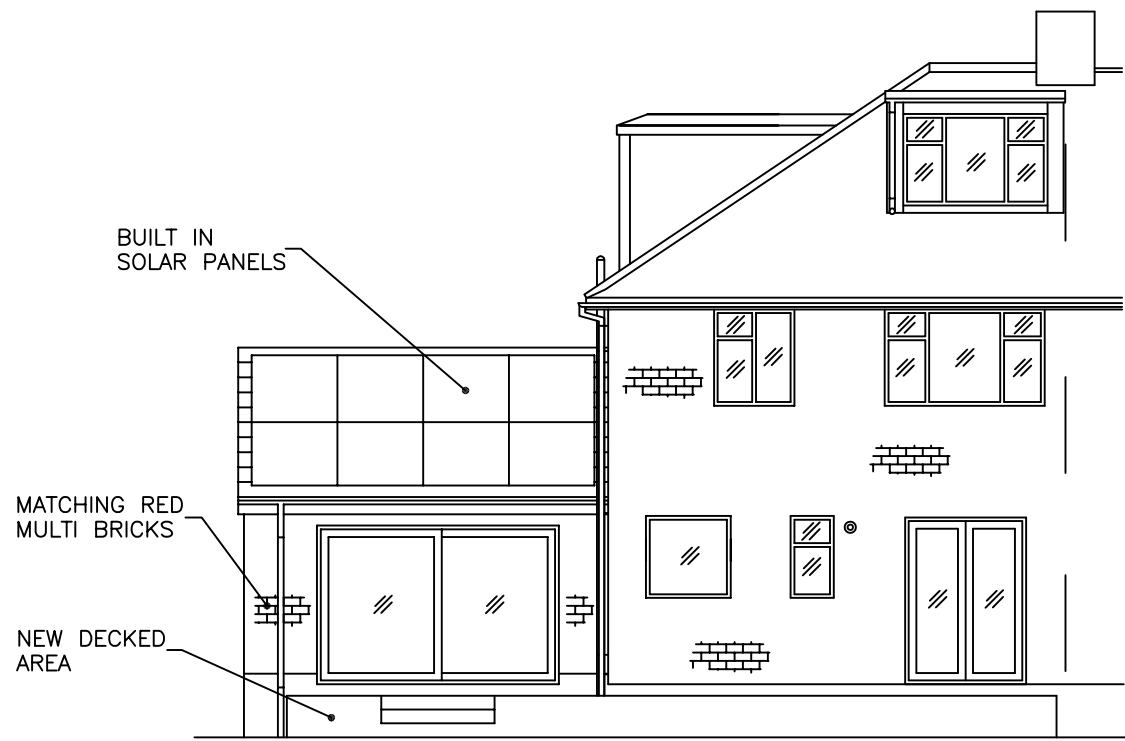

REAR ELEVATION

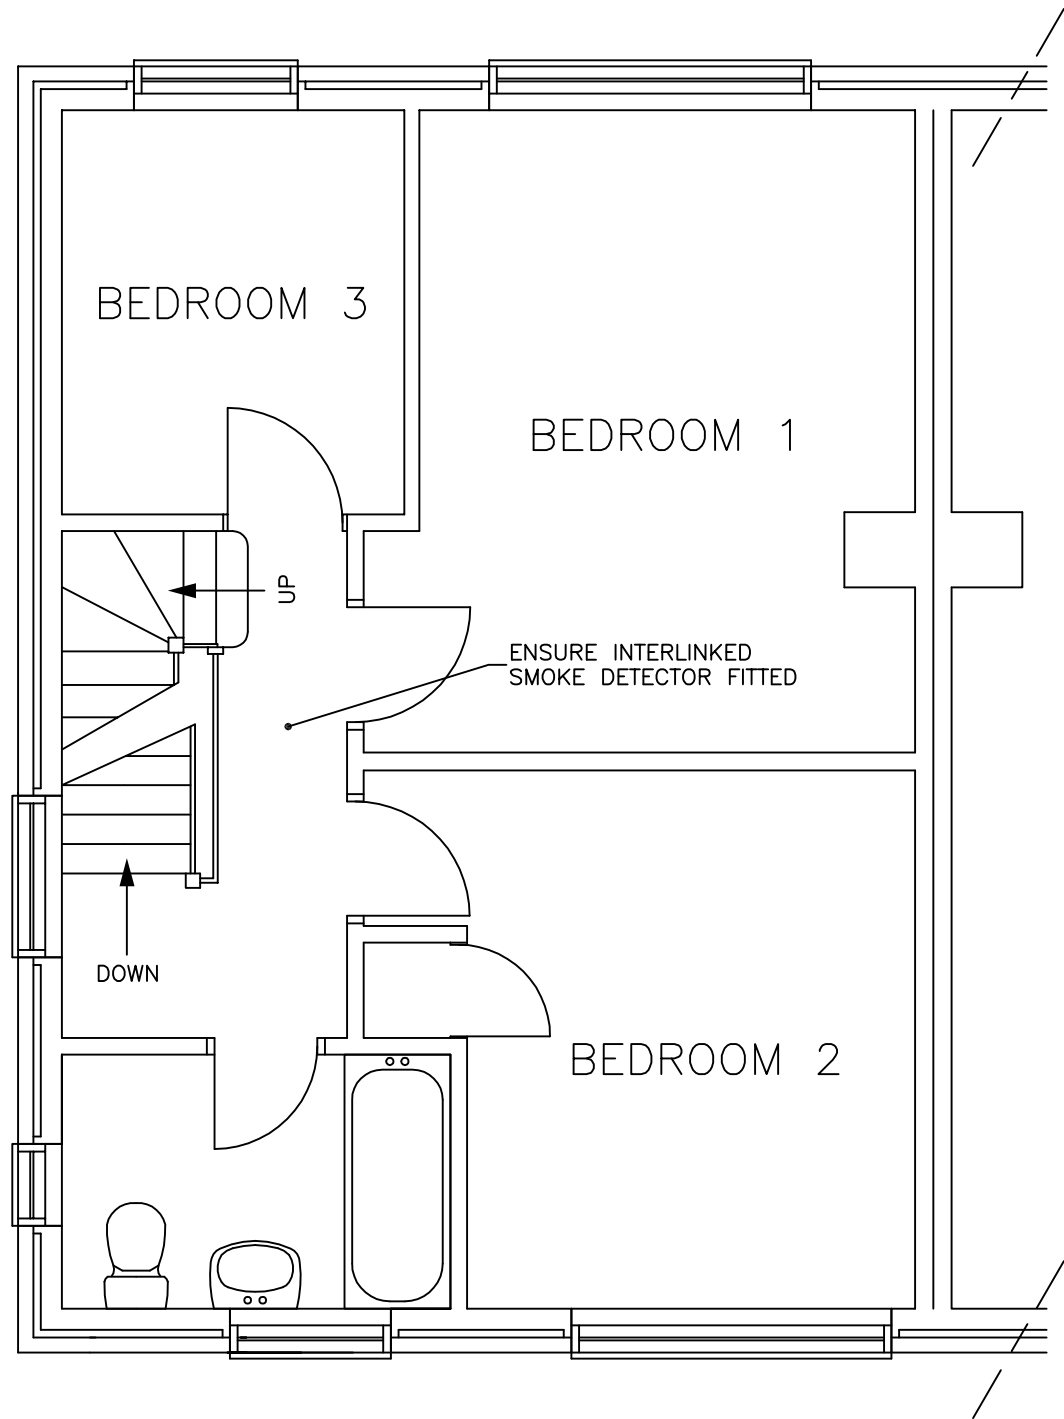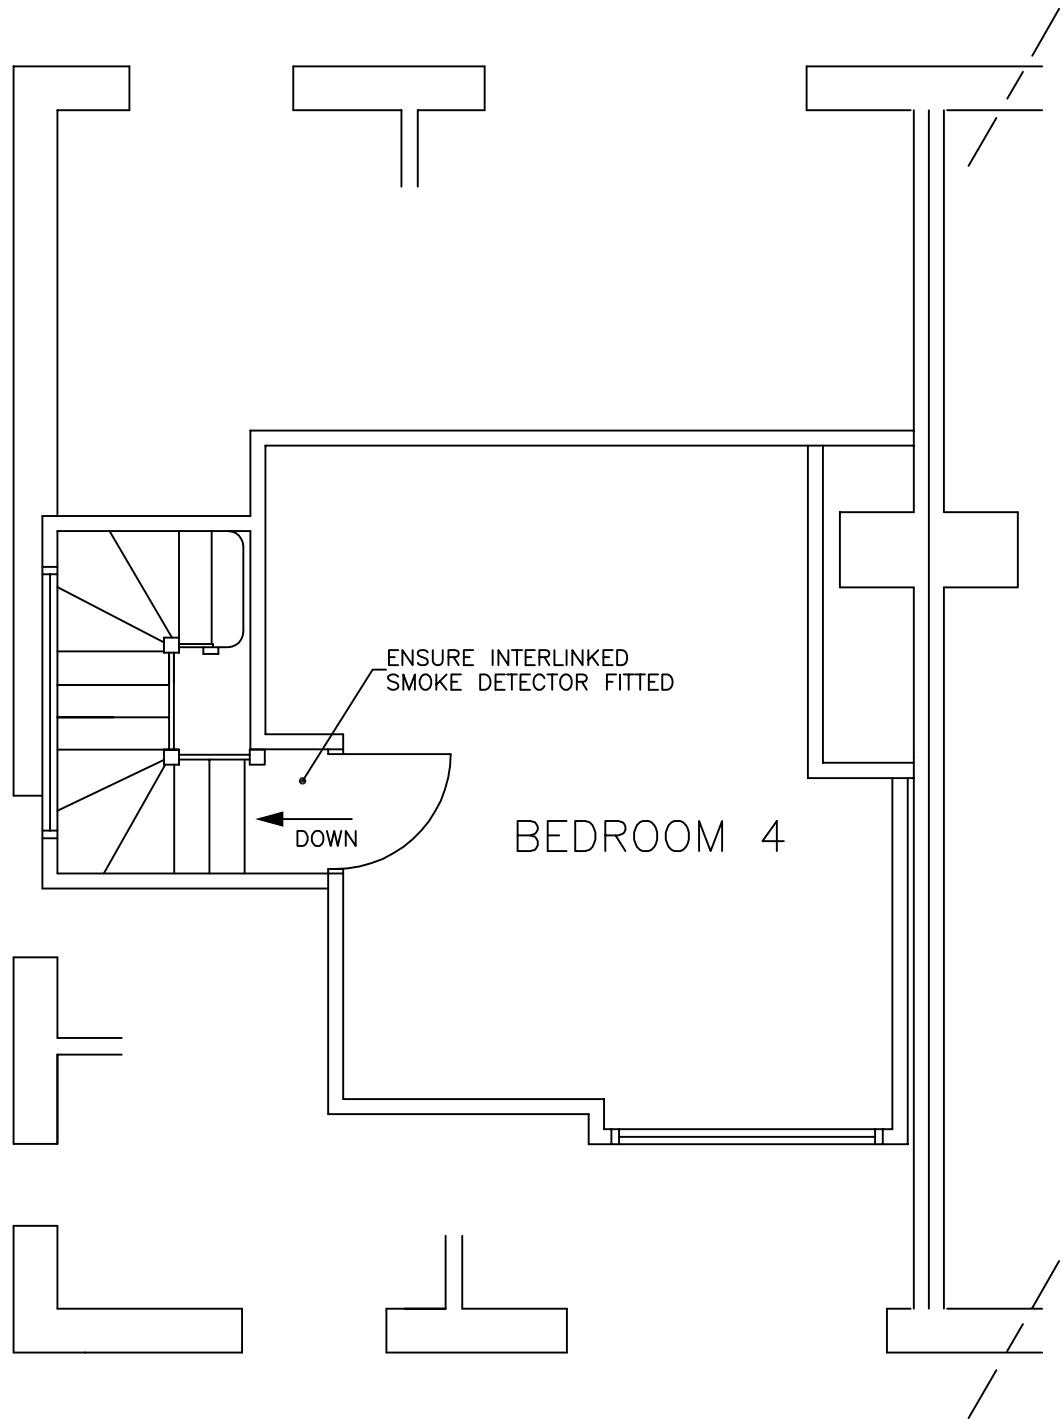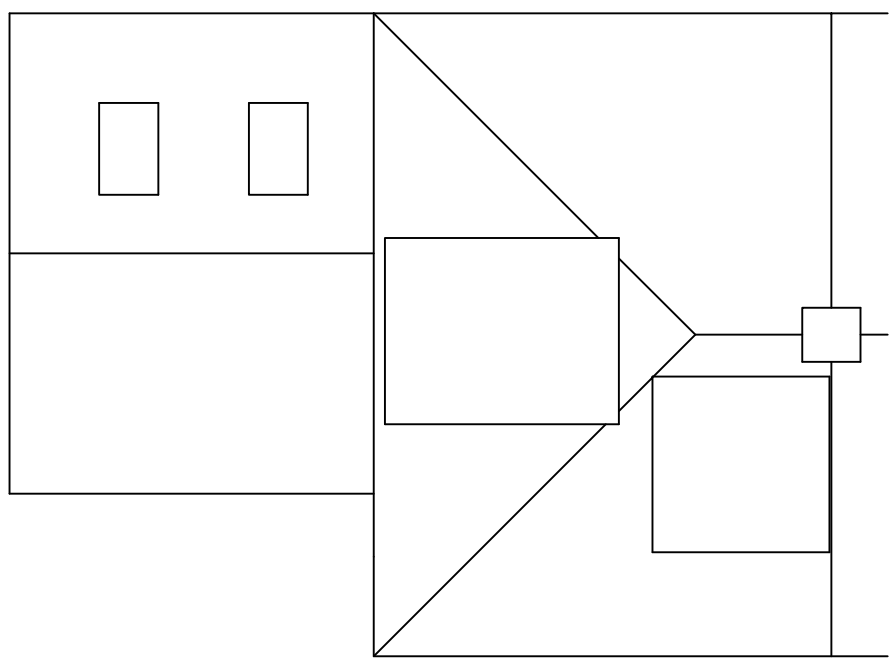

11. EXPOSED AREAS OF BEAMS & LINTELS TO BE CLAD IN TWO LAYERS OF 12.5mm FIRE RESISTANT PLASTERBOARD WITH 7mm GYPSUM SKIM. FIT I.A.W. THE MANUFACTURERS INSTRUCTIONS TO PROVIDE MINIMUM 1/2 HOUR FIRE RESISTANCE.
12. RADIATORS EXTENDED INTO NEW AREAS TO BE FITTED WITH THERMOSTATIC VALVES.
13. RAINWATER GOODS: 100mm HALF ROUND GUTTERS 75mm DOWNPIPES DISCHARGING INTO 1M³ SOAKAWAY MINIMUM 5000mm FROM BUILDING.
14. TIMBER BEAMS TO BE BOLTED TOGETHER USING 9.5mm STEEL STUD BAR AT 600mm CENTRES FITTED WITH NUTS & DOUBLE SIDED TOOTHED CONNECTORS.
15. FIT MAINS OPERATED INTERLINKED SMOKE DETECTORS ON LANDINGS & HALL WITH BATTERY BACK UP.
16. FIT LED LIGHTING IN NEW/REFURBISHED AREAS.
17. ALL ELECTRICAL WORK TO MEET THE REQUIREMENTS OF PART 'P' (ELECTRICAL SAFETY) MUST BE DESIGNED, INSTALLED, INSPECTED & TESTED BY A PERSON COMPETENT TO DO SO. PRIOR TO COMPLETION THE COUNCIL SHOULD BE SATISFIED THAT PART 'P' HAS BEEN COMPLETED WITH. THIS MAY REQUIRE AN APPROPRIATE BS 7671 ELECTRICAL INSTALLATION CERTIFICATE TO BE ISSUED FOR THE WORK BY A QUALIFIED PERSON.

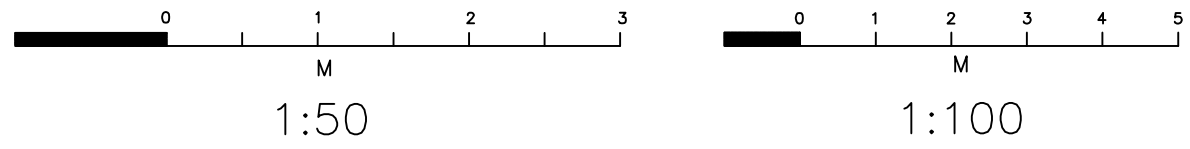

FOR MR & MRS HAMBLING
DATE: 15/07/2026
SCALES 1-50 1-100
DRAWN BY M. WARBURTON.
TELEPHONE 07814019651 OR 023-92349420.