
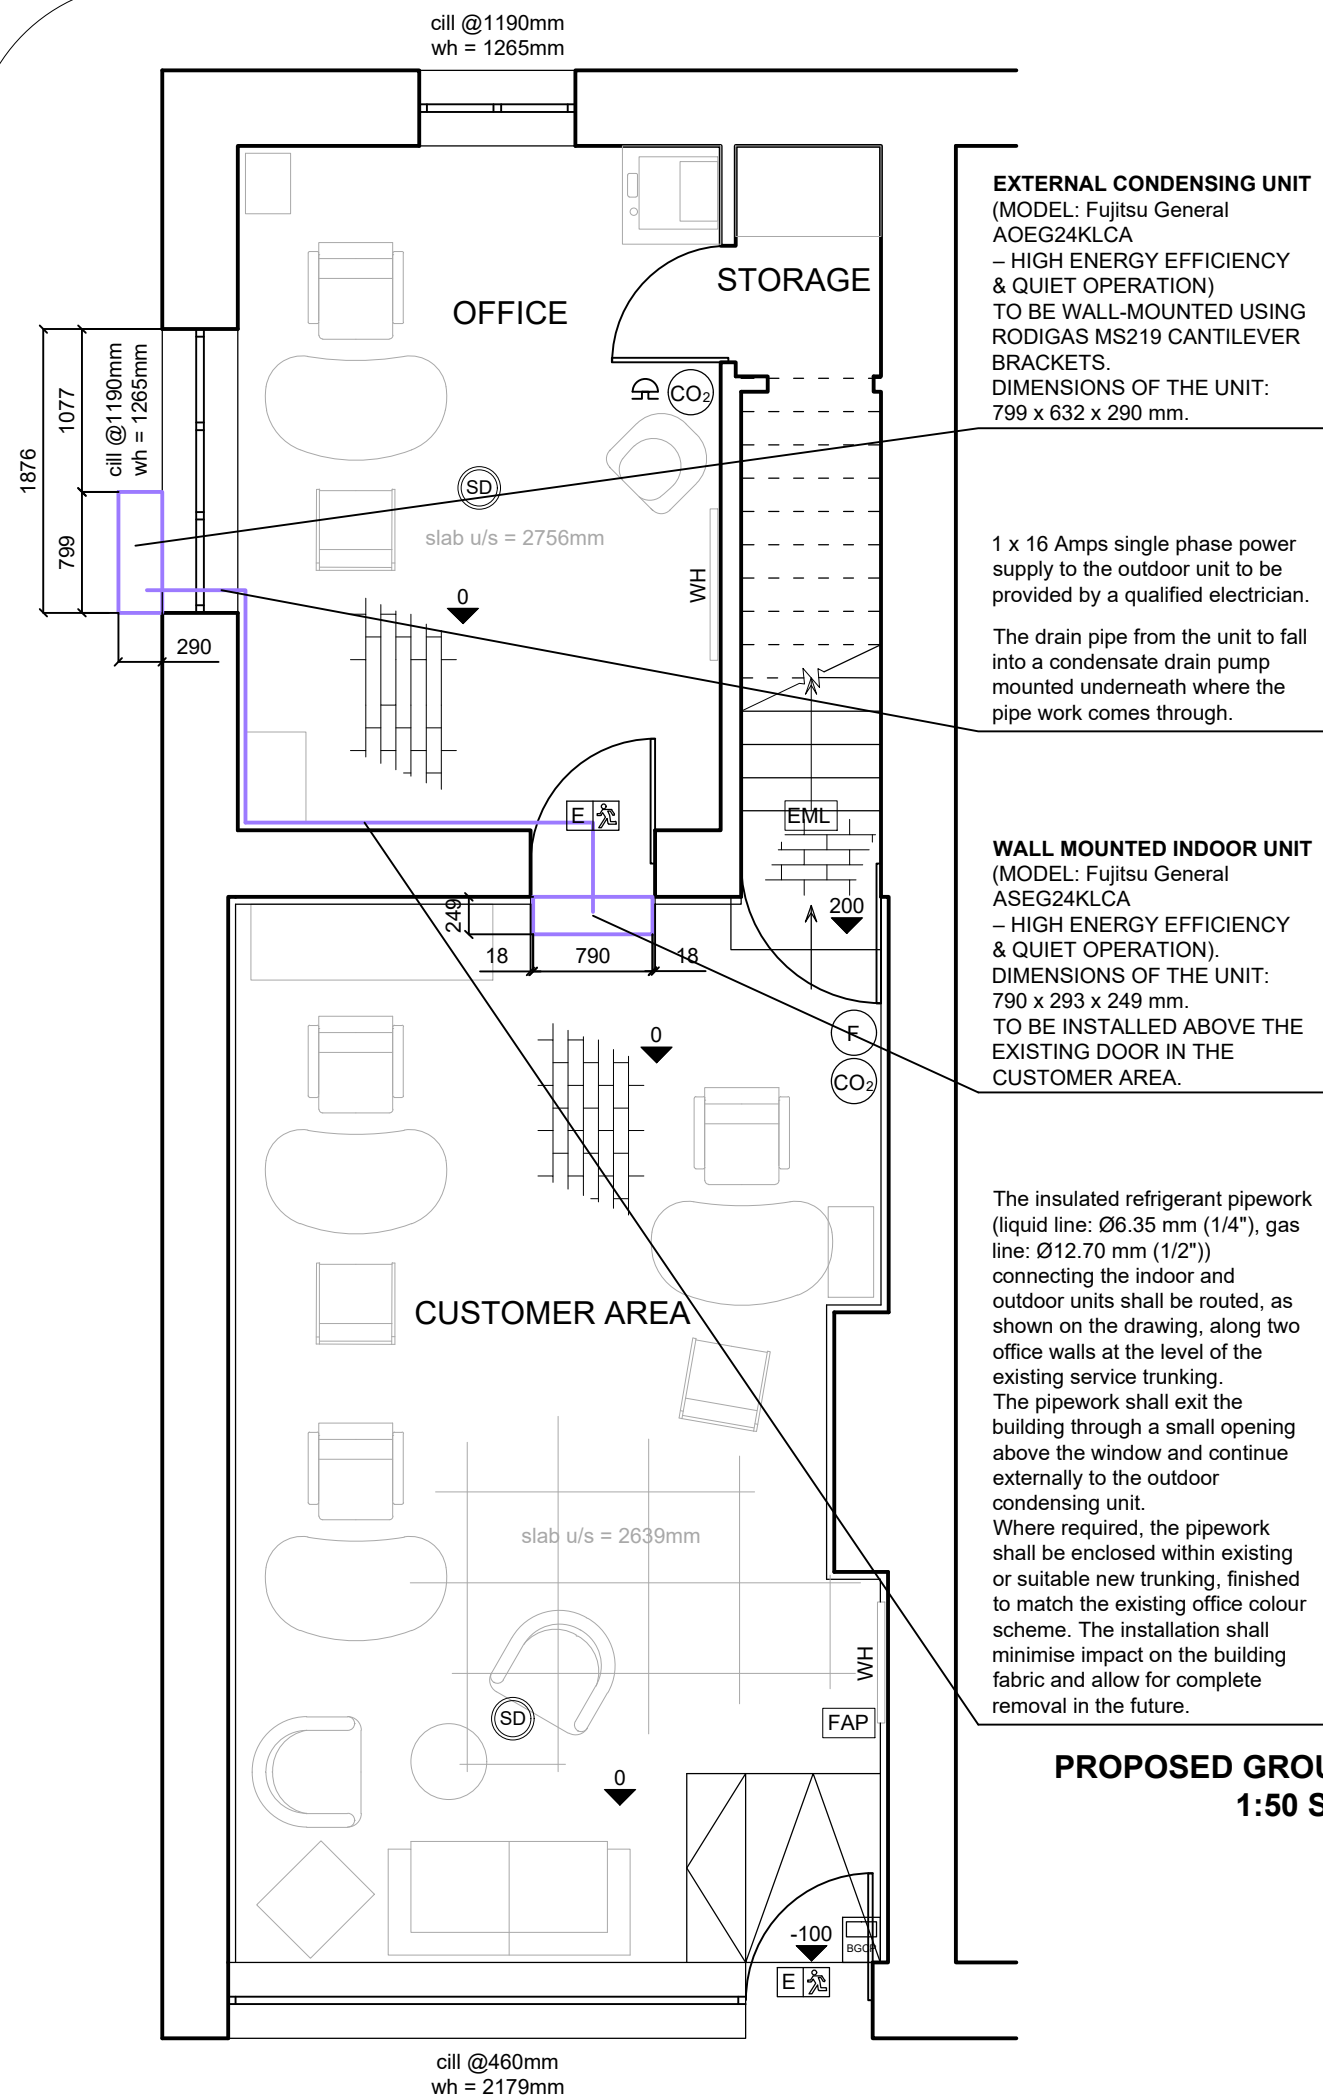


 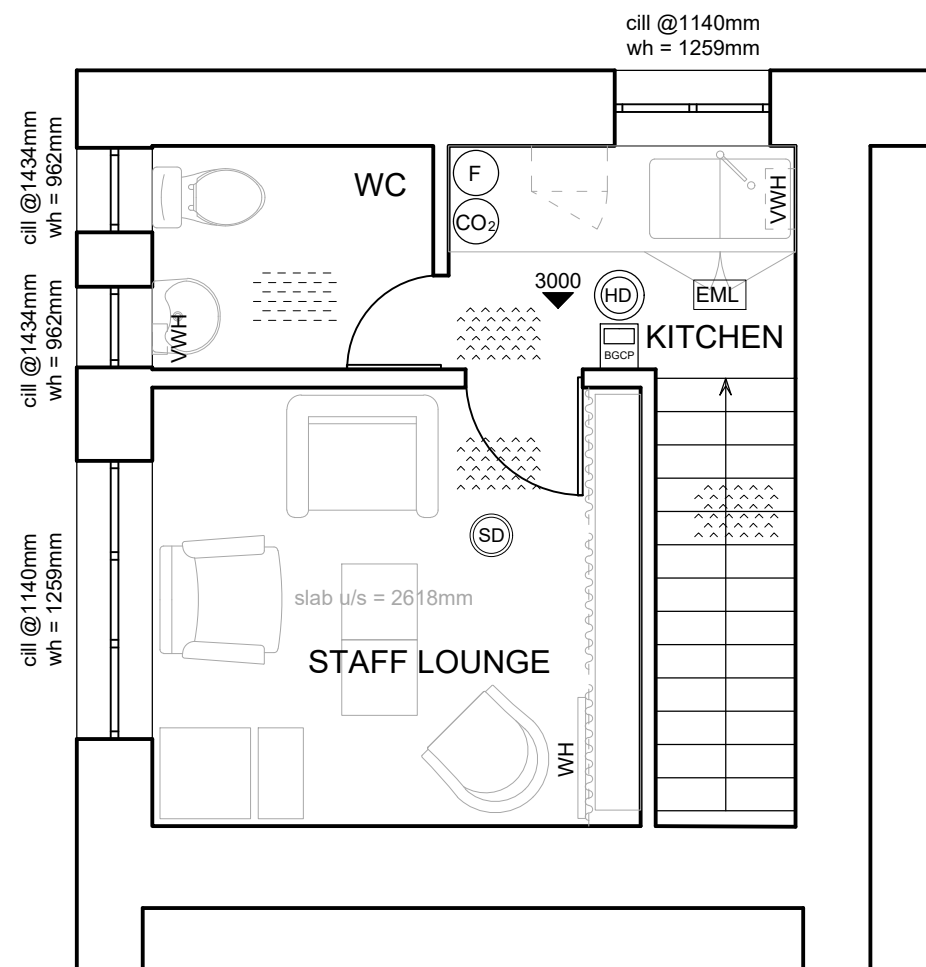


PROPOSED FIRST FLOOR PLAN
1:50 SCALE

PROPOSED GROUND FLOOR PLAN
1:50 SCALE

NOTE:
NO OTHER WORKS THAN
INDICATED ARE PROPOSED

- CO₂ CARBON DIOXIDE FIRE EXTINGUISHER
- F FOAM FIRE EXTINGUISHER
- FAP FIRE ALARM PANEL
- BGCP BREAK GLASS CALL POINT
- HD HEAT DETECTOR
- SD SMOKE DETECTOR
- FIRE ALARM SOUNDER
- E Exist Luminaire Sign
- EML EMERGENCY LIGHTING
- WH WALL HEATER
- VWH OVERSINK VENTED WATER HEATER



This drawing to be read in conjunction with all relevant consultants, sub-contractors and specialists drawings.

All dimensions and levels are to be checked on site before any construction begins and any discrepancies are to be reported to the relevant Project Manager.

Partial Service : Any discrepancies or any other information are to be advised to the relevant Project Manager and direction sought before the implementation of the detail.

Responsibility is not accepted for errors made by others in scaling from this drawing. All construction information should be taken from figured dimensions only. Any error or omission should be reported to CMC Projekt.

EMSWORTH

1 South St, Emsworth
PO10 7EG

client

Gascoigne-Pees

drawn by:

MB

checked by:

AR



CMC Projekt Europe Sp. z o. o.

Copyright is reserved by CMC and is issued on the condition that it is not copied or disclosed by, or to, any unauthorised persons without prior consent in writing from CMC. All dimensions to be checked on site prior to any fabrication. All errors, omissions/discovered inconsistencies to be reported to the C.A immediately. Drawings show design intent only. Responsibility is not accepted for errors made by others in scaling from this drawing.

drawing title:

**Proposed
Floor Plans**

drawing number:

GSP_EMS_C12

project status:

PLANNING APPLICATION

scale: 1 : 50 @A3

date: SEPTEMBER 2026

revision:

0