


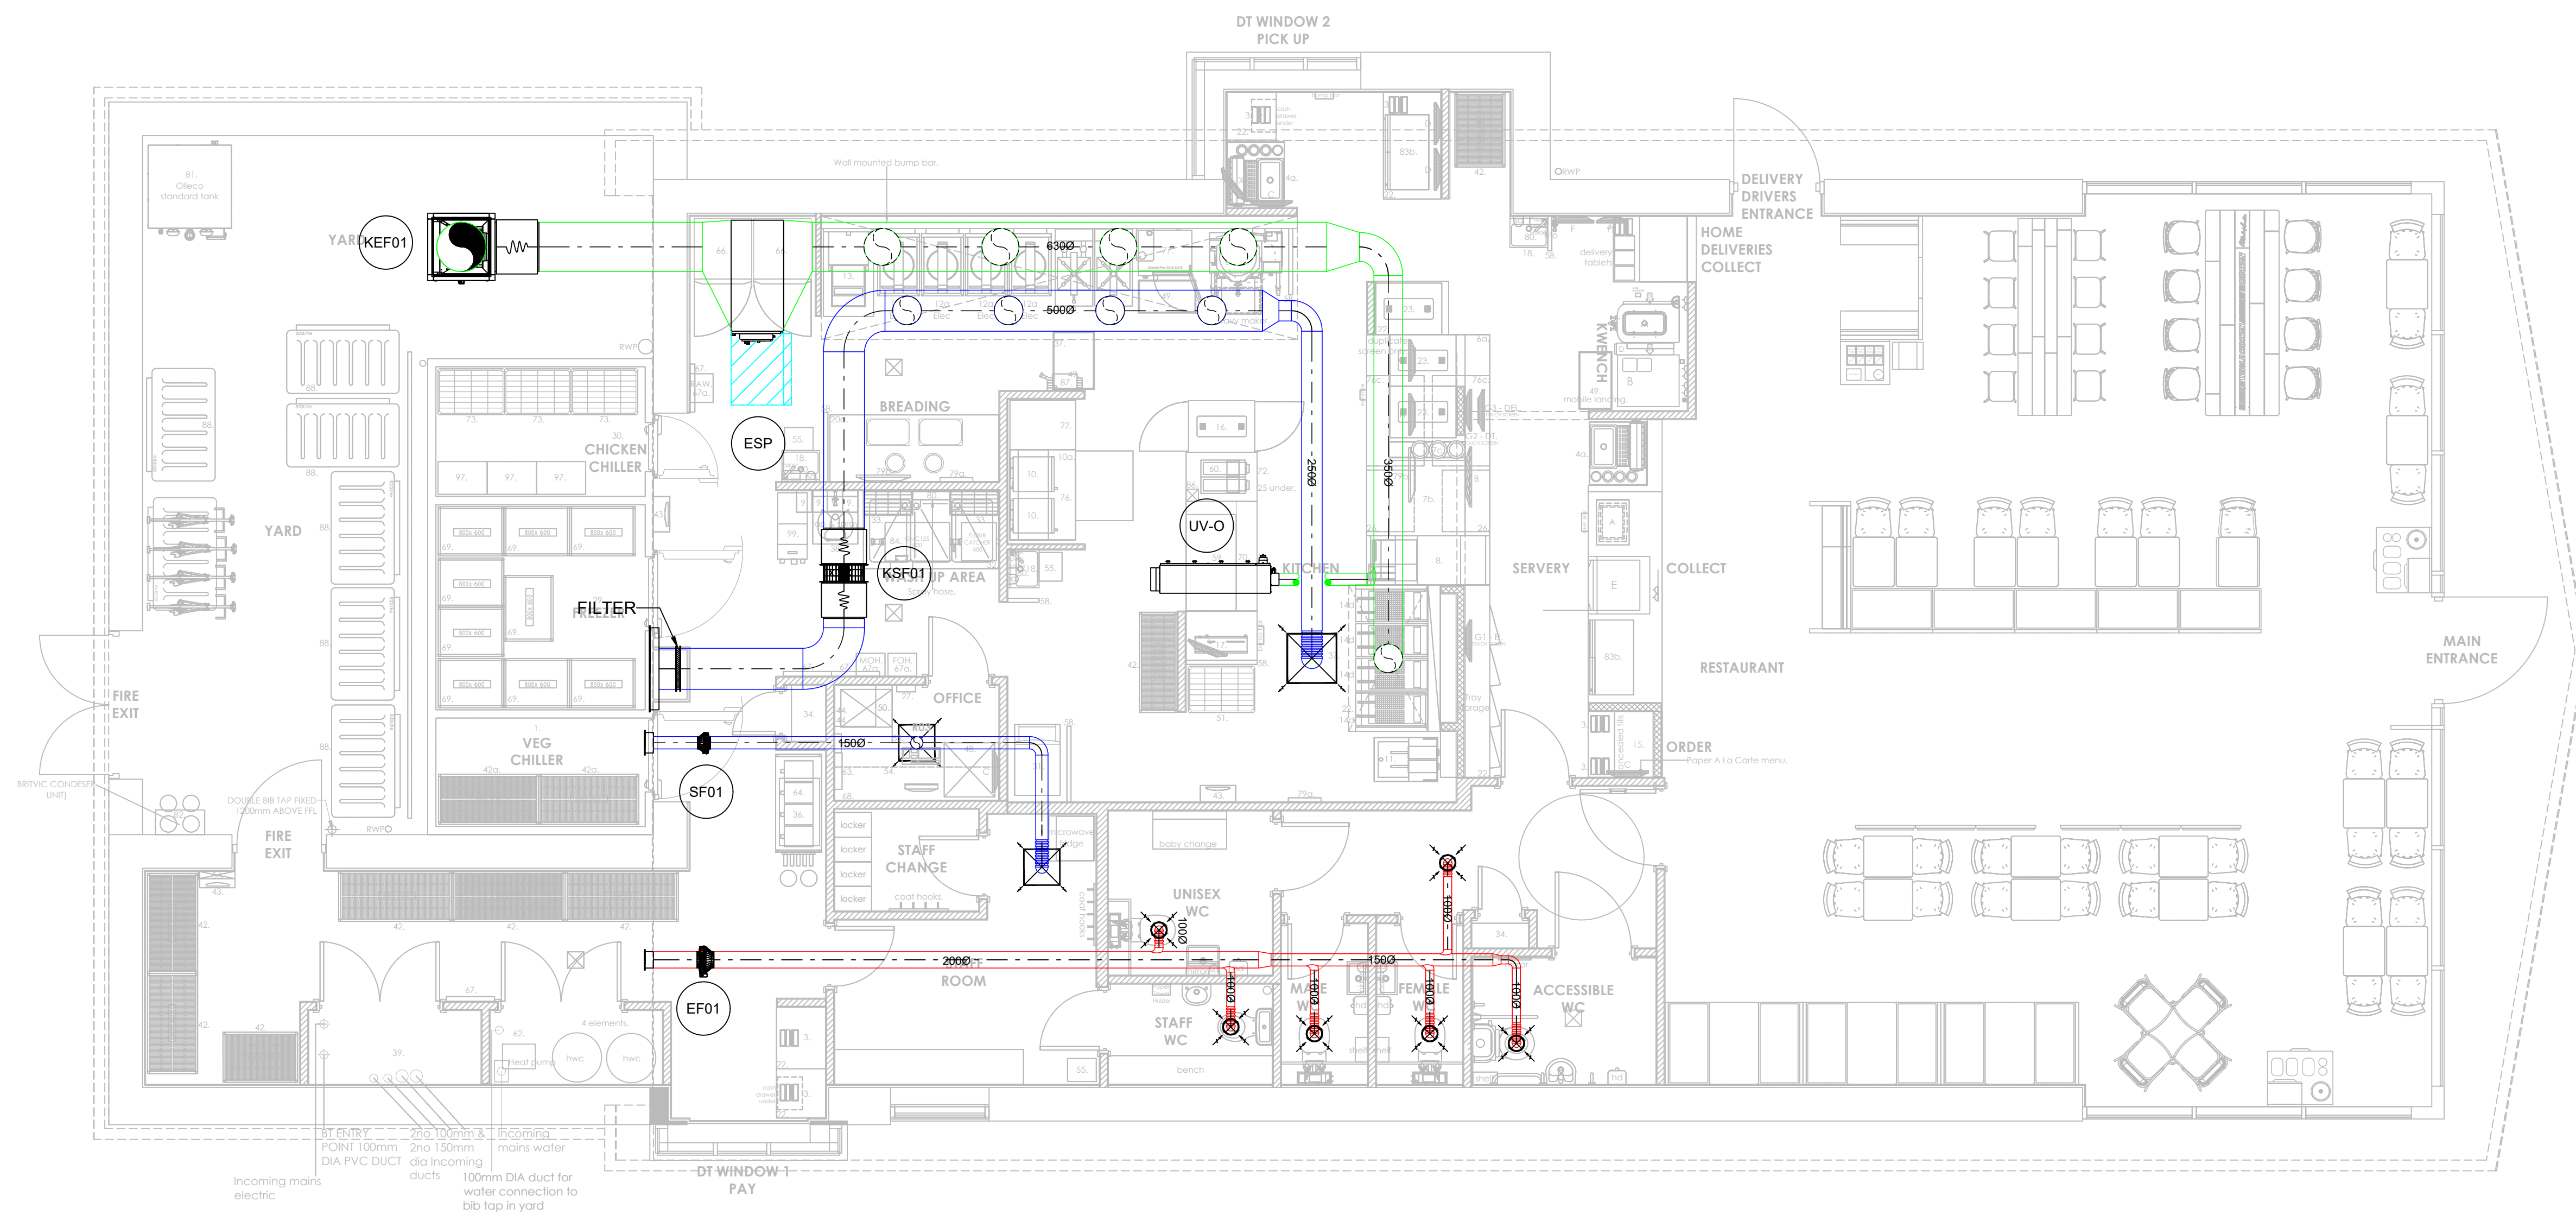

Ventilation					
Location	Indoor Ref	Manufacturer	Model	Control	Power Supply Required
WC Extract	EF01	Systemair	K200 S1eo	Activate with Lights	On light supply for toilet
Office & Team Room Supply	SF01	Systemair	K150 S1eo	Activate with Lights	On light supply for Staff Room & Office
Back of House	KSF01	Systemair	AF600 S1eo	Speed Controller	1ph 10A
Back of House	KEF01	Systemair	MUB/T 062 560	Inverter	3ph 20A
Back of House	UV-O	Purified Air	UV-O1000		1ph 10A
Back of House	ESP	Purified Air	ESP4500		1ph 10A

GENERAL NOTES:

REV	DETAIL OF AMENDMENT	DATE
1	ESP ADDED	28.08.2026
2	UVO RELOCATION	25.09.2026



SITE: KFC WATERLOOVILLE
CLIENT: K & Z HOLDINGS
TITLE: PROPOSED VENTILATION LAYOUT
DRAWING BY: GW CHECKED BY: AC
DATE: 25/09/2026 SCALE: 1:50 PAPER SIZE: A1
DRAWING NO. 10001410-KZH-00-DR-02 REV 2