



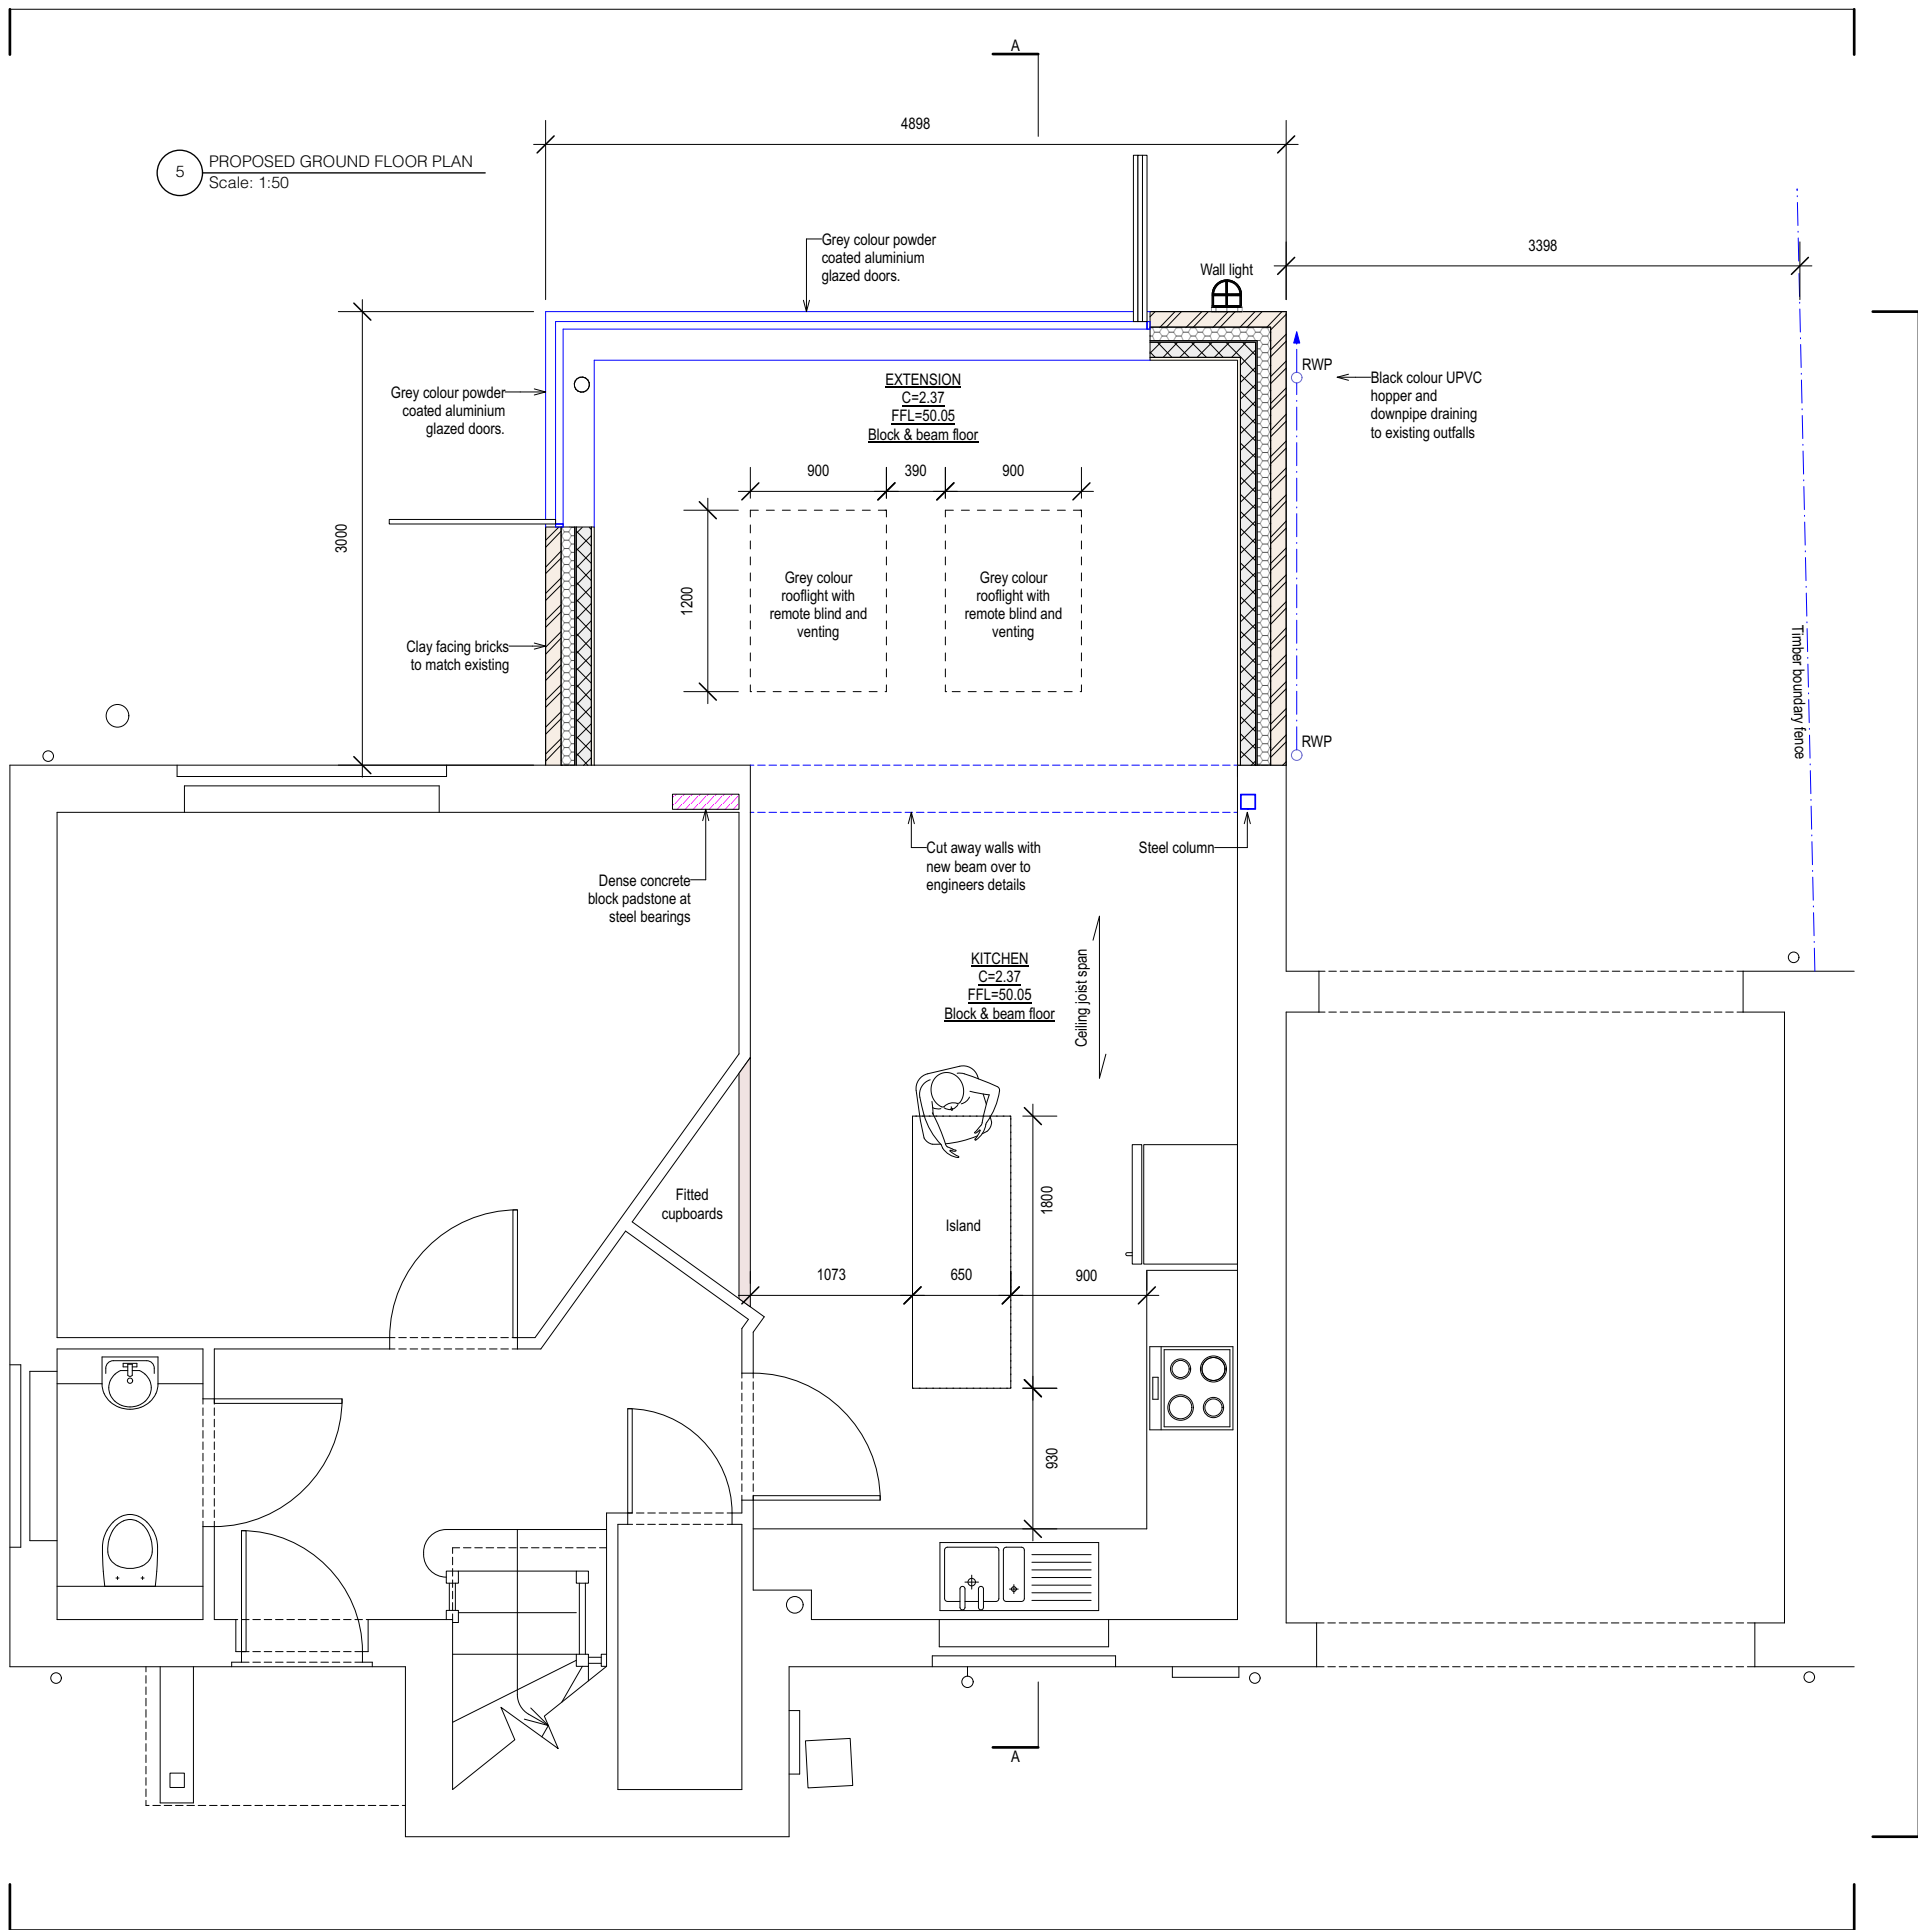


PLANNING

LEVEL DATUM		
Survey based on local grid and levels based on Temporary Bench Mark (TBM) located on Station A, Value = 50.00m		
NOTES		
1. All dimensions and levels to be checked on site by contractor prior to fabrication/construction.		
2. This drawing is to be read in conjunction with all relevant consultant's and/or specialist's drawings and documents. Any discrepancies or variations are to be notified to SurveyCloud Ltd before the affected work commences.		
3. This drawing and the copyrights and patents therein are the property of SurveyCloud Ltd and may not be used or reproduced without prior consent.		
KEY		
A	Approximate	LB Litter Bin
AB	Air Brick	LP Lamp Post
AC	Arch Crown Height	LTB Lighting Bollard
Agg	Aggregate	MH Manhole
AS	Arch Spring Height	MK Marker Post
Asph	Asphalt	MPO Metal Post
B	Bollard	NPO Name Plate
BB	Beisha Beacon	OH Overhead Cable
BH	Borehole	OHB Overhead Building
Bpav	Brick Pavers	OHE Overhead Electric Cable
BIG	Back Inlet Gully	OHT Overhead Telecom Cable
BRW	Brick Wall	PB Post Box
BS	Bench Seat	PM Parking Meter
C	Ceiling Height	PO Post
Clup	Ceiling Slopes Up	PWL Parapet Wall Level
CF	False Ceiling Height	RB Removable Bollard
CH	Ceiling Hatch	RE Rodding Eye
CL	Cover Level	RG Road Gully
Cob	Cobbles	RL Ridge Level
Conc	Concrete	RPO Reflective Post
Cpav	Crazy Paving	RS Road Sign
Cpd	Cupboard	RWP Rainwater Pipe
CPO	Concrete Post	SH Window Sill to Head Height
CPS	Concrete Paving Slabs	SP Soil Pipe
CWT	Cold Water Tank	SSL Structural Slab Level
D	Depth (metres)	STN Survey Station
DC	Drainage Channel	SVP Soil Vent Pipe
DH	Door Head Height	SWC Surface Water IC
DPC	Damp Proof Course	TCB Telephone Call Box
EL	Eaves Level	TFL Top Fence Level
EP	Electric Pole	TL Traffic Light
ER	Earth Rod	TLCB Traffic Light Control Box
FB	Fixed Bollard	Tmac Tarmac
FFL	Finished Floor Level	TP Telegraph Pole
FH	Fire Hydrant	Tpav Tactile Paving
FL	Flood Light	TPO Timber Post
FP	Flag Pole	TWL Top Wall Level
FPO	Fence Post	U Unknown
FRL	Flat Roof Level	UB Underside of Beam Height
FWC	Foul Water IC	Ubox Underside of Boxing Height
G	Gully	UID Underside of Ducting Height
GM	Gas Meter	UP Underside of Pipe Height
GP	Gas Pipe	US Underside
GPO	Gate Post	UTL Unable to Lift
H	Height (metres)	VP Vent Pipe
HB	Hinged Bollard	WAC Window Arch Crown Height
HMC	Hot Water Cylinder	WAS Window Arch Spring Height
IC	Inspection Cover	WH Window Head Height
ID	Invert Depth	WL Water Level
IL	Invert Level	WM Water Meter
JB	Junction Box	WP Water Pipe
KIG	Kerb Inlet Gully	WS Window Sill Height
L	Level	WSV Water Stop Valve

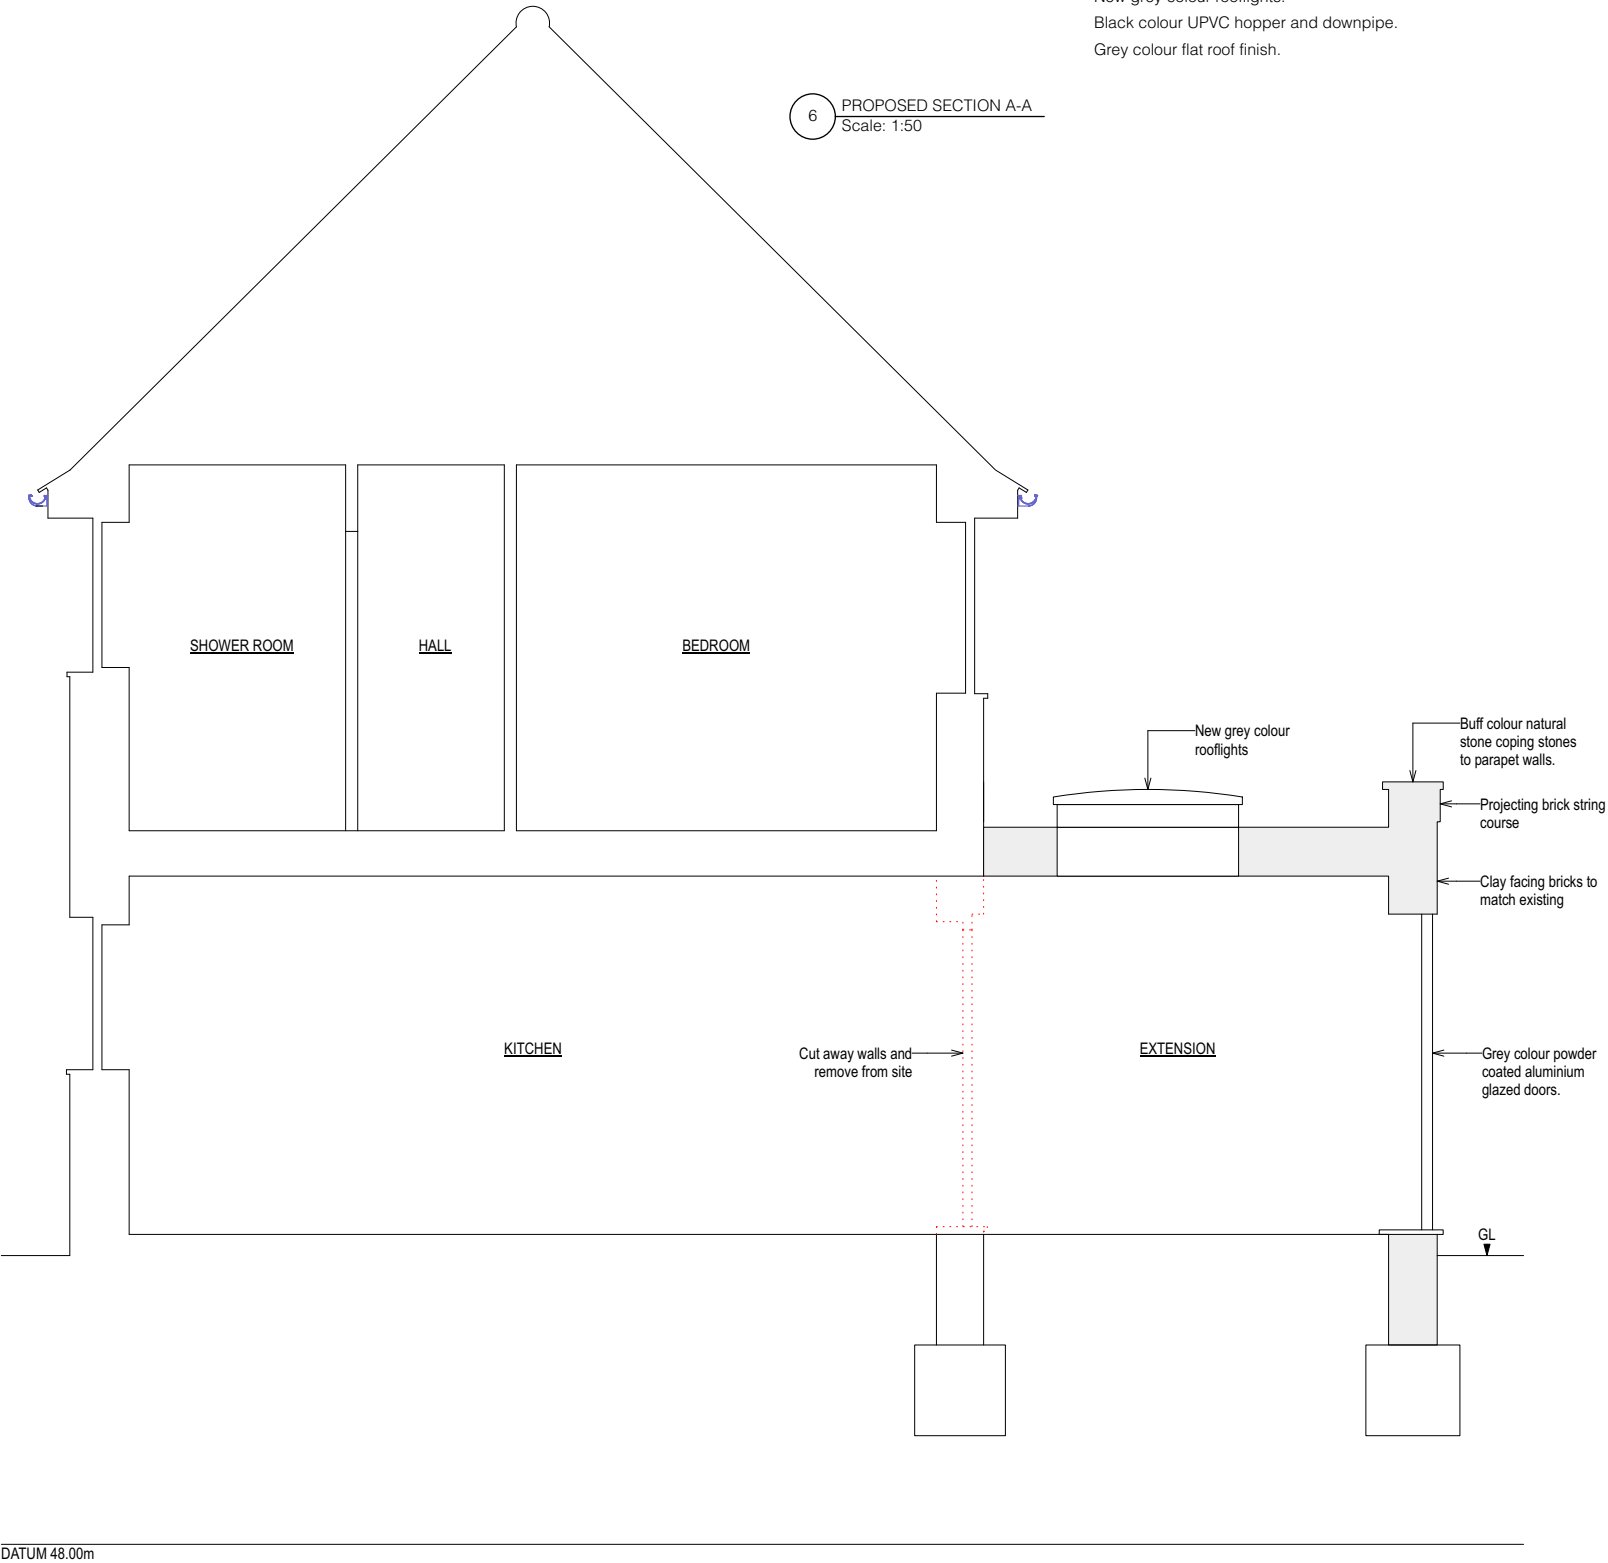


2 PROPOSED SIDE ELEVATION 2 (NORTH)
Scale: 1:100

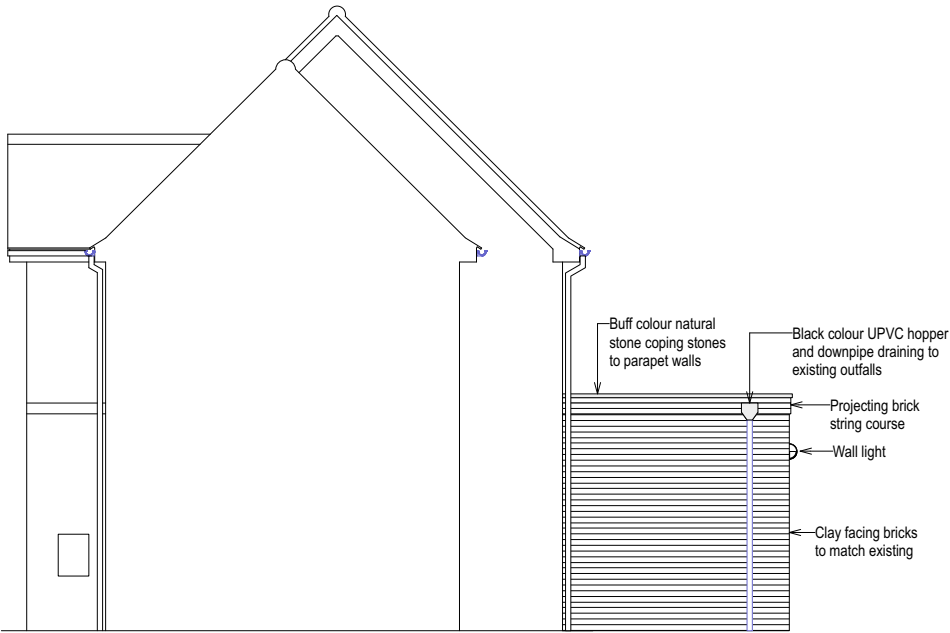

3 PROPOSED REAR ELEVATION 3 (WEST)
Scale: 1:100



4 PROPOSED SIDE ELEVATION 4 (SOUTH)
Scale: 1:100

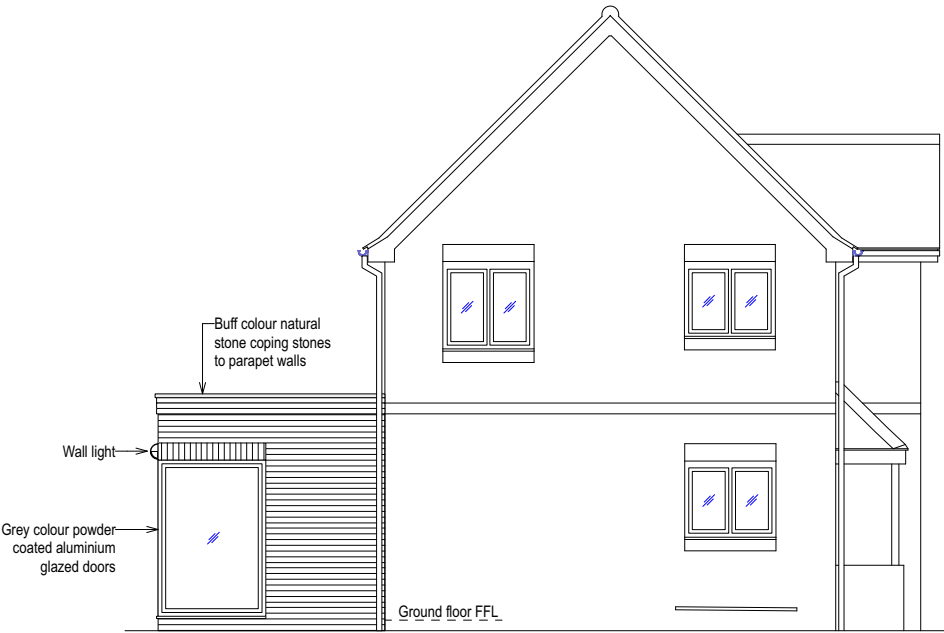

Revision	Comment	Date
Client		
MISS GRADY		
Project		
23 PEPPER CLOSE		
HAYLING ISLAND		
HAMPSHIRE PO11 0NS		
Title		
PROPOSED PLANNING		

Drawing Number	Revision	Status
SD26769-PP2.0	A	PLANNING
Scale	Sheet Size	Drawn By
AS SHOWN	A2	DW
Date	Date	Date
		OCTOBER 2026